

Date: March 5, 2021

Project: Cajon Valley Union School District

Bostonia Language Academy

Modular Classroom Buildings Relocation

1390 East Broadway El Cajon, CA 92021

Project No: 2020-06795-000

DSA App. No: 04-119479

Notice to Bidders:

This Addendum describes additions to the scope of work that changes the Drawings and Specifications, forms a part of the Contract, and becomes part of the Contract Documents. All work affected by the following modifications shall conform with related provisions and General Conditions of the Contract and of the original Specifications and Drawings. The narrative provided herein is provided to assist in describing revisions to the Contract Documents but may not be inclusive of all revisions.

Acknowledge receipt of this Addendum No. 2 in the space provided on the Bid Form. Failure to do so may subject Bidder to disqualification.

Item 1: Bid Form

Replace Bid Form (Pages 13-16 of bid documents) with attached <u>Revised</u> Bid Form (Addendum 2) to include Additive Alternates 1 and 2. Bidder must bid on all line items including Base Bid and Alternates or the bid will be non-responsive.

Item 2: Alternate Bids

Revise Instructions to Bidders, Section 6, as follows:

ALTERNATE BIDS

If alternate bid items are called for in the Contract Documents, the lowest bid will be determined on the basis of the base bid enly plus all alternate bids. However, the District may choose to award the contract on the basis of the base bid alone or the base bid and any alternate or combination of alternates. The time required for completion of the alternate bid items has been factored into the Contract duration and no additional Contract time will be awarded for any of the alternate bid items. The District may elect to include one or more of the alternate bid items, or to otherwise remove certain work from the Project scope of work, accordingly each Bidder must ensure that each bid item contains a proportionate share of profit, overhead and other costs or expenses which will be incurred by the Bidder.



Item 3: Changes to the Drawings

EF-01: Revised audio/visual circuit information in rooms 49 & 50.

E6-21: Revised keynote #1. Revised fire alarm wiring designation chart. Revised fire alarm riser diagram. Revised speaker circuit load calculation chart.

Added reference sets:

A#04-51283 A#04-51190 A#04-66161 (PC 275)

Item 4: Building Improvements

Interior Improvements:

- 1. Clean interior of each building, including removal of any existing ramp systems. Confirm items to be salvaged with District.
- 2. Demolish 9 LF of existing upper cabinets at Building RM 48. See Figure A below. Clean and patch wall to match existing finish. See item #7 below.
- 3. Protect existing ceiling grid in place. Replace all 2x4 ceiling tiles throughout. Product to be Armstrong, 24"x24"x¾" Ultima Beveled Tegular,1951. NRC 0.60, Light Reflectance 0.90, color white.
- 4. Demolish 40 LF of interior walls at Building RM 46. See Figure B below. Patch floor and walls to match existing construction and finish. See item #5 and #7 below.
- 5. Remove existing flooring throughout and replace with carpet tile. Product to be 24"x24" Mannington Halftime Infinity Modular in Cobb color.
- 6. Provide walk-off mats at all exterior doors. Product to be Mannington Friction Force in Slide color 34368. See Figure C below for layout.
- 7. Remove any existing whiteboards, display board, posters, and/or other wall mounted accessories. Clean and prep wall surface. Install new ½" thick vinyl tackboard panels on entirety of wall surfaces throughout over existing tackable wall surface. Product to be Koroseal Ceres Vinyl Tackboard Panels in Fog color B321-91. Coordinate with existing conduit, raceway, switches, and devices to remain. Extend all electrical boxes as needed, including receptacles and light switches. Reinstall any removed whiteboards at locations per District. Estimated 2-4 whiteboards per building.
- 8. Contractor to field verify and provide report on condition of existing mechanical equipment and devices, including registers, ducts, and thermostats. District to advise on replacement or repair.
- 9. Contractor to field verify existing lights are in good working condition. Submit report to District as required to determine any necessary replacement.
- 10. Remove existing window blinds throughout and provide new window mini-blinds. Product to be SWF Contract 1" Heavy-Duty Aluminum Mini-Blinds in True White 544 color. Provide separate cords for tilt and for raising and lowering blinds.
- 11. Prep and paint all interior trim, doors, and frames. District to provide colors. See Figure D below for Painting Schedule.



Exterior Improvements:

- 12. Remove existing sheet metal gutters and downspouts. Provide new gutters and downspouts to match existing DSA pre-approved building drawings. Attached with Addendum #2 package for reference only.
- 13. Contractor to field verify condition of existing siding and provide report to District for evaluation. Remove and replace T111 siding and membrane to match existing as necessary. If membrane exists, lap new membrane minimum 12" beyond edge of undamaged existing membrane. Estimated at 1,000 SF of total wall area. See Alternate NO. 1 on revised Bid form.
- 14. Reinstall loose batt insulation below floors as required. Replace any missing or damaged insulation to match existing. Estimated at 1,000 SF of total floor area. See Alternate NO. 2 on revised Bid form.
- 15. Remove metal security grille at windows of Building RM 48. Patch window trim and prep prior to painting.
- 16. Prep and paint entire exterior to match adjacent buildings, including doors, frame, trim, siding, eave, fascia, equipment, and miscellaneous metal. District to provide colors. See Figure D below for Painting Schedule.

General Notes:

- 1. Contractor to submit all samples, product data, mock-ups, and shop drawings prior to work, as requested by District and Architect.
- 2. If any product is unavailable or Contractor requests to submit an alternative, Contractor to provide full submittal. Architect and District to determine if equal to specified product.
- 3. Follow all applicable manufacturer installation instructions and recommendations, including prep, paint primer, underlayment, adhesives, and fastening.
- 4. Materials, products, and install to match existing construction and finish where replacement is required unless otherwise noted above.



Figure A: Upper Cabinets to be Demolished



Figure B: Interiors Walls to be Demolished





Figure C: Walk-Off Mat

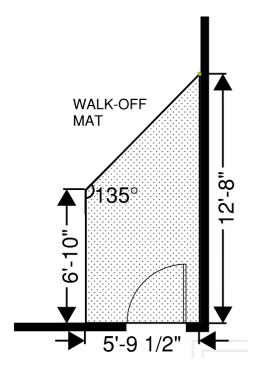


Figure D: Painting Schedule

SURFACE	DUNN-EDWARDS PAINTS
Exterior Wood & Plaster Walls	Evershield Eggshell
Gravel Stops and Wood Fascia	Aristoshield Semi- Gloss
Doors	Aristoshield Semi-Gloss
Door Jambs	Aristoshield Semi-Gloss
Window Trim	Aristoshield Semi-Gloss
Metal Handrails, Columns, Gutters, and Downspouts	Aristoshield Semi-Gloss
Interior Walls	Suprema Eggshell
Wooden Casework	Suprema Semi-gloss
Acoustic Ceiling Tile	Acoustikote
Wood Surface Primer	Ultra-grip Primer



Pre-Bid Questions:

Question 1: In regards to the steel ramps; are these prefabricated ramps from TMI Services that only need to be installed, or do the ramps need to be fabricated as well?

Response 1: Ramps are to be prefabricated by TMP services per DSA pre-approved ramp drawings in set. Contractor to coordinate work with ramp fabricator and provide installation.

Question 2: Is there a predetermined route for relocating the existing buildings from the play yard to their final location?

Response 2: No. This is means and methods by Contractor. Coordinate route and schedule with District.

Question 3: What are the required improvements if any to the exterior and interior of the buildings given their current condition?

Response 3: See Item 3 Building Improvements in Addendum 2.

Question 4: There are some issues with the existing Fire Alarm system at this site.

- A. The existing system has many troubles that are related to the devices, cabling and control boards.
- B. The existing system is not capable of installing a new fire alarm panel without replacing the existing devices throughout the site.
- C. The new devices that are CSFM approved, are not compatible with the existing discontinued panel and devices.
- D. Fire Vac system on the symbols list, has been discontinued.

Response 4: Build per DSA approved plans.

End of Addendum No. 2

REVISED BID FORM (Addendum 2)

To be returned with bid documents:

LEGAL NAME OF BIDI	DER:
Business Name:	
Contact Name:	
Business Address:	
Phone Number:	()
FAX:	()
E-Mail Address:	
Company Website:	
Check if Credit Card	payment is accepted for no additional charge:
Vendor accepts:	Visa American Express

The undersigned, hereby declare that we have carefully examined the location of the proposed Work, and have read and examined the Contract Documents, including all plans, specifications, and all addenda, if any, for the following Project:

REQUEST FOR BID NO. 1551 RELOCATABLE CLASSROOM MOVES BOSTONIA LANGUAGE ACADEMY

We hereby propose to furnish all labor, materials, equipment, tools, transportation, and services, and to discharge all duties and obligations necessary and required to perform and complete the Project for the following bid prices:

BASE BID	BID PRICE (IN WRITTEN FORM) Said Sum includes all applicable taxes and costs	BID PRICE (IN NUMBERS) Said Sum includes all applicable taxes and costs
BASE BID Bostonia Language Academy 1390 Broadway El Cajon, CA 92021		\$
ALLOWANCE *Owner Allowance for unforeseen conditions	Thirty-five thousand dollars and zero cents	<u>\$35,000.00</u>
TOTAL BASE BID (Base Bid plus Allowance)		\$

*The allowance is to be added to the contractor's base bid amount for Base Bid. All work performed under the allowance shall be directed by the District. The Contractor shall be responsible to document all costs incurred and provide all required documentation to the District within 60 days of execution of work, and prior to billing for said work. Each allowance shall be listed as a line item on the Contractor's Schedule of Values. A deductive change order will be prepared for any portion of allowances not used.

The Owner reserves the right to reject any or all bids, or to waive any irregularities or ities in any bids or in the bidding. The award of the contract, if made by the Owner, will be to the lowest responsive, responsible bidder therefore. The lowest bid will be determined on the basis of the TOTAL BASE BID plus All Alternate Bids. However, the District may choose to award the contract for the Total Base Bid alone or the Total Base Bid and any alternate or combination of alternates, at the District's sole option. Bidder must bid on all line items including Base Bid and Alternate(s) or the bid will be non-responsive.

ALTERNATE BIDS	Unit Price	Estimated Quantity	BID PRICE (IN NUMBERS) Said Sum includes all applicable taxes and costs
ALTERNATE NO. 1 Replacement of dry rot damaged T111 siding – Square footage costs to replace one full sheet T111 siding to match existing as needed. (Total Bid Price will be calculated based on Unit Cost x 1,000 sq ft. Actual quantities are unknown. Awarded contractor will be paid for or will provide a credit for actual quantities based on unit price) X AddDEDUCT	\$ per square foot	1,000 sq ft	Total Price for 1,000 sq ft
ALTERNATE NO. 2 Replacement of damaged or missing floor insulation — Square footage costs to provide and install insulation as needed (Total Bid Price will be calculated based on Unit Cost x 1,000 sq ft. Actual quantities are unknown. Awarded contractor will be paid for or will provide a credit for actual quantities based on unit price) X Add DEDUCT	\$ per square foot	1,000 sq ft	Total Price for 1,000 sq ft

In case of discrepancy between the written price and the numerical price, the written price shall prevail.

The undersigned agrees that this Bid Form constitutes a firm offer to the District which cannot be withdrawn for the number of calendar days indicated in the Notice Inviting Bids from and after the bid opening, or until a Contract for the Work is fully executed by the District and a third party, whichever is earlier.

The Contract duration shall commence on the date stated in the District's Notice to Proceed, and shall be completed by the Contractor in the time specified in the Contract Documents. In no case shall the Contractor commence construction prior to the date stated in the District's Notice to Proceed.

Bidder	certifies that it is licensed in accordance with the law providing for the registration of Contractors,
Licens is a joi	e No, Expiration Date, class of license If the bidder nt venture, each member of the joint venture must include the above information.
List all	other classifications for this license number
	is to indicate if they are a Certified DVBE Contractor (Attached is a copy of DVBE Certification issued by OSBCR, if applicable).
	Yes No
	is to indicate if a Good Faith Effort was made to include DVBE Subcontractors and suppliers in the dicating "No" does not disqualify the bid):
	Yes No
	ndersigned acknowledges receipt, understanding and full consideration of the following addenda to intract Documents.
	Addenda No
	Addenda No
	Addenda NoAddenda No
1.	The required Certification Of Contractor And Subcontractor Division Of Industrial Relations Registration form is attached hereto or bidder's bid will be rejected as nonresponsive.
2.	The required Contractor's Certificate Regarding Workers' Compensation is attached hereto or bidder's bid will be rejected as nonresponsive.
3.	The required bid security in the amount of not less than 10% of the Total Bid Price is attached hereto or bidder's bid will be rejected as nonresponsive.

The required Designation of Subcontractors is attached hereto or bidder's bid will be rejected as


nonresponsive.

4.

- 5. The Information of Bidders (List of Current Projects & List of Completed Projects) is attached hereto.
- 6. The required Asbestos-Free Materials Certification is attached hereto or bidder's bid will be rejected as nonresponsive.
- 7. The required Recycled Content Certification is attached hereto or bidder's bid will be rejected as nonresponsive.
- 8. The required Fingerprinting Requirement Certification is attached hereto or bidder's bid will be rejected as nonresponsive. (not required for this project)
- 9. The required Contractors Statement Regarding Maintaining a Drug Free Workplace is attached hereto or bidder's bid will be rejected as nonresponsive.
- 10. The required Non-Collusion Declaration is attached hereto or bidder's bid will be rejected as nonresponsive.
- 11. The required Iran Contracting Act form is attached hereto if bidder's bid total is \$1 million or more.

I hereby certify under penalty of perjury under the laws of the State of California, that all of the information submitted in connection with this Bid and all of the representations made herein are true and correct.

Business Name of Bidder	
Authorized Signature	
Name and Title	
Dated	

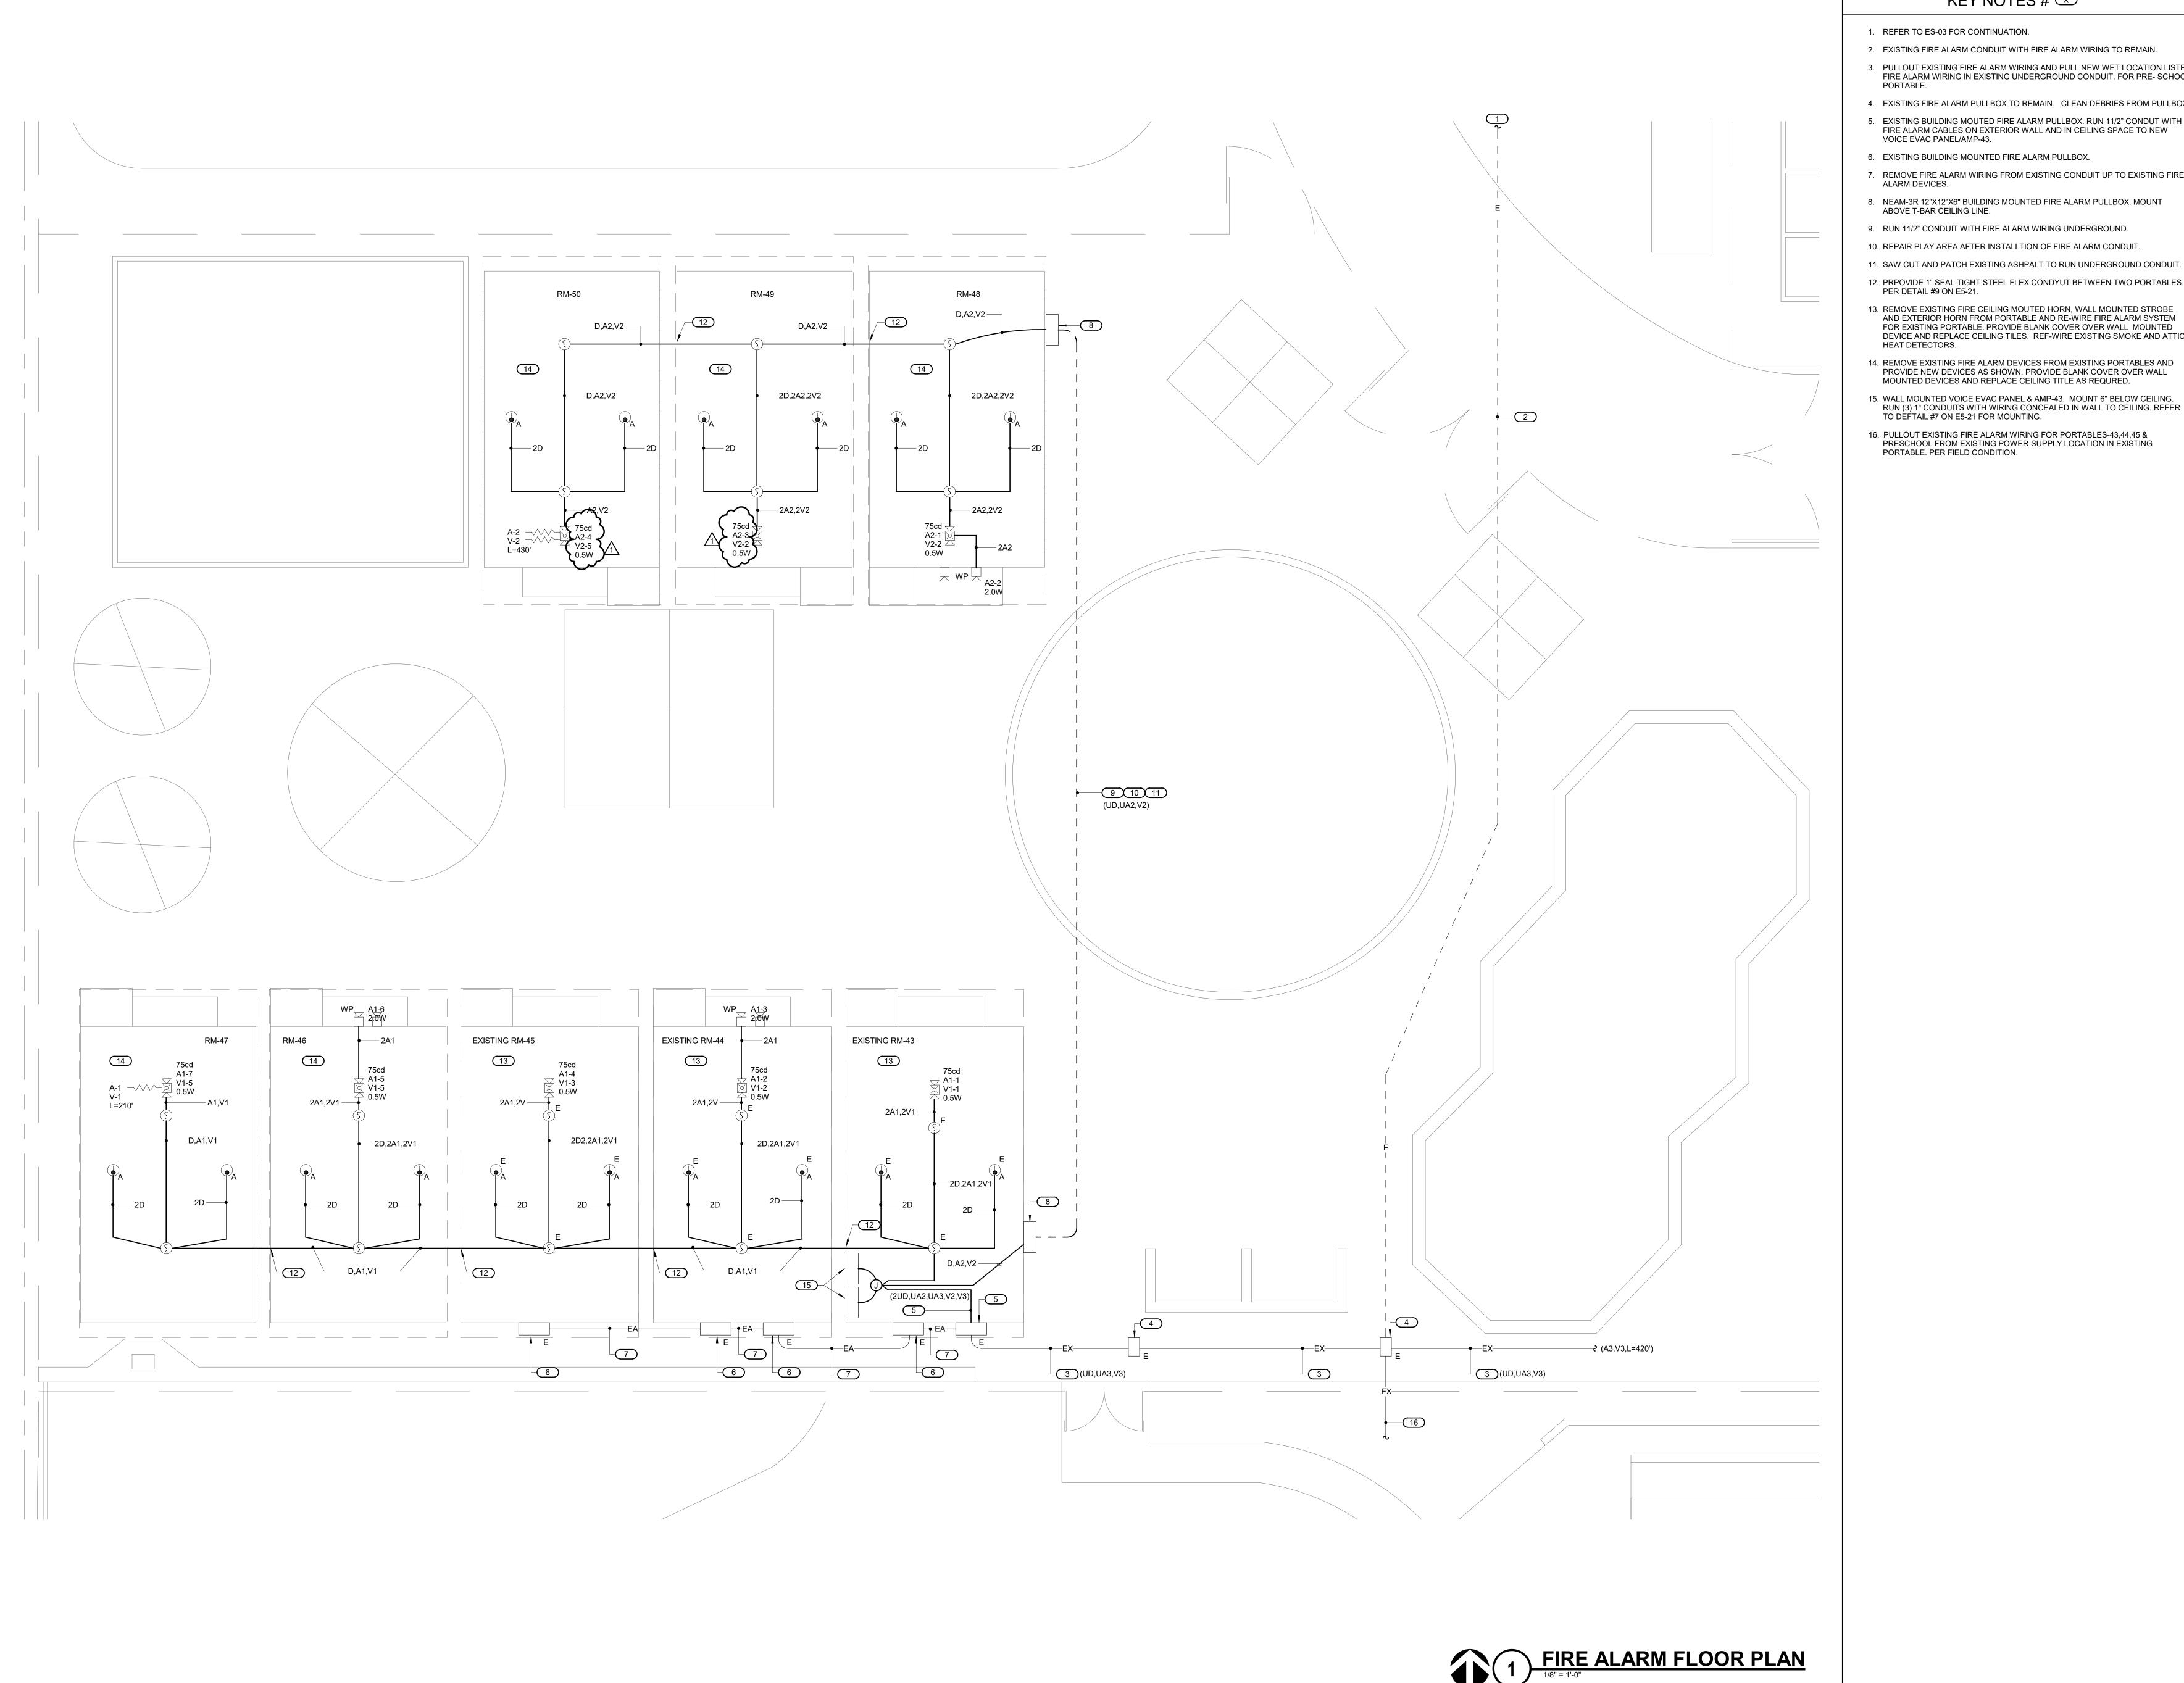

- 1. REFER TO ES-03 FOR CONTINUATION.
- 2. EXISTING FIRE ALARM CONDUIT WITH FIRE ALARM WIRING TO REMAIN.
- 3. PULLOUT EXISTING FIRE ALARM WIRING AND PULL NEW WET LOCATION LISTED FIRE ALARM WIRING IN EXISTING UNDERGROUND CONDUIT. FOR PRE- SCHOOL
- 4. EXISTING FIRE ALARM PULLBOX TO REMAIN. CLEAN DEBRIES FROM PULLBOX. 5. EXISTING BUILDING MOUTED FIRE ALARM PULLBOX. RUN 11/2" CONDUT WITH FIRE ALARM CABLES ON EXTERIOR WALL AND IN CEILING SPACE TO NEW
- 6. EXISTING BUILDING MOUNTED FIRE ALARM PULLBOX.
- 7. REMOVE FIRE ALARM WIRING FROM EXISTING CONDUIT UP TO EXISTING FIRE ALARM DEVICES.
- 8. NEAM-3R 12"X12"X6" BUILDING MOUNTED FIRE ALARM PULLBOX. MOUNT ABOVE T-BAR CEILING LINE.
- 9. RUN 11/2" CONDUIT WITH FIRE ALARM WIRING UNDERGROUND.
- 10. REPAIR PLAY AREA AFTER INSTALLTION OF FIRE ALARM CONDUIT.
- 12. PRPOVIDE 1" SEAL TIGHT STEEL FLEX CONDYUT BETWEEN TWO PORTABLES. PER DETAIL #9 ON E5-21.
- 13. REMOVE EXISTING FIRE CEILING MOUTED HORN, WALL MOUNTED STROBE AND EXTERIOR HORN FROM PORTABLE AND RE-WIRE FIRE ALARM SYSTEM FOR EXISTING PORTABLE. PROVIDE BLANK COVER OVER WALL MOUNTED DEVICE AND REPLACE CEILING TILES. REF-WIRE EXISTING SMOKE AND ATTIC
- 14. REMOVE EXISTING FIRE ALARM DEVICES FROM EXISTING PORTABLES AND PROVIDE NEW DEVICES AS SHOWN. PROVIDE BLANK COVER OVER WALL MOUNTED DEVICES AND REPLACE CEILING TITLE AS REQURED.
- 15. WALL MOUNTED VOICE EVAC PANEL & AMP-43. MOUNT 6" BELOW CEILING. RUN (3) 1" CONDUITS WITH WIRING CONCEALED IN WALL TO CEILING. REFER TO DEFTAIL #7 ON E5-21 FOR MOUNTING.
- 16. PULLOUT EXISTING FIRE ALARM WIRING FOR PORTABLES-43,44,45 & PRESCHOOL FROM EXISTING POWER SUPPLY LOCATION IN EXISTING PORTABLE. PER FIELD CONDITION.



BOSTONIA LANGUAGE **ACADEMY**

1390 East Broadway El Cajon, CA 92021

Modular Classroom Buildings Relocation

Date Issued For 08/14/2020 Design Development

08/17/2020 100% CD 11/06/2020 DSA BACKCHECK 11/19/2020 DSA BACKCHECK 03/04/2021 ADDENDUM NO. 1

901 VIA PIEMONTE SUITE 400 ONTARIO, CA 91764 909.477.6915 FAX: 909.477.6916 www.imegcorp.com #20003155.00



(619) 318-3800 WWW.HED.DESIGN



FIRE ALARM FLOOR PLAN

EF-01

			(E) FACP		RPS-43					
DESCRIPTION		SUPERVISORY	/ CURRENT	ALARM CURRENT			SUPERVISORY CURRENT		ALARM CURF	ENT
	QTY	UNIT	TOTAL	UNIT	TOTAL	QTY	UNIT	TOTAL	UNIT	TOTAL
(E) FACP AND DEVICES	1	0.279	0.279	6.75	6.75					
REMOTE POWER SUPPLY	1	0.00000	0.00000		0.00000	1	0.07500	0.07500	0.17500	0.1750
SMOKE DETECTOR	10	0.00030	0.003	0.00650	0.065					
N) ATTIC HEAT DETECTOR	10	0.00035	0.003	0.00500	0.065					
CONTROL MODULE	2	0.00375	0.00075	0.00650	0.013					
MONITOR MODULE	0	-	-	-	-					
STROBE (15cd)						2			0.06600	0.13
STROBE (30cd)						0			0.09400	0.0000
STROBE (75cd)						0			0.15800	0.0000
STROBE (110cd)						0			0.20200	0.0000
SPEAKER/STROBE COMBO (15cd)						0			0.066	0.0000
SPEAKER/STROBE COMBO (30cd)						0			0.094	0.0000
SPEAKER/STROBE COMBO (75cd)						9			0.158	1.42
SPEAKER/STROBE COMBO (110cd)						0			0.21200	0.0000
SPEAKER - WEATHERPROOF						0			0.06900	0.0000
TOTAL			0.293		6.89			0.075		1.72
		0.293	Α	6.89	A		0.075	A	1.729	4
		<u>x 24</u>	Н	x 0.25	Н		<u>x 24</u>	Н	<u>x 0.25</u> l	4
		7.02	AH	1.72	АН		1.800	AH	0.43	λH
FIRE ALARM DEVICE QUANTITIES ARE			7.02	AH, STANDBY				1.800	AH, STANDBY	
SHOWN SOLELY FOR ENGINEERING			1.72	AH, ALARM				0.43	AH, ALARM	
CALCULATIONS. IT SHALL NOT BE USED			8.74	AH, SUB TOTA	L			2.23	AH, SUB TOTA	L
FOR BID QUANTITY TAKEOFFS.		04	10.49AH	(W/20% SAFE	ΓΥ MARGIN)				(W/20% SAFET	Y MARGIN
			AH, BATTERY C					AH, BATTERY CA		
		13.51	AH, SPARE CAI	PACITY			4.3	AH, SPARE CAP	ACITY	

SEQUENCE OF OPERATION										
	BUILDING POWER FAILURE	SMOKE	ATTIC HEAT DETECTOR	OPEN SHORT OR GROUND						
ANNUNCIATE AT FIRE CONTROL PANEL (ALARM, SUPERVISION & TROUBLE)	YES	YES	YES	YES						
SOUND CONTROL PANEL TROUBLE BUZZER	YES	ON WIRING FAULT	ON WIRING FAULT	YES						
ACTIVATE AUDIBLE ALARM SIGNALS (UNTIL SILENCE)	NO	YES	YES	NO						
ACTIVATE VOICE SIGNALS (UNTIL SILENCE)	NO	YES	YES	NO						
ACTIVATE VISUAL ALARM SIGNALS (UNTIL RESET)	NO	YES	YES	NO						
REPORT TO CENTRAL STATION	YES	YES	YES	NO						
ANNUNCIATE AT FAA ANNUNCIATOR PANEL	YES	YES	YES	NO						


STROBE SIG	NAL CIRCUIT	SCHEDULE																						
BLDG.	PANEL	CIRCUIT	15cd	STROBE	30cd	STROBE	75cd	STROBE	110cd	STROBE	15cd	STROBE/SPEAKER	30cd S	STROBE/SPEAKER	75cd S1	TROBE/SPEAKER	110cd	STROBE/SPEAKER	TOTAL	WIRE	SIZE (CU)			
NO.	NO.	NO.	0.066	AMPS	0.094	AMPS	0.158	AMPS	0.202	AMPS	0.066	AMPS (*)	0.094 A	AMPS (*)	0.158 AM	MPS (*)	0.202	AMPS (*)	CIRCUIT		CIRC.	FEEDER LENGTH IN FT.	VOLTAGE	
			NO.	AMPS	NO.	AMPS	NO.	AMPS	NO.	AMPS	AMPS	#	MILLS	(FROM PANEL TO EOL)	DROP (%)	REMARKS								
RELOS	RPS-43	V1	0	0.000	0	0.000	0	0.000	0	0.000	0	0.000	0	0.000	5	0.790	0	0.000	0.790	12	6530	210	2.3	
RELOS	RPS-43	V2	0	0.000	0	0.000	0	0.000	0	0.000	0	0.000	0	0.000	3	0.474	0	0.000	0.474	12	6530	430	2.8	
RELOS	RPS-43	V3	2	0.132	0	0.000	0	0.000	0	0.000	0	0.000	0	0.000	1	0.158	0	0.000	0.290	12	6530	410	1.6	
RELOS	RPS-43	V4	0	0.000	0	0.000	0	0.000	0	0.000	0	0.000	0	0.000	0	0.000	0	0.000	0.000	0	0	0	0.00	SPARE

		WIRE		CIRCUIT	APPI I	ANCES OLI	JANTITIES / TAP VAL	LIES				TOTAL	ESTIMATED		DROP PER CIRCUIT MAXIMUM	TOTAL
	PANEL	GAUGE	.	CIRCOIT	SPEAK		SPEAKER	SPEAK	FR	SPF	AKER	CIRCUIT	CIRCUIT	ACTUAL	ALLOWABLE	CIRCUIT
PEAKER CIRCUIT DESCRIPTION	CIRCUIT	(18, 16, 14		(25 OR	TAPPED AT		TAPPED AT	TAPPED AT		TAPPED AT		LOAD	LENGTH	WIRE/LOSS	CKT. LENGTH	RESISTANCE
	NUMBER	12)		70 VRMS)	0.25	Watts	0.5 Watts	1	Watt	2	Watts	(WATTS)	(FEET)	(dB)	(FEET)	(OHMS)
RELOS	A1	16	₩G	70 Vrms	0		2.5	0		4	1	6.5 Watts	210 ft.	-0.08 dB	30,040 ft.	3.4 Oh
RELOS	A2	16 /	WG	70 Vrms	0		1.5	0		2	2	3.5 Watts	430 ft.	-0.05 dB	43,391 ft.	2.9 Oh
RELOS	A3	16	AWG	70 Vrms	0		0.5	0		2	2	2.5 Watts	410 ft.	0.00 dB	0 ft.	0.0 Oh
RELOS (SPARE)	0	16	WG	70 Vrms	0		0	0		C)	0.00 Watts	0 ft.	0.00 dB	0 ft.	0.0 Oh
	<u>'</u>		,		Applian	ce Summar	у	'				Total Load (Watts)				
		<u> </u>			0		4.5	0		8	3	12.50				

	FIRE ALARM SYMBOL LIST											
SYMBOL	MFG.	PART NO.	DESCRIPTION	REMARKS	CSFM LISTING NO.							
			FIRE ALARM CONDUIT RUN. 3\4"C. MIN. UNLESS INDICATED OTHERWISE IN THE DWGS. REFER TO DWGS. & SPECS. REQUIRED WIRING.									
-			END OF LINE RESISTOR "EOL"									
FATC			24"x36"x4" FIRE ALARM TERM. CAB.									
FACP	GAMEWELL FCI	7200	EXISTING FIRE ALARM CONTROL PANEL WITH DIGITAL ALARM COMMUNICATOR TRANSMITTER		7165-0694:174							
RPS	GAMEWELL FCI	GFPS-9	REMOTE POWER SUPPLY		7300-1703:0167							
VECP	GAMEWELL FCI	FIRE VAC IV	VOICE EVACUATION PANEL		6911-1703:0112							
②	GAMEWELL FCI SYSTEM SENSOR	ASD-PL2F B210LP	SMOKE DETECTOR - PHOTOELECTRIC DETECTOR BASE		7272-1703:0121 7300-1653:0109							
\bigcirc_{A}	GAMEWELL FCI SYSTEM SENSOR	ATD-HL2F	HEAT DET. MNTD. IN ATTIC AND BELOW PLATFORM, 194°F FIXED TEMPERATURE DETECTOR BASE		7270-1703:0115 7300-1653:0109							
)O(15cd	SYSTEM SENSOR	SR	STROBE (ADJUSTABLE) WALL MOUNT WITH CANDELA (cd) RATING AS SHOWN	SEE DETAIL FOR WIRING & MOUNTING	7125-1653:0186							
15cd 1/2W	SYSTEM SENSOR	SPSCR	SPEAKER/STROBE (ADJUSTABLE) CEILING MOUNT WITH CANDELA (cd) & SPEAKER RATING AS SHOWN	SEE DETAIL FOR WIRING & MOUNTING	7320-1653:0201							
□ WP 2W	SYSTEM SENSOR	SPRK-MWBB	WEATHERPROOF SPEAKER WITH HORN RATING AS SHOWN	MOUNT AT +90" A.F.F.	7320-1653:0201							
sc	GAMEWELL FCI	AOM-2SF	ADDRESSABLE OUTPUT SUPERVISED CONTROL MODULE RELAY		7300-1703:0102							
M	GAMEWELL FCI	AMM-2F	MONITOR MODULE		7300-1703:0102							
С	GAMEWELL FCI	AM-2RF	CONTROL MODULE		7300-1703:0102							

MARGIN OF SAFETY, TAKING INTO CONSIDERATION THE ACTUAL INSTALLED CIRCUIT ROUTING MAY DIFFER FROM WHAT IS

SHOWN ON THE SHOP DRAWINGS. IF THE ACTUAL CIRCUIT LENGTH IS GOING TO EXCEED THE MAXIMUM ALLOWABLE CIRCUIT

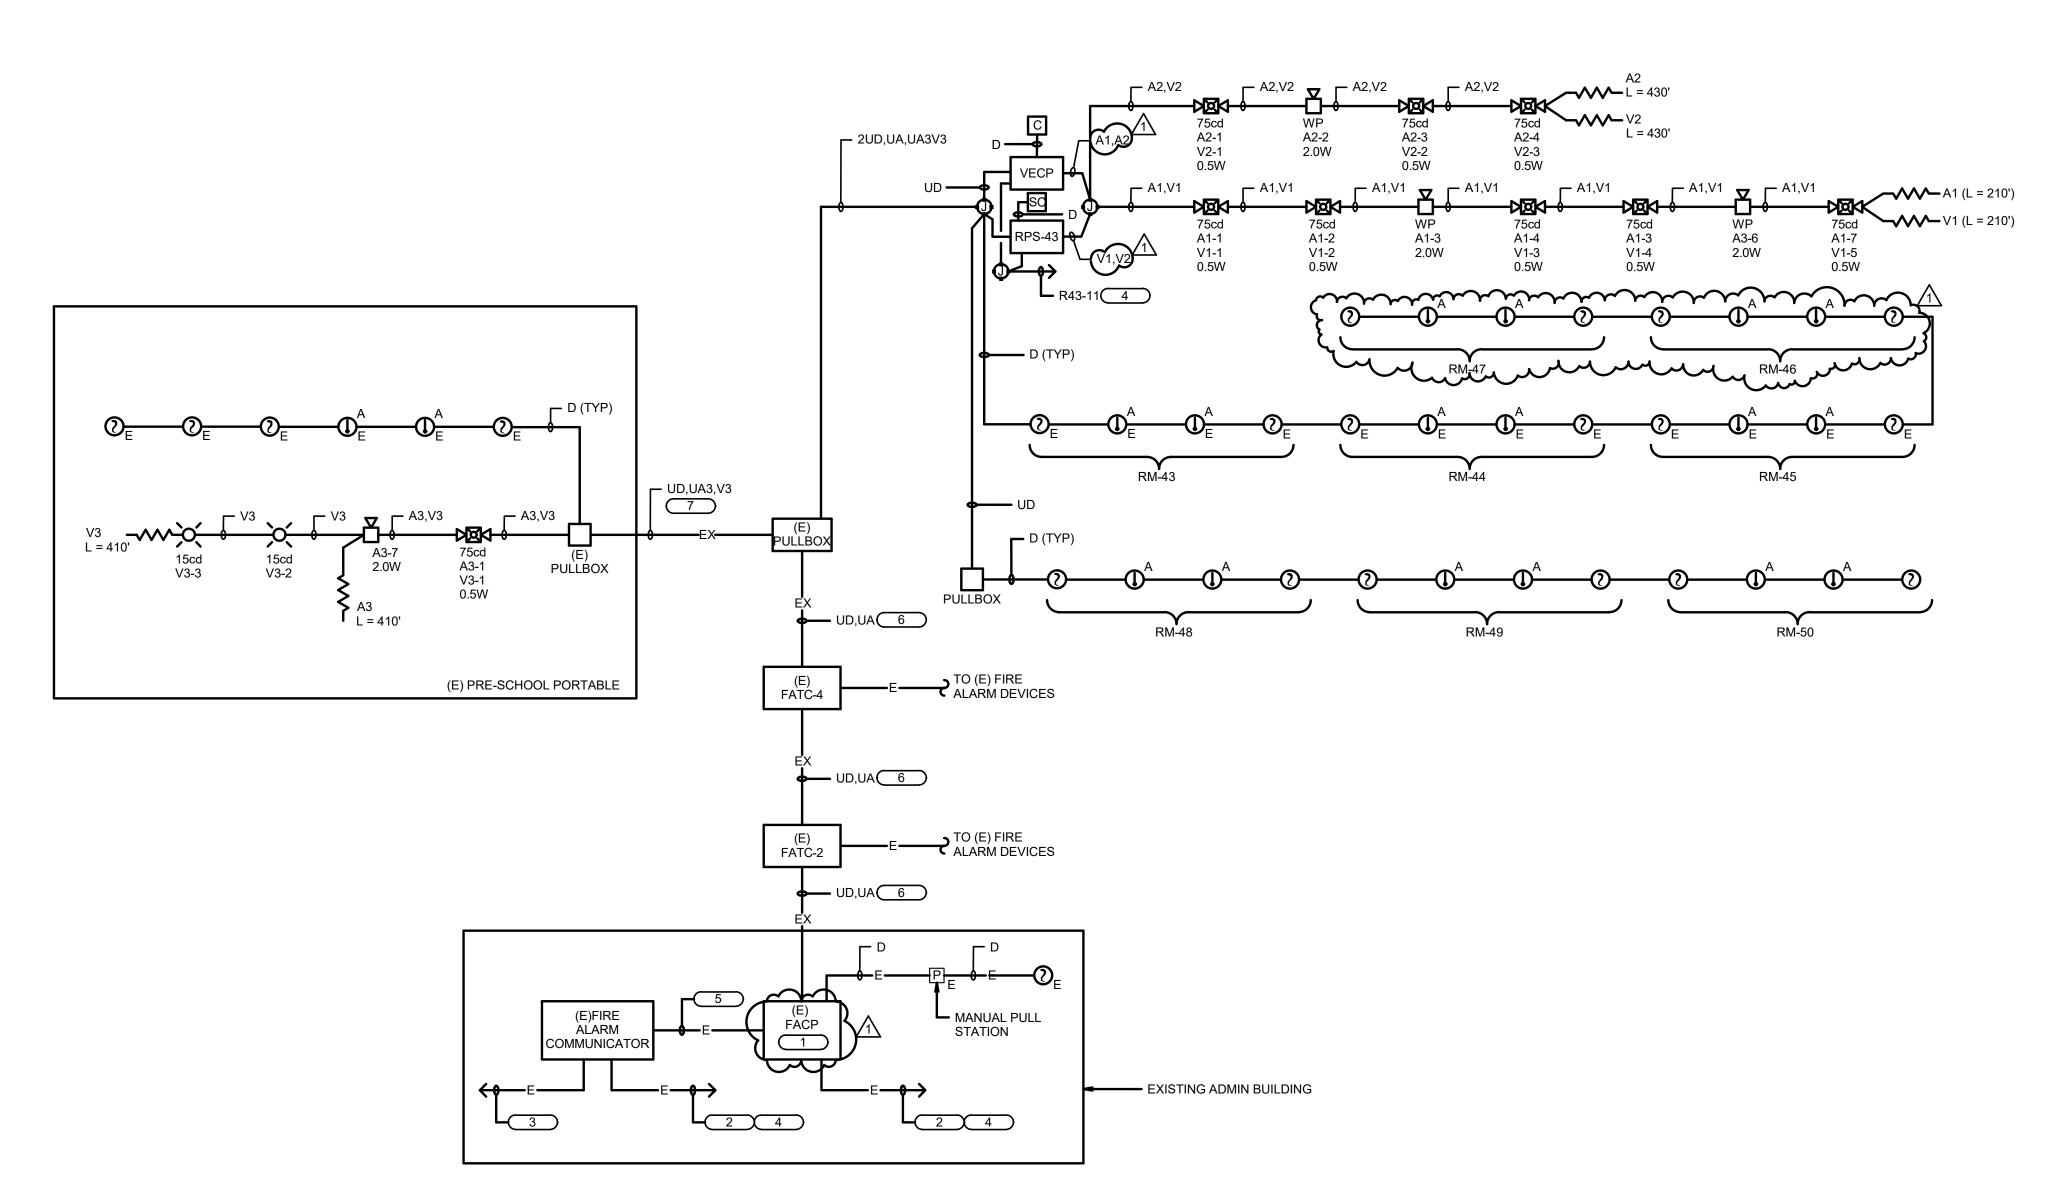

FIRE ALARM NOTES

MINIMUM OF 3 YEARS, IN A DEDICATED FIRE ALARM RECORD DOCUMENT CABINET IN ACCORDANCE WITH NFPA 72, 7.7.2.

38. THE DISTRICT SHALL RETAIN RECORD DRAWINGS ON THE PREMISES FOR A

- EVERY NEW FIRE ALARM SYSTEM SHALL PROVIDE A DOCUMENTATION CABINET, INSTALLED AT THE SYSTEM CONTROL PANEL.
- THE DOCUMENTATION CABINET SHALL BE PROMINENTLY LABELED,
- "SYSTEM RECORD DOCUMENTS". ALL RECORED AND TESTING DOCUMENTATION SHALL BE STORED IN THE
- CONTENTS SHALL BE ACCESSIBLE BY AUTHORIZED PERSONNEL ONLY.
- WHERE CABINET IS INSTALLED IN A LOCATION OTHER THAN THE SYSTEM CONTROL UNIT, ITS LOCATION SHALL BE IDENTIFIED AT THE
- SYSTEM DOCUMENTS AS APPLICABLE:
- RECORD DRAWINGS/AS-BUILTS

SYSTEM CONTROL UNIT.

- EQUIPMENT CUT SHEETS & CA SFM LISTINGS
- ALTERNATIVE MEANS AND METHODS
- PERFORMANCE BASED DESIGN DOCUMENTATION (NFPA 72, 7.3.7)
- SYSTEM RECORED OF COMPLETION & ANY SUPPLEMENTAL INSPECTION AND TESTING DOCUMENTATION (NFPA 72, 7.8.2)
- EMERGENCY RESPONSE PLAN (NFPA 72, 7.3.8)

EVALUATION DOCUMENTATION (NFPA 72, 7.3.9)

SOFTWARE & FIRMWARE CONTROL DOCUMENTATION (NFPA 72, 23.2.2)

39. EXTRA DEVICES

- DUE TO UNFORESEEN CONDITION, THE FOLLOWING EXTRA DEVICES SHALL BE INCLUDED IN THE CONTRACTORS BID:
- a. SMOKE DETECTORS 4 EACH b. ATTIC HEAT DETECTORS 4 EACH
- c. SPEAKER/STROBE 2 EACH d. STROBE 2 EACH e. SPEAKER 2 EACH
- FOR BID PURPOSES, ALLOW TWENTY (20) FEET OF CONDUIT AND ITS SUPPORT SYSTEM TO INCLUDE FITTINGS, WIRES AND LABOR FOR EACH OF THE DEVICES LISTED ABOVE.

KEY NOTES

- 1 EXISTING LUSH WALL MOUNTED FCI#7200A FIRE ALARM CONTROL PANEL (DSA #A59184 LOCATED IN RECEPTION AREA TO REMAIN. RE-PROGRAM PANEL TO ADD 1 NEW DEVICES.
- 2 EXISTING CIRCUIT WITH LOCK-ON DEVICE TO BREAKER AND RED LABEL TO CIRCUIT ID.
- 3 EXISTING (2) TELEPHONE LINES FROM TEL. BOARD.
- PROVIDE "LOCK-ON" DEVICE TO BREAKER HANDLE AND RED LABEL INDICATING
- 5 EXISTING FIRE ALARM WIRING.
- 6 PULL NEW FIRE ALARM WIRING IN EXISTING CONDUIT ALONG WITH EXISTING FIRE ALARM WIRING.
- 7 REMOVE EXISTING FIRE ALARM WIRING AND PULL NEW WIRING AS SHOWN.

THIS IS A COMPLETE AUTOMATIC FIRE ALARM SYSTEM PLAN SUBMITTAL PER

2019 CFC 907.2.3 AND 2019 CBC 907.2.3.

. THE NEW FIRE ALARM SYSTEM EXTENSION IS CONFIGURED TO A FULLY

AUTOMATIC SYSTEM, AS IS THE EXISTING INSTALLATION.

- THE FIRE ALARM SYSTEM INDICATED ON THESE DRAWINGS IS APPROVED BY CALIFORNIA STATE FIRE MARSHAL AND SHALL BE INSTALLED AS DESCRIBED ON THESE DRAWINGS AND AS NOTED IN THE SPECIFICATIONS. ANY CHANGES TO THESE PLANS, I.E., DELETION, RELOCATION OR ADDING OF DEVICES SHALL BE RESUBMITTED TO THE STATE FIRE MARSHAL FOR APPROVAL.
- INSTALLATION OF FIRE ALARM SYSTEM MAY START AFTER TTG RECEIVES THESE APPROVED DRAWINGS. A.O.R. SHALL STAMP AND SIGN ALL DRAWINGS.
- 4. ALL WIRING AND INITIATING DEVICES SHALL BE SUPERVISED TO THE PRINCIPAL POINT OF ANNUNCIATION (F/A PANEL TO SUPERVISE ALL CIRCUITS AND INITIATING DEVICES).
- 5. WIRING SHALL NOT BE LOOPED THROUGH DEVICES; WIRE MUST BE CUT FOR IN AND FOR OUT.
- 6. ALL WIRING TO BE IN CONDUIT.
- 7. ALL TERMINATIONS IN JUNCTION BOXES, PULL BOXES AND TERMINAL CABINETS SHALL BE ON BOX MOUNTED TERMINAL BLOCKS. DO NOT USE WIRE NUTS FOR SPLICING. DO NOT SPLICE WIRES IN ANY BOXES.
- 8. ALL CONDUIT SIZES INDICATED IN DRAWINGS ARE MINIMUM. CONTRACTOR TO ADJUST SIZE FOR FIELD CONDITIONS BUT SHALL NOT BE SMALLER THAN 3/4 INCH.
- 9. ALL FIRE ALARM WIRING MUST TEST FREE OF OPENS, SHORTS AND GROUNDS.
- 10. FIRE ALARM DRAWINGS ARE SCHEMATIC IN NATURE ONLY. CONTRACTOR TO ROUTE CONDUIT AS FIELD CONDITIONS INDICATE.
- 11. CONDUIT AND JUNCTION/BACK BOXES ARE NOT TO BE USED FOR UNRELATED WIRING.
- 12. THE SYSTEM SHALL CONFORM TO TITLES 19 AND 24 AS APPLICABLE TO THIS PROJECT. 13. UPON COMPLETION OF SYSTEM INSTALLATION, THE SYSTEM SHALL BE TESTED IN THE
- PRESENCE OF, AND IN A MANNER ACCEPTABLE TO, THE ENFORCING AGENCY.
- 14. THE CONTRACTOR SHALL REPROGRAM AND CERTIFY ADDRESSABLE FIRE ALARM CONTROL PANEL TO ACCOMMODATE ADDITIONAL DEVICES.
- 15. FIRE ALARM SYSTEM SHALL BE INSTALLED BY FACTORY AUTHORIZED REPRESENTITIVE.
- 16. CONDUCTOR LENGTHS AND DEVICE QUANTITIES ARE SHOWN SOLELY FOR CALCULATION PURPOSES ONLY, AND SHALL NOT BE USED FOR BID TAKE-OFF.
- 7. THE FIRE ALARM SYSTEM SHALL CONFORM TO ARTICLE 760 OF CALIFORNIA ELECTRICAL CODE. INSTALLATION OF THE FIRE ALARM SYSTEM SHALL NOT BE STARTED UNTIL DETAILED PLANS AND SPECIFICATIONS, INCLUDING CALIFORNIA STATE FIRE MARSHAL LISTING NUMBERS FOR EACH COMPONENT OF THE SYSTEM HAVE BEEN APPROVED BY DSA-ORS. UPON COMPLETION OF THE INSTALLATION OF THE FIRE ALARM SYSTEM A SATISFACTORY TEST OF THE ENTIRE SYSTEM SHALL BE MADE IN THE PRESENCE OF THE FIRE AUTHORITY HAVING JURISDICTION.
- 18. ALL FIRE ALARM AND COMMUNICATIONS WIRES AND CABLES SHALL BE ONE CONTINUOUS LENGTH FROM A BUILDING TERMINAL CABINET TO ANOTHER BUILDING TERMINAL CABINET OR JUNCTION BOX. ABSOLUTELY NO SUBGRADE SPLICES WILL BE PERMITTED! PROVIDE TERMINAL BLOCKS WITH MOUNTING IN TERMINAL CABINETS ONLY AS
- REQUIRED. 9. EVERY ALARM SIGNALING DEVICE INSTALLED SHALL BE OF THE SAME BASIC TYPE (BELLS, HORNS, CHIMES, SPEAKERS, ETC.) AS ALL OTHER SIGNALING DEVICES IN THE FACILITY, (EXCEPTION: ANY SIGNALING DEVICES REQUIRED FOR THE DEAF OR HEARING IMPAIRED PER 2016 NFPA-72.
- ²⁰. INSULATED CONDUCTORS USED IN WET LOCATIONS SHALL BE (1) LEAD-COVERED, (2) TYPES RHW.TW. THW. THWN, THWN, XHHW; OR (3) OF A TYPE LISTED FOR USE IN WET LOCATIONS. CABLES OF ONE OR MORE CONDUCTORS USED IN WET LOCATIONS SHALL BE OF A TYPE LISTED FOR USE IN WET LOCATIONS. CONDUCTORS USED FOR DIRECT BURIAL APPLICATIONS SHALL BE OF A TYPE LISTED FOR SUCH USE (PER 2016 CEC ARTICLE 310).
- 1. THE FIRE ALARM DEVICE SUPPLIER SHALL FURNISH ALL SURFACE MOUNT ENCLOSURES FOR PULLSTATIONS AND SKIRTS FOR ALL VISUAL AND AUDIO VISUAL DEVICES TO CONCEAL 4S BACK BOXES.
- ^{22.} AFTER THE SYSTEM IS COMPLETED, ALL ADDRESSABLE DEVICES SHALL BE PROGRAMMED AT THE FACP ACCORDING TO THE ACTUAL BUILDING ROOM NUMBER. THE CONTRACTOR IS RESPONSIBLE TO COORDINATE WITH THE SCHOOL DISTRICT TO OBTAIN ACCURATE ROOM NUMBER INFORMATION.
- 23. POWER SERVICES SHALL BE ON A DEDICATED BRANCH CIRCUIT WITH A RED MARKING & LOCKING DEVICE AND IDENTIFIED AS "FIRE ALARM CIRCUIT CONTROL".
- 24. PROVIDE CALIFORNIA TEMPORAL-THREE TONE DISTINCTIVE FIRE ALARM SOUND. (2019 CFC SEC. 907.6.2.1.3 & 2016 NFPA 72 SEC. 18.4.2.1)
- 25. AUDIBLE FIRE ALARM SOUND LEVEL SHALL BE AT LEAST 15 dBA ABOVE THE AVERAGE AMBIENT SOUND LEVEL IN ALL OCCUPIABLE AREAS (2019 NFPA 72 SEC. 18.4.3.1) (i.e. CLASSROOM AVERAGE AMBIENT ROOM NOISE IS45dBA PLUS 15dBA EQUAL = 60dBA MINIMUM ALARM TONE REQUIRED)
- 26. STROBES SHALL FLASH AT A RATE NOT EXCEEDING TWO FLASHES PER SECOND NOR BE LESS THAN ONE FLASH EVERY SECOND. (2019 NFPA 72 SEC. 18.5.3.1)
- ^{27.} FINAL FIRE ALARM TEST SHALL BE MADE WITH THE DSA INSPECTOR OF RECORD (IOR). LOCAL FIRE AUTHORITY SHALL BE NOTIFIED OF DATE AND TIME OF FINAL ALARM TESTING AND SHALL ASSIST/WITNESS SUCH TESTING WHEN ABLE.
- 28. FIRE ALARM CONTRACTOR SHALL PROVIDE A "RECORD OF COMPLETION" TO THE INSPECTOR OF RECORD (IOR)/DSA AFTER COMPLETION OF OPERATION ACCEPTANCE TEST. (2016 NFPA 72 SEC. 7.5.6. &
- 29. UNLESS SPECIFICALLY SHOWN ON THESE PLANS NO STRUCTURAL MEMBER SHALL BE CUT, DRILLED, NOR NOTCHED WITHOUT PRIOR WRITTEN AUTHORIZATION FROM THE STRUCTURAL ENGINEER AND DISTRICT STRUCTURAL ENGINEER FROM THE DIVISION OF THE STATE ARCHITECT.
- 30. THE INSTALLING CONTRACTOR SHALL PROVIDE A STATEMENT OF COMPLIANCE ALONG WITH THE REQUEST FOR ACCEPTANCE TESTING PER 2019 NFPA-72.
- 31. OCCUPANCY OF THE BUILDINGS IS PROHIBITED UNTIL THE FIRE ALARM SYSTEM IS COMPLETED, TESTED, AND APPROVED PER 2016 NFPA 72.
- 32. SMOKE DETECTORS SHALL BE TESTED PER THE METHOD SHOWN IN 2019 CFC.
- 33. REACCEPTANCE TESTING SHALL BE PERFORMED AS REQUIRED BY 2016 NFPA 72.
- 34. ALL BACKUP BATTERIES FOR FIRE ALARM SYSTEM EQUIPMENT SHALL BE VISUALLY CHECKED FOR DATE OF INSTALLATION. ALL BATTERIES OVER 5 YEARS OLD SHALL BE REPLACED WITH NEW BATTERIES OF THE SAME MANUFACTURER, TYPE, AND AMP-HOUR
- 35. FIRE ALARM SYSTEMS SHALL BE SUPERVISED BY AN APPROVED UL LISTED CENTRAL STATION, OR REMOTE STATION (UUFX) MONITORING COMPANY (UUJS) (2019 CFC, 907.2.3.5, 907.6.5.3.)
- 36. A SINGLE FAULT ON A PATHWAY CONNECTED TO THE ADDRESSABLE DEVICES SHALL NOT CAUSE THE LOSS OF MORE THAN 50 ADDRESSABLE DEVICES (2019 NFPA 72

EIDE ALADMAMDE DECIGNATION GUADT

┝	IRE ALARM WIRE DE	SIGNATIC)N (CHARI
SYMBOL	DESCRIPTION	NUMBER OF CONDUCTORS	SIZE	TYPE
V	NOTIFICATION APPLIANCE CIRCUIT	TWO	#12	THHN/THWN
D	SIGNALING LINE CIRCUIT (SLC) - ABOVE GRADE	TWISTED PAIR 1	#16	WEST PENN #D990
UD	SIGNALING LINE CIRCUIT (SLC) - BELOW GRADE	TWISTED PAIR	#16	WEST PENN #AQC225
Р	24 POWER	TWO	2#12	THHN/THWN
Α	VOICE EVACUATION CIRCUIT - ABOVE GRADE	TWISTED PAIR	#16	WEST PENN #D991
UA	VOICE EVACUATION CIRCUIT - BELOW GRADE	AQUA SEAL TWISTED SHIELDED PAIR	2#16	WEST PENN #AQC294

1. SYMBOL INDICATES QTY & I.D. OF CIRCUIT. I.E. 2N2, INDICATES (2) 2#12 CI CABLE FOR N CIRCUIT 2. 2. ALL CONDUIT USED FOR FIRE ALARM SHALL BE 3/4" MINIMUM ABOVE GRADE AND 1" MINIMUM BELOW GRADE UNLESS NOTED OTHERWISE. 3. ALL WIRING USED IN UNDERGROUND CONDUITS SHALL BE LISTED FOR WET AREA APPLICATION, IN IN ACCORDANCE WITH CEC 760.

> FIRE ALARM SYSTEM IS ADDRESSABLE. NAC DEVICES ARE 2-WIRE DEVICES. ALL NAC CIRCUITS ARE SYNCHRONIZED.

THE CONTRACTOR SHALL PROVIDE FIRE WATCH DURING DURATION OF FIRE ALARM SYSTEM SHUT-DOWN.



BOSTONIA

1390 East Broadway El Cajon, CA 92021

Modular Classroom Buildings Relocation

Date Issued For 08/14/2020 Design Development 08/17/2020 100% CD

11/06/2020 DSA BACKCHECK 11/19/2020 DSA BACKCHECK 1 03/04/2021 ADDENDUM NO. 1





92101 USA (619) 318-3800 WWW.HED.DESIGN



2020-06795-000

SCHEDULES, CALCS & NOTES E6-21



SCOTSMAN 24' x 40' RELOCATABLE CLASSROOM

INDEX OF DRAWINGS

ROOF FRAMING PLAN & BUILDING SECTIONS

DESCRIPTION						
1. OCCUPANCY CLASS - El	6. CONSTRUCTION - TYPE V, NON RATED					
2. NUMBER OF STORIES - 1	7. AREA PER FLOOR - 947 S.F.					
3. ADDN. TO EXIST. BLDG NO	8. AREA EXIST. BLDG. — NOT APPLICABLE					
4. TOTAL SQUARE FEET - 23'-8" x 40'-0"	9. CAPACITY - 48 PERSONS					
5. AUTO. FIRE SPRINKLERS - NONE	10. HEIGHT IN FEET - 12'-1" MIN. TO 13'-3" MAX.					

tesish Loads:

ROOF LIVE LOAD - 20 PSF FLOOR LIVE LOAD - 50 PSF RAMP LIVELOAD - 100 PSF SEIS ZONE - IV

pergraph of this clan does not authorize at approve or is arrivation or deviction transapplicable fegulations. Final approval to project to held inspection One set of as proved plans shall be available on the project site at all times.


STRUCTURAL SAFTY SE 19:41


A51190 JAN 13 1989


- ALL WORK OF ALL TRAPES SHALL COMPLY WITH THE REQUIREMENTS OF TITLE 19,21,24 OF CALIF. ADMINISTRATIVE CODE, 1979 LIBC \$ 1965 LIMC UPC PIBO NATIONAL ELECT, CODE AND APPLICABLE
- ALL CHANGES TO APPROVED PLANS WILL REQUIRE WRITTEN APPROVAL BY THE AGENCY APCHITECT. OSA AND CLA PRIOR TO BEGINING THE WORK
- IS NOT A PART OF THIS CONTRACT; R. PREPARAMON AND CLEARING OF SITE
 - AND GRAPING TO WITHIN 9" OF LEVEL GRAPE b removal of ture and other site pebris. C. BUILDING PAD BEARING CAPACITY OF AT LEAST 1000 PSF,
- d. INSTALLATION OF SITE UTILITIES AND COORDINATION OF ON-SITE FIRE ALARM
- GENERAL REQUIREMENTS FOR CONSTRUCTION: REFER TO SHEET S.1.
- 5. FINISH NOTES AND MATERIAL SPECIFICATIONS: PETER TO SHEET A-1 & A-3,





DESTRUCTED STORE STUDIES ACCANICOSSITE DA PERSON

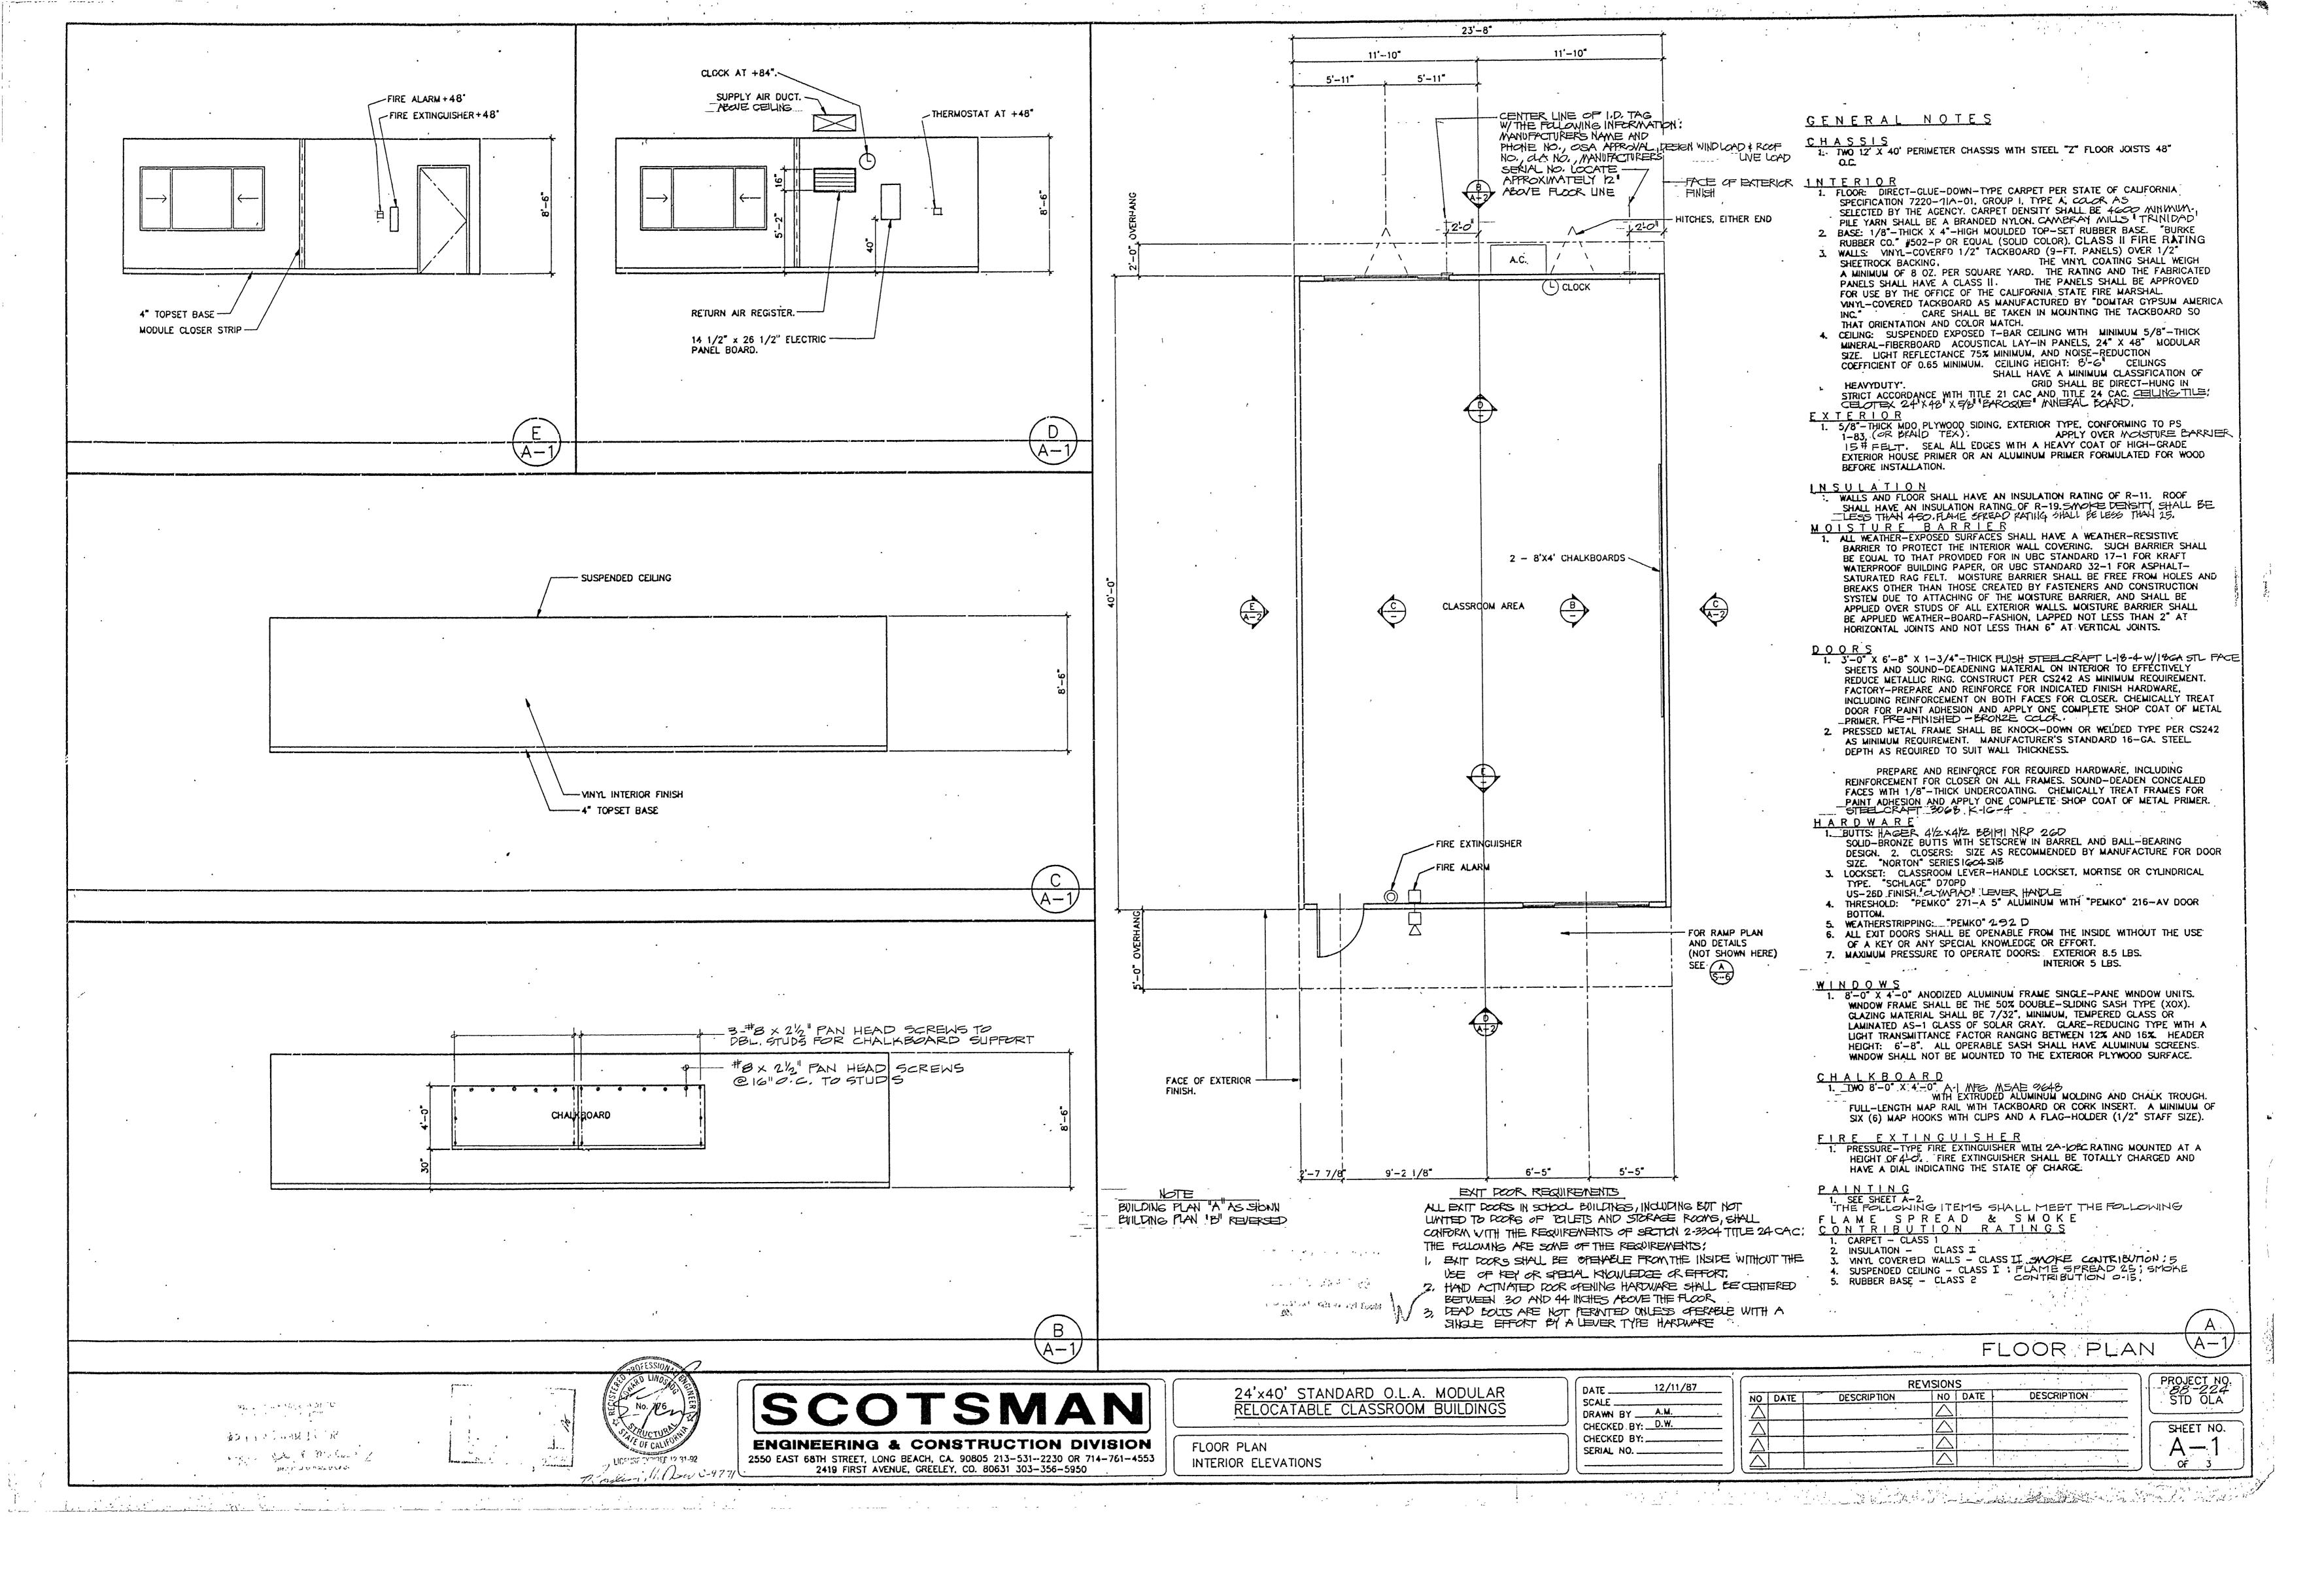


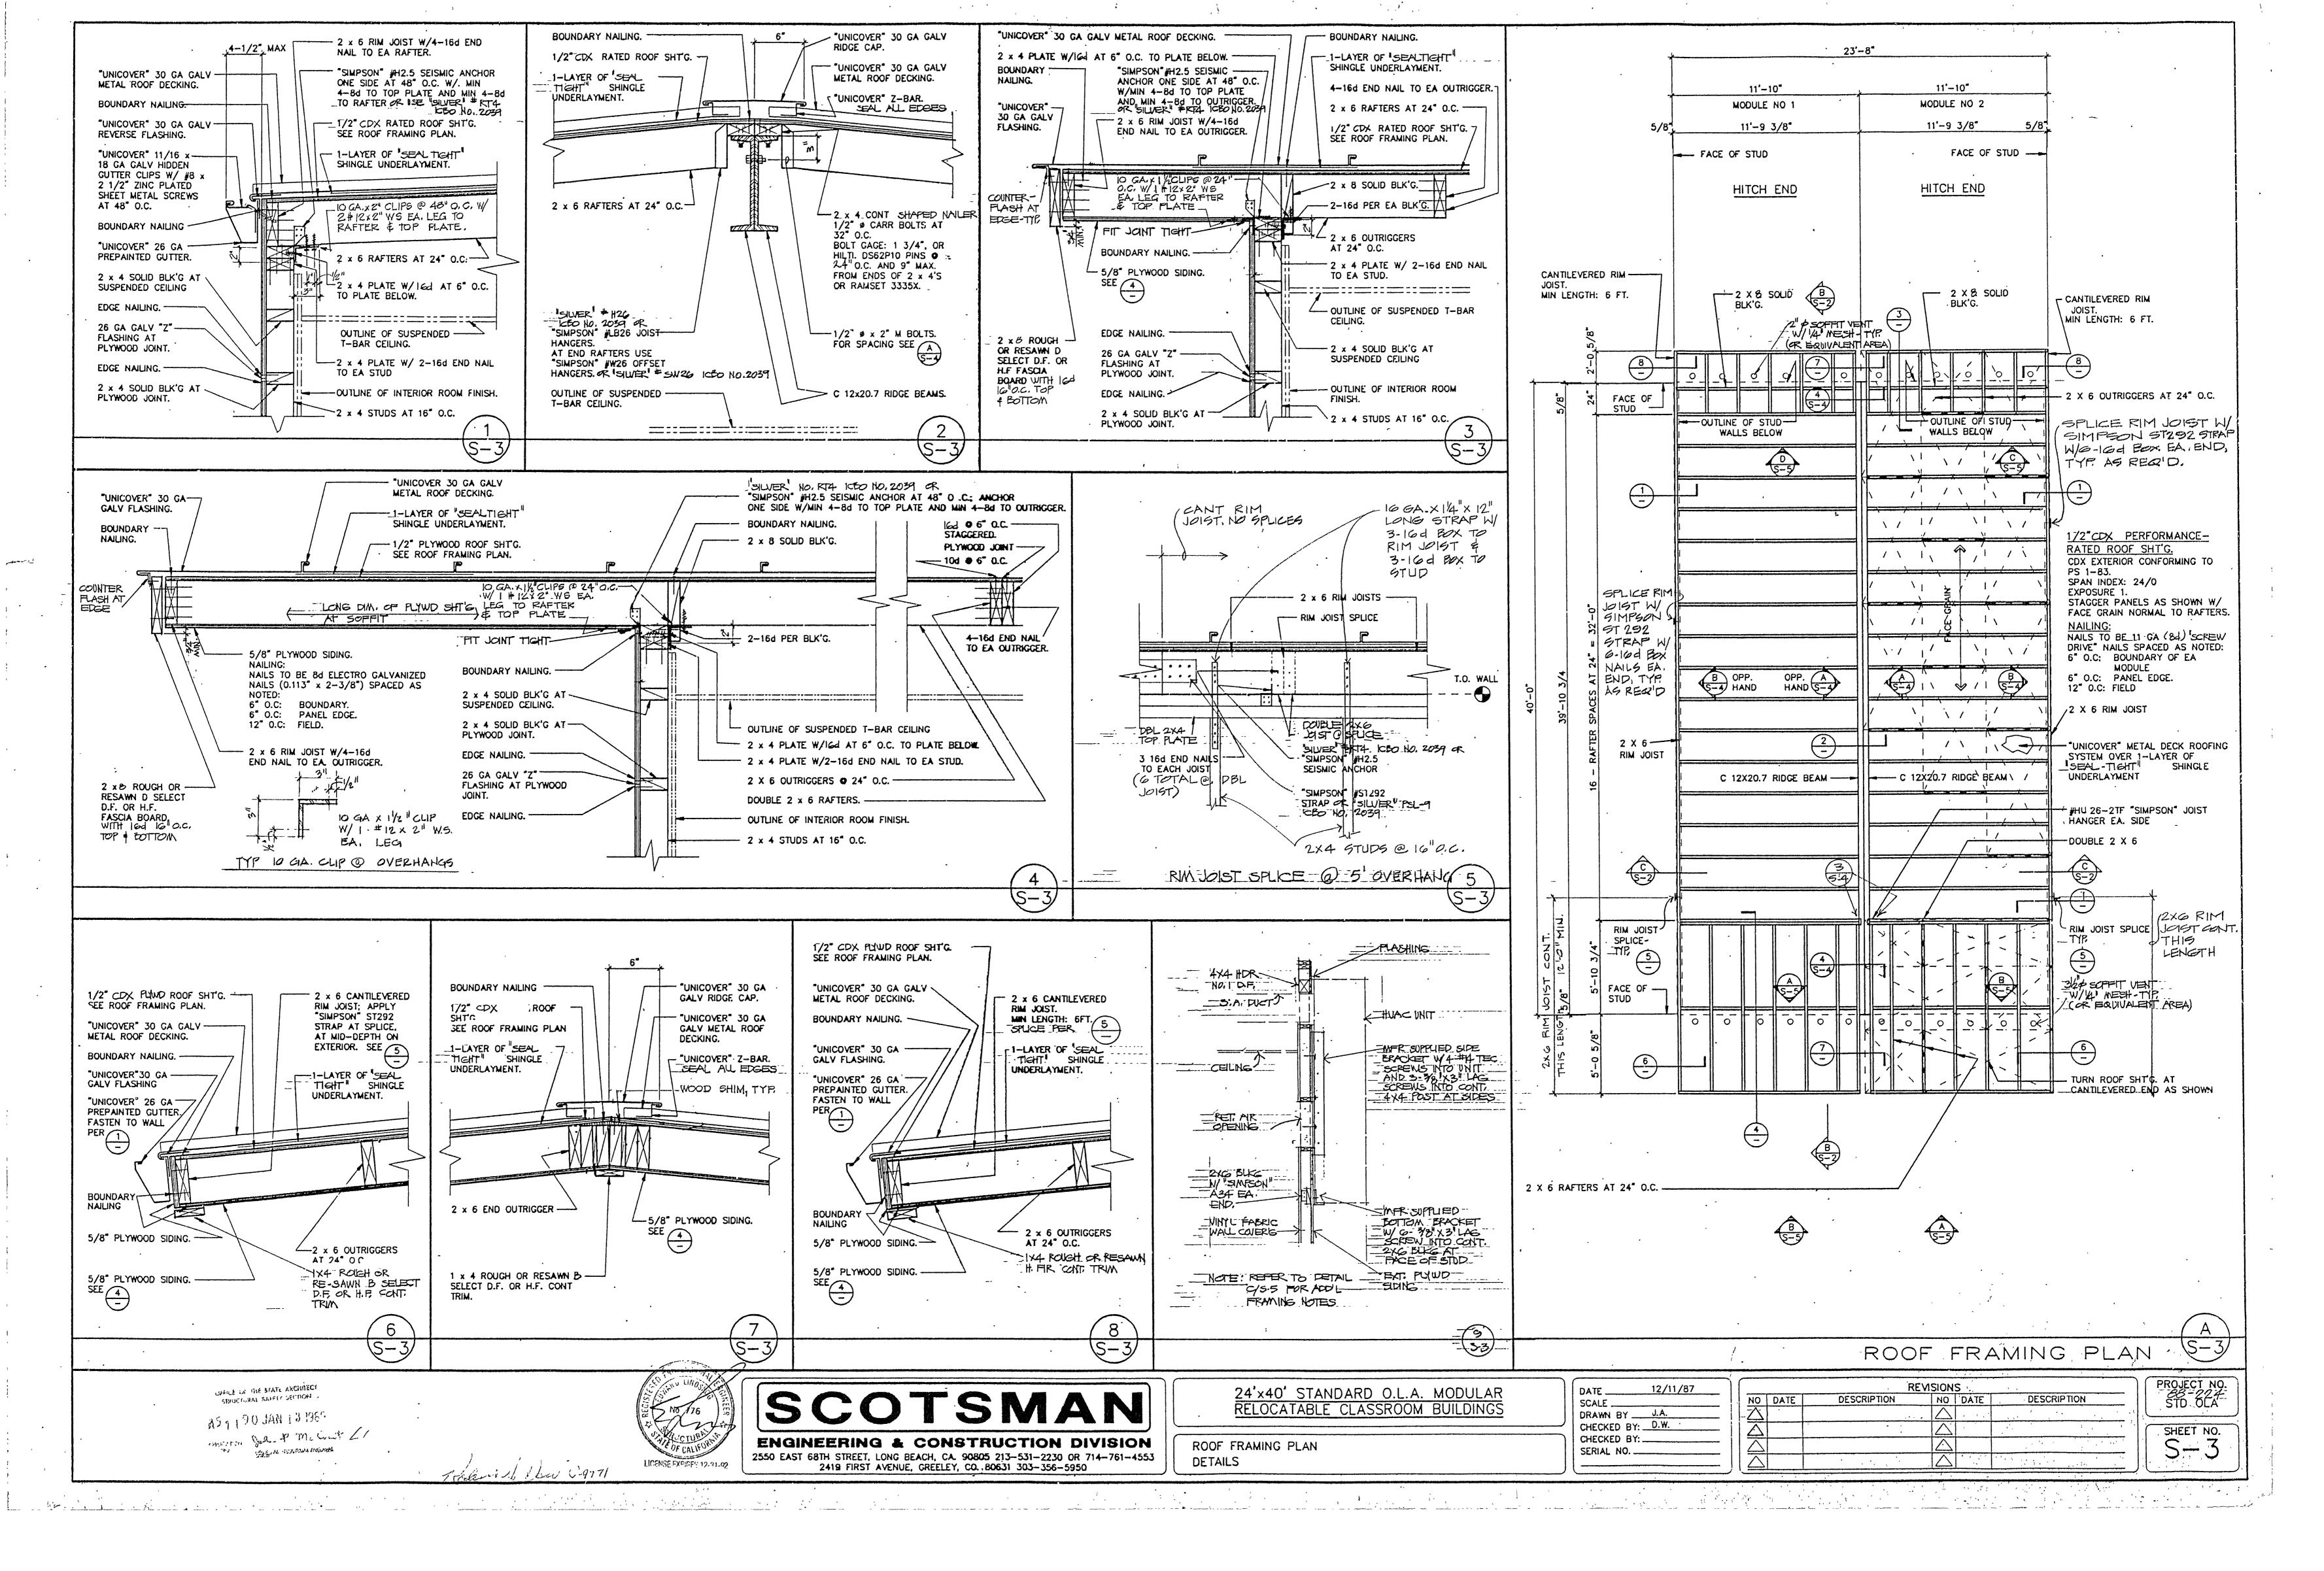

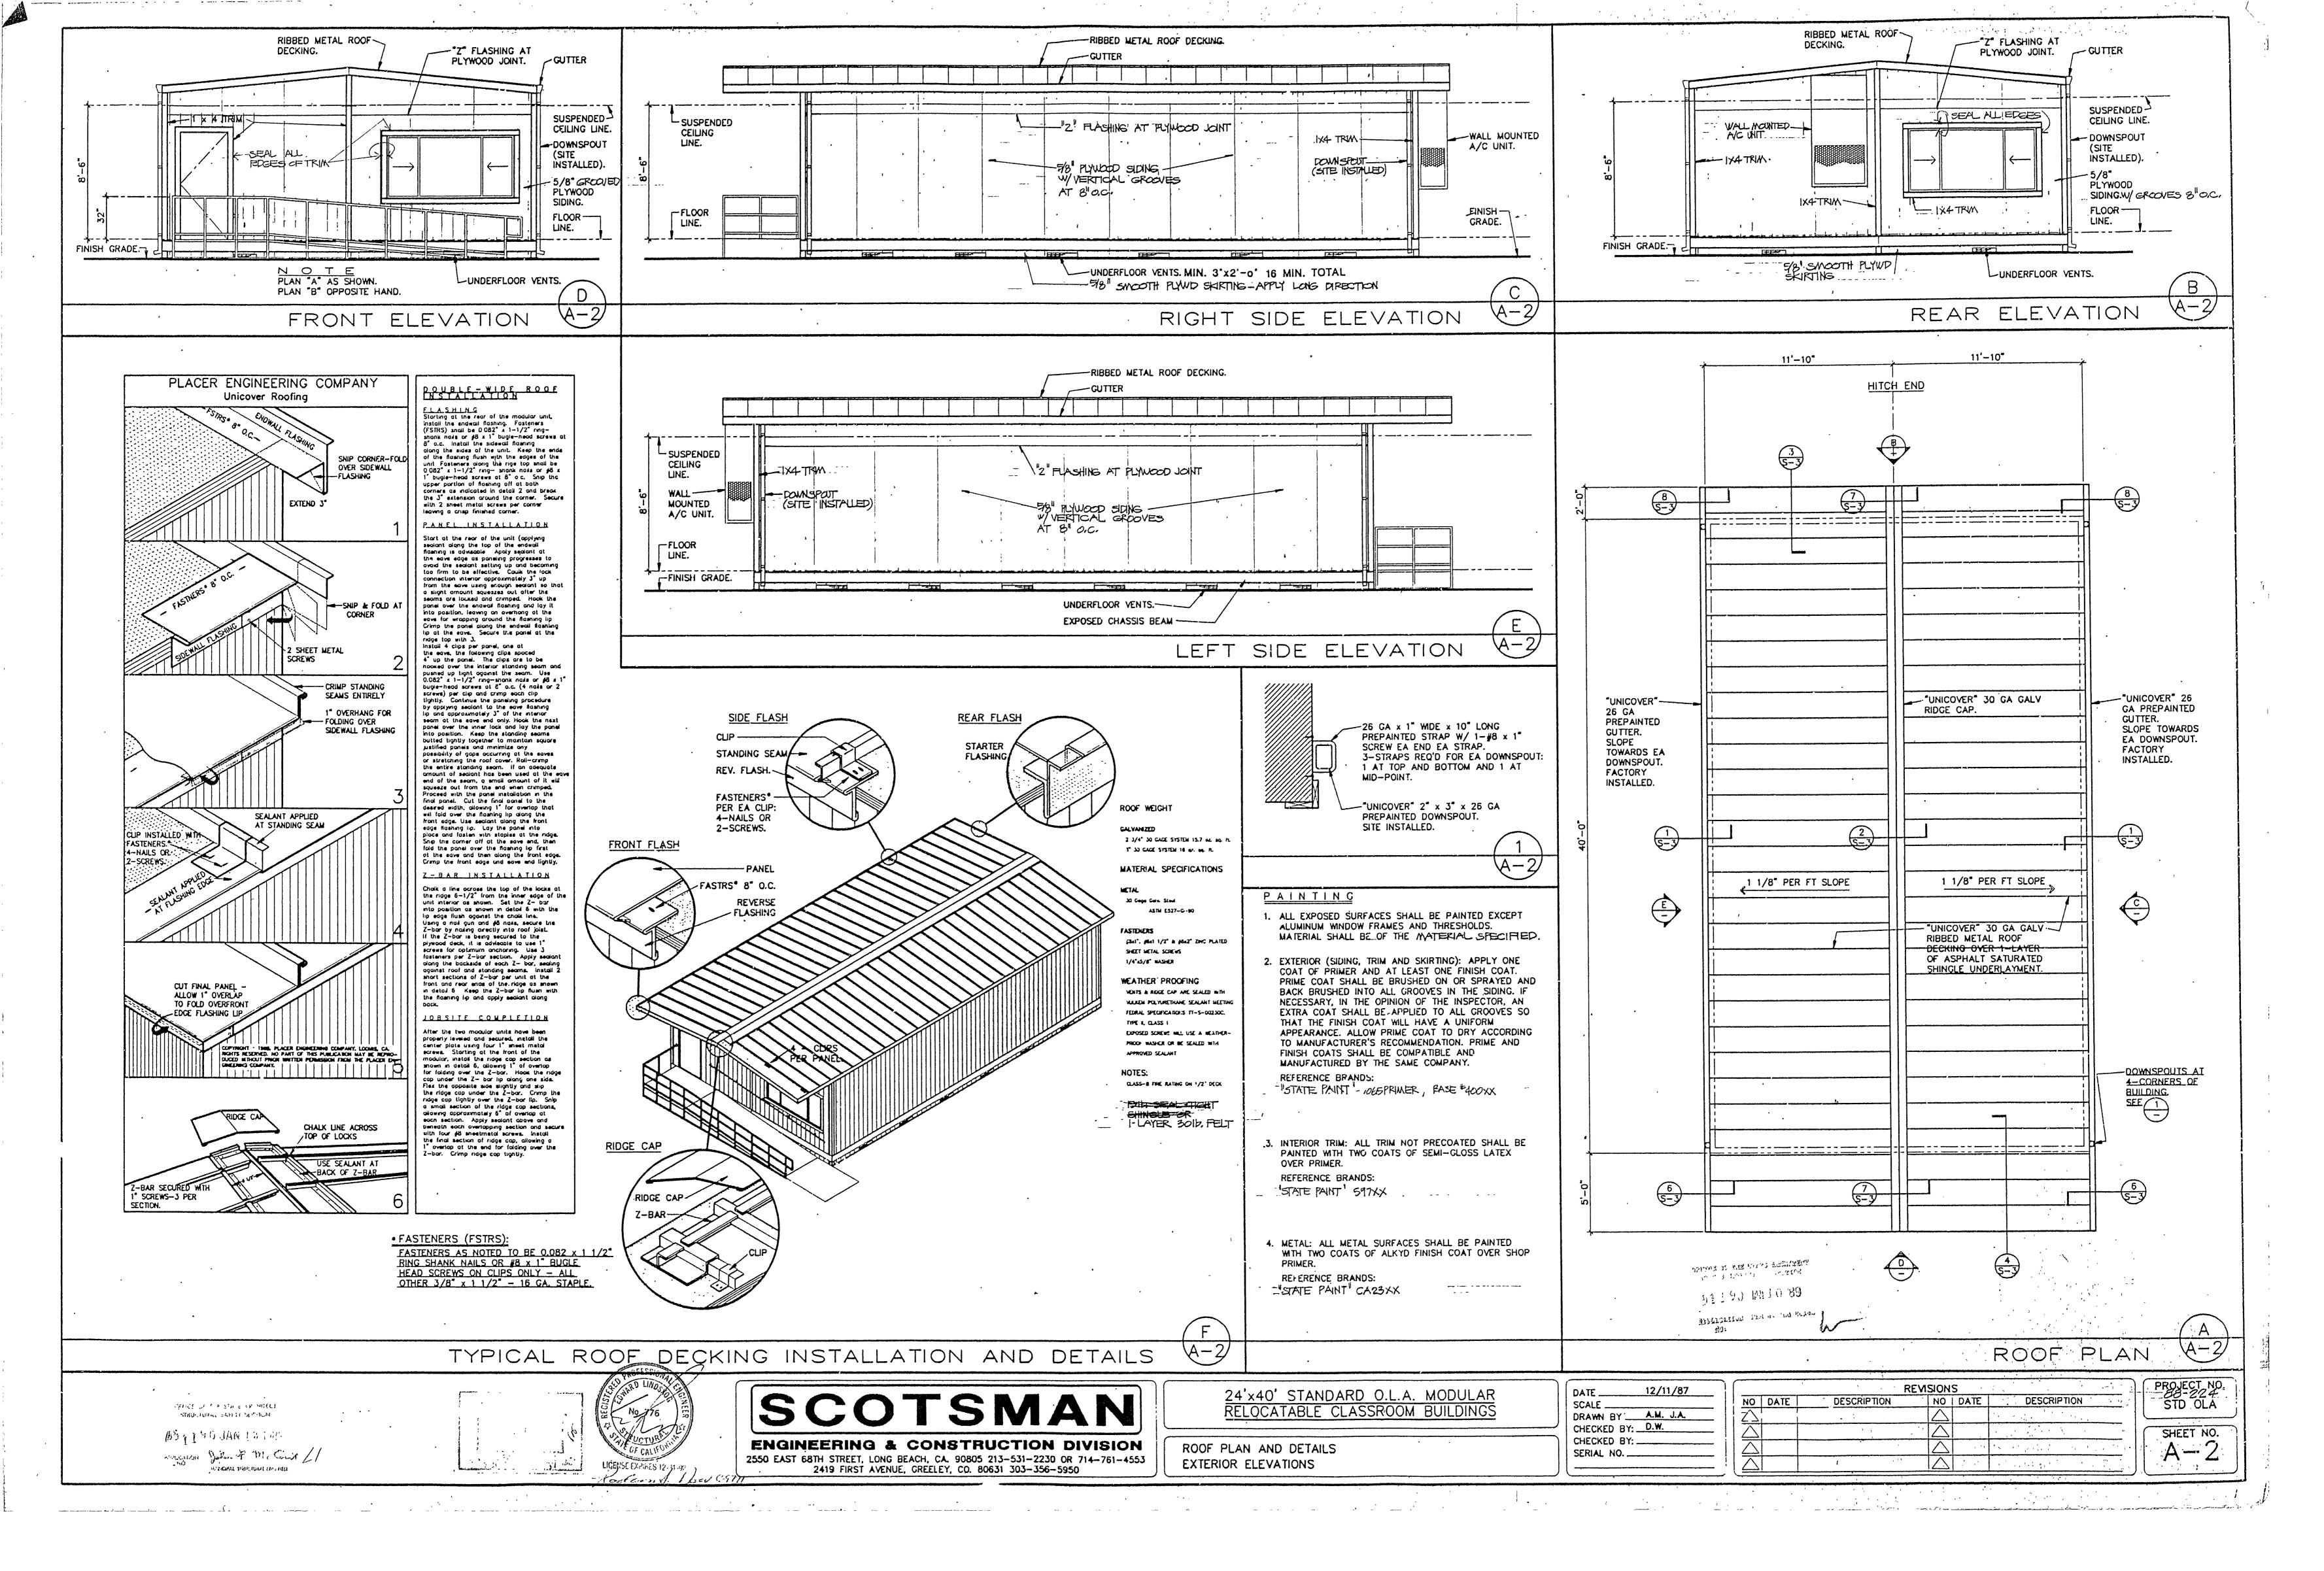

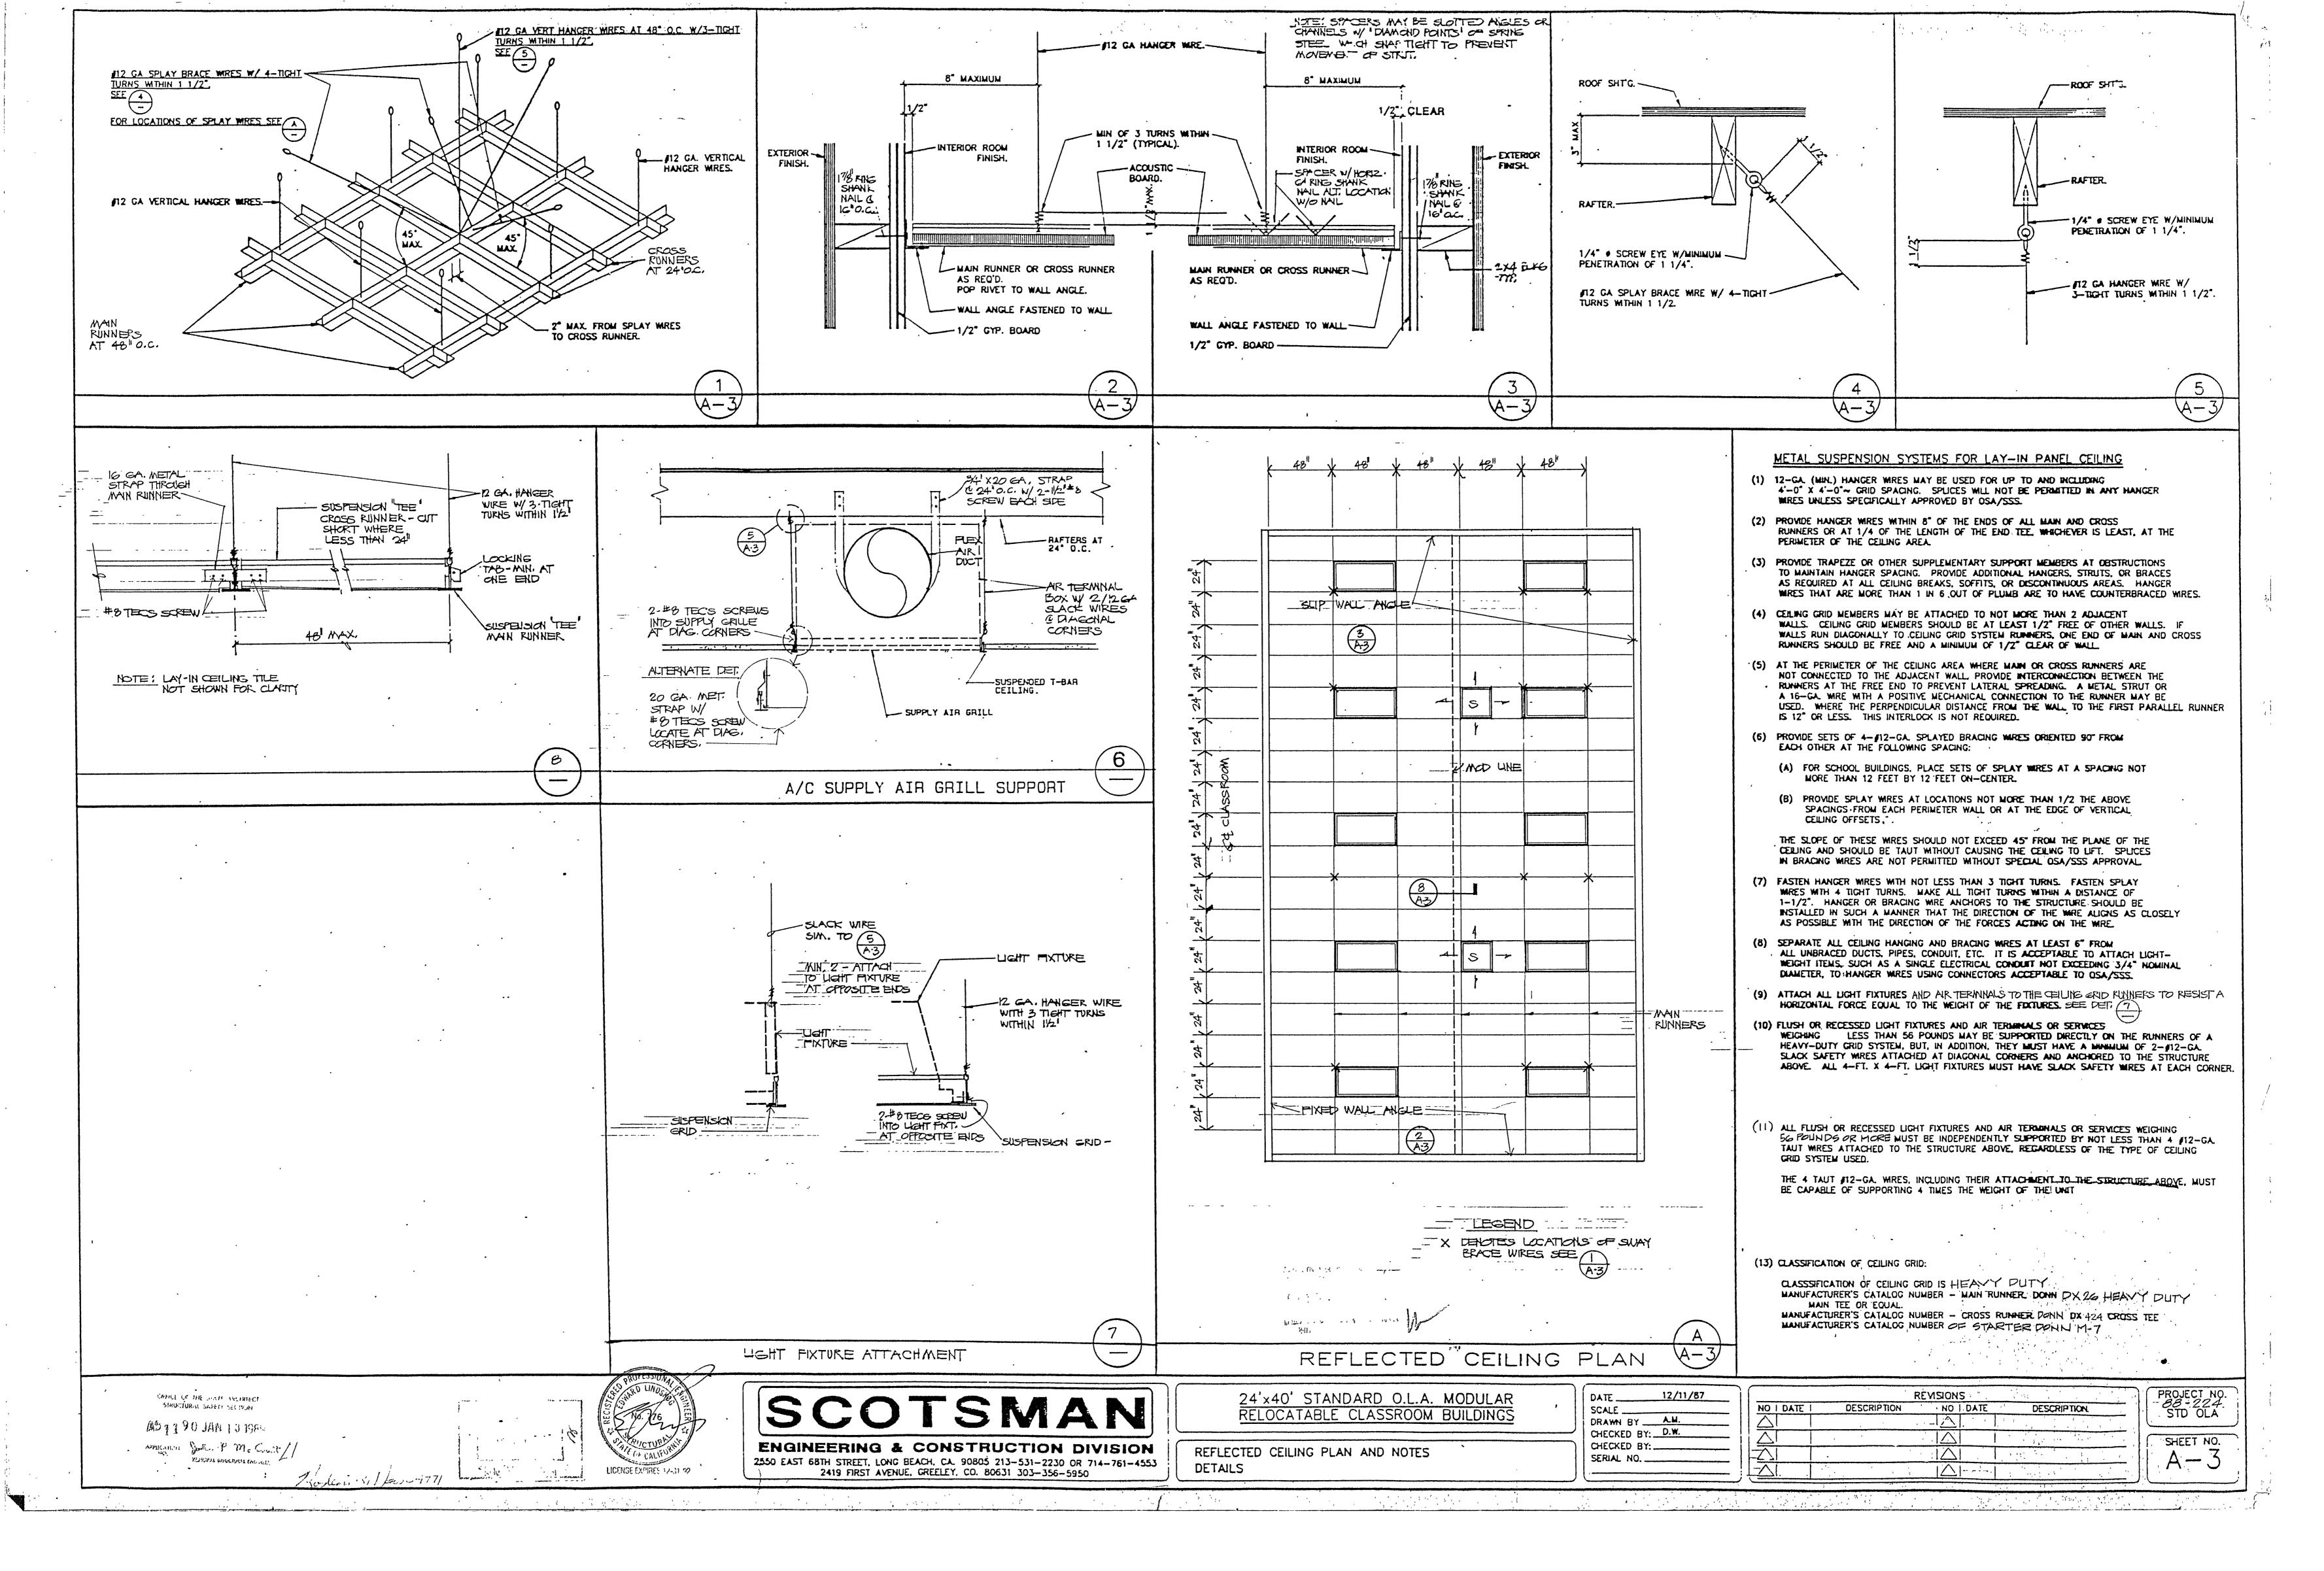

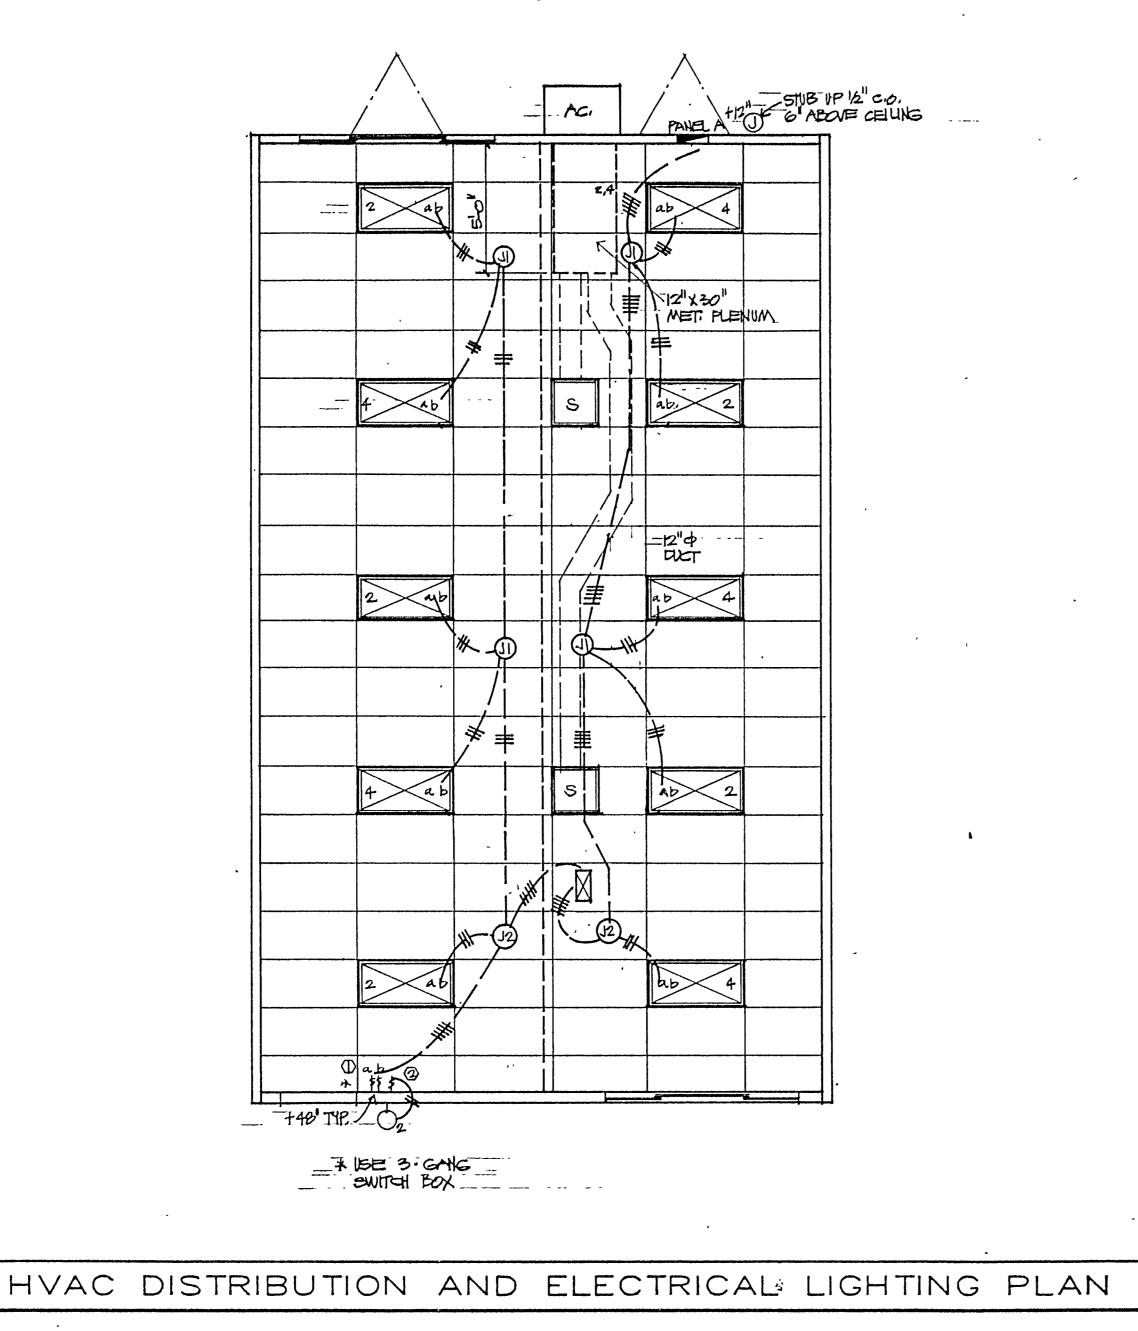

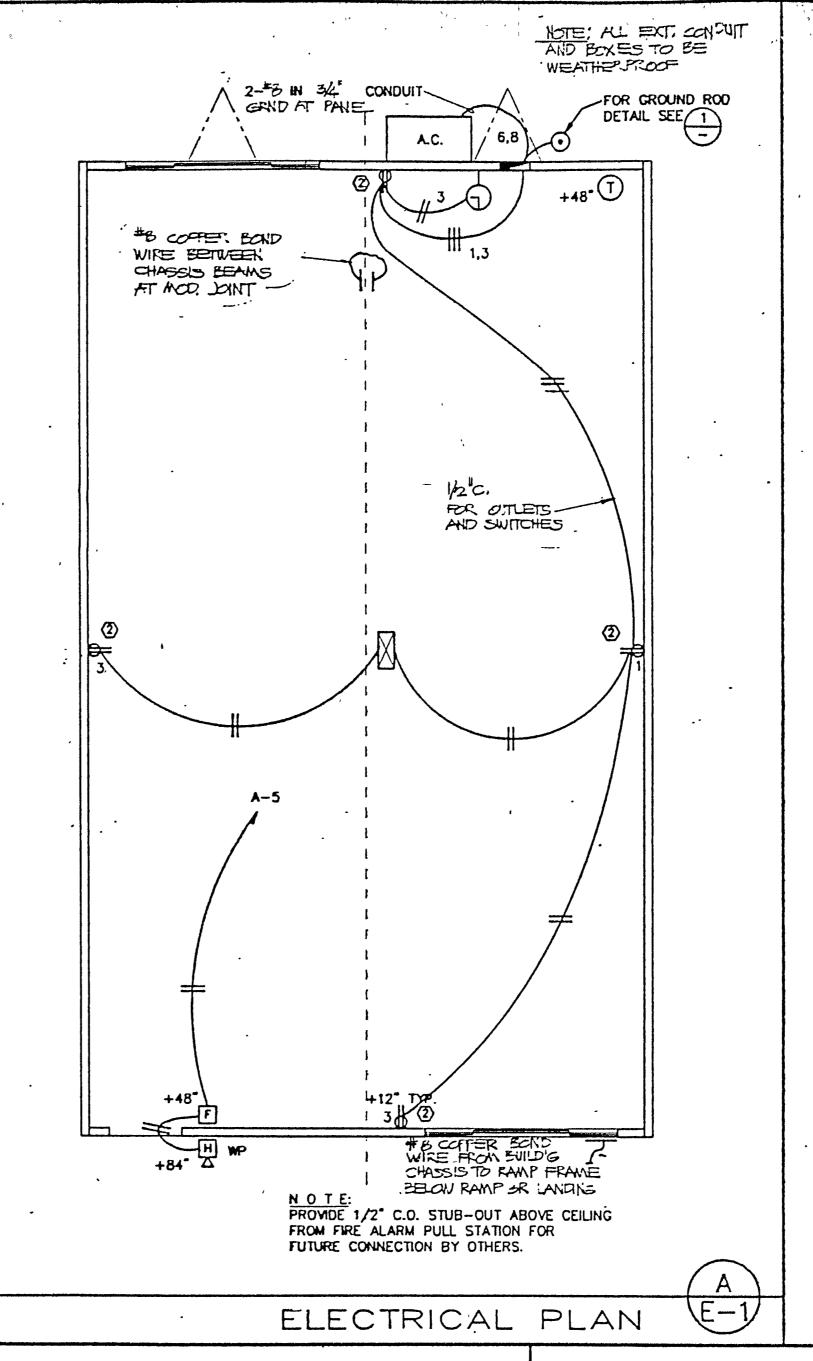

ELECTRICAL AND MENCHANICAL SYMBOLS DESCRIPTION LIGHTING AND POWER PANEL 120/240V 1PH 3W FLUSH MTD. NEMA 1-100A. MAIN. BRK. CROUSE-HINDS LCIOBMF BARD END MT. A/C W/HEAT PUMP. 45WH1-A0ECD004(8KW) 240V. 1 PHASE OR INTERTHERAL PUXOSIO FLOURESCENT LTG. FIXTURE - RECESSED 4 TUBE 2' x 4' - LITHONIA 2GT. W/ ENERGY SAVING LAMPS-35W, COOL WHITE PORCH LIGHT - 1 (100 W.) INCANDESCENT - FAIL SAFE 180 752 SINGLE POLE SWITCH - 120V 20A, +48" BRYANT 4801 I DUPLEX RECEPTACLE - 120V. 20A. HOSPITAL GRADE PASS & SEYMOR 9200 WHITE - RODGERS 1792. CLOCK OUTLET EAGLE 742BD AND EDWARDS CLOCK 1882A MANUAL FIRE ALARM PULL STATION. NOTIFIER BNG - ITS . CALIF. F.M. #7150-028:3+48 HORN - WHEELOCK TESTER CALIF. F.M. #7135-785-5 #7135-78517 LOUDNESS RATING: 90db AT 1 METER. GROUND ROD 1/2" COPPER CLAD STEEL B" LONG. CROSSOVER BOX $-4^{\circ} \times 11/2^{\circ}$ JUNCTION BOX 45WFB 1/2 JUNCTION BOX 550VFB /2 BOX - 45WFB RING - 4064 RING - 4054 CL'XCH' - KRUEGER #154 - 4 WAY THROW

THE TYPE OF FIRE ALARM SYSTEM AND/OR COMPONENTS MAY HAVE TO BE CHANGED DUE TO THE SITE. EXISTING SITUATIONS, OR INCOMPATIBLE COMPONENTS. APPROVAL OF THIS PLAN DOES NOT CONSTITUTE APPROVAL FOR THIS FIRE ALARM AT ALL STES.

VOLTS: 120/240 V PANEL: A FEED: BOTTOM MAIN: 100 A. I LOCATION: SEE PAN MOUNTING: FLUSH-NEMA WATTS BREAKER + A B + BREAKER WATTS LOAD LOAD O Amps PI AØ BØ AØ BØ Amps P O 20 1 1 RECEPTACLES 2 20 1 570 . LICHTING 4 20 1 770 LIGHTING RECEPTACLES 360 | 20 | 1 | 3 | 20 1 5 -6 50 2 4476 h A/C FIRE ALARM SPACE - 18 - 18 4476 A/C WATTS/PHASE A: 5746 WATTS/PHASE 400 | 360 53-16 5046 B= 5606 AMPS 120/240 VOLTS 1 Ø | 3 WIRE TOTAL 4000 WATTS | 58.3

MECHANICAL AND ELECTRICAL NOTES:

- MAIN SERVICE TO PANEL BY: OTHERS.
- 2. OVERCURRENT DEVICES SHALL HAVE ADEQUATE SHORT CIRCUIT INTERRUPTING CAPACITY. ALL CONDUCTORS SHALL BE COPPER WRING IN FLEX OR EMT. USE
- LIGHTING UNIFORMLY. STEEL BUILDING FRAME AND THE ELECTRICAL SYSTEM SHALL BE BONDED TO A COMMON GROUNDING LUG TO THE PANEL. GROUNDING ALL RACEWAY SYSTEMS, FIXTURES, OUTLETS, MOTORS.
- 5. EQUIPMENT ENCLOSURES AND METAL BUIDLING MUST BE PERMANENTLY AND EFFECTIVELY GROUNDED IN ACCORDANCE WITH THE 1984 NEC. CAC. TITLE 8,19, AND LOCAL CODES.
- IN ACCESSIBLE CONCEALED PORTIONS OF DUCT SYSTEM RIGO 1° FIBERGLASS OR INSULATED "FLEXDUCT" WITH VAPOR BARRIER MAY BE SUBSTITUTED FOR SHEET METAL DUCTWORK. ALL DUCTWORK WITHIN 5' OF THE HVAC UNIT AND ALL INTERFACE CONNECTIONS SHALL BE METAL DUCTWORK AND 1/2" 112 WRE U.O.N. OUTLETS & SWITCHES TO BE 12/2 ROMEX W/GROUND, REINFORCEMENT SHALL BE DESIGNED FOR 2" STATIC PRESSURE. REFERENCE SWITCH TWO TUBES EACH OF FOUR TUBE LIGHTING FIXTURE TO REDUCE BRANDS: "OWENS-CORNING FIBERGLASS" DUCT BOARD, 1" THICK, AND "MANVILLE" MICRO-AIRE, TYPE 475. NON-METALLIC DUCTWORK SHALL

NCL:760 LCL: 10592 X1.25 = 13240 + 760 = 14000

7. THERMOSTAT: ELECTRONIC PROGRAMMABLE PROMDE WHITE-RODGERS 1F92 THERMOSTAT. PROVIDE LOCKING, CLEAR THERMOSTAT COVER WITH ACCESS HOLE FOR TEMPERATURE UP AND DOWN BUTTONS. THERMOSTAT SHALL HAVE THE FOLLOWING FUNCTIONS:

CONFORM TO NFPA 90-A AND 90-B AND SMACNA CLASS I RATING.

- A. 5 AND 2 WEEKDAY/WEEKEND PROGRAMMING WITH 4 SEPARATE TIME\TEMPERATURE SETTINGS PER 24-HOUR PERIOD.
- B. KEY BOARD LOCKOUT SWITCH. C. PROGRAMMABLE DISPLAY.

FEEDER 3-#2 AND 1-16 GROUND

- D. 3-HOUR OVERRIDE. E. STATUS INDICATED LEDS.
- F. BATTERY BACK-UP.
- 8. DUCTWORK SUSPENSION AND SEISMIC BRAACING SHALL BE IN ACCORDANCE WITH SMACNA STANDARDS.
- 9. ALL MECHANICAL AND ELECTRICAL EQUIPMENT SHALL BE BRACED OR ANCHORED TO RESIST A HORIZONTAL FORCE ACTING IN ANY DIRECTION USING THE FOLLOWING CRITERIA:

E-1

FRED EQUIPMENT AN GRADE! 229. OF OFFICIAL VEIGHT THYED EQUIPMENT AL STRUCTURE, 45% OF GERATING WEIGHT


to the second

ENERGENCY POVER EQUIPMENT CN GRAPE 35% OF OFFRATING WEIGHT EMERGENCY POWER EQUIPMENT ON

STRUCTURE 50% OF OPERATING, WEIGHT

FOR FLEXIBLY MOUNTED EQUIPMENT USE 2 * THE ABOVE VALUES. SIMULTANEOUS VERTICAL FORCE - USE 1/3 x HORIZONTAL FORCE.

WHERE ANCHORAGE DETAILS ARE NOT SHOWN ON THE DRAWINGS THE FIELD INSTALLATION SHALL BE SUBJECT TO THE APPROVAL OF THE ARCHITECT AND THE FIELD REPRESENTATIVE OF THE OPFICE OF THE STATE ARCHITECT.

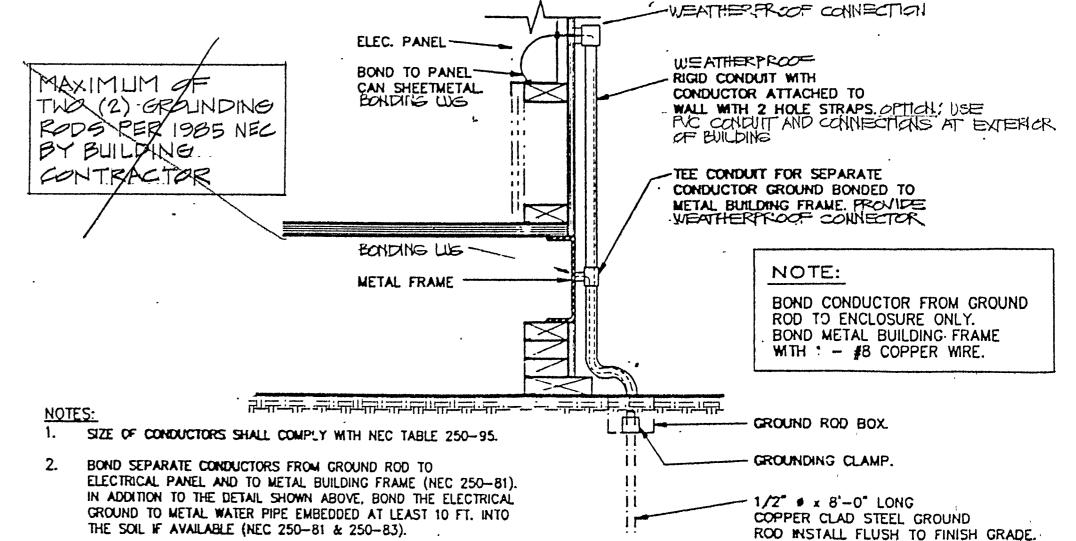


ALL MODULES OF METAL FRAME BUILDINGS AND RAMP TO BE ELECTRICALLY BONDED TOGETHER (BOLTING ONLY IS NOT ACCEPTABLE BONDING.)

CHECK RSISTANCE TO GROUND. IF RESISTANCE EXCEEDS 25 OHMS IN STATI '1 ADDITIONAL GROUND ROOS WITH CONDUCTORS AS SHOWN, SEPARATED AT LEAST 6'-0" UNTIL RESISTANCE IS REDUCED TO 25 OHMS OR LESS. (NEC 250-84).

LOCATED UNDER BUILDING -GROUND ROD BOX MAY BE OMITTED, MFGR WILL PROVIDE A MAXIMUM OF 2 GROUND ROPS PER BUILDING.

NOTE: WHEN FOUND POD IS

GROUDNING DETAIL

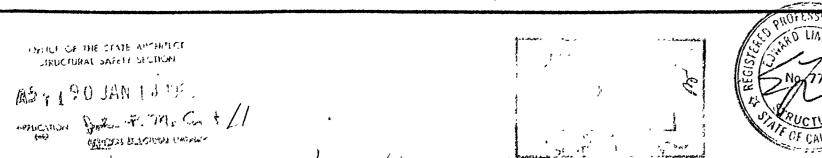

"Coolering ion. Co-9711


SCOTSMAN

ENGINEERING & CONSTRUCTION DIVISION 2550 EAST 68TH STREET, LONG BEACH, CA. 90805, 213-531-2230 OR 714-761-4553 2419 FIRST AVENUE, GREELEY, CO. 80631 303-356-5950

24'x40' STANDARD O.L.A. MODULAR RELOCATABLE CLASSROOM BUILDINGS


CEILING, LIGHTING, HVAC. & POWER PLAN

ATE	12/11/87	
CALE		NO
RAWN BY	A.W.	$\prod \bigwedge$
HECKED BY:	D.W.	🗮
HECKED BY:		
CDIAL NO		1 - / \

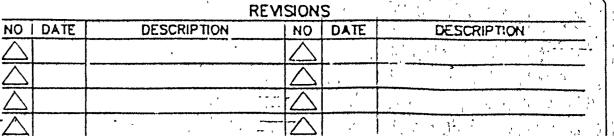

PROJECT NO. 88-224 STD OLA SHEET NO. --

E-1

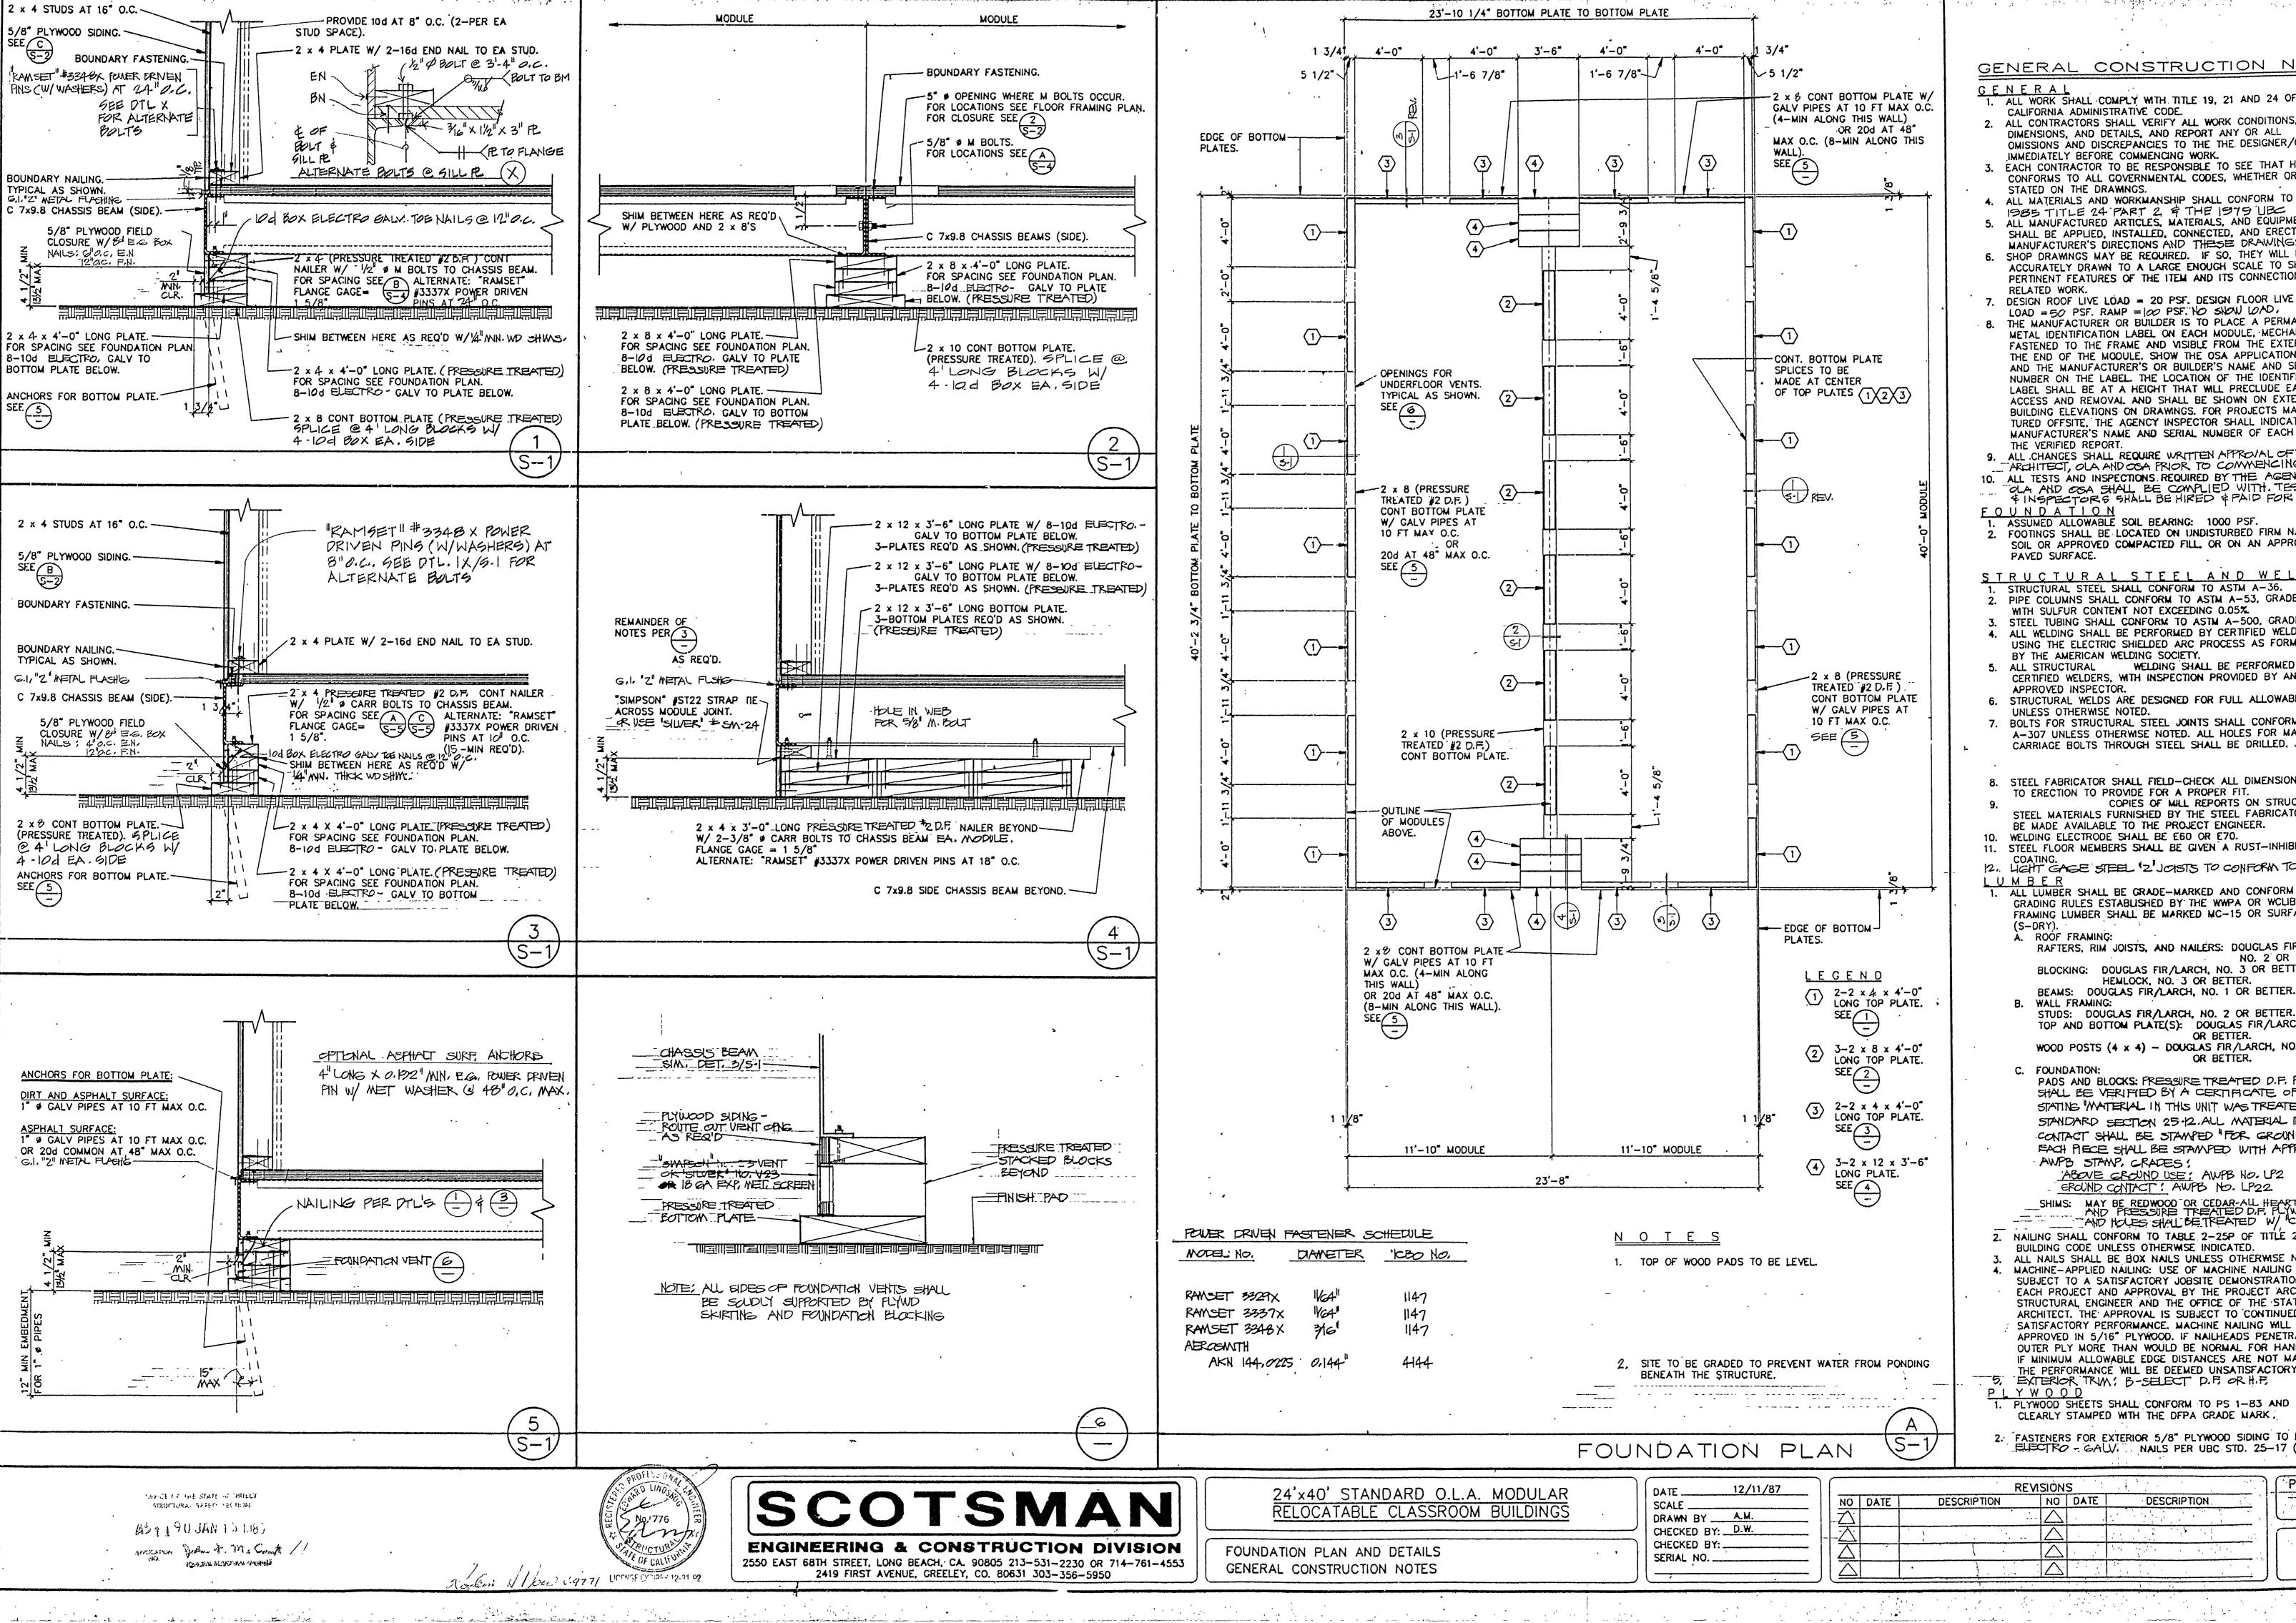

GENERAL CONSTRUCTION NOTES

1. ALL WORK SHALL COMPLY WITH TITLE 19, 21 AND 24 OF THE CALIFORNIA ADMINISTRATIVE CODE.

2. ALL CONTRACTORS SHALL VERIFY ALL WORK CONDITIONS, DIMENSIONS, AND DETAILS, AND REPORT ANY OR ALL OMISSIONS AND DISCREPANCIES TO THE THE DESIGNER/OWNER

MMEDIATELY BEFORE COMMENCING WORK. 3. EACH CONTRACTOR TO BE RESPONSIBLE TO SEE THAT HIS WORK CONFORMS TO ALL GOVERNMENTAL CODES, WHETHER OR NOT SO

4. ALL MATERIALS AND WORKMANSHIP SHALL CONFORM TO THE

1985 TITLE 24 PART 2 & THE 1979 UBC 5. ALL MANUFACTURED ARTICLES, MATERIALS, AND EQUIPMENT SHALL BE APPLIED, INSTALLED, CONNECTED, AND ERECTED PER

MANUFACTURER'S DIRECTIONS AND THESE DRAWINGS. SHOP DRAWNGS MAY BE REQUIRED. IF SO, THEY WILL BE ACCURATELY DRAWN TO A LARGE ENOUGH SCALE TO SHOW ALL PERTINENT FEATURES OF THE ITEM AND ITS CONNECTION TO

DESIGN ROOF LIVE LOAD = 20 PSF. DESIGN FLOOR LIVE LOAD = 50 PSF. RAMP = 100 PSF. NO SHOW LOAD.

THE MANUFACTURER OR BUILDER IS TO PLACE A PERMANENT METAL IDENTIFICATION LABEL ON EACH MODULE, MECHANICALLY FASTENED TO THE FRAME AND VISIBLE FROM THE EXTERIOR OF THE END OF THE MODULE. SHOW THE OSA APPLICATION NUMBER AND THE MANUFACTURER'S OR BUILDER'S NAME AND SERIAL NUMBER ON THE LABEL THE LOCATION OF THE IDENTIFICATION LABEL SHALL BE AT A HEIGHT THAT WILL PRECLUDE EASY ACCESS AND REMOVAL AND SHALL BE SHOWN ON EXTERIOR BUILDING ELEVATIONS ON DRAWINGS. FOR PROJECTS MANUFAC-TURED OFFSITE, THE AGENCY INSPECTOR SHALL INDICATE THE MANUFACTURER'S NAME AND SERIAL NUMBER OF EACH MODULE ON

ALL CHANGES SHALL REQUIRE WRITTEN APPROVAL OF THE AGENCY ARCHITECT, OLA AND OSA PRIOR TO COMMENCING WORK. ALL TESTS AND INSPECTIONS REQUIRED BY THE AGENCY ARCHITEC OLA AND OSA SHALL BE COMPLIED WITH. TESTING AGENCY & INSPECTORS SHALL BE HIRED & PAID FOR BY OWNER.

1. ASSUMED ALLOWABLE SOIL BEARING: 1000 PSF. FOOTINGS SHALL BE LOCATED ON UNDISTURBED FIRM NATURAL SOIL OR APPROVED COMPACTED FILL, OR ON AN APPROVED

STRUCTURAL STEEL AND WELDING STRUCTURAL STEEL SHALL CONFORM TO ASTM A-36.

PIPE COLUMNS SHALL CONFORM TO ASTM A-53, GRADE "B. WITH SULFUR CONTENT NOT EXCEEDING 0.05% STEEL TUBING SHALL CONFORM TO ASTM A-500, GRADE "B."

4. ALL WELDING SHALL BE PERFORMED BY CERTIFIED WELDERS USING THE ELECTRIC SHIELDED ARC PROCESS AS FORMULATED BY THE AMERICAN WELDING SOCIETY.

WELDING SHALL BE PERFORMED BY CERTIFIED WELDERS, WITH INSPECTION PROVIDED BY AN OSA-

6. STRUCTURAL WELDS ARE DESIGNED FOR FULL ALLOWABLE STRESS UNLESS OTHERWISE NOTED.

BOLTS FOR STRUCTURAL STEEL JOINTS SHALL CONFORM TO ASTM A-307 UNLESS OTHERWISE NOTED. ALL HOLES FOR MACHINE AND CARRIAGE BOLTS THROUGH STEEL SHALL BE DRILLED. .

STEEL FABRICATOR SHALL FIELD-CHECK ALL DIMENSIONS PRIOR

TO ERECTION TO PROVIDE FOR A PROPER FIT. COPIES OF MILL REPORTS ON STRUCTURAL STEEL MATERIALS FURNISHED BY THE STEEL FABRICATOR SHALL BE MADE AVAILABLE TO THE PROJECT ENGINEER.

STEEL FLOOR MEMBERS SHALL BE GIVEN A RUST-INHIBITIVE

COATING.
12. LIGHT GAGE STEEL 12 JOISTS TO CONFORM TO ASTM-570

1. ALL LUMBER SHALL BE CRADE-MARKED AND CONFORM TO THE GRADING RULES ESTABLISHED BY THE WWPA OR WCLIB. ALL FRAMING LUMBER SHALL BE MARKED MC-15 OR SURFACED DRY

A. ROOF FRAMING: RAFTERS, RIM JOISTS, AND NAILERS: DOUGLAS FIR/LARCH, NO. 2 OR BETTER. BLOCKING: DOUGLAS FIR/LARCH, NO. 3 OR BETTER, OR

HEMLOCK, NO. 3 OR BETTER. BEAMS: DOUGLAS FIR/LARCH, NO. 1 OR BETTER.

TOP AND BOTTOM PLATE(S): DOUGLAS FIR/LARCH, NO. 2 OR BETTER. WOOD POSTS (4 x 4) - DOUGLAS FIR/LARCH, NO. 1 OR BETTER.

PADS AND BLOCKS: PRESSURE TREATED D.F. PADS AND PLOCKS SHALL BE VERIFIED BY A CERTIFICATE OF TREATMENT STATING WATERIAL IN THIS UNIT WAS TREATED PER IBC STANDARD SECTION 25-12. ALL MATERIAL IN GROUND CONTACT SHALL BE STAMPED "FOR GROUND CONTACT" FACH PIECE SHALL BE STAMPED WITH APPROPRIATE AWPB STAMP, GRADES!

'ABOVE GROUND USE: AWPB NO. LP2 EROUND CONTACT : AWPB No. LP22

SHIMS: MAY BE REDWOOD OR CEDAR-ALL HEART OF FIX GRADE AND PRESSURE TREATED D.F. PLYWD, ALL CUT ENDE

2. NAILING SHALL CONFORM TO TABLE 2-25P OF TITLE 24 OF BUILDING CODE UNLESS OTHERWISE INDICATED.

3. ALL NAILS SHALL BE BOX NAILS UNLESS OTHERWISE NOTED. 4. MACHINE-APPLIED NAILING: USE OF MACHINE NAILING IS SUBJECT TO A SATISFACTORY JOBSITE DEMONSTRATION FOR EACH PROJECT AND APPROVAL BY THE PROJECT ARCHITECT OR


STRUCTURAL ENGINEER AND THE OFFICE OF THE STATE ARCHITECT, THE APPROVAL IS SUBJECT TO CONTINUED SATISFACTORY PERFORMANCE, MACHINE NAILING WILL NOT BE APPROVED IN 5/16" PLYWOOD. IF NAILHEADS PENETRATE THE OUTER PLY MORE THAN WOULD BE NORMAL FOR HAND HAMMER, OR IF MINIMUM ALLOWABLE EDGE DISTANCES ARE NOT MAINTAINED, THE PERFORMANCE WILL BE DEEMED UNSATISFACTORY.


1. PLYWOOD SHEETS SHALL CONFORM TO PS 1-83 AND SHALL BE CLEARLY STAMPED WITH THE DFPA GRADE MARK!


2. FASTENERS FOR EXTERIOR 5/8" PLYWOOD SIDING TO BE ELECTRO - GALVI NAILS PER UBC STD. 25-17 (1985).


NO DATE DESCRIPTION


PROJECT NO. STD OLA SHEET NO. S-OF 6

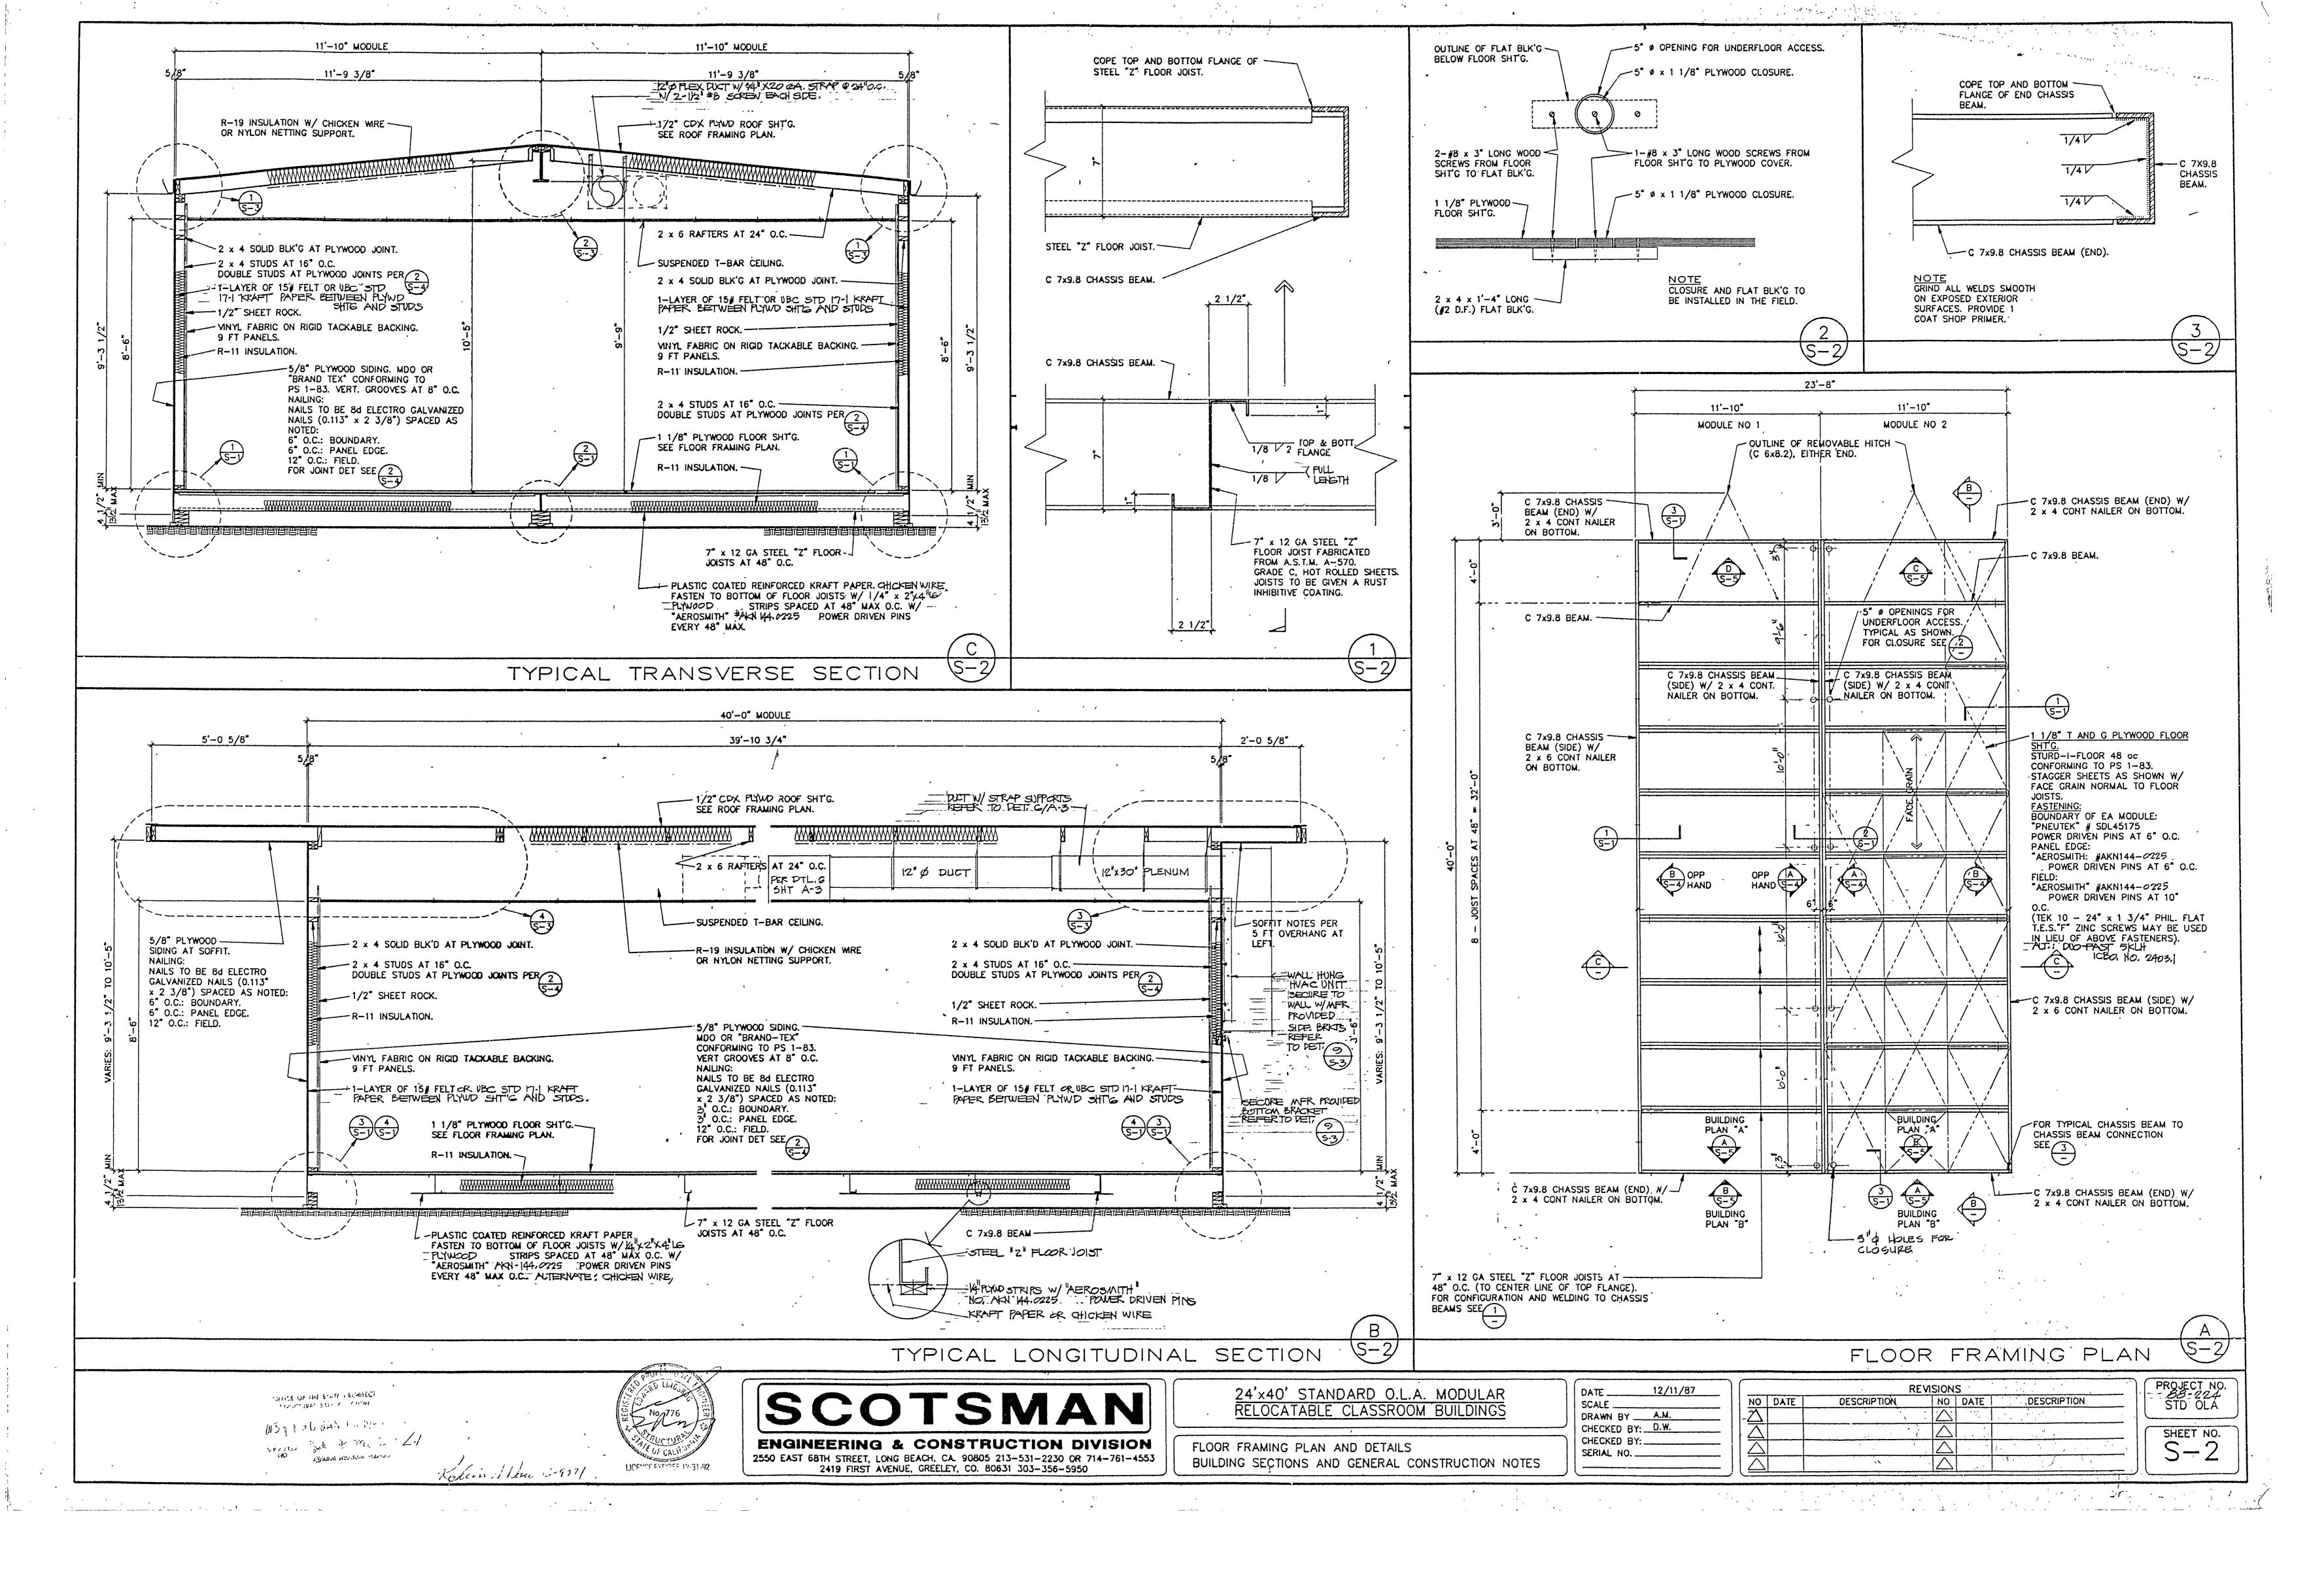

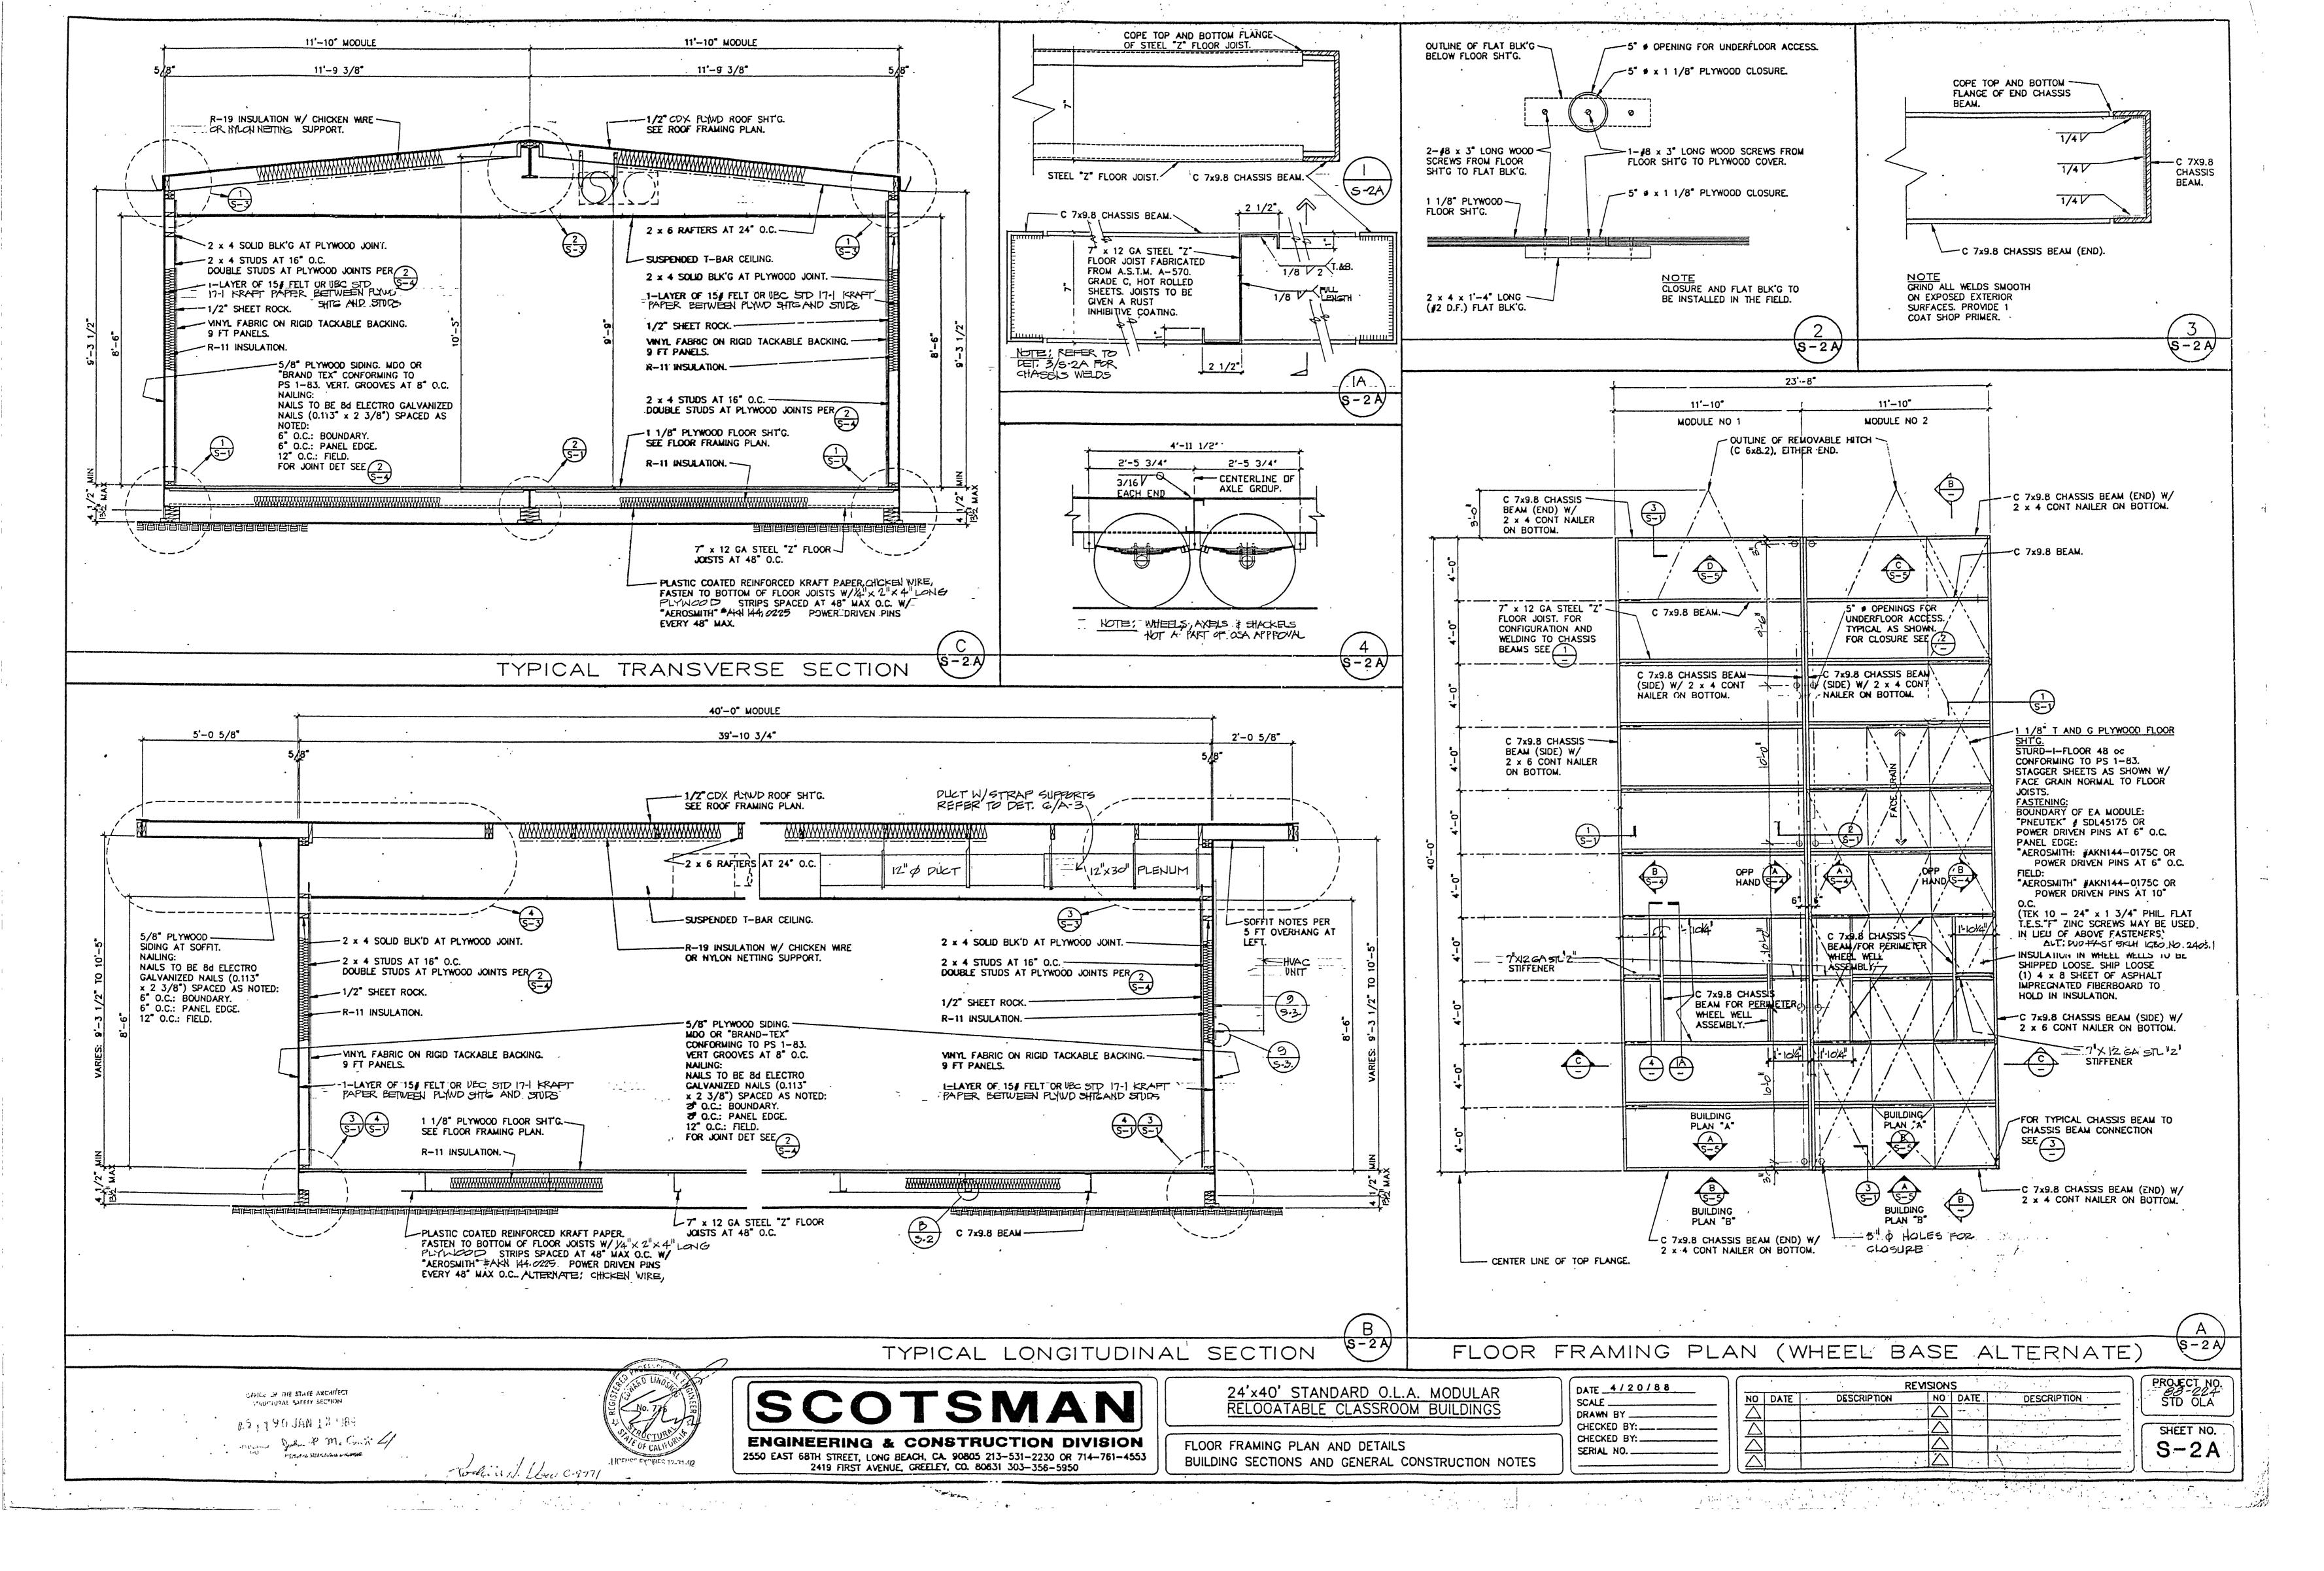

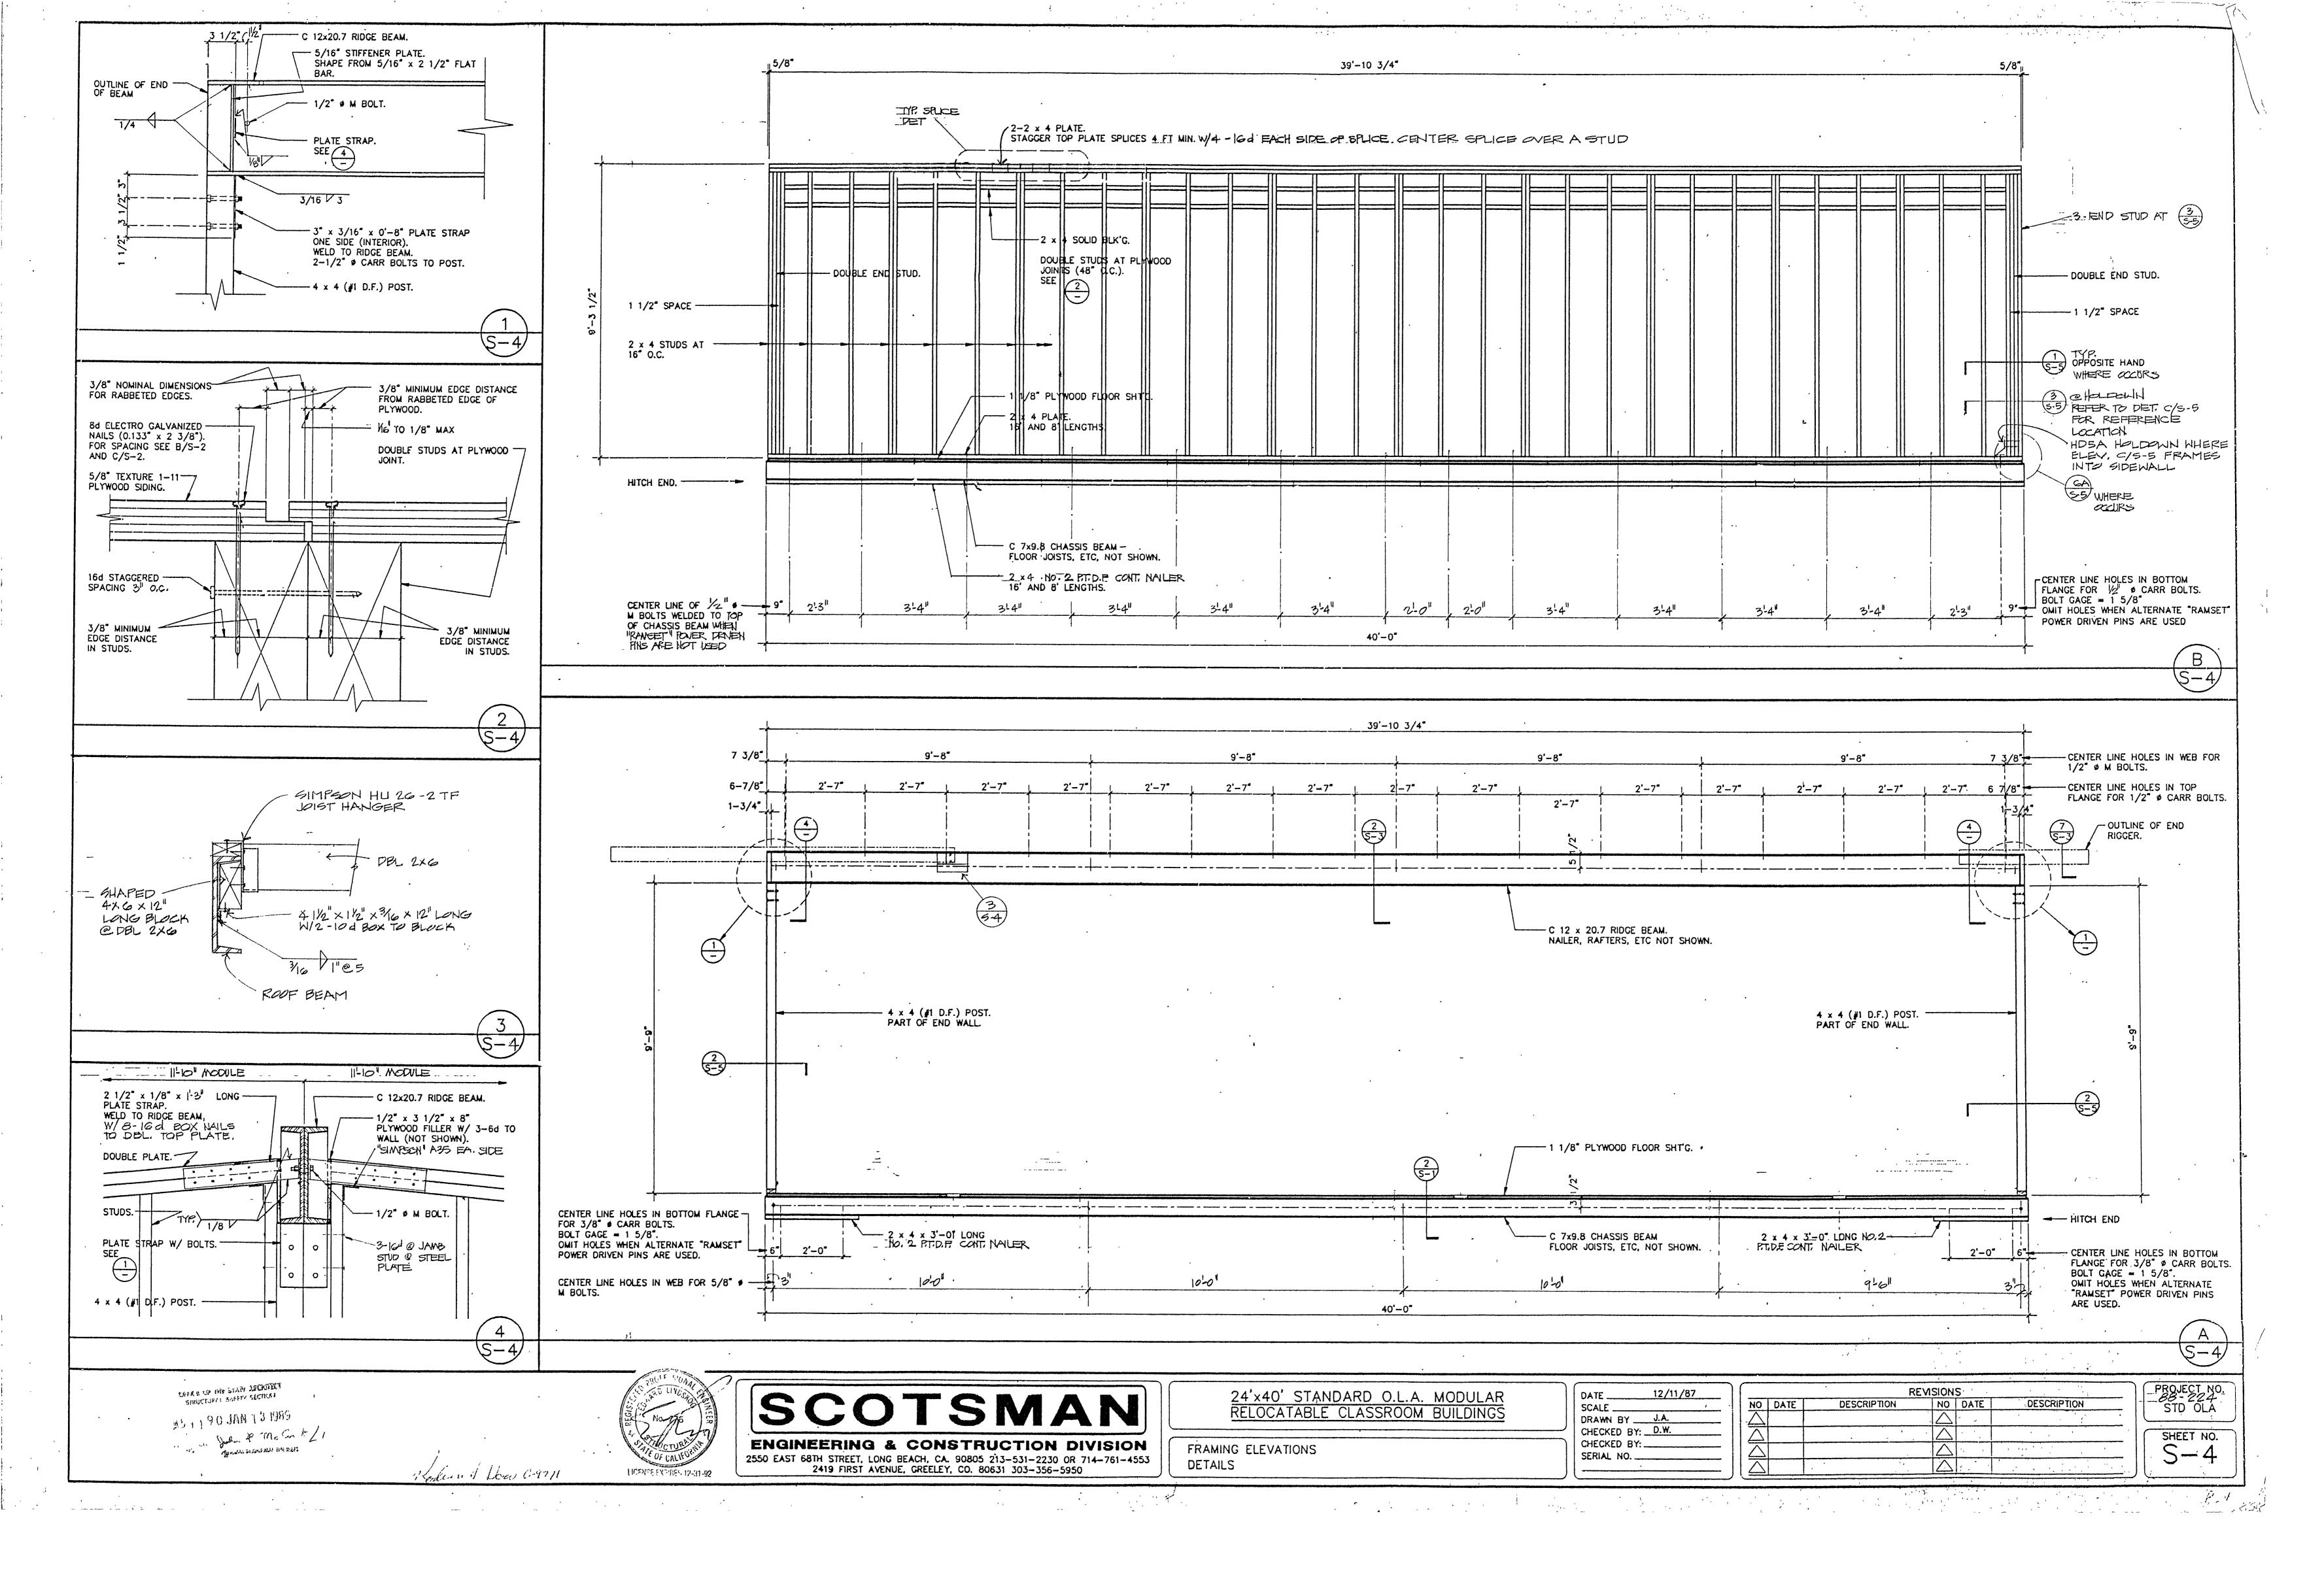

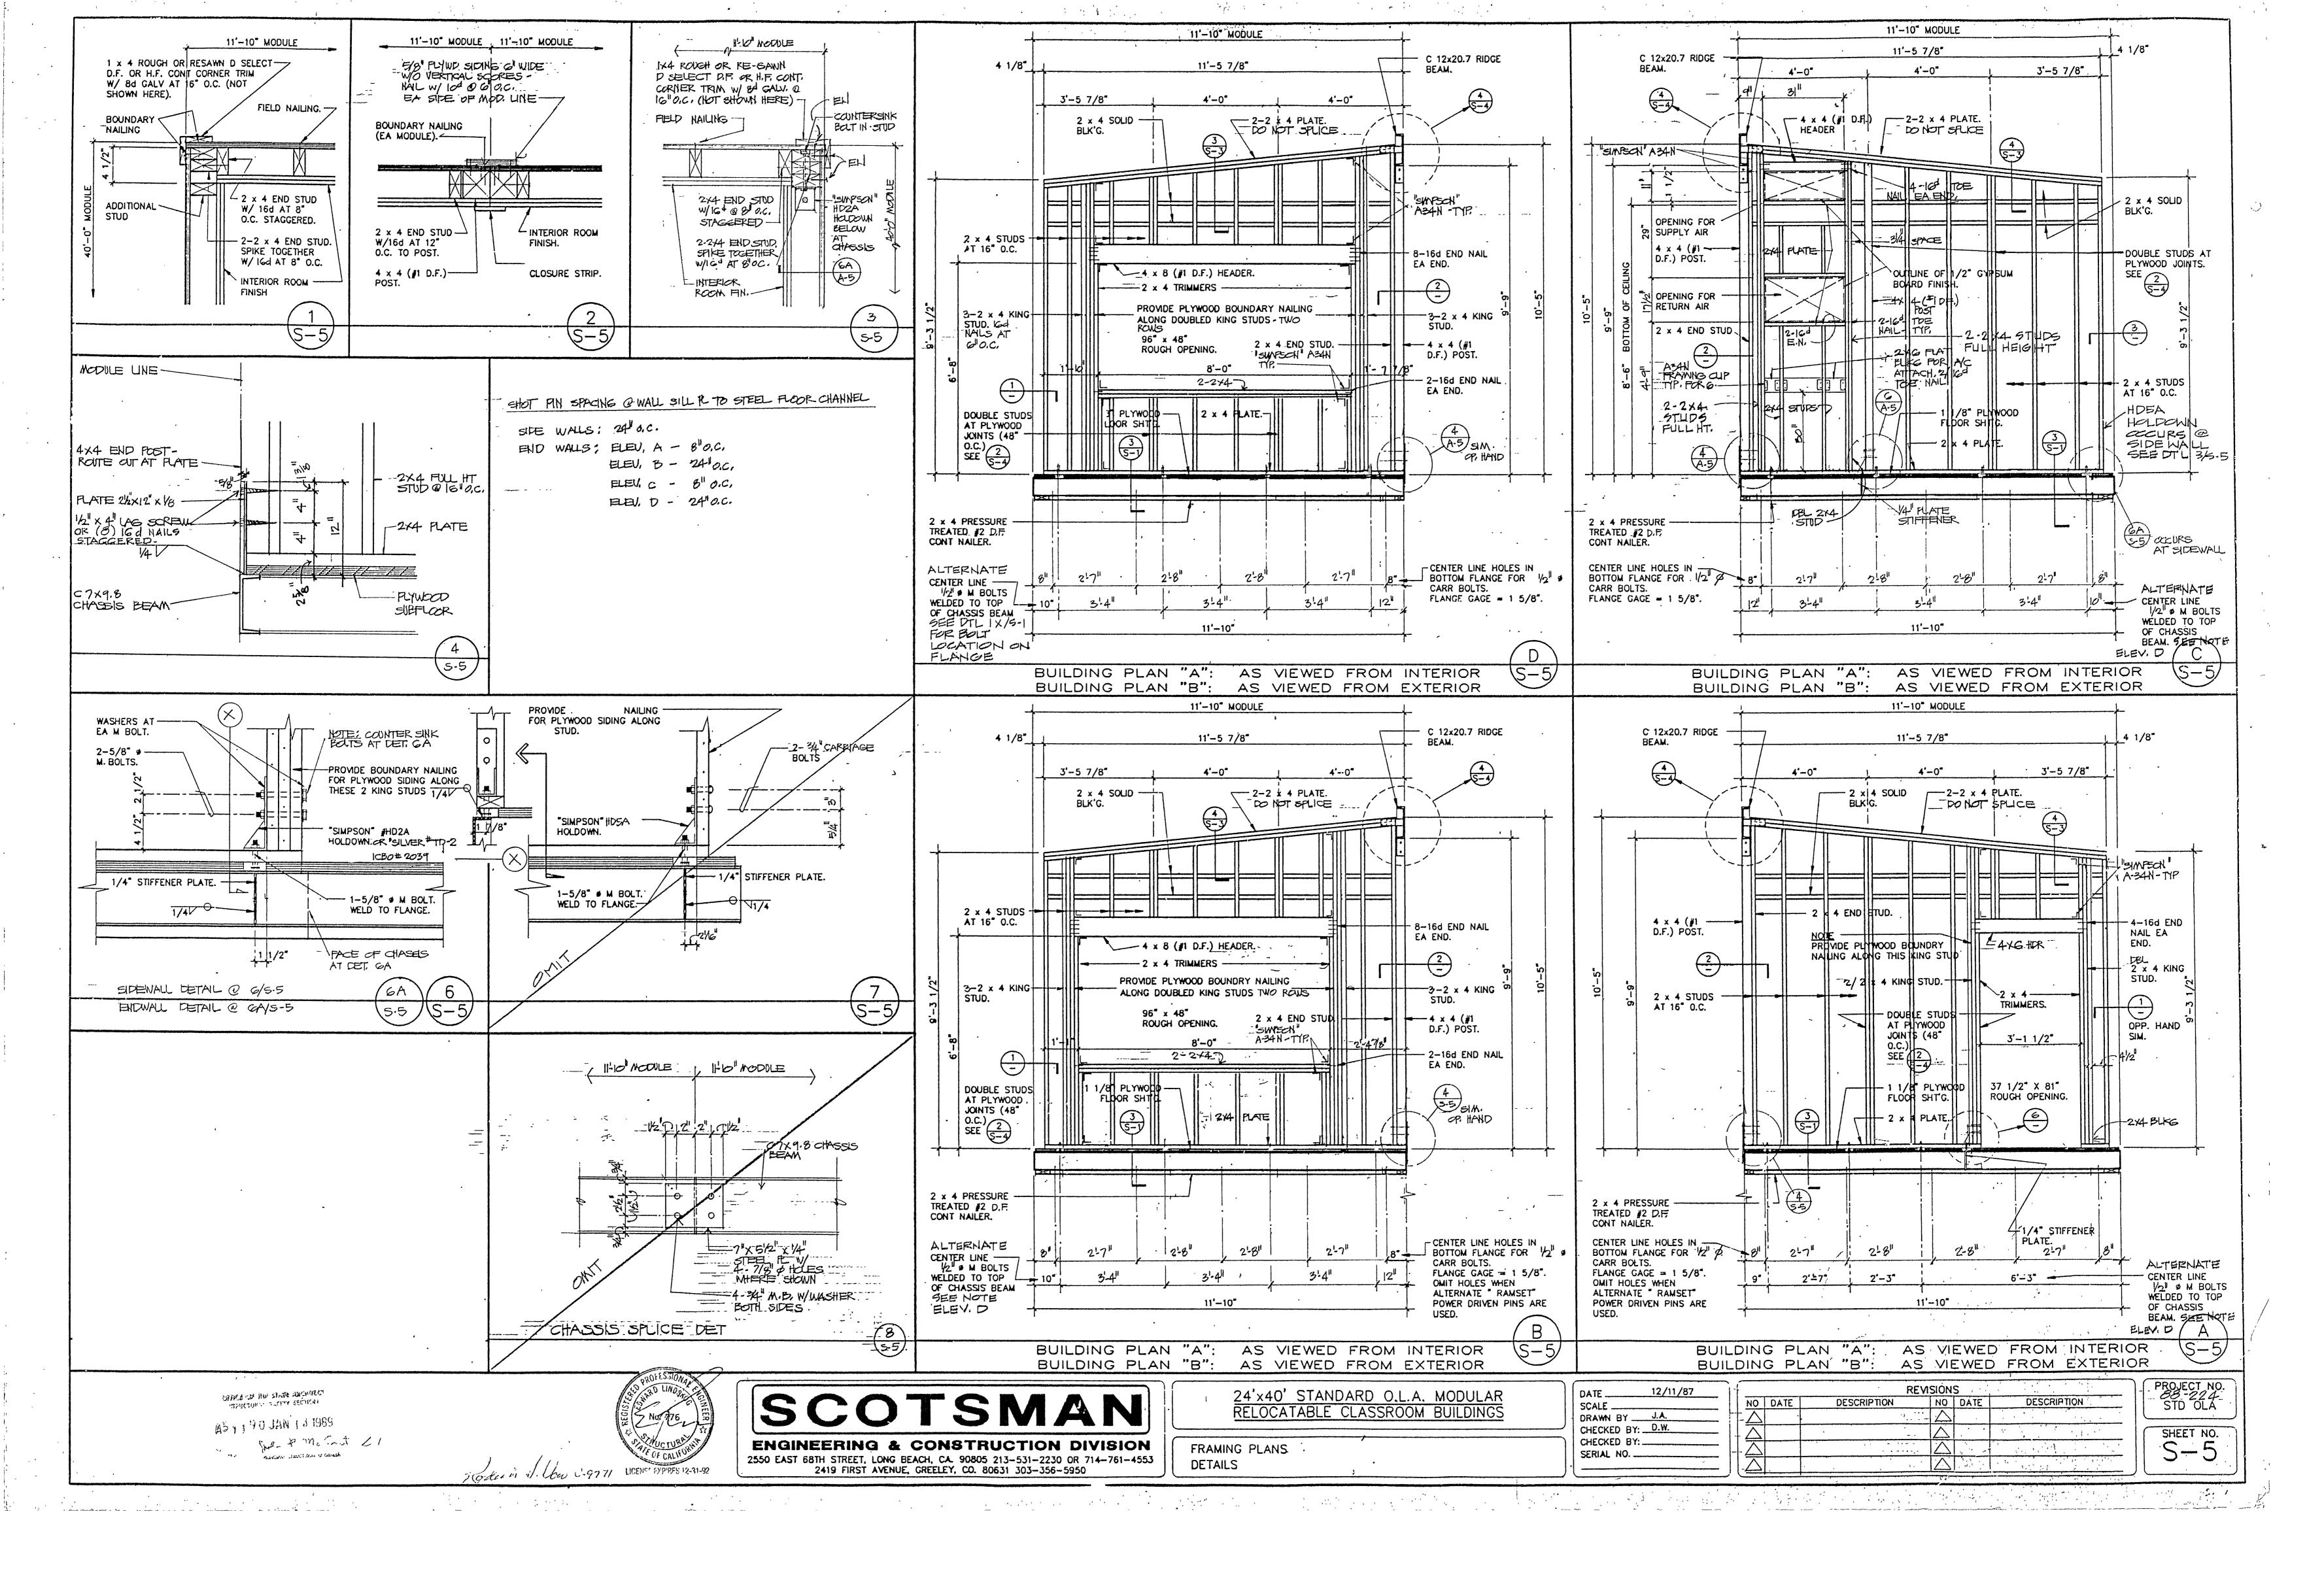


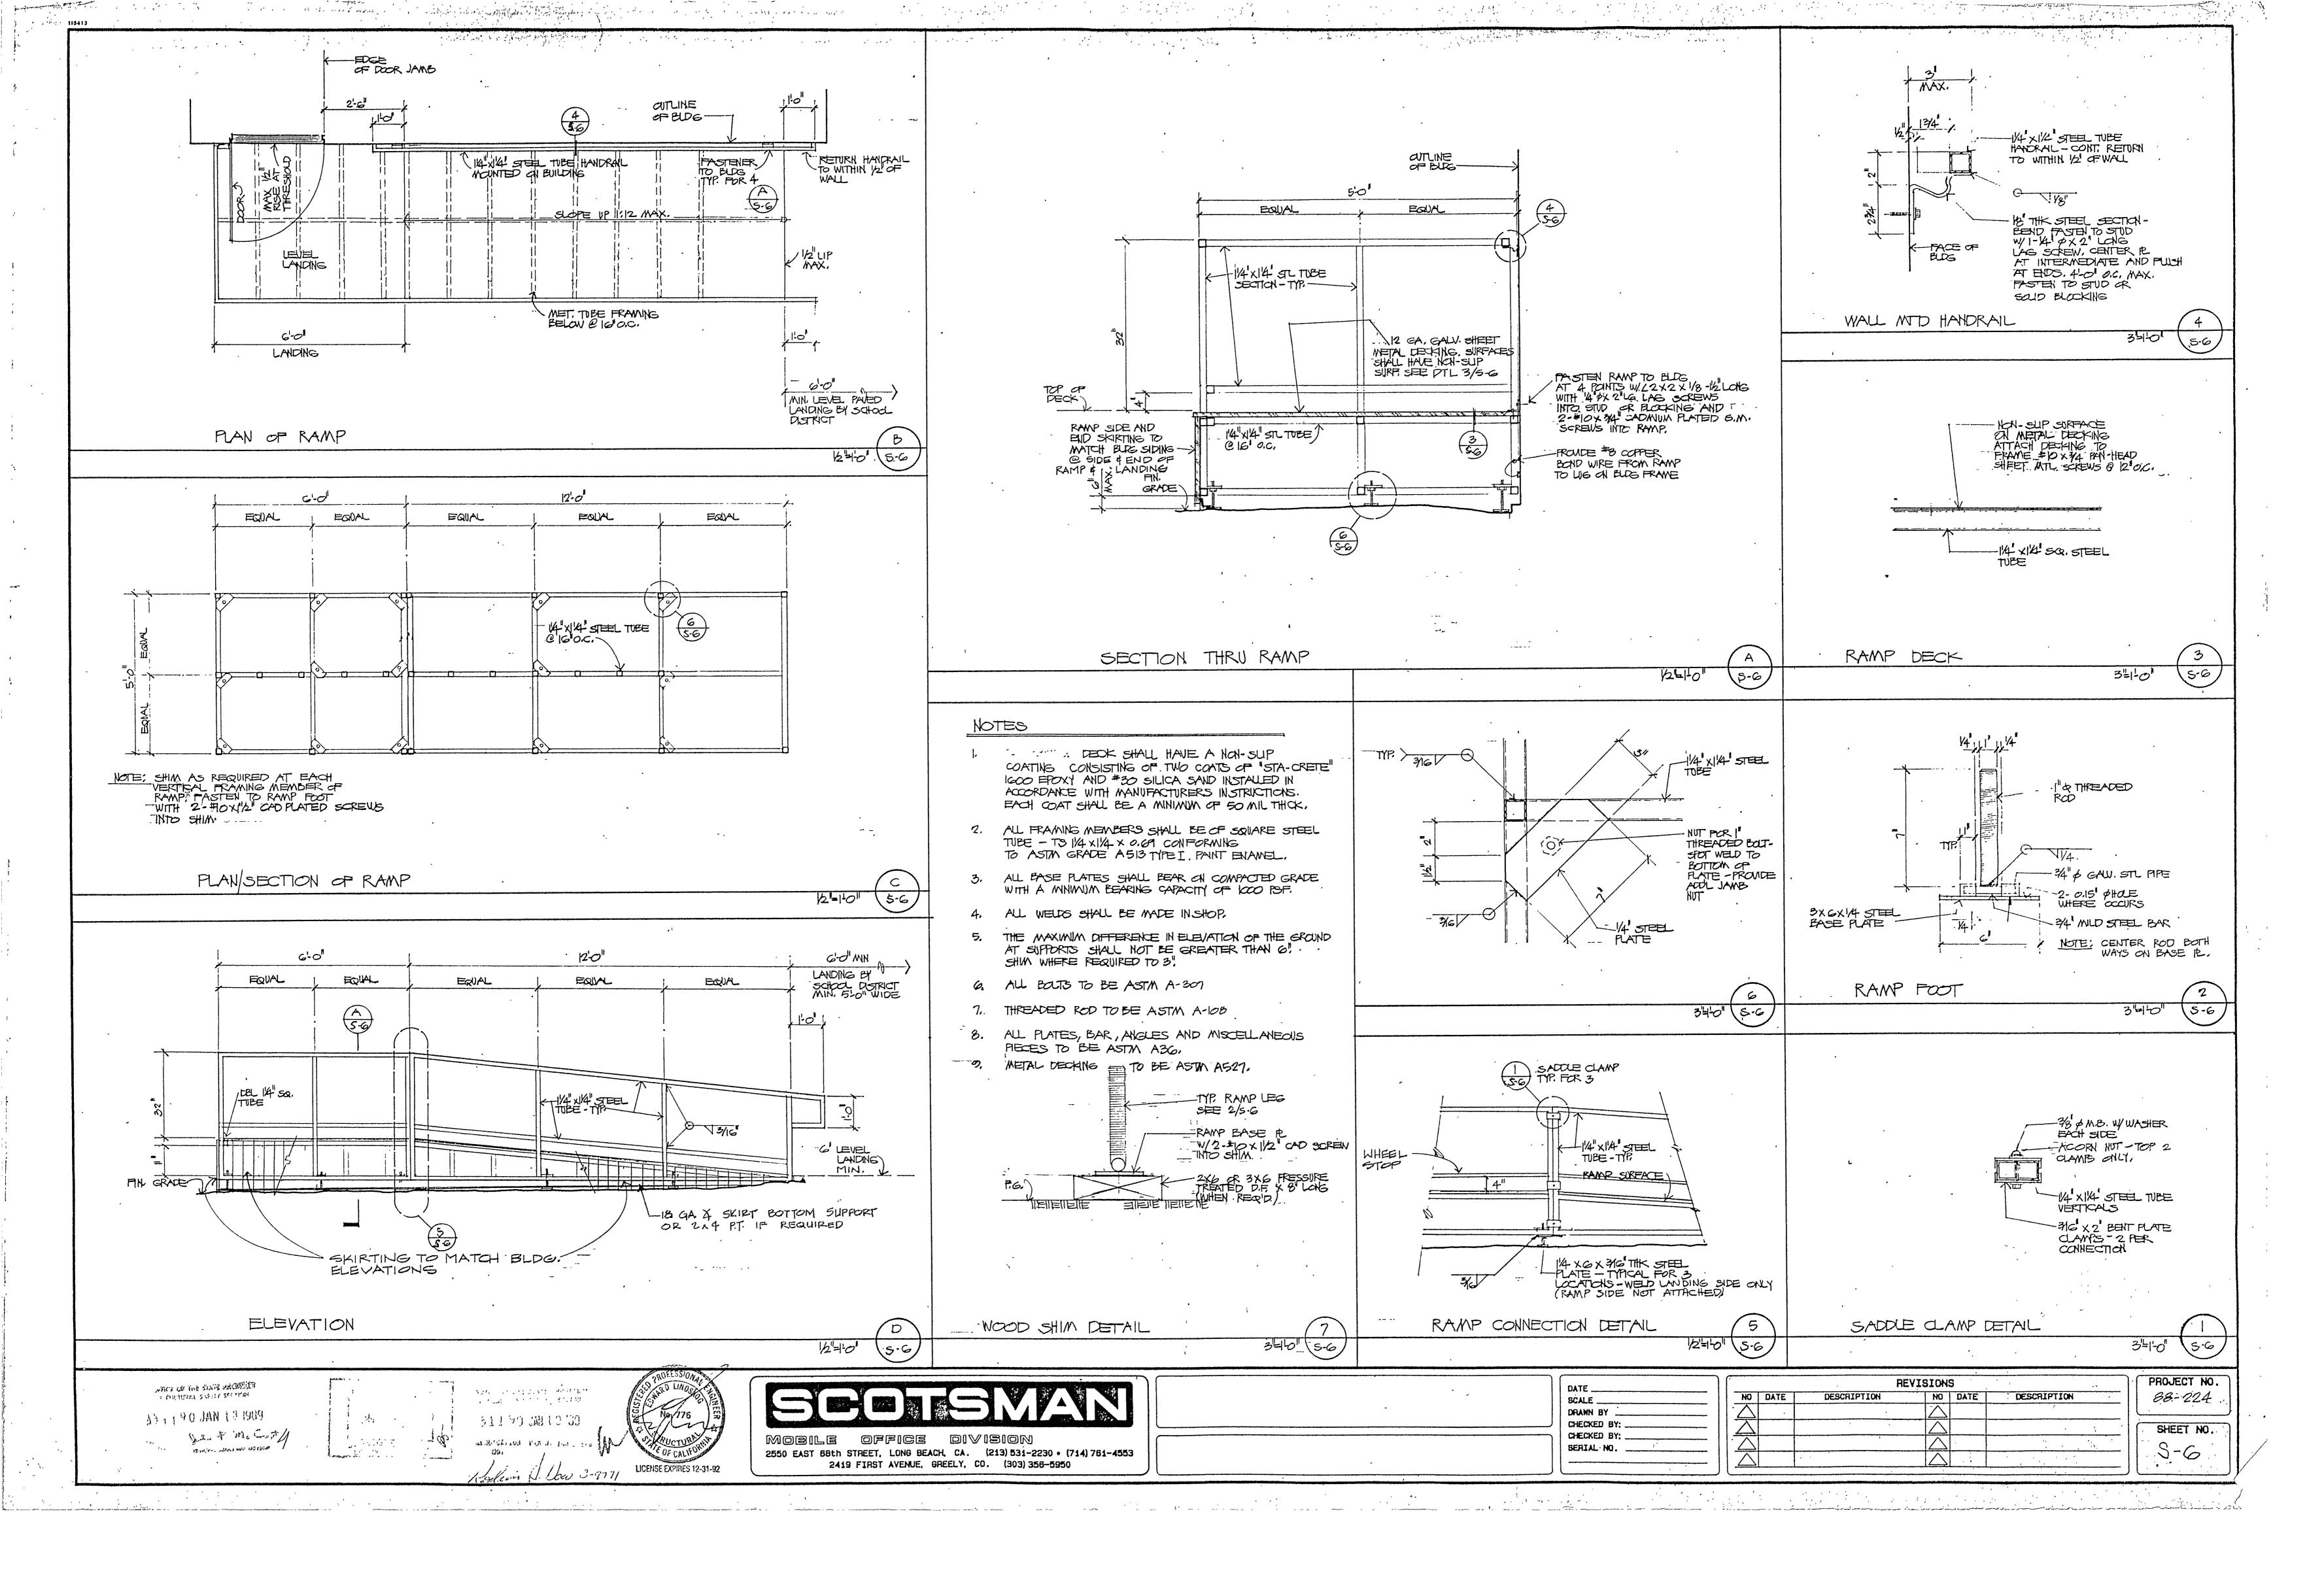



MODTECHLING. Relocatable classroom buildings

OFFICE OF LOCAL ASSISTANCE

			APRICATION AND APRICATION APPLICATION
INDEX			AR BUILDING
BINDING SHEET	DESCRIPTION		driver or a typic color and a color of the c
ORDER NUMBER			,51283JAN11'88
0.0	COVER SHEET:	INDEX, BUILDING BATA,	ATRIBATION PIEW. Staf Boise.
1.0	PLOOR, FOUND ELEVATIONS,		FIRE MARSHAL
3 2.0 4 2.1	TYPICAL DETA TYPICAL FOUN		
5 3.0 6 4.0 -	STRUCTURAL F ELECTRICAL.		
7 5.0 8 6.0 9 M-1	SUSPENDED CE GENERAL NOTE AIR CONDITION	S AND SPECIFICATIONS	
10 R-1	STANDARD RAMI		
11 R-Z	STANDARD RAM	AP PLAM	
			18
SYMBOL	. S		
TYPE 6	YMBOL	MEANING	
DETAIL	1	DETAIL ON SAME SHEET AS SYMBOL	
DETAIL		DETAIL NUMBER (1)	
	2	ON SHEET NO. (2)	
DETAIL	DET 5:2	DETAIL NUMBER (5) ON SHEET NO. (2)	
NOTE	(1)	NOTE NO (1) ON SAME SHEET AS SYMBOL	O L
NOTE	$\frac{4}{5}$	NOTE NUMBER (4) ON SHEET, NUMBER (5)	1600 N
NOTE	NOTE 4:3	NOTÉ NUMBER (1) ON	
PANEL		SHEET NUMBER (3)	
		SH. (8) FOR FRAMING	00893 G 译列
SECTION	(A)	SECTION (A) ON SHEET (2)	
			00780. 0078
A WAIVER OF	FURABILITY Sylvan Dist	will be read.	
CONDITIONAL	STATIDARD	FOUNDATION"	
Arrage			σ Σ Ξ
BUILDIN	GDATA		
OCCUPANCY TYPE OF CONSTRUC	E-2 CTION V-N		
WIND LOAD FLOOR LIVE LOAD ROOF LIVE LOAD	50 1	b/sq ft b/sq ft b/sq ft	
BUILDING AREA	(EACH) 960 s		
U.B.C. 1979 TITLE 24 C.A.C. TITLE 21 C.A.C.	STRUCTURAL PART 2		JV.O.B.L.G.F.V
	HEAR WALL		
FOUNDATION: W	WA 121-ANI		"我们是《A····································
CTUTTION TO	WO 12'x40'		() () () () () () () () () ()
SIMILAR TO: PC-	OOD		ROOM : OOS 19
	OOD	SHAL	ASSROOM 93 & 009 19 14 28 SSSTANCE
OFFICE	OOD OF STATE FIRE MAR. APPROVED		E CLASSROOM CORPS & YOUR SOURCE CORPS & YOUR S
Approval of this any omission or	OOD OF STATE FIRE MAR APPROVED plan does not authorized	e or approve	TABLE CLASSROOM OG. TOO BE & TOO FOR THE CONTRACT OF THE CONT
Approval of this any omission or tions. Final appro	OOD OF STATE FIRE MAR! APPROVED plan does not authorized deviation from application oval is subject to field in oved plans shall be available.	e or approve ble regula- ispection.	OCATABLE CLASSROOM No. CLASSROOM TECH JOB NO.
Approval of this any omission or tions. Final appro	OOD OF STATE FIRE MAR! APPROVED plan does not authorized deviation from application oval is subject to field in oved plans shall be available.	e or approve ble regula- ispection.	RELOCATABLE CLASSROOM P.O. No. No. OO 993 & 009 Fg Bid No. OO 0438 & 009 Fg OFFICE NO. ASSISTANCE NO. ASSISTANC
Approval of this any omission or tions. Final appropriate of appropriate at all	OOD OF STATE FIRE MAR! APPROVED plan does not authorized deviation from application oval is subject to field in oved plans shall be available.	e or approve ble regula- ispection.	TRELOCATABLE CLASSROOM P.O. No. OOTBOS: OOG93 & OO9F9 BIRD NO. A 9 0 - OO 0.4.58 OFFICE & LOCAL ASSISTANCE WOOTECH JOB, NO.
Approval of this any omission or tions. Final appropriate of appropriate at all	OF STATE FIRE MAR. APPROVED plan does not authorized deviation from application oval is subject to field in oved plans shall be available available.	e or approve ble regula- ispection.	TRELOCATABLE CLASSROOM ON NO NO NO SO

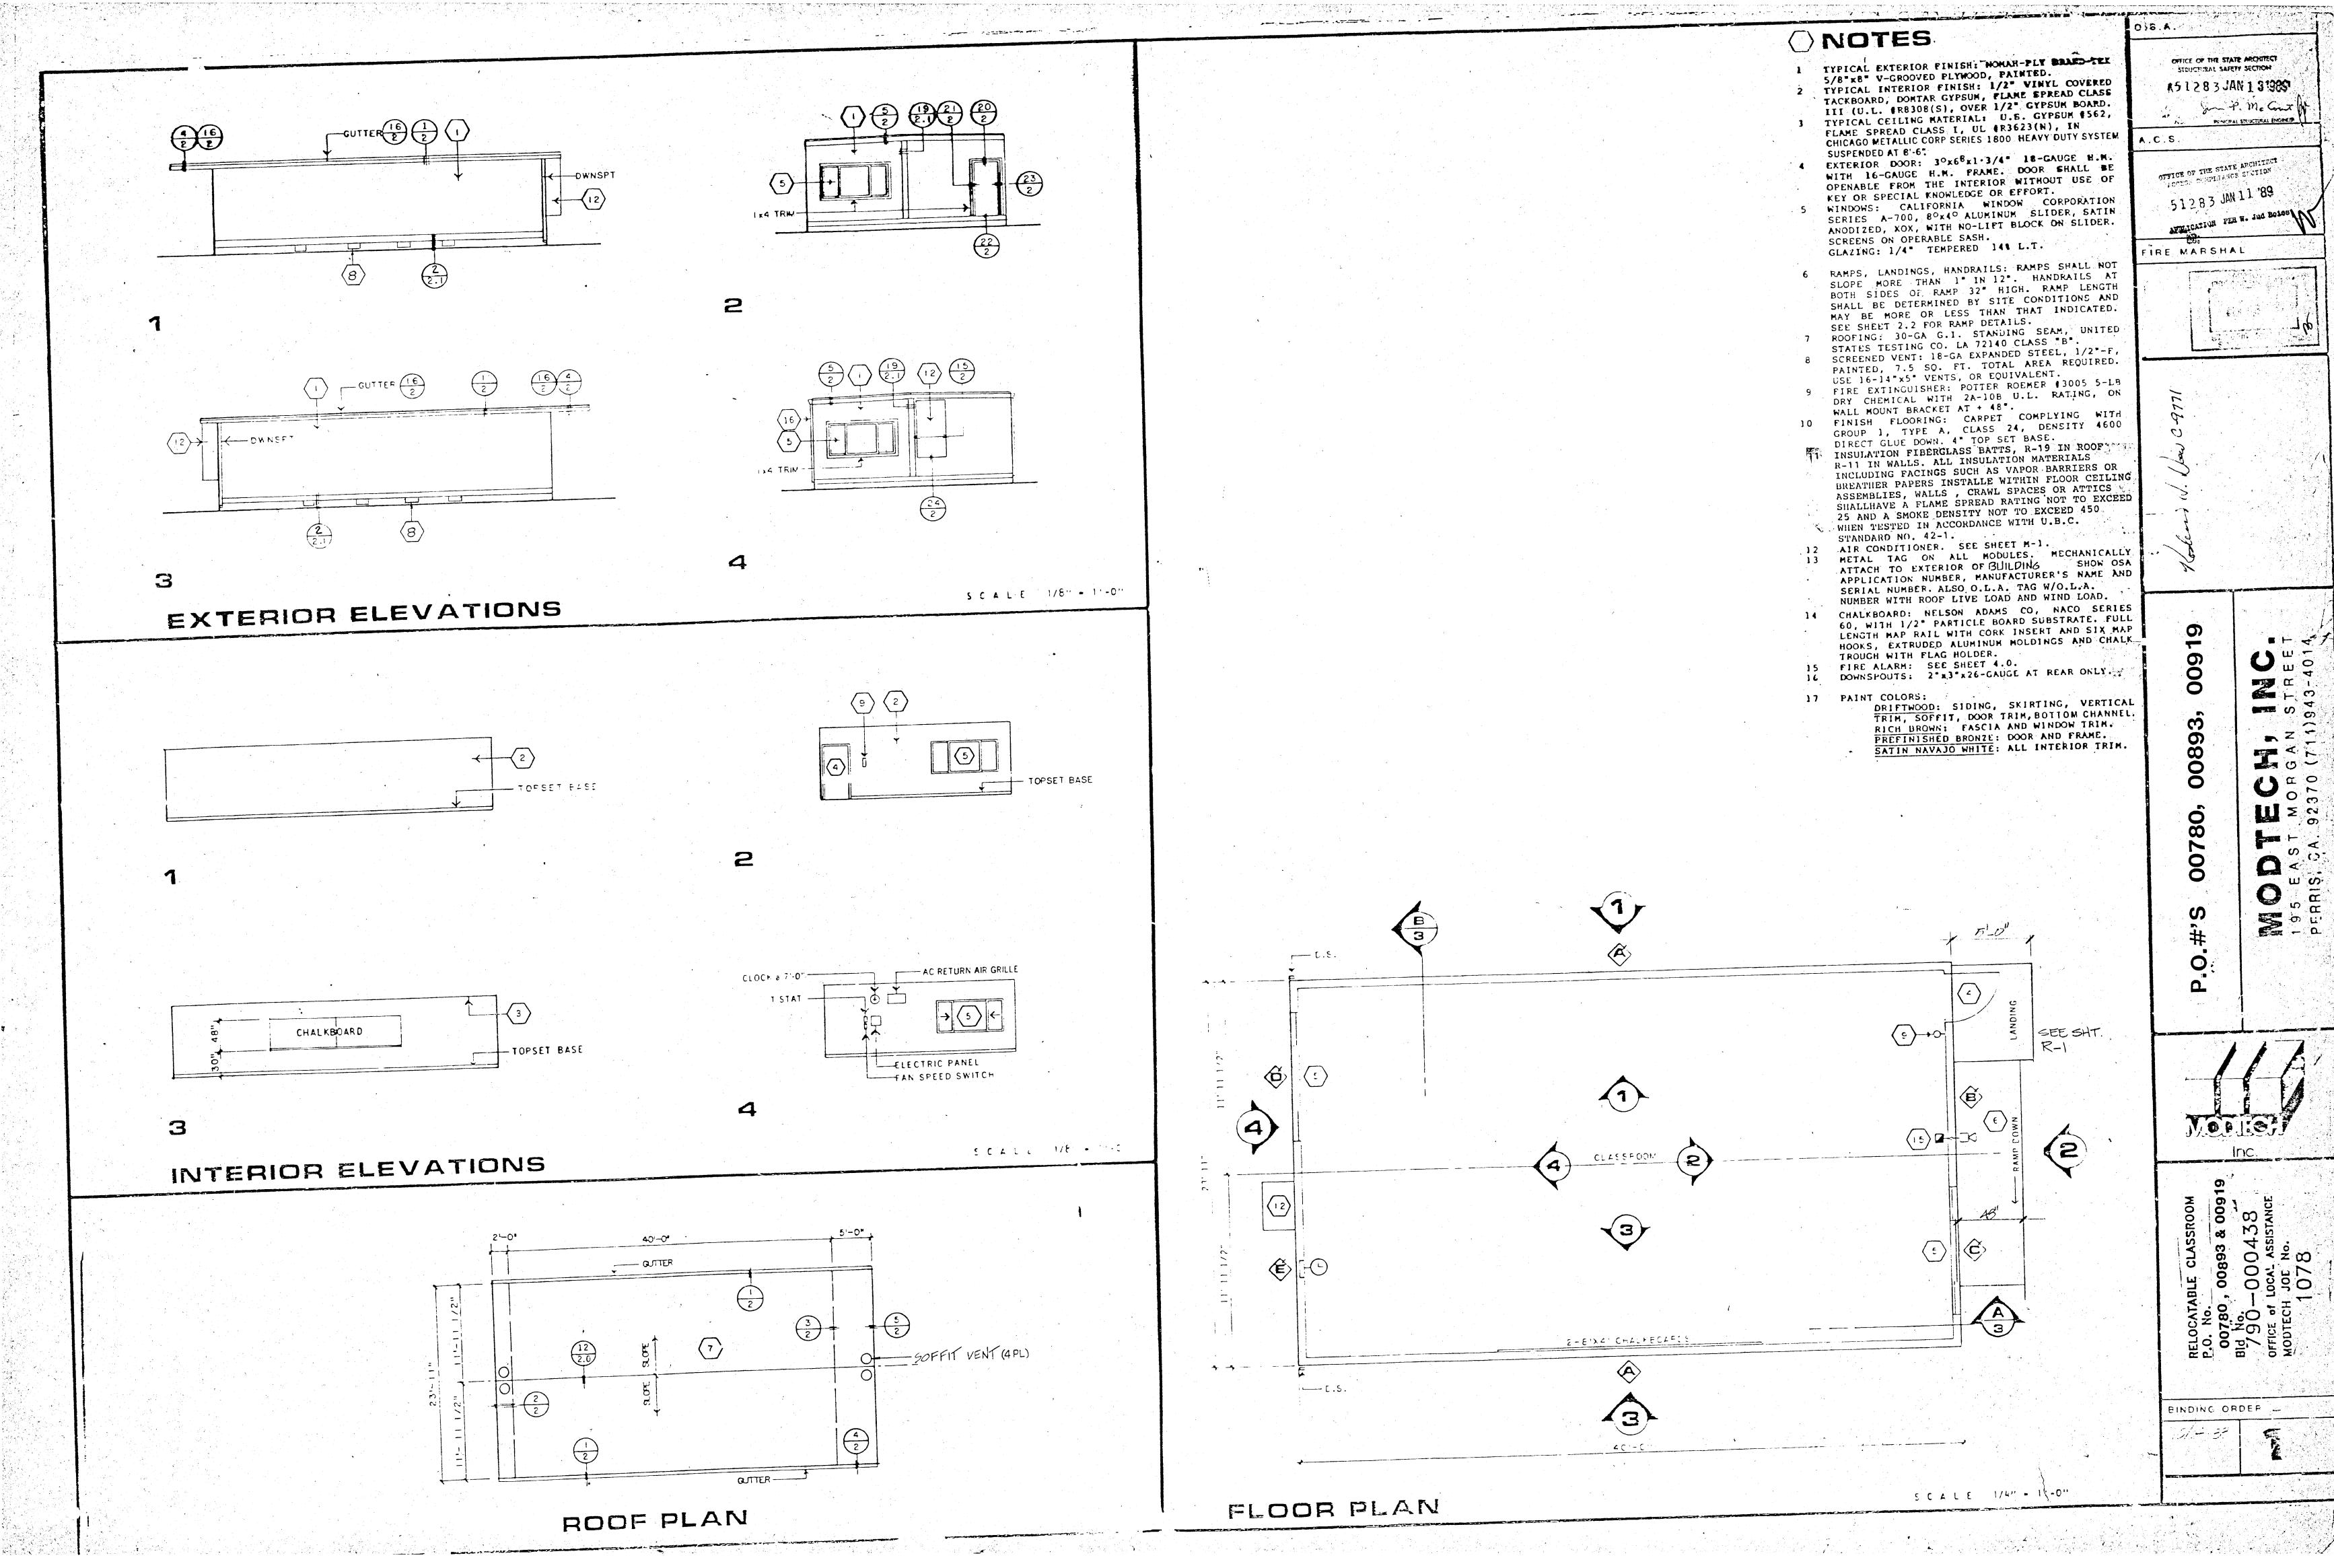

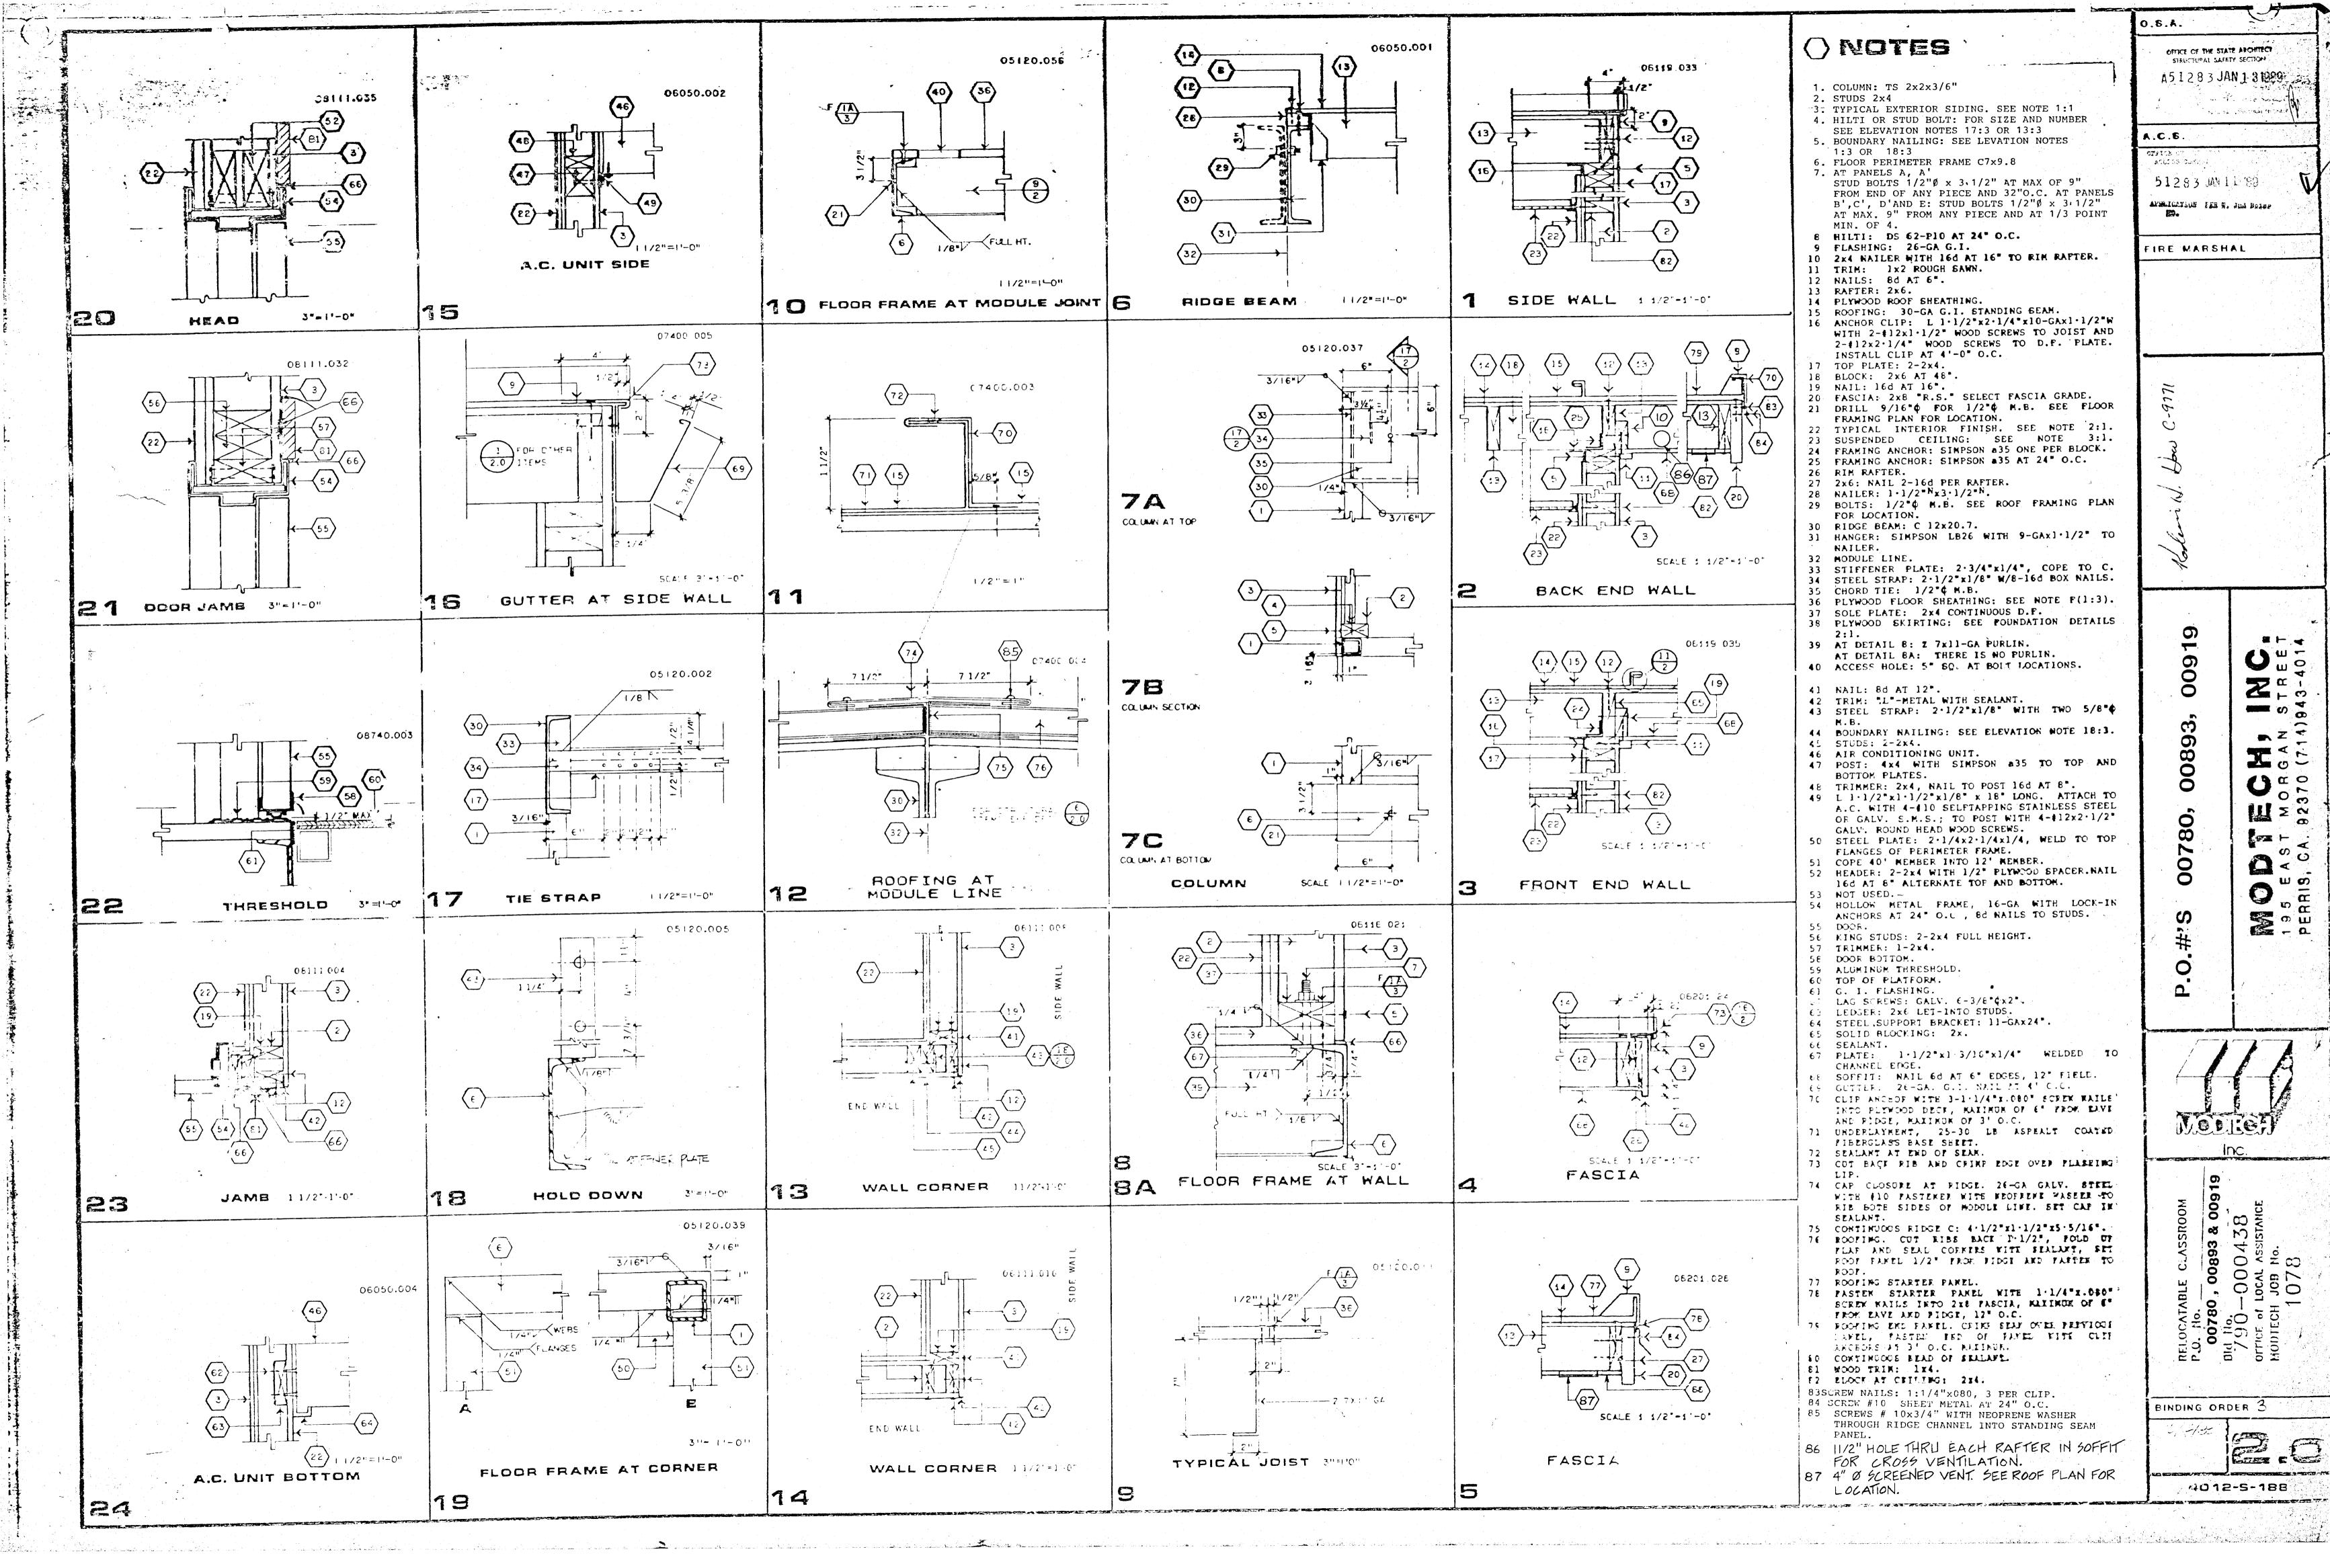

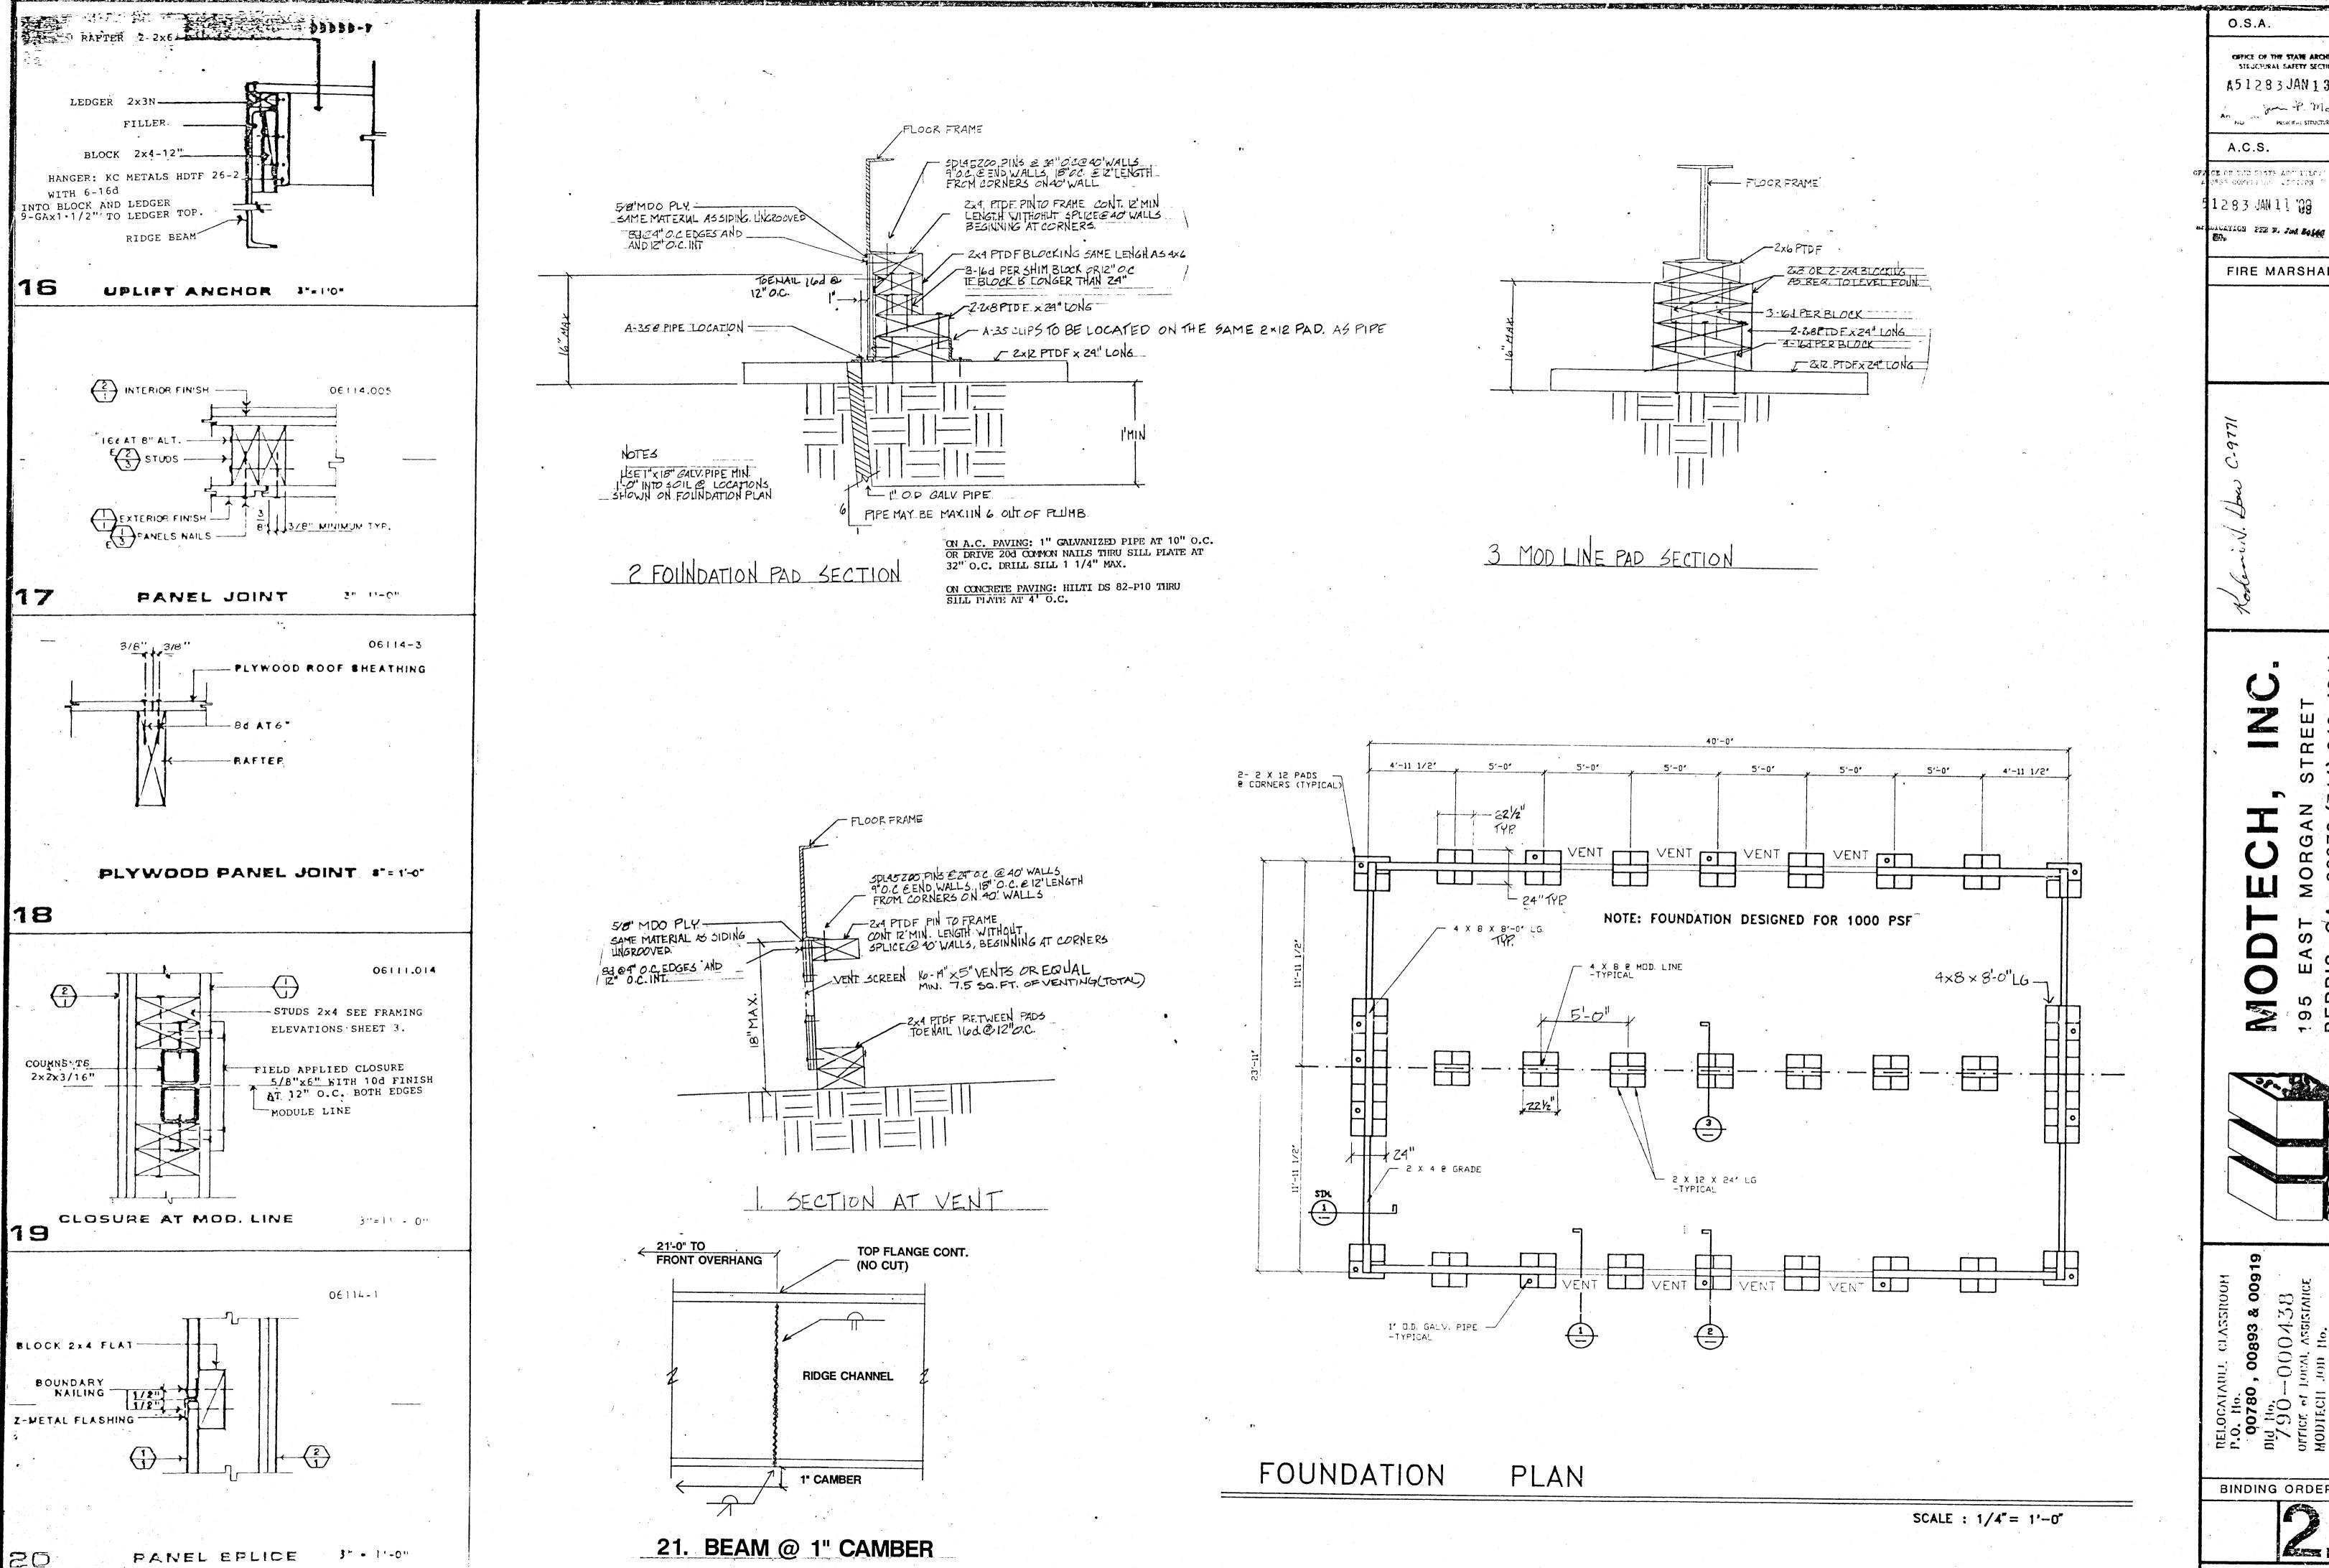


STEUCHURAL SAFETY SECTION A51283 JAN 1 31989 PRINCIPAL STRUCTURAL ENGINESS A.C.S.


OR OF THE STATE ASSULTED TST COMPLISHED CICIPEN 1283 JAN 11 'QQ


FIRE MARSHAL

195 EA PERRIS,

BINDING ORDER

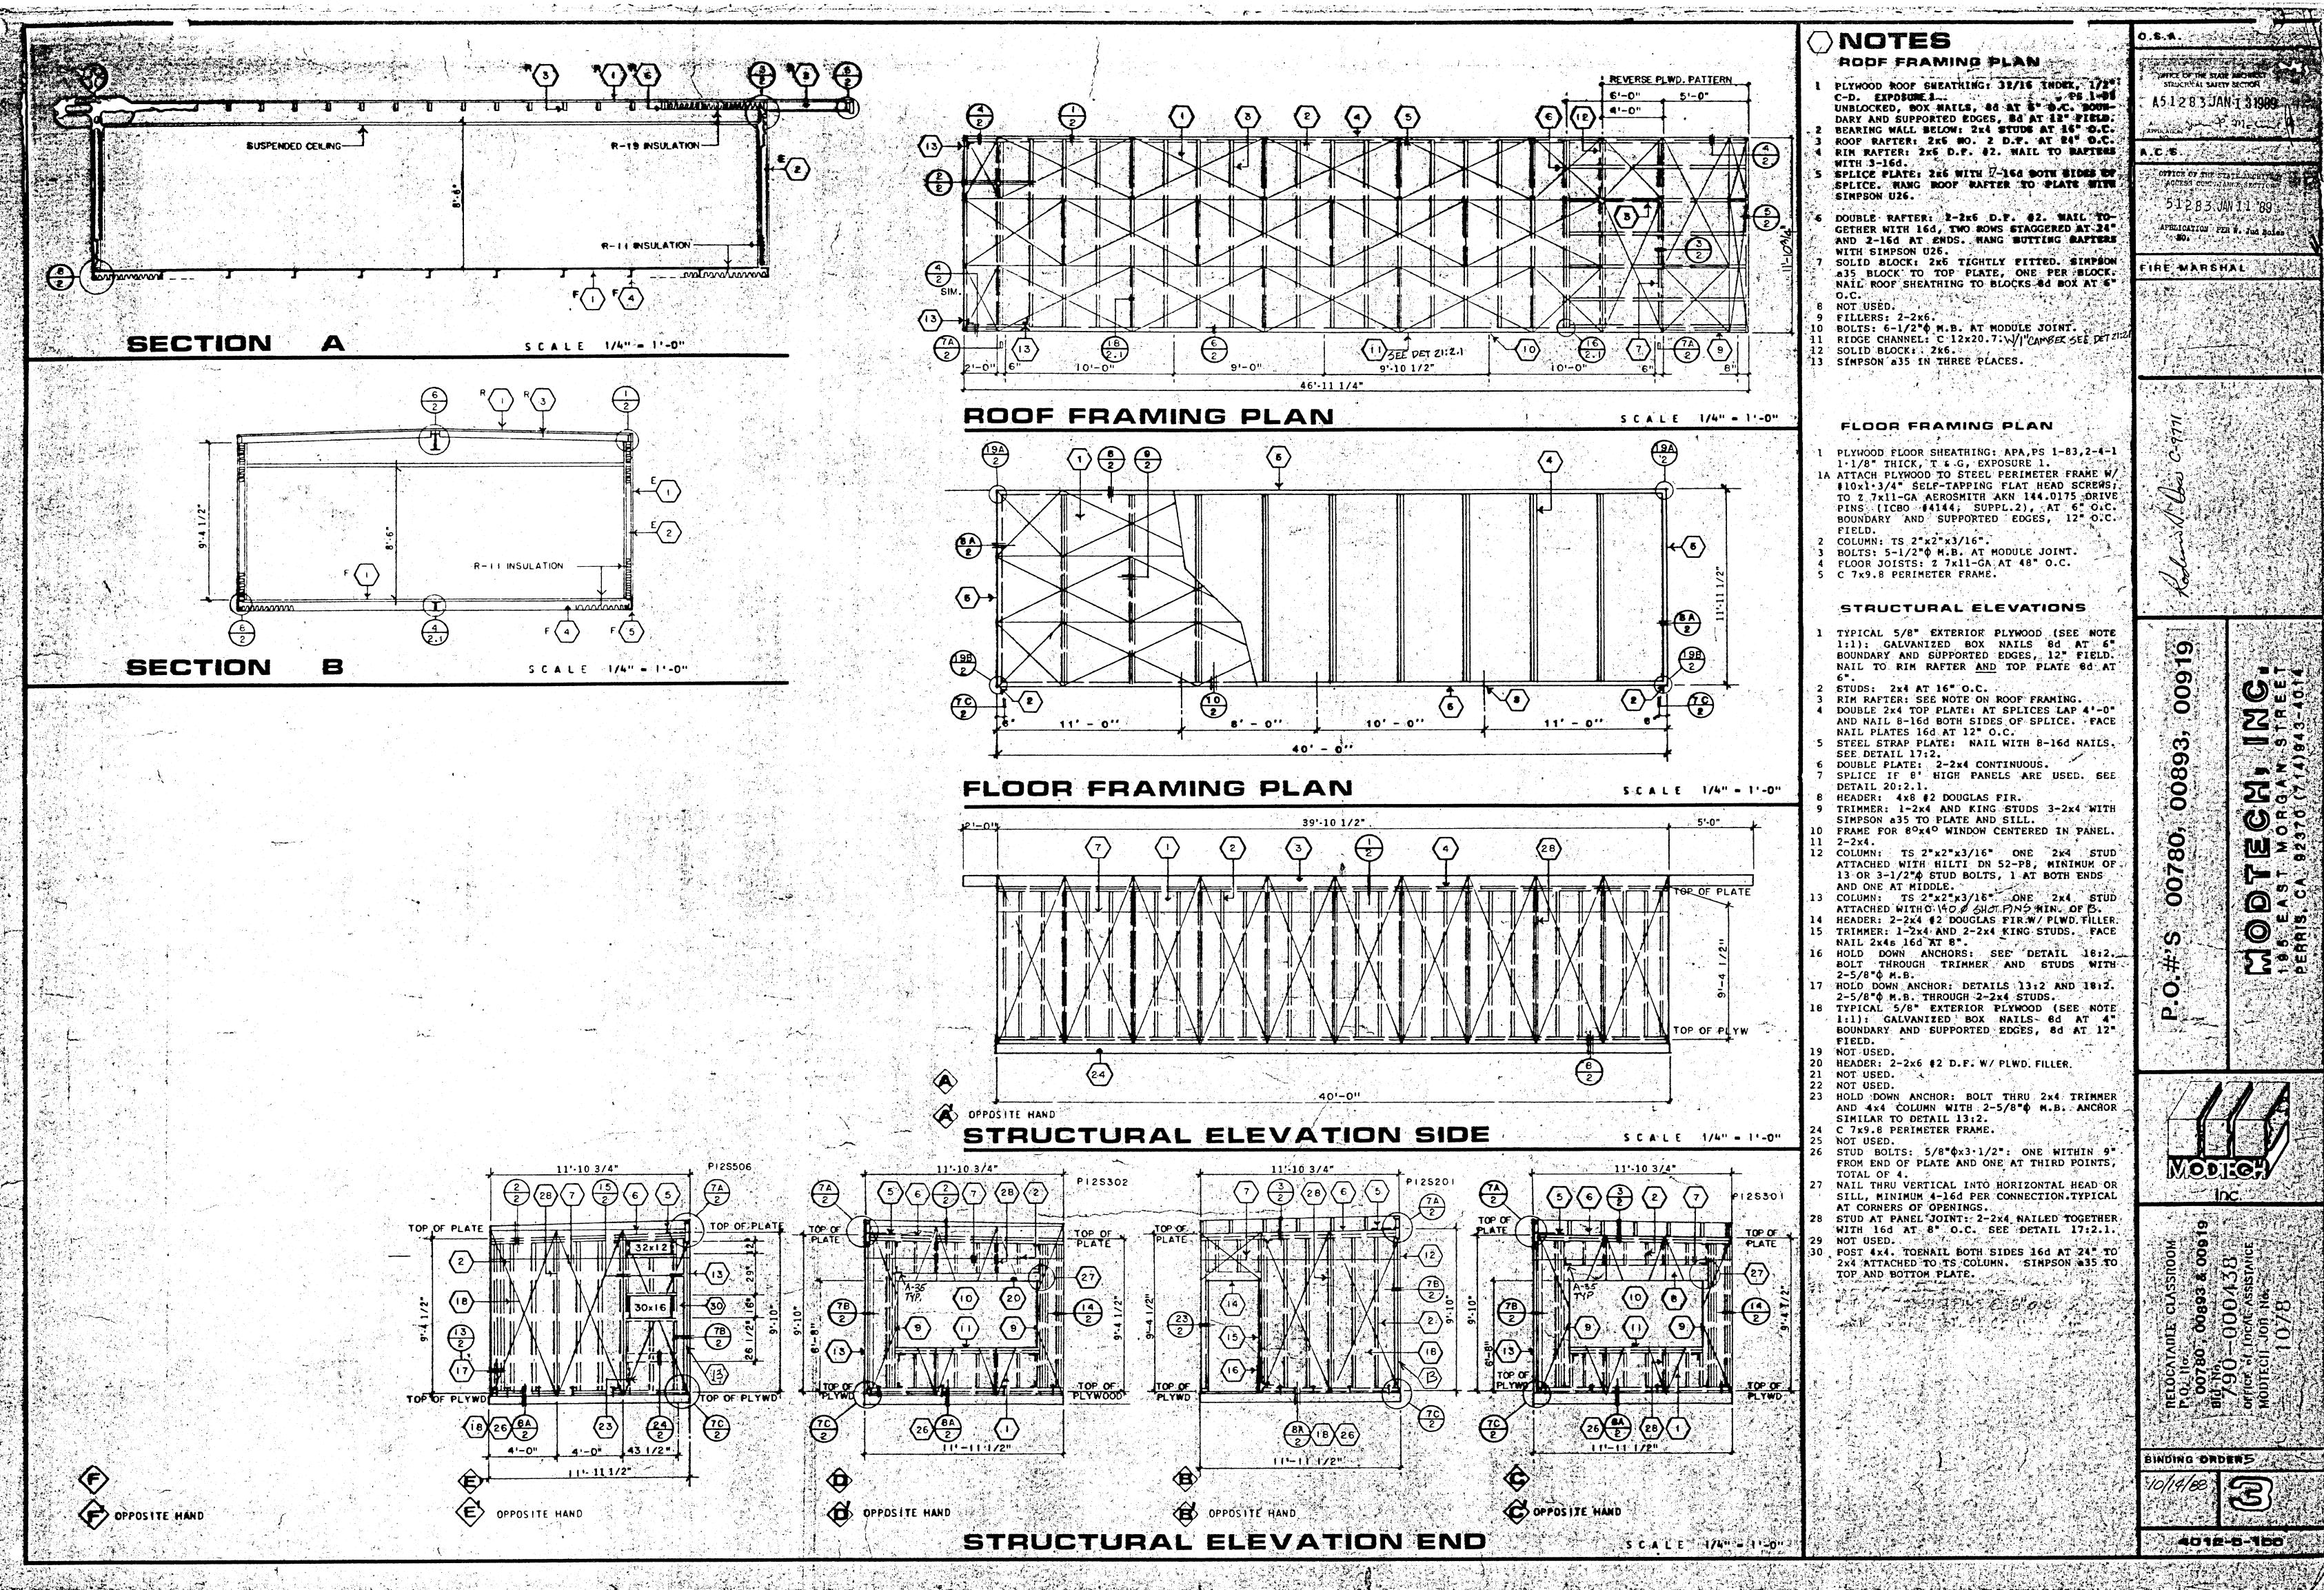

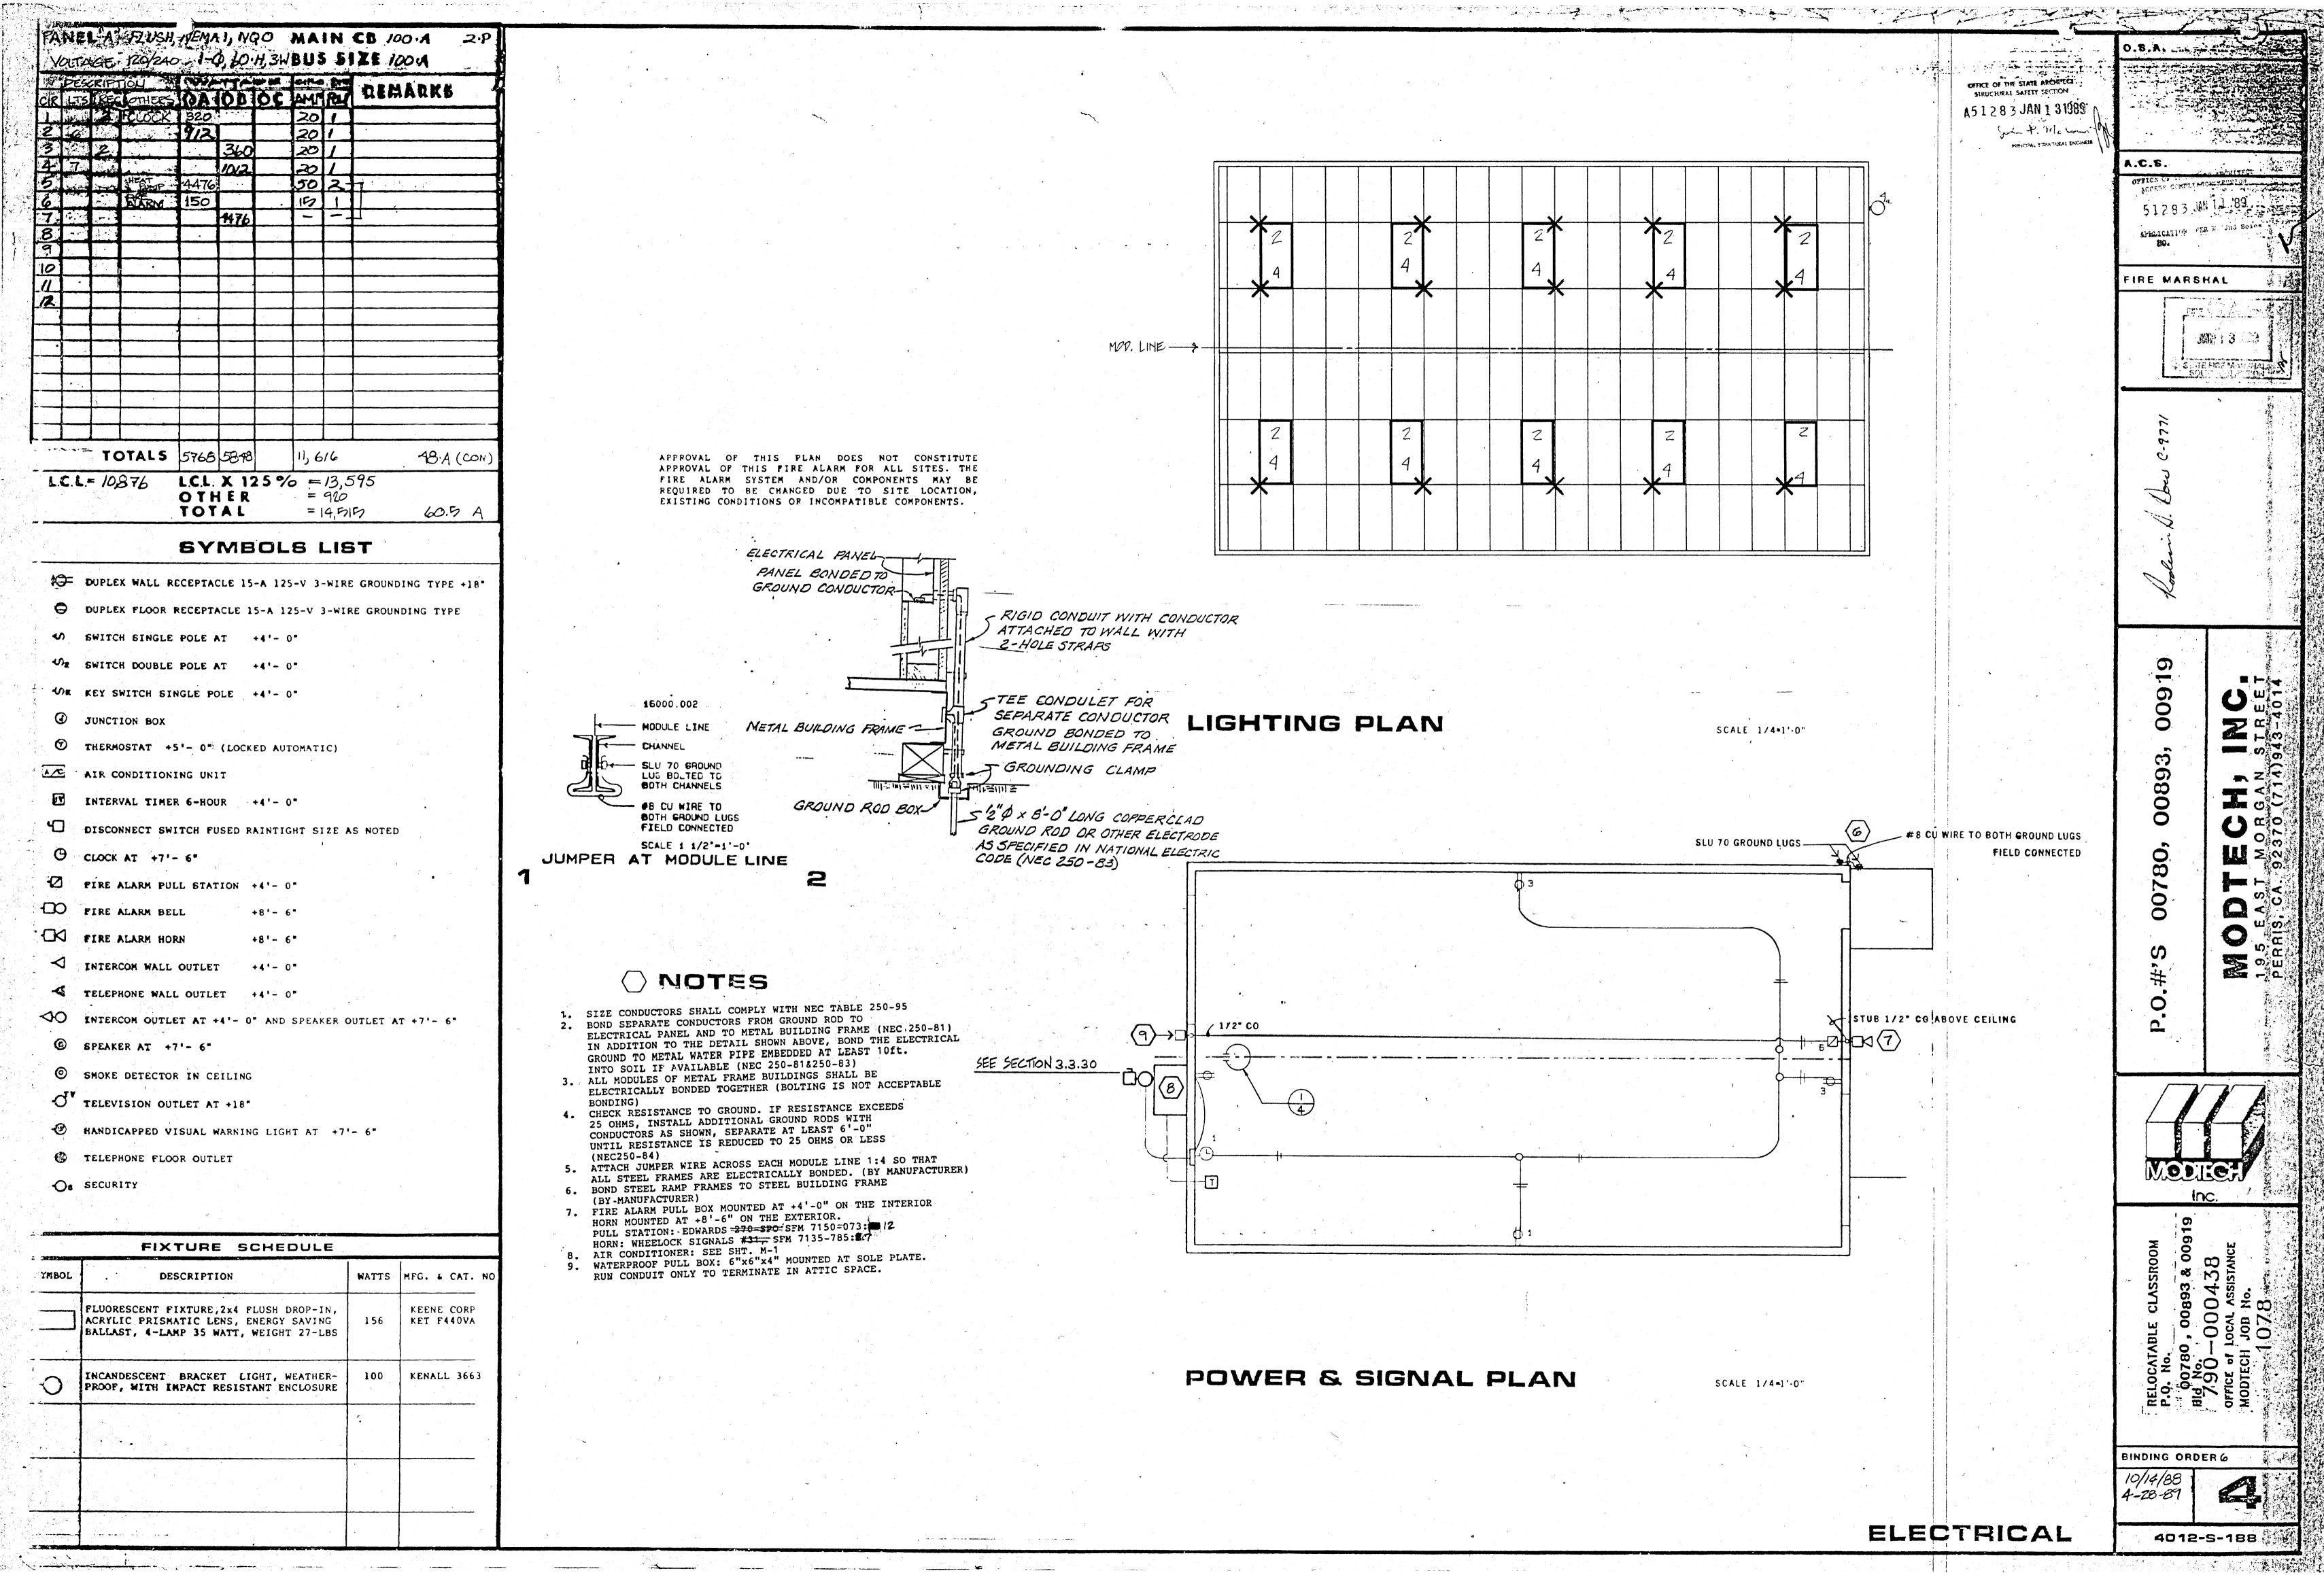

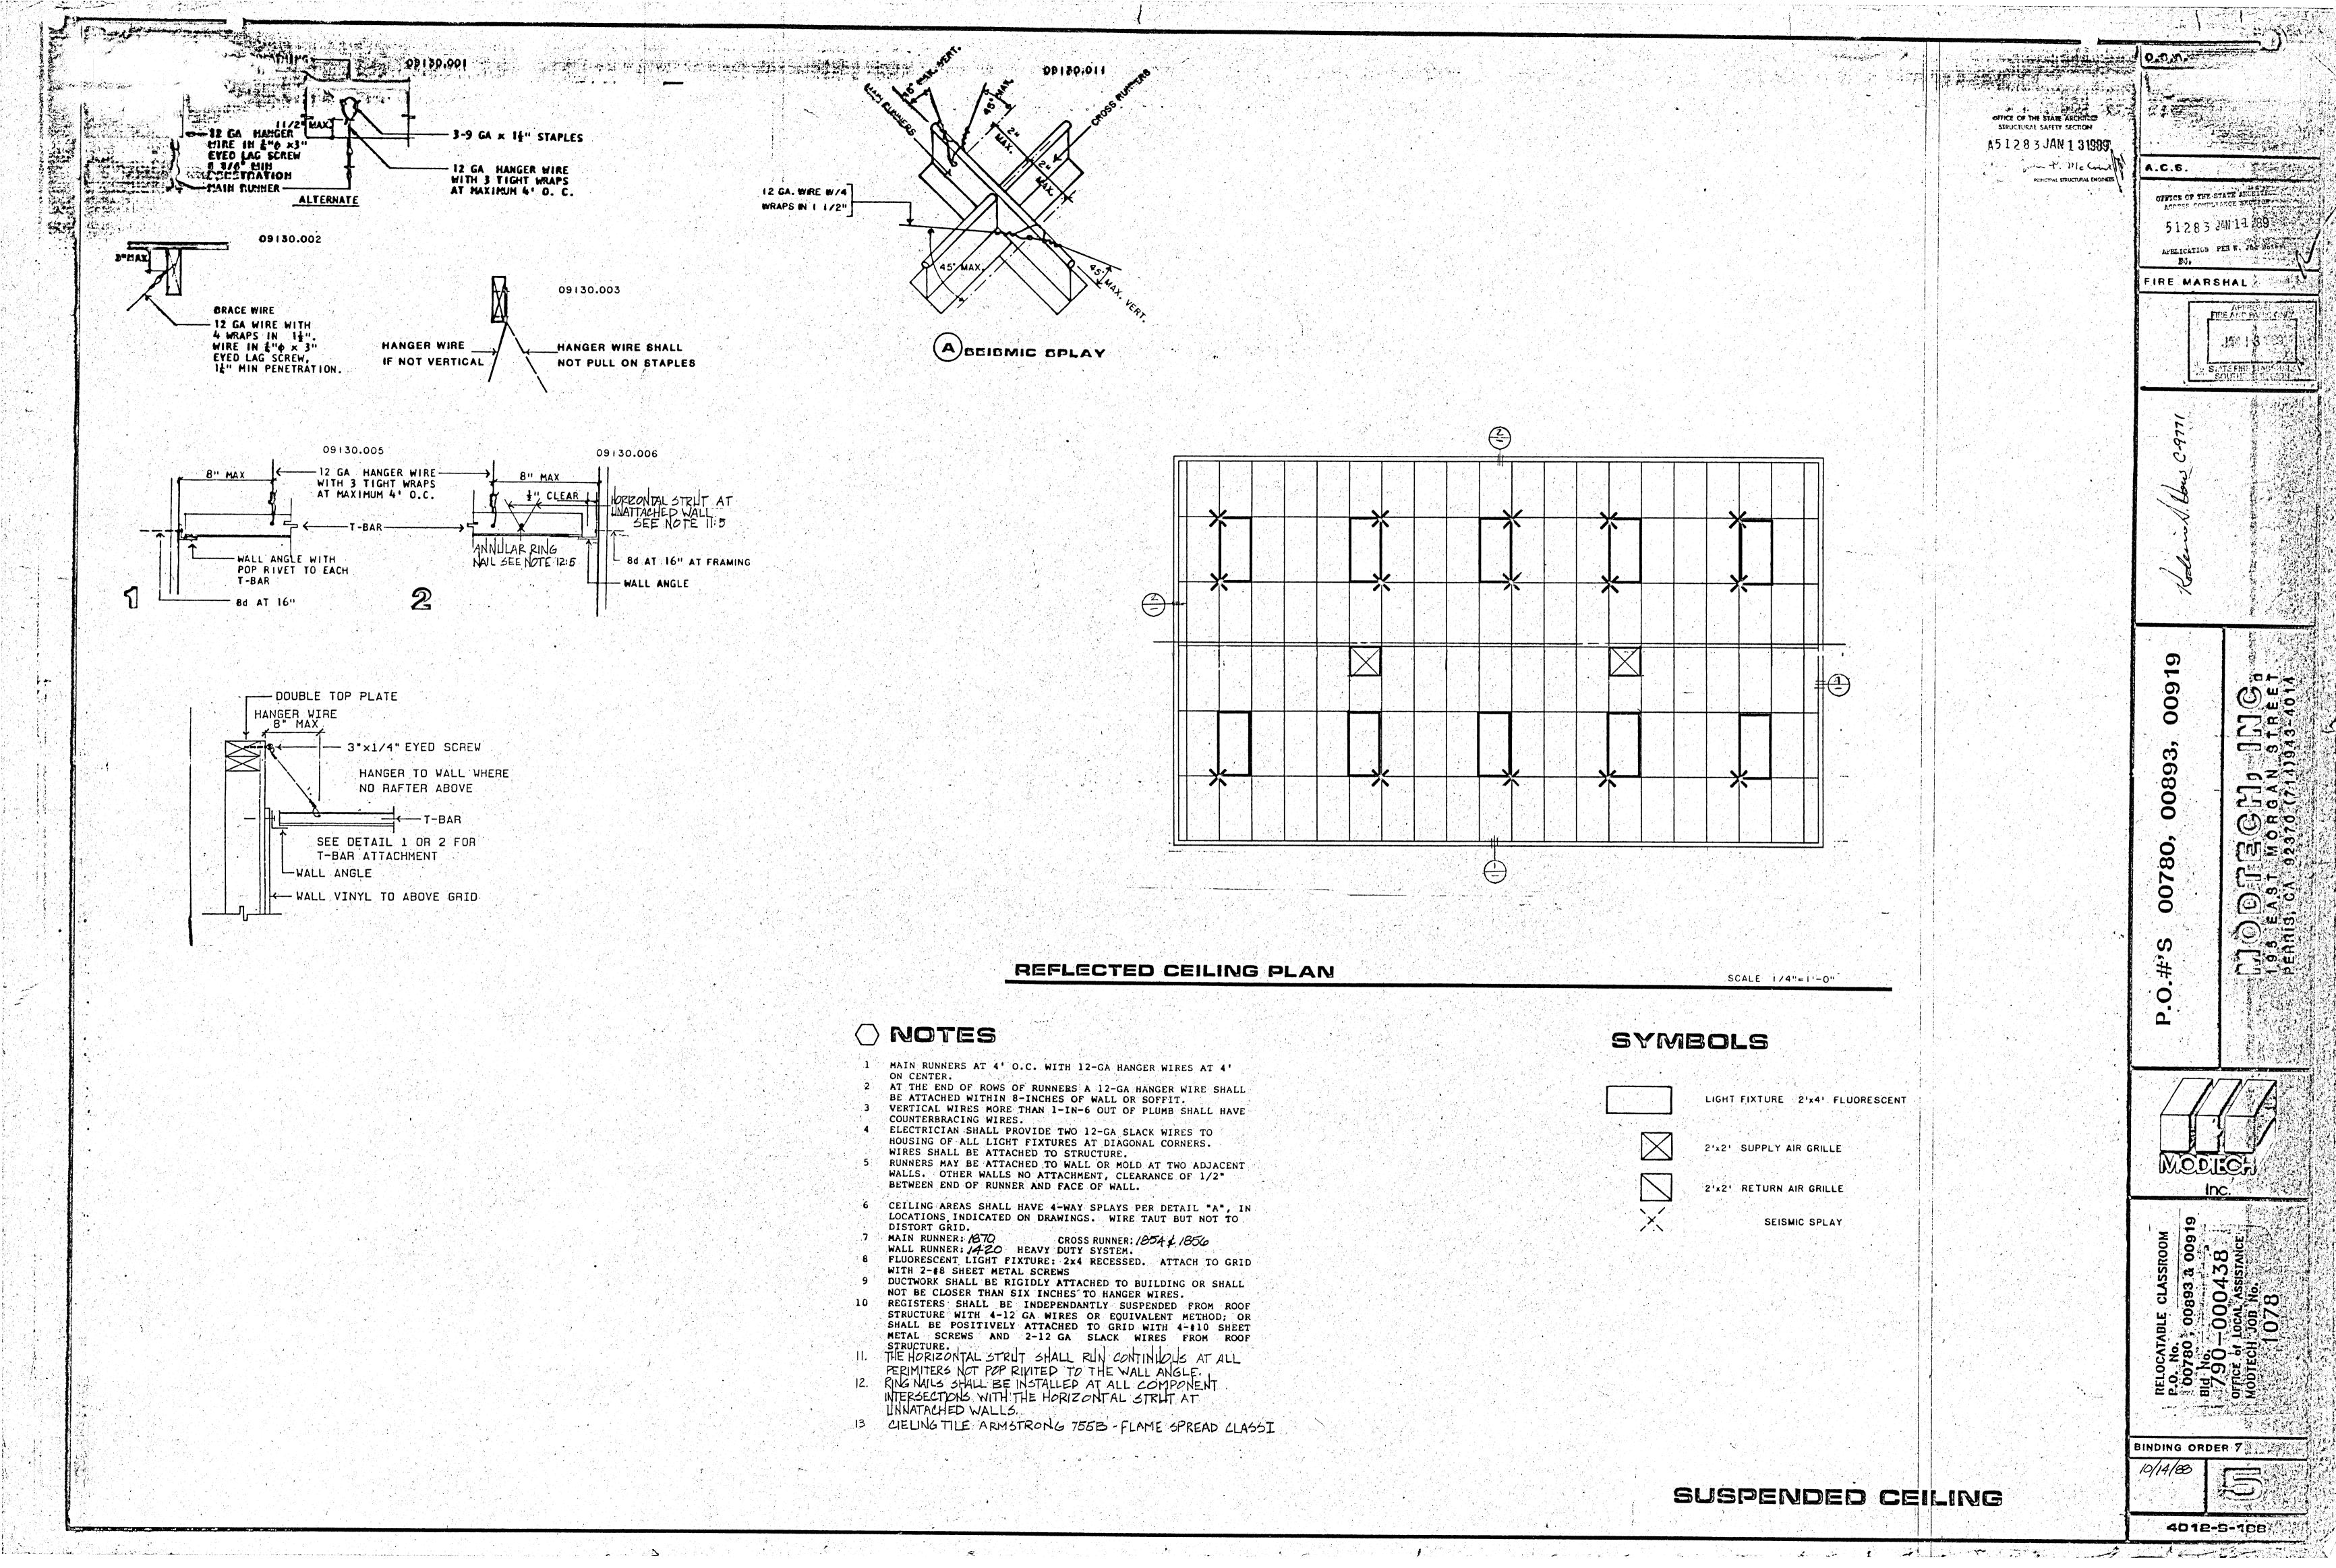

GENERAL REQUIREMENTS

A. PERFENAL.

- A. The requirements of the General Conditions of the egreement and this General Regulrements apply to the several trade sections with the same force as though fully repeated in each trade section.
- D. Time brands are indicated to establish a standard of quality. Items of equal or better quality may be substituted for the listed brand named products only with written approval of the Office of Procurement, Office of Local Assistance and the Agency Architect.
- C. All work shall comply with the requirements of Titles 19, 21 and 24. No changes shall be made from 0.5.A. approved drawings or specifications without prior written approval of O.S.A., the Agency Architect and the Office of Local Assis-

2. SCOPE OF WORK.

- A. The work consists of manufacturing off-site in a plant, and installing on-site, modular relocatable buildings as defined herein and shown and detailed on drawings.
- B. All requirements of Titles 19, 21 and 24 of the State of California Administrative Code relating to inspections and verified reports shall be complied with and shall include:
- 1. General responsibile charge of Field Administration by the Architect of Record.
- 2. Inspection in-plant during the course of construction by an inspector approved by the Office of the State Architect and the Architect. The inspector shall be responsible for and approved to inspect the general construction, welding, mechanical and electrical work. Cost of these inspections shall be borne by the Office of Local
- Assistance. On-site inspection of the building installation electrical and utility installation or connections by an inspector approved by the Office of the State Architect and the Architect and retained by the Office of Local
- 4. Other special tests or inspections as may be required by the Office of the State Architect.

3. WORK NOT INCLUDED.

- A. All on-site or off-site utilities and the connection of them to the building unless indicated on the drawings.
- B. All leveling, grading or other site preparation except concrete or wood leveling strips, where required, unless otherwise indicated on the drawings.
- C. Fire alarm system, fire extinguisher, program bell, clock, public address system, intercom system, TV system unless otherwise indicated on the drawings.
- . ACCESSIBILITY OF SITE. The School District shall provide access to the site for the installation of buildings. Removal of trees, shrubs, fencing, sprinklers, etc. necessary for the move-in of buildings shall be the responsibility of the School District.

5. GENERAL CONSTRUCTION.

- Structural Frame. Each module shall be designed as a shear wall structure to withstand vertical and horizontal loads and comply with requirements of the Office of the State Architect. The necessary provisions shall be incorporated in the structure to permit the relocation of the structural frame in sections not exceeding 12-feet in width.
- Floor. The floor shall be steel framed with a design live oad of 50-1bs. per square foot. Ramp and landing floor load shall be 100-1bs. per square foot.
- Watertightness. Workmanship and materials shall be such that buildings will be weathertight and watertight.

SECTION 05120.1

STRUCTURAL STEEL

1. GENERAL.

The Contract Documents are fully a part of this Section.

2. SCOPE OF WORK.

Contractor shall provide all labor, materials and services required for structural and miscellaneous steel as specified and indicated on the drawings.

MATERIALS.

- A. Structural Steel Shapes. ASTM A-36, open hearth or electric-furnace only, all regular shapes as described in AISC Construction Manual, unless noted otherwise.
- B. Cold-Formed Light Gauge Steel. ASTH A-570, Grade C, minimum yield 33,000 PSI.
- C. Structural Pipe and Tubing. ASTM A-500 Grade B A-53 Type S Grade B.
- D. Bolt Materials. Bolts and nuts, American Standard Regular, as detailed in AISC Construction Manual, fabricated from structural quality steel, ASTM A-307.
- Arc-Welding Electrodes. Class E-70 Series for Welding A-36 steel to A-36 and E-60 Series for welding A-570 steel to A-36, conforming to requirements of the "Structural Welding Code of American Welding Society, latest edition.

4. NORKMANSHIP.

- A. General. All work shall conform to requirements of AISC pundard Specifications, Title 21 and 24 of the California Administrative Code and the American from and Steel Institute Cocifications for Design of Light Gauge Steel Structural
- Welding. All welding done by shielded electric-arc or flux cored-arc process complying with requirements of the "Structural Welding Code" of the American Welding Society. Welding done by operators qualified by tests acceptable to the Office of the State Architect.

Erection. Structural steel erected true, straight, plumb and

- to its designated location. Field connections bolted or welded as indicated on the drawings. D. Bolts, Muts, Screws, etc. All exterior work shall be cadmium
- plated or galvanized.
- Handrails. Fabricated as detailed, welds ground smooth.

C 12x20.7; C 7x9.8, Z 7x11-GA.

- All steel coated with one shop coat of red oxide primer, 2: All surfaces thoroughly cleaned by effective means prior to application of shop coat,
- 1. Provide mill certificates or test the following members per T24 Sec. 2-2727(a):
- 2. Welds shall be inspected and/or tested per T24 Sec. 2-2727(e).

SECTION 06100.

1. SCOPE OF WORK. Contractor shall provide all labor, materials and services to install carpentry.

CARPENTRY

2. MATERIALS.

Lumber grade marked in accordance with "Standard Grading and Dressing Rules No. 16" of West Coast Lumber, Inspection Bureau, or "Grading Rules for Western Lumber, 3rd Edition" of Western Wood Products Association. Plywood grade marked in accordance with *Product Standard PS 1-83 for Softwood Plywood" of American Plywood Association, complying with U.B.C. Standard 25-9.

- All framing lumber marked MC-15 or surfaced dry (S-DRY).
- A. Rafters: Douglas Fir/Larch No. 2 or better, S4s. Headers: Douglas Fir/Larch No. 2 or better, S4s.
- C. Plates: Douglas Fir/Larch No. 2 or better.
- D. Blocking: Douglas Fir/Larch No. 3 or better, or Hem-Fir No.3
- E. Foundation Lumber: Lumber in contact with concrete, asphaltic concrete or earth, Douglas Fir with AWPB stamp LP-22. Lumber for above grade use, Douglas Fir with AWPB stamp LP-2. Treat cut ends and drillholes with "ZERPEL" copper #8-quinolinolate" Shims shall be minimum of 1/4" thick & size of blocks, Foundation Grade Redwood or Pressure Treated Exterior Grade
- F. Plywood Roof Sheathing: A.P.A., 1/2"-Thick, C-D Grade, Exposure 1. PS 1-83. G. Plywood Floor Sheathing: A.P.A., 2-4-1, 1.1/8"-Thick, T & G,
- Exposure 1. PS 1-83. H. Plywood Siding-Sheathing and Skirting: A.P.A., V-308, 5/8", 303MDOX 8" exterior. PS 1-83. Nomah-Ply Brand-Tex PS 1-83. (PLAIN UNGROOVED MAY BE USED) FOR SKIRTING
- Moisture Bertier: Araft waterproof building paper, Cle.C. standard 17-1. Fascia: 2x Resawn D Select D.F. or H.F.
- Window Trim: 1x4 Resawn D Select D.F. or H.F. Exterior Fasteners: Nails, Electro-Galvanized, complying with U.B.C. Standard 25-1717 (1985). Other fasteners galvanized or cadmium plated.
- M. Studs and Cripples: Douglas Fir/Larch No. 2 or better. Soffits: 3/8"-thick, MDO OR NOMAH-PLY

. WORKMANSHIP

- A. Framing securely nailed, bridged and blocked to form rigid structure. Work cut, fitted and assembled level, plumb and true-to-line. Trim in as long lengths as possible with all standing trim in one piece.
- Nailing in accordance with Title 24, California Administrative Code: TABLE NO. 2-25-P Machine Applied Nailing shall have prior demonstration and approval by OSA field representative and the Architect. Plywood shall have a minimum thickness of 3/8" and hailing shall be done with plywood in a horizontal position. Nailing that fractures plywood surface or MDO face is not acceptable.
- C. Moisture barrier applied to study weather-board fashion, horizontal joints lapped minimum of 2", vertical joints lapped minimum of 6". Plywood siding applied over moisture barrier.

METAL ROOFING

SECTION 07410

1. SCOPE OF WORK. Contractor shall provide all labor, materials and services to install metal roofing. United States Testing Company Test Report LA 72140, CLASS B.

, MATERIALS.

- A. Roofing. 2-inch standing seam 26-gauge galvanized interlocking sheet steel panels 24" wide.
- B. Base Sheet. Fiberglass 25-30 pound asphalt coated. C. Edge Flashing. 26-gauge galvanized steel.

WORKMANSHIP.

edge-flashing.

BASE SHEET: Apply to roof deck shingle fashion with 2-inch overlap seams. Staple to deck at 12" o.c. around perimeter and at 12" o.c. through overlap seams.

INSTALL 26-gauge edge flashing around perimeter and 26-gauge ridge angles to plywood deck with \$10x3/4" galvanized sheet metal screws at 12" o.c.

STARTER PANEL one piece full length from ridge to eave, attached with 3" long by 26-gauge galvanized steel hold-down clips at 3feet maximum on center. Clips attached to roof deck with #10x3/4" galvanized sheet metal screws. Butt panel tightly to ridge angle and set all joints in sealant.

CONTINUE with additional panels using hold-down clips along each seam and crimping panel edges over previous panel. At finish panel cut to fit and crimp edge over edge flashing.

At bottom edge cut back rib 1-inch and tightly crimp edge over

INSTALL continuous ridge flashing cap in field. Final installation shall be completely watertight.

PLASHING AND THEET METAL BECTION 07600

- 1. SCOPE OF FORK Contractor shall provide all labor, materials and pervices to install indicated cheet metal.
- A. Sheet Metal. Steel sheets hot dip galvanized with 1.25 oz. per square foot sinc coating conforming to ASTM A123. Mini-
- mum 26 gauge unless othervise noted on the drawings. B. Solder. Of standard brand, Grade "A" of equal parts lead and tin ASTM B32.
- C. Flux. Zinc saturated muriatic acid.
- 3. WORKMANSHIP. Sheet metal accurately formed to dimensions and shapes detailed with true straight lines, corners and angles. Flashings installed in longest lengths possible. Exterior work formed, fabricated and installed so that it adequately provides for expansion and contraction in the completed work and finishes water and weather tight. Aluminum shall be separated from ferrous metal by polyethelene tape.

SEALANT/CAULKING SECTION 07920

- SCOPE OF WORK. Contractor shall provide all labor, materials and services to seal building.
- 2. MATERIALS. MAGIC SEAL elastomeric copolymer.
- WORKMANSHIP. Sealant applied to dry clean surfaces, wherever, indicated on drawings and as needed to make buildings watertight, in accordance with manufacturer's specifications.

SECTION 08100 HOLLOW METAL DOORS & FRAMES

1. SCOPE OF WORK. Contractor shall provide all labor, materials and services to install hollow metal doors and frames.

2. MATERIALS.

- A. Doors. Type L Full Flush, Manufactured by Steelcraft Manufacturing Company, 18-gauge, 1:3/4-in. thick.
- B. Frames. 16-gauge, cold rolled, 2-inch faces. Reinforced for all required hardware and include strike boxes.

WORKMANSHIP.

- All work fabricated in shop per CS242, to required profiles byforming and welding, with arises and edges straight, sharp fit, fabricated accorately with square corners, hairline joints and surfaces free from warp, wave, buckle or other defects. Install sound deadening material winside doors and 1/8 thick sound deadener inside frames. After fabrication, doors and frames cleaned thoroughly, all welds ground smooth and given prime
- Install frames with minimum of 3-anchors per jamb and adjustable

SECTION 08710 FINISH HARDWARE

1. SCOPE OF WORK. Contractor shall supply finish hardware as

SCHEDULE.

A. for each exterior door:

specified and as required.

~ ~ .
24
26
计一定数 的复数人

3. SPECIAL REQUIREMENTS.

- A. Exit doors shall be openable from the interior without key or any special knowledge or effort.
- B. Closer shall be set for a maximum opening pressure of 8:1/2 lbs. for exterior doors, 5 lbs. for interior doors.
- C. Master key to existing.

SECTION D9900.2 PAINTING

- 1. GENERAL. The Contract Documents are Cally o Port (7 1)10
- 2. SCOPE OF WORK. Contractor shall provide all lebor, caterials and services to paint building. All exposed surfaces of building and ramp shall be painted except eluminum window frames, thresholds and prefinished coors and frames.
- MATERIALS OR EQUAL.

VOL-PRO COO DY DENJAMIN FOORE VINYL LATEX FLAT

A STATE OF THE PARTY OF THE PAR

SO SERIES-409 FINE LINE PAINT CORP. INDUSTRIAL ENAMEL (Distributed by Benjamin Moore)

WORKMANSHIP.

- A. Exterior: Wood siding, trim and skirting apply one coat of primer and at least one finish coat. Prime coat shall be brushed on or sprayed and back brushed. Spray coating only of prime coat is not acceptable. Allow prime coat to dry according to manufacturer's recommendation. Prime and finish coats shall be compatible and manufactured by the same company, If necessary, in the opinion of the Inspector, an extra coat shall be applied. to all grooves so that the finish coat will have a uniform appearance.
- Interior trim: Trim not precoated shall be painted with two coats of semi-gloss latex over primer.
- Metal: All metal surfaces shall be painted with 2 coats f alkyd finish coat over shop primer,

SITE ASSEMBLY SECTION 13000

1. GENERAL. The Contract Documents are fully a part of this Section.

2. SCOPE OF WORK.

- Contractor shall provide all labor, materials and services to prepare the building elements, transport them from the plant to the site and to complete the assembly at the site.
- The condition of the site, such as drainage and soil bearing capacity, shall be the responsibility of the School District. Unless called for in the Contract, steps, ramps, walkways or handrails shall not be the responsibility of the contractor.

ASSEMBLY OF ELEMENTS.

- A. In a location on the site as determined by the School District, the contractor shall place concrete leveling strips or other suitable supports as detailed on the drawings.
- B. The elements shall be brought to the site on wheel assembly and transferred to the prepared site. Great care shall be taken to avoid damage to the elements by racking or bumping each other.
- C. Connection of the elements together shall be done according to instruction on the drawings. Flashings, trim and other loose items shall be installed.

SECTION 15000 AIR CONDITIONING

- 1. GENERAL. The Contract Documents are fully a part of this Section.
- 2. SCUPE OF WORK. Contractor shall provide all labor, materials and services to install the air conditioning system as shown on the drawings and specified including A.C. units and accessories, remote thermostat, grilles and power wiring complete to load center. Contractor shall instruct owner's operators on operation and maintenance of A.C. system. Manufacturer's literature, instructions and quarantees shall be delivered to school office.
- 3. EQUIPMENT. Air Conditioning units as noted on drawings.
- 4. WORKMANSHIP. Units shall be installed complete and operating with all accessories in accordance with the manufacturer's instructions.

ELECTRICAL SECTION 16000

- 1. GENERAL. The Contract Documents are fully a part of this Section.
- 2. SCOPE OF WORK. Contractor shall provide all labor, materials and services for electrical installation complete with associated equipment and fixtures, in operating conditions ready for use. The work includes: light and power systems, lighting fixtures complete with lamps; connections and disconnects to A.C. equip-
- MATERIALS AND EQUIPMENT. All new complying with requirements of National Electric Code and National Fire Protection Association.
- A. Electric Metallic Tubing, couplings and flex conduit galvan-
- zed or sherardized. B. Pahelboards: Flush mounted with hinged lockable doors and indexed card holders. Locks furnished by School District.
- Conductors: Copper, insulated for 600 volts, type TW for sizes \$12 to \$6, type THW for larger sizes.
- Receptacles: HOSPITAL GRADE Clock Receptacle: Eagle or equal:
- Switches: HEAVY DUTY. Lighting Fixtures: As noted on drawings.
- 4. WORKMANSHIP. Materials and equipment installed in a secure, neat, workmanlike manner in accordance with Code requirements. Panelboard cards filled out. Conduit and cable installed in wall and ceiling spaces. Work piercing waterproofed areas, flashed and sealed to a watertight condition.


SUCCEPTAL SAFTY TO THE 151283 JAN 181800 _ + m (____

0.8.A.

- A.C. G. PENCHAL BRICHAL END
- OFFICE OF THE STATI AREALES Access concluded Eccion

APRICATION PER W. Jud Boses

FIRE MARSHAL

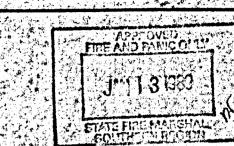


C - -಄ಀೄಁಽ (II)

KZ

1. TO ... $O \le z \infty$

BINDING ORDERD

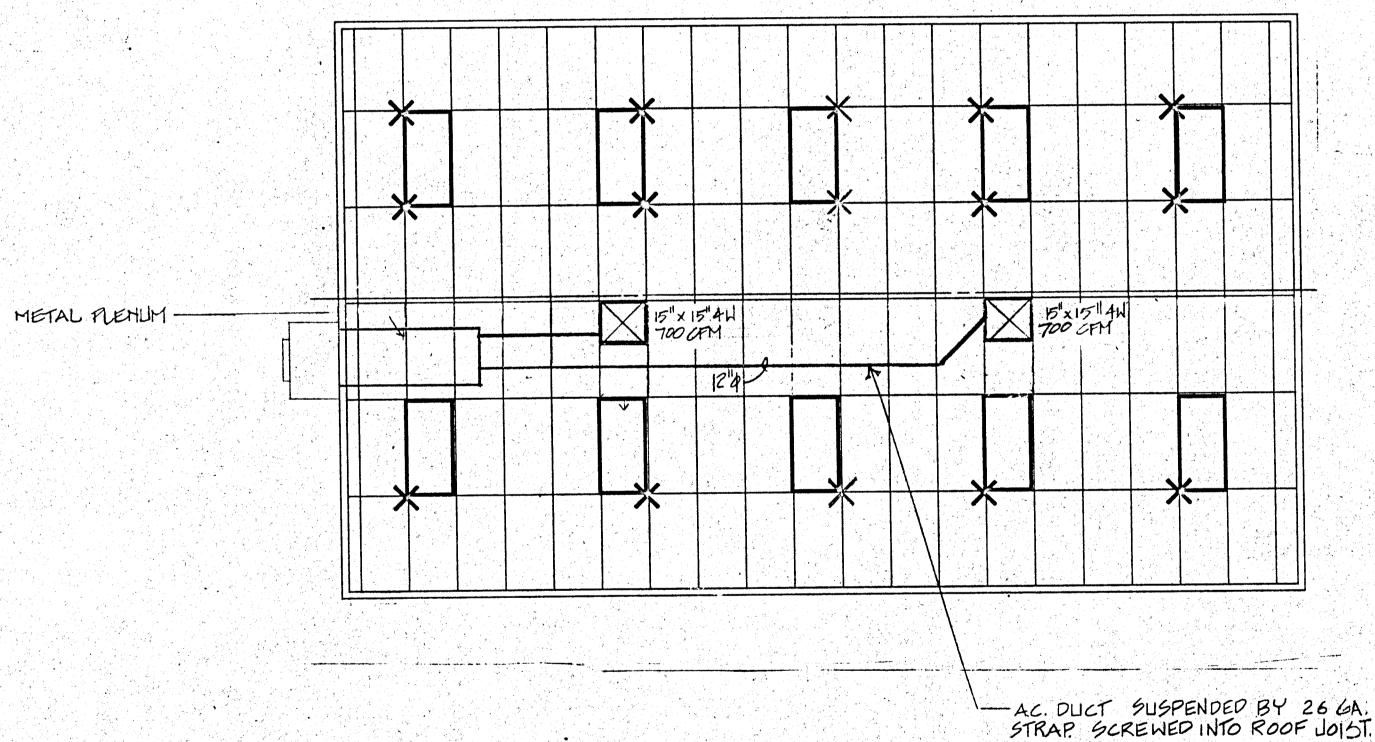

o notes

Heat Pump: Single package wall mounted air-to-air electric heat

Reference Brands: Bard 45 WH1-A08CD004

comparable and meet current energy standards.

that will meet the geographic requirements.

ductwork within 8'0' of HVAC unit.

2. Ductwork:

pump. Unit shall be rated in accordance with ARI Standard 240-77.

Harvair AVP 42 HPA-08S, or comparable

Intertherm PWY-042KAVX08

At elevations where the HVAC heat pump noted above is not adequate to meet the listed criteria, the contractor shall provide a HVAC heat pump

A. The system shall maintain an automatically controlled indoor classroom temperature of 78°F. in summer and 68°F. in

temperature varies between 100°F. in summer and 10°F. in winter and a wet bulb temperature of 720F. (average).

is adjusted to use approximately one-third fresh air.

A. Construct all ductwork of galvanized sheet metal in accordance with U.M.C., ASHRAE Guide Equipment Volume and SMACNA Low Velocity Duct Construction Hanual, latest editions. All ductwork shall be insulated with 1° thick fiberglass duct wrap

with vapor barrier. Provide 1 duct attenuation at all

B. Non-Metallic Ductwork Option: In accessible concealed portions

(1) (1) 1 vapor barrier may be substituted for sheet metal ductwork. All

"Owens-Corning Fiberglass" Duct Board, 1" thick, and "Manville" Micro-Aire, Type 475. Non-metallic ductwork shall conform to

connections shall be metal. Ductwork and reinforcement shall He has be designed for 2" static pressure. Reference Brands:

did y ductwork within 5% of the HVAC unit and all interface

3. Registers and Diffusers: Provide two (min.) 4-way throw air diffusers as manufactured by Carnes, Titus, Hart & Cooley, Barber-Coleman or Kruegar commercial grade grilles and registers.

4. Thermostat: Provide electronic programmable thermostat.

1. 5 and 2 weekday/weekend programming with 4 separate .. time/temperature settings per 24-hour period.

Thermostat shall have the following functions:

HEPA 90-A and 90-B and SMACNA Class I cating.

of duct system rigid 1 fiberglass or insulated "Flexduct" with

B. The system must maintain the above temperatures when the damper

winter with a 45% relative humidity when the outdoor dry bulb

All units shall be 230/208 volt, I phase system, UL approved or

OFFICE OF THE STATE ARCHITECT STRUCTURAL SAFETY SECTION

A51283 JAN 1 31983

51283 JAN 11 89 ERRICATION PER W. way butter

FIRE MARSHAL

E (0, 0)


00780, O


BINDING ORDER 9

AIR CONDITIONING PLAN


CONDITIONER JUMPER. CONTROL SCHEMATIC


2. Key board lockout switch. 3. Programmable display. 4. 2-hour override minimum. 5. Status indicated LEDs. 6. Battery back-up. Provide locking clear thermostat cover with access hole for program White Rodgers, 1792 is required.

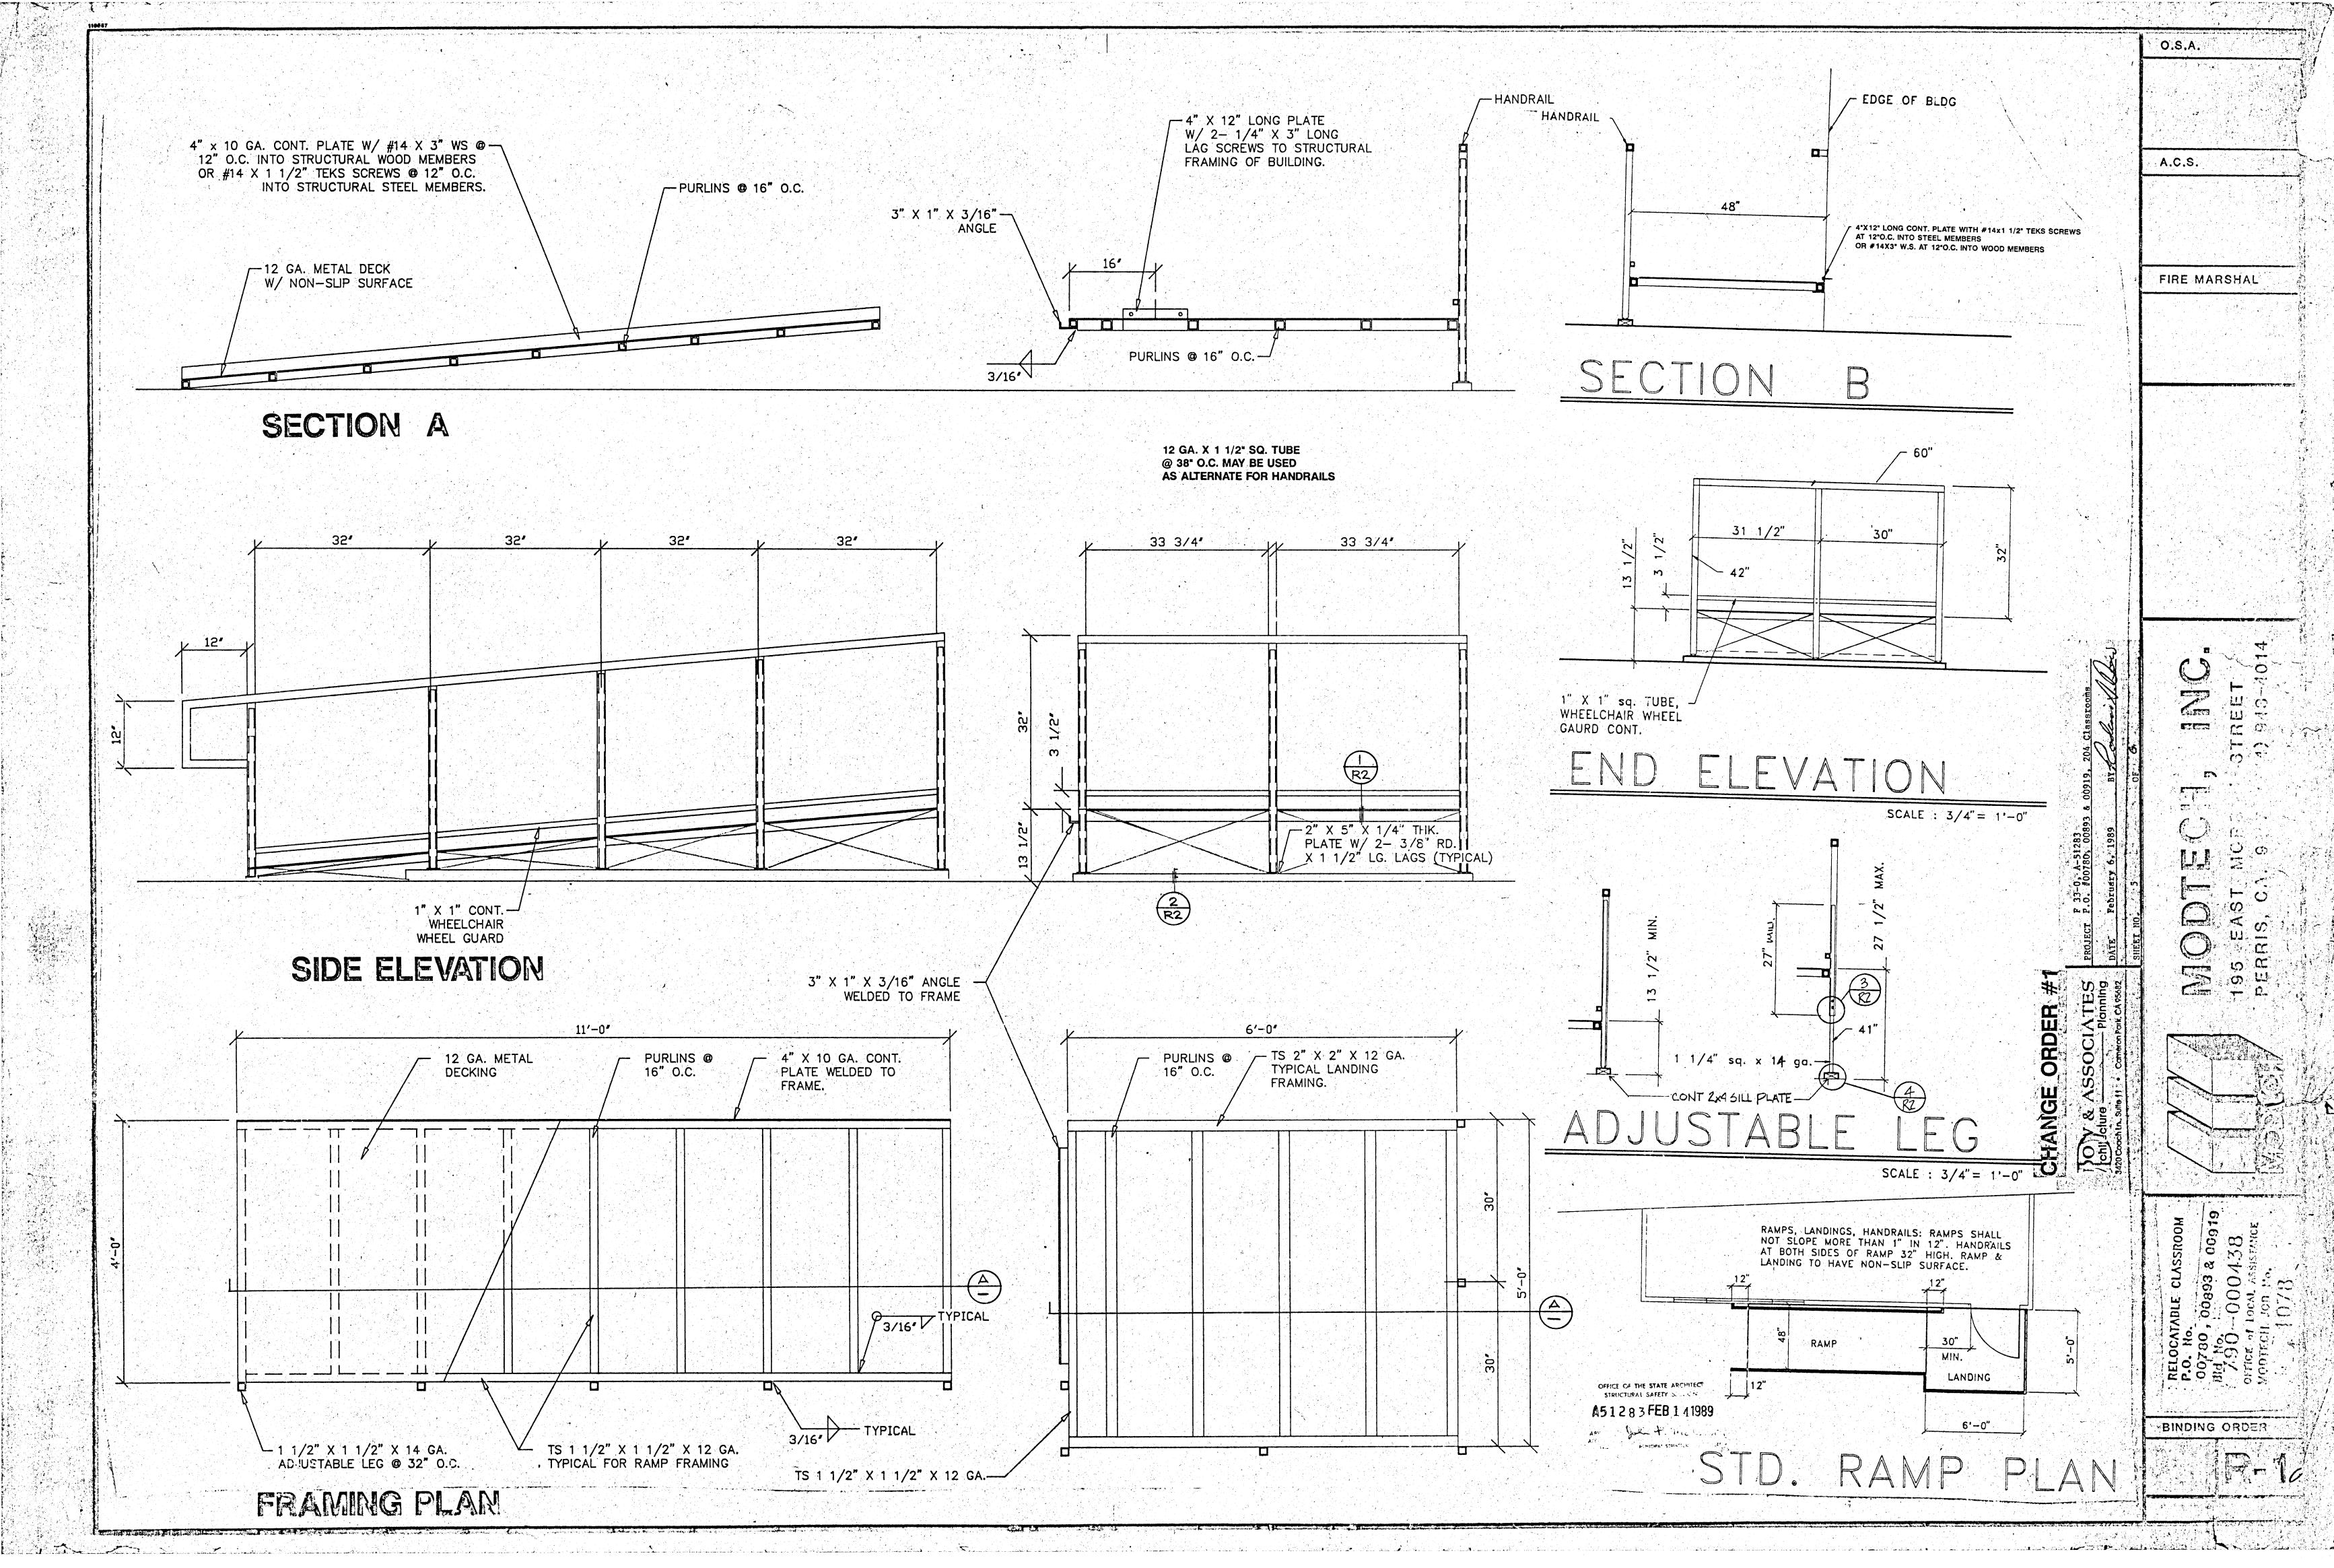

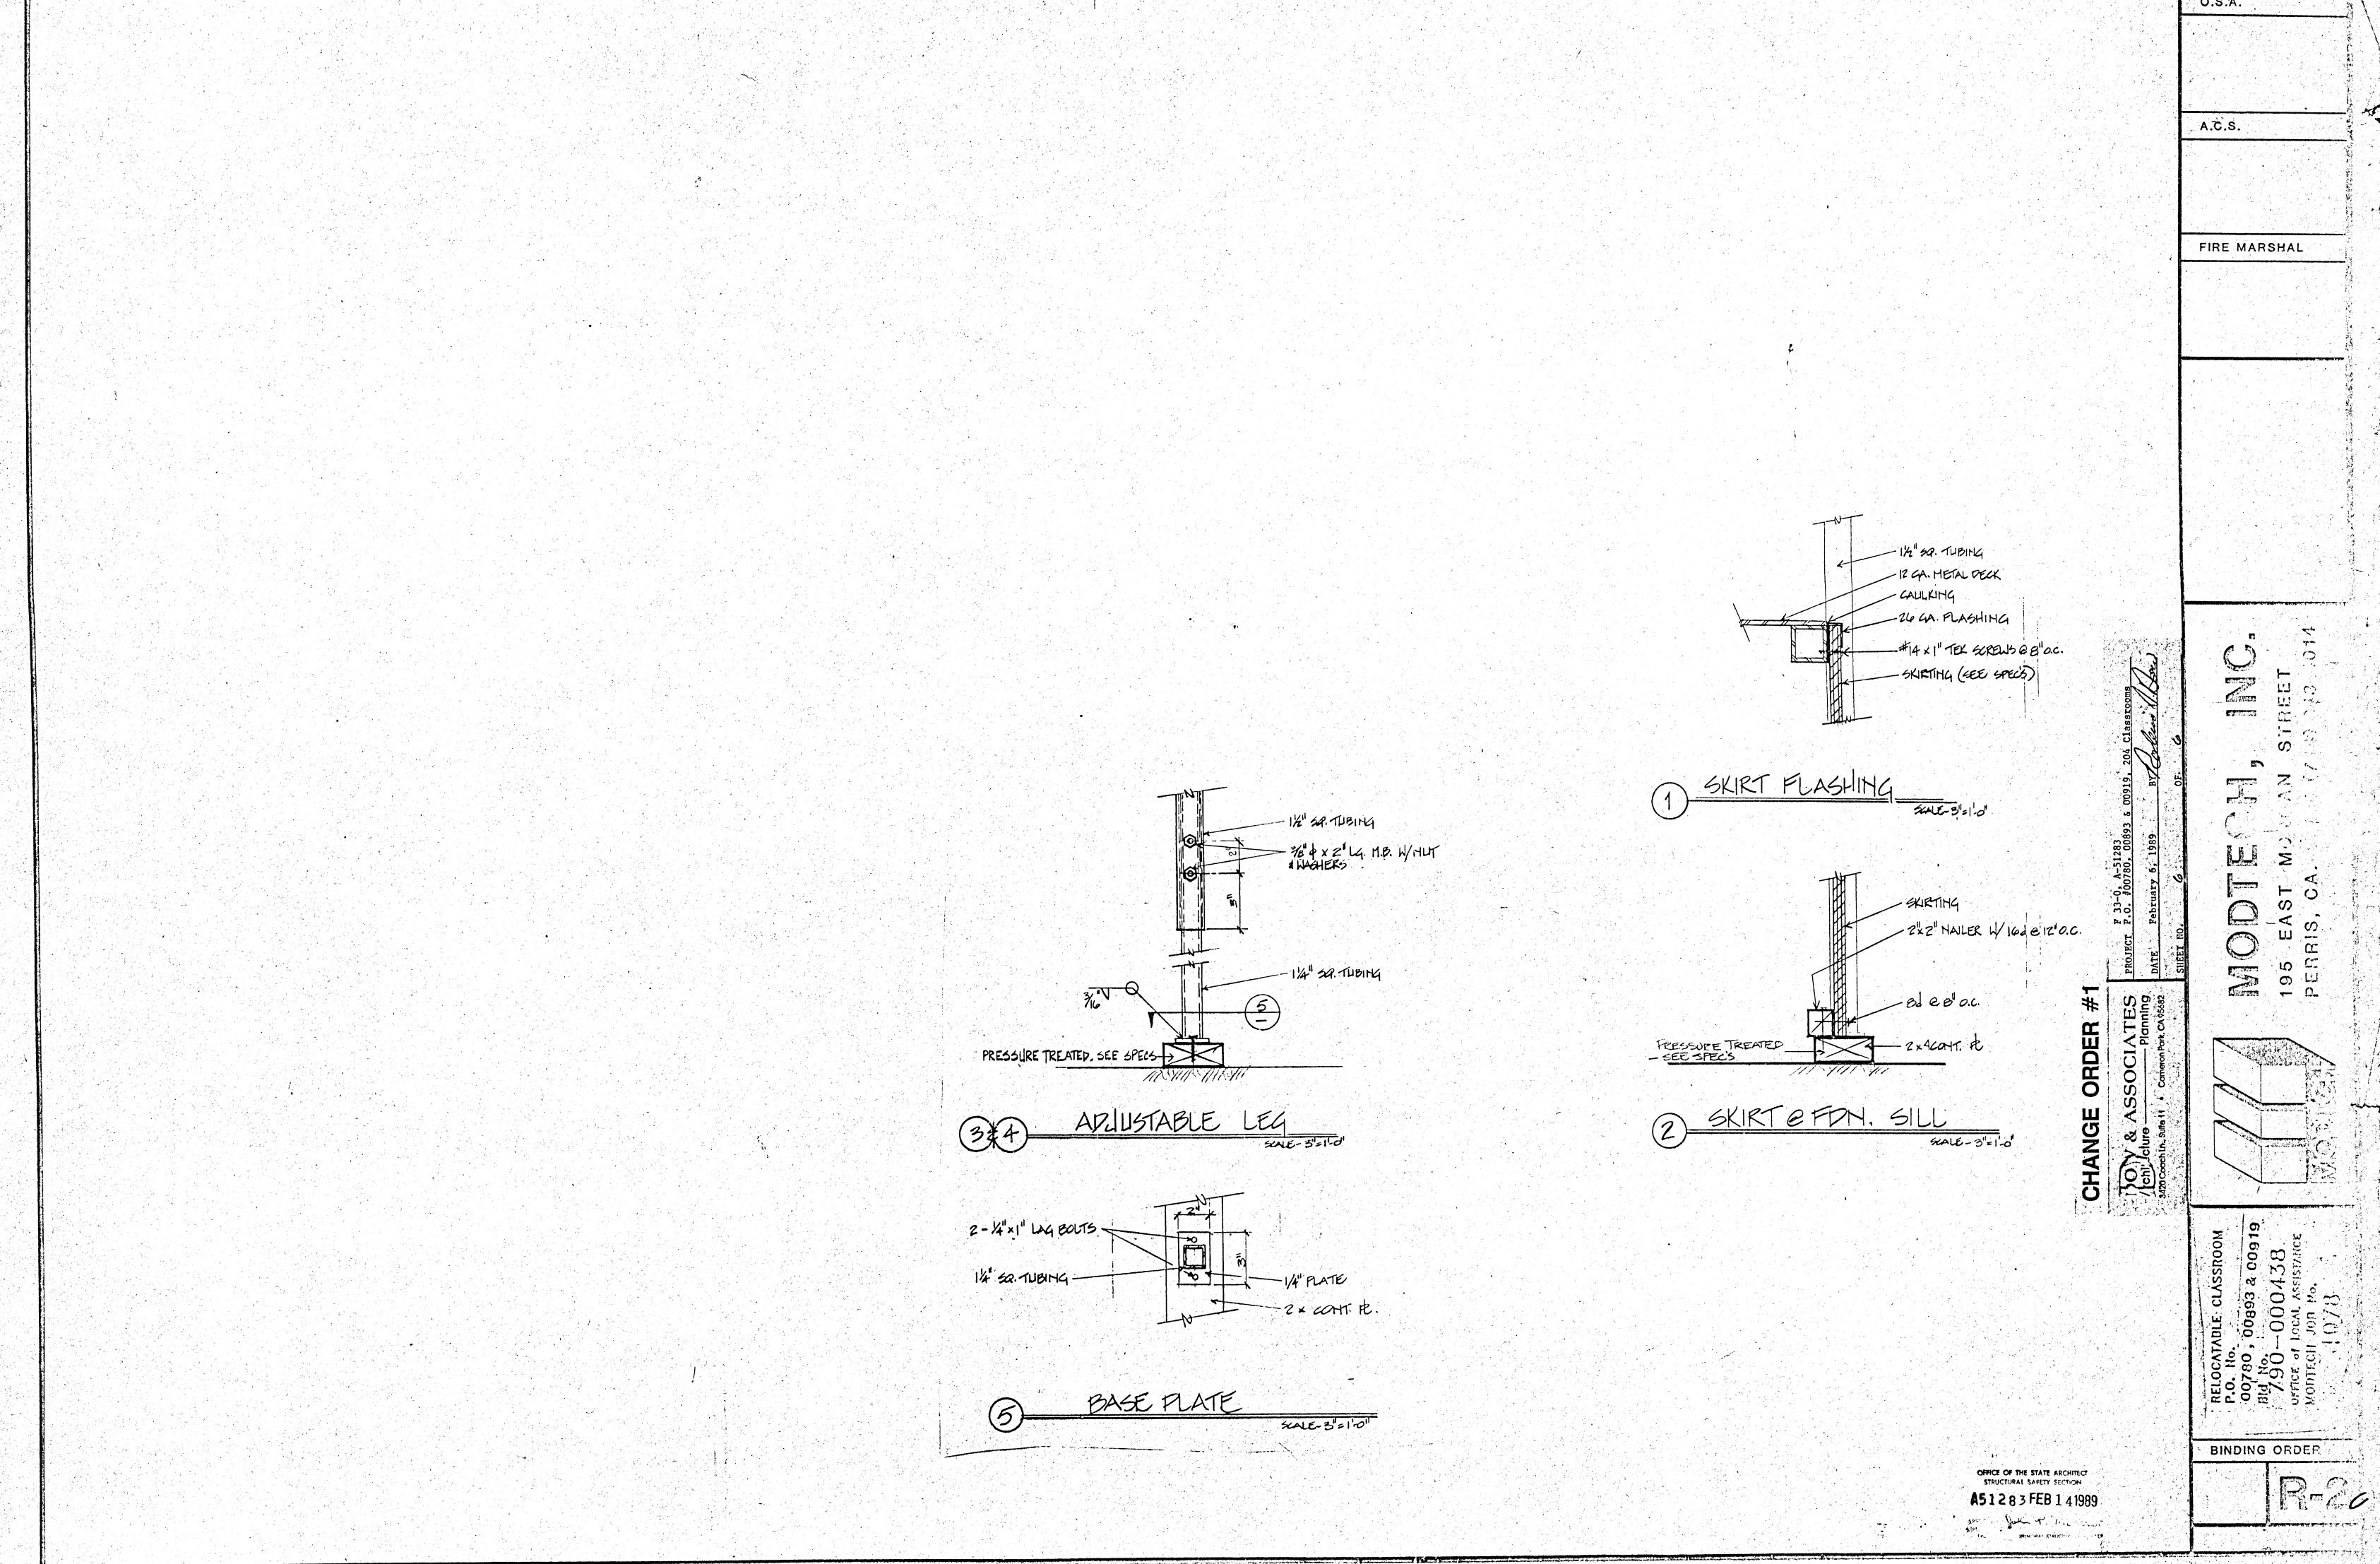

O.S.A.

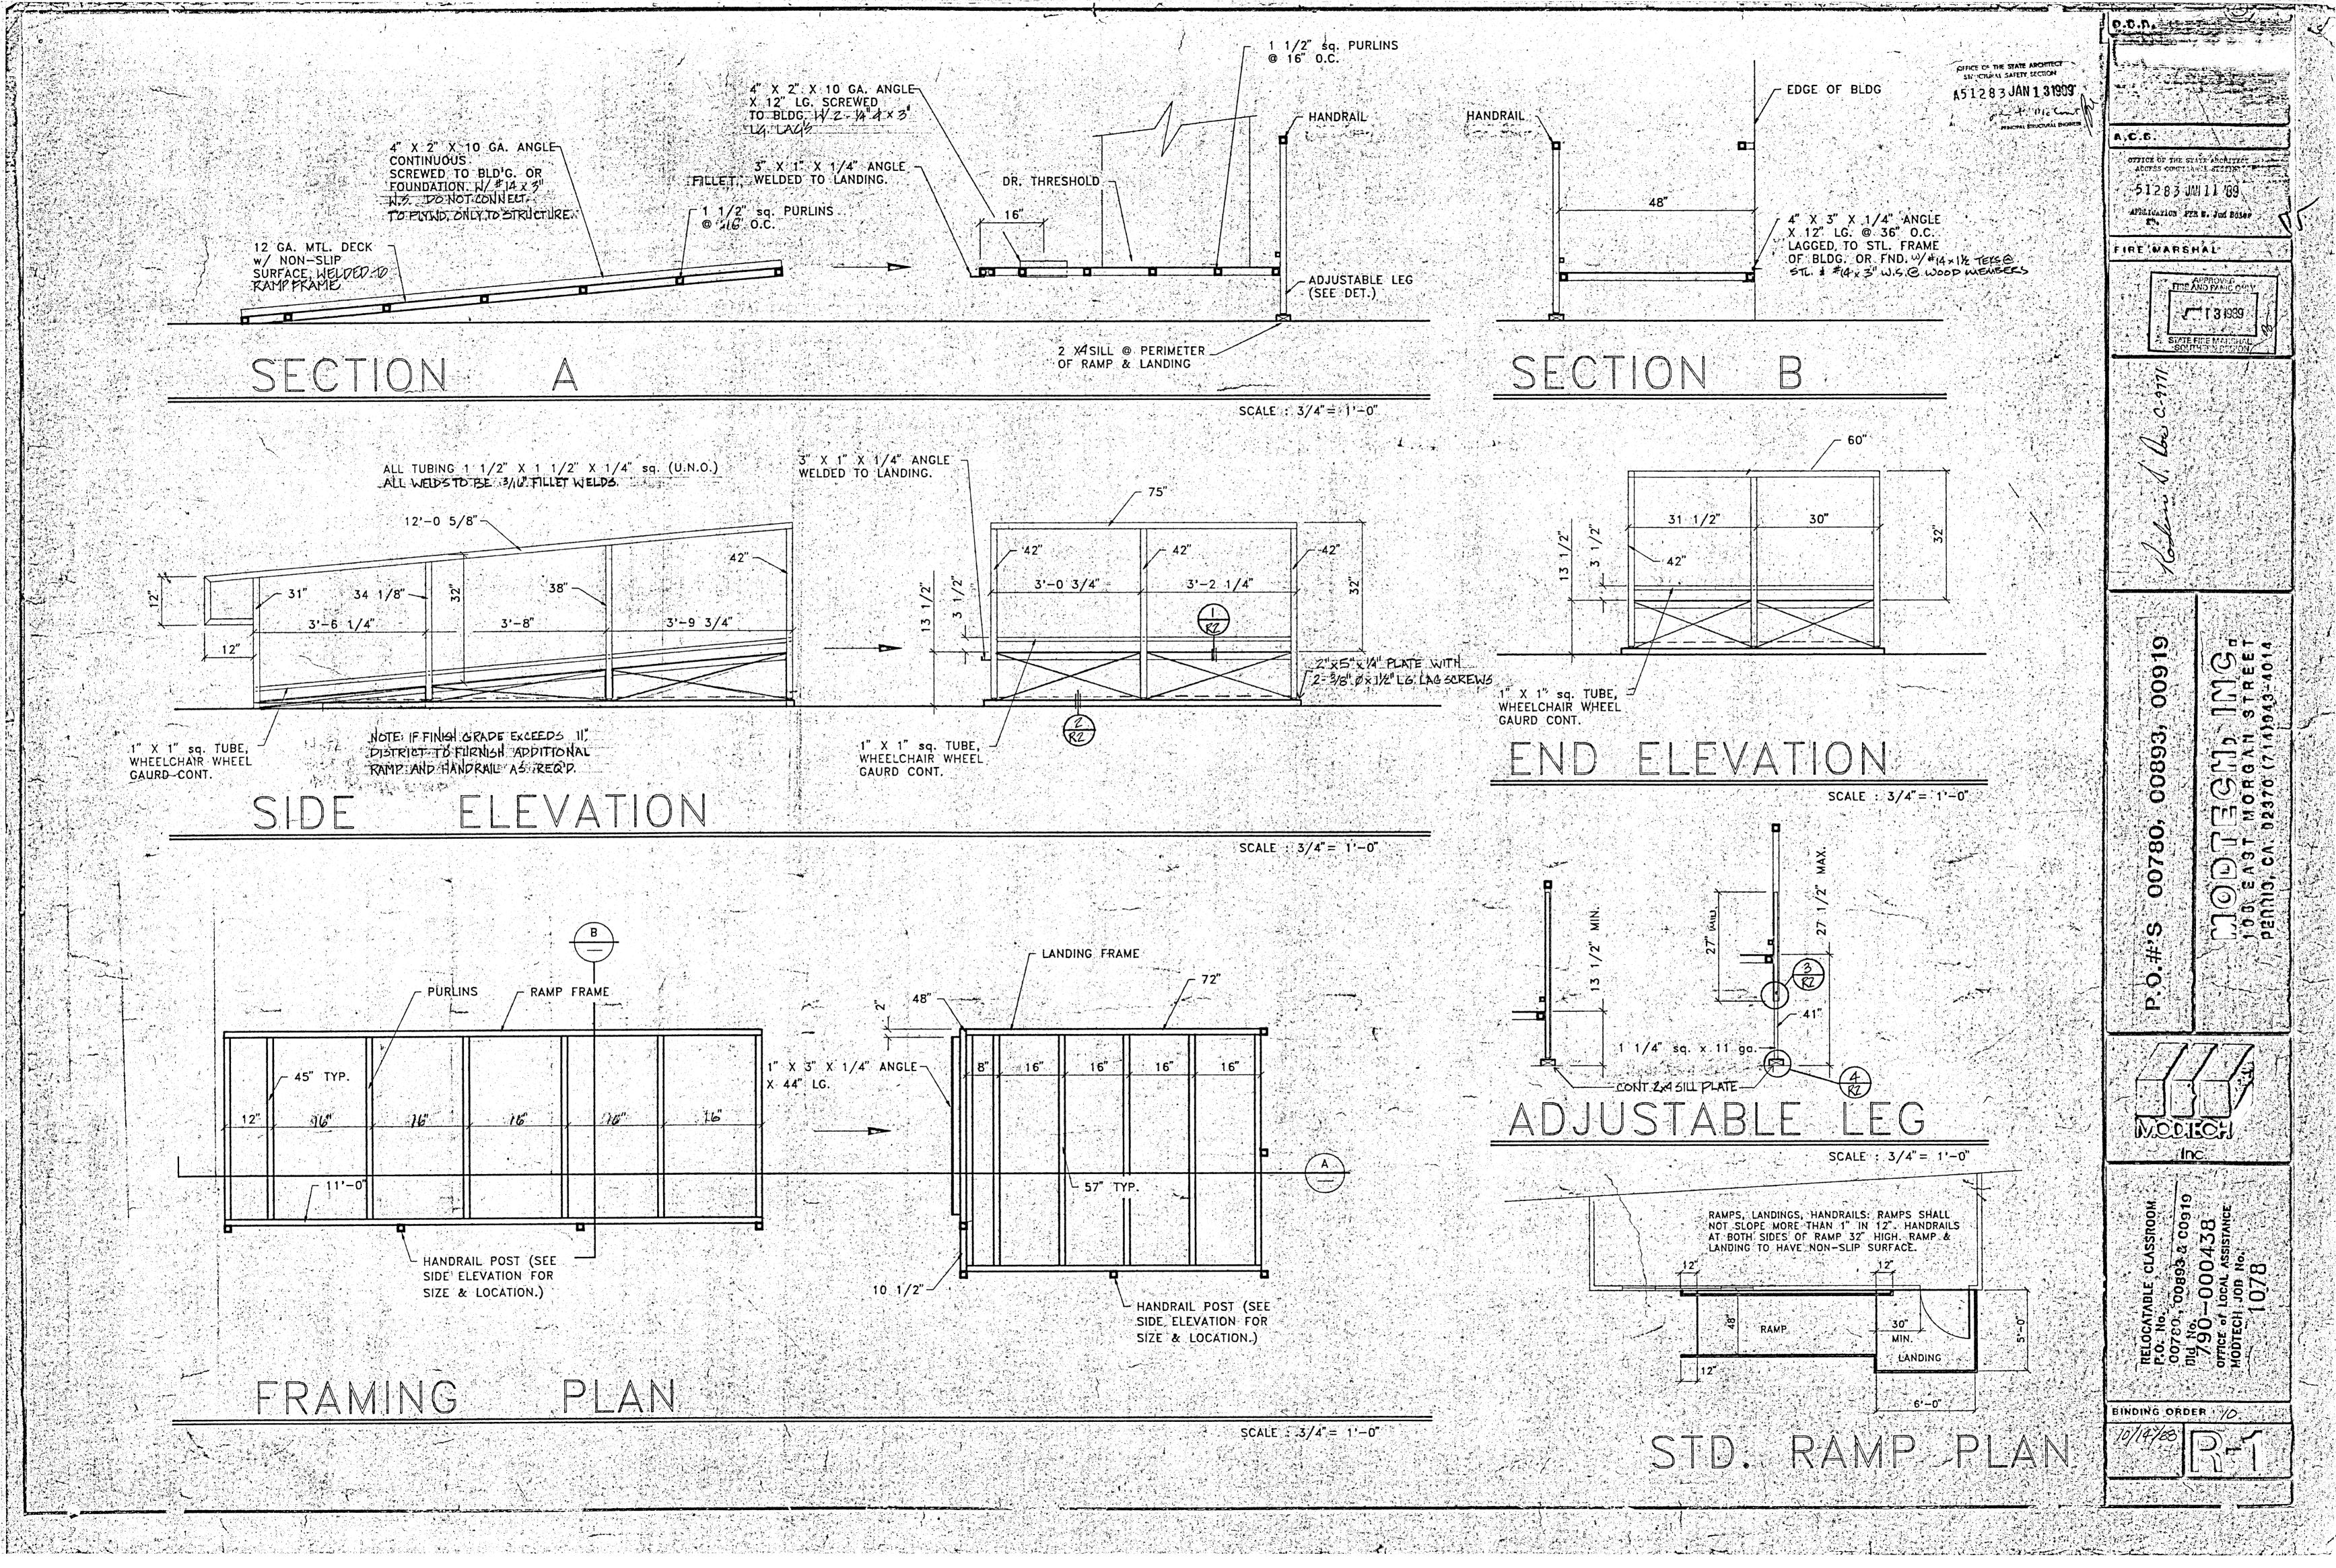

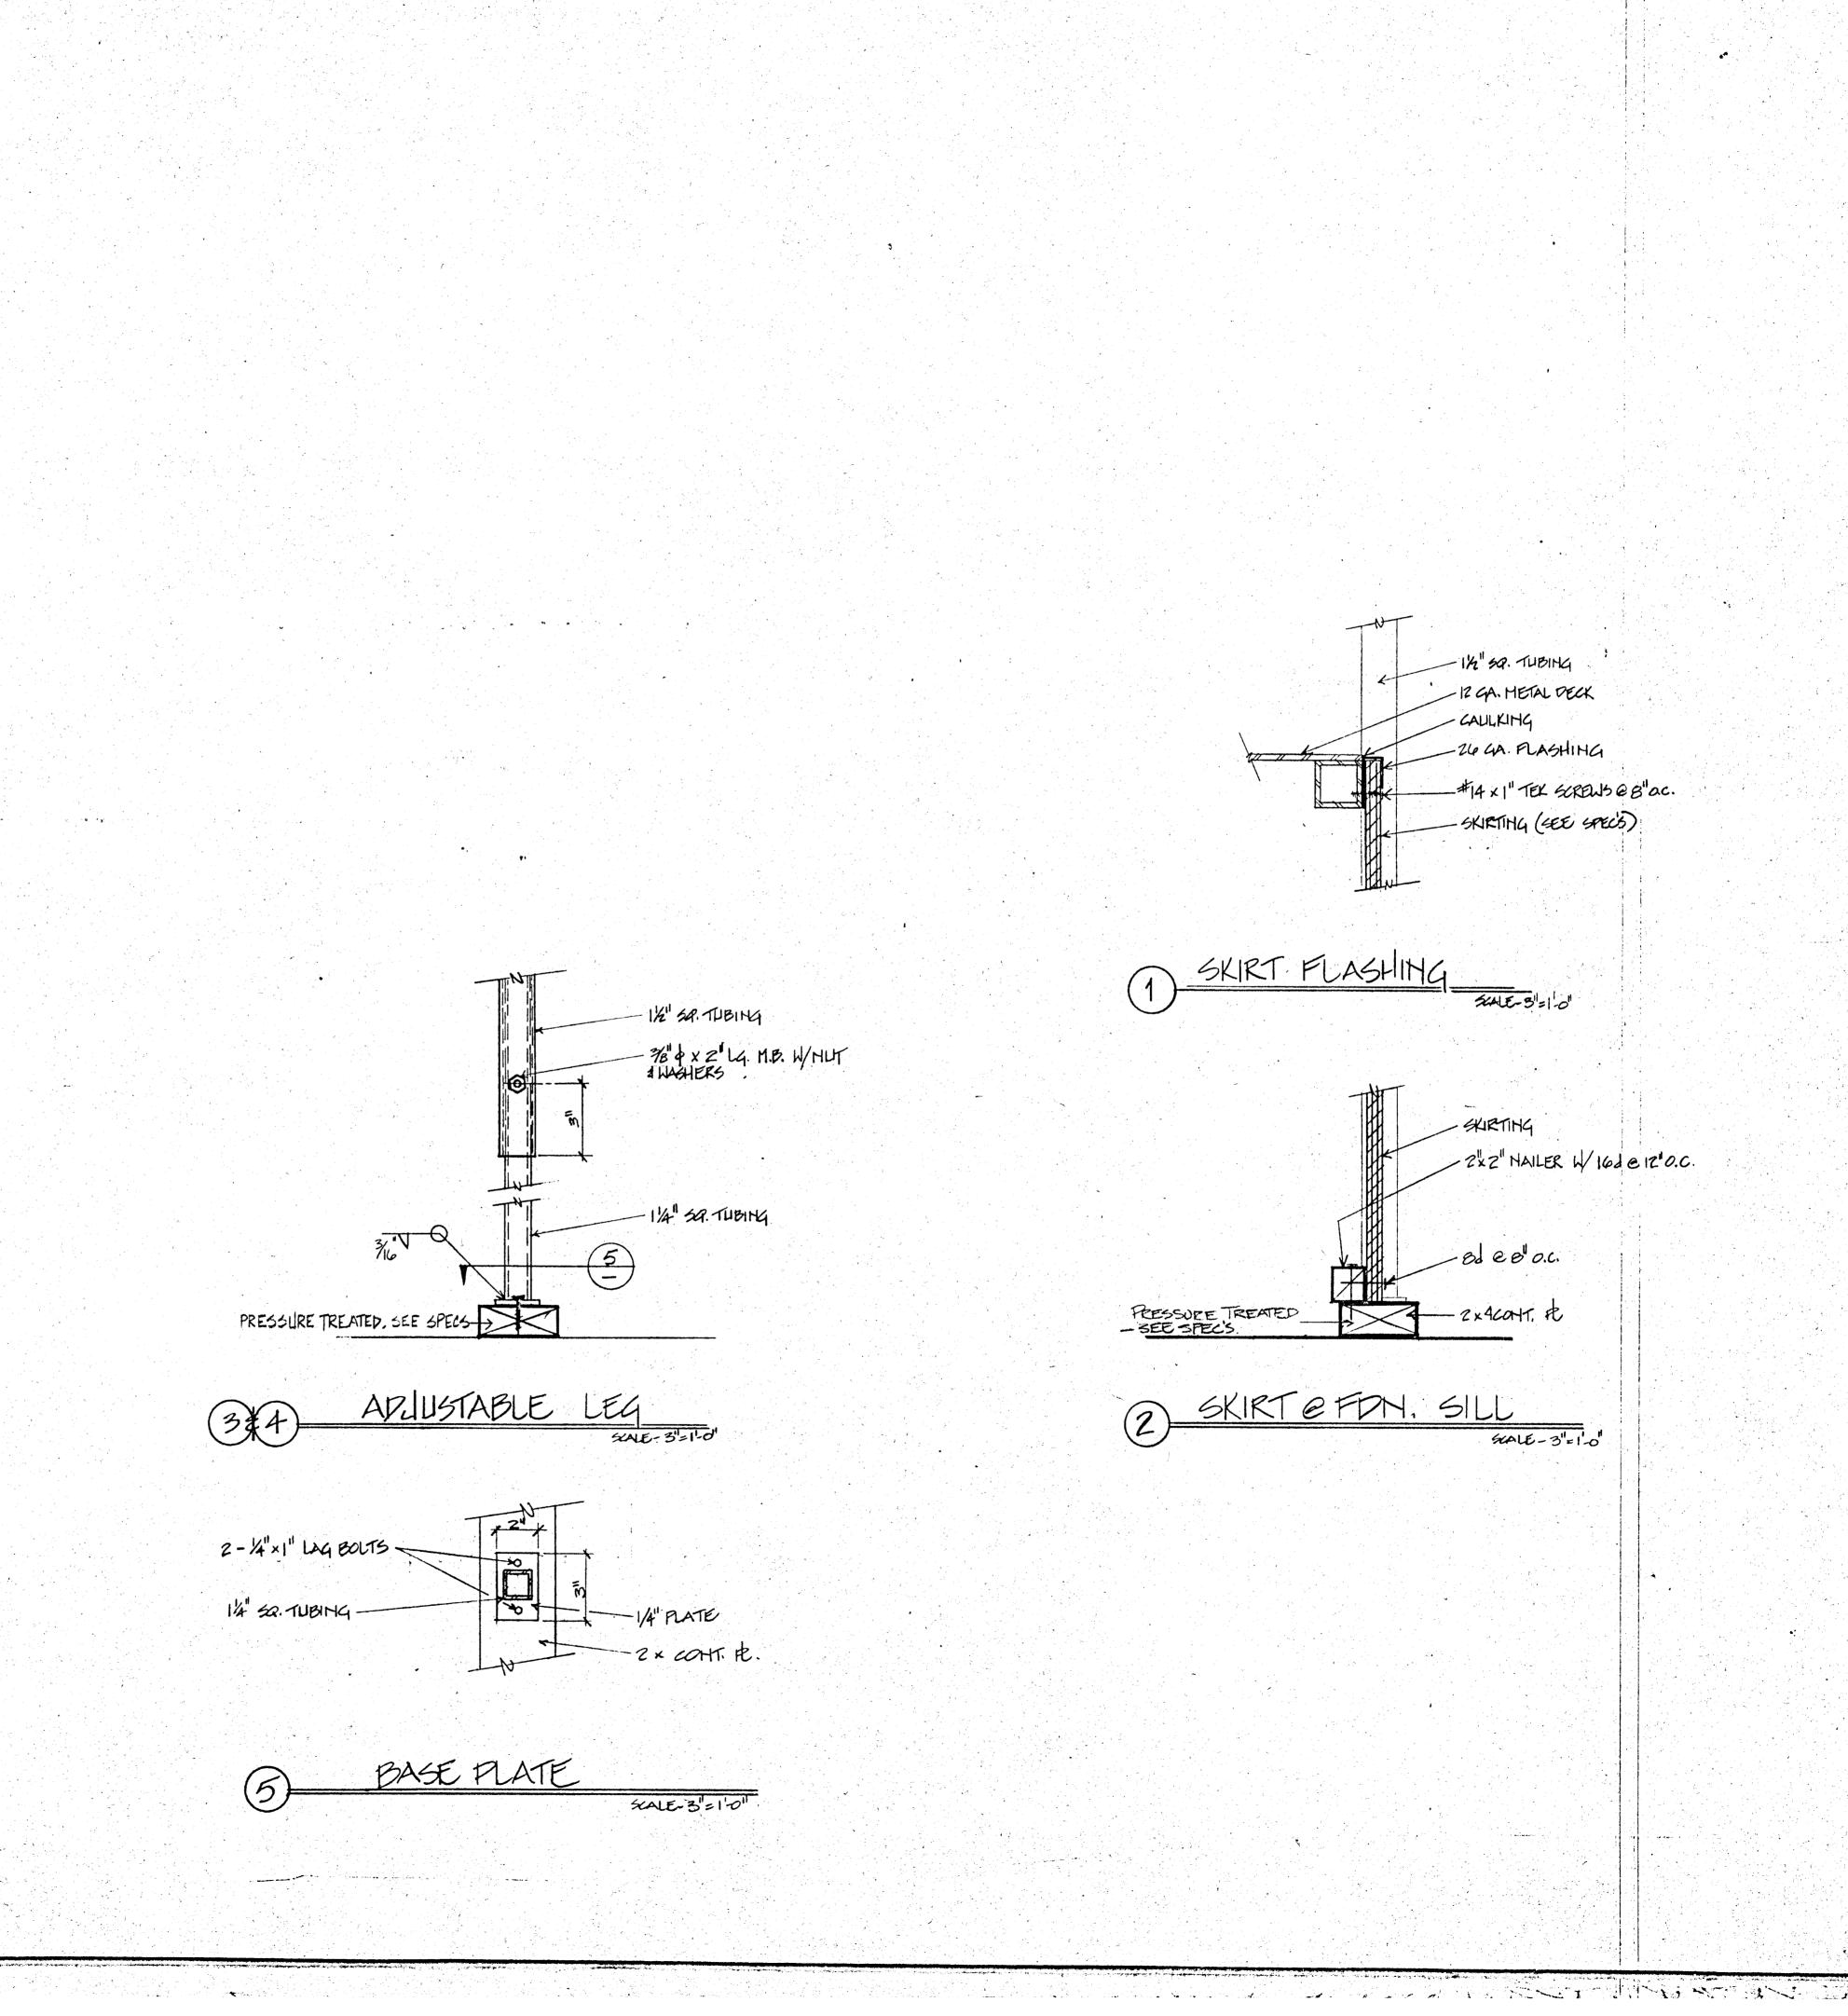

o profes

O.S.A. OFFICE OF THE STATE ARCHITECT 51283 JAN 11 89 APPLICATION PER W. Sur Holes FIRE MARSHAL FIRE AND WAR CITY PERRIS OF STANDARD AND A TREET 00893 00780, О. О. BINDING ORDER

RELOCATABLE BUILDING (S) FOR CAJON VALLEY USD

24' X 40'

SYMBOLS					
TYPE	SYMBOL	DESCRIPTION			
DETAIL	(1)	DETAIL ON SAME SHEET AS SYMBOL			
DETAIL .	2	DETAIL NUMBER (I) ON SHEET NUMBER (2)			
NOTE		NOTE NO I ON SAME SHEET AS SYMBOL			
NOTE	NOTE NO 4 ON SHEET NUMBER (5)				
WALL PANEL	A	WALL PANEL TYPE "A" ON SHEET (I)			
SECTION	A 2	SECTION "A" ON SHEET (2)			
REV		REVISION: CHANGE IN DWG NO (1) FIRST REVISION			
REV	ECLOUD 3	HIGHLIGHTS CHANGED AREA			
REF		DOOR REFERENCE			
REF	固	WINDOW REFERENCE			
REF	ST	SEE STRUC, DING			
REF	HV)	SEE MECH DWG			
REF	EL ,,	" SEE ELEC DWG			
REF.	PLG	SEE PLUM DING			

Single States	man sa durak sa kinakan da suni				
The Party of the P				-	
Silk Land Dalle make make a		7.	•		`
	n, zár aju a er rest de di	ers value alle sents dem	part to approve that		-
			,	٠.	-
est anscapan so bushasa so					
read exist commission seales	examinad b	y erro sart h	erio Leon I	ruind he e	nansi Bi
edectivate recoversate of	isto es, ce stynos,	WANTED	ow or man	MARCO 30	and e
The house district before and a time project for which I am the change for for which I has a t work.)	n becomen	halprand!	c by in th	narné fiéra	XX PART
a true became ered telli Liberarda ed et et egykkert	rrestad. Po	i dantajs	。 事 對外管	of an e	CONTO
45. \$ da	,	,	1 - 1		
Bust.	e de la companya de l	- Company and the	10/3	angle and the same) nor
			10/	- Special Contraction of	,
hymica is the Archivectics	na yeri sa sahinggadan mini na n	enter entre	10/1	A Company	enter s
Aug value of the Androecolog Augusta, tipe, establish		The contract of the contract o	10/1	onfinistions	and the second s
Agranta de la provinción de la company de la			10/3	on fraction of	A STATE OF THE STA

BUILDING DATA 24' × 40' BLDG'S				
OCCUPANCY	F-2 (=)			
TYPE OF CONSTRUCTION	V-N			
WIND LOAD	TO MPH EXP "C"			
FLOOR LIVE LOAD	50 PSP/			
ROOF LIVE LOAD	20 PSF. REDUCED FOR ARE			
BUILDING AREA	460 SOFT#			
STRUCTURAL DESIGN	RIGID FRAME			

there's and accepted. For description, a latting of all economics of the e		SS OA- STRUCTURAL ELEVATIONS AND DETAILS (DUAL PITCH) 54 O- WALL FRAMING (WOOD) 55 O- FRAMING DETAILS (WOOD) 55 I- FRAMING DETAILS (WOOD)
	MECHANICAL	MIO-HVAC (HVAC) PLAN (24X40)
DING DATA BLDG'S E-2 V-N	ELECTRICAL	EIO - ELECTRICAL PLAN (24X40)
70 MPH EXP "C" 50 PSF. REDUCED FOR AREA 460 SOFTE	RAMP	RIO - RAMP PLAN R20 - RAMP DETAILS
		"我们的,我们是一个人,我们就没有一个人的,我们就没有一个人,我们就没有一个的最后的,我们就没有的人的,我们就没有这个人。""我们的,我们也不是一个人,我们就会

JOB # 2961

CAJON VALLEY USD

SPECIFICATIONS SUBJECT TO CHANGE DUE TO PRODUCT IMPROVEMENT


APPLICABLE CODES - NEW CONSTRUCTION

1994 UBC AND 1995 CALIFORNIA AMENDMENTS (95 CALIFORNIA BUILDING CODE - PART 2, TITLE 24, CCR)
1993 NEC AND 1995 CALIFORNIA AMENDMENTS (95 CALIFORNIA ELECTRICAL CODE - PART 5, TITLE 24, CCR) MITH THE SIGNING OF THE DRAWINGS, WE ACKNOWLEDGE THAT WE HAVE REVIEWED THESE PLANS AND SPECIFICATIONS AND HAVE FOUND THEM TO BE IN GENERAL COMPLIANCE WITH THE BID DRAWINGS, SPECIFICATIONS AND ASSOCIATED ADDENDUMS WHEN THESE PLANS AND SPECIFICATIONS HAVE BEEN APPROVED BY THE DEPARTMENT OF HOUSING, THEY SHALL PRESIDE OVER CONFLICTING AREAS IN THE BID DRAWING AND SPECIFICATIONS, AND ANY ADDENDUMS THERETO 1994 UMC AND 1995 CALIFORNIA AMENDMENTS (95 CALIFORNIA MECHANICAL CODE - PART 4,TITLE 24, CCR) 1994 UPC AND 1995 CALIFORNIA AMENDMENTS (95 CALIFORNIA PLUMBING CODE - PART 5, TITLE 24, CCR) 1994 UNIFORM FIRE CODE WITH STATE AMENDMENTS (CALIFORNIA FIRE CODE - PART 9, TITLE 24, CCR) 1994 BUILDING STANDARDS CODE (95 STATE REFERENCED STANDARDS CODE - PART 12, TITLE 24, CCR) TITLE 19 C.C.R PUBLIC SAFETY, STATE FIRE MARSHELL REGULATIONS

ARCHITECT

STRUCTURAL

APOR PC PLAN ONLY -A/B OF RECORD: JAMES T. OMPOON BKL STRUCTURAL BHOJING 921 & WHITTIBE BUYES LA HABRACA 90601 (810) 697-7804

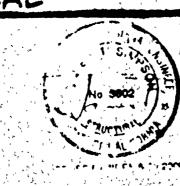

SHEET INDEX

A2 OA - ROOF PLAN (24X40) DUAL PITCH


AT 2- REFLECTED CEILING DETAILS


FOI - FOUNDATION PLAN (24X40) 50* WOOD


52 OA- ROOF FRAMING PLAN (TYP DUAL PITCH)

521- ROOF FRAMING DETAILS (TYPICAL)


AO - COVER SHEET

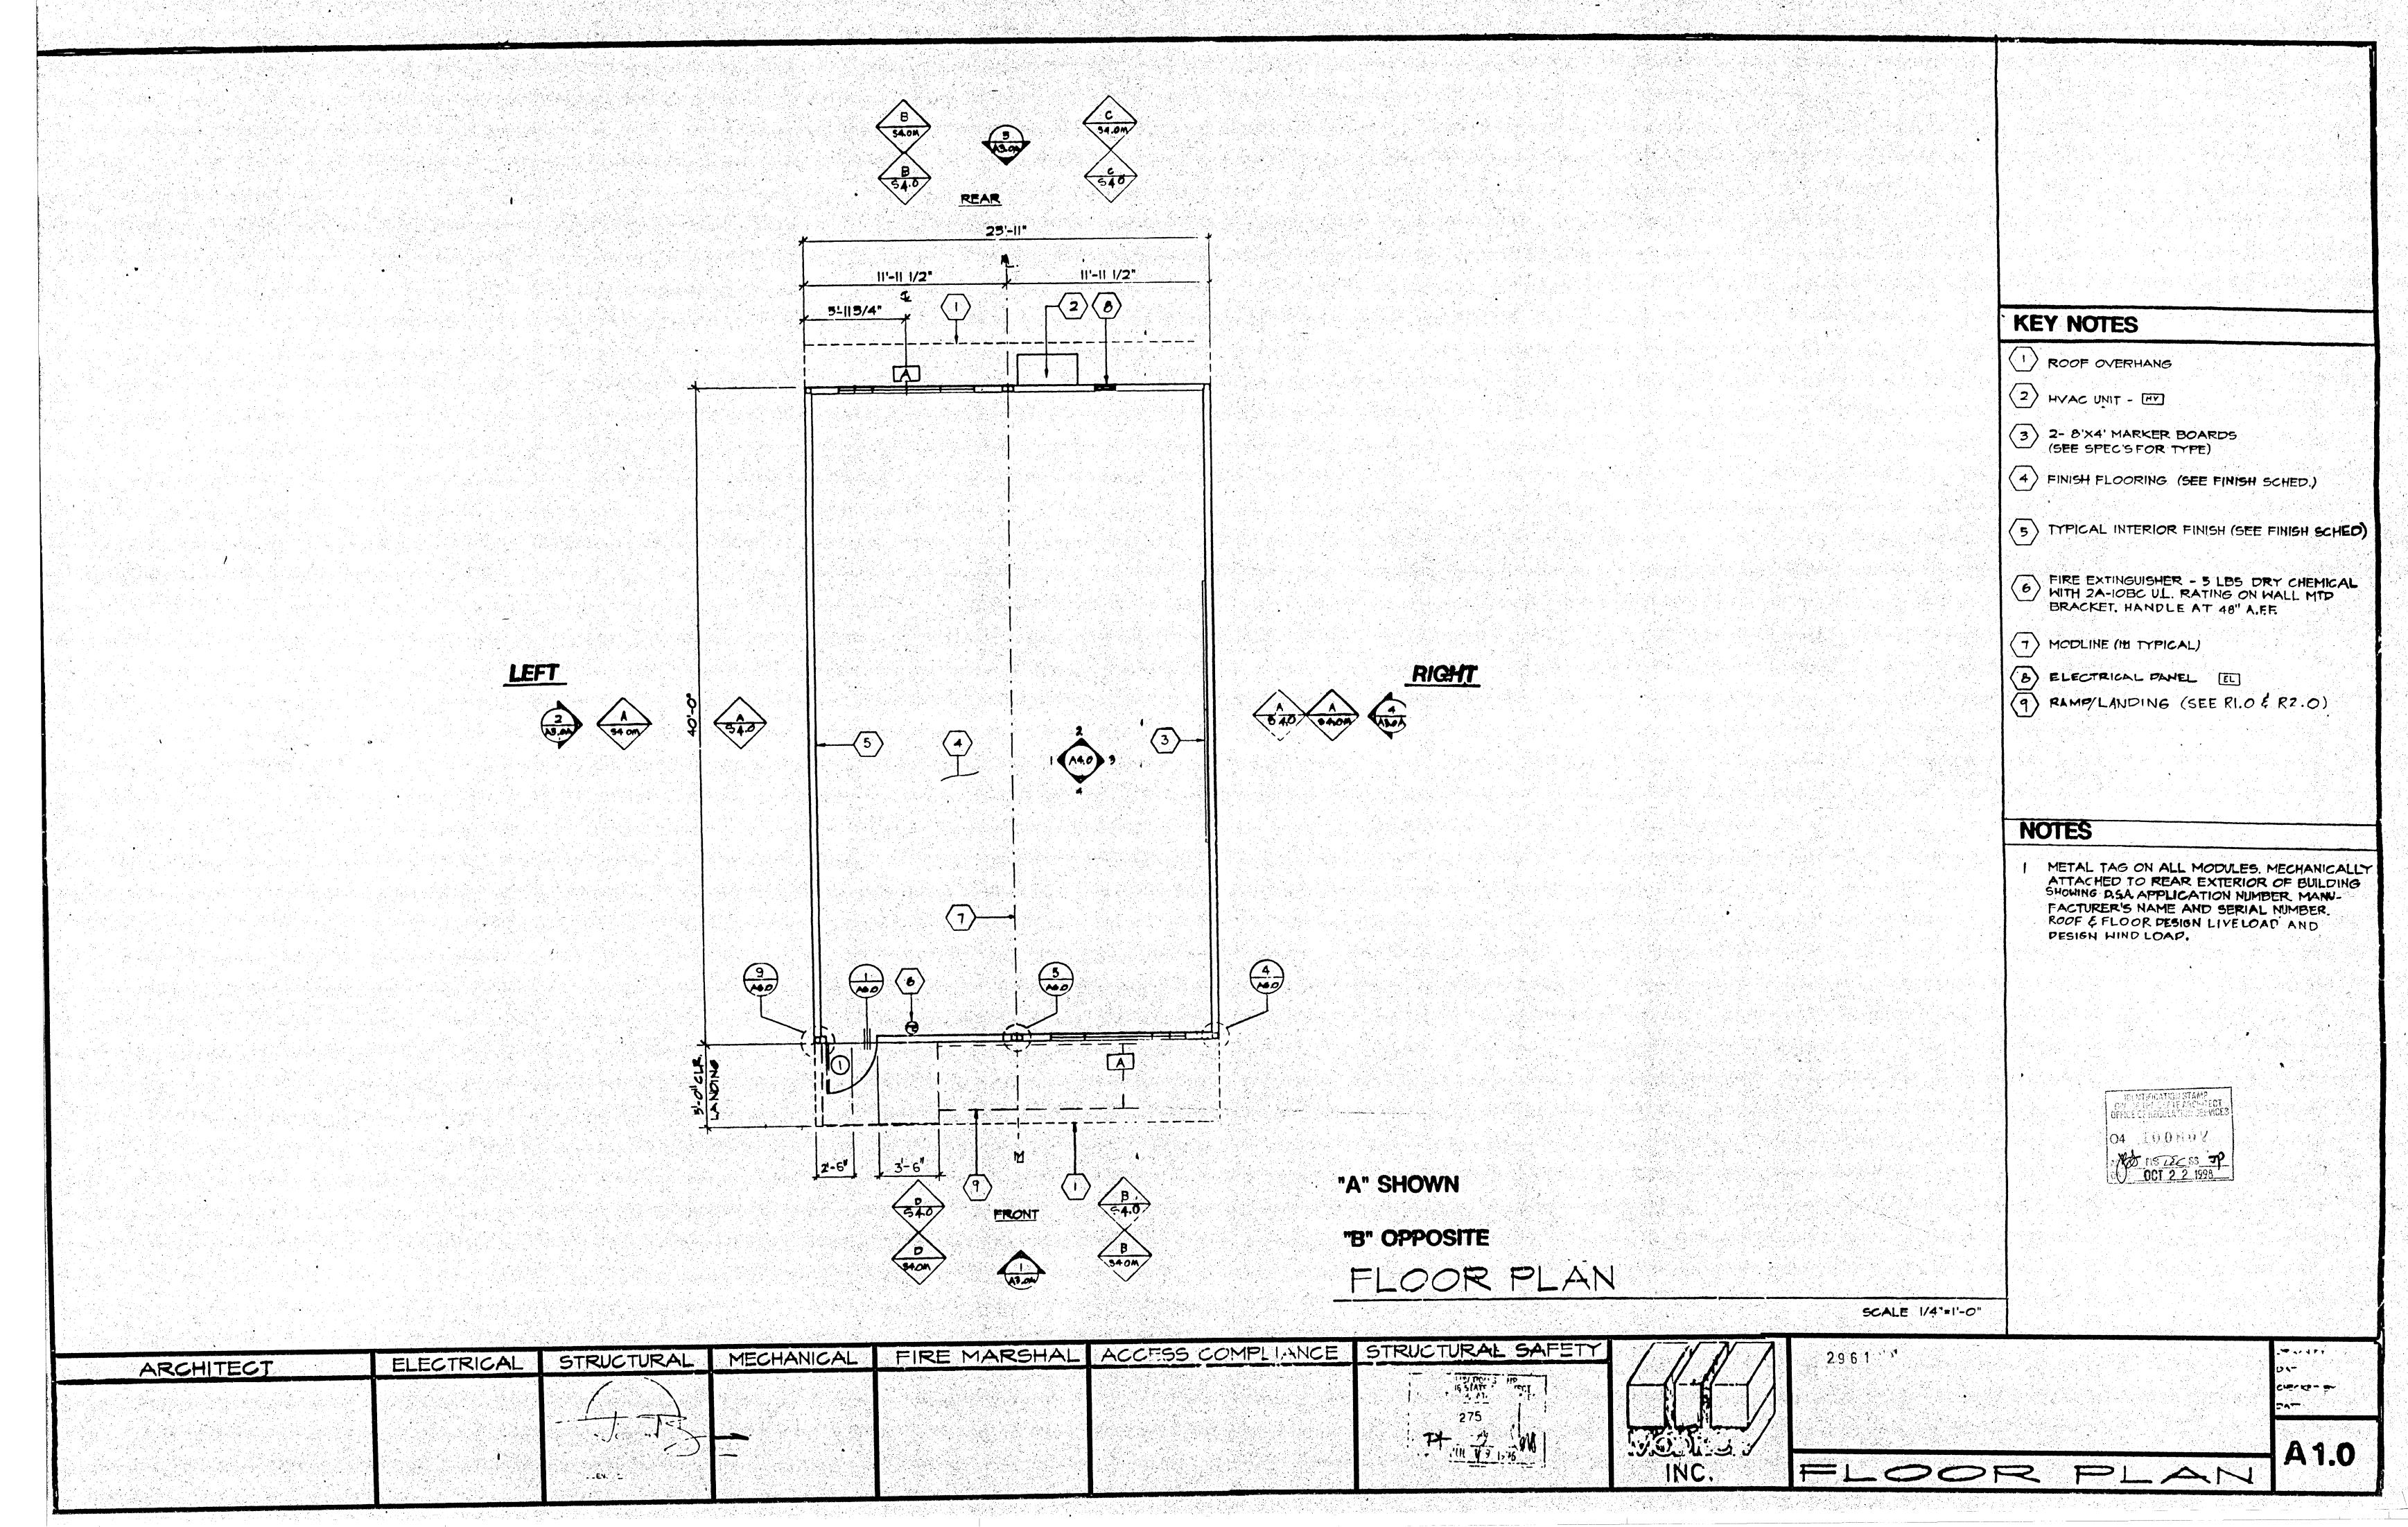

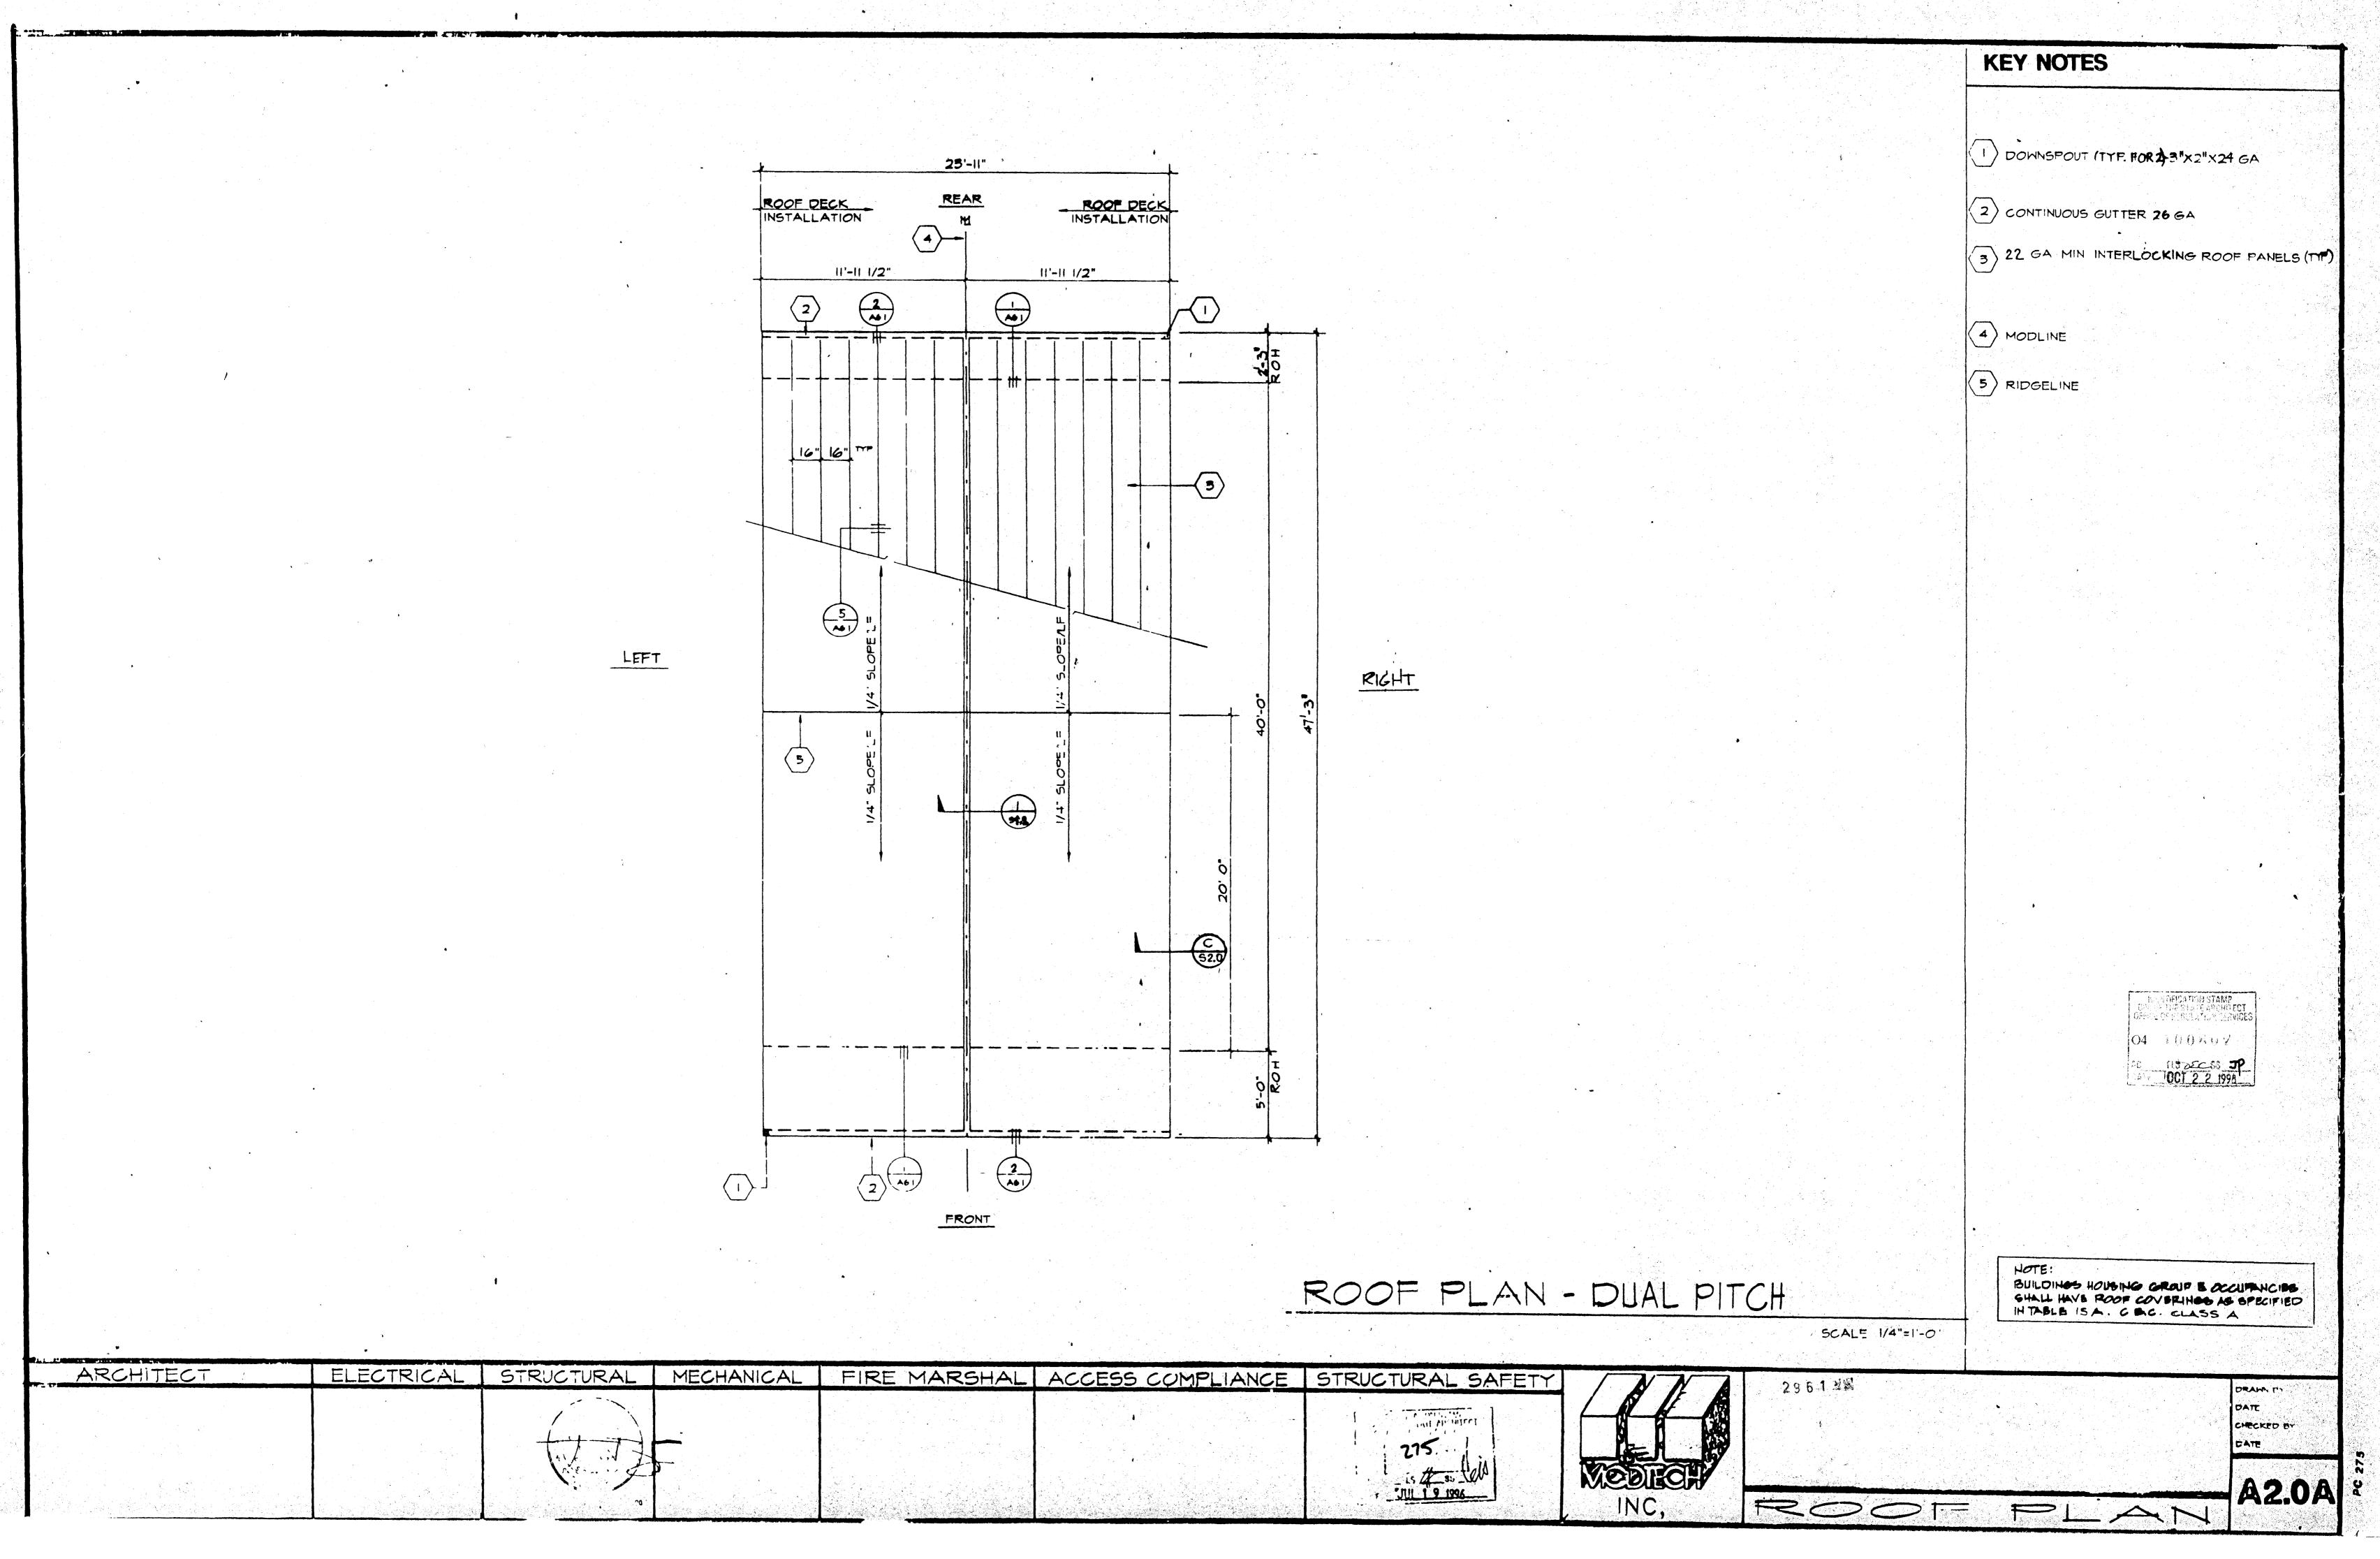

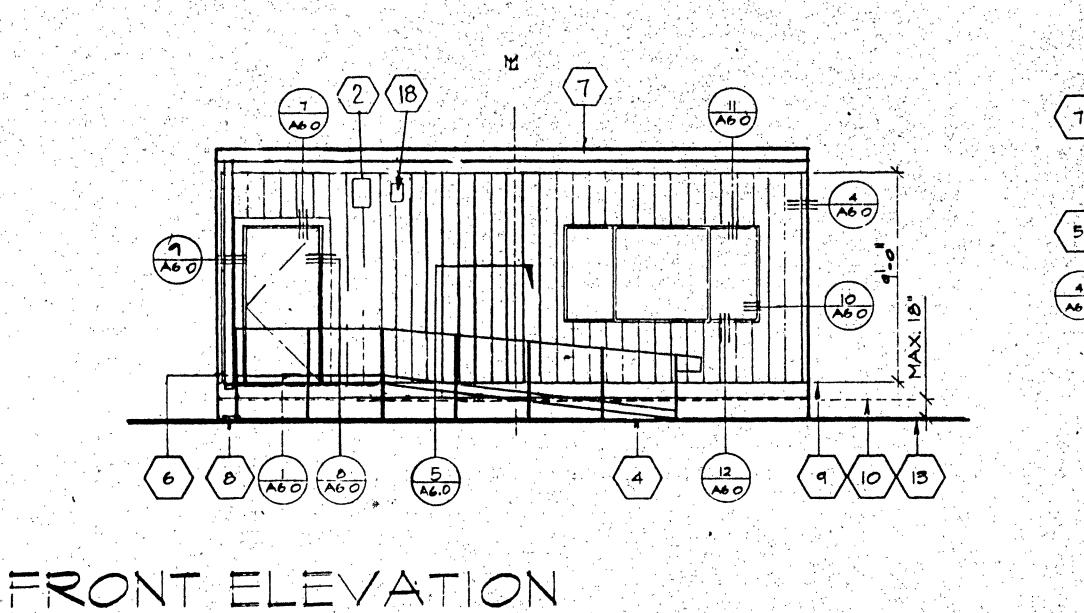


SCALE 1/4"=1'-0"

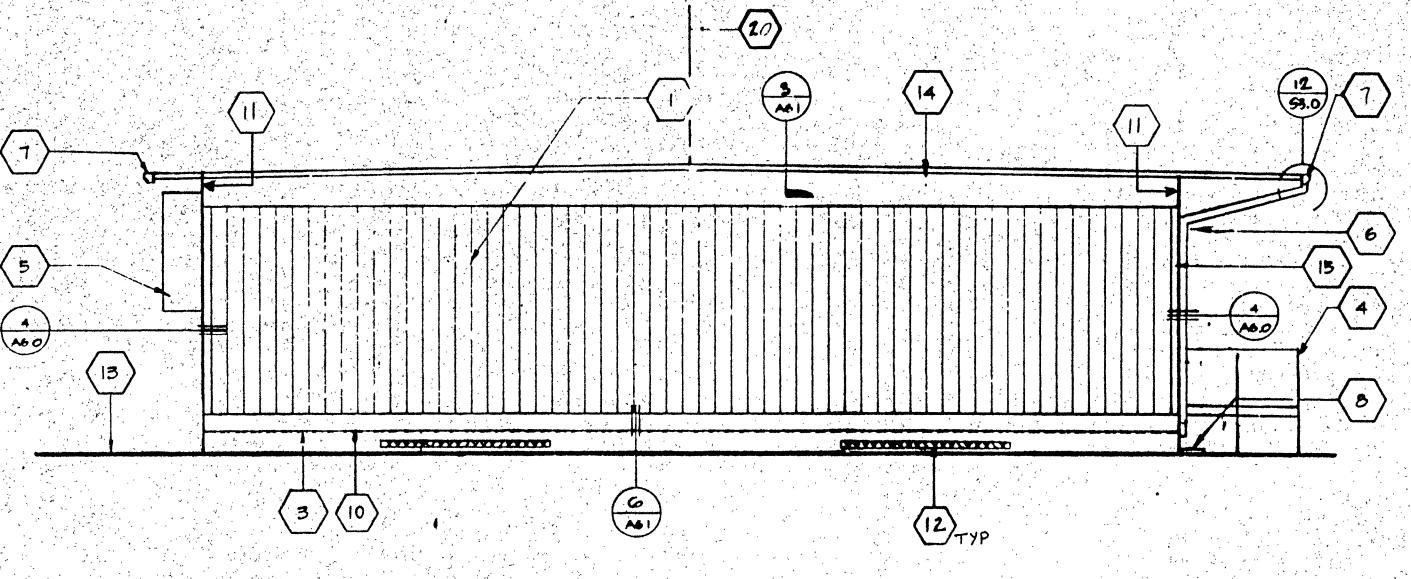

SIDE ELEVATION

(6) 15 14 A6 O 5 A6.0 (4 \10 \15

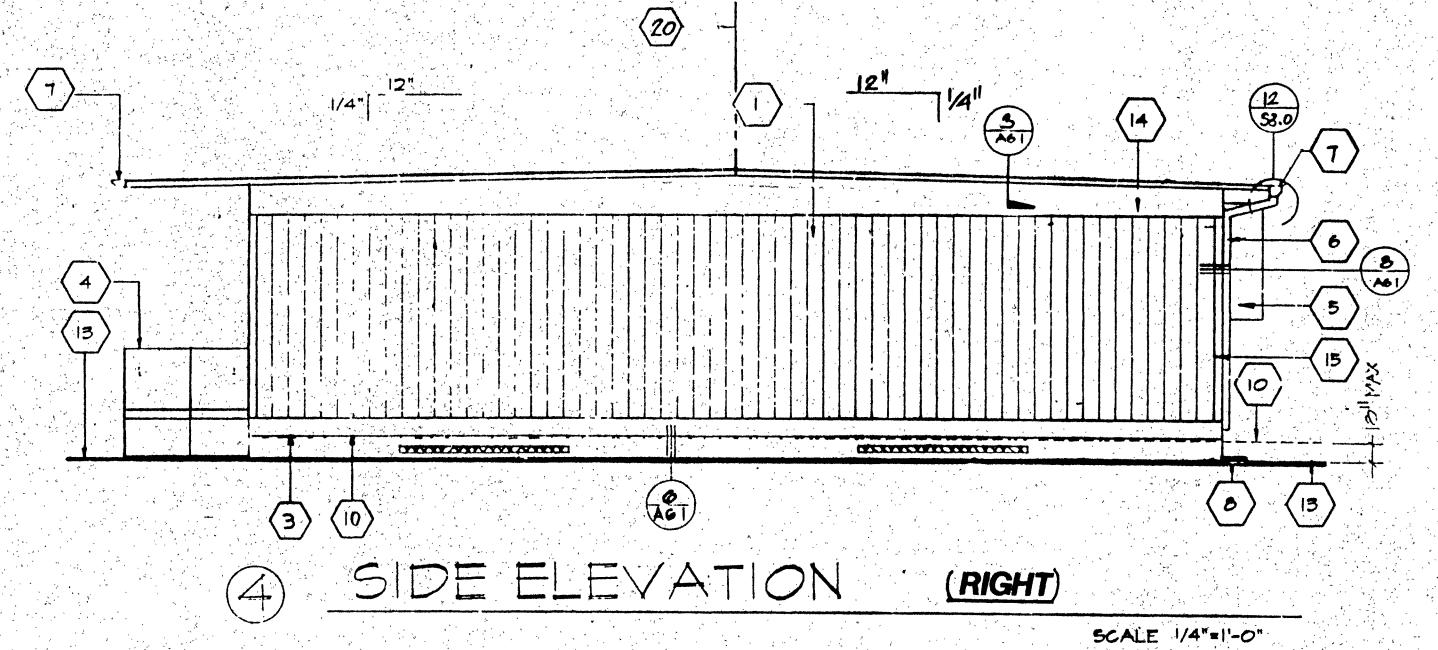

(9) FINISH FLOOR LINE DO BOTTOM FLANGE OF FLOOR PRAM (II) ROOF HEADER (12) VENT SEE FOUNDATION PLAN 13 FINISH GRADE 04-100507 REAR ELEVATION (16) ELECTRICAL STUB-DUT EL SCALE 1/4"=1'-0" (IT) GROUND STUB-CUT [EL] 18 J BOX FOR F.A. HORN EL GUTTER DON FL "A" SHOWN (20) PIDISE "B" OPPOSITE SCALE 1/4"=1'-0" ARCHITECT ELECTRICAL STRUCTURAL ACCESS COMPLIANCE MECHANICAL FIRE MARSHAL STRUCTURAL SAFETY 2961 CHECKET BY Medich 24'X40' DUAL PITCH A3.0A EXTERIOR ELEVATIONS


(4) RAMP AND LANDING SEE SHT 5-1.0 (LEFT) 5 HVAC UNIT HV SCALE 1/4"=1'-0" , DOWNSPOUT (TYP. 2) FASTEN TO BLDC.TYD. 3 PLACES (SEE PI/AGIL) CONTINUOUS GUTTER WITH DOWNSPOUT (LOCATION OF DOWNSPOUT SHOWN ON ROOF PLAN A20) (B) SPLASH BLOCK (E) CTHERS)

KEY NOTES

(3) TOP OF SKIRTING

TYPICAL EXTERIOR SIDING (SEE FINISH SCHED)

2 EXTERIOR LIGHT FIXTURE IFT

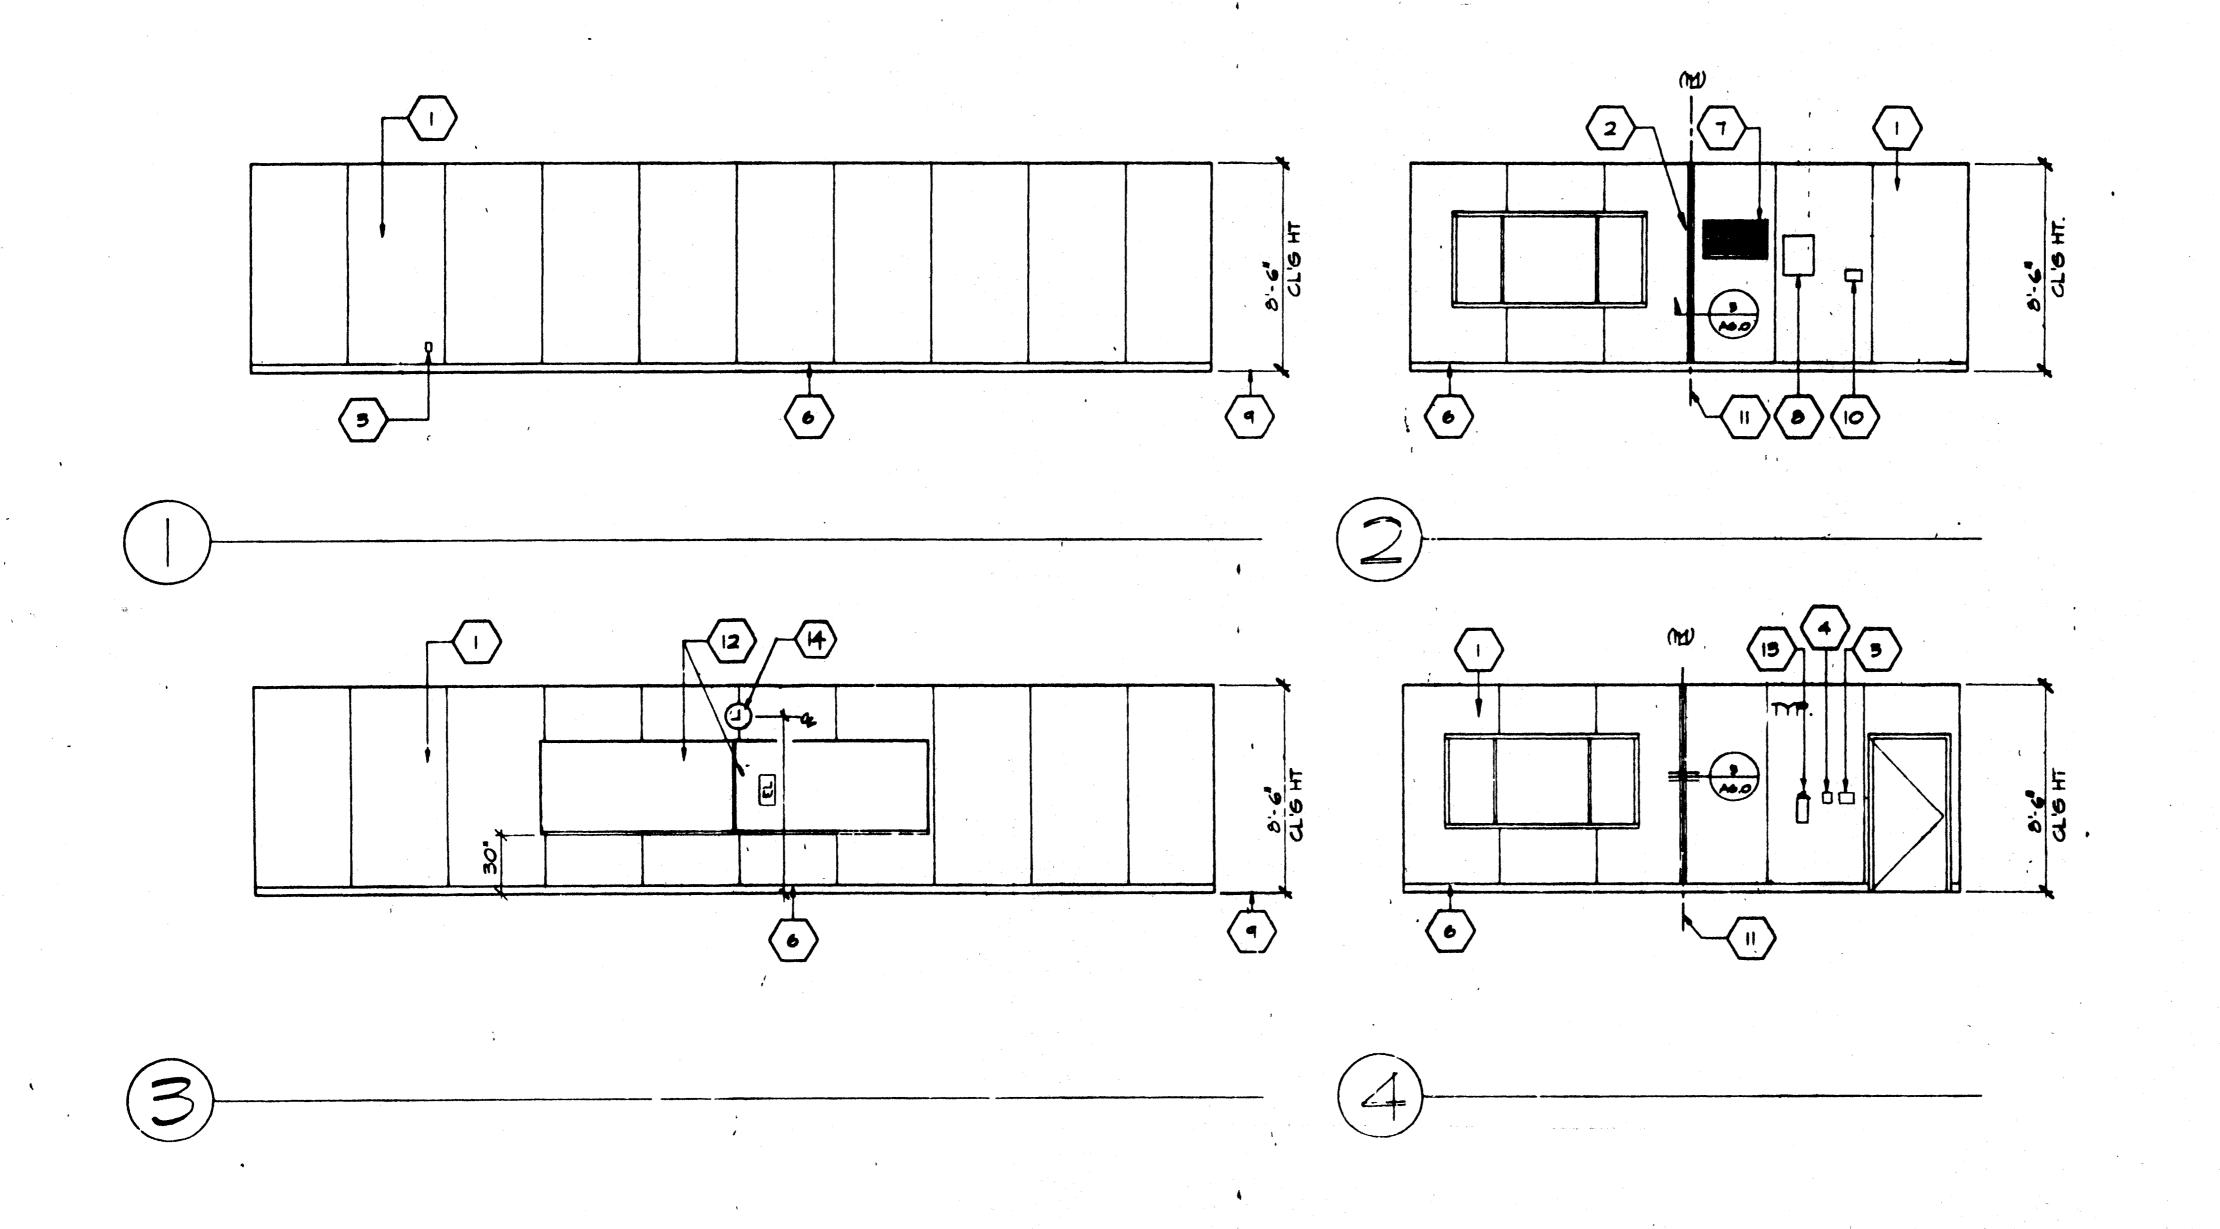

KEY NOTES

TYPICAL INTERIOR FINISH (SEE FINISH SCHEDULE SHT A5 0)

CLOSURE AT MODULAR JOINT

(3) DUPLEY WALL RECEPTAGLE

(4) PIRE ALARM PULL STATION

(5) LIGHT SWITCH.

6 TOP SET BASE (TYPICAL)
SEE FINISH SCHED

(7) RETURN AIR GRILL

(8) ELECTRICAL PANEL EL

(9) FINISH FLOOR

(10) THERMOSTAT HY

(II) MODULAR JOINT

(12) 8040 MARKBOARD

FIRE EXTINGUISHER 5LBS DRY CHEMICAL WITH 2A -IOBC UL RATING ON WALL MITO BRACKET, HANDLE AT 48" A.F.F.

"A" SHOWN

"B" OPPOSITE


INTERIOR ELEVATIONS (24'x40')


SCALE 1/4"=1'-0"

2961

NOTE: OBB ELECTRICAL BAR FOR MOUNTING HEIGH


ACCESS COMPLIANCE STRUCTURAL SAFETY FIRE MARSHAL STRUCTURAL MECHANICAL ELECTRICAL ARCHITECT

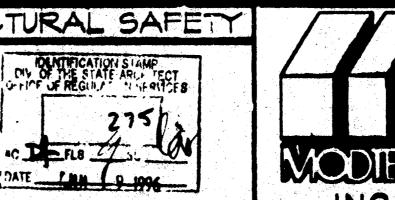


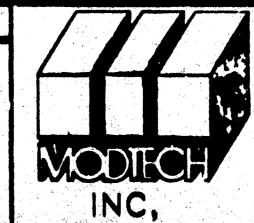



INTERIOR ELEVATIONS

A4.0

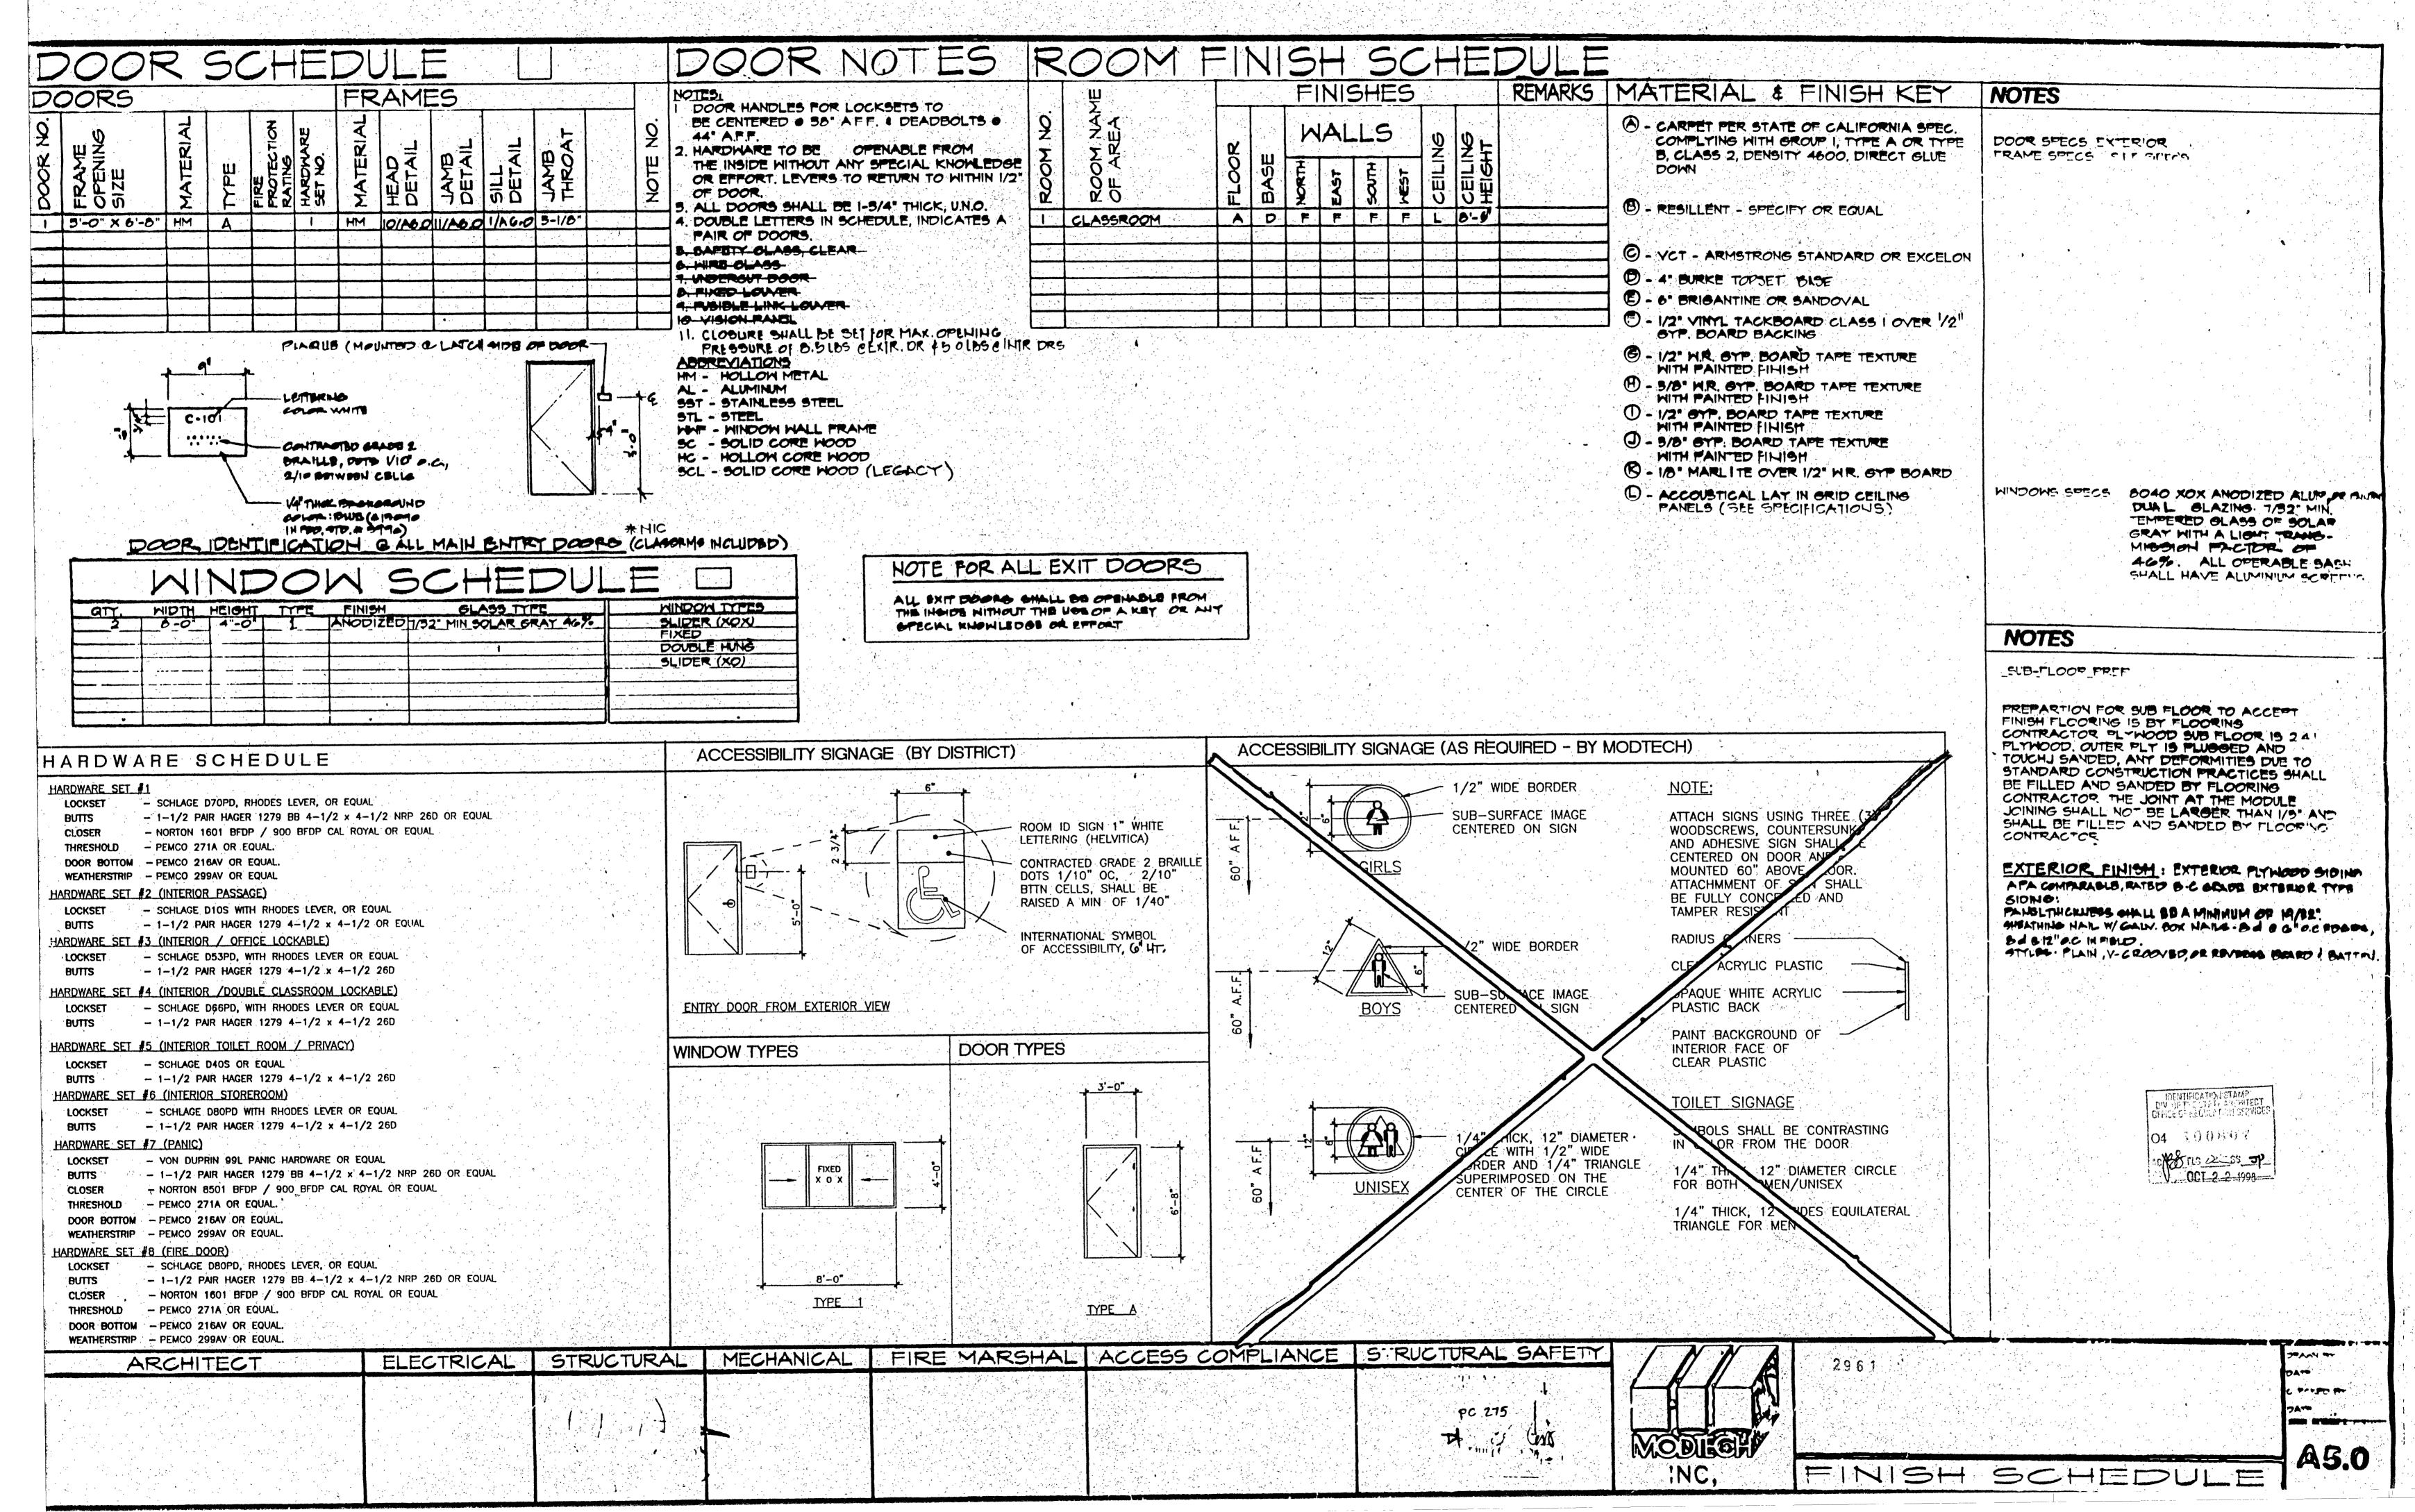

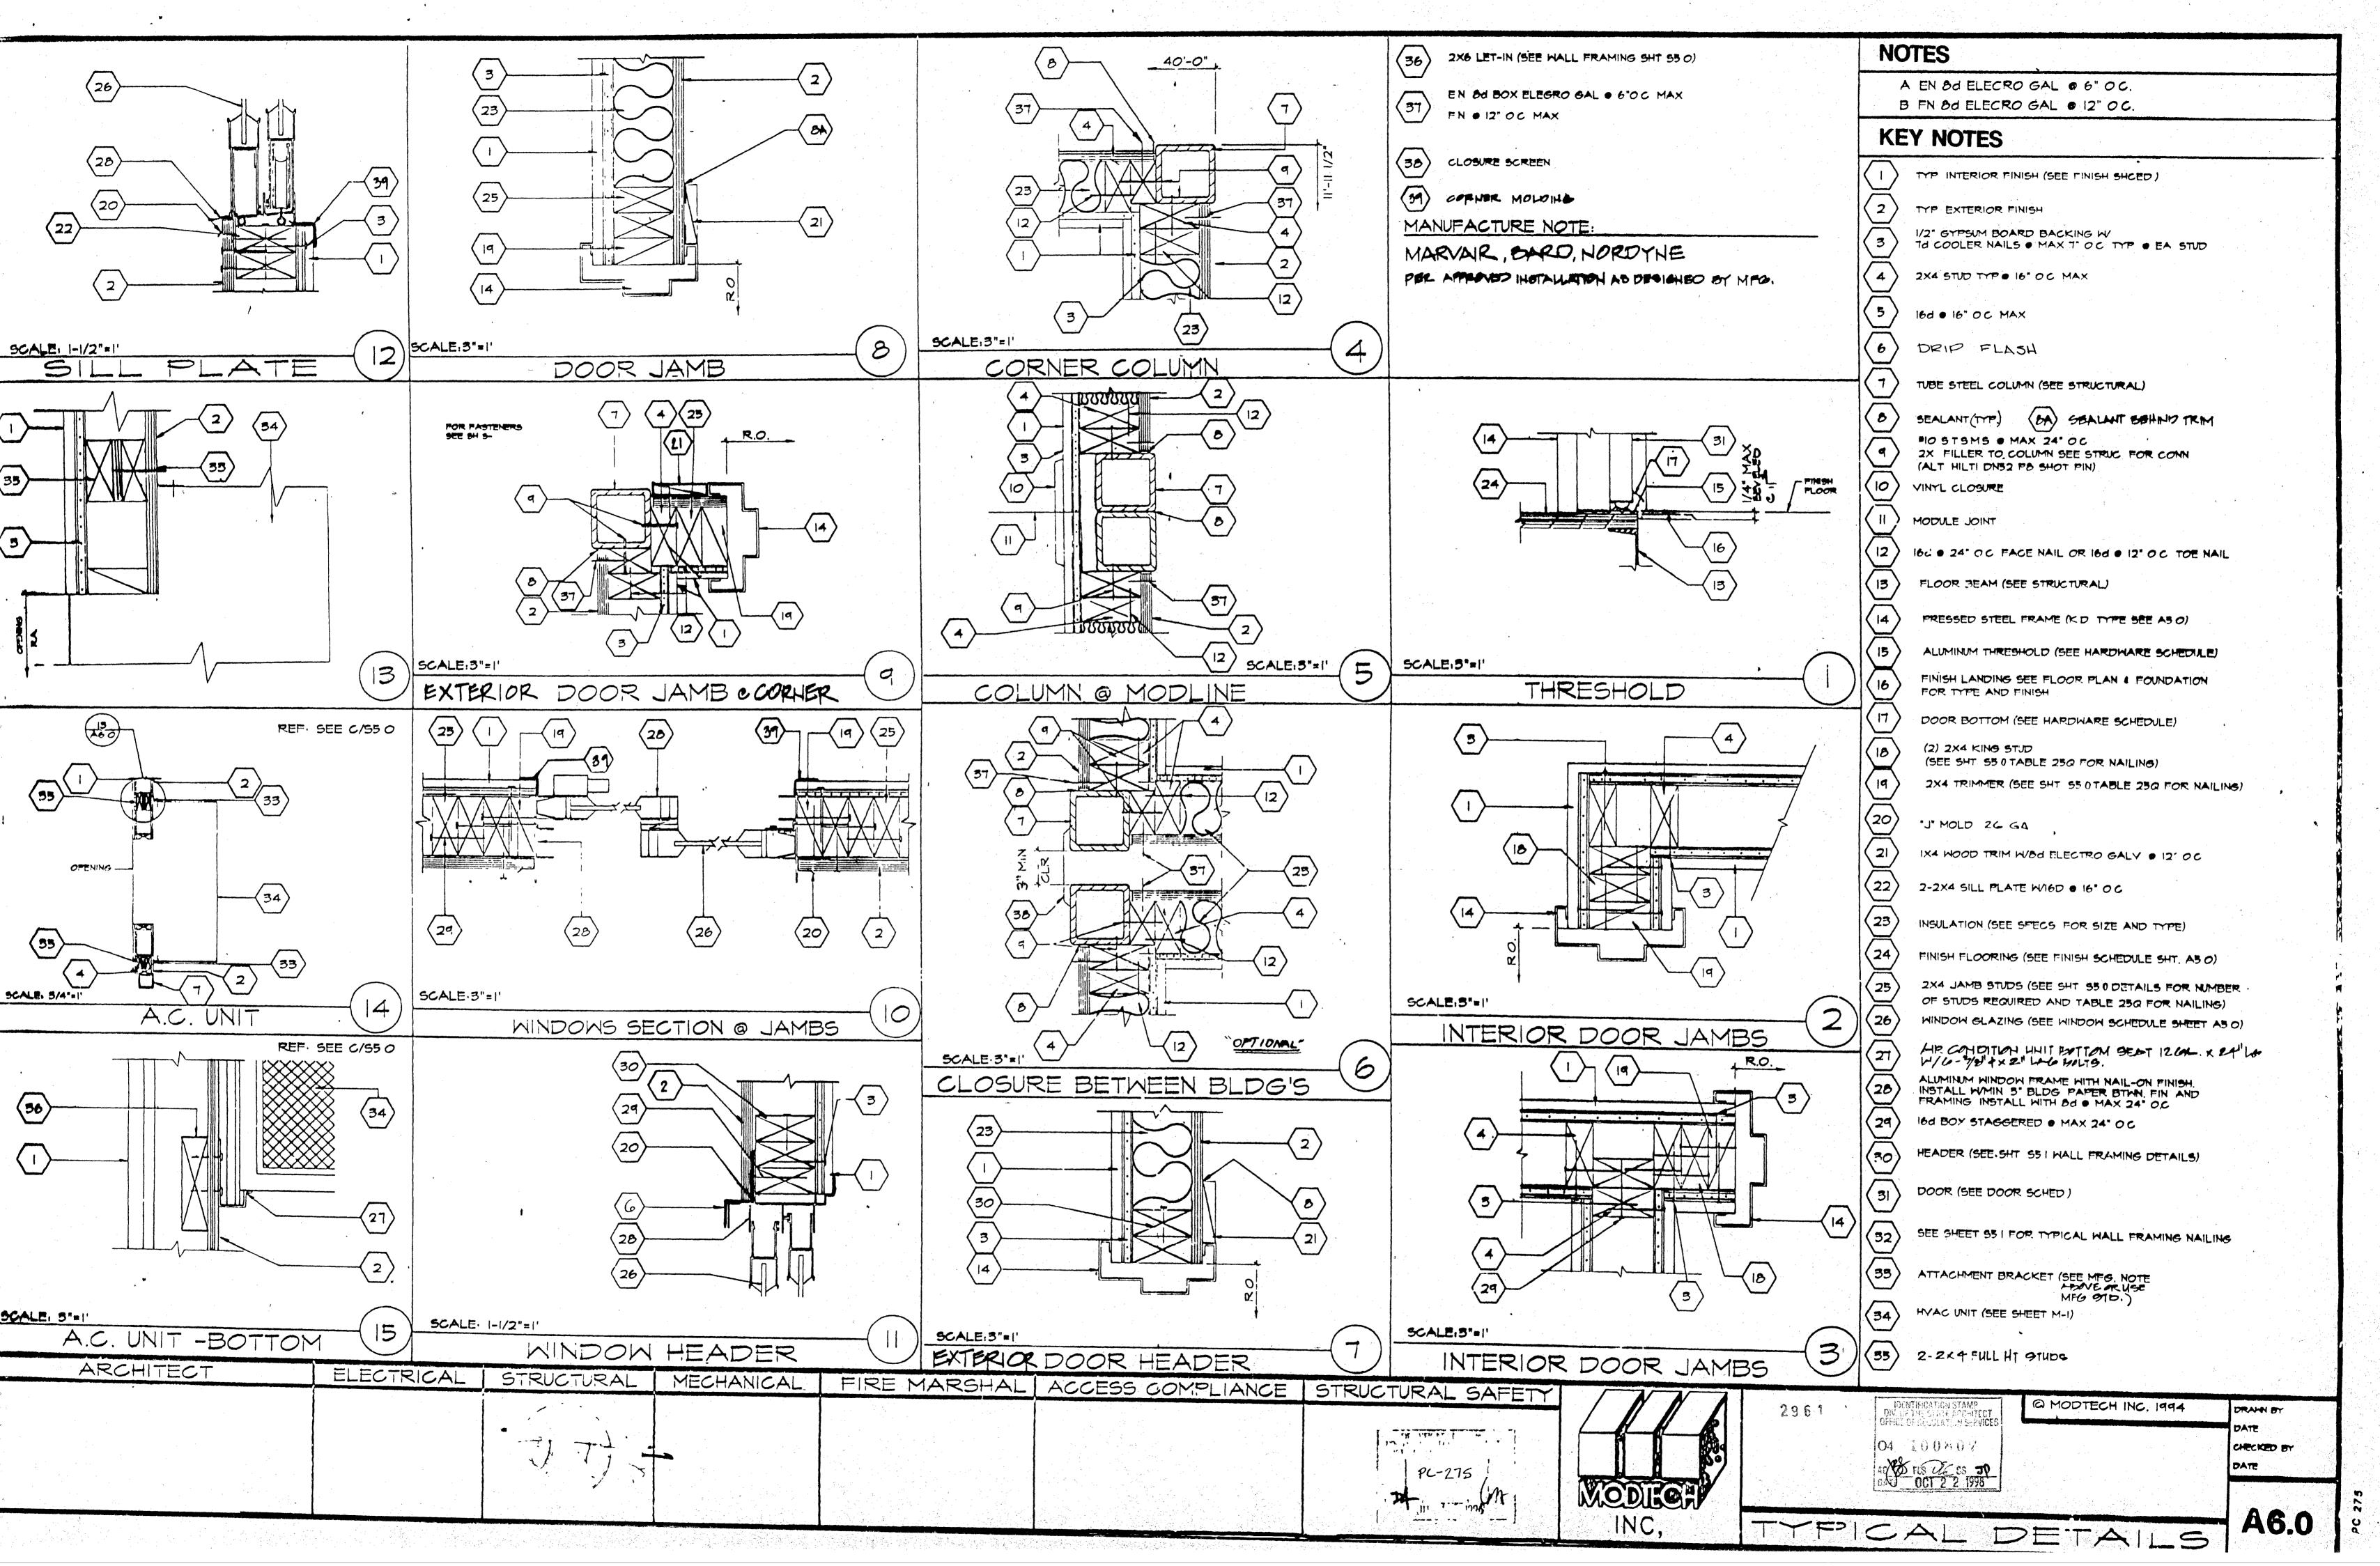

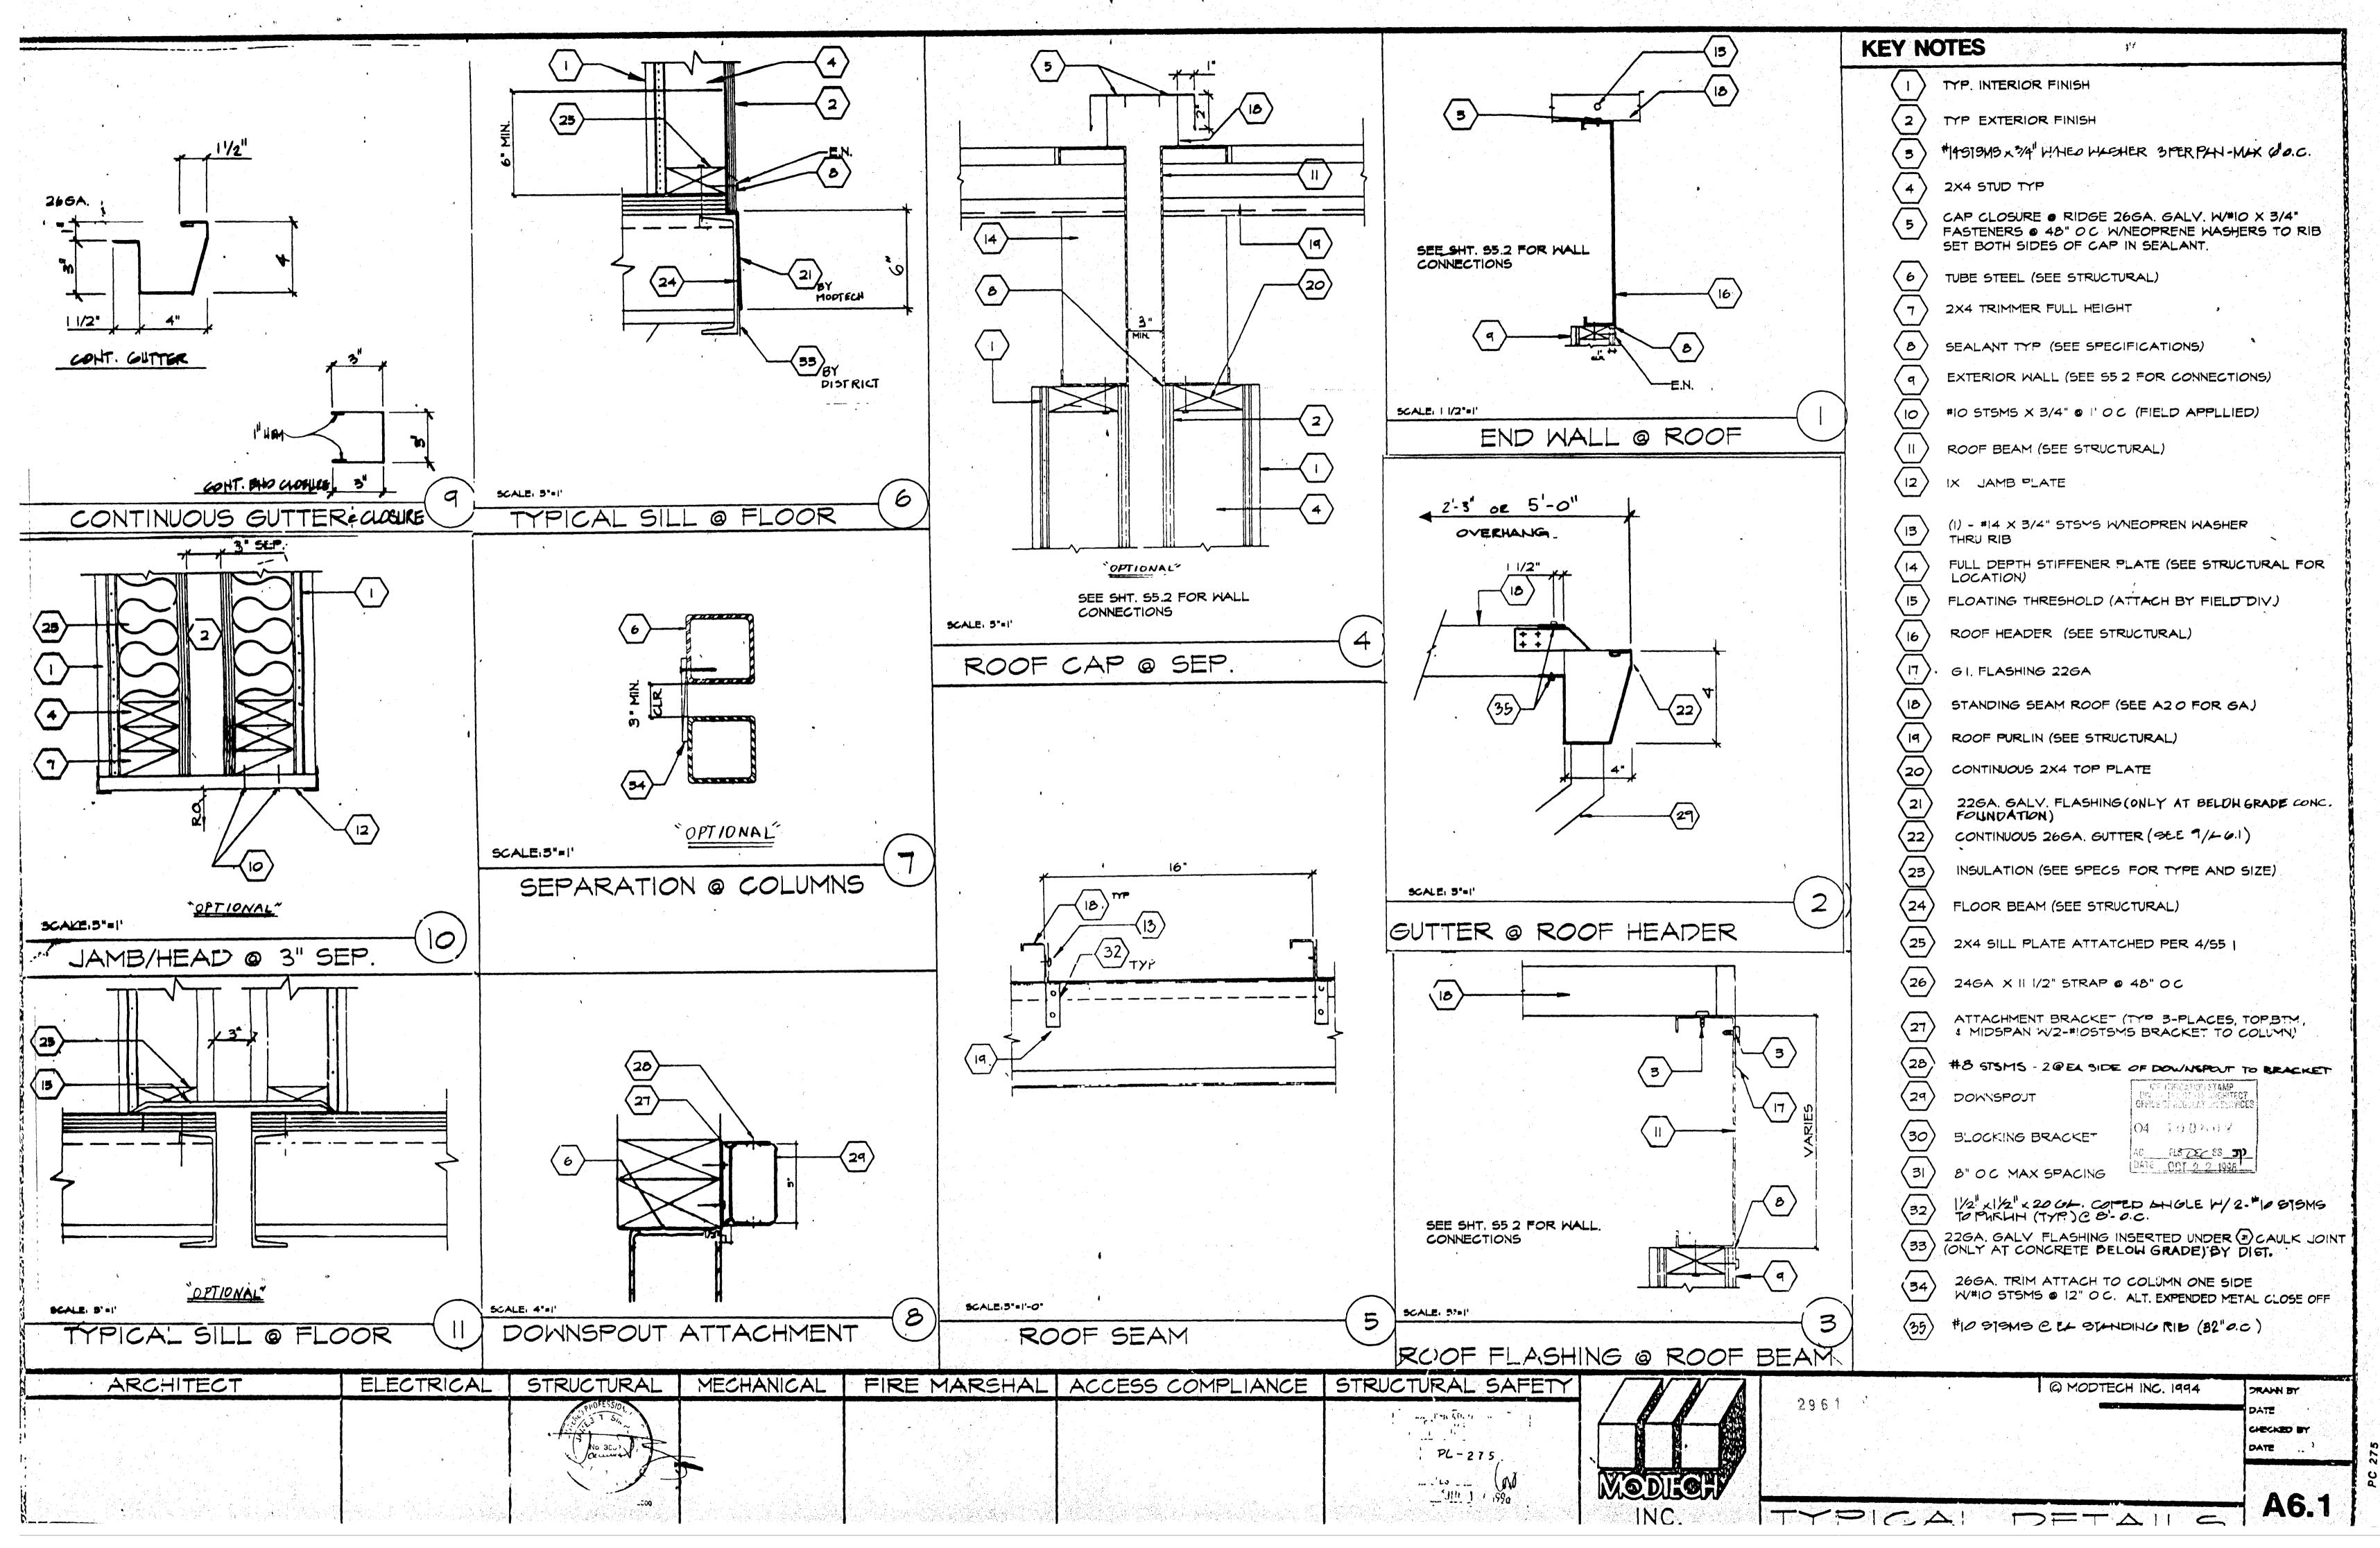

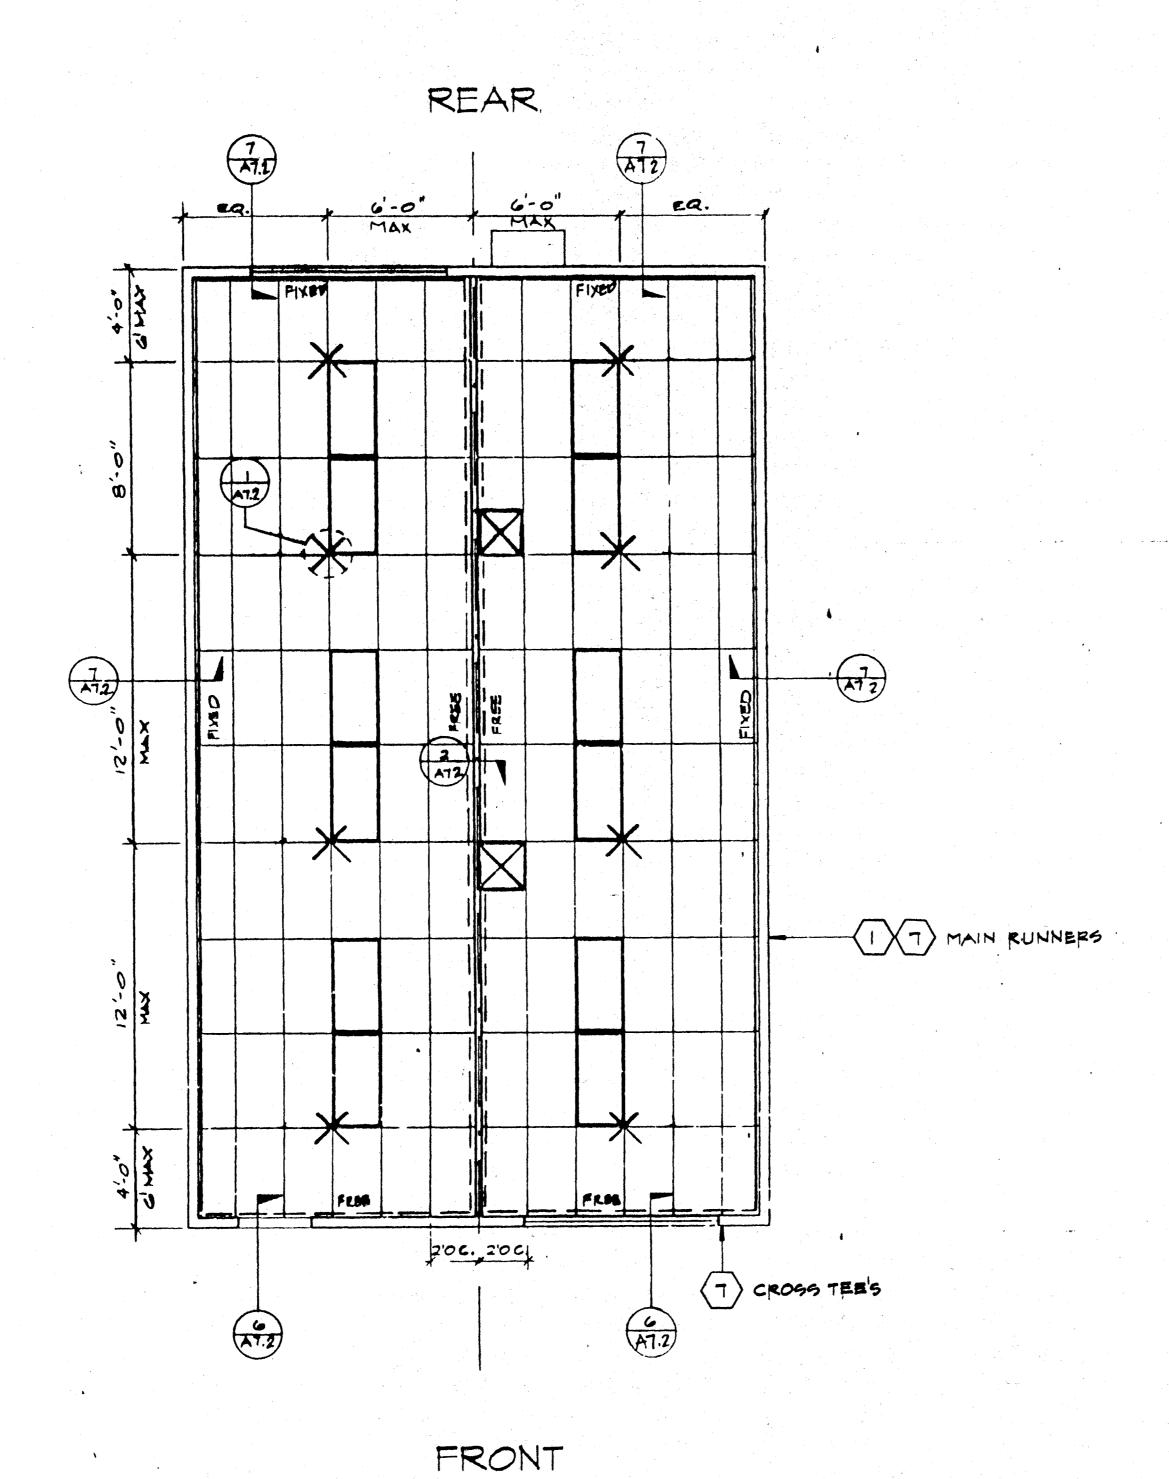

KEY NOTES


1. MAIN RUNNERS @ 4'-O" W/12GA HANGER WIRES @ END OF EACH RUNNER


HAVE COUNTERBRACING WIRES

- 2. AT THE END OF ROWS OF RUNNERS A 12GA HANGER WIRE SHALL BE ATTACHED WITHIN 8" OF WALL OR SOFFIT 3. VERTICAL WIRES MORE THAN 1-IN-6 OUT OF PLUMB SHALL
- 4. PROVIDE 2-12GA SLACK WIRES TO HOUSING OF ALL LIGHT FIXTURES AT DIAGONAL CORNERS WIRES SHALL BE ATTACHED TO STRUCTURE LIGHT FIXTURES 2 X 4 RECESSED, ATTACHED TO GRID W/I-*8 SHEET METAL SCREW AT EACH CORNER
- 5. RUNNERS MAY BE ATTACHED TO WALLS OR MOLD AT 2-ADJACENT WALLS OTHER WALLS NO ATTACHMENT. CLEARANCE OF 1/2" BETWEEN END OF RUNNERS AND FACE OF WALL
- 6. CEILING AREAS SHALL HAVE 4-WAY SPLAYS PER DETAIL 1 ON SHEET AT.2 IN LOCATIONS INDICATED ON DRAWINGS WIRES TAUT BUT NOT TO DISTORT GRID

T-BAF	PART I	NUMBER	35
	ARMSTRONG PA-041	CHICAGO METALLIC IR-47	USG IR-47
RUNNER MAIN	7301	200	DS 26
4' CROSS TEE	, 7342	1210	DX 422
2' CROSS 7328		1226	DX 216
WALL ANGLE	7800	1420-01	M-7

- 8 DUCTWORK SHALL BE RIGIDLY ATTACHED TO BUILDING AND SHALL NOT BE CLOSER THAN 6" TO HANGER WIRES
- 9 REGISTERS SHALL BE POSITIVELY ATTACHED W/4-10GA
 SHEET METAL SCREWS
- 10 CEILING PANELS 2 X 4 LAY-IN PANELS ASTM FLAME SPREAD CLASS (0-25) FLAME SPREAD SMOKE DEVELOPMENT DENSITY LESS THAN 450

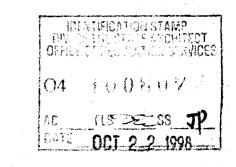

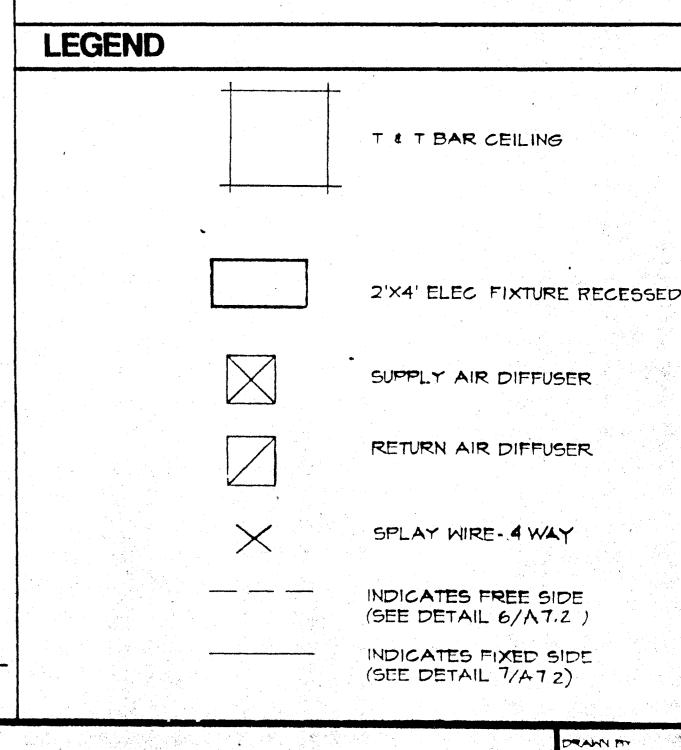


REFLECTED CEILING PLAN

(24'x40')

SCALE 1/4"=1'-0"

ARCHITECT ELECTRICAL STRUCTURAL MECHANICAL FIRE MARSHAL ACCESS COMPLIANCE STRUCTURAL SAFETY

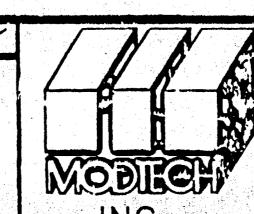


2961

DA-TE
CHECKE
D'A-TE


REFIECTED CEILING PLAN

470

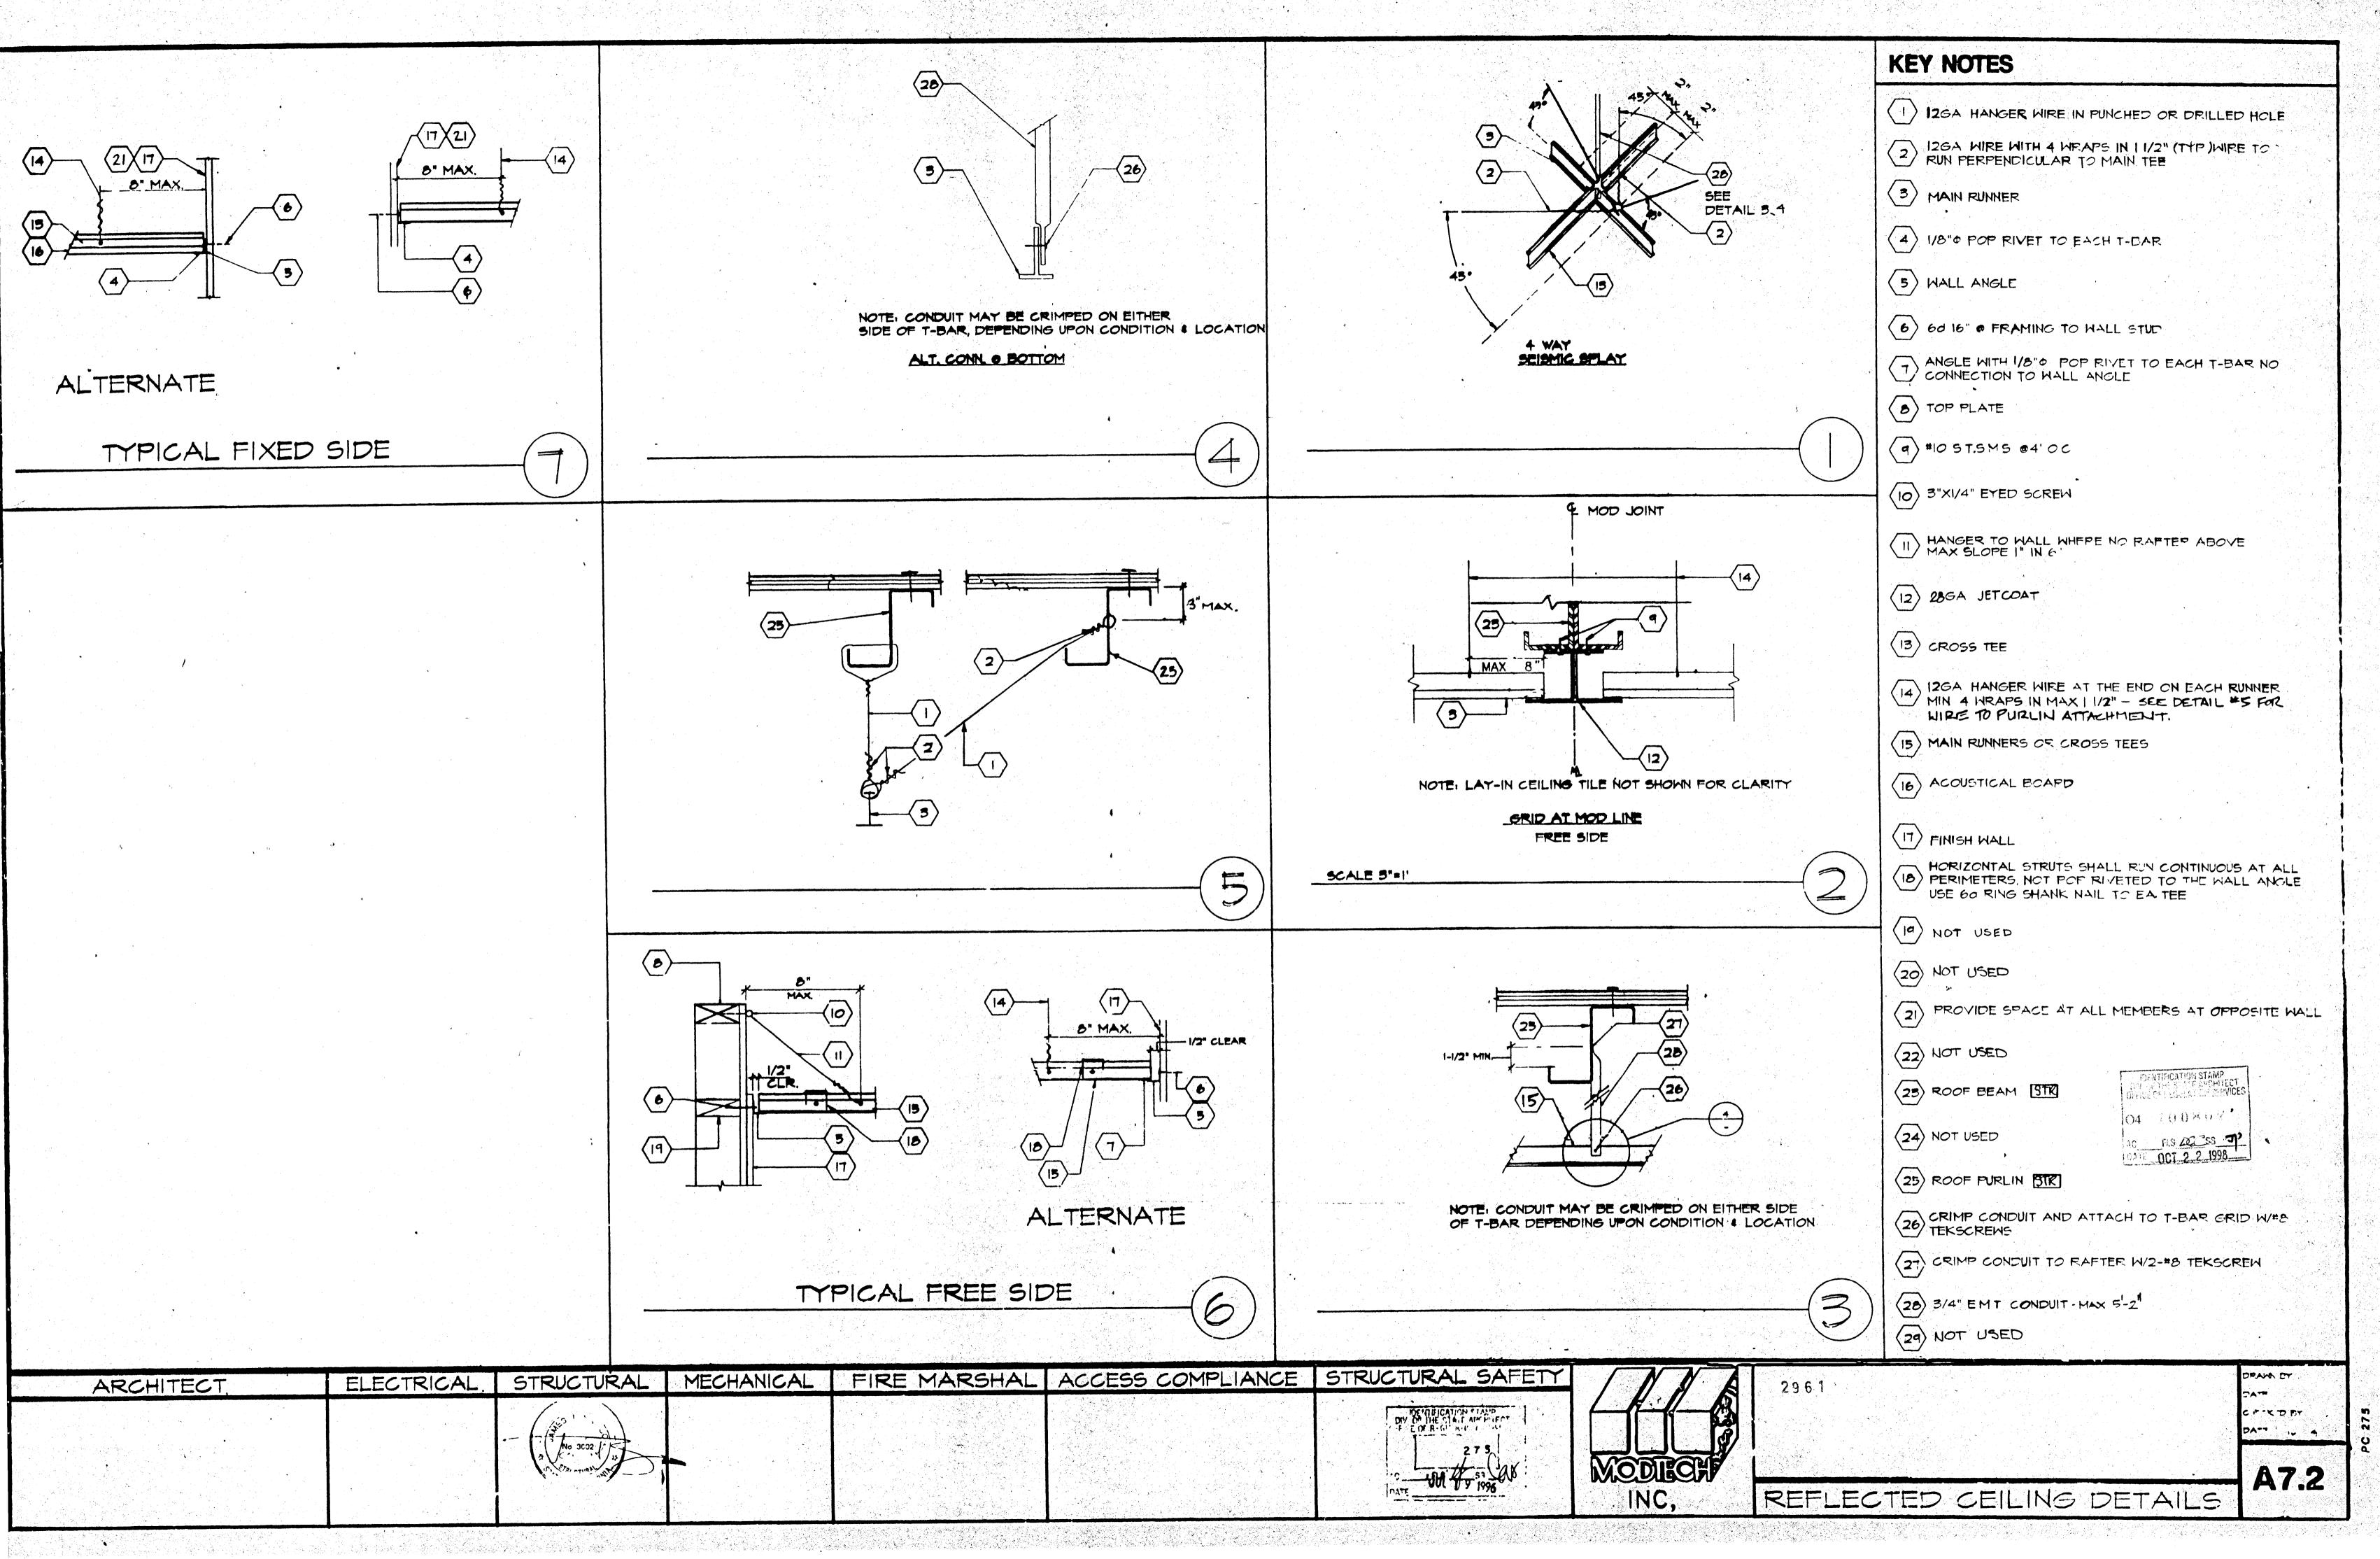



"MACHINE APPLIED 16d FASTENERS SHALL HAVE AN EMBEDMENT OF NOT LESS THAN 1 1/2" INTO SECOND MEMBER, AND SHALL BE NOT LESS THAN 3" IN OVERALL LENGTH"

THE ABOVE NAILS SHALL ALSO BE ACCEPTABLE FOR HAND NAILING, PROVIDED THE REQUIRED EMBEDMENT IS MAINTAINED

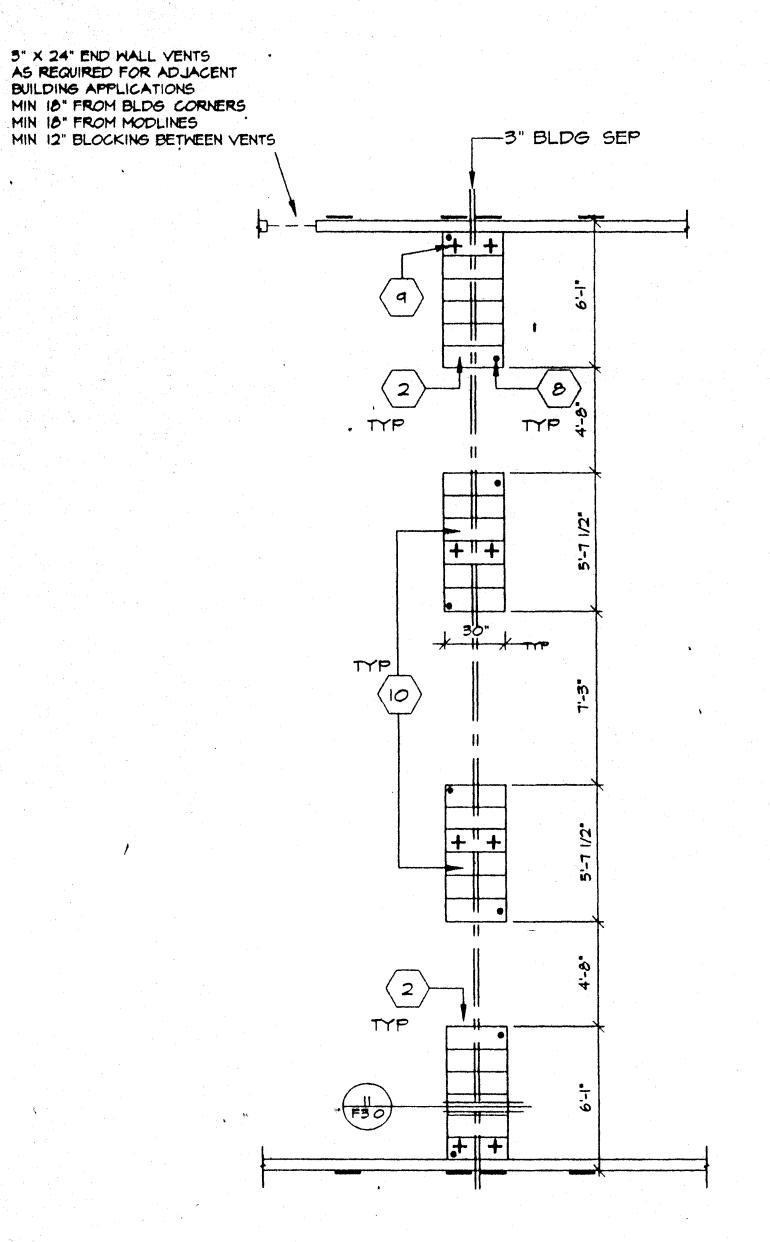

PAD FTG'S AT ADJ BLDG

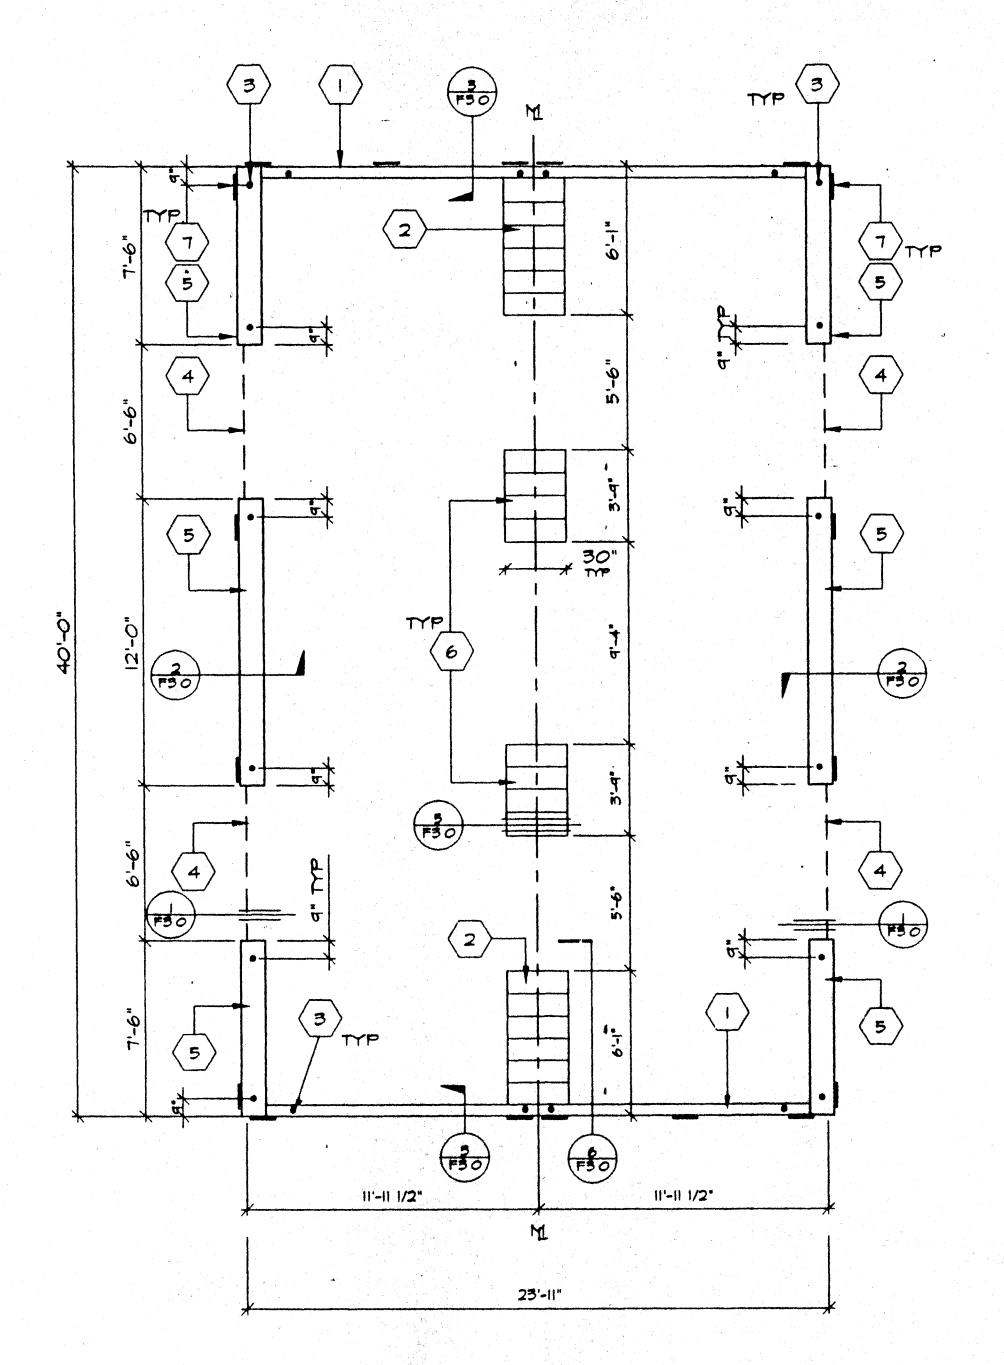

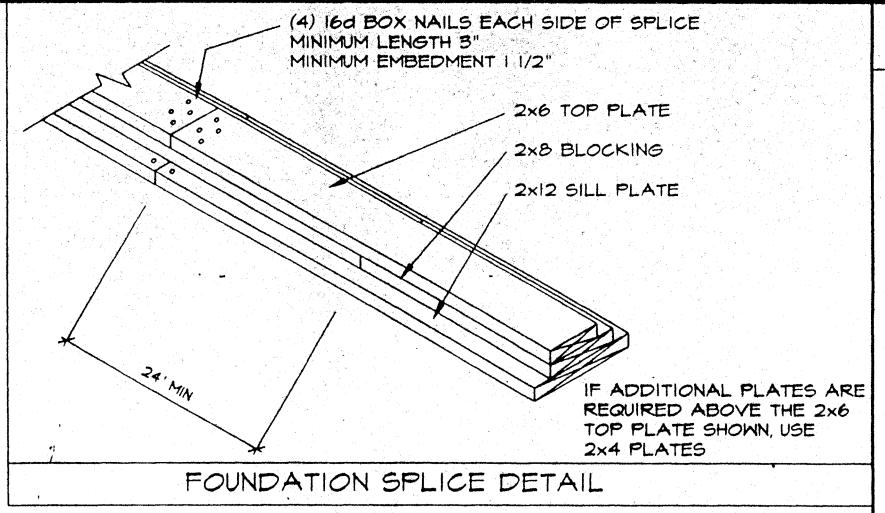

KEY NOTES

- 2"X6" SILL PLATE (END WALL)
- 6- 2XI2X30" LONG SILL PADS
- PIPE TO GRADE (TYP)
- 3" HIGH BY 6'-6" LONG VENT
- 2XI2 SILL PLATE (SIDE WALL)
- 4-2XI2X30" LONG SILL PADS
- 6"XI2"XIO GA PLATES
- I" PPPE EA END EA PAD AT ADJ BLOG LINE
- 5/8" Φ X4" LAG (4-PER BLDG MIN)
- 6- 2XI2X30" LONG SILL PADS

NOTES

- SILL RESTRAINT ON AC PAVING AND ON SOIL I" OD GALVANIZED PIPE AT 10'-0" 12" PENETRATION BELOW SURFACE VERTICALLY DRILL SILL 1-1/4" MAX PIPE MAY BE DRIVEN MAX OF 45° ANGLE TO VERTICAL (18-1/2" LONG PIPE REQUIRED FOR PENETRATION AT 45° ANGLE)
- 2 ON CONCRETE PAYING HILTI DS 82-PIO THRU SILL PLATE

END WALLS 8" O.C SIDE WALLS 22 "O.C

- 3. WHERE SHIM STOCK IS REQUIRED FOR LEVELING USE 1/4", 1/2", OR 3/4" THICK PLYWOOD SAME WIDTH AS BLOCK PT
- 4. VERIFY DRAINAGE, TO PREVENT WATER FROM PONDING BENEATH THE STRUCTURE, WITH DISTRICT ARCHITECT SITE PLANS
- 5. ALL FOUNDATION MATERIAL SHALL BE HEM FIR GROUND CONTACT: LP-22 (CCA 40) ABOVE GROUND LP-2 (CCA 25)
- 6 FOUNDATION DESIGNED FOR 1000 PSF SOIL BEARING PRESSURE PER ORS IR 23-6 ABOVE GROUND: LP-2

FOUNDATION (WOOD SILL)

24 × 40 - 50 PSF LL

SCALE 1/4"=1'-0"

JOB NO 2961

VENT CALCS.

VENTILATION REQ'D 960+150= 64 0

BLD'G SIZE 24' X 40'= 960 Ø


3" × 6'-6" VENT=1625\(\overline{1}\)

65 2 > 64 2

4 VENTS X 16250 = 650

104 100807

REVISIONS	ELECTRICAL	MECHANICAL	STRUCTURAL	ARCHITECT	DIVISION OF THE STATE ARCHITECT
			3PHOFESS/OFY		DEVISED ATTR 2 7 1996 DIV OF THE STATE ARCHITECT OFFICE OF PEGINATION SERVICES
			Mo 3802 2 5		
			The state of the s		Pc 275
			LICENSE EXPL CO 6-70 5000		ACFIS_SS_CA DATE_7-19-46

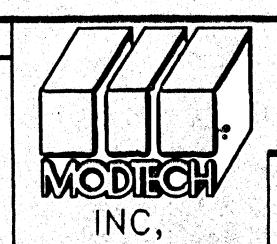



MODTECH INC. 2830 BARRETT AVE PERRIS, CA. 92572 PH (909) 943-4014 FX (909) 940-0427


CONFIDENTIAL - THIS DOCUMENT AND THE INFORMATION CONTAINED HEREIN ARE THE PROPERTY OF MODITECH INC UNAUTHORIZED COPYING, DISCLOSURE, OR OTHER UNAUTHORIZED USES ARE PROHIBITED FOUNDATION PLAN


CHECKED BY


DRAWN BY

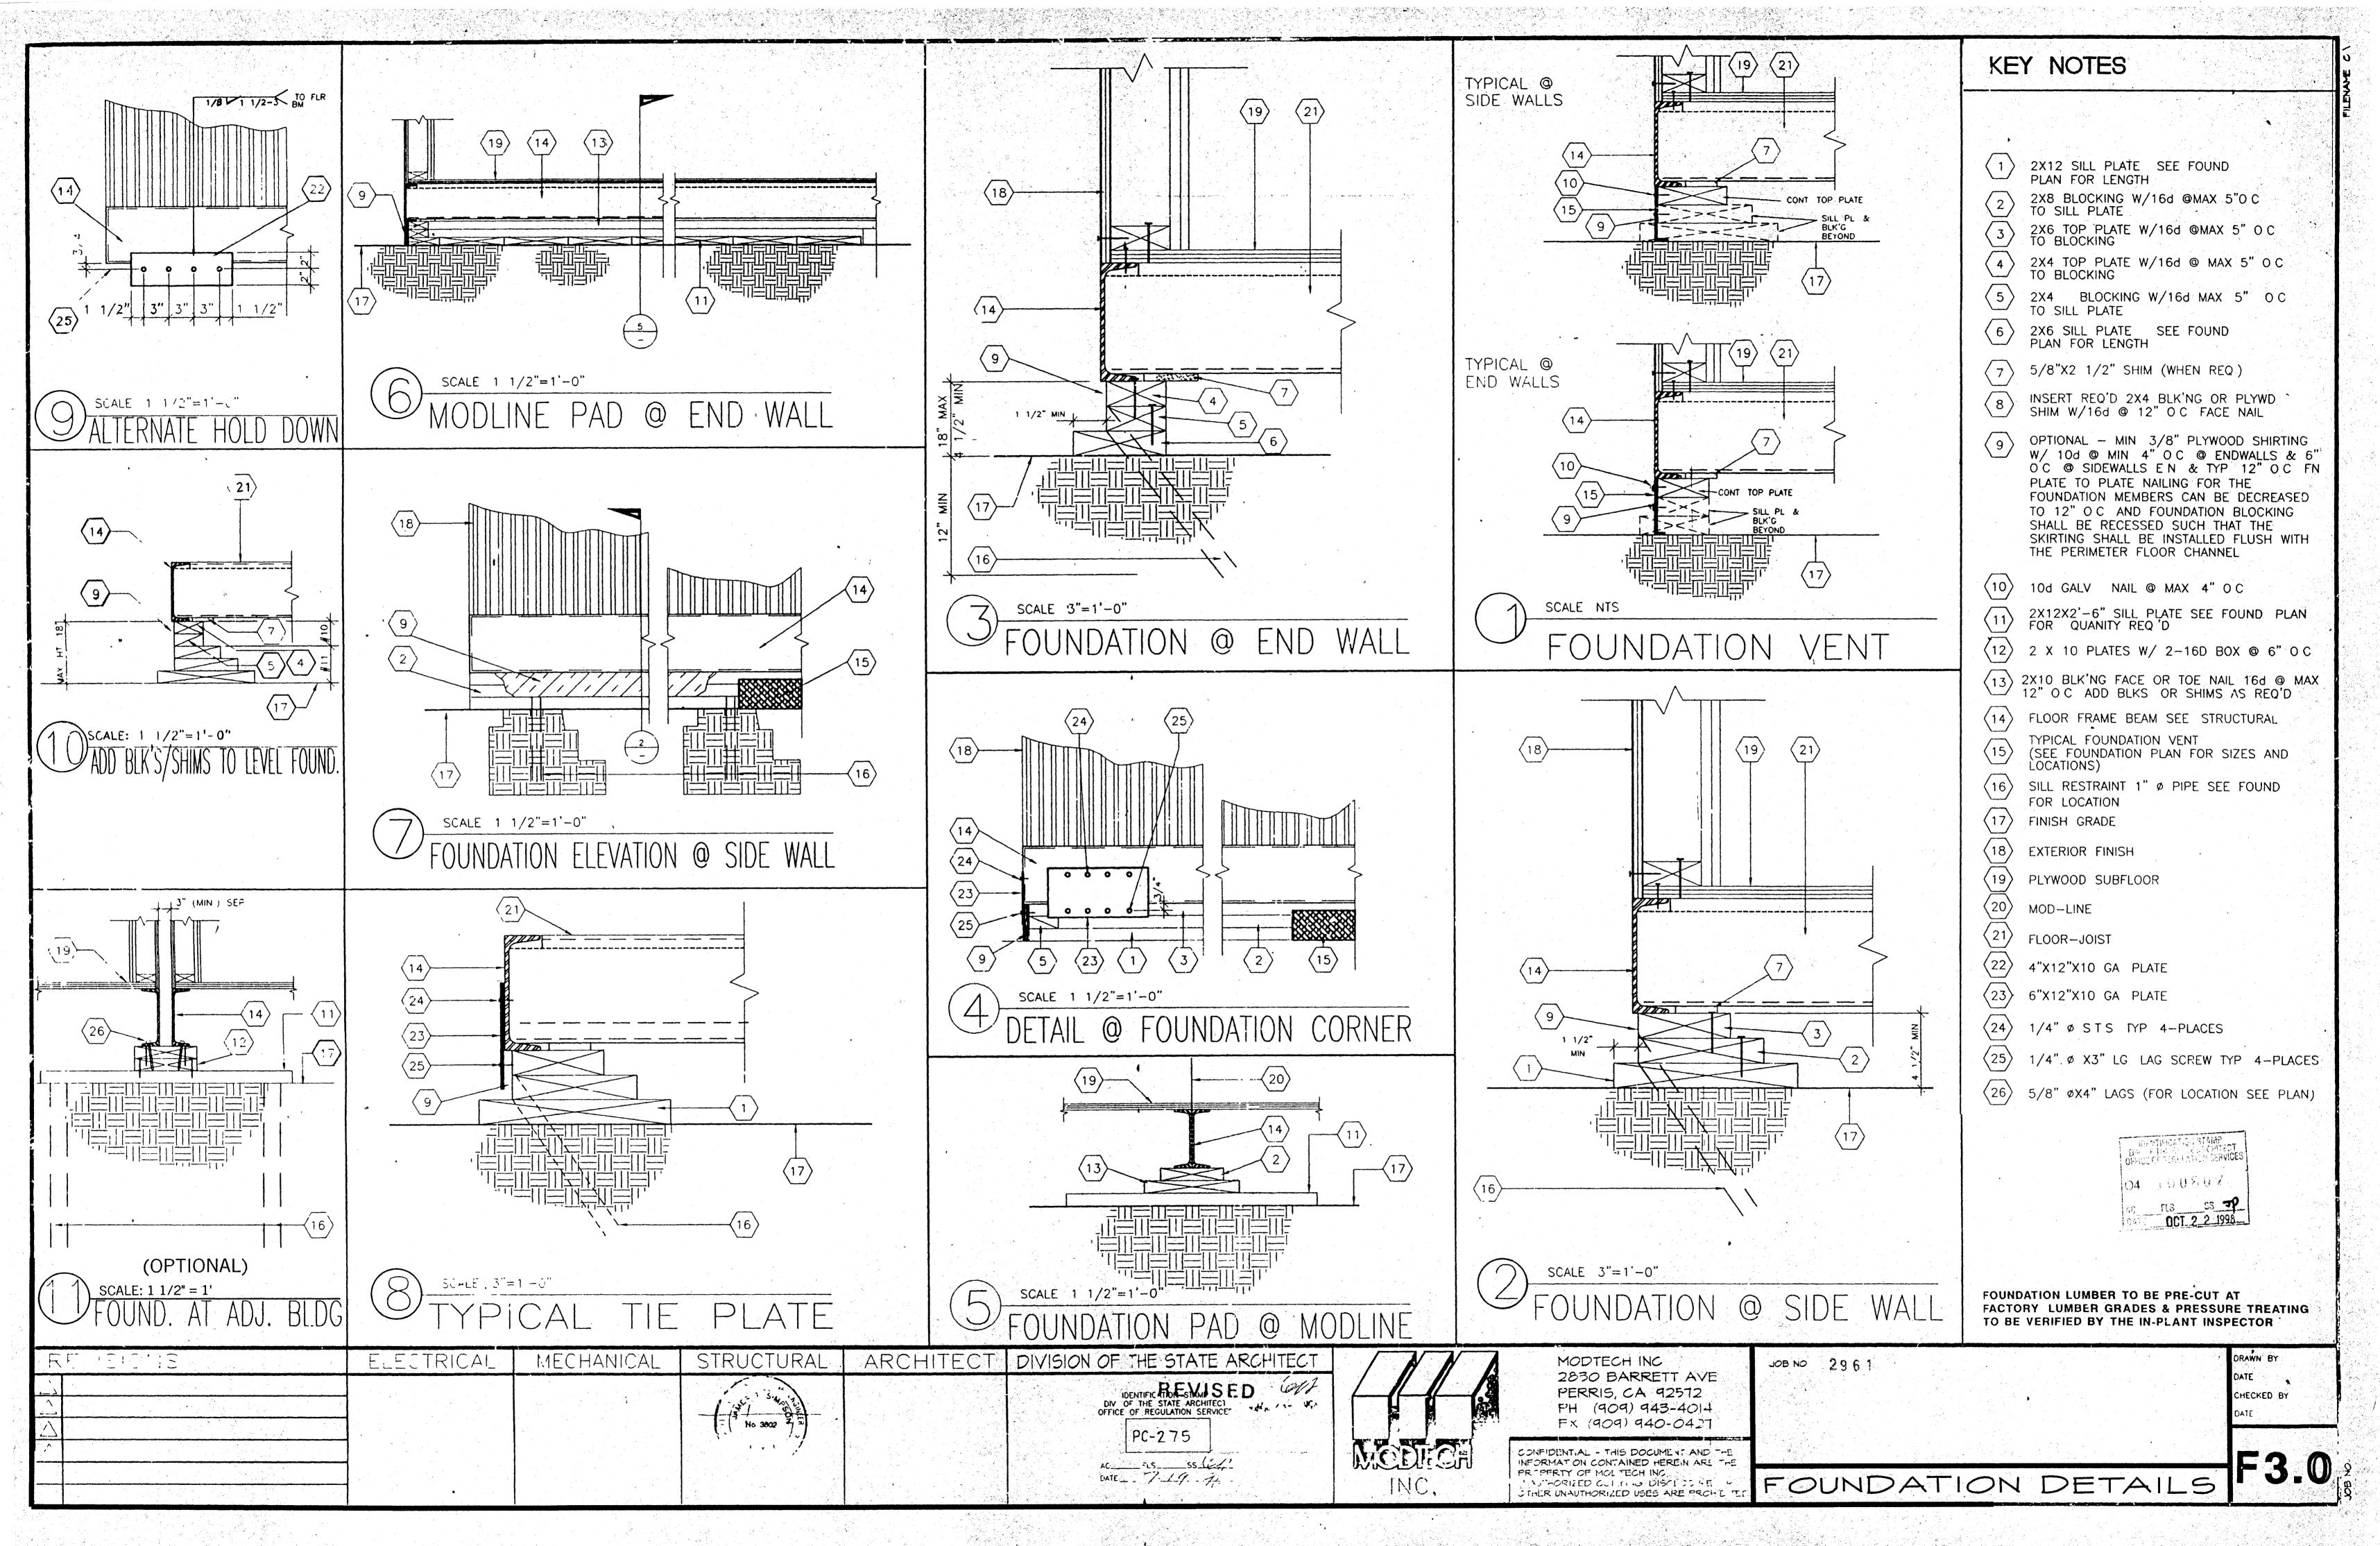


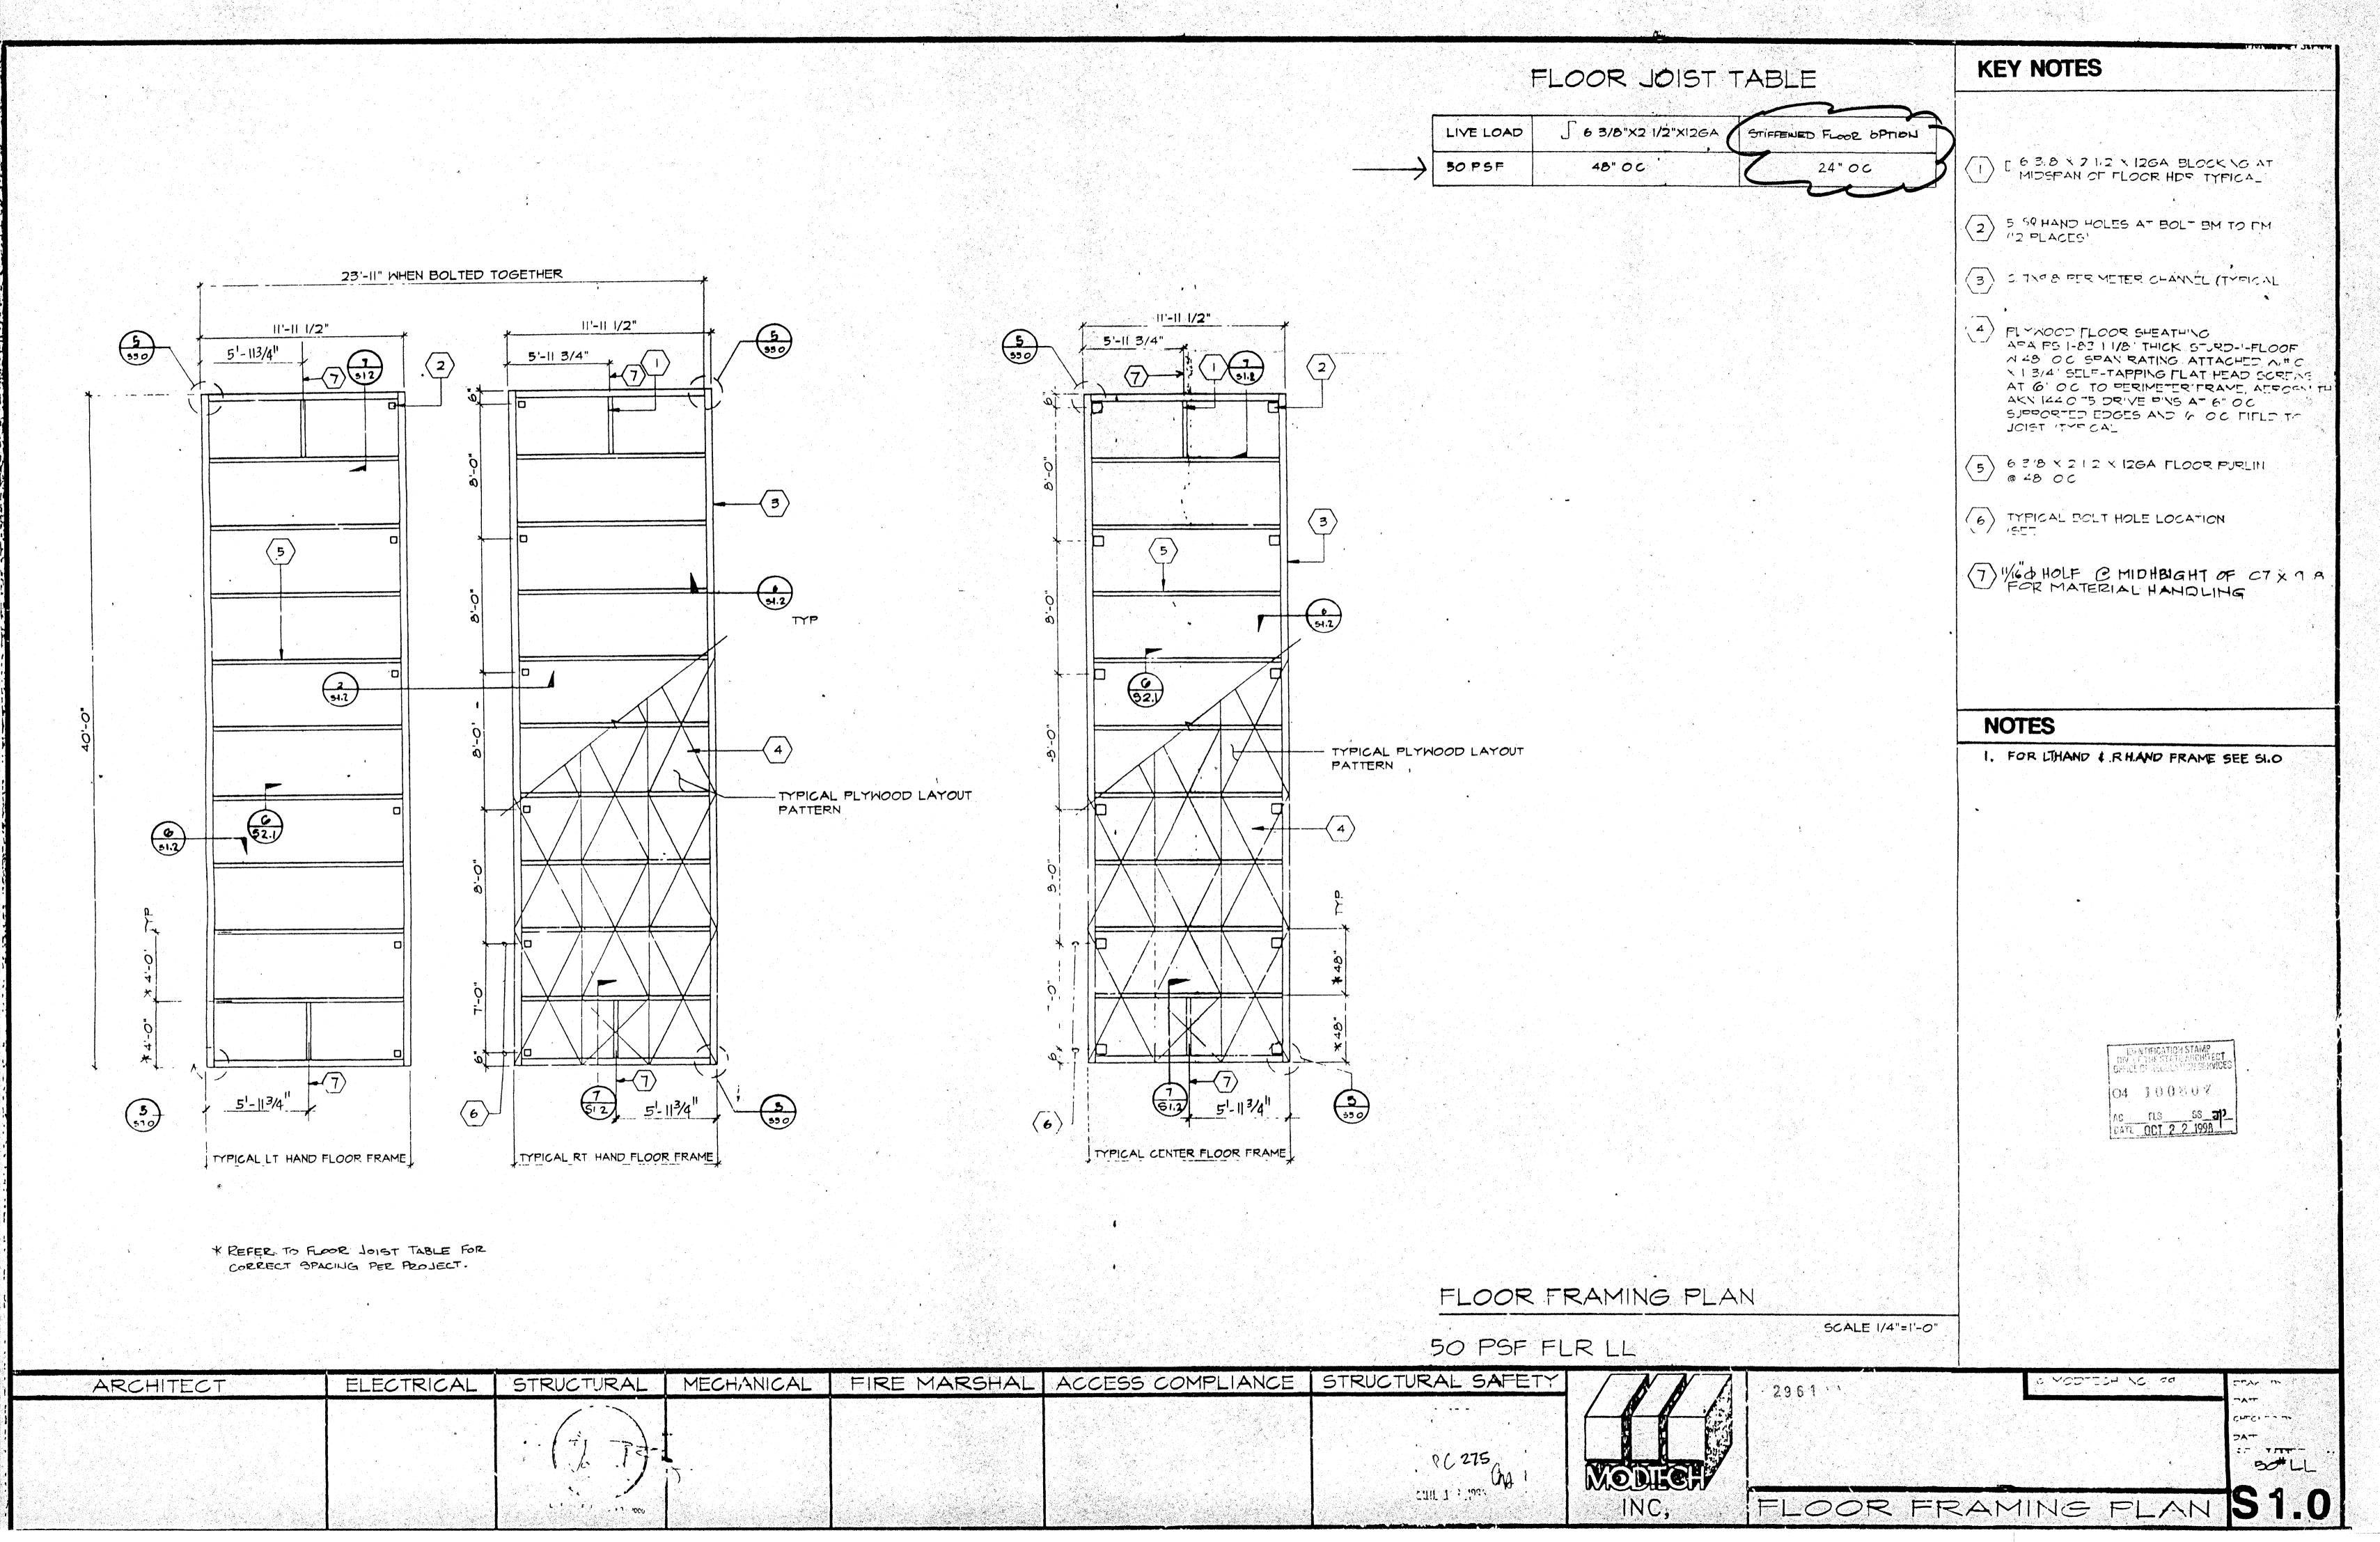


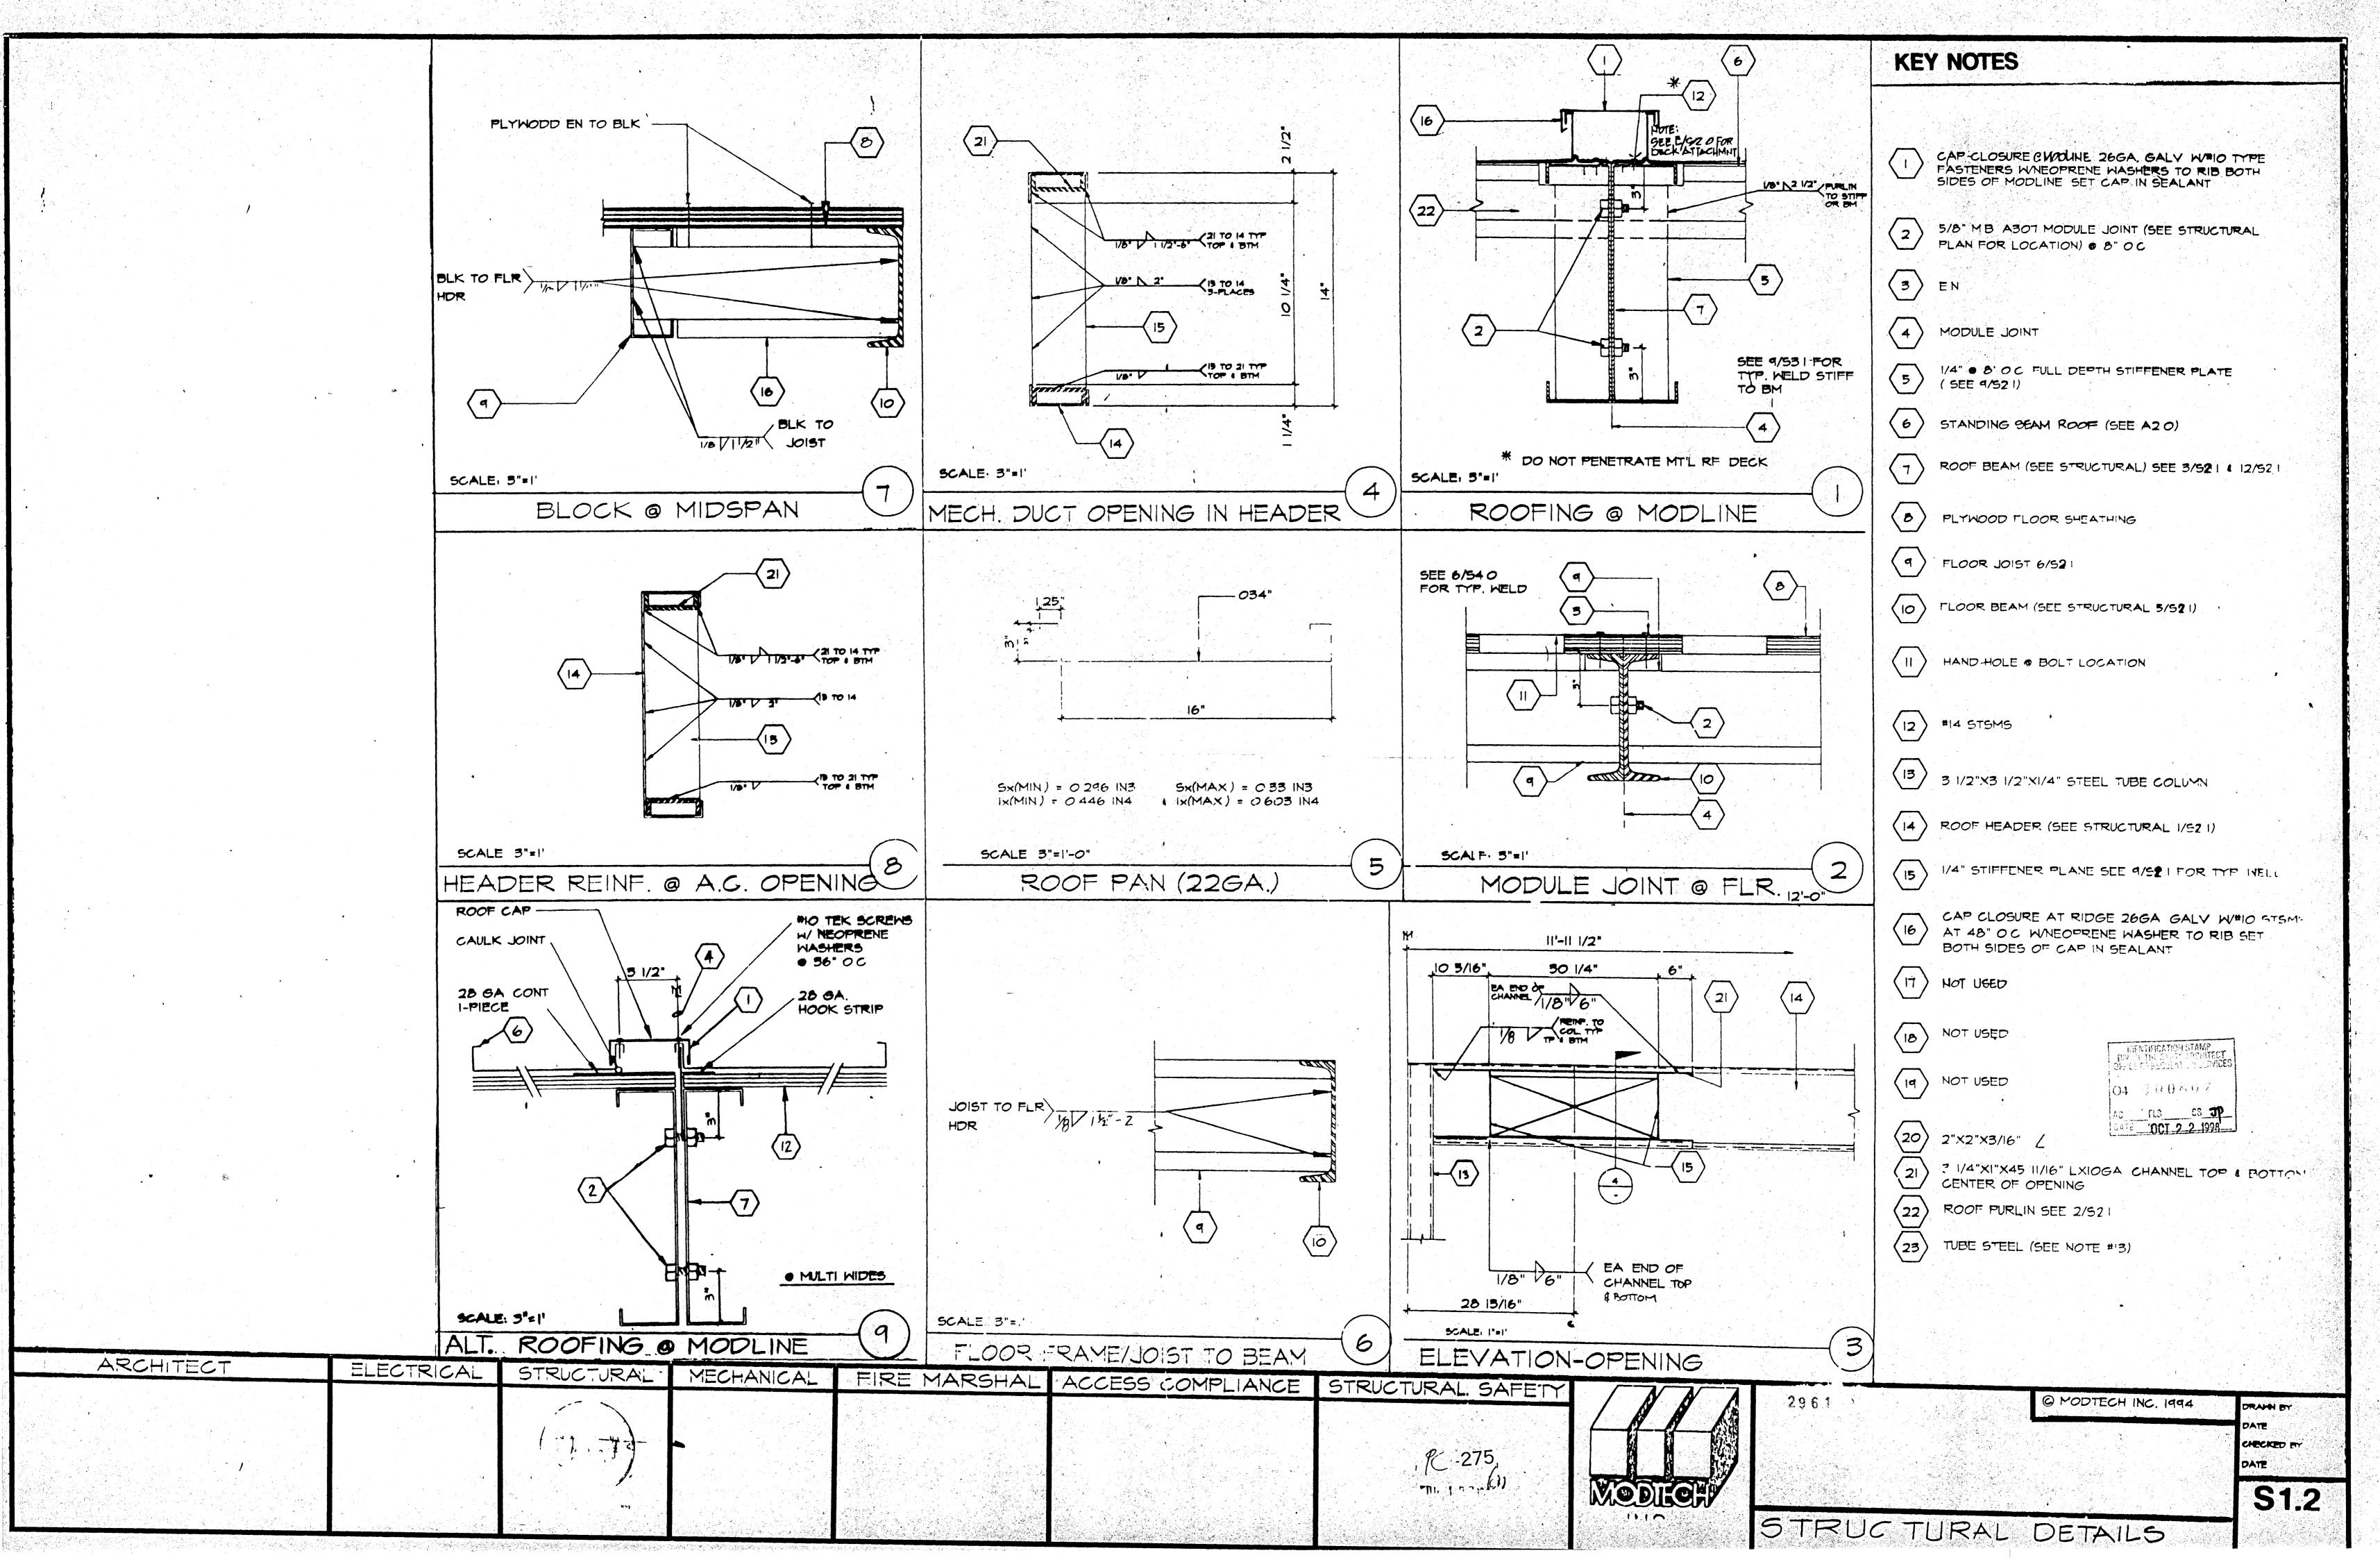


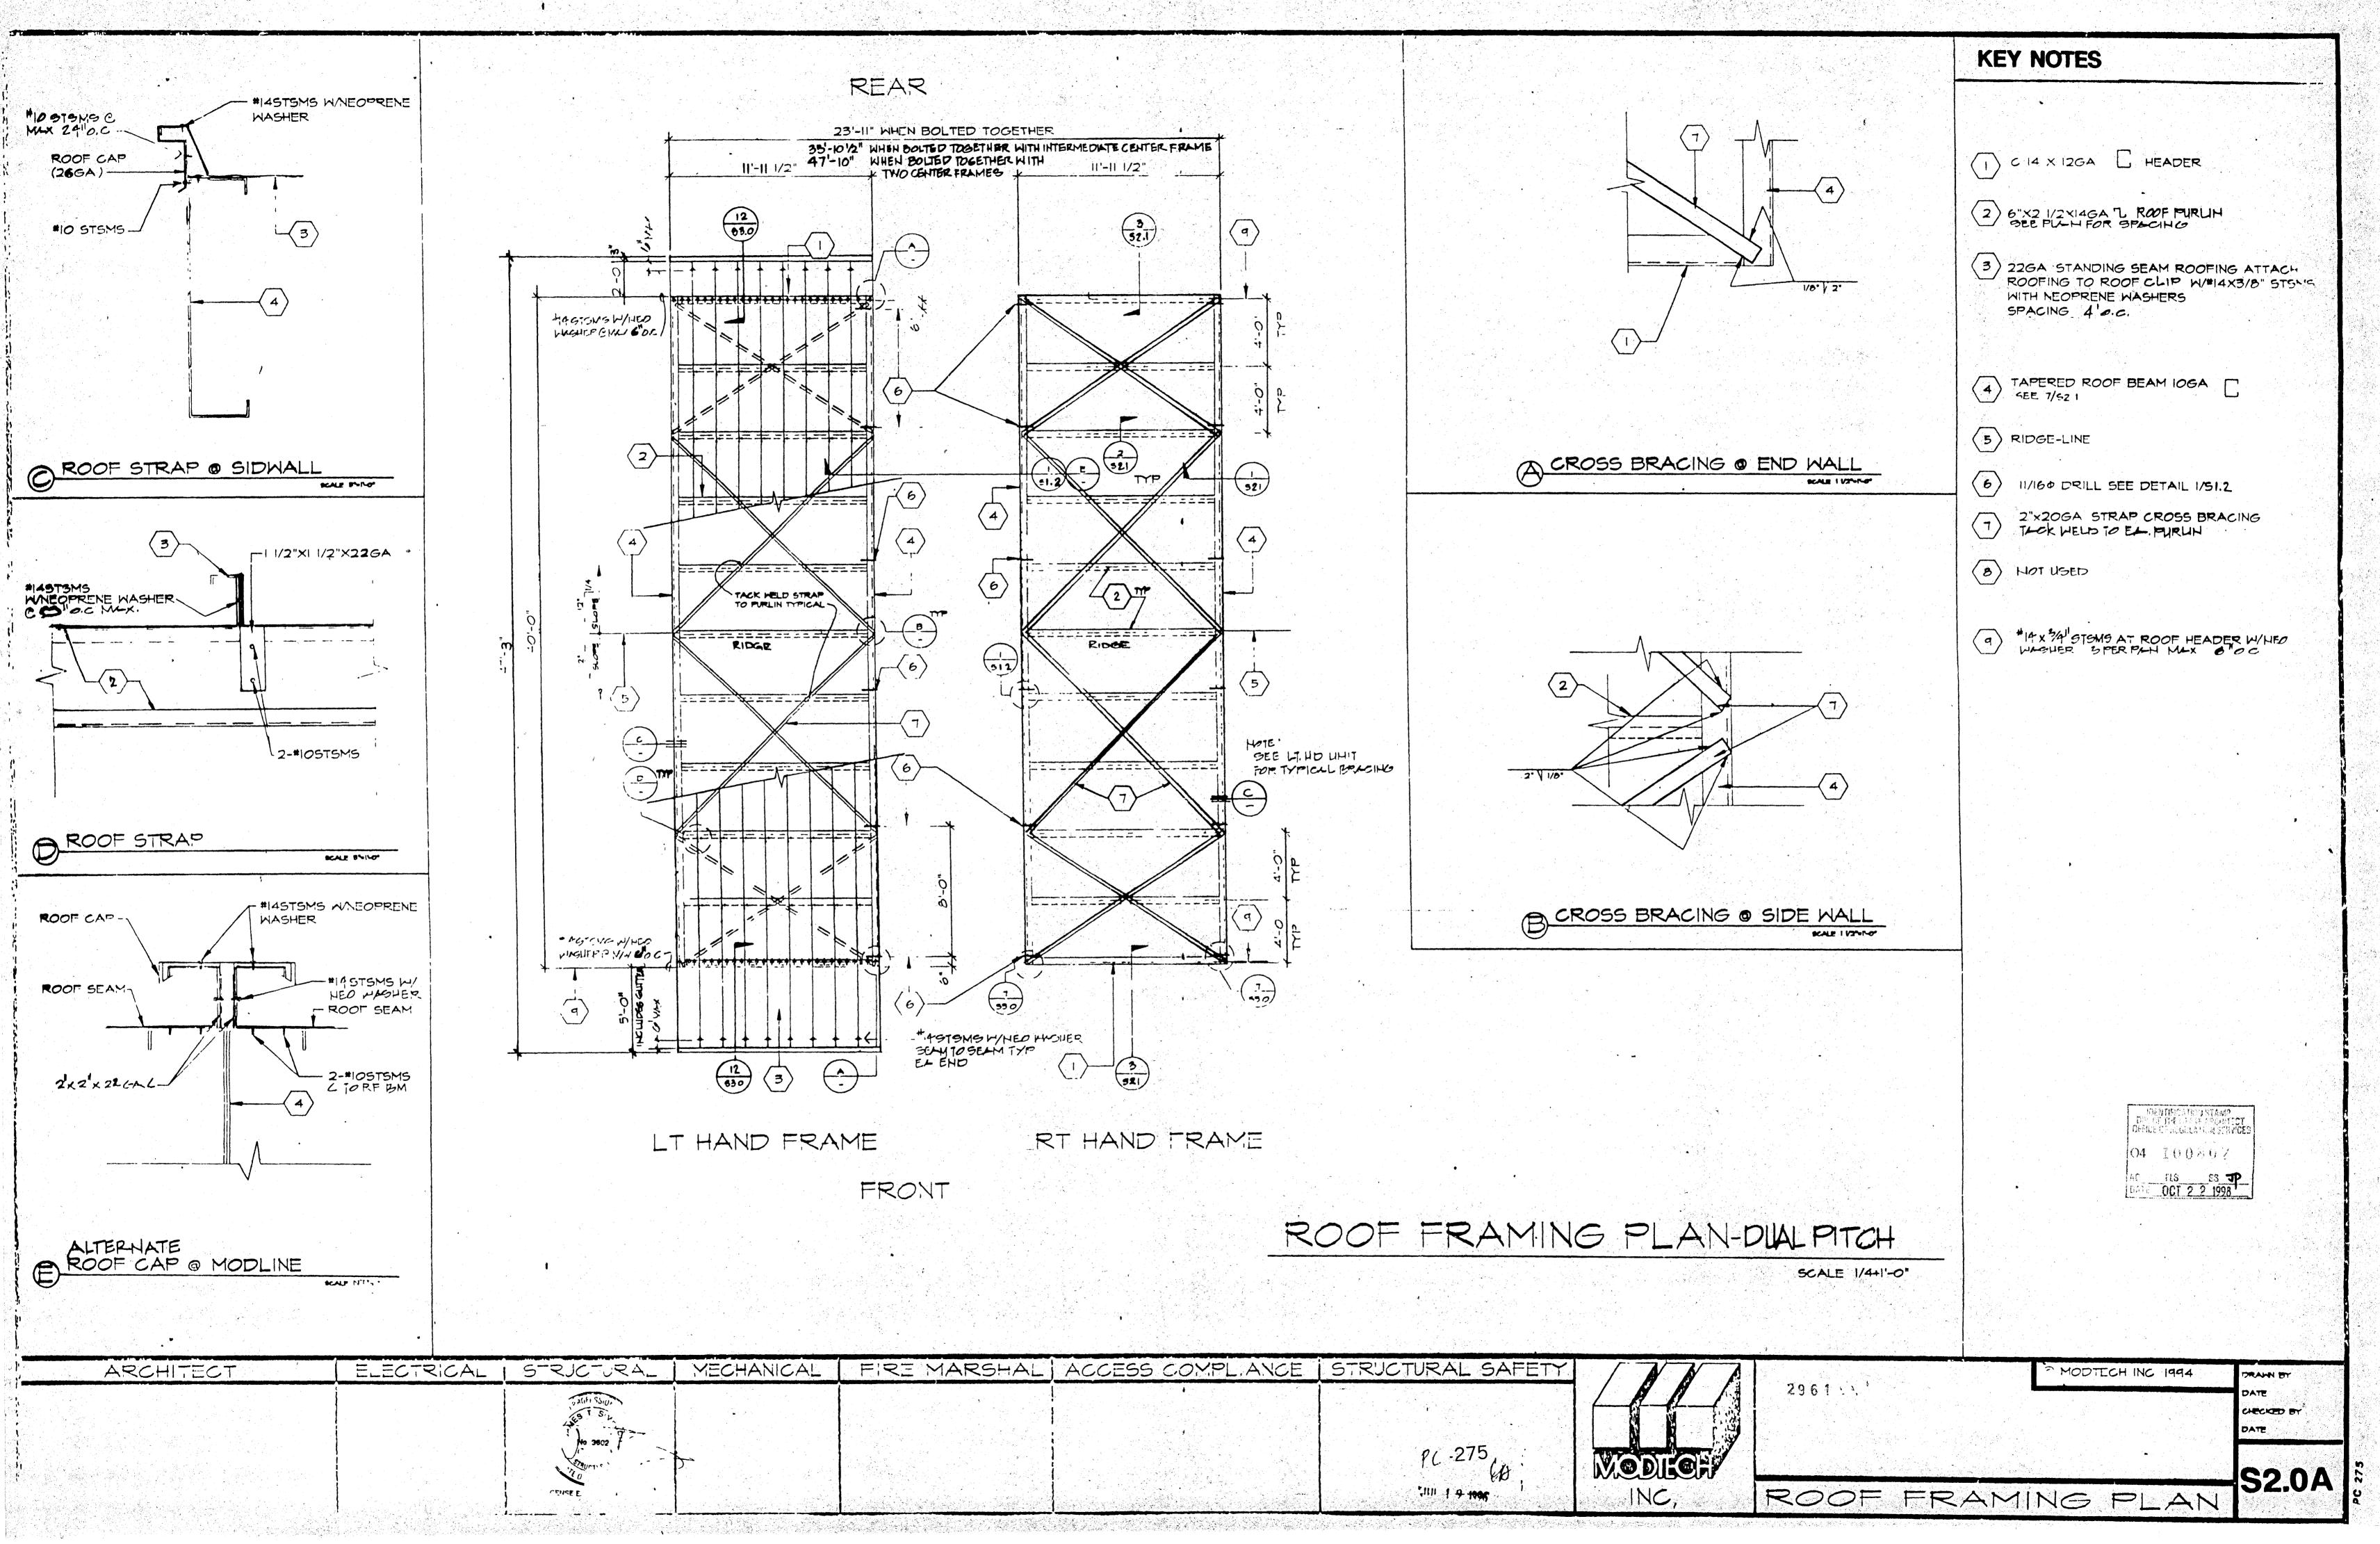


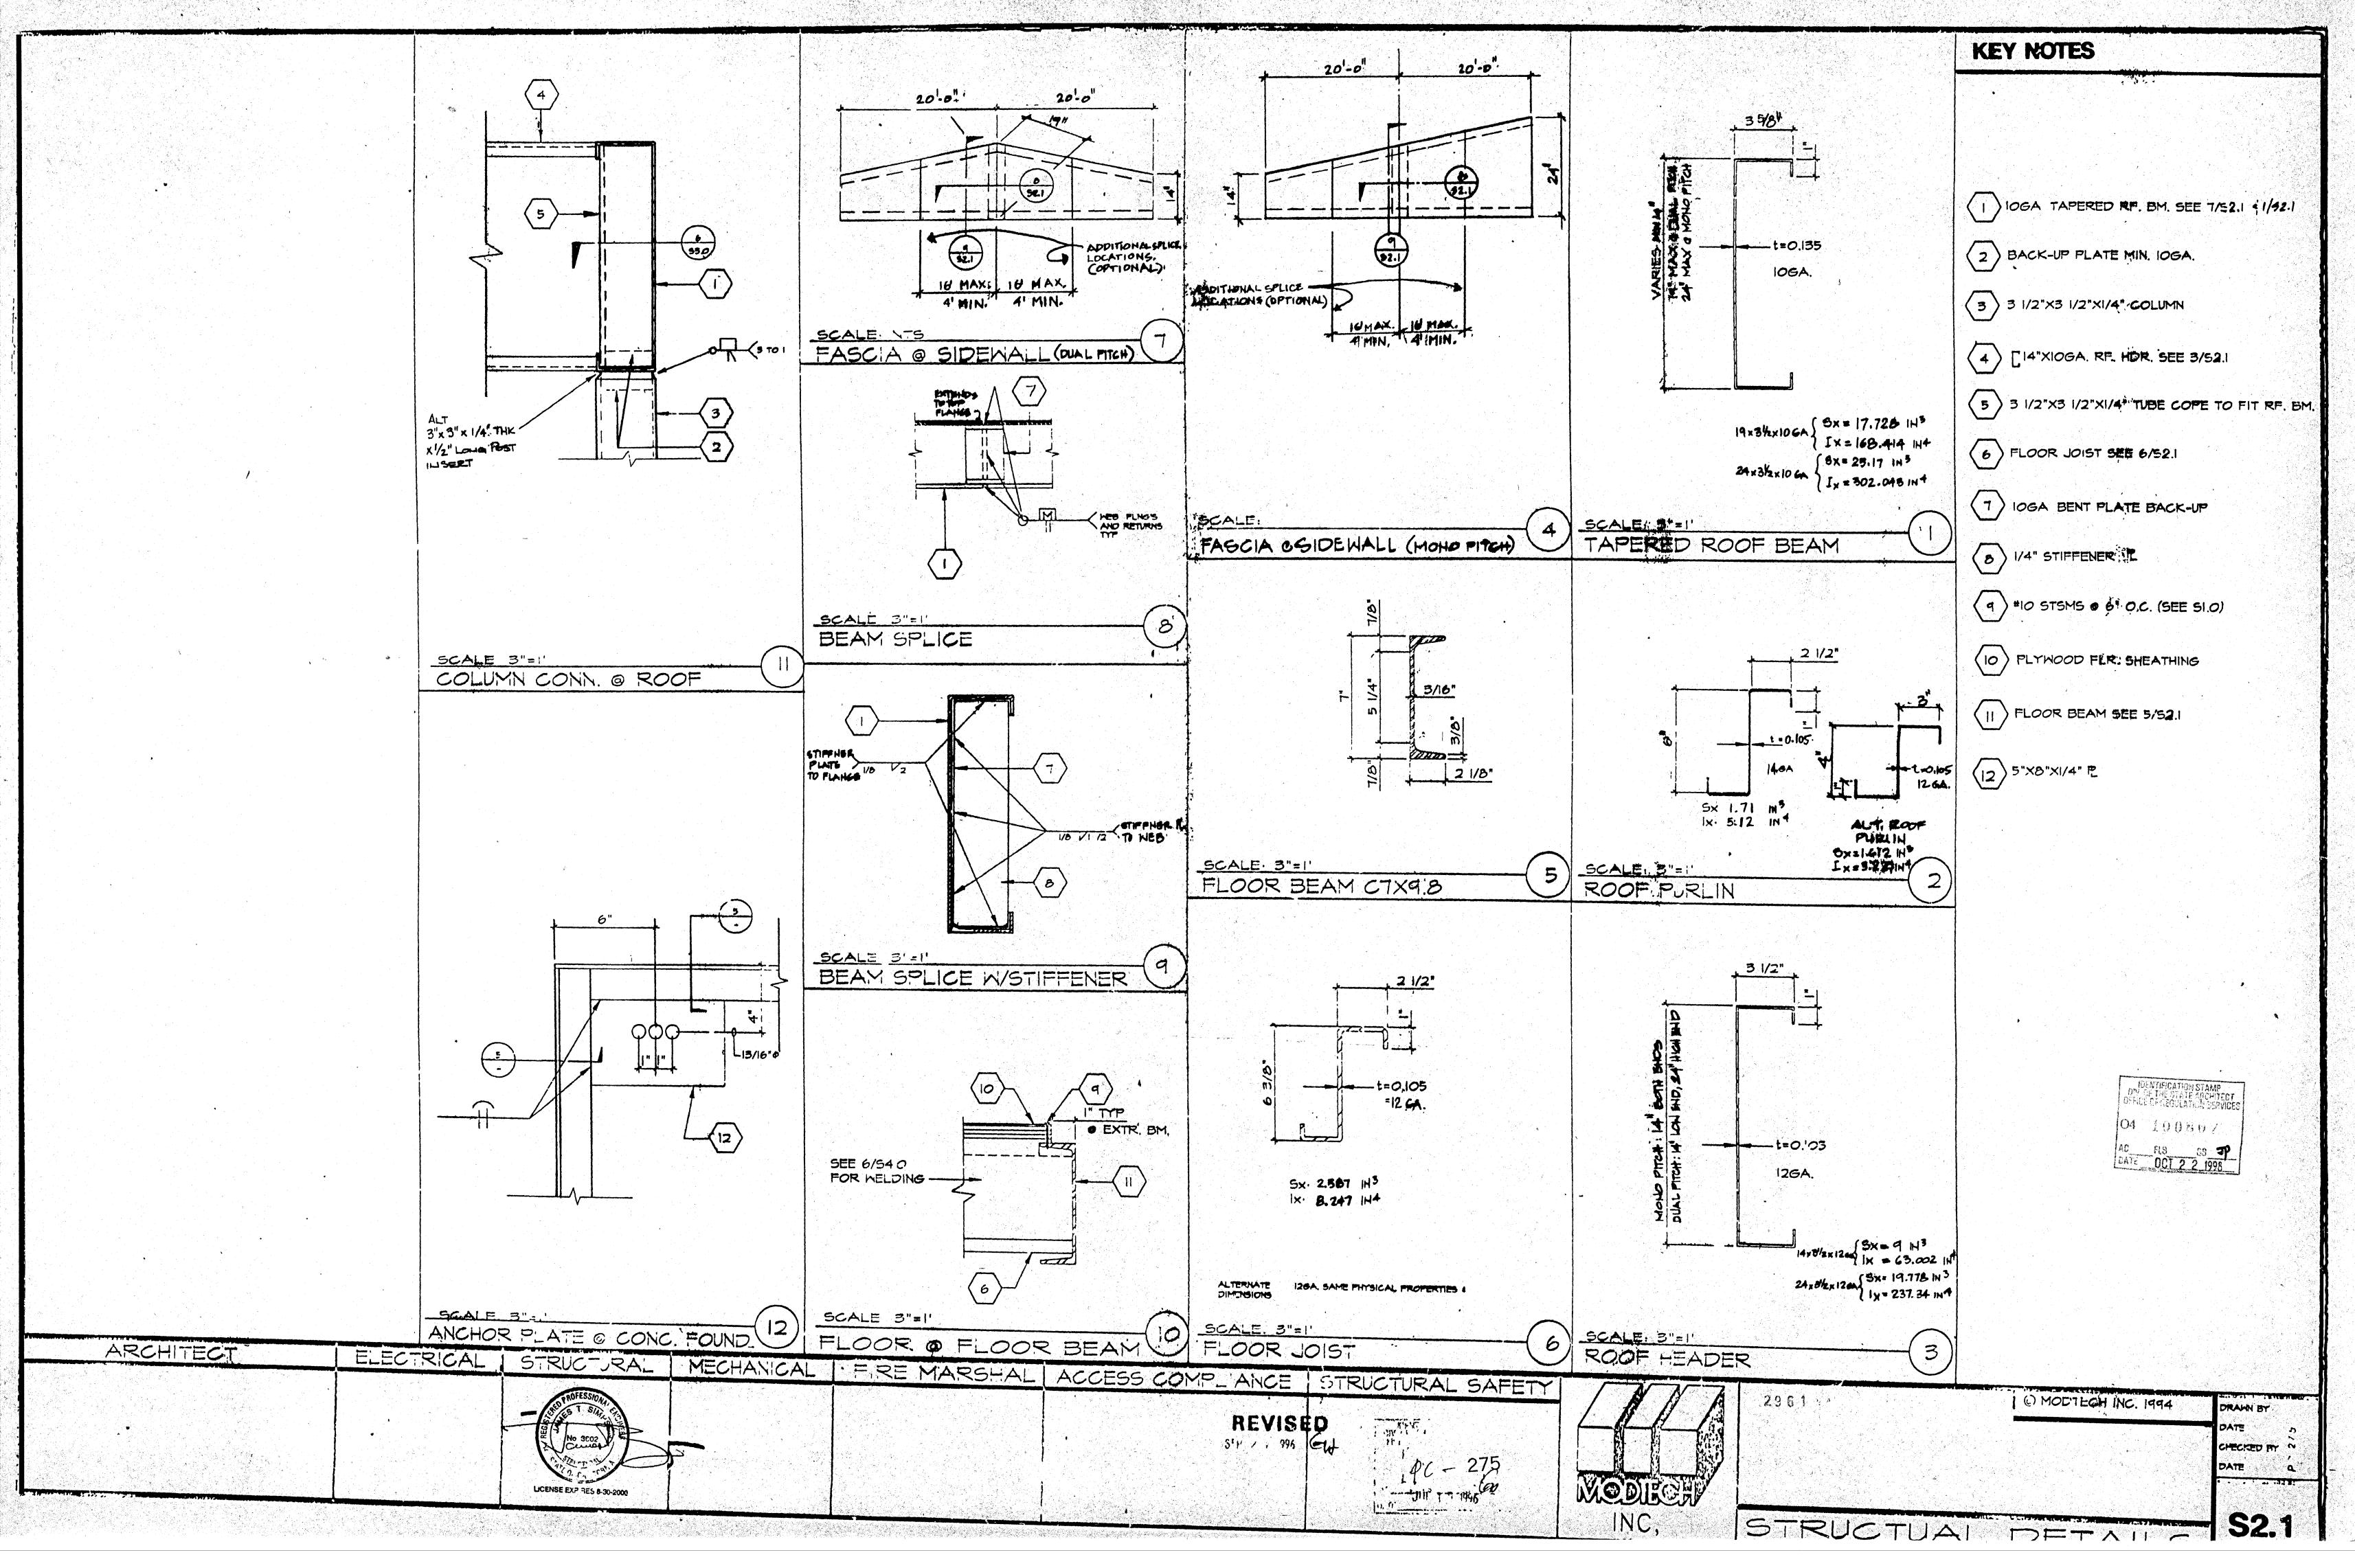


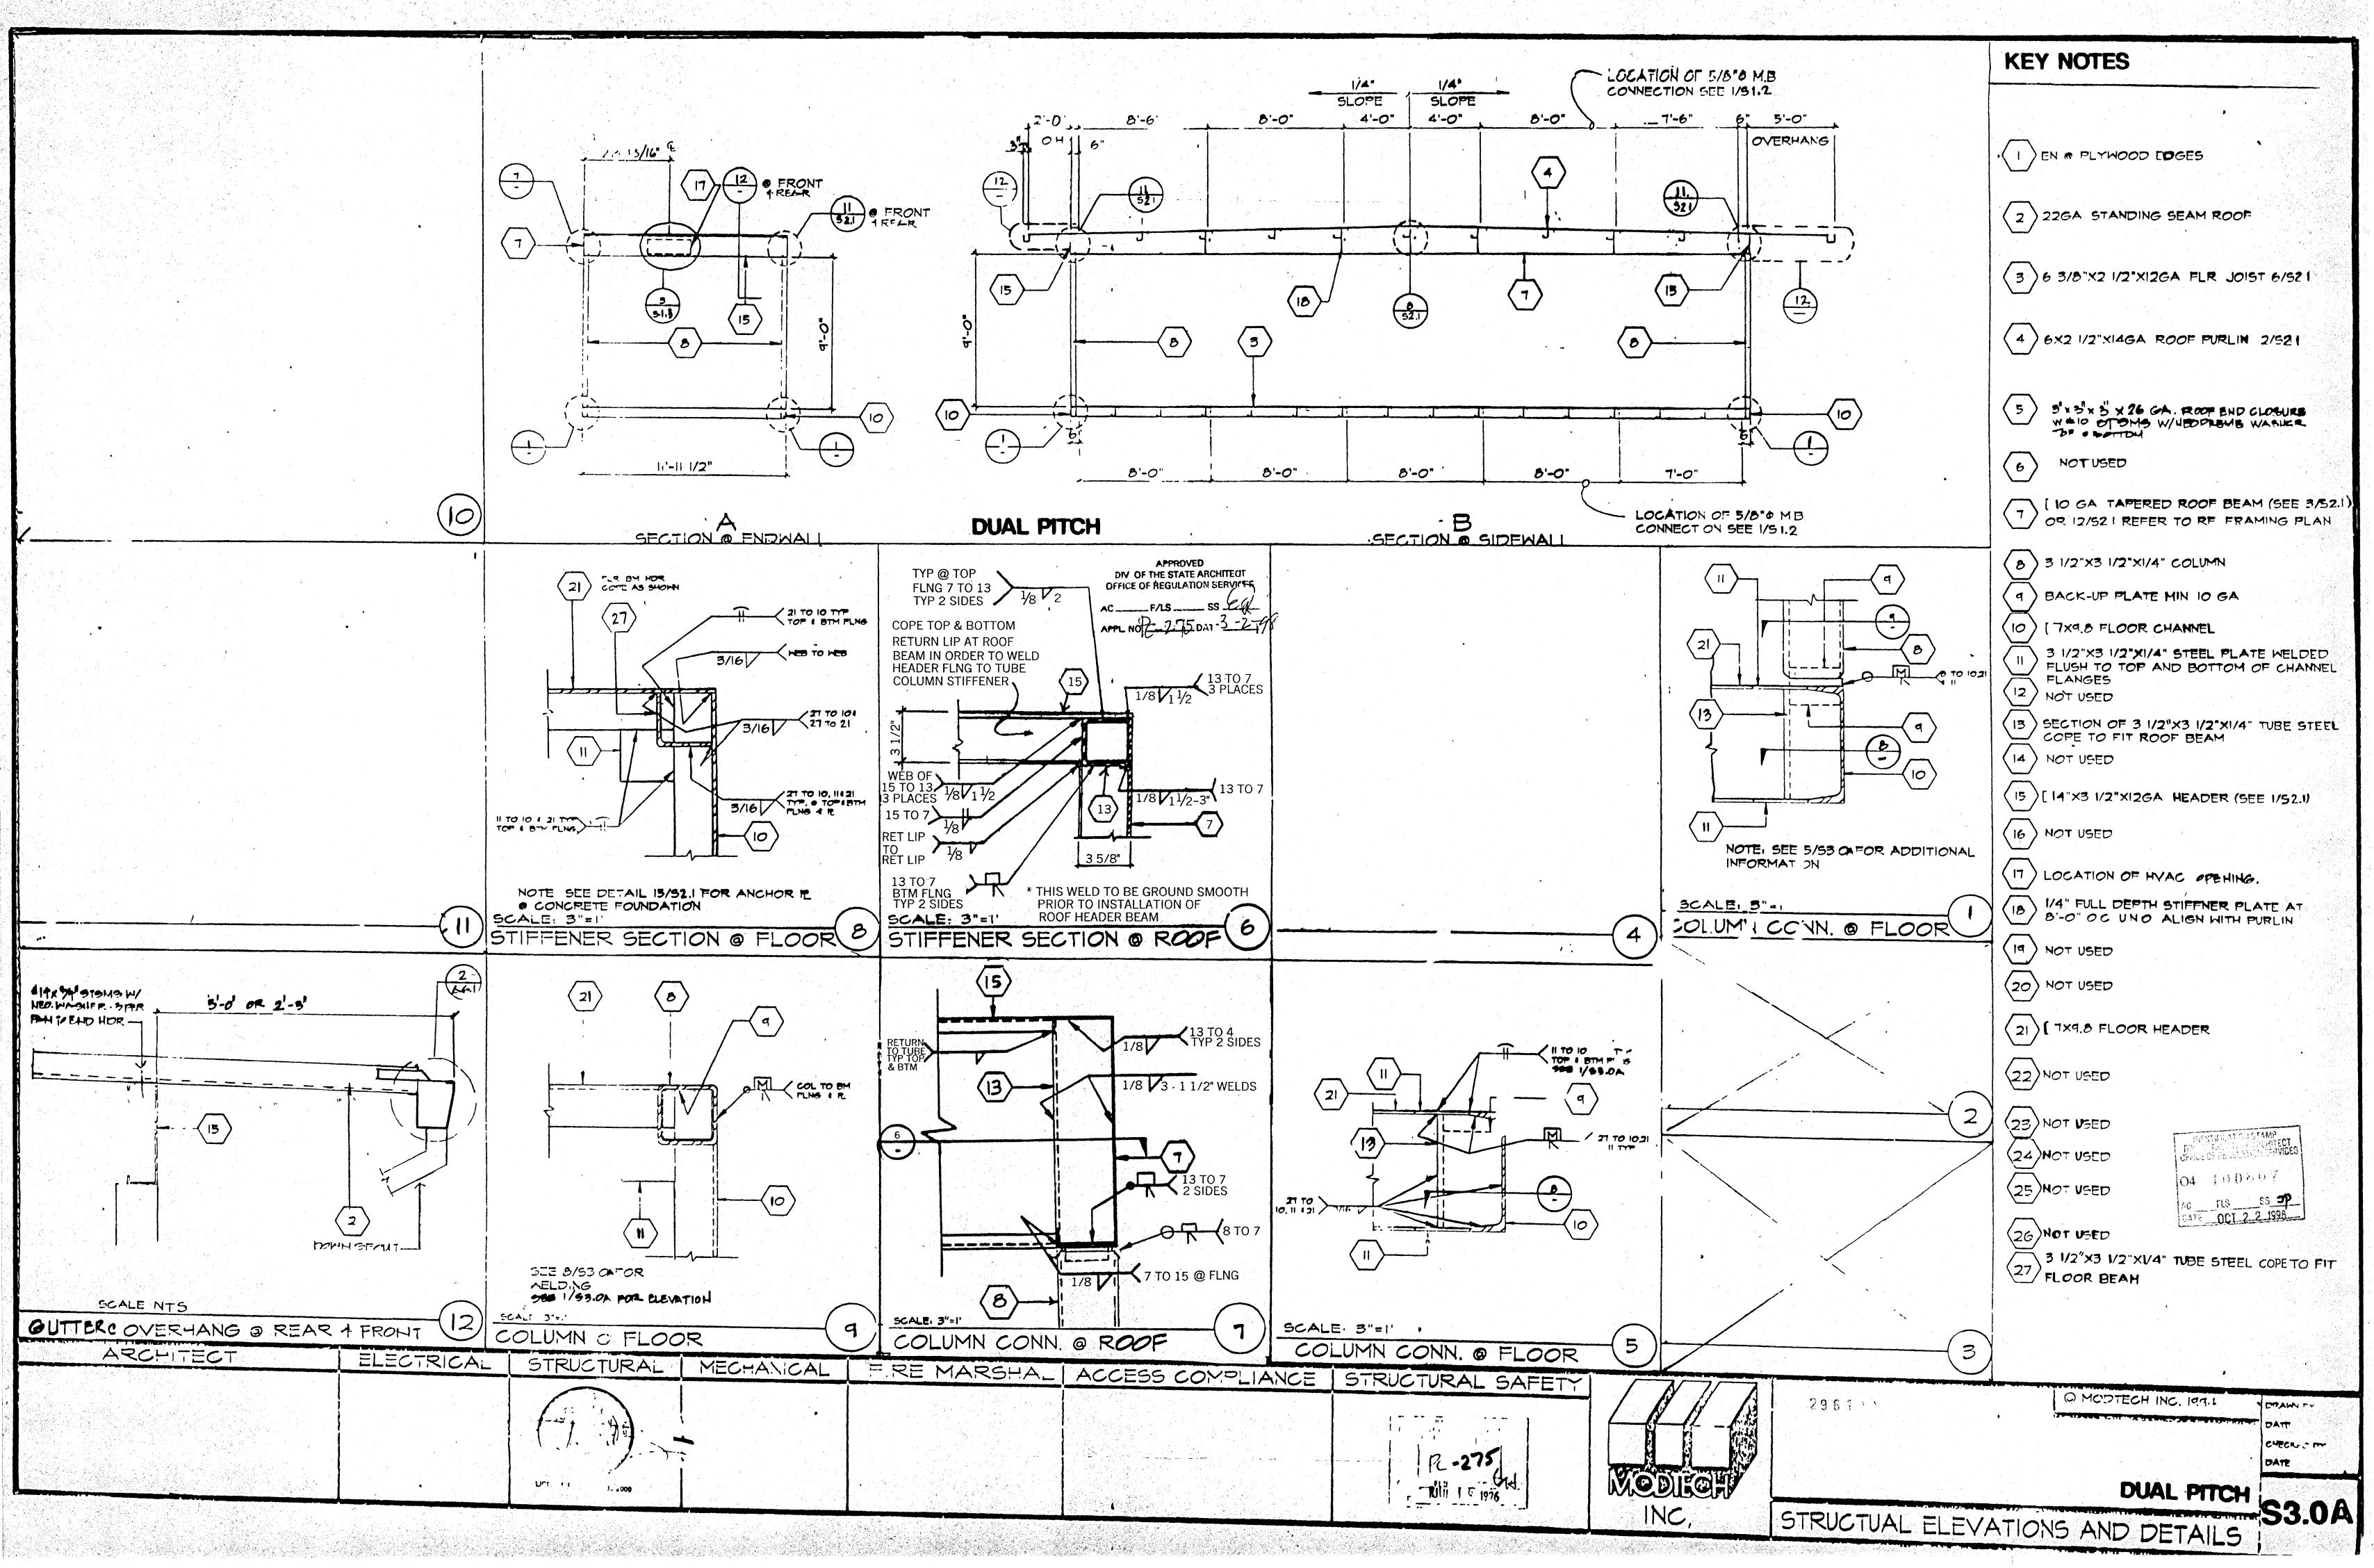


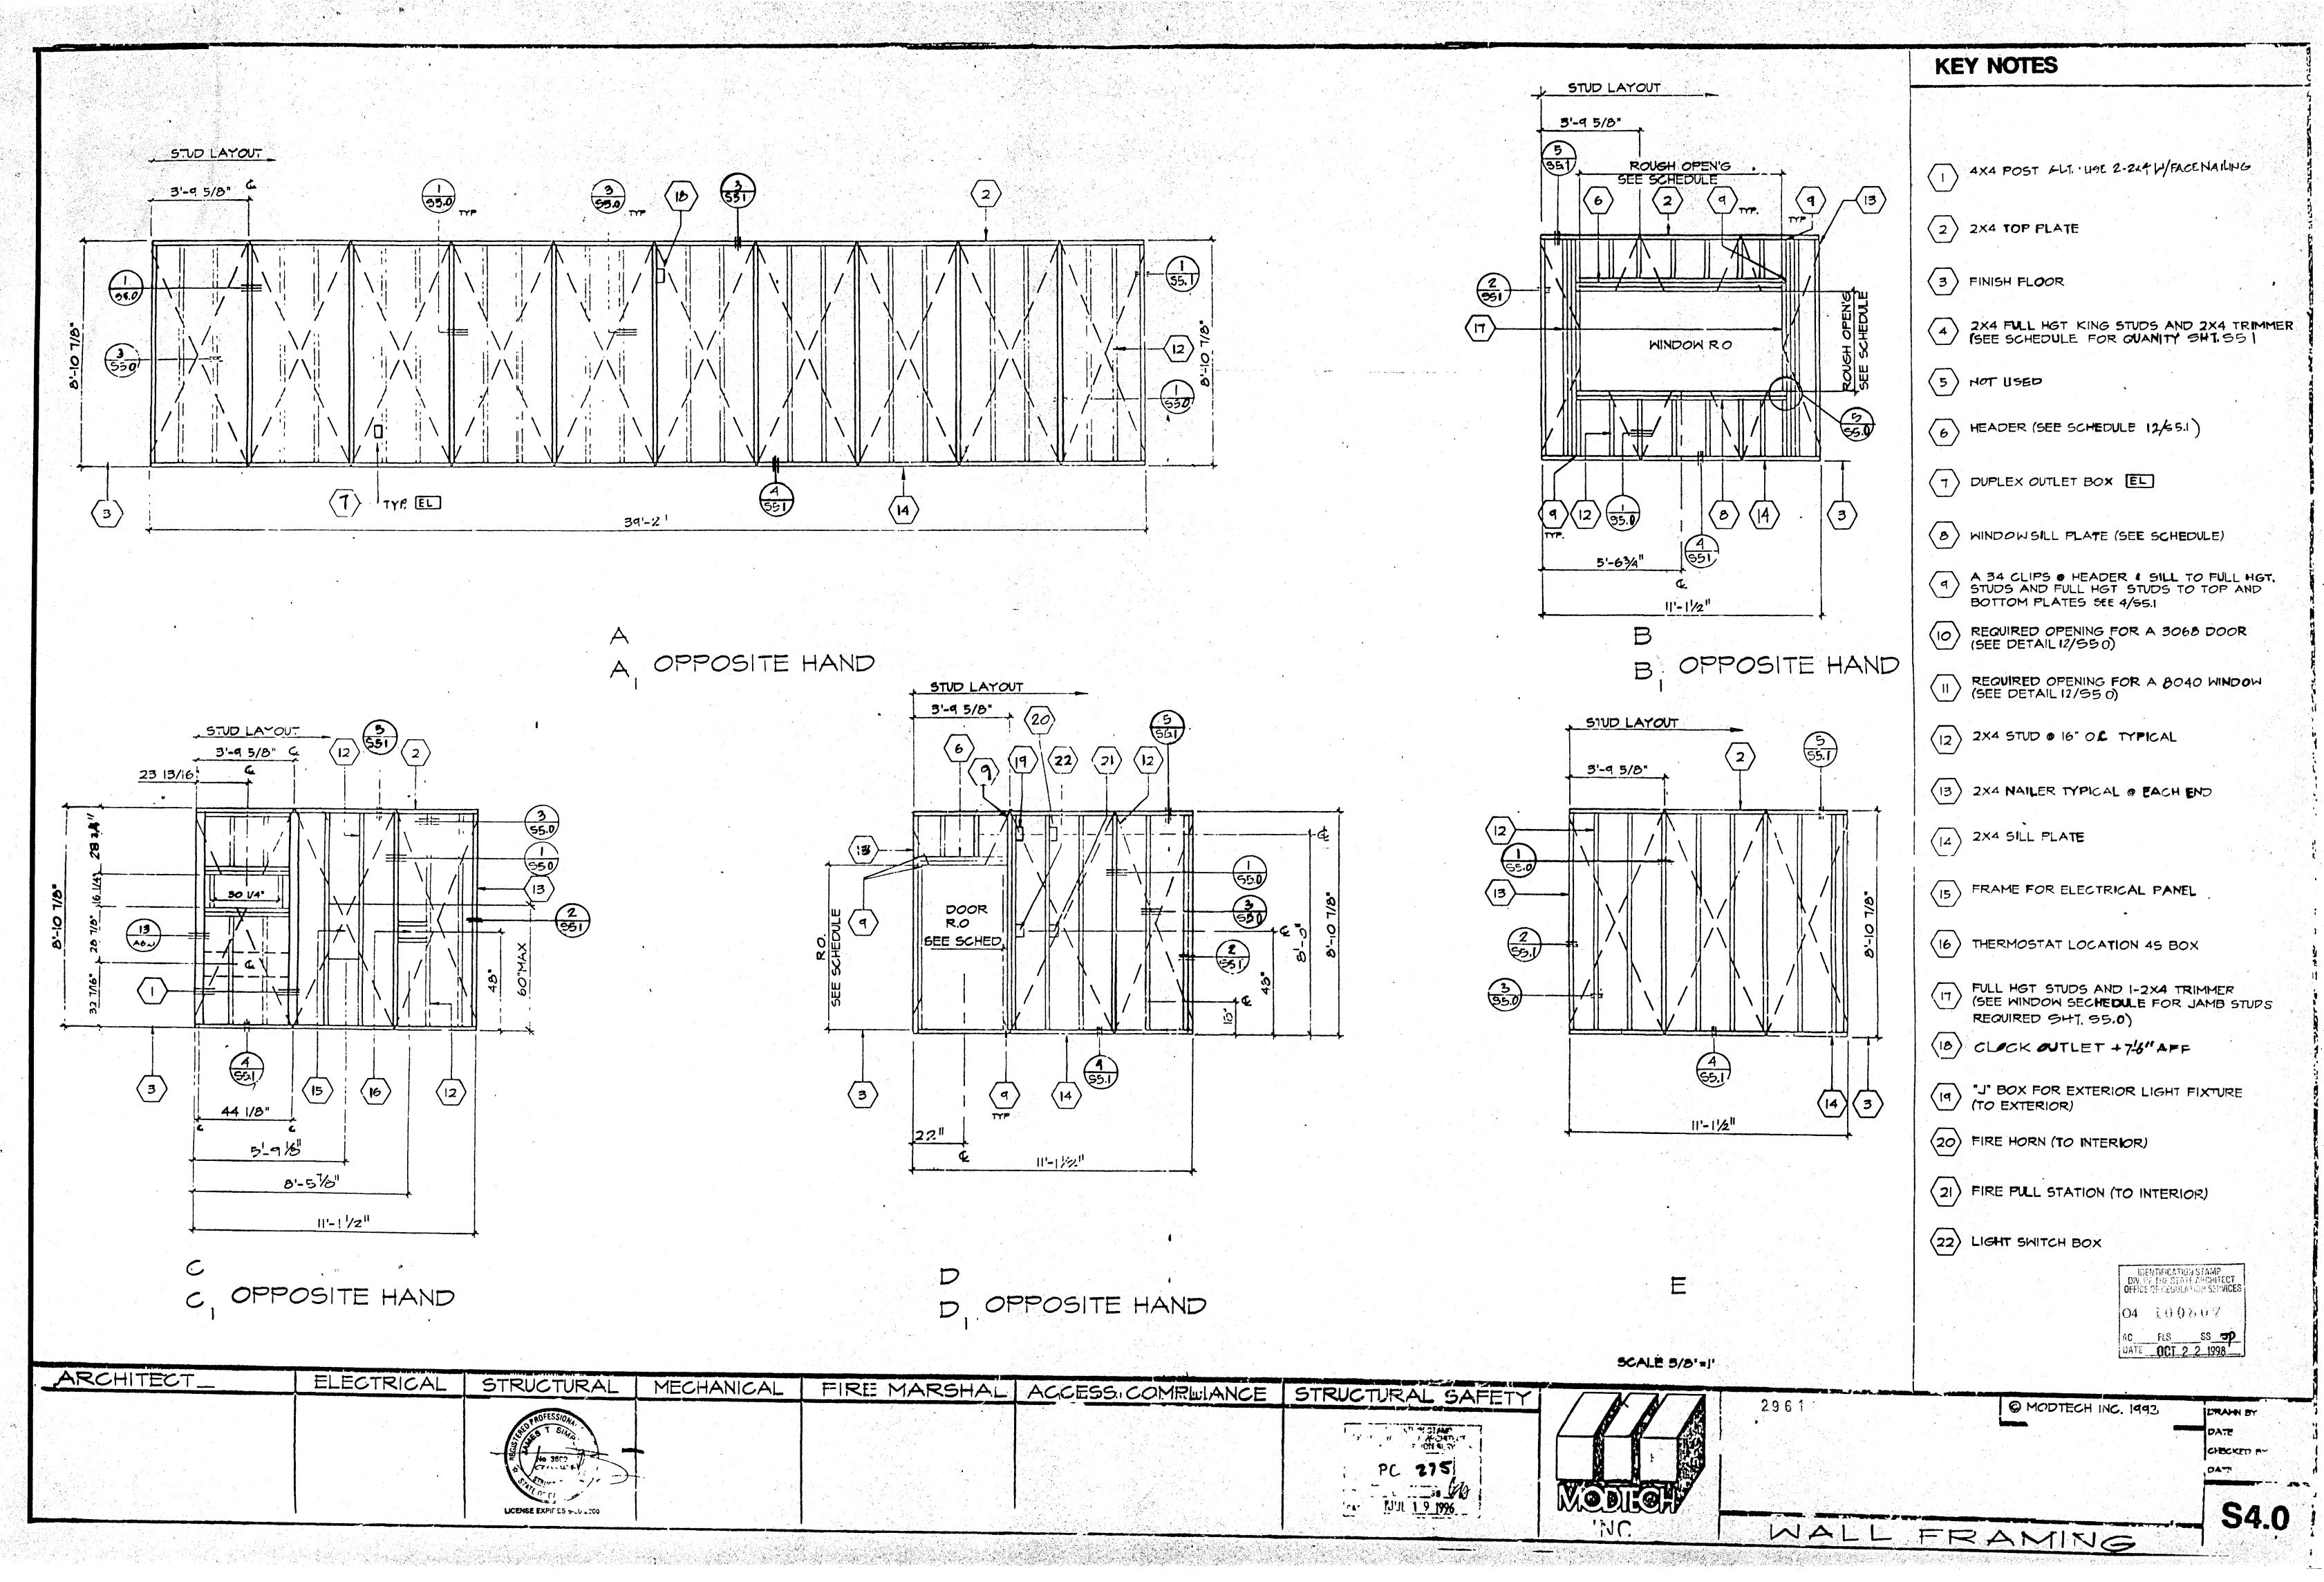

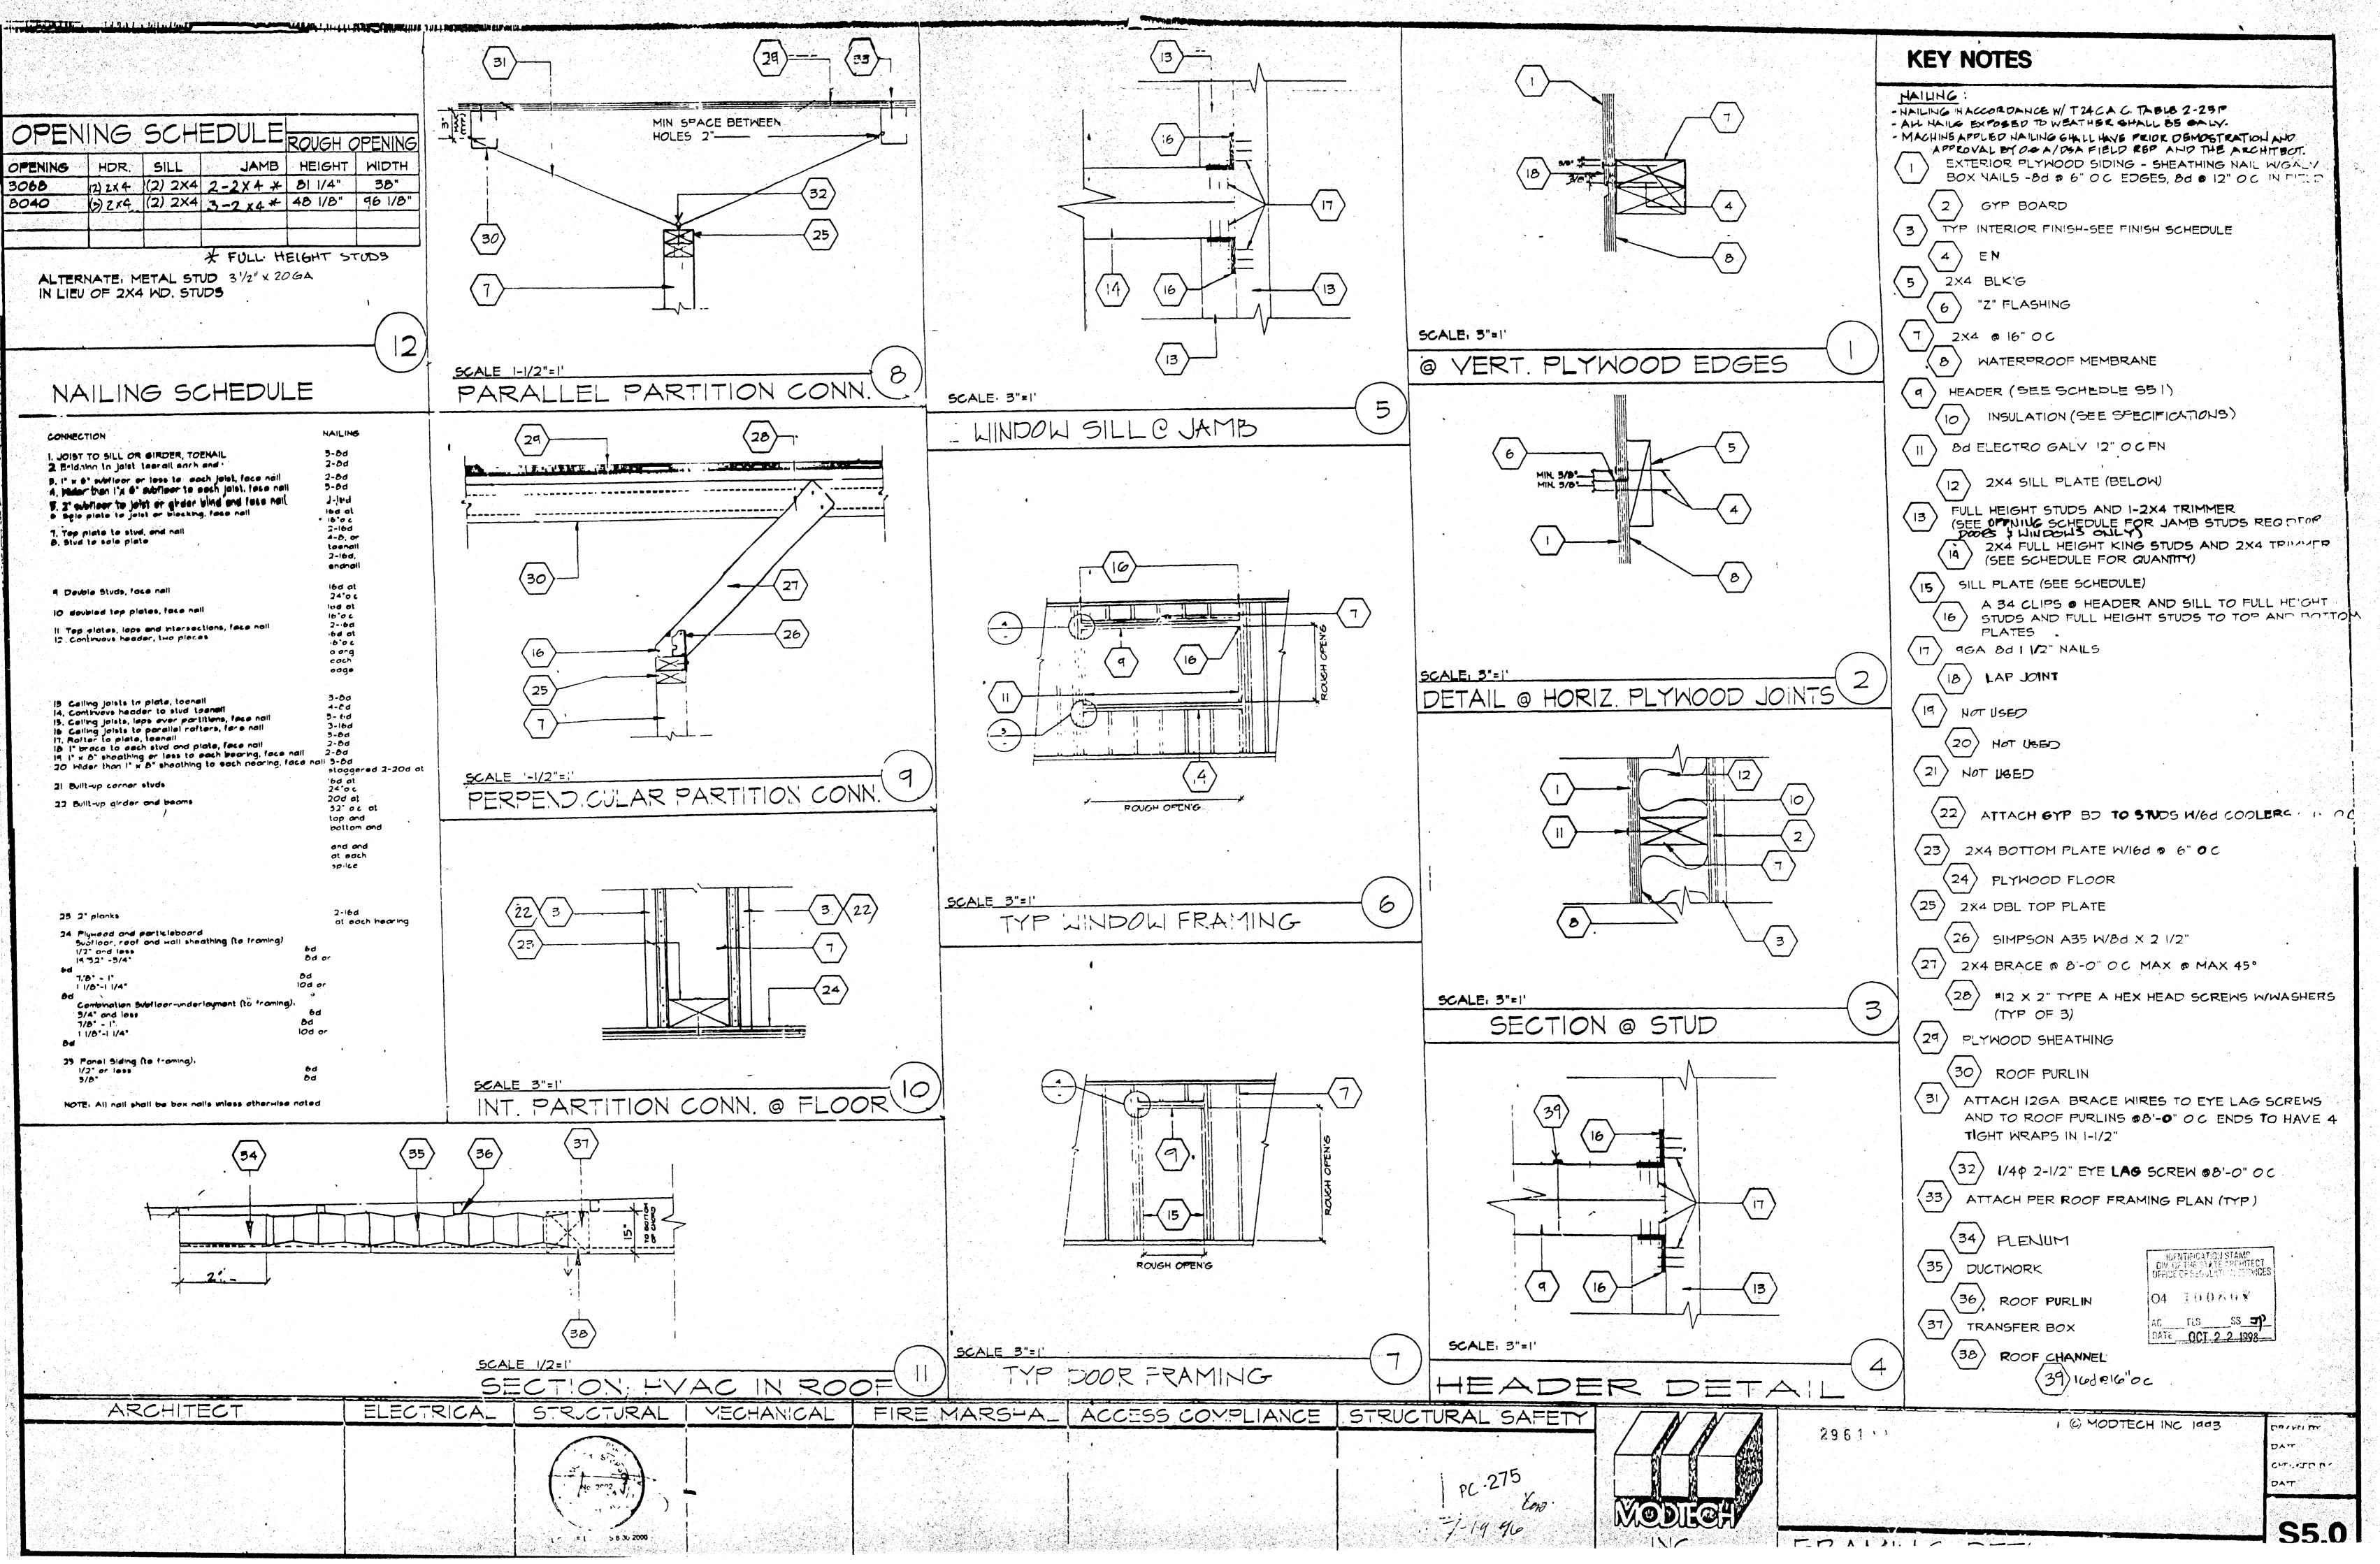

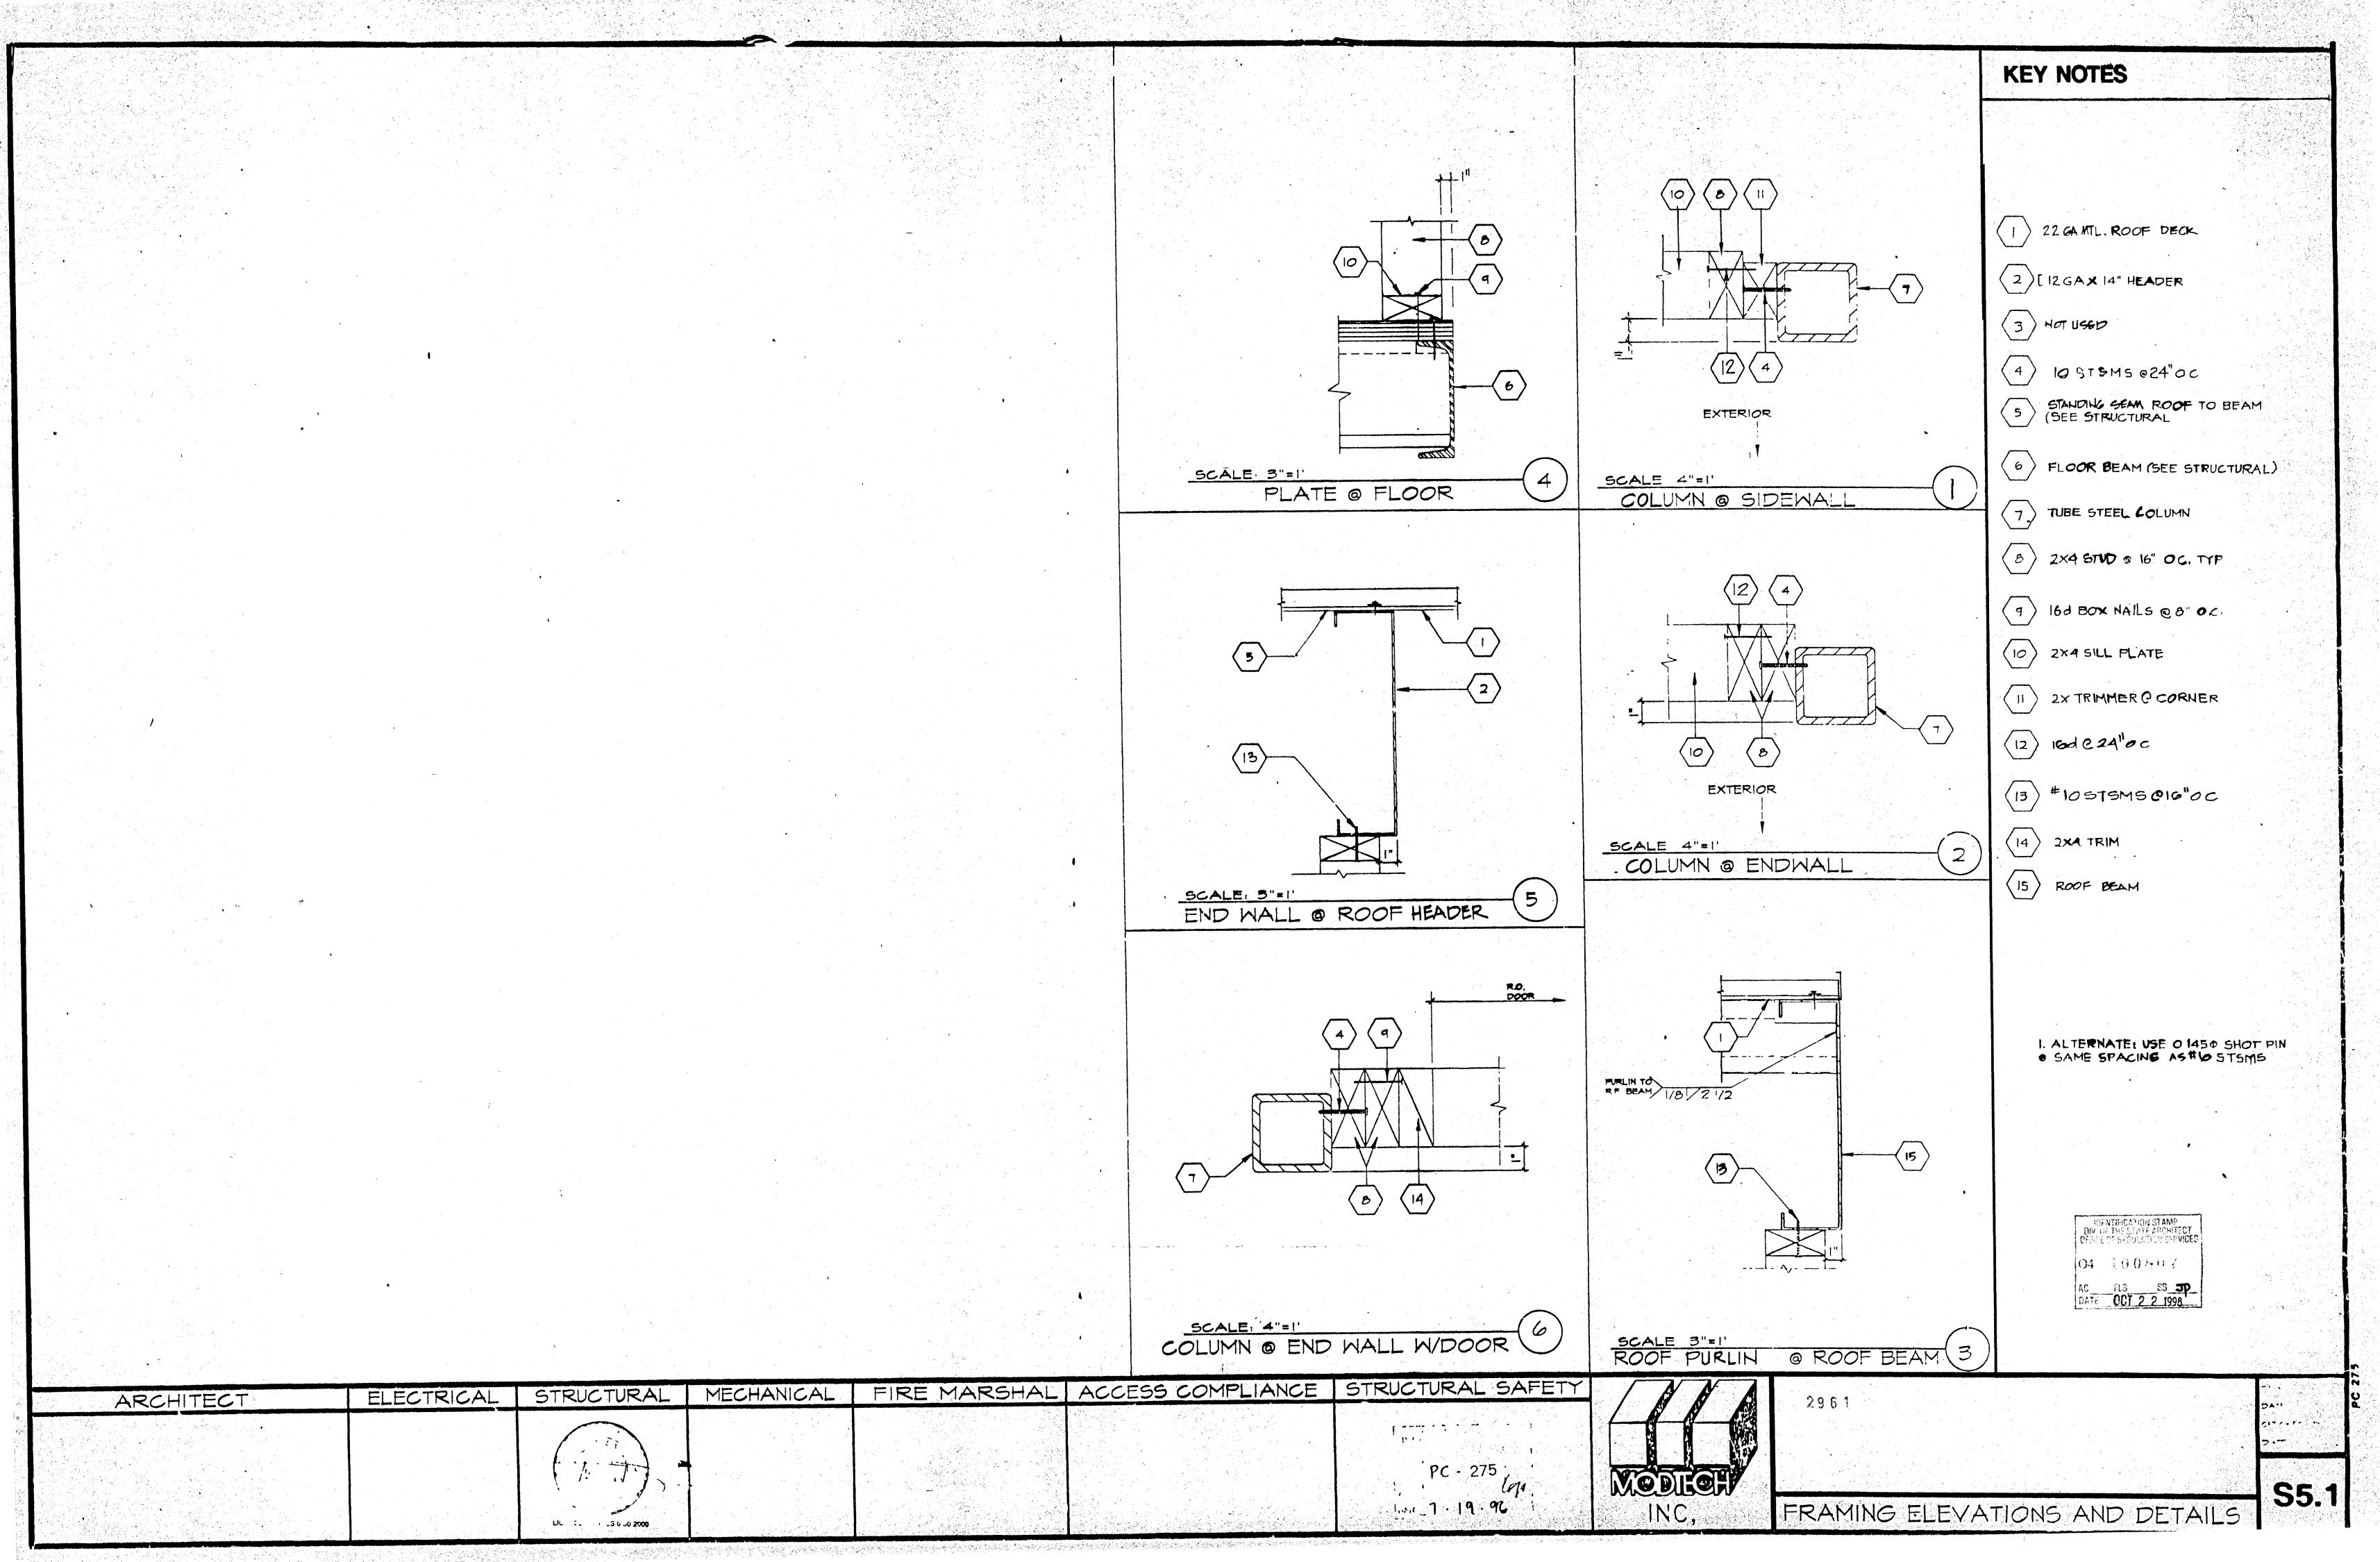

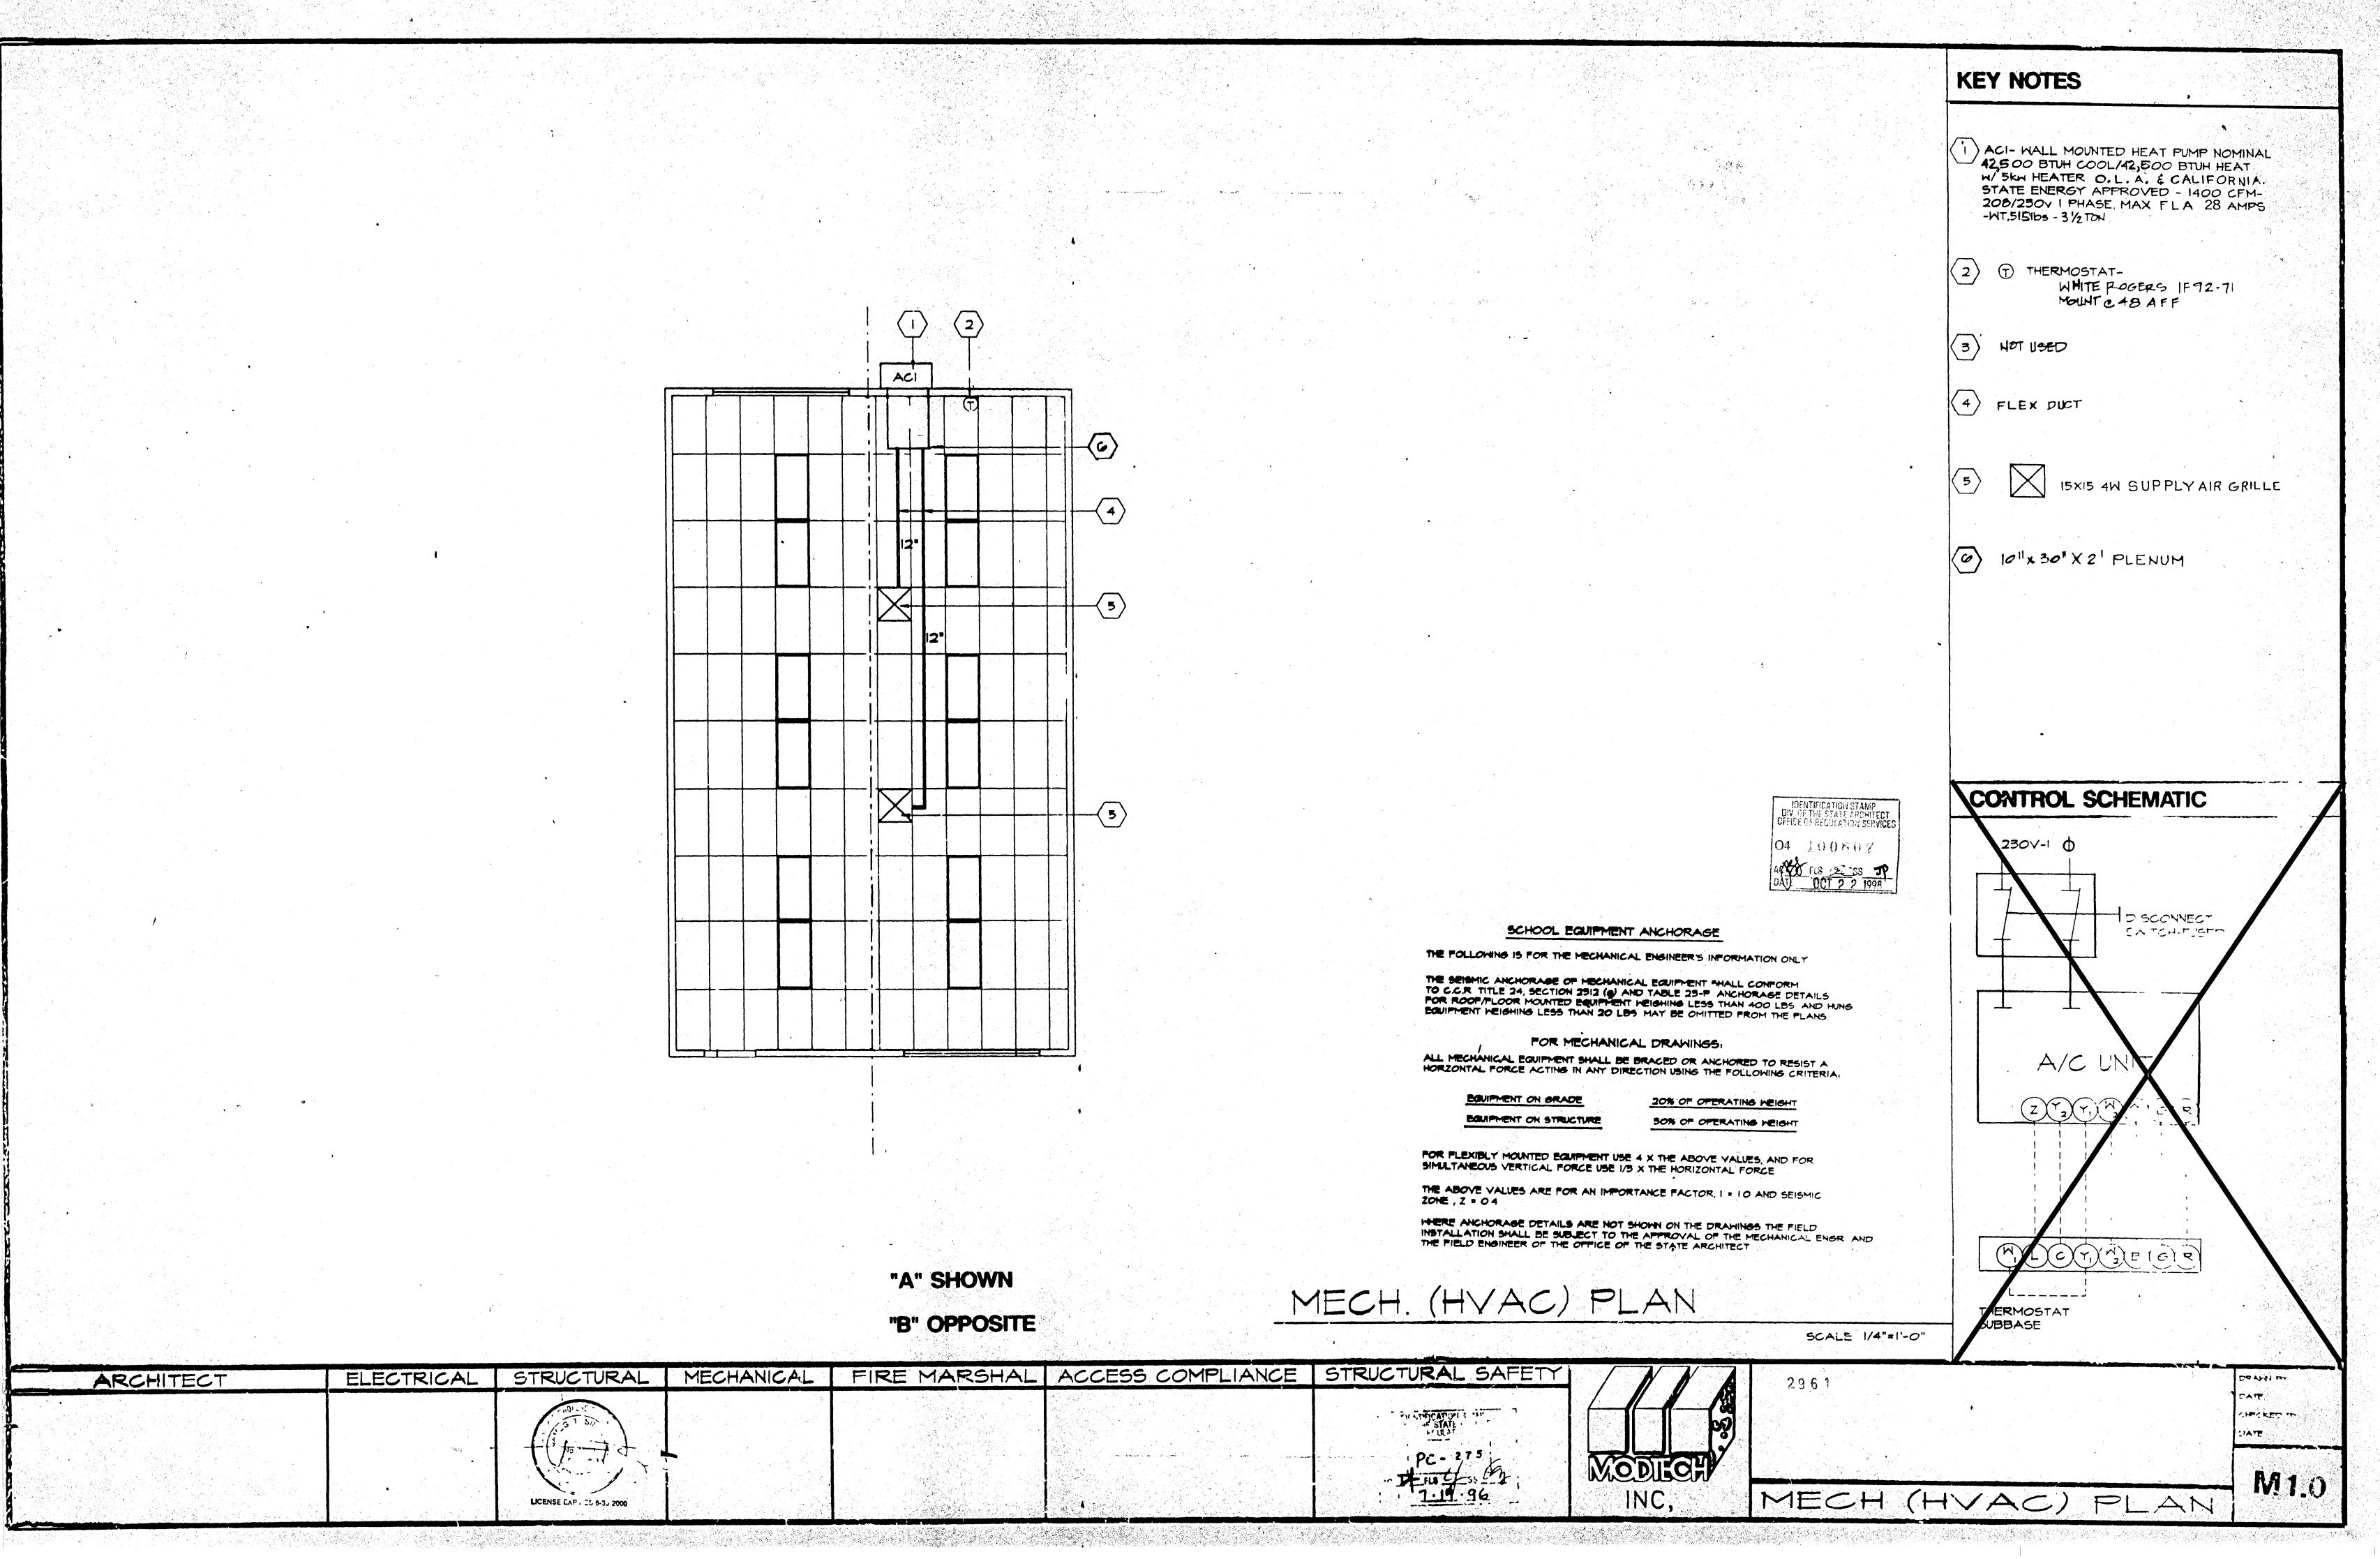

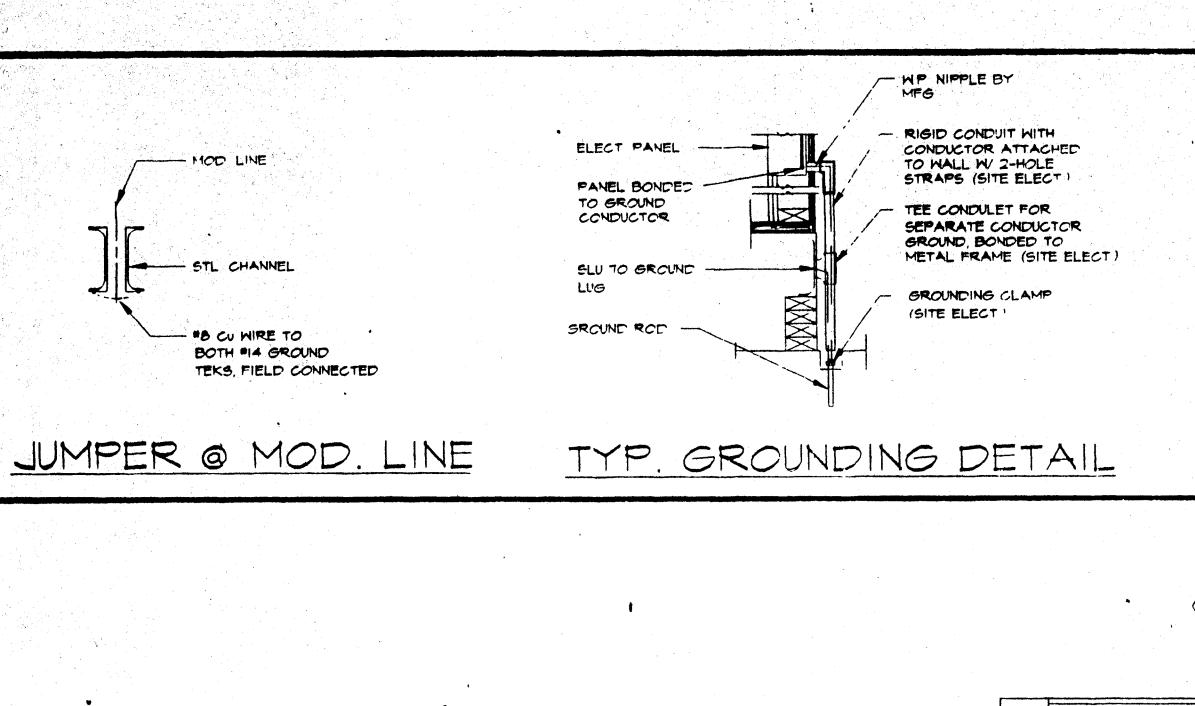

- EACH BUILDING SHALL BE SEPARATELY GROUNDED WITH A 3/4" RD X B' COPPERCLAD STEEL GROUND ROD WHERE ROCK BOTTOM IS INCOUNTERED, ROD SHALL BE DRIVEN AT AN ANGLE NOT TO EXCEED 45 DEGREE'S FROM THE VERTICAL OR SHALL BE BURIED IN A TRENCH THAT IS AT LEAST 30" DEEP (BY SITE ELECTRICAL)
- 2 TESTING, TEST FOR RESISTANCE TO GROUND IF RESISTANCE EXCEEDS 25 OHMS, INSTALL ADDITIONAL GROUND RODS SEPERATED AT LEAST 6'-O" UNTIL RESISTANCE IS REDUCED TO 25 OHMS OR LESS (BY SITE ELECTRICAL)
- PROVIDE EQUIPMENT ANCHORAGE PER TITLE 24 TABLE 16 J. PART B
- 4 APPROVAL OF THIS PLAN DOES NOT CONSTITUTE APPROVAL OF THIS FIRE ALARM FOR ALL SITES THE FIRE ALARM SYSTEM AND/OR COMPONENTS MAYBE required to be changed due to site location, EXISTING CONDITIONS OR INCOMPATABLE COMPONENTS
- GROUND MG TEST SHALL BE DONE IN THE PRESENCE OF THE PROJECT INSPECTOR GROUNDING SHALL BE IN ACCORDANCE W/CEC ARTICLE 250

PANEL! A VOLTS: 120/240 V FEED BOTTOM KEY NOTES MAIN: 100 A (HOM 120M 100C 50D) LOCATION MOUNTING RECESSED LOAD Amps P Ap Bo AD BO AMOS 2 50 2330 20 1 RECEPTACLES HVAC (3 1/2 TON) 3360 HVAC (3 1/2 TON) RECEPTACLES & CLOCK HEAT STRIPS 5KW INT./EXT. LIGHTS 30 2 2500 (3) ELECTRICAL PANEL "A" 840 20 1 2500 HEAT STRIPS 5KW INT/LIGHTS FIRE ALARM 4 EXTERIOR LIGHT FIXTURE WATTS/PHASE A = 7520 2020 1740 WATTS/PHASE 5860 5860 B = 7600 TOTAL 15,595 WATTS COS AMPS 120/240 VOLTS 3 WIRE NCL = 13,220

6 DUPLEX WALL RECEPTACLE 15-A 125-V 3-WIRE CLOCK OUTLET (SEE SPEC'S)

) 45 JUNCTION BOX FOR FIRE ALARM EXT

4/SDP WEATHER PROOF GUTTER BOX + 18"

(6×6×4)

HVAC UNIT HV

HORN (ROUGH IN ONLY)

- 8 2' X 4' FLUORESCENT LIGHT AND FIXTURE 4-TUBE (SEE SPEC'S)
- 45 JUNCTION BOX FOR FIRE ALARM INT HORN/STROBE (ROUGH-IN ONLY)

(10) 45 JUNCTION BOX FOR FIRE ALARM

J BOX & CONDUIT FOR DATA CABLING LOCATE ADJACENT TO ALL STD RECEPTACLES ROUGH IN ONLY - STUB UP ABOVE CEILING (450P)

PULL STATION + 48"

CONN BOX PROVIDE TULL STRING

REAR

LEGEND

2' X 4' FLUORESCENT LIGHT FIXTURE WITH 4-TUBE (SEE SPEC'S) 84 WATTS

- EXTERIOR LIGHT FIXTURE + 93" AFF.
- \$ SWITCH +48" AFF
- ELECTRICAL FANEL 5'-0" A.F.F.
- DUPLEX WALL RECEPTACLE 15-A 125-V 3-WIFE HE" AFF.
- THERMOSTAT +48" & MAX A.F.F.
- "J' BOX FOR FIRE ALARM EXT HORN/BELL +8'-6" A.FF.
- 45 JUNCTION BOX FOR FIRE ALARM INTHORN / STROBE +80" AFF.
- F A PULL STATION +48" AFF
- 4/SDP EXTERIOR WEATHERPROOF GUTTER BOX (6X6X4) +18" AF.F.
- "J' BOX & CONDUIT FOR DATA CABLING LOCATE ADJACENT TO ALL STD RECEPTACLES (ROUGH IN ONLY - STUB UP ABOVE CEILING) MOUNTED AT 18" AFF
- CLOCK OUTLET +7'-6" AF.F.

SCHOOL EQUIPMENT ANCHORAGE

THE FOLLOWING IS FOR THE ARCHITECTS INFORMATION ONLY

THE SEISMIC ANCHORAGE OF ELECTRICAL EQUIPMENT SHALL CONFORM TO CCR. TITLE 24, SECTION 2512 (g) AND TABLE 25-P ANCHORAGE DETAILS FOR ROOF/FLOOR MOUNTED EGUIPMENT WEIGHING LESS THAN 400 LBS AND HUNG EQUIFMENT WEIGHING LESS THAN 20 LBS MAY BE OMITTED FROM THE PLANS

FOR ELECTRICAL DRAWINGS

ALL ELECTRICAL EQUIPMENT SHALL BE BRACED OR ANCHORED TO RESIST A HORZONTAL FORCE ACTING IN ANY DIRECTION USING THE FOLLOWING CRITERIA

EQUIPMENT ON GRADE

20% of Coerating Weight


EQUIPMENT ON STRUCTURE

50% OF OPERATING WEIGHT


FOR FLEXIBLY MOUNTED EQUIPMENT USE 4 X THE ABOVE VALUES AND FOR SIMULTANEOUS VERTICAL FORCE USE 1/3 X THE HORIZONTAL FORCE

THE ABOVE VALUES ARE FOR AN IMPORTANCE FACTOR 1 = 10 AND SEISMIC ZONE Z = 04

WHERE ANCHORAGE DETAILS ARE NOT SHOWN ON THE DRAWINGS THE FIELD INSTALLATION SHALL BE SUBJECT TO THE APPROVAL OF THE ARCHITECT AND THE FIELD ENGINEER OF THE OFFICE OF THE STATE ARCHITECT

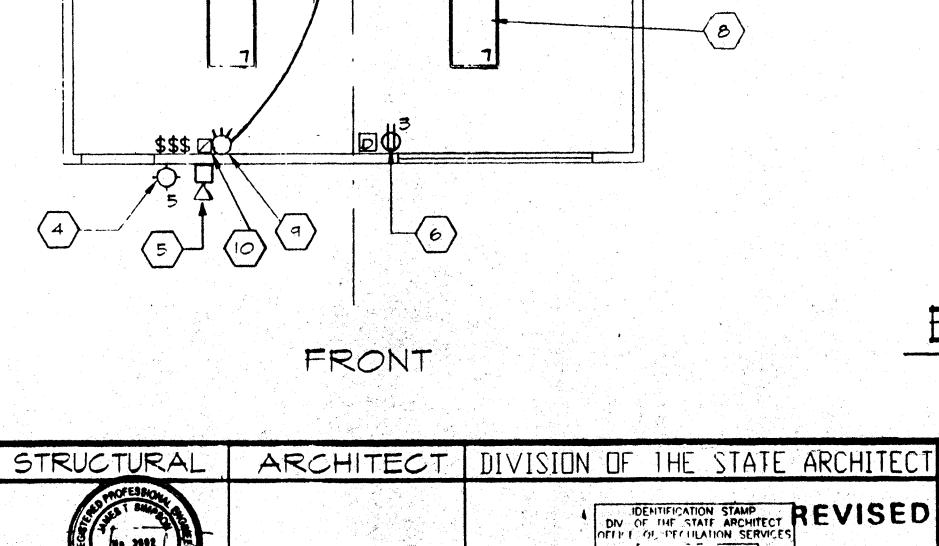

REVISIONS ELECTRICAL MECHANICAL LINENSE EXPINES 6-30-19

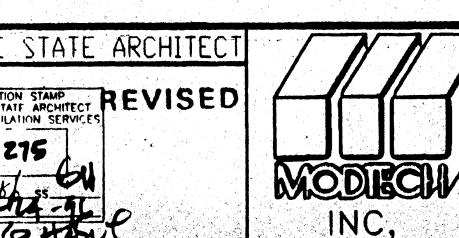

MODTECH INC. 2830 BARRETT AVE. PERRIS, CA. 92572 PH. (909) 943-4014 FX. (909) 940-0427

ELECTRICAL PLAN

CONFIDENTIAL - THIS DOCUMENT AND THE INFORMATION CONTAINED HEREIN ARE THE PROPERTY OF MODITECH INC UNAUTHORIZED COPYING, DISCLOSURE, OR

DTHER UNAUTHORIZED USES ARE PROHIBITED

2961

IDENTIFICATION STAMP DIV. OF THE STATE APPOINTECT OFFICE OF REGULATION STRVICES

04 100807

DAY OCI 2 2 1998

SCALE 1/4"-1'-0"

CHECKED BY

DRAWN BY

ELECTRICAL PLAN

