


UNDERGROUND UTILITY MAP

WITHIN THE CITY OF SAN DIEGO, COUNTY OF SAN DIEGO, CALIFORNIA PREPARED FOR:

GROSSMONT UNION HIGH SCHOOL DISTRICT

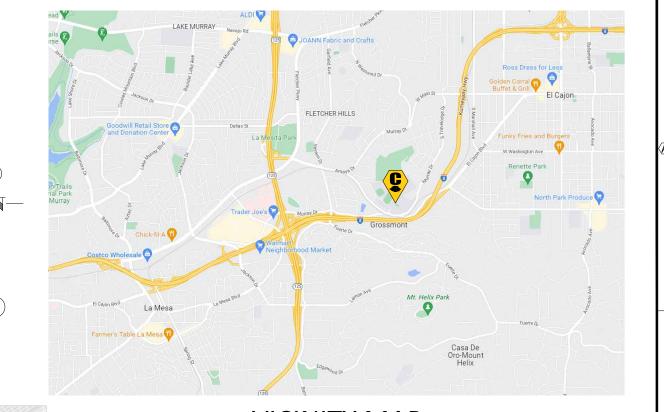

VICINITY MAP NOT TO SCALE

UTILITY QUALITY LEVELS NOTES

INFORMATION PROVIDED FROM AMERICAN SOCIETY OF CIVIL ENGINEERS (ASCE) CI/ASCE 38-02 MANUAL.

UTILITY QUALITY LEVEL A

PRECISE HORIZONTAL AND VERTICAL LOCATION OF UTILITIES OBTAINED BY THE ACTUAL EXPOSURE (OR VERIFICATION OF PREVIOUSLY EXPOSED AND SURVEYED UTILITIES) AND SUBSEQUENT MEASUREMENT OF SUBSURFACE UTILITIES, USUALLY AT A SPECIFIC POINT. MINIMALLY INTRUSIVE EXCAVATION EQUIPMENT IS TYPICALLY USED TO MINIMIZE THE POTENTIAL FOR UTILITY DAMAGE. A PRECISE HORIZONTAL AND VERTICAL LOCATION, AS WELL AS OTHER UTILITY ATTRIBUTES, IS SHOWN ON PLAN DOCUMENTS. ACCURACY IS TYPICALLY SET TO 15-MM VERTICAL AND TO APPLICABLE HORIZONTAL SURVEY AND MAPPING ACCURACY AS DEFINED OR EXPECTED BY THE PROJECT OWNER.

UTILITY QUALITY LEVEL B

INFORMATION OBTAINED THROUGH THE APPLICATION OF APPROPRIATE SURFACE GEOPHYSICAL METHODS TO DETERMINE THE EXISTENCE AND APPROXIMATE HORIZONTAL POSITION OF SUBSURFACE UTILITIES. QUALITY LEVEL B DATA SHOULD BE REPRODUCIBLE BY SURFACE GEOPHYSICS AT ANY POINT OF THEIR DEPICTION. THIS INFORMATION IS SURVEYED TO APPLICABLE TOLERANCES DEFINED BY THE PROJECT AND REDUCED ONTO PLAN DOCUMENTS.

UTILITY QUALITY LEVEL C

INFORMATION OBTAINED BY SURVEYING AND PLOTTING VISIBLE ABOVE-GROUND UTILITY FEATURES AND BY USING PROFESSIONAL JUDGMENT IN CORRELATING THIS INFORMATION TO QUALITY LEVEL D INFORMATION.

<u>utility quality level d</u>

INFORMATION DERIVED FROM EXISTING RECORDS OR ORAL RECOLLECTIONS.

UTILITY NOTES


- 1 FACILITIES (UTILITY LINES) SHALL BE LOCATED AND MARKED PRIOR TO EXCAVATION. CALL (800) 90-BELOW.
- (2) CONTRACTOR SHALL HAND-EXPOSE TO A POINT OF NO CONFLICT 24" ON EITHER SIDE OF THE UNDERGROUND FACILITY, REGARDLESS OF THE ESTIMATED DEPTH.
- (3) DEPTHS SHOWN ARE APPROXIMATE. ESTIMATED DEPTHS ARE FROM THE GROUND SURFACE TO THE CENTER OF THE FACILITY, INVERT OF WASTE LINES. OR TO THE FACILITY TRACER WIRE. DEPTH ESTIMATES SHOULD BE USED WITH CAUTION AND MAY VARY ALONG THE LENGTH OF THE FACILITY.
- 4 UTILITY BRACKETS ARE SHOWN TO DEMONSTRATE MULTIPLE LINES TRAVELING TOGETHER IN EITHER A DUCTBANK OR BUNDLE.
- (5) THE SCOPE OF THIS SURVEY DOES NOT INCLUDE FACILITY SIZE OR NUMBER OF CONDUIT IN MULTIPLE CONDUIT RUNS. IRRIGATION LINES ARE NOT INCLUDED IN THIS SURVEY.
- (6) THE BACKGROUND SITE PLAN USED IN PREPARING THIS MAP WAS PREPARED BY OTHERS AND PROVIDED TO C BELOW BY THE CLIENT. C BELOW MAKES NO REPRESENTATION AS TO THE ACCURACY OF THE PLAN.
- (7) IN THE EVENT THE INFORMATION SHOWN IN THIS PLAN VARIES FROM THE ACTUAL SITE CONDITIONS, C BELOW SHALL BE NOTIFIED WITHIN 24 HOURS AFTER DISCOVERY OF THE CONFLICT.

9: 888-902-3569

www.cbelow.com


F: 909-606-6555

UNDERGROUND LINE LEGEND

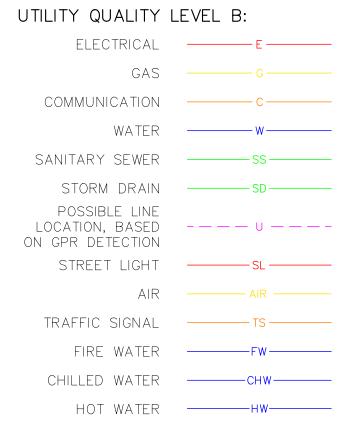

RECLAIMED WATER -----RW------

UTILITY QUALITY LEVEL C:

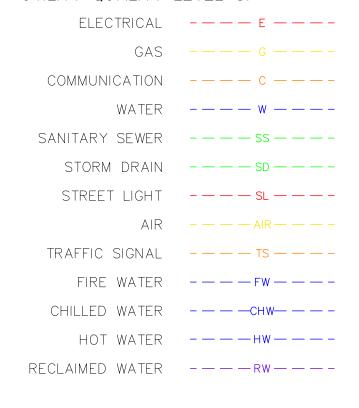

UTILITY QUALITY	LEVEL D:
ELECTRICAL	———Е——
GAS	G
COMMUNICATION	C
WATER	
SANITARY SEWER	SS
STORM DRAIN	SD
STREET LIGHT	SL
AIR	——————————————————————————————————————
TRAFFIC SIGNAL	TS
FIRE WATER	FW
CHILLED WATER	CHW
HOT WATER	HW
RECLAIMED WATER	RW

UTILITY DEPICTION

UNDERGROUND UTILITY DEPICTION SHOWN HEREON IS BASED ON LOCAL CONTROL AND/OR ON THE SMARTNET RTK NETWORK, UNLESS STATED OTHERWISE.

KEY NOTES

- NON-CONDUCTIVE, UNABLE TO LOCATE PAST THIS POINT.
- NO ACCESS, UNABLE TO LOCATE PAST THIS POINT. CANNOT PUSH FURTHER PAST THIS POINT.
- 4 AT BUILDING

ABBREVIATIONS

СО	CLEAN OUT
(C)	COMMUNICATION
(E)	ELECTRIC
(G)	GAS
RD	ROOF DRAIN
(RW)	RECLAIMED WATER
(SD)	STORM DRAIN
(SL)	STREET LIGHT
(SS)	SANITARY SEWER
TRN	TRANSFORMER
(U)	UNKNOWN

WATER

LEGEND/SYMBOL

	DEPTH FROM SURFACE		
d	FIRE HYDRANT		
\Rightarrow	LIGHT POLE		
	MANHOLE		
	PULL BOX		
\otimes	VALVE		
	VAULT		



_1'-6"	DEPTH FROM SURFACE	
d	FIRE HYDRANT	
\Rightarrow	LIGHT POLE	
	MANHOLE	
	PULL BOX	
\otimes	VALVE	
	VAULT	

NOTE: **BACKGROUND IMAGE IS FROM GOOGLE** EARTH AND IS FOR REFERENCE ONLY.

NO BACKGROUND HAS BEEN PROVIDED BY CLIENT. ONCE BACKGROUND IS PROVIDED UTILITY MAP WILL BE UPDATED

DRAWING SHEETS			
SHEET NO.	SHEET TITLE		
1	COVER SHEET		
2	UTILITY MAP		

KEY MAP NOT TO SCALE

KUMEYAAY (I-8) HIGHWAY

MURRAY DRIVE



BELOW SUBSURFACE IMAGING 14280 EUCLID AVE CHINO, CA 91710 / GROUND PENETRATING RADAR (GPR) UTILITY LOCATING

RADIOGRAPHY

POTHOLING

MAPPING

NOTES: The services provided by C Below, Inc. do not relieve the Client and/or property owner of the responsibility of having to comply with California Government Code §§4216-4216.9. It is expressly understood by the Client and/or owner that CBSI services are not a substitute for compliance with California Code §§4216-4216.9.


PARTIAL UNDERGROUND UTILITY MAP FOR: **GROSSMONT HIGH SCHOOL** 1100 MURRAY DRIVE EL CAJON, CA 92020


CLIENT:

GROSSMONT UNION HIGH SCHOOL DISTRICT 1100 MURRAY DRIVE EL CAJON, CA 92020


	REVISIONS					
NO DATE BY DESCRIPTION						
1	04/25/22	OG	MAP WAS UPDATED WITH INFO. LOCATED ON APRIL 2022			


DATE LOCATED: 2/2022 DRAWN BY/DATE: LB 3/07/2022 TECHNICIAN SHEET 1 OF 3 CHECK BY/DATE: G. DILLON QC CHECKED BY/DATE: OG 3/09/2022 DRAWING NAME: COVER SHEET PROJECT NO: 22-4757 SCALE: N.T.S.

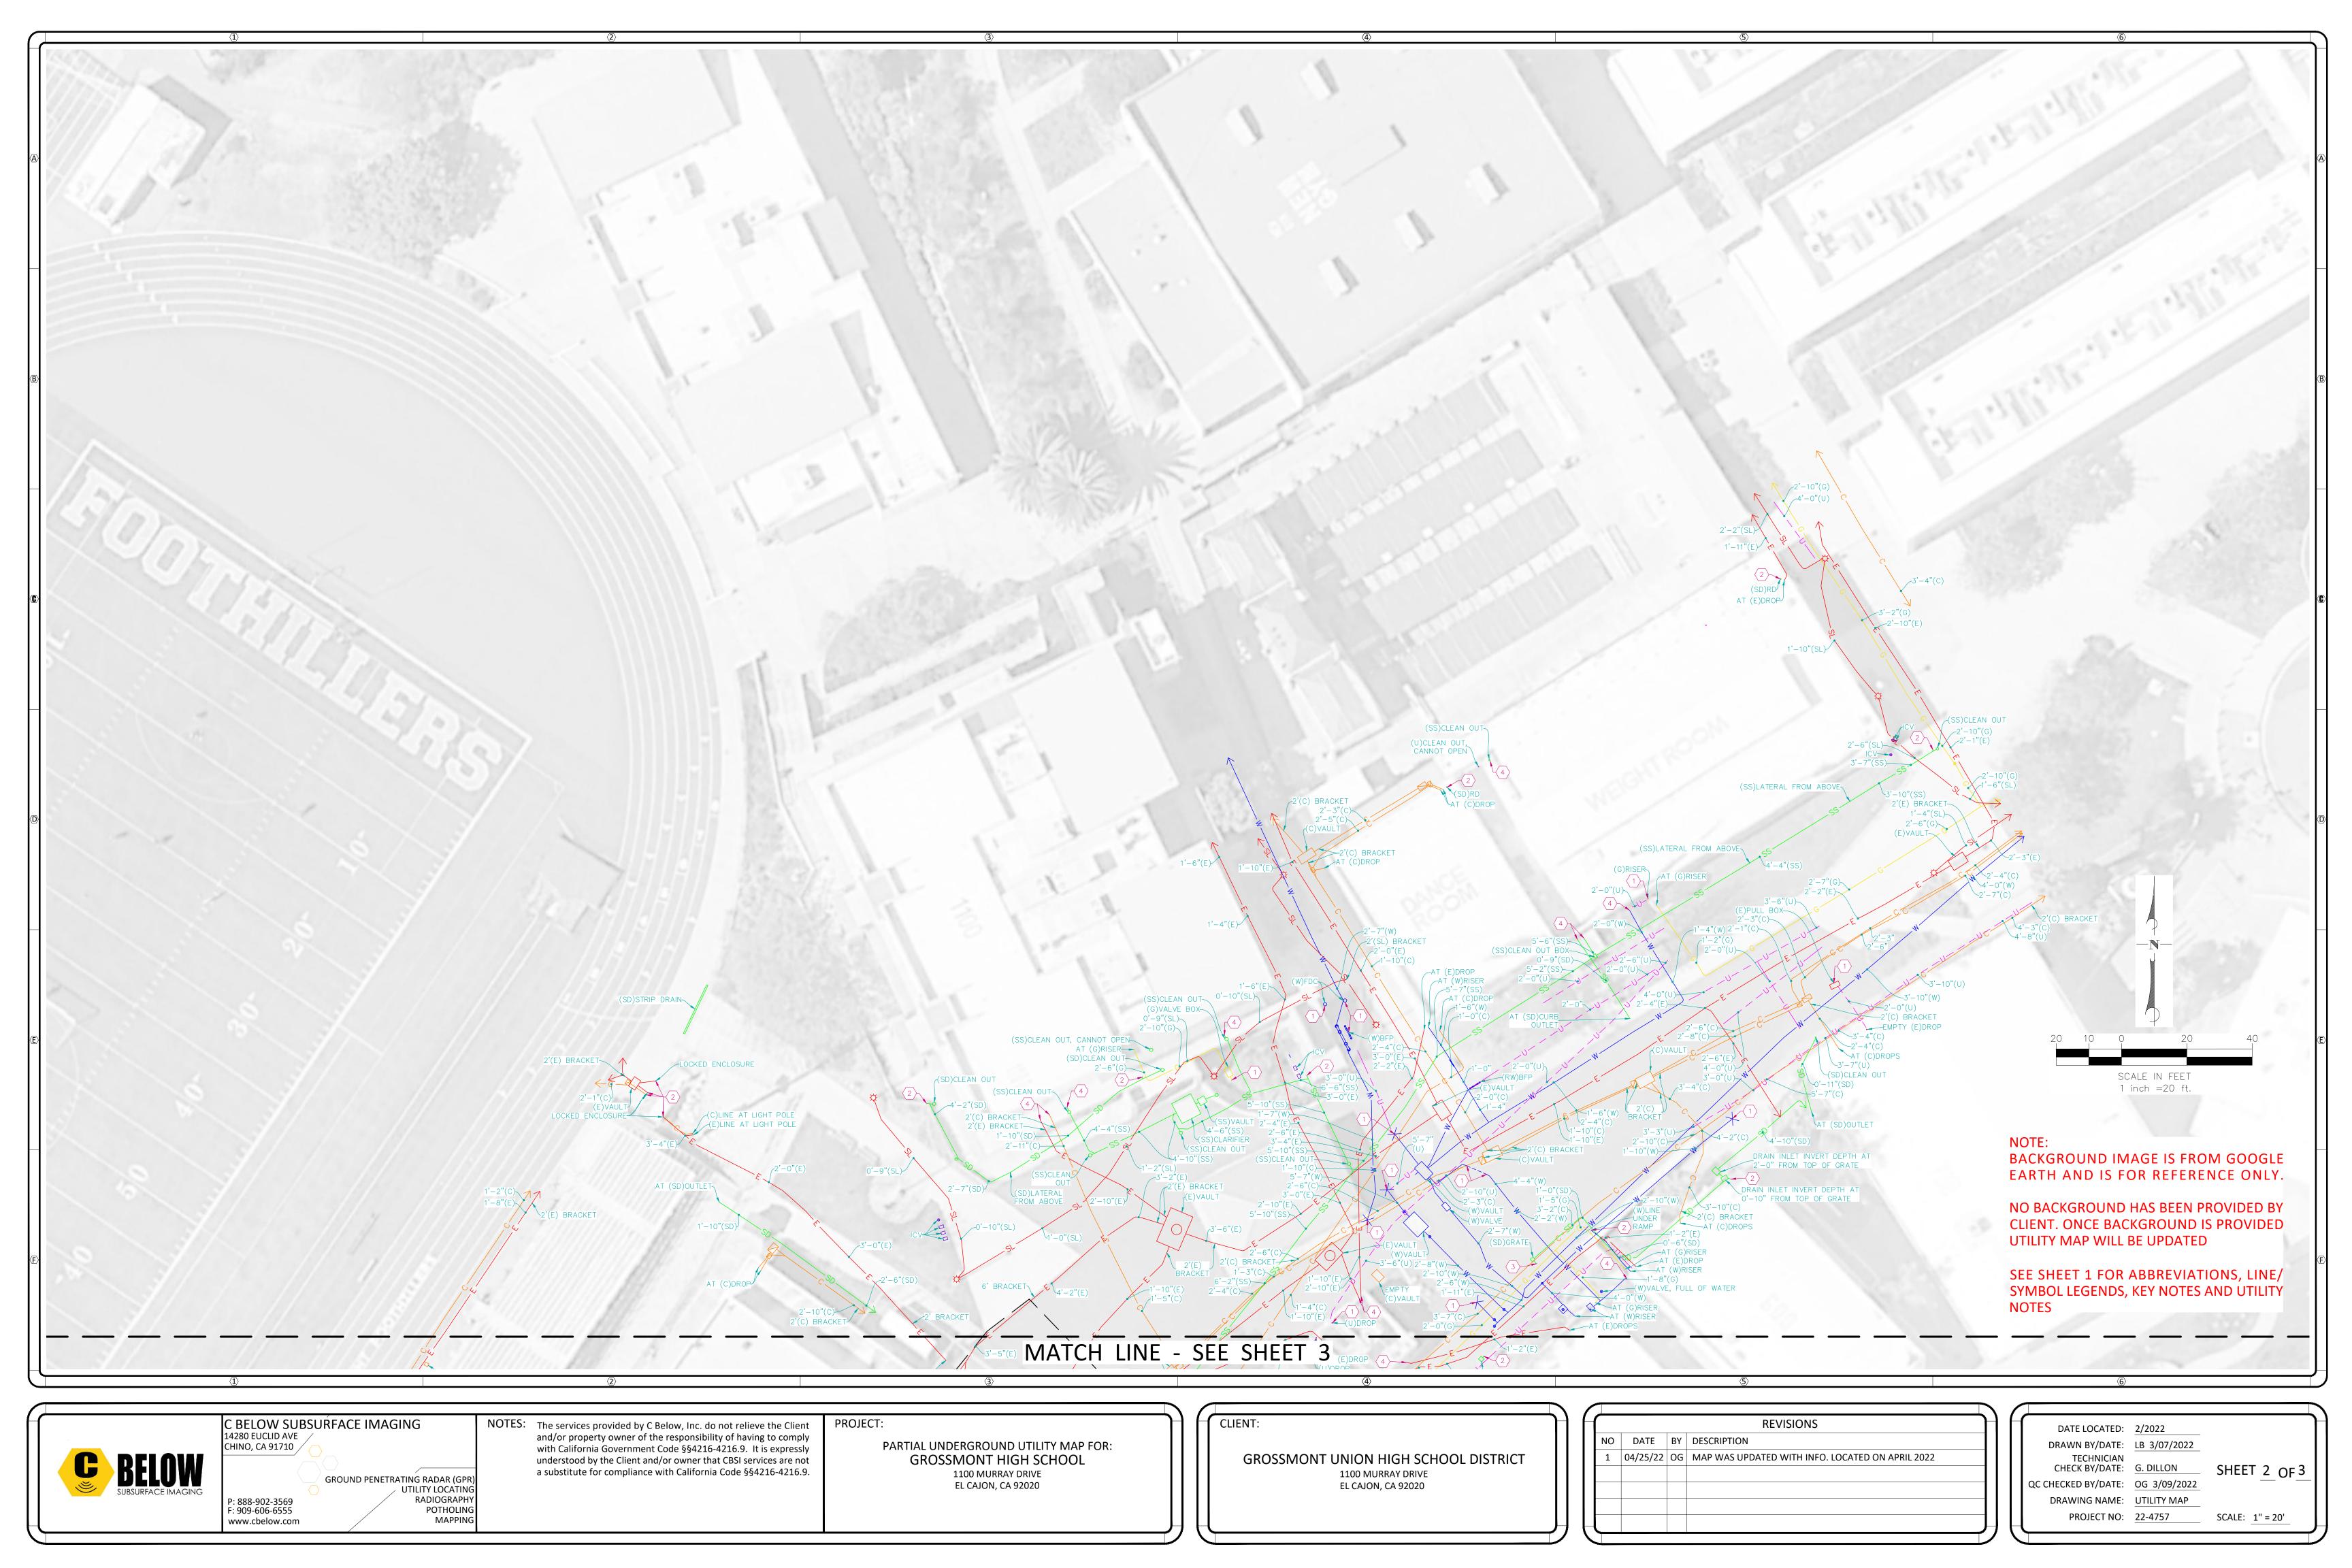


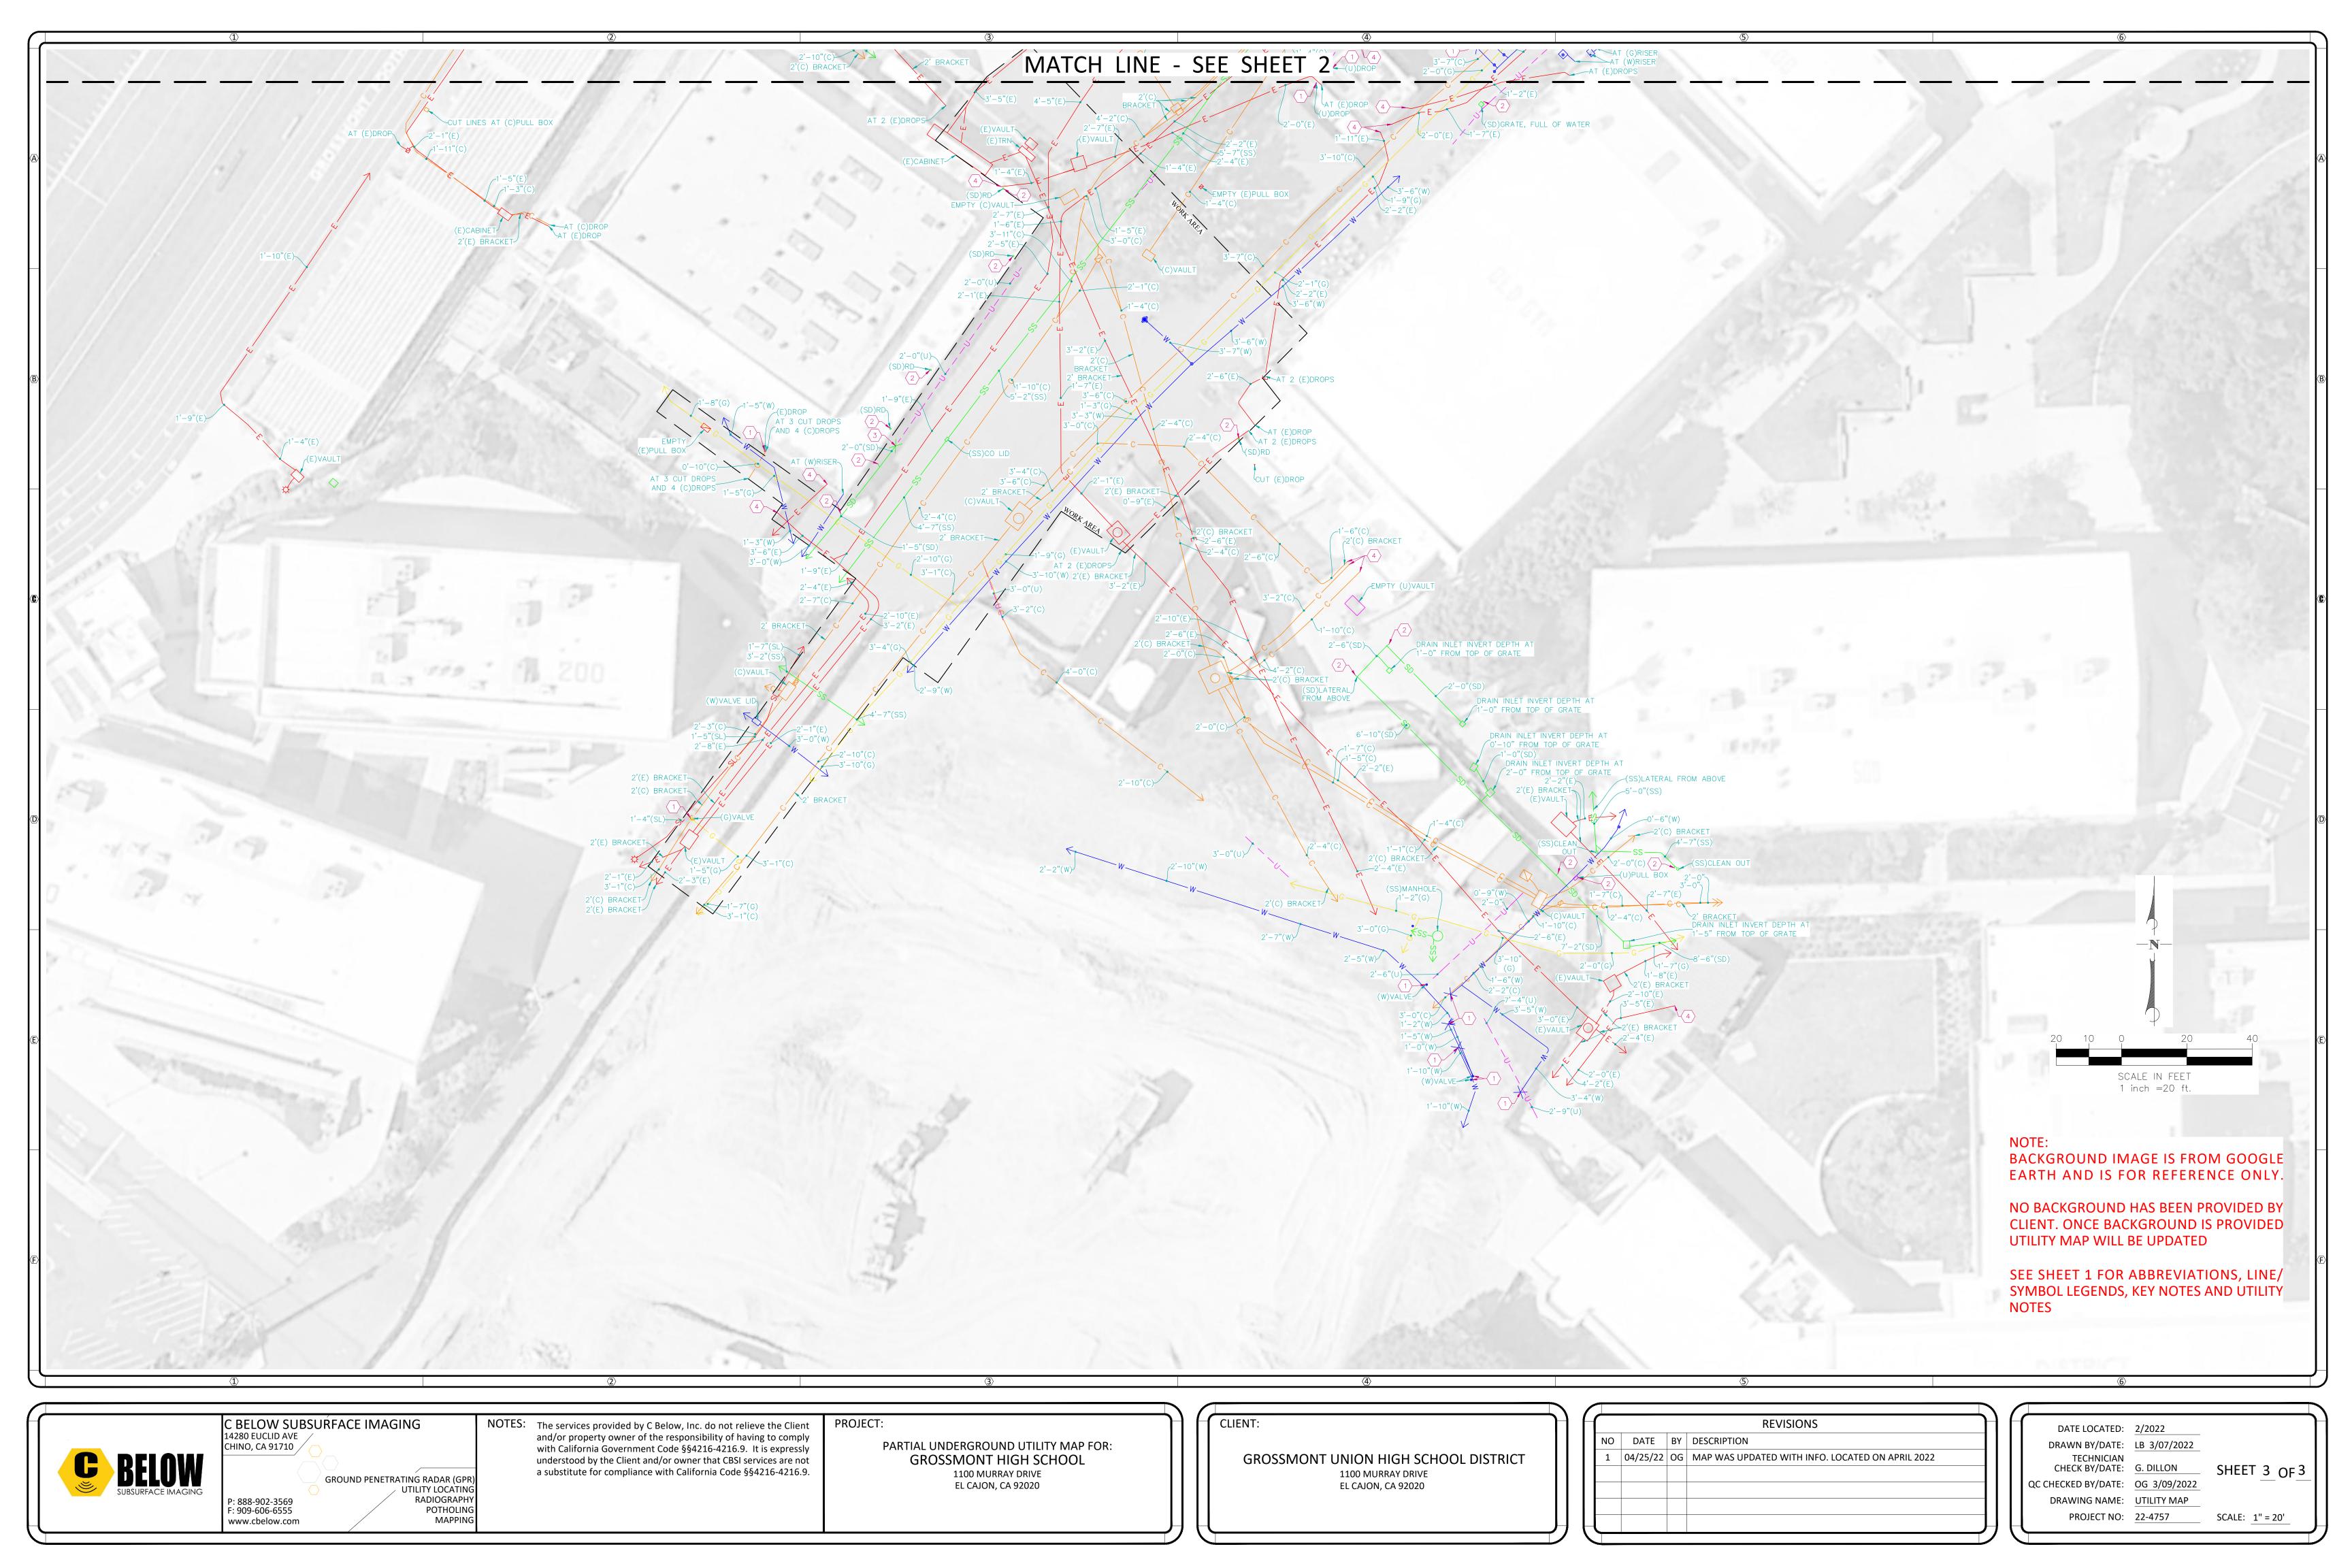



INTENTIONALLY LEFT BLANK

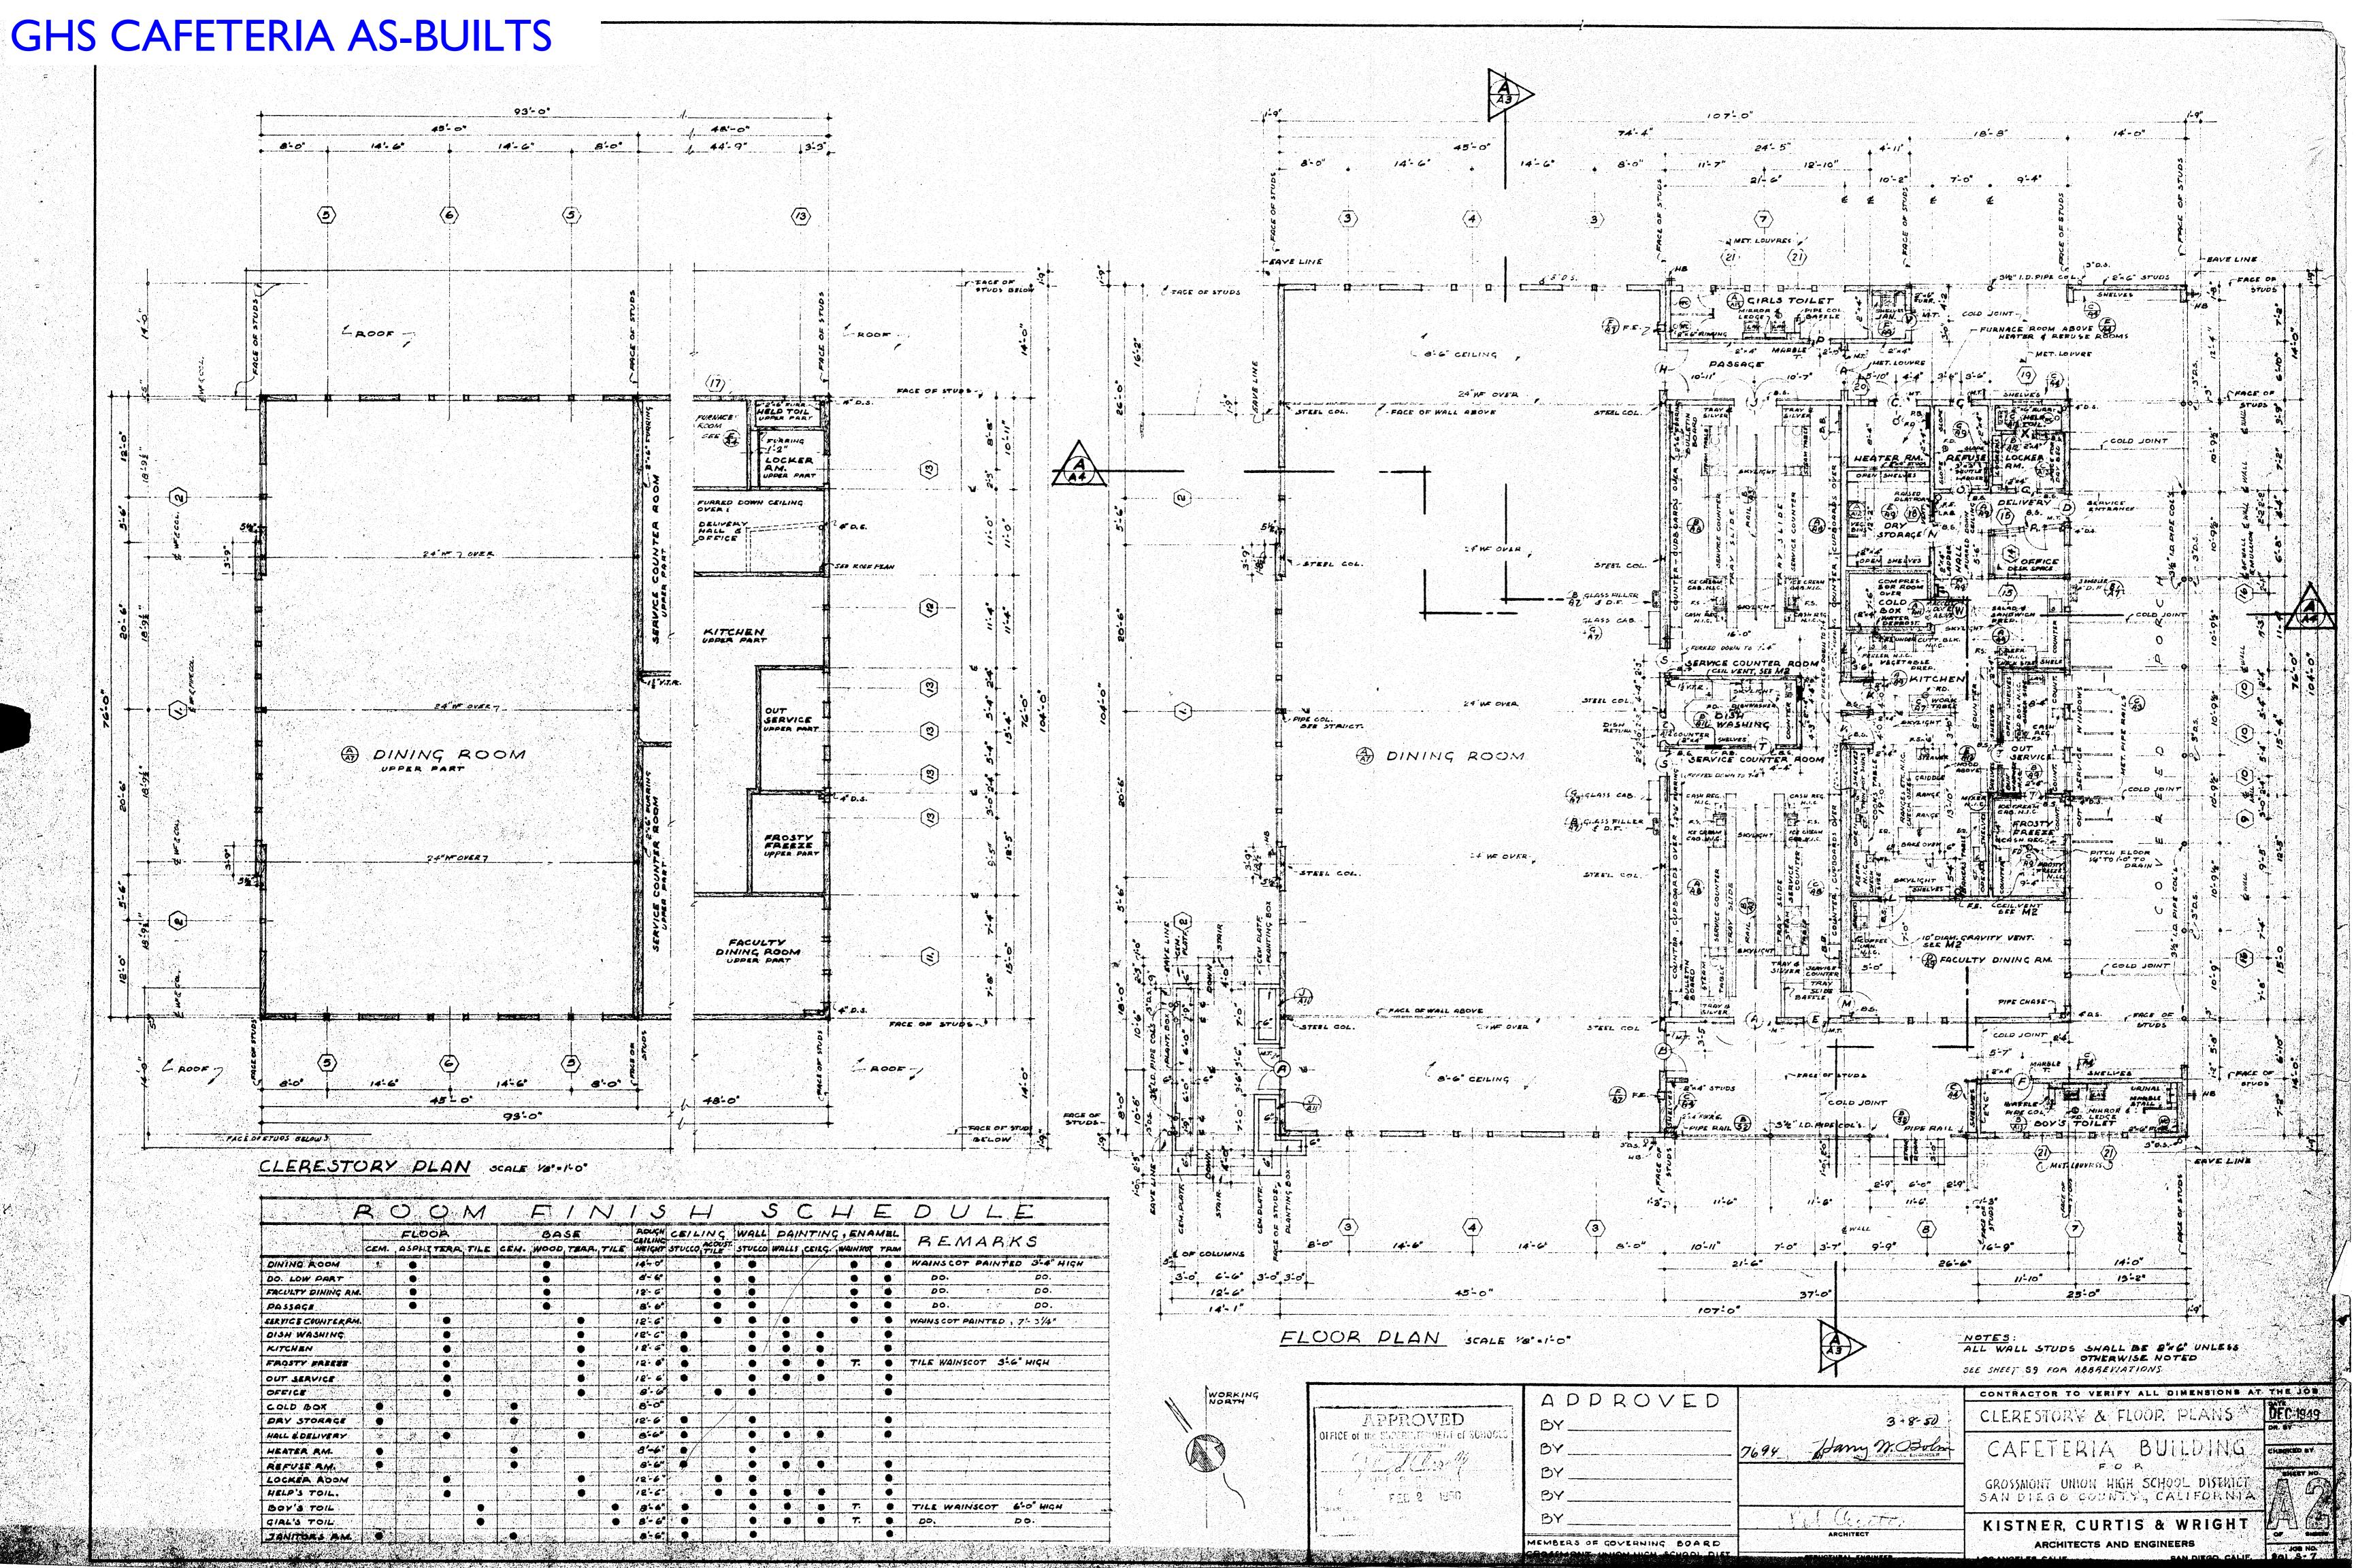


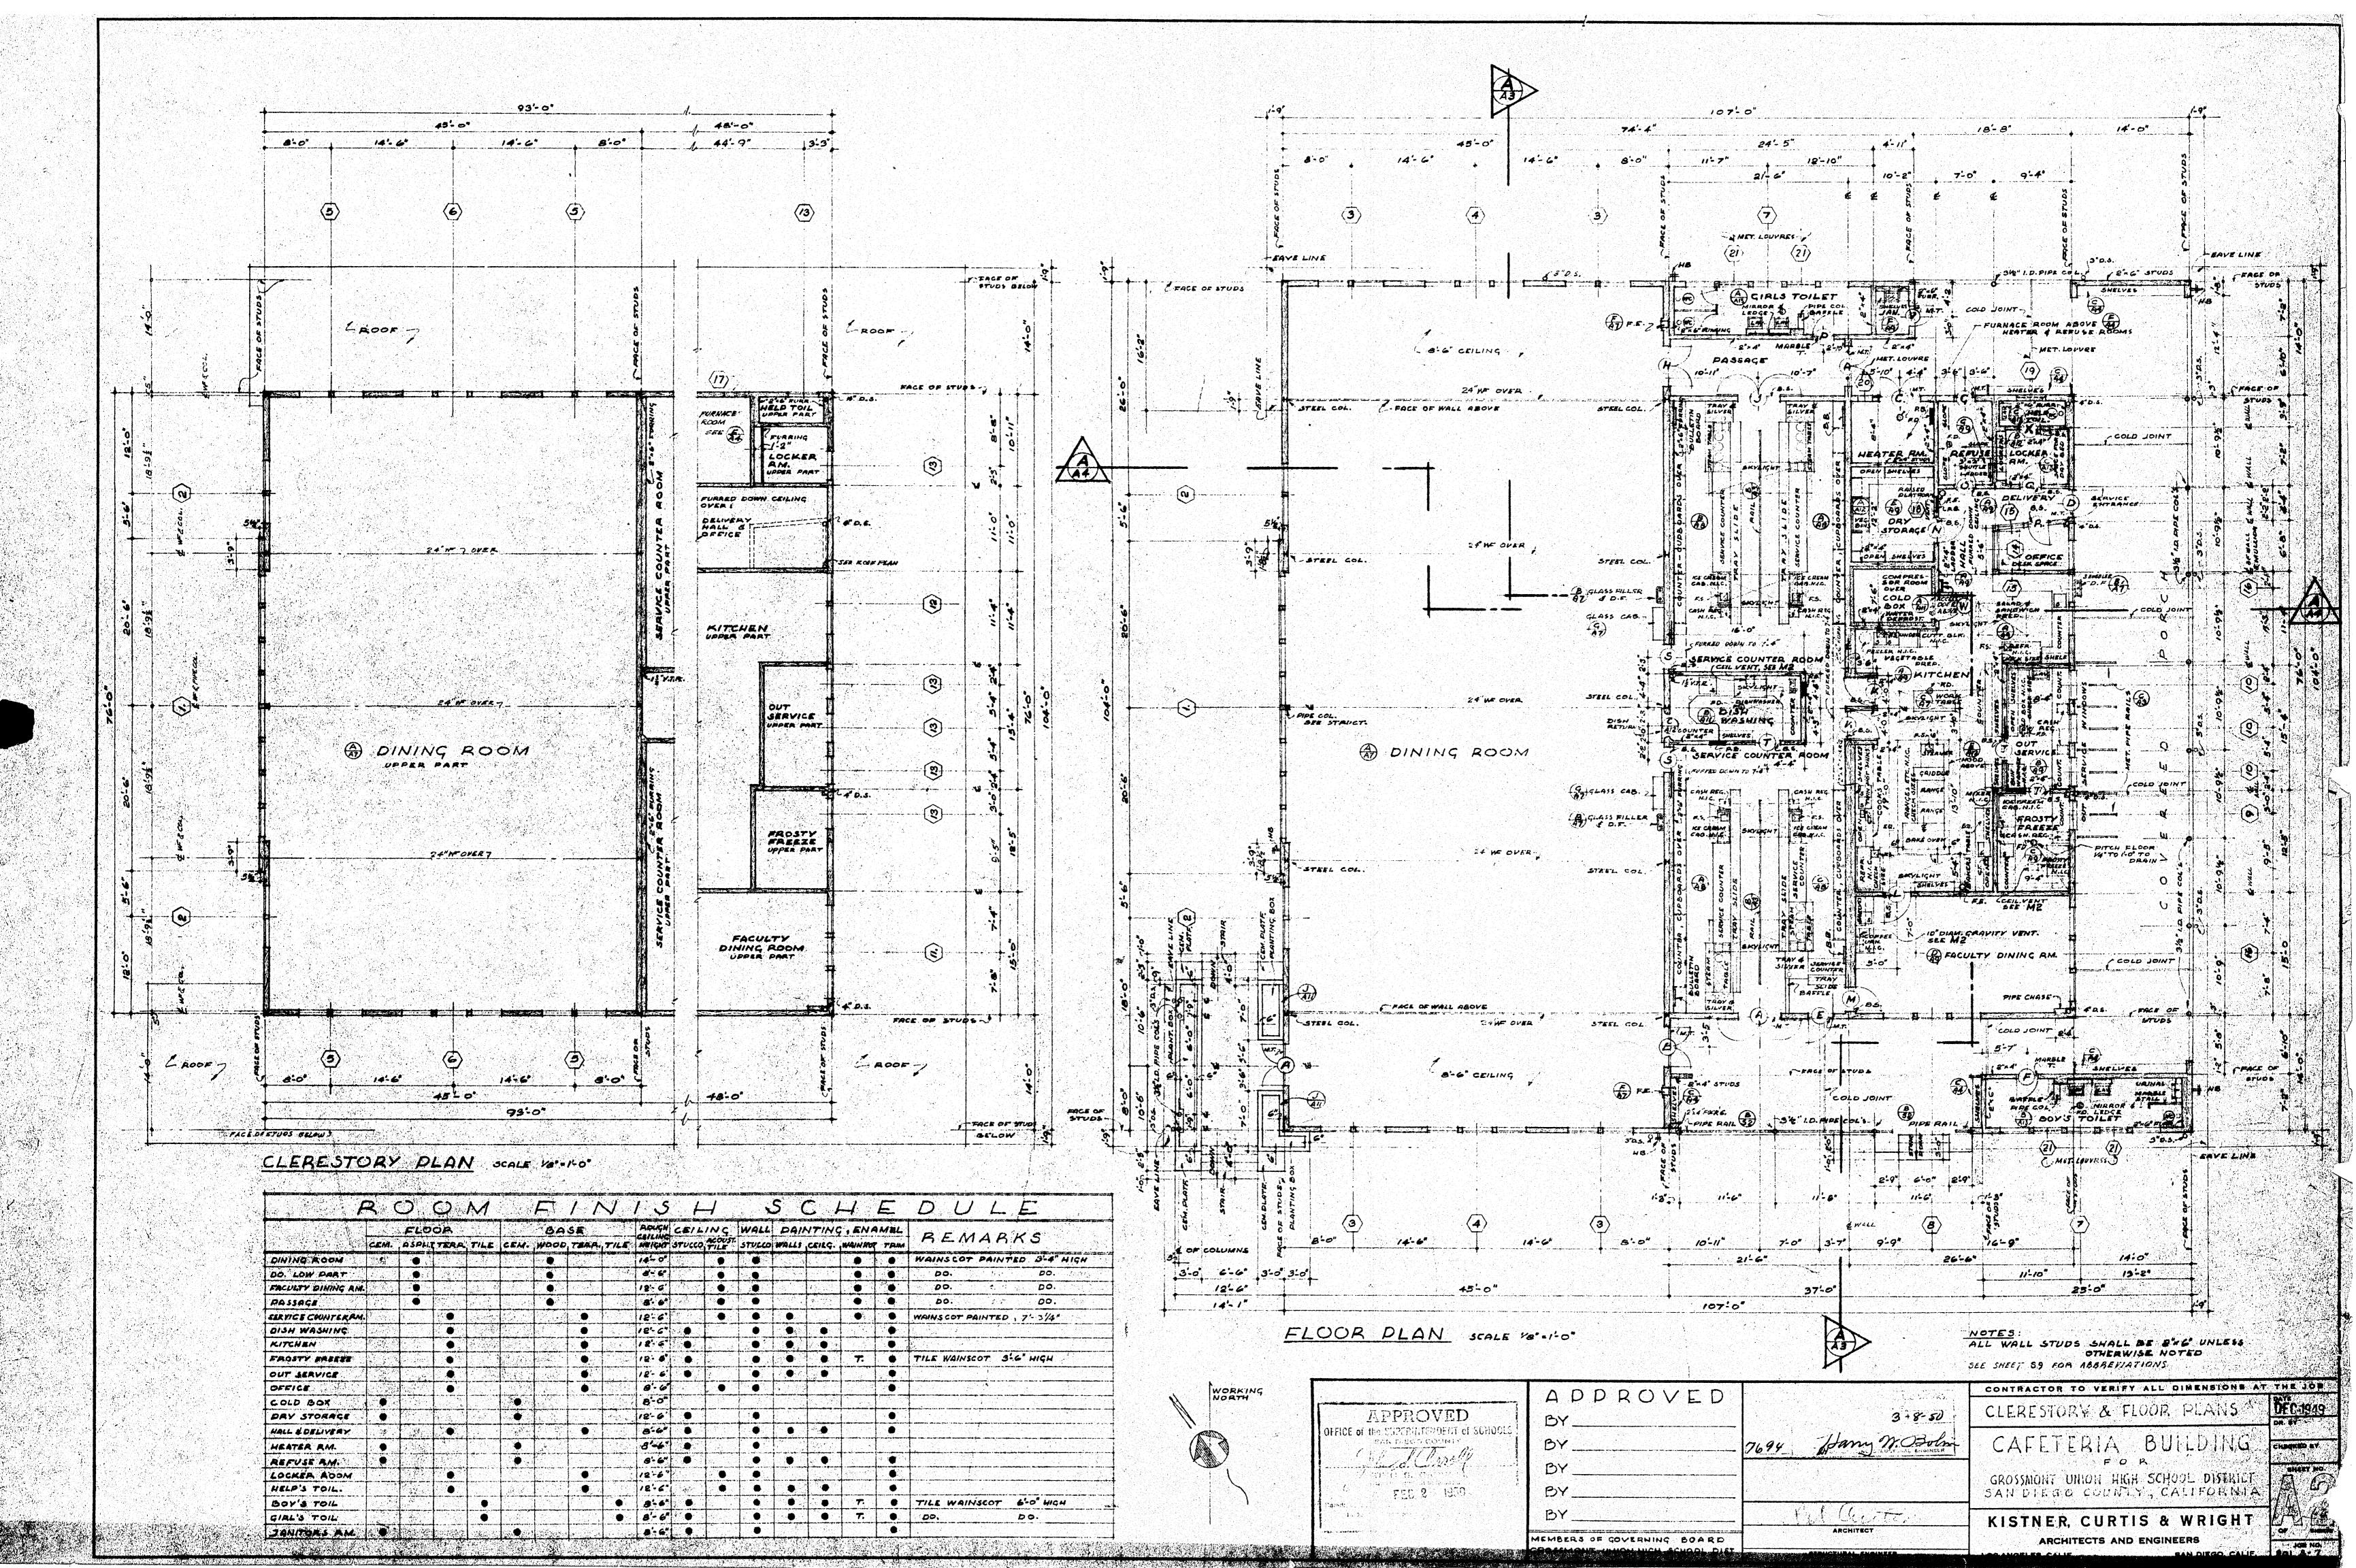


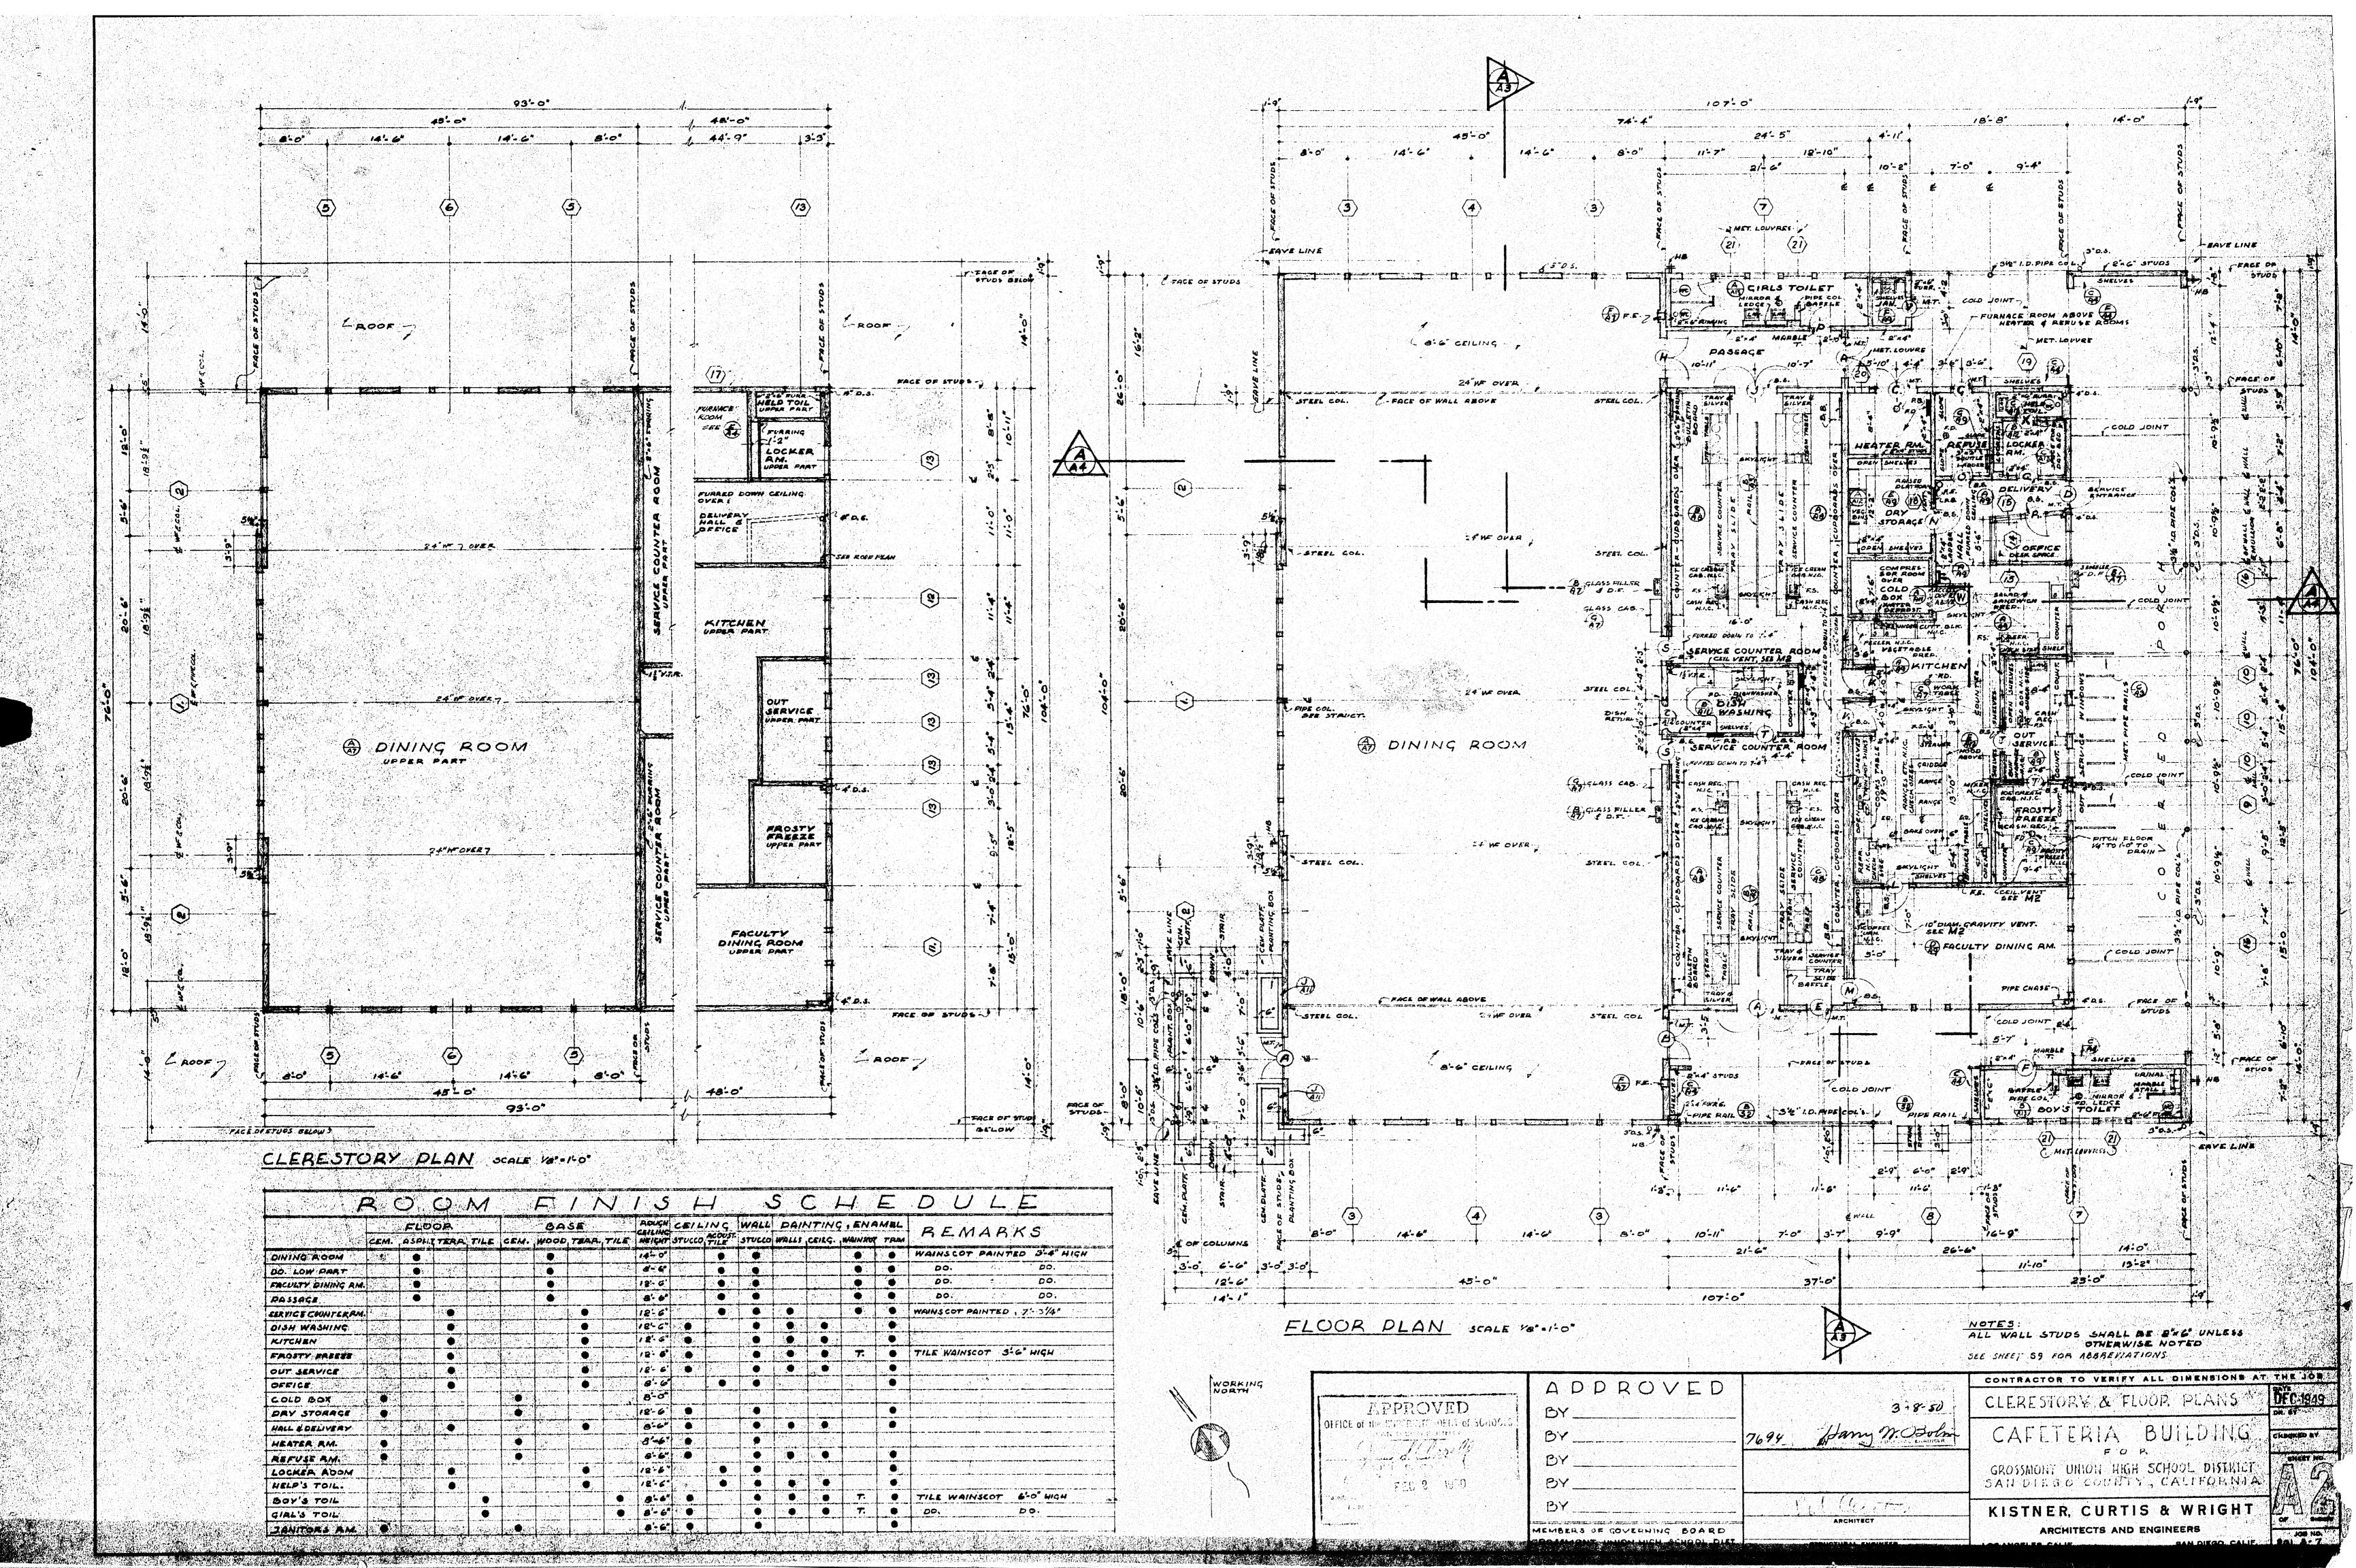


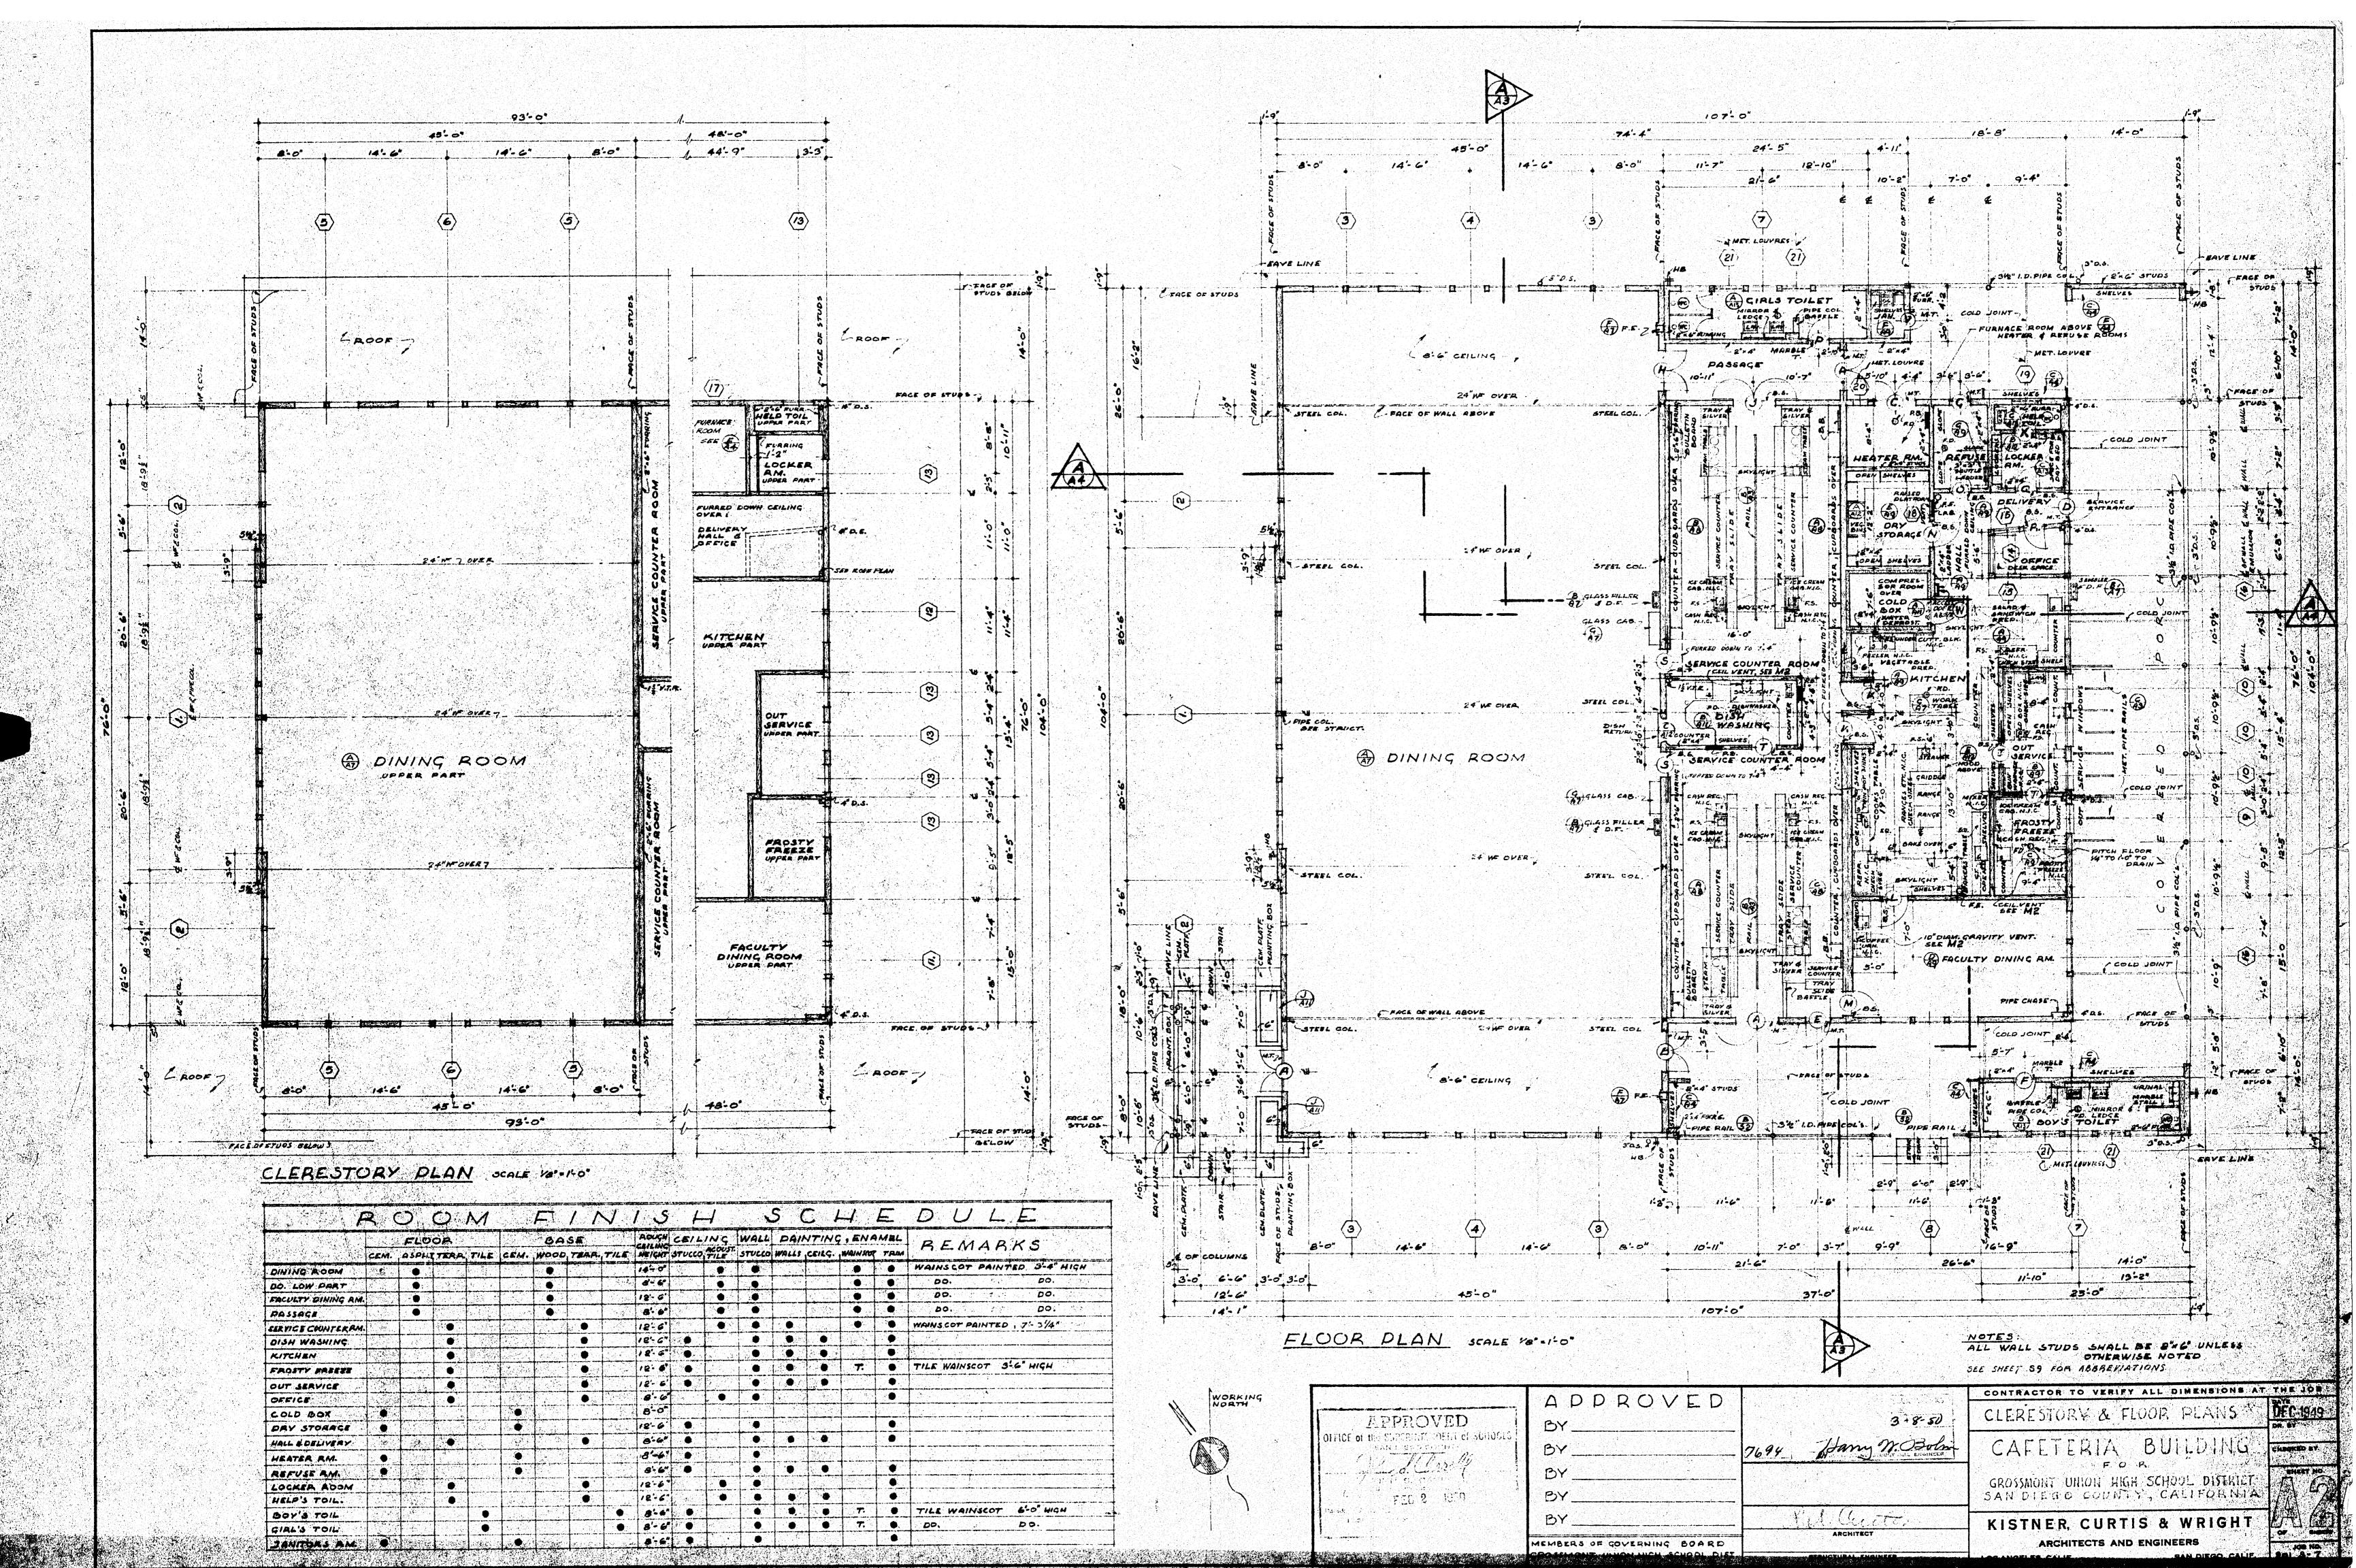


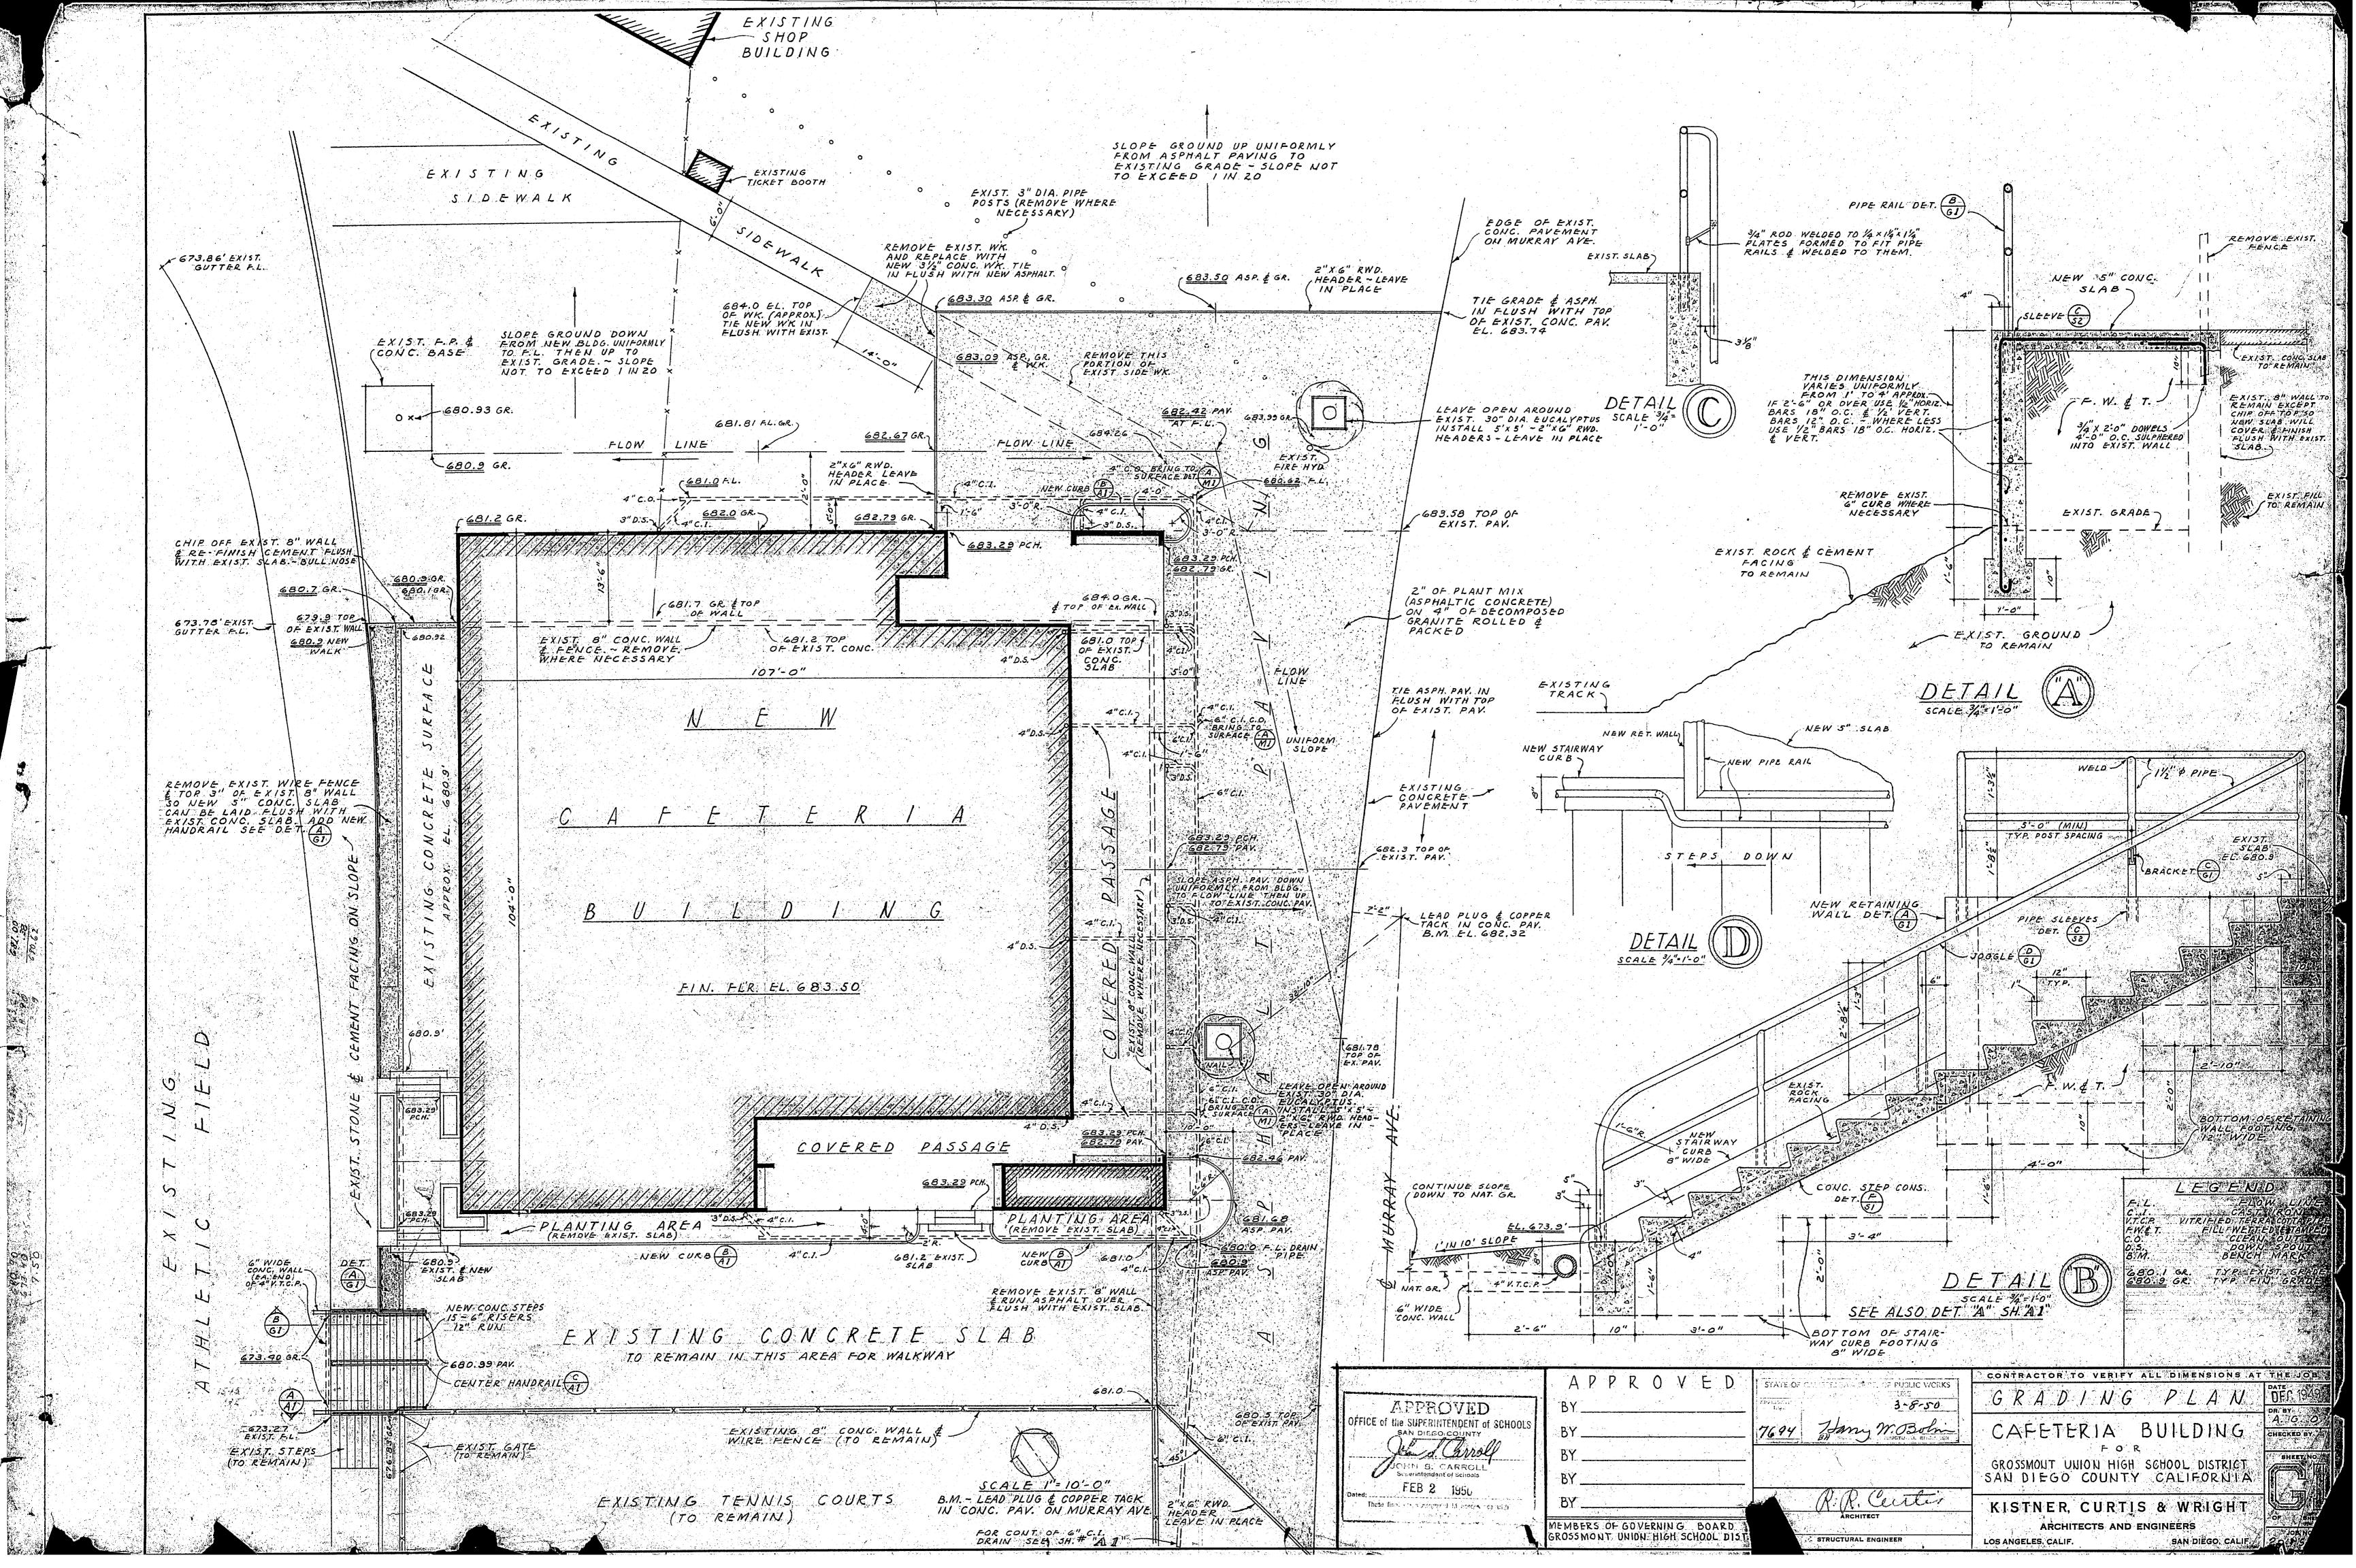


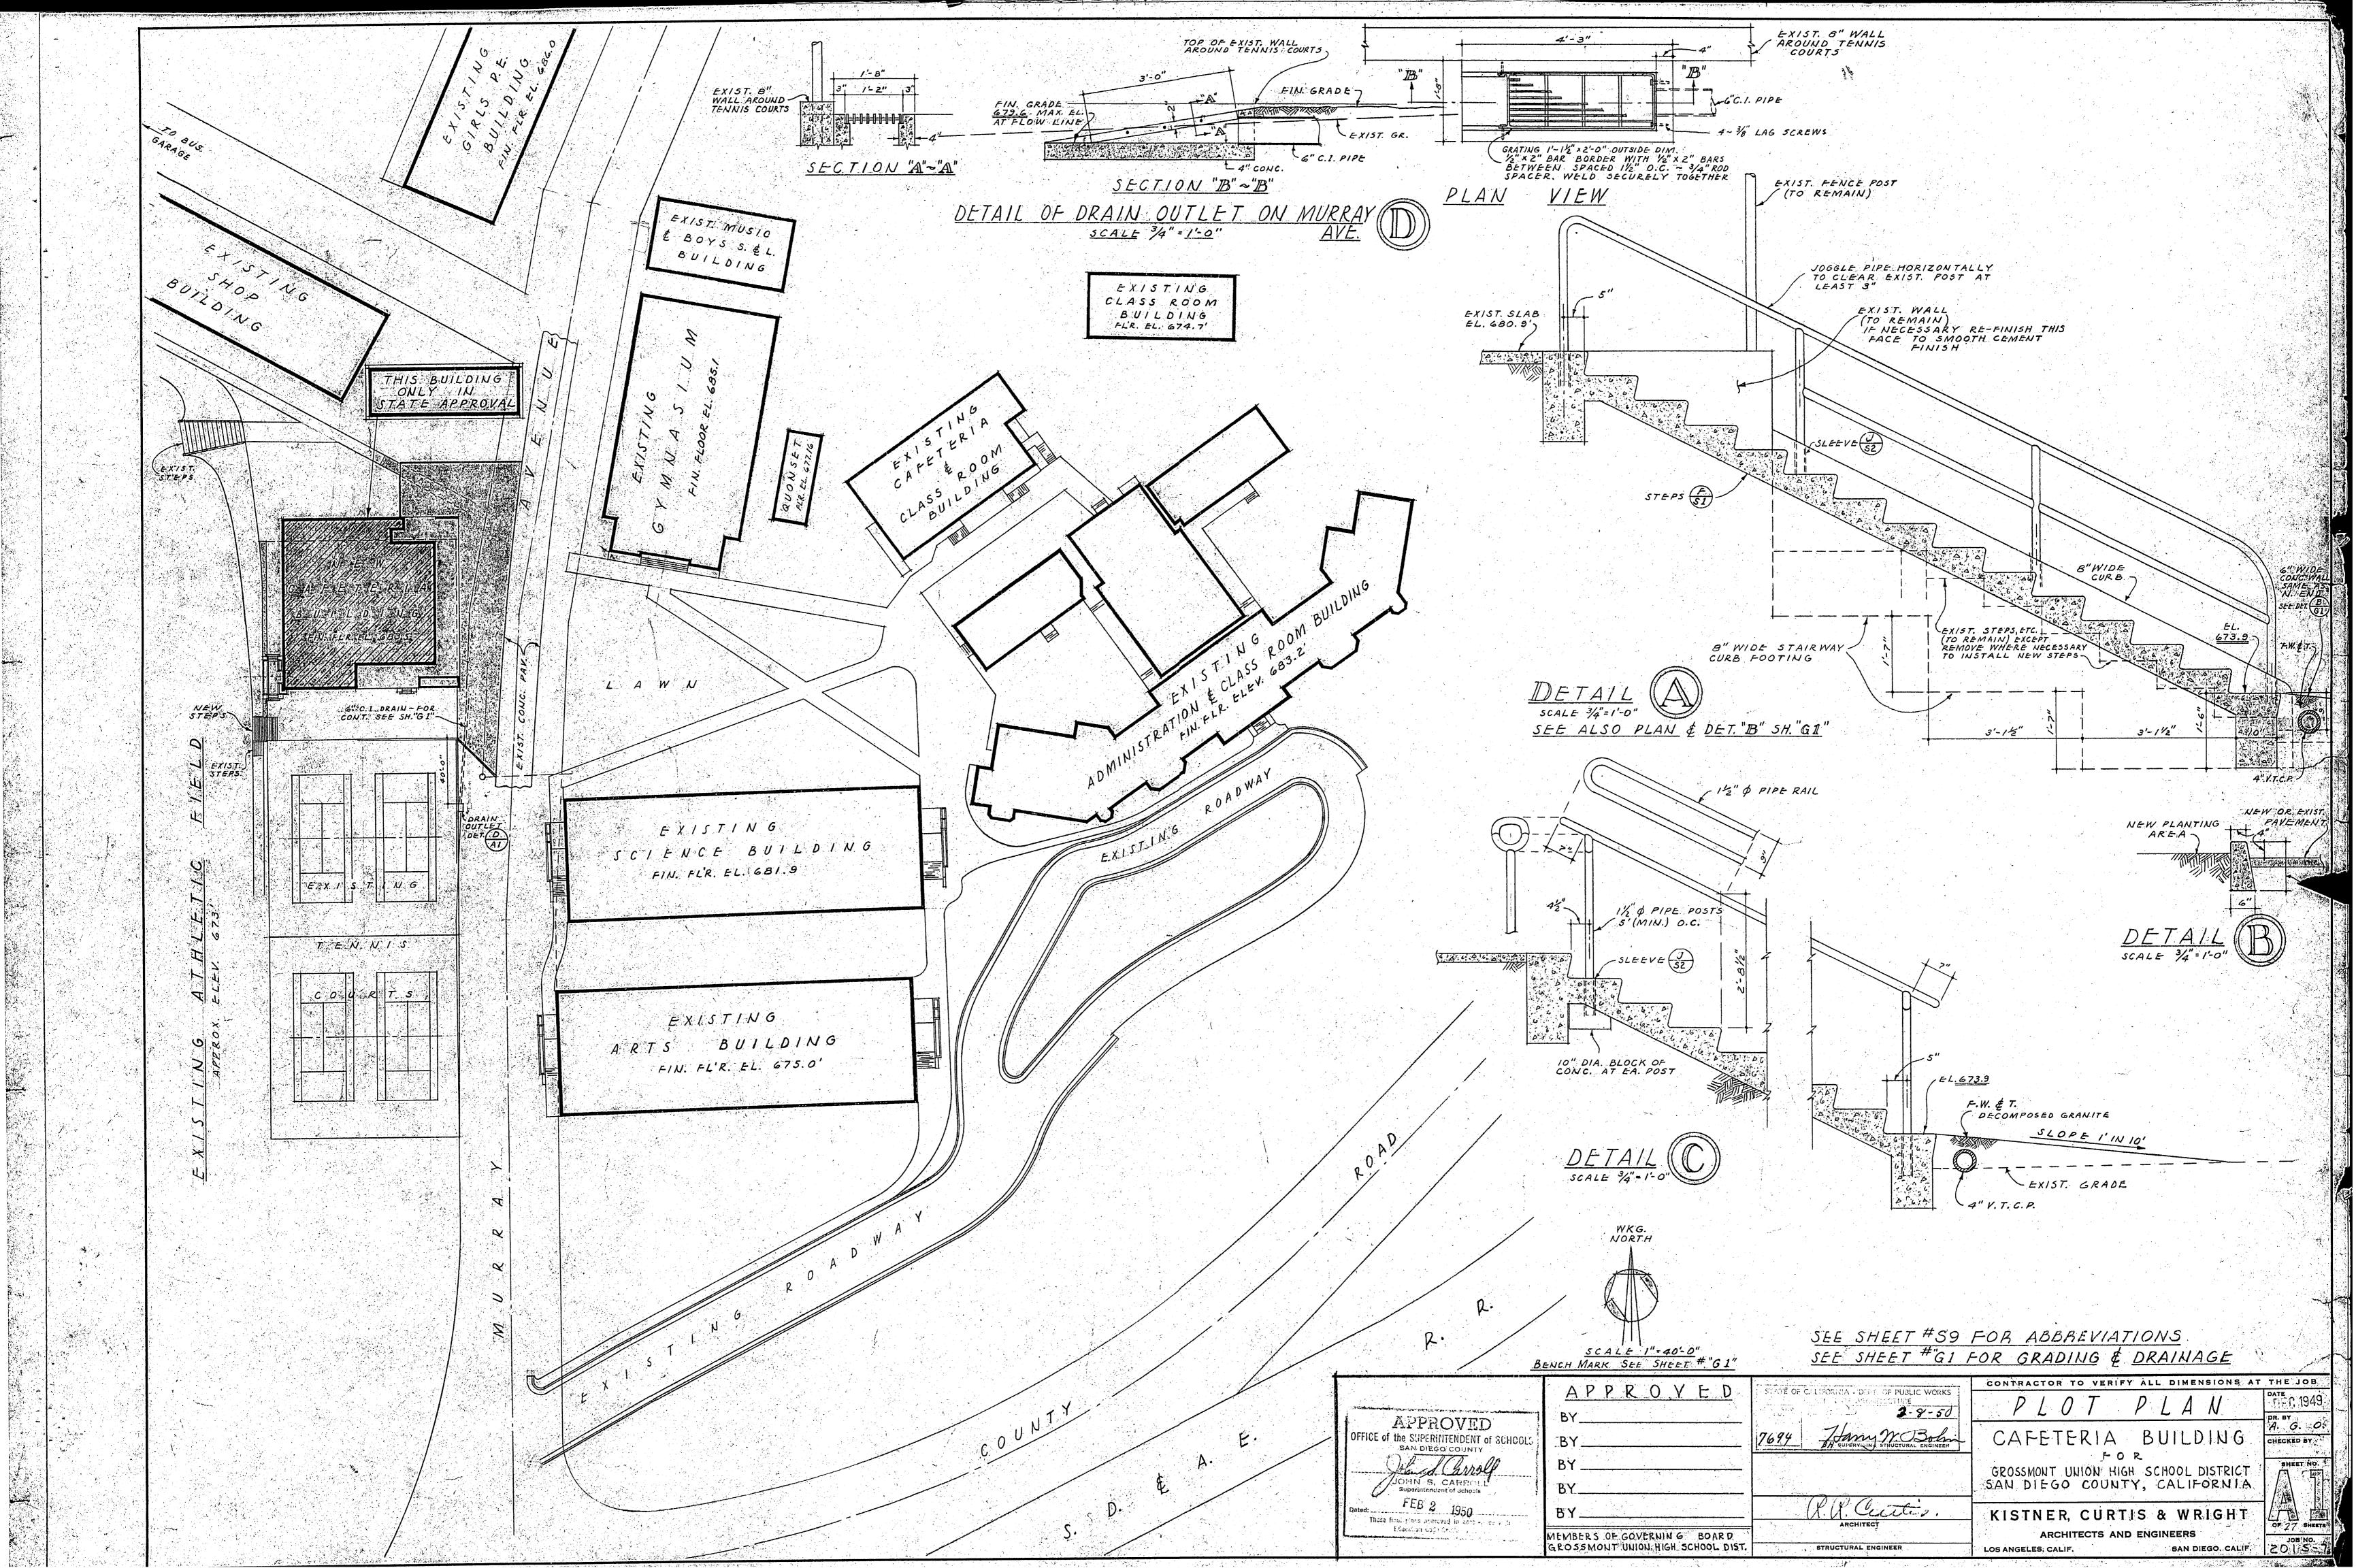


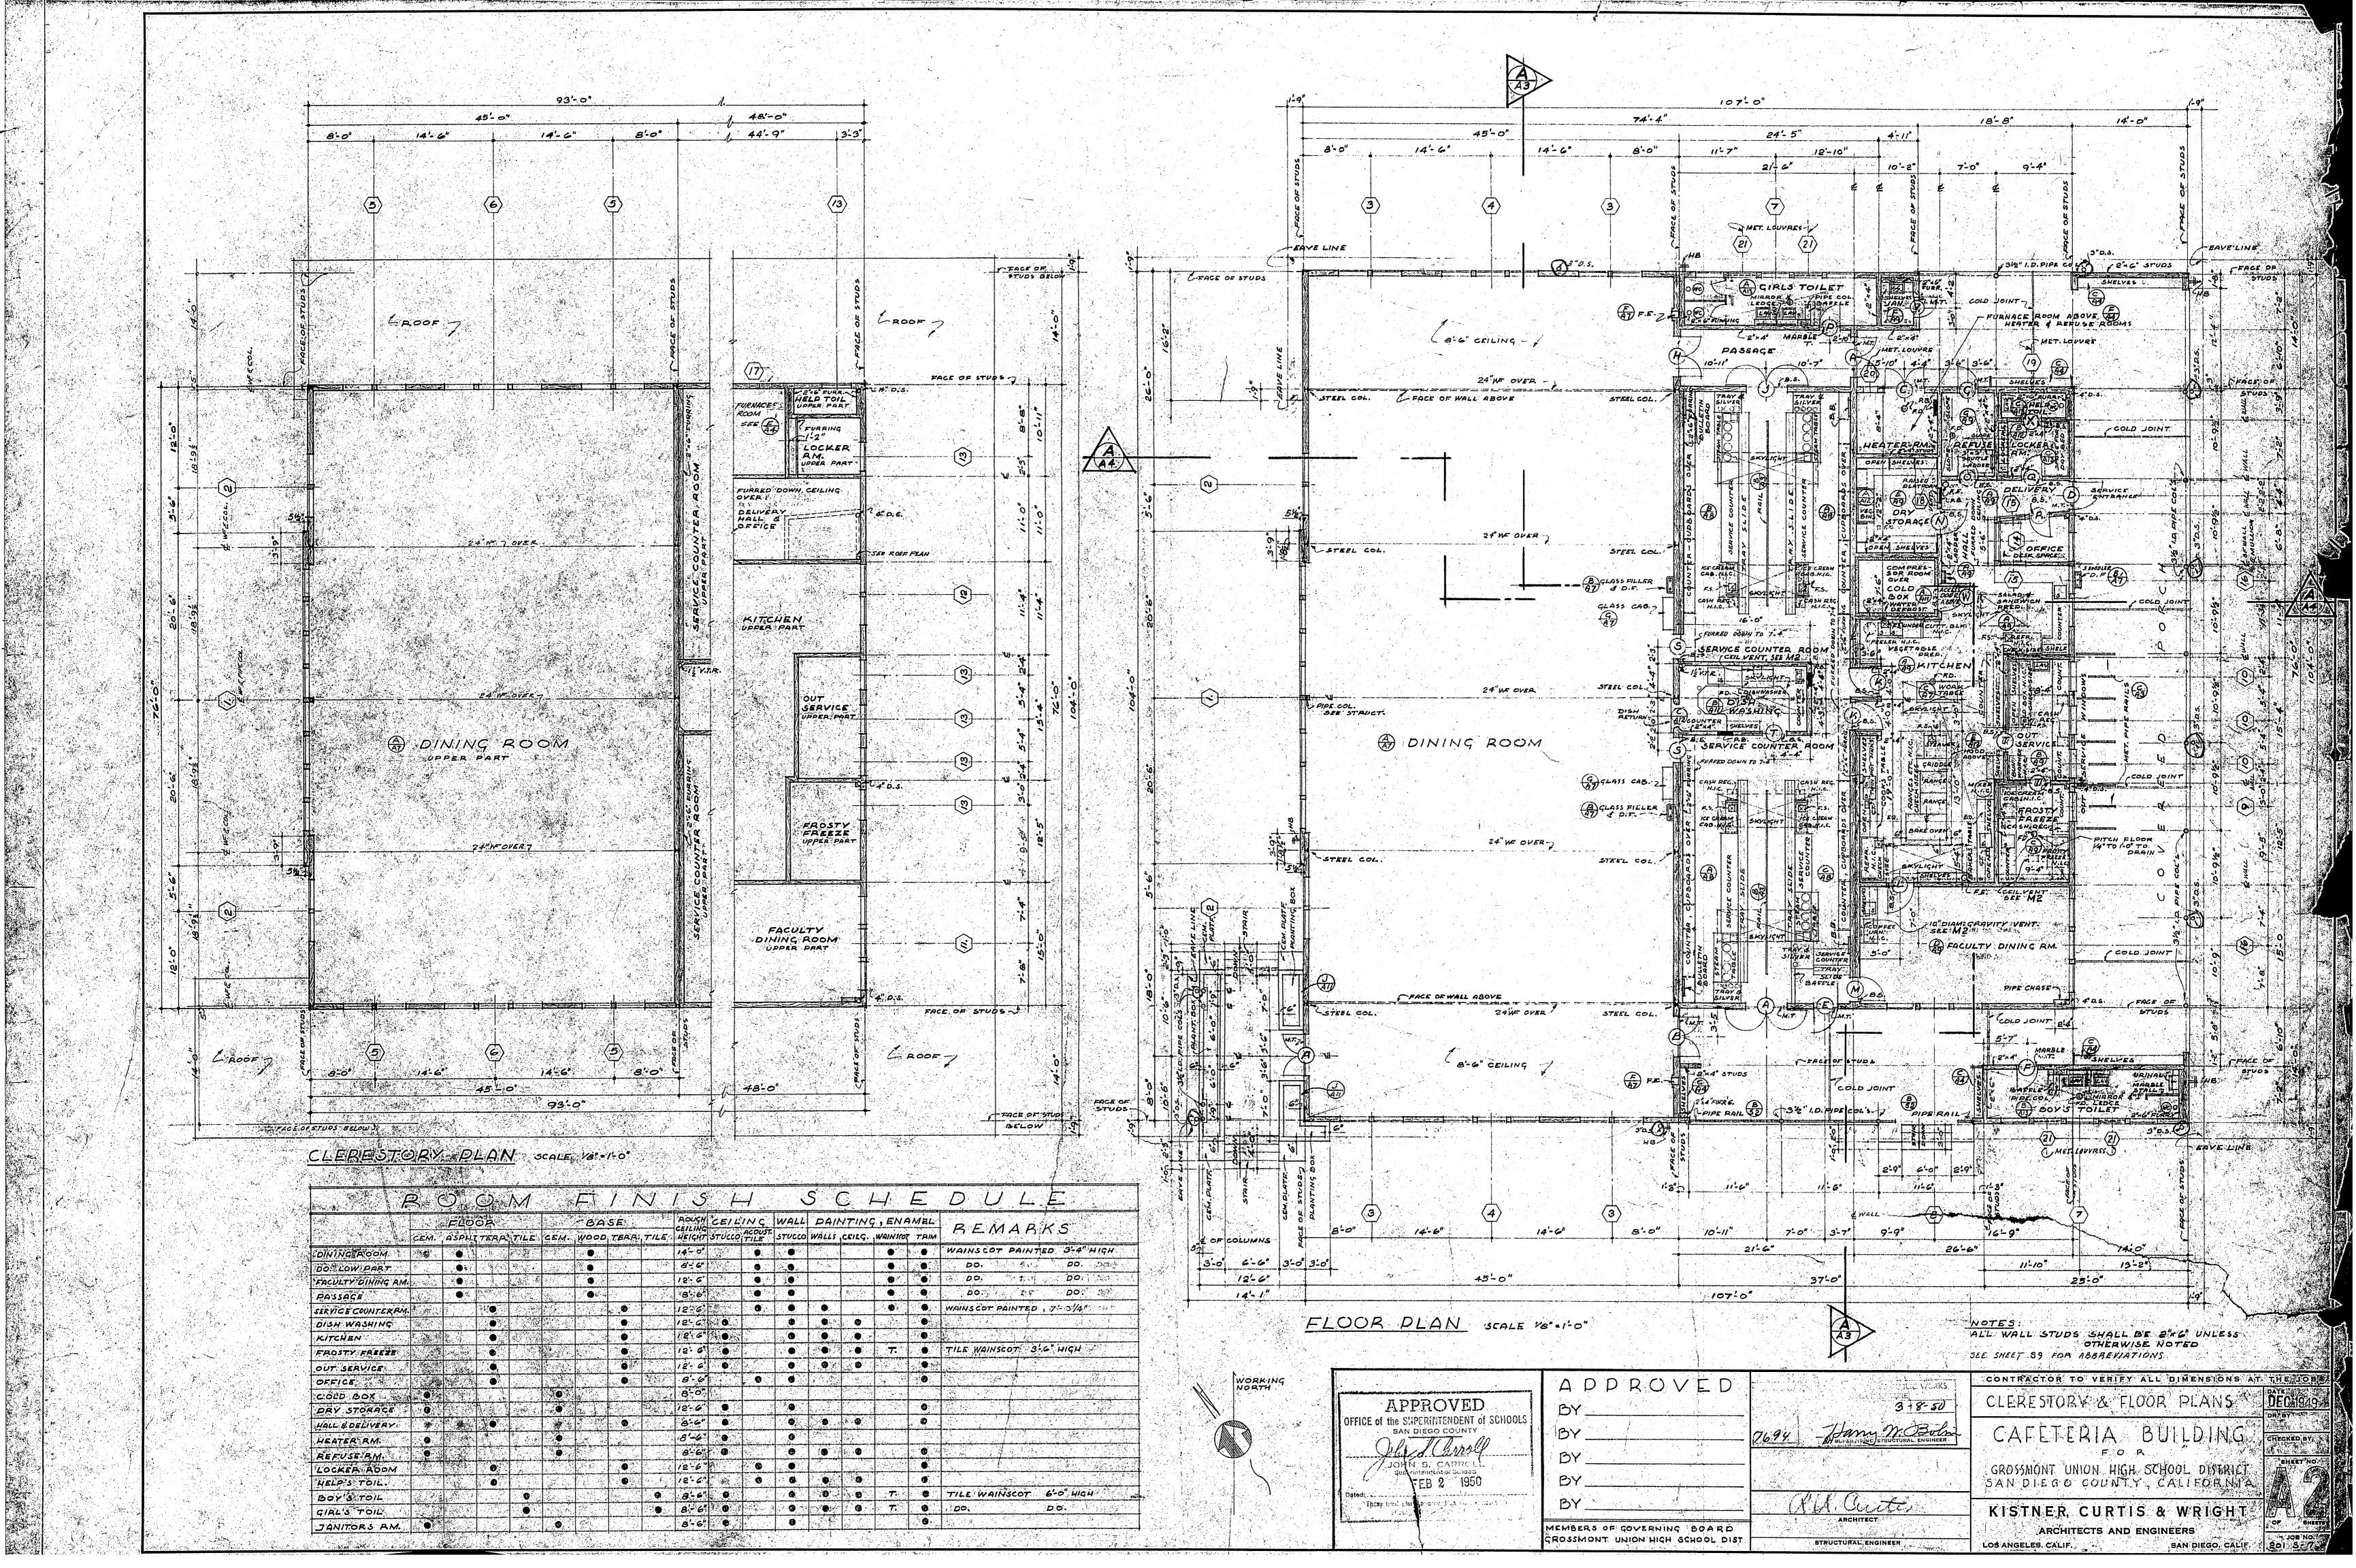


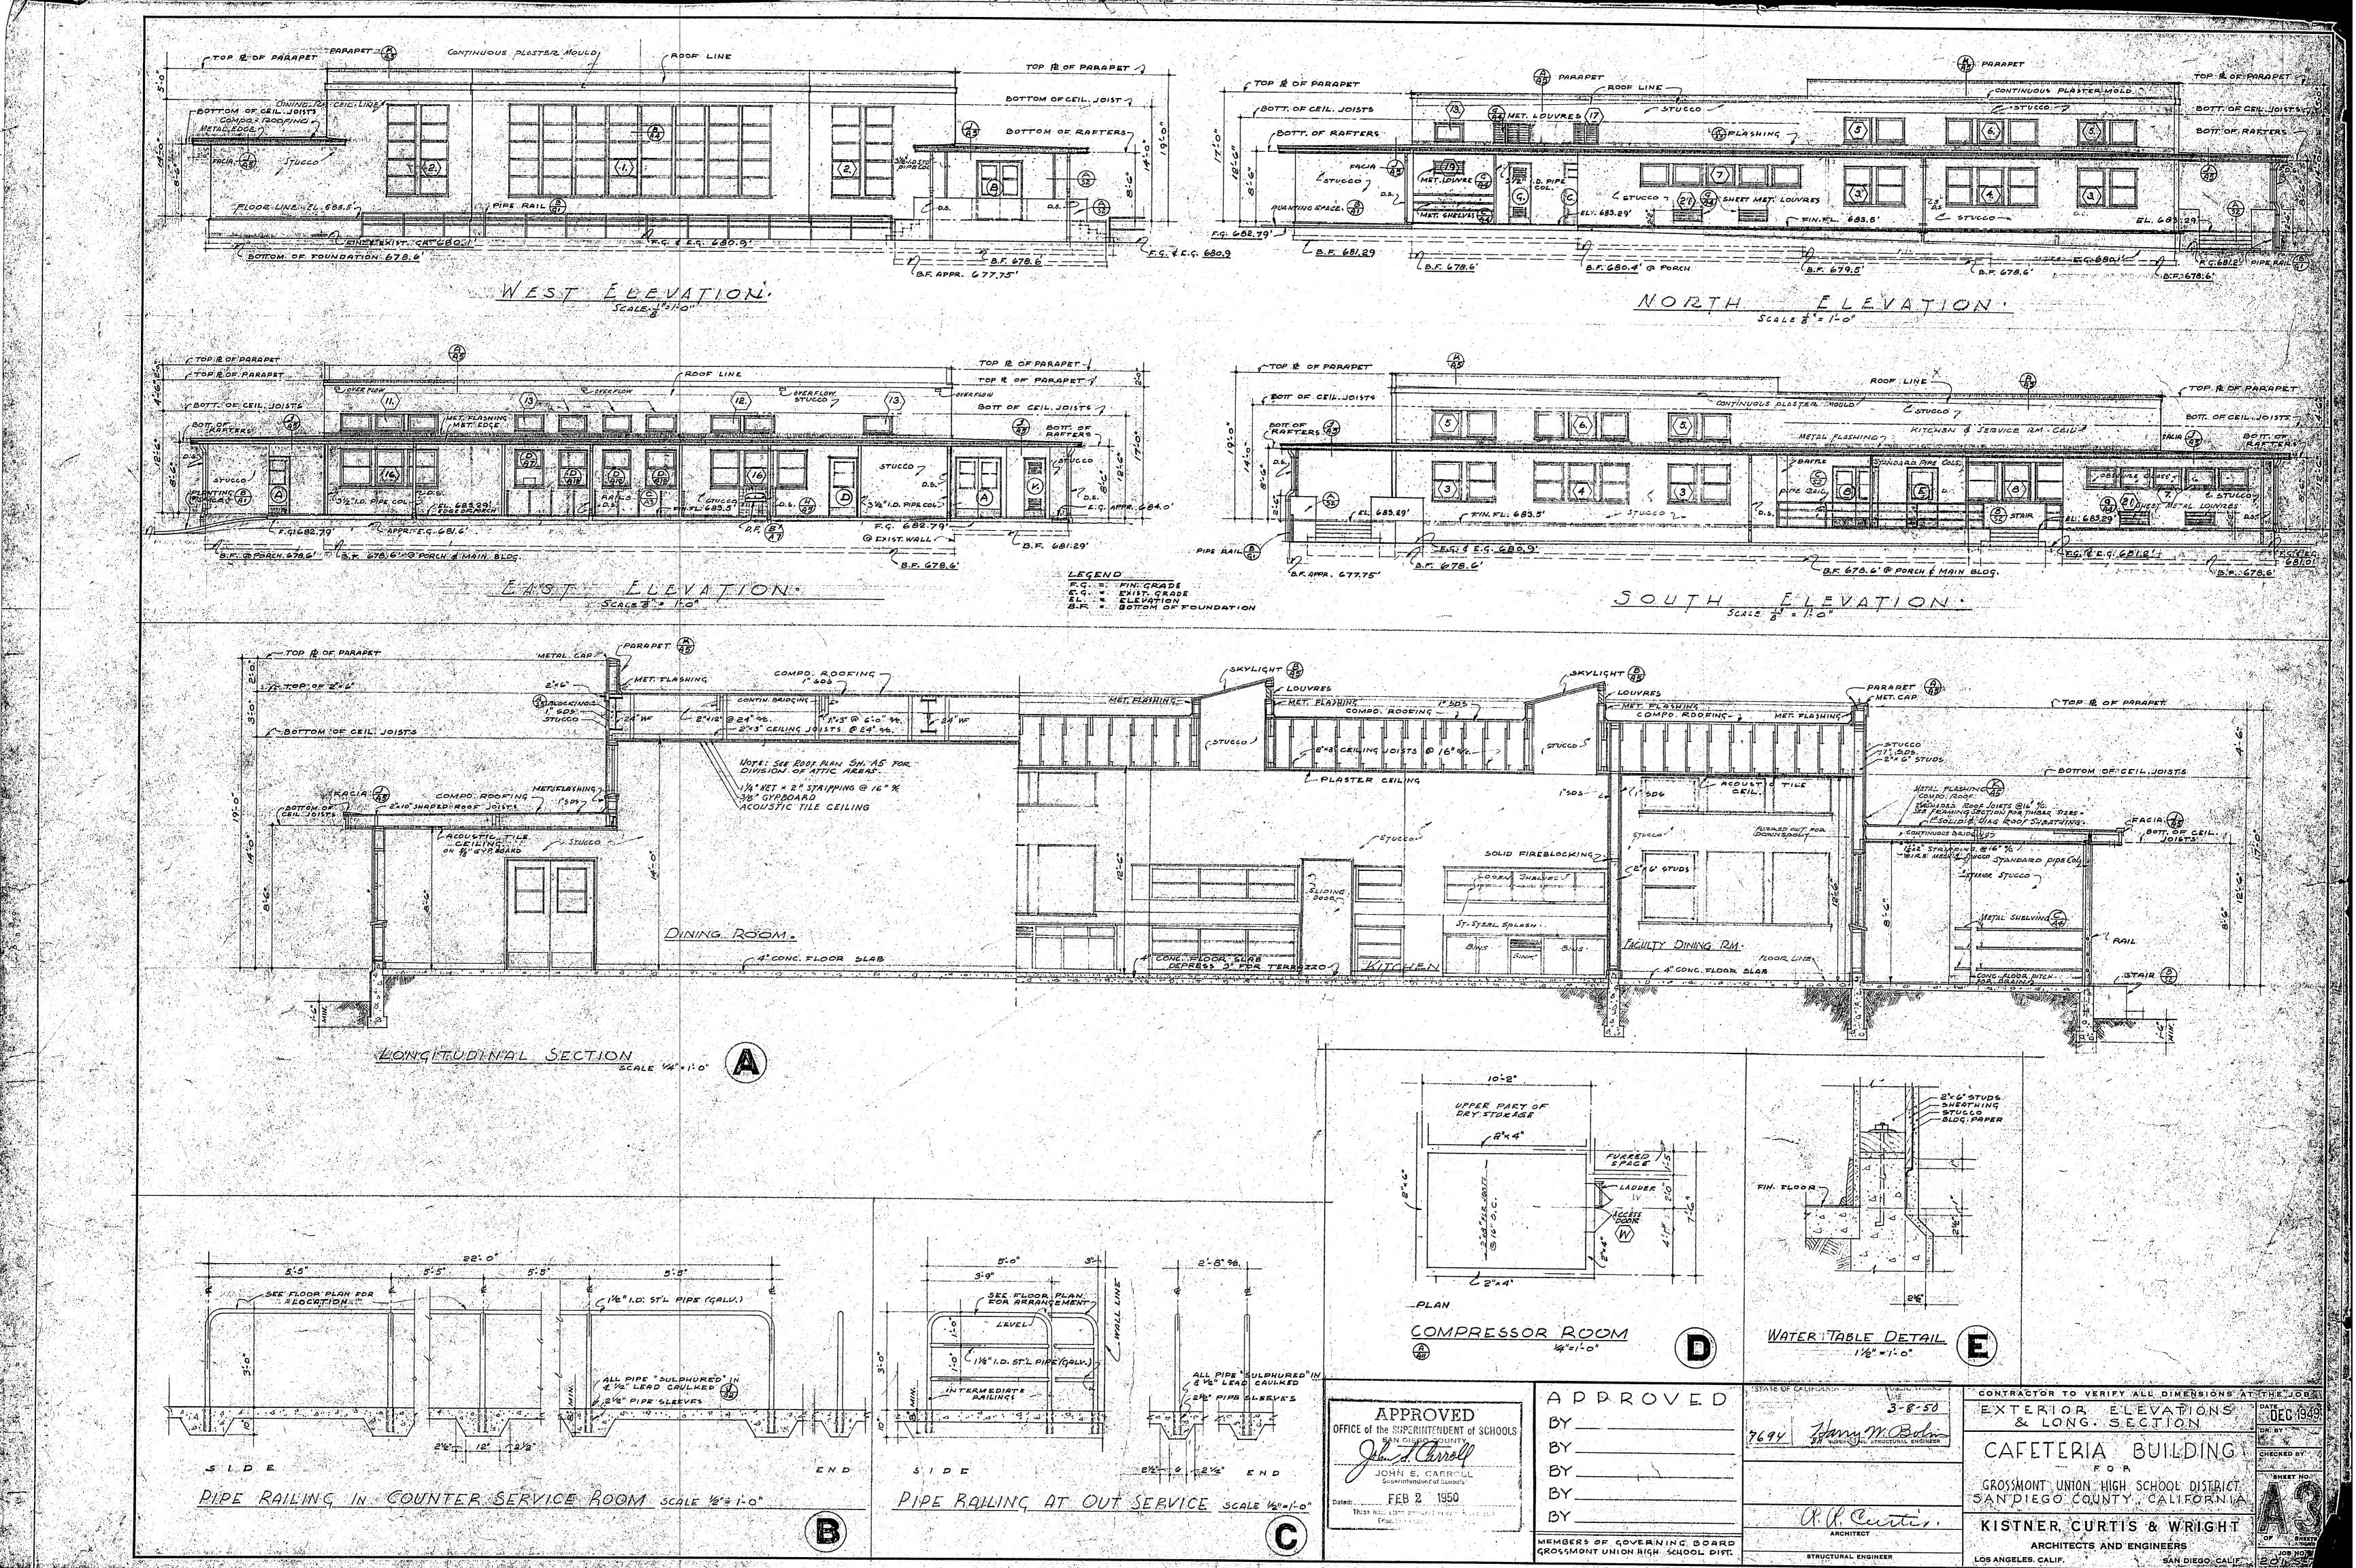


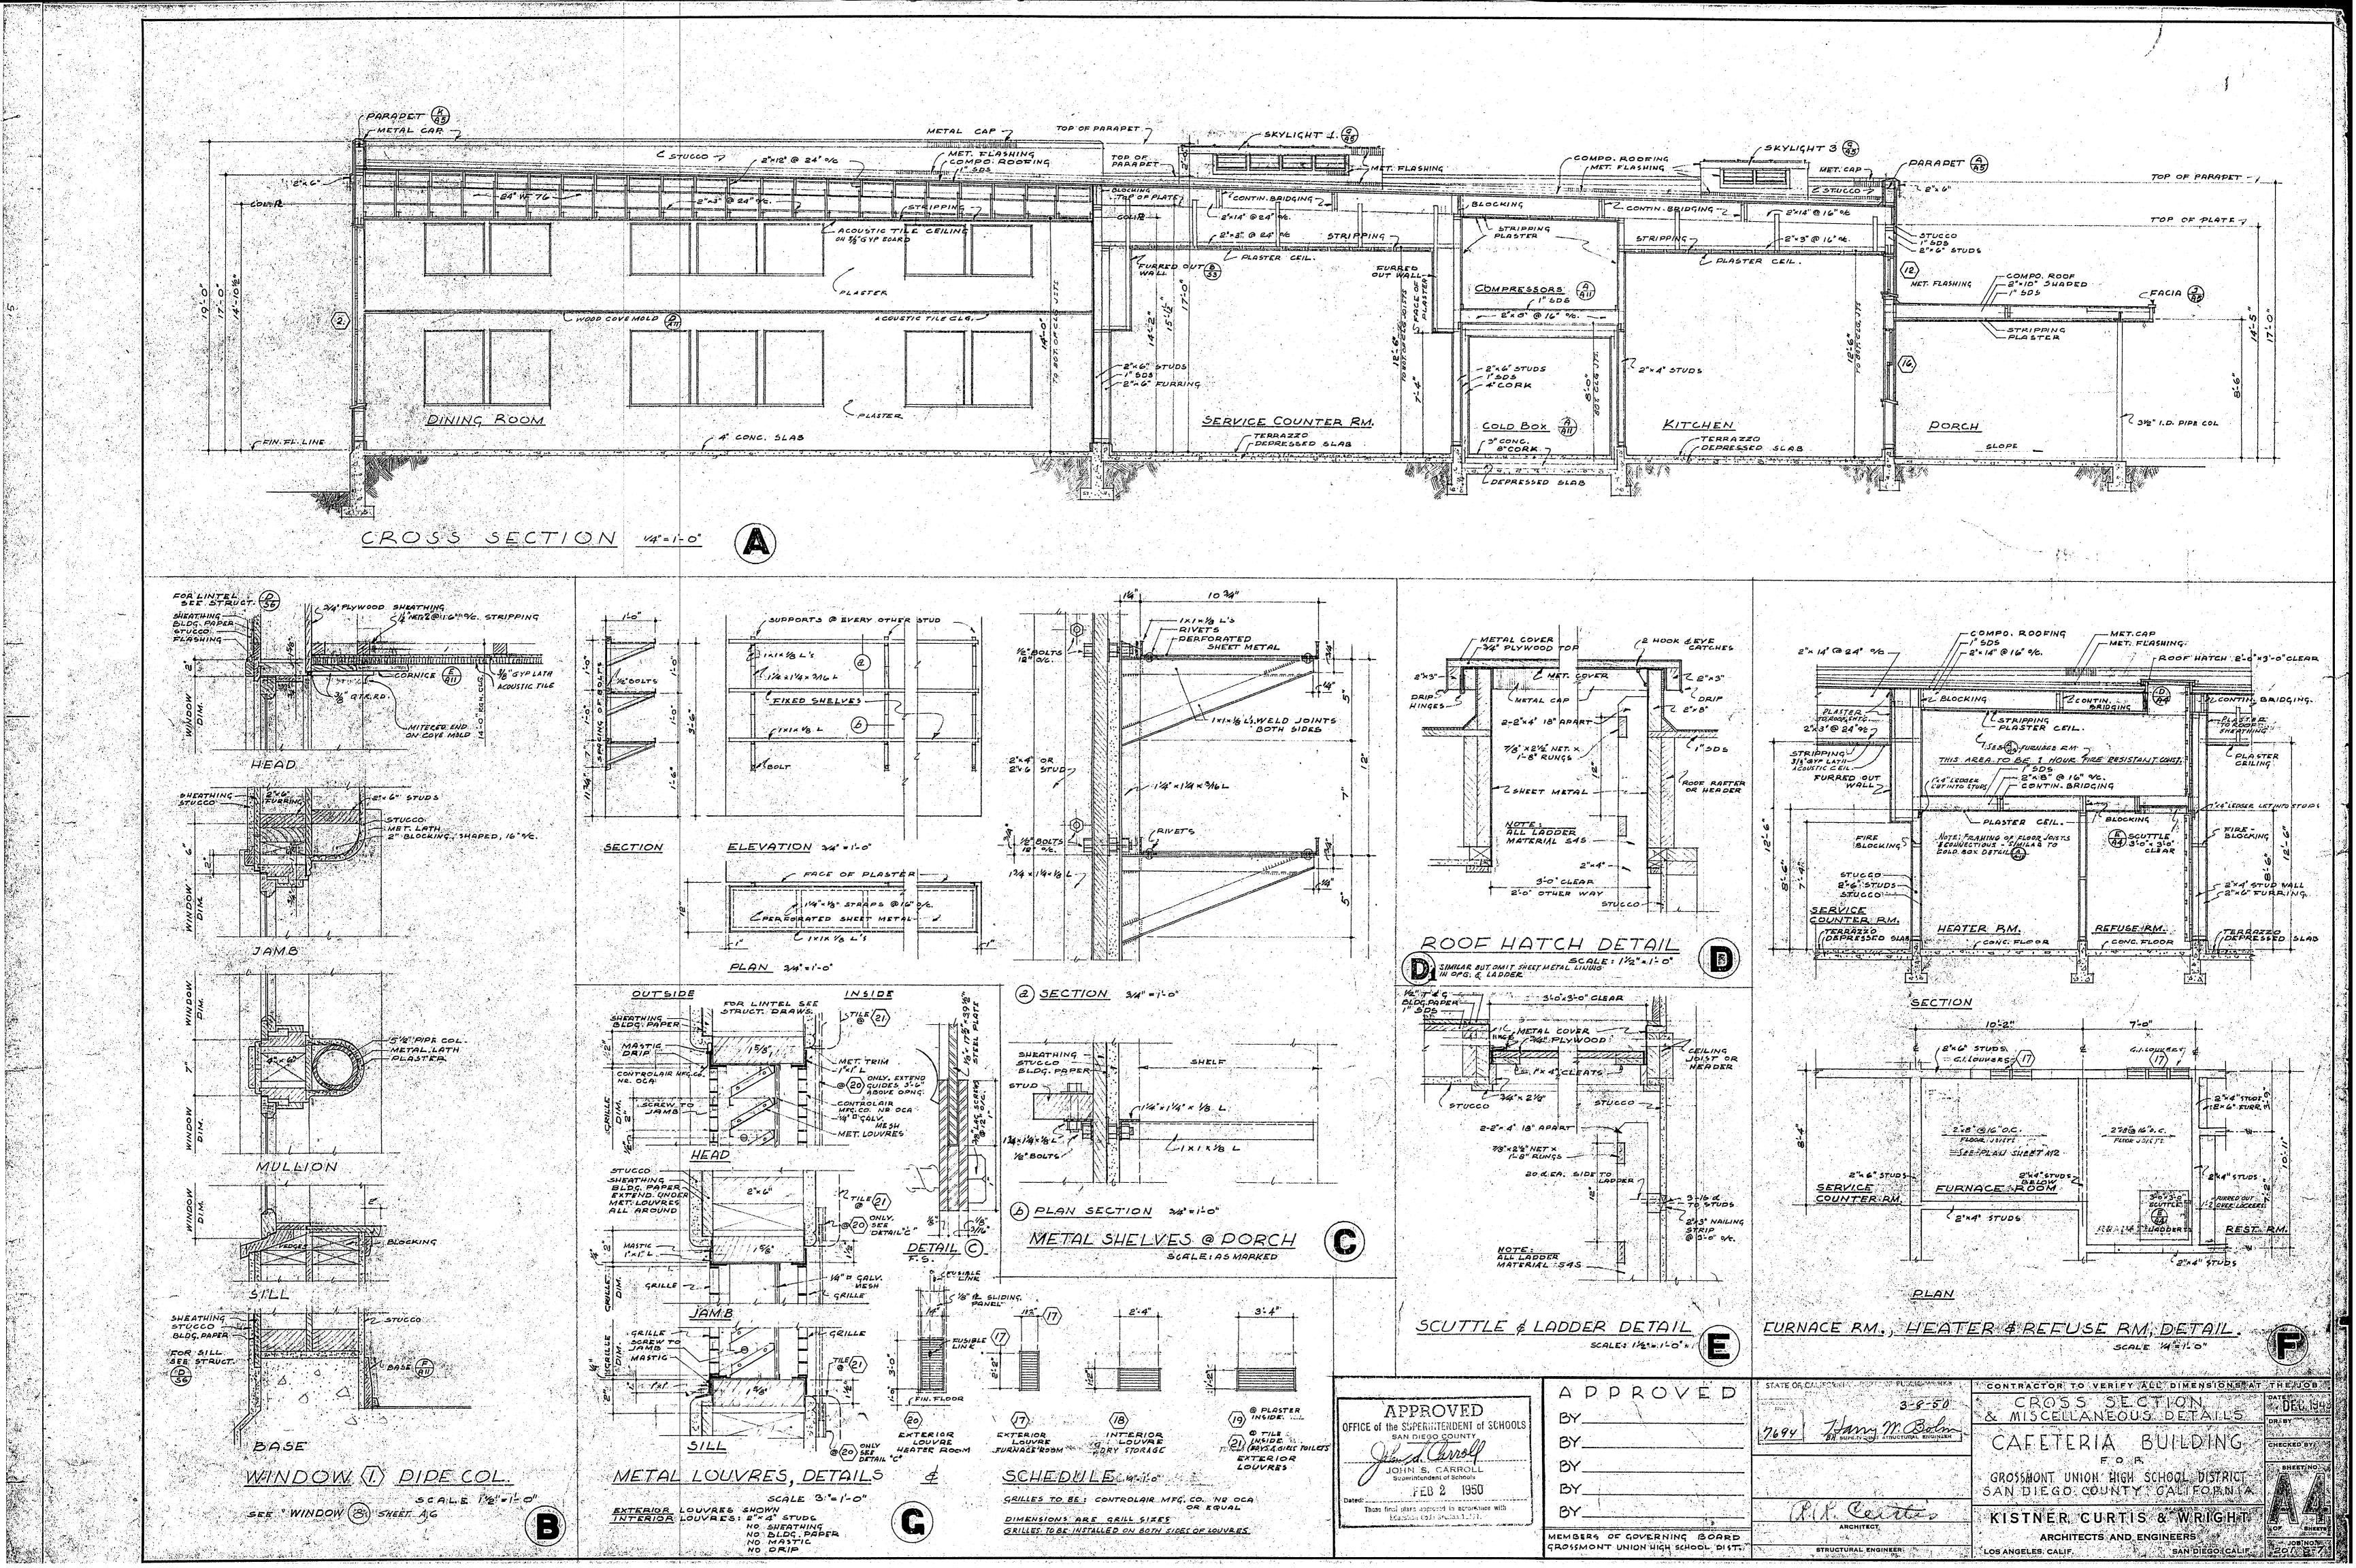


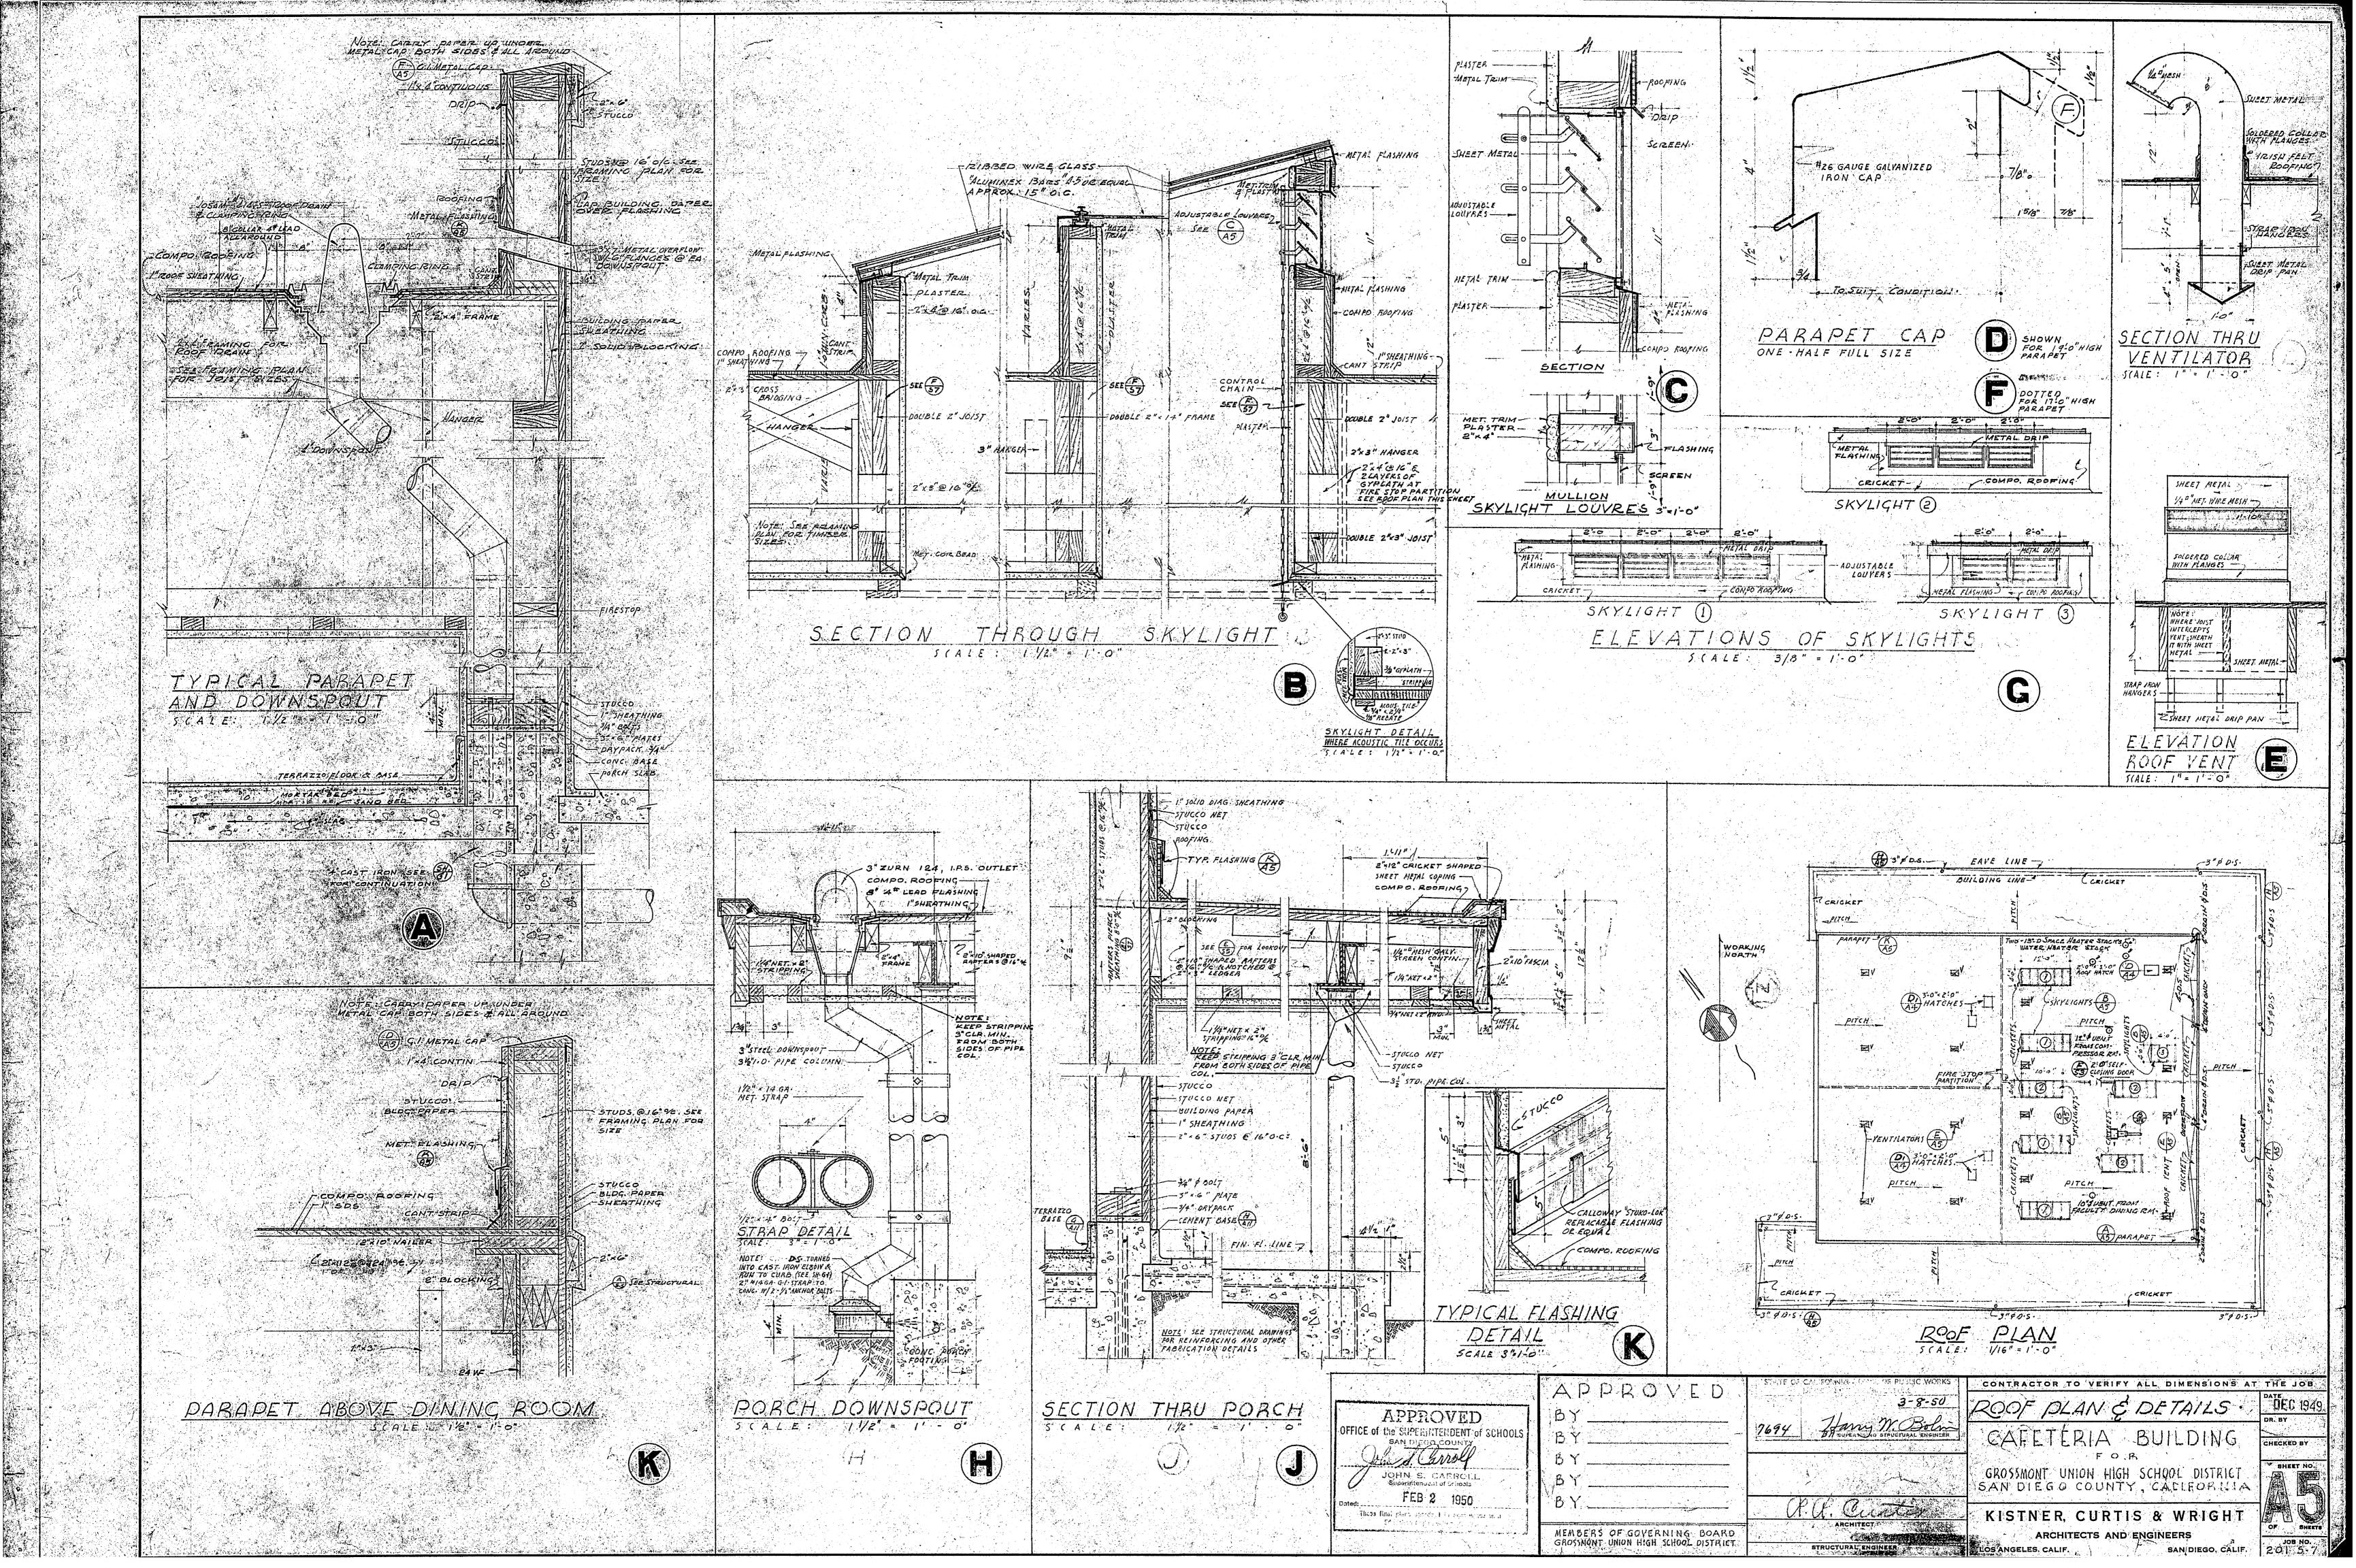


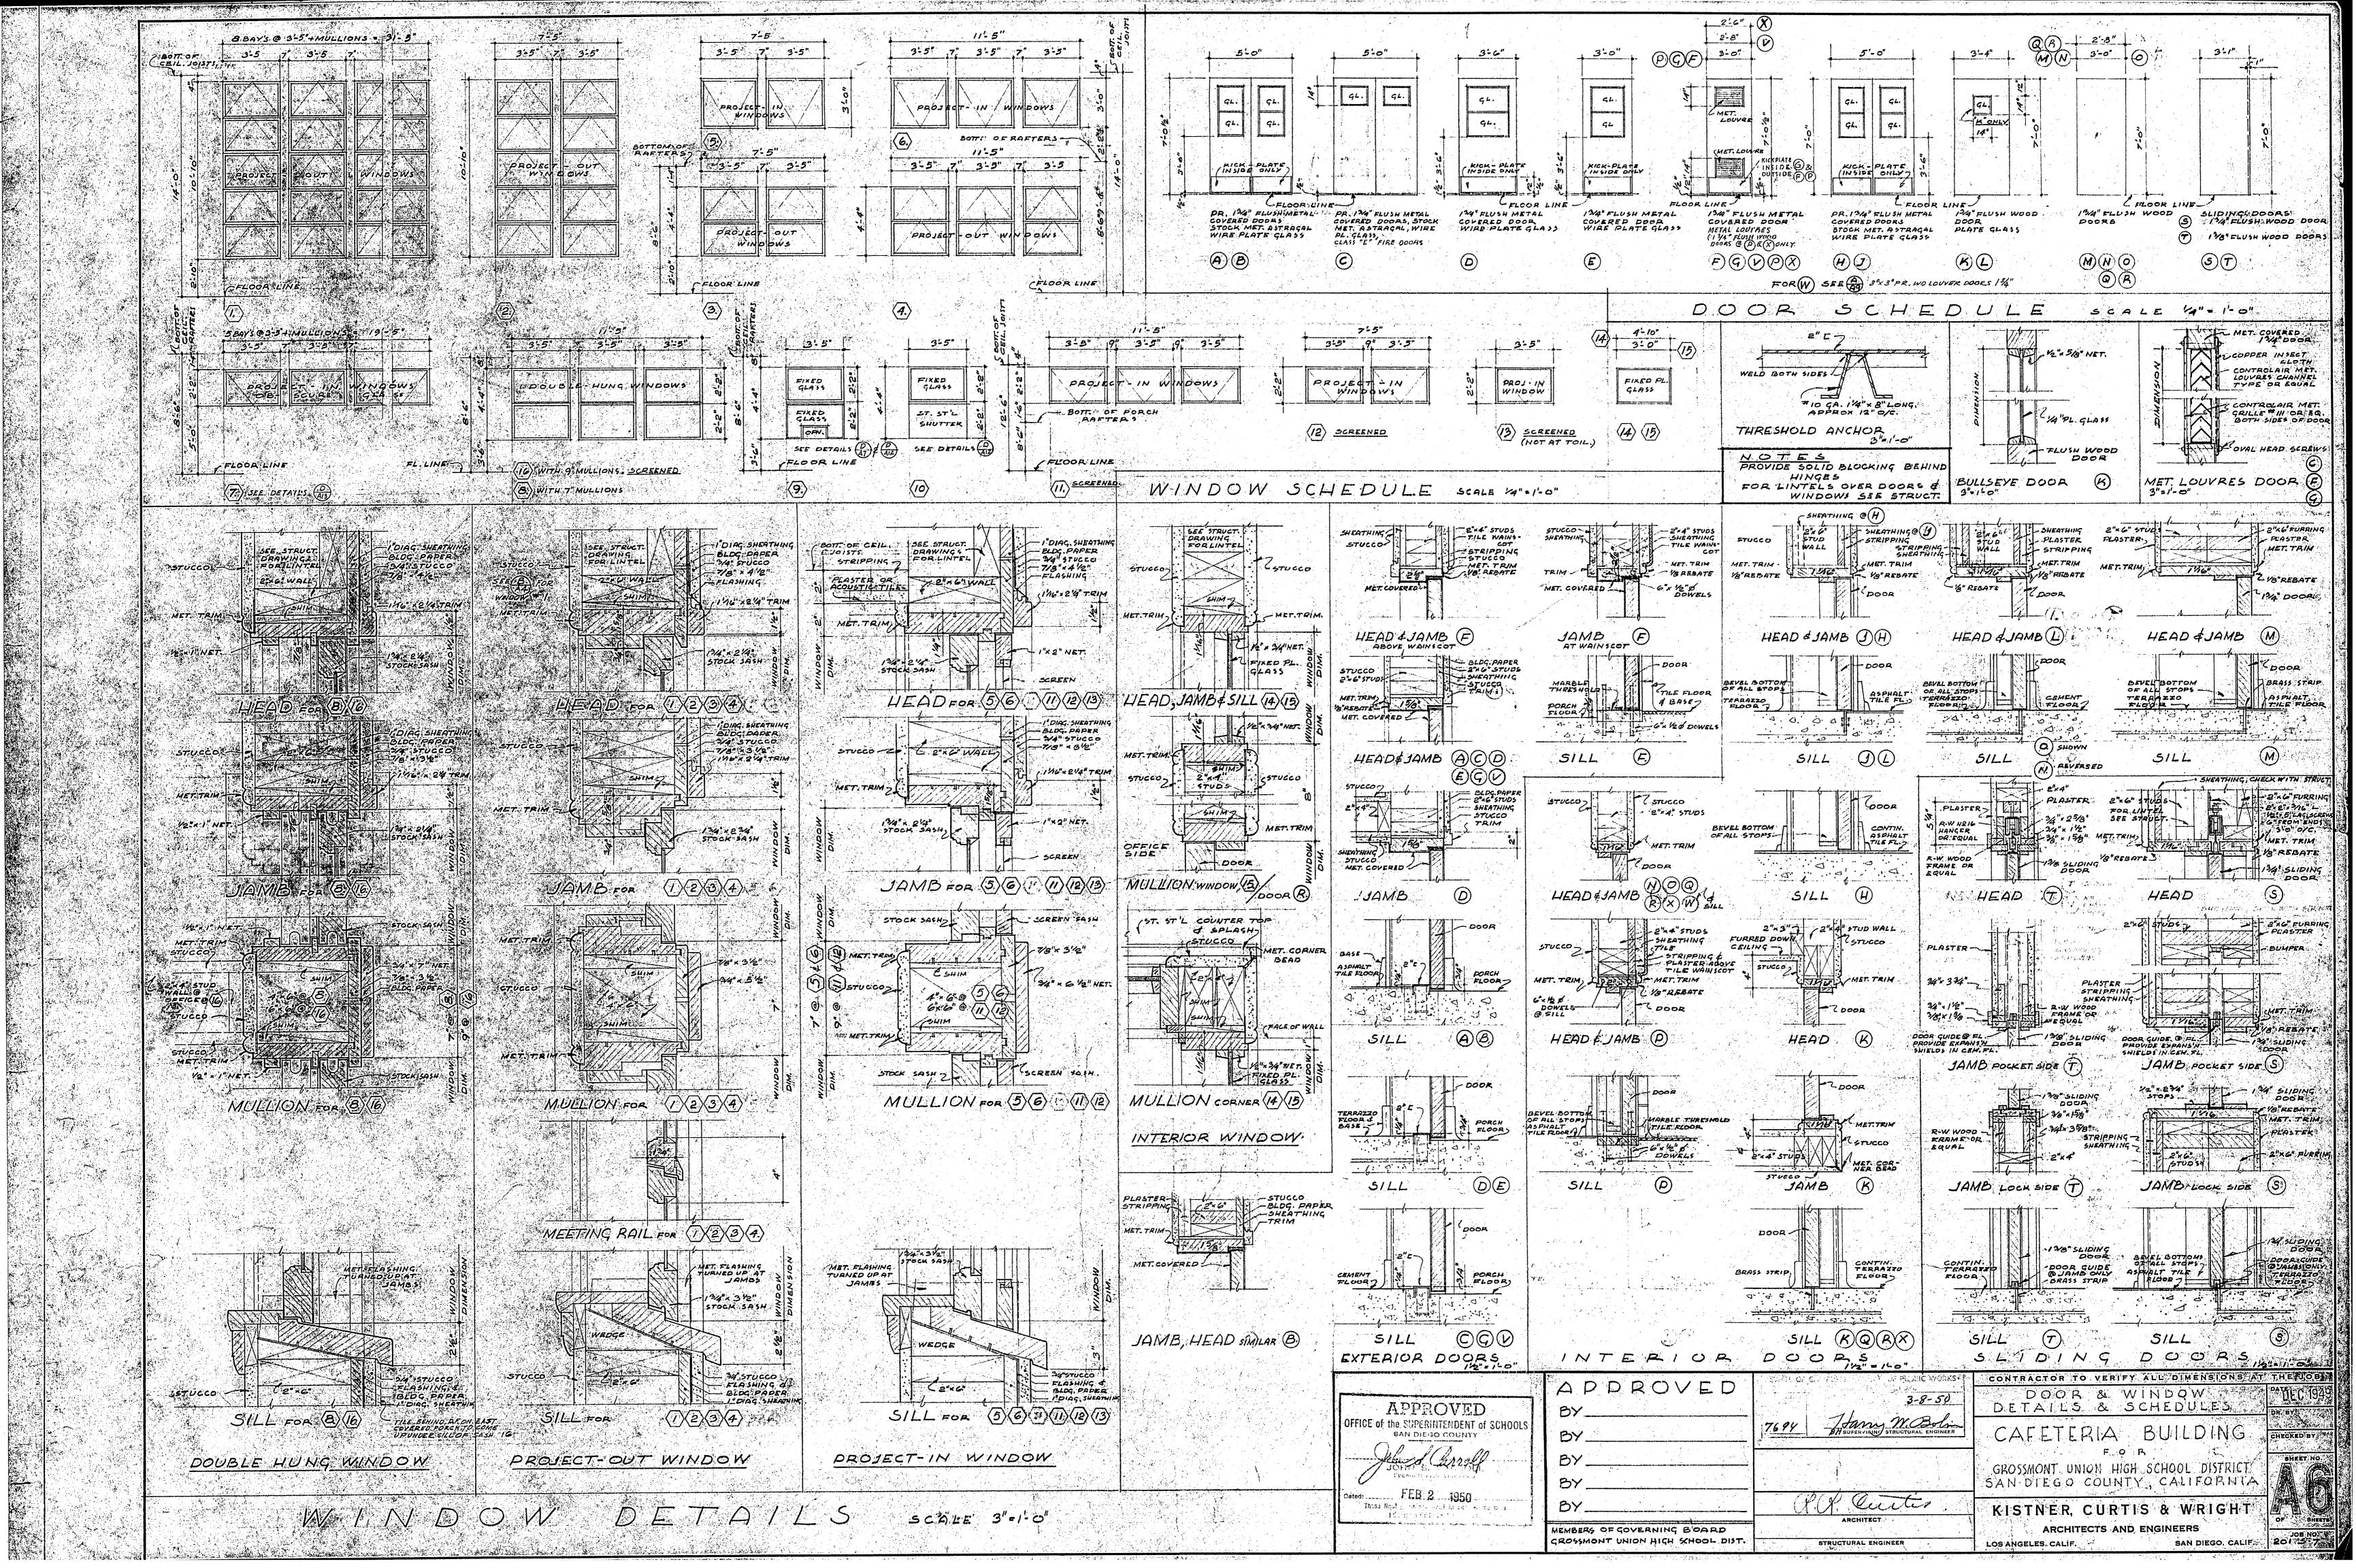


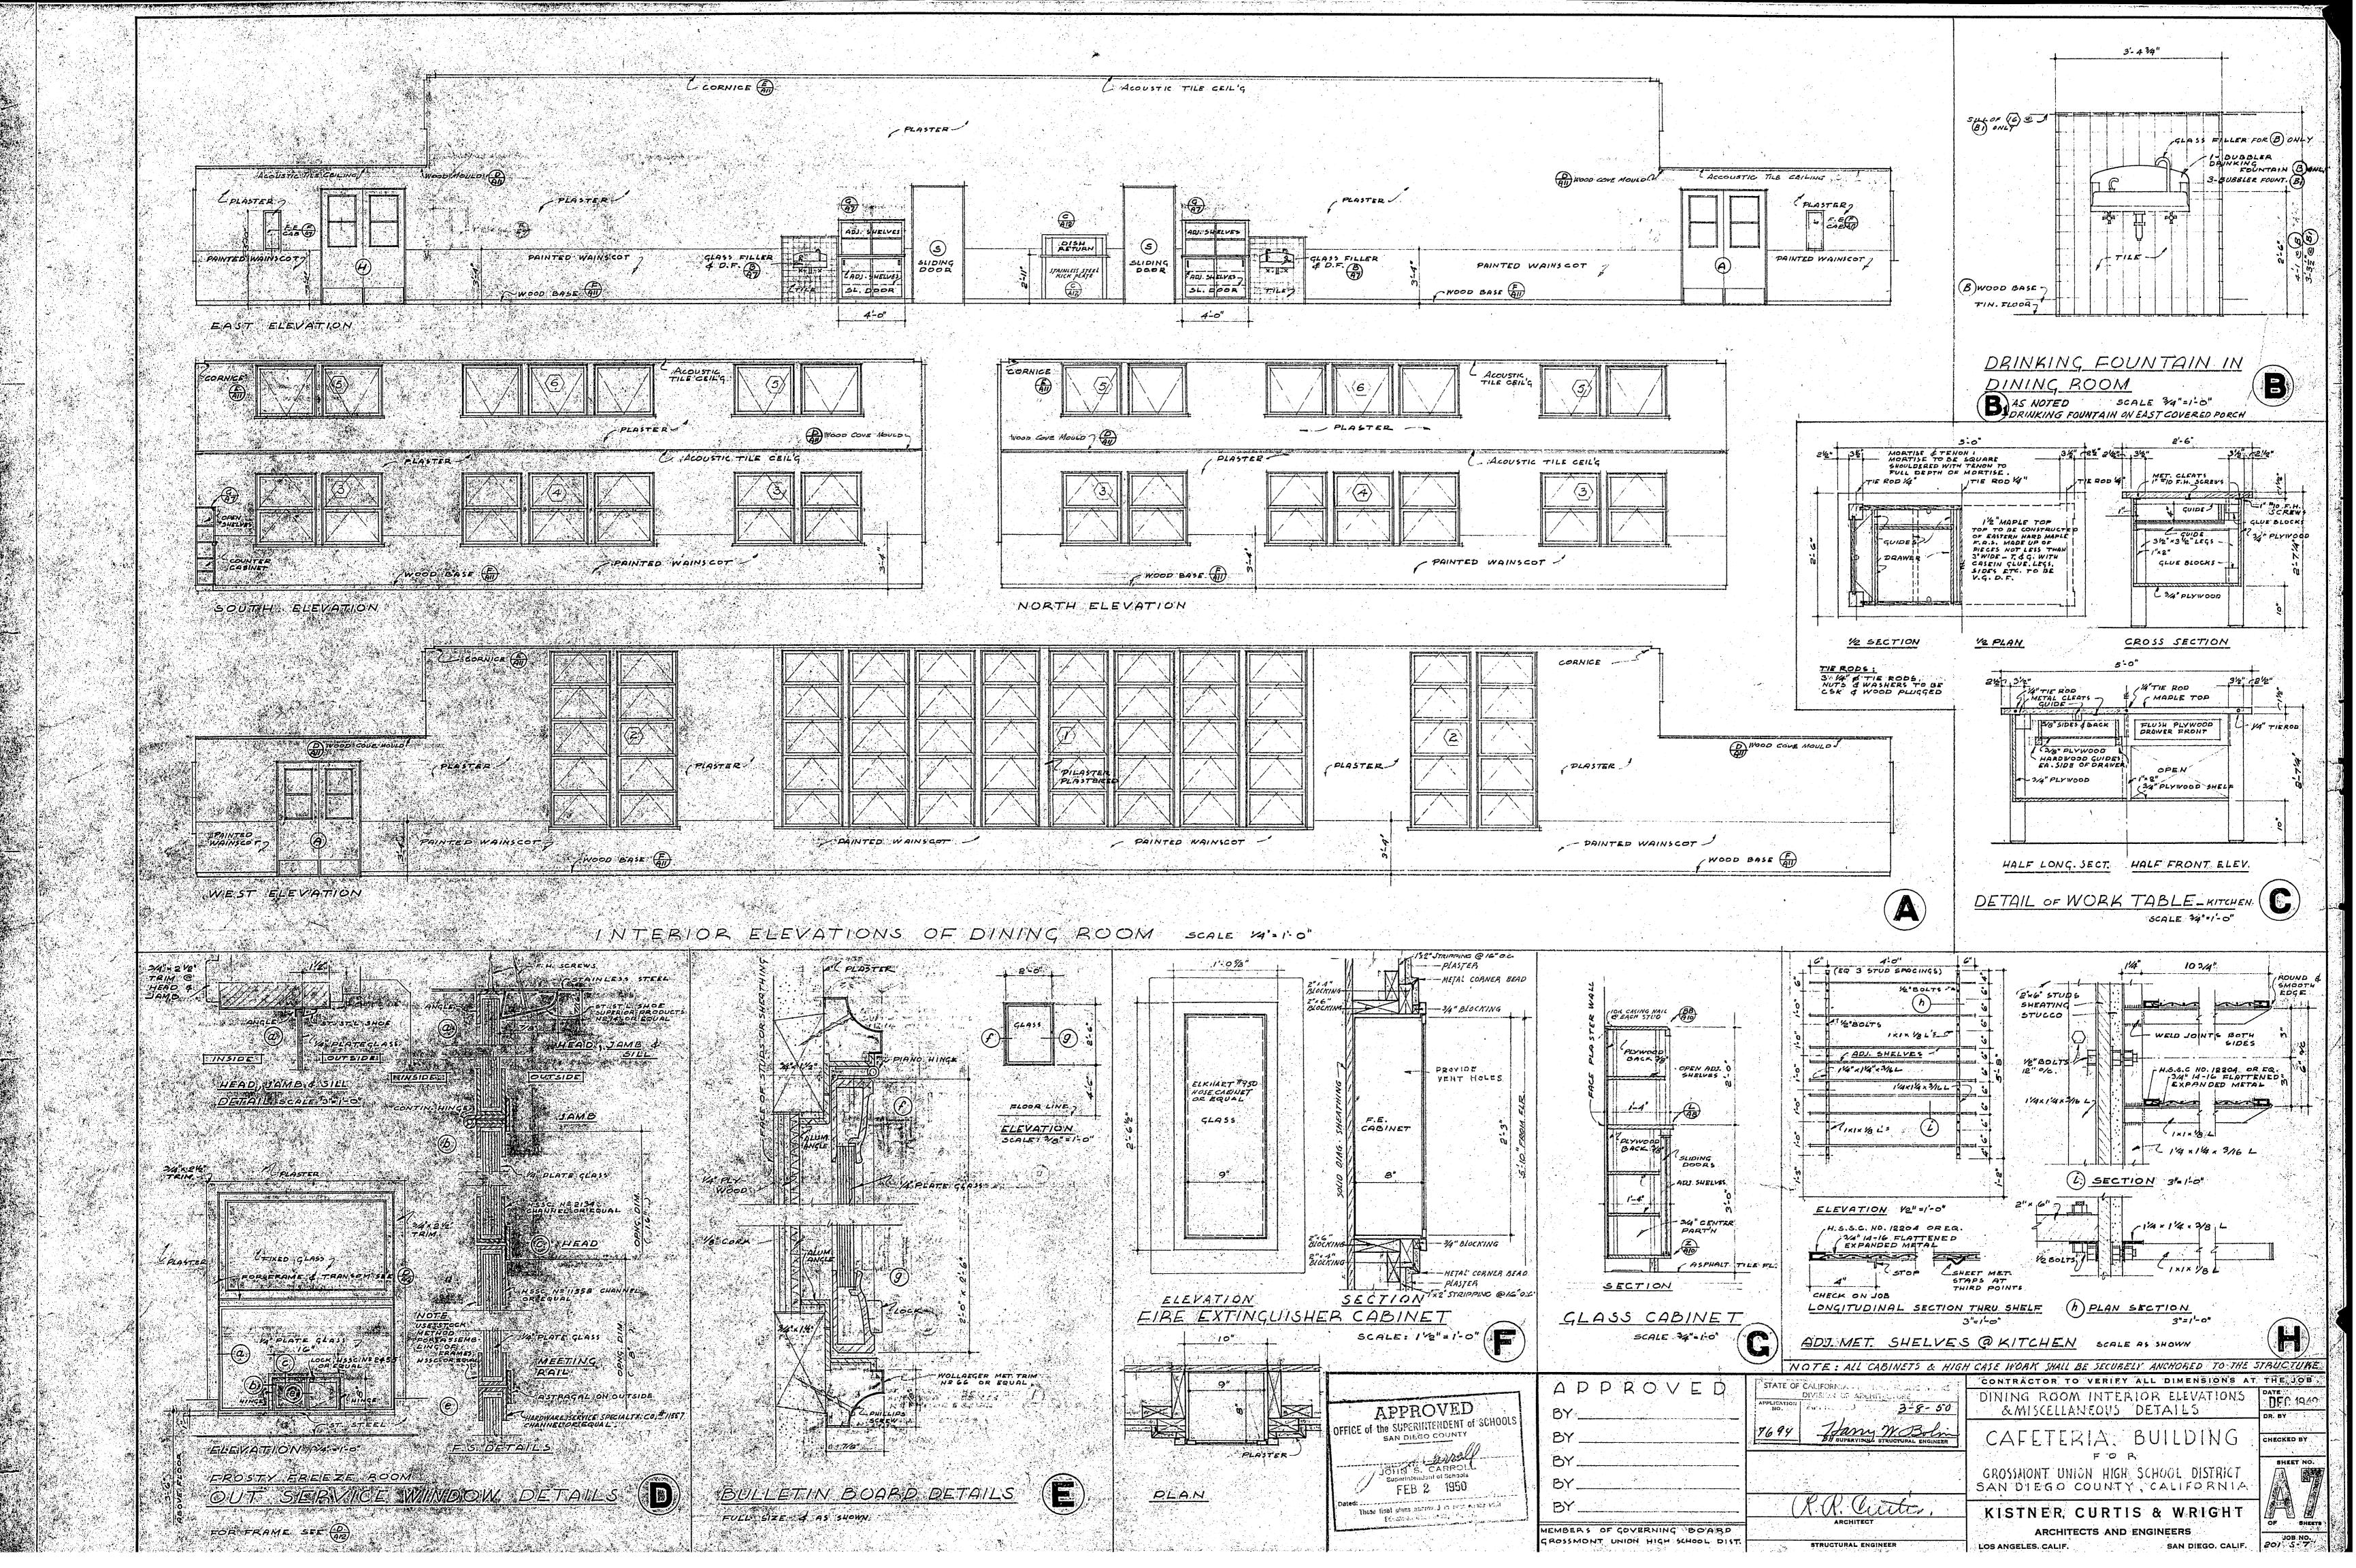


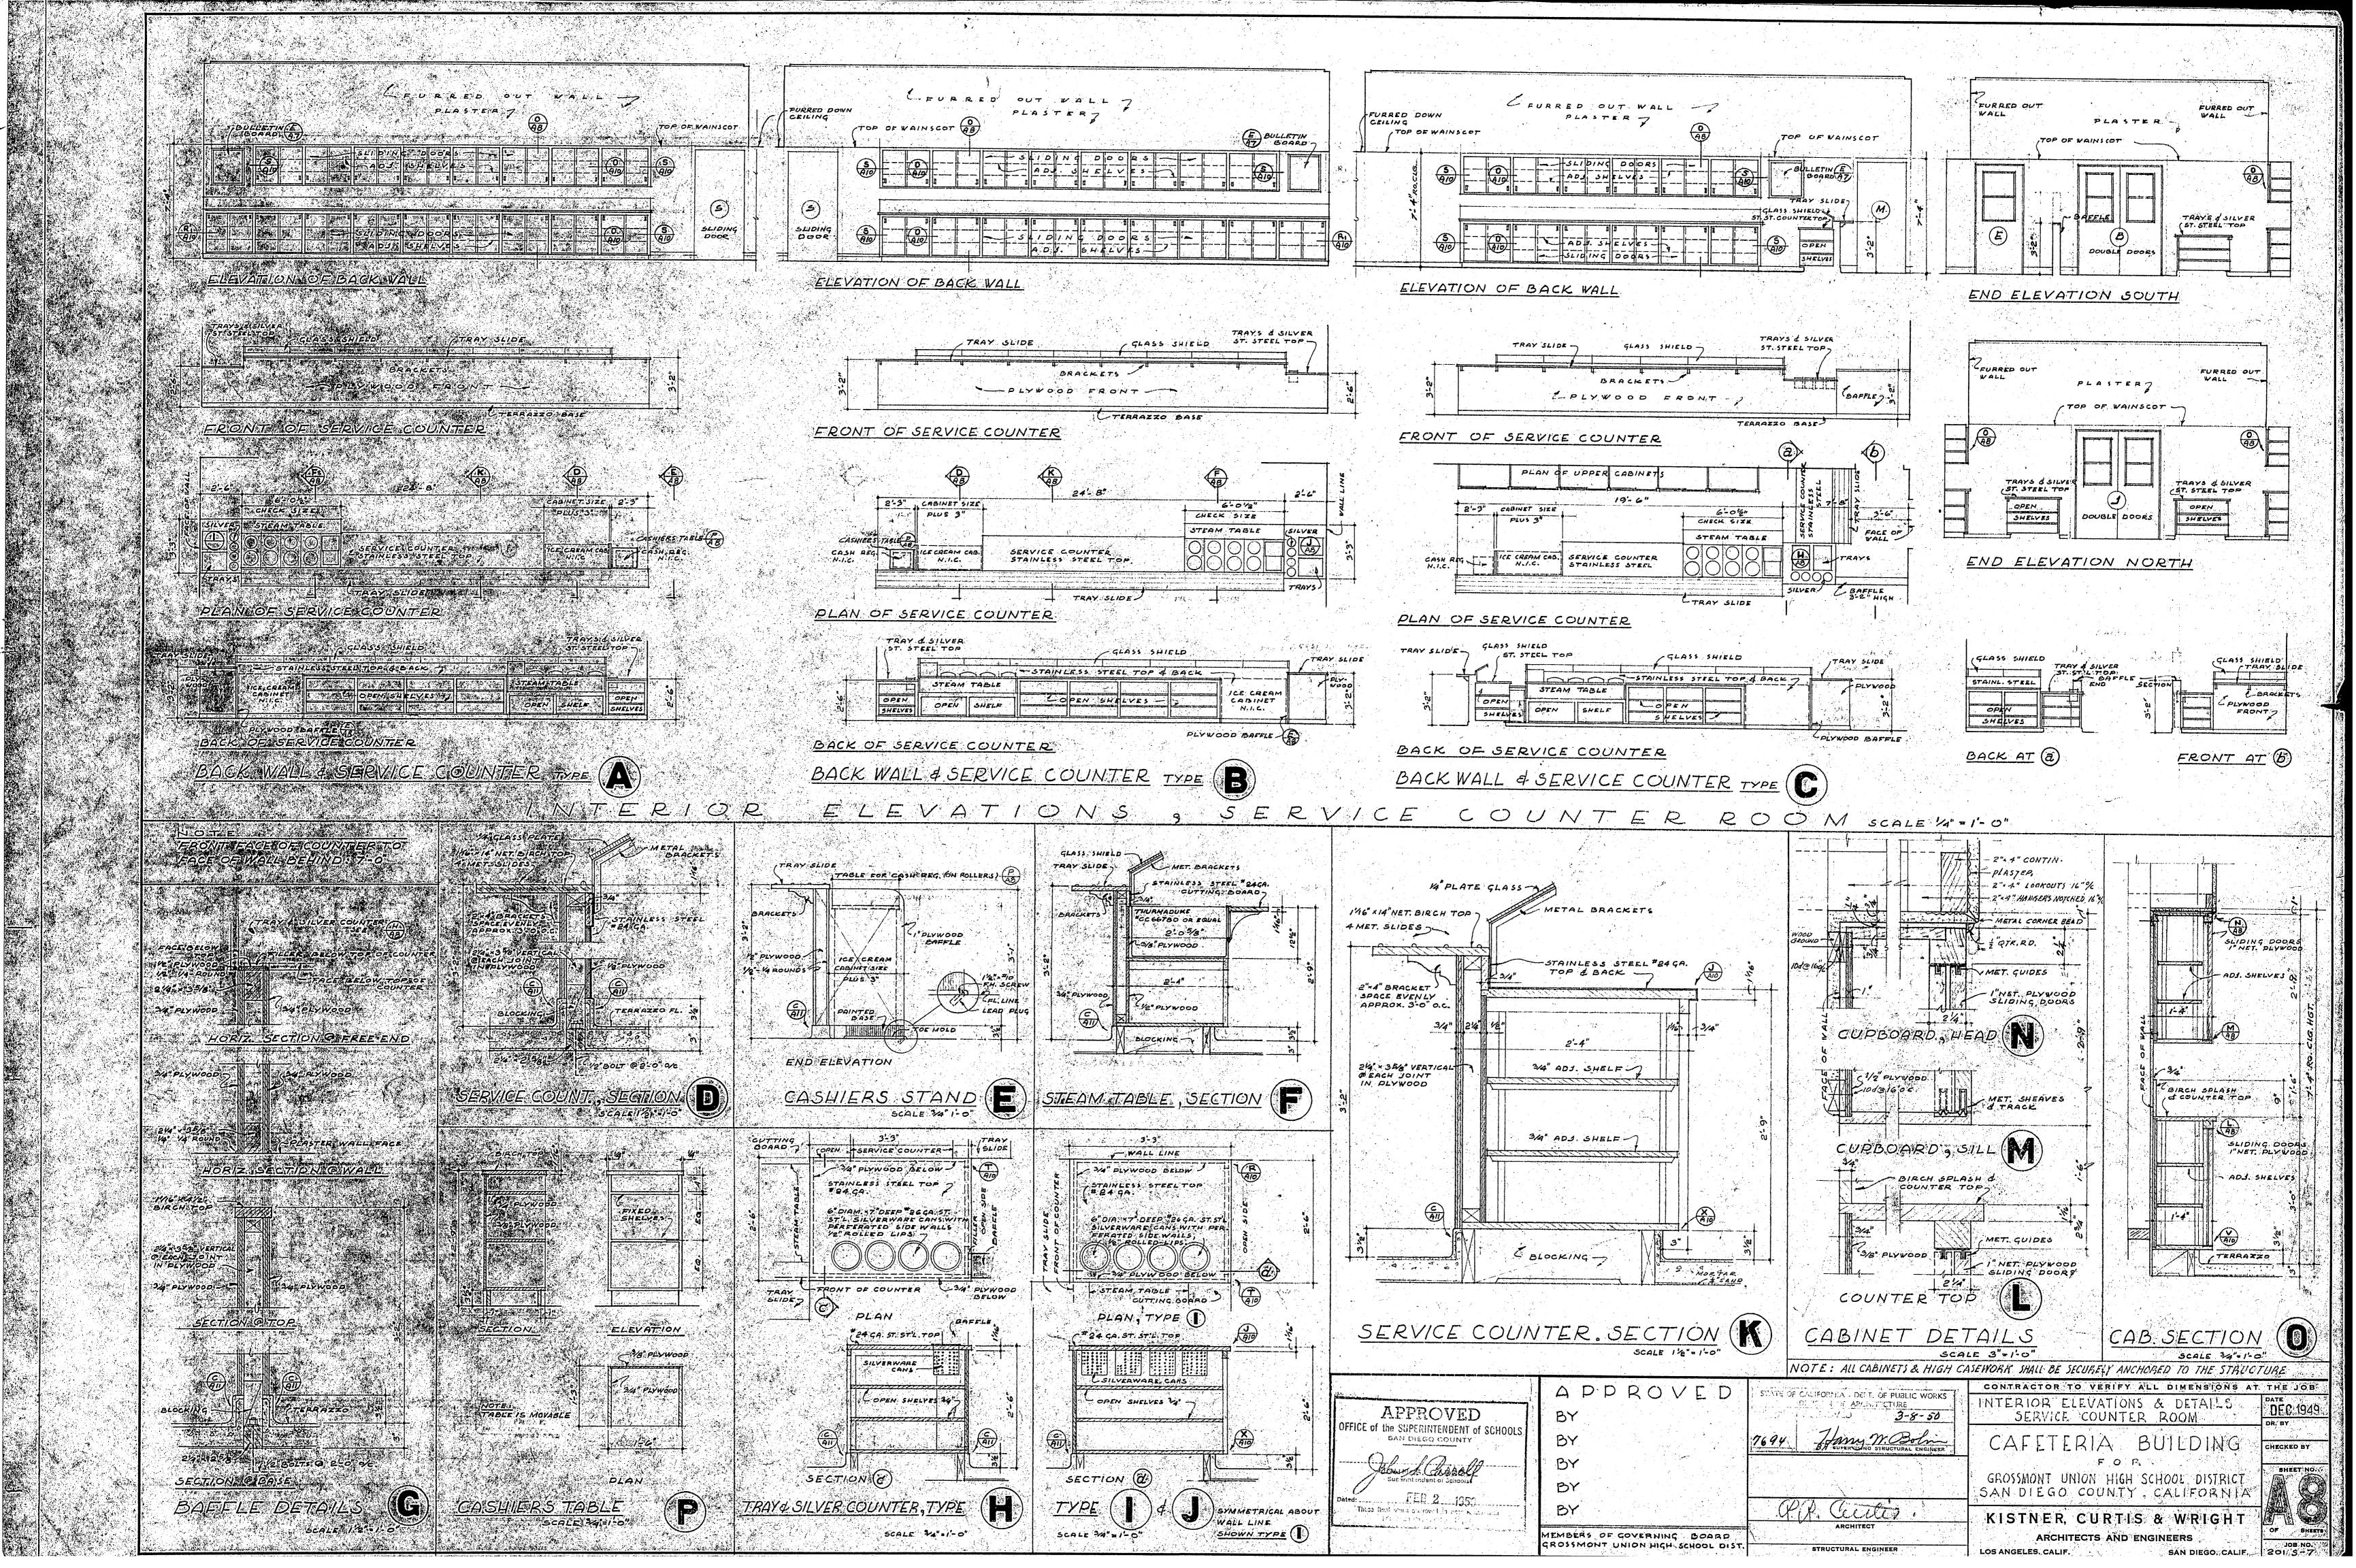


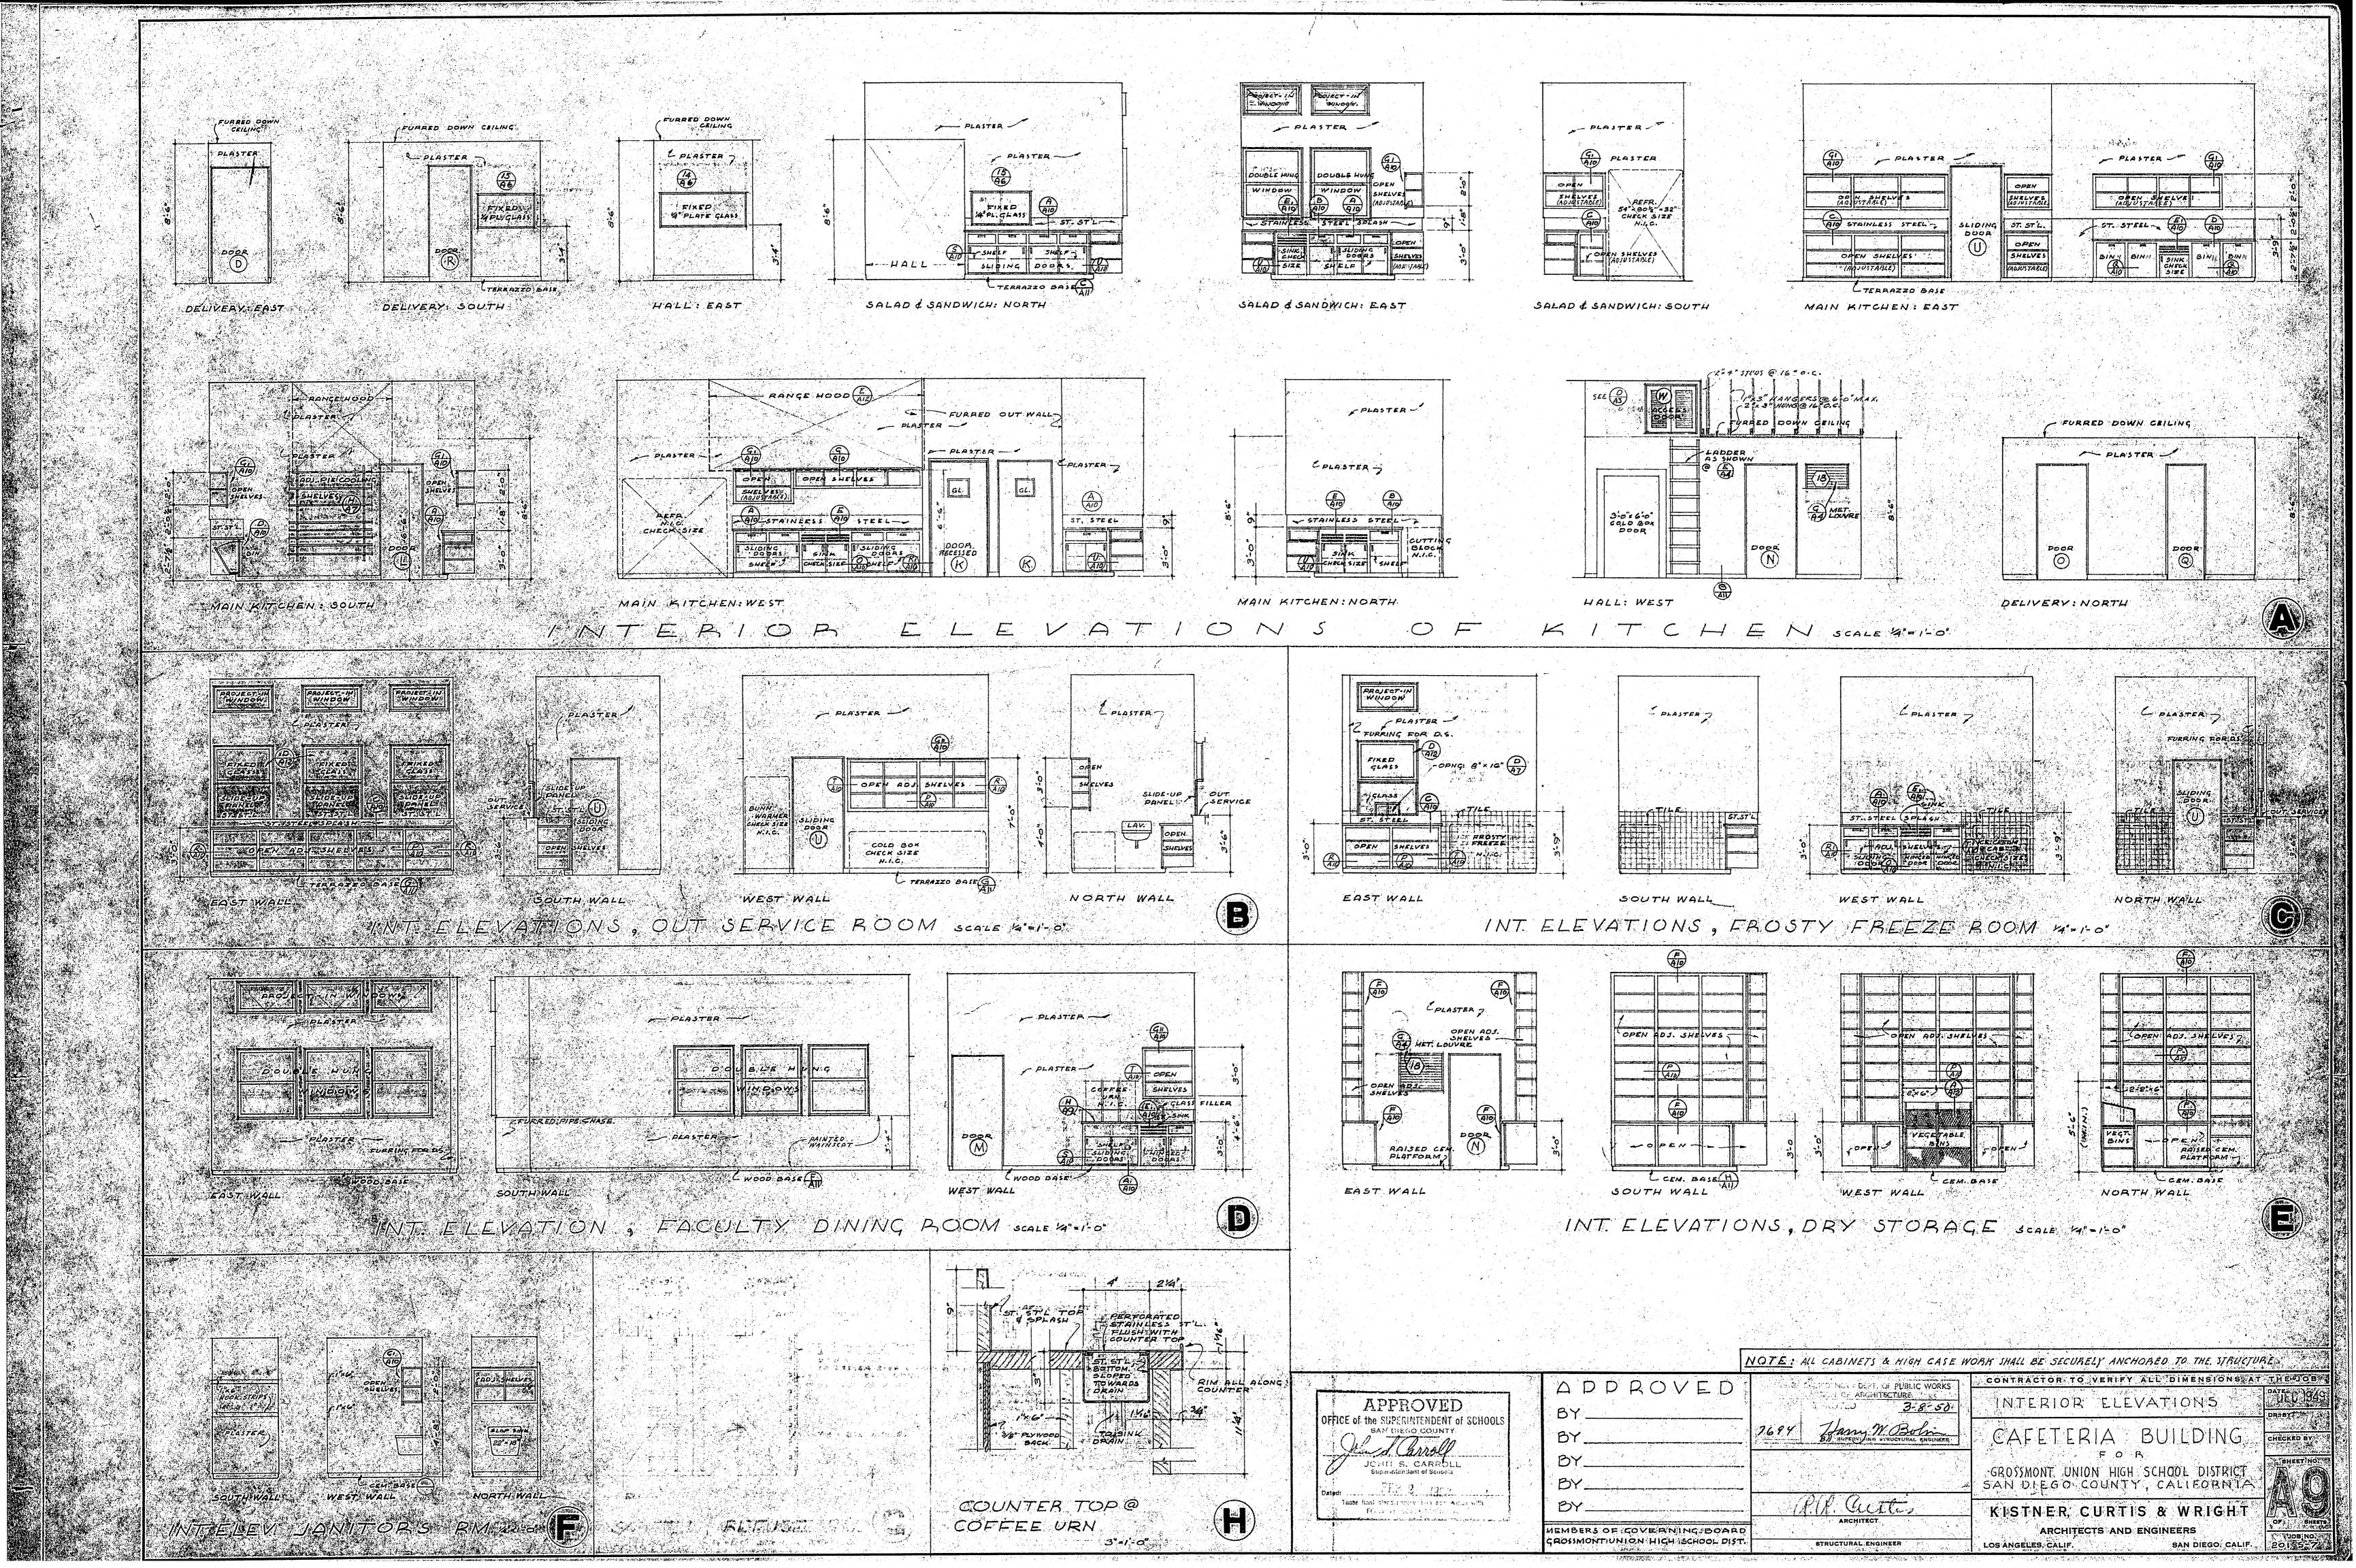


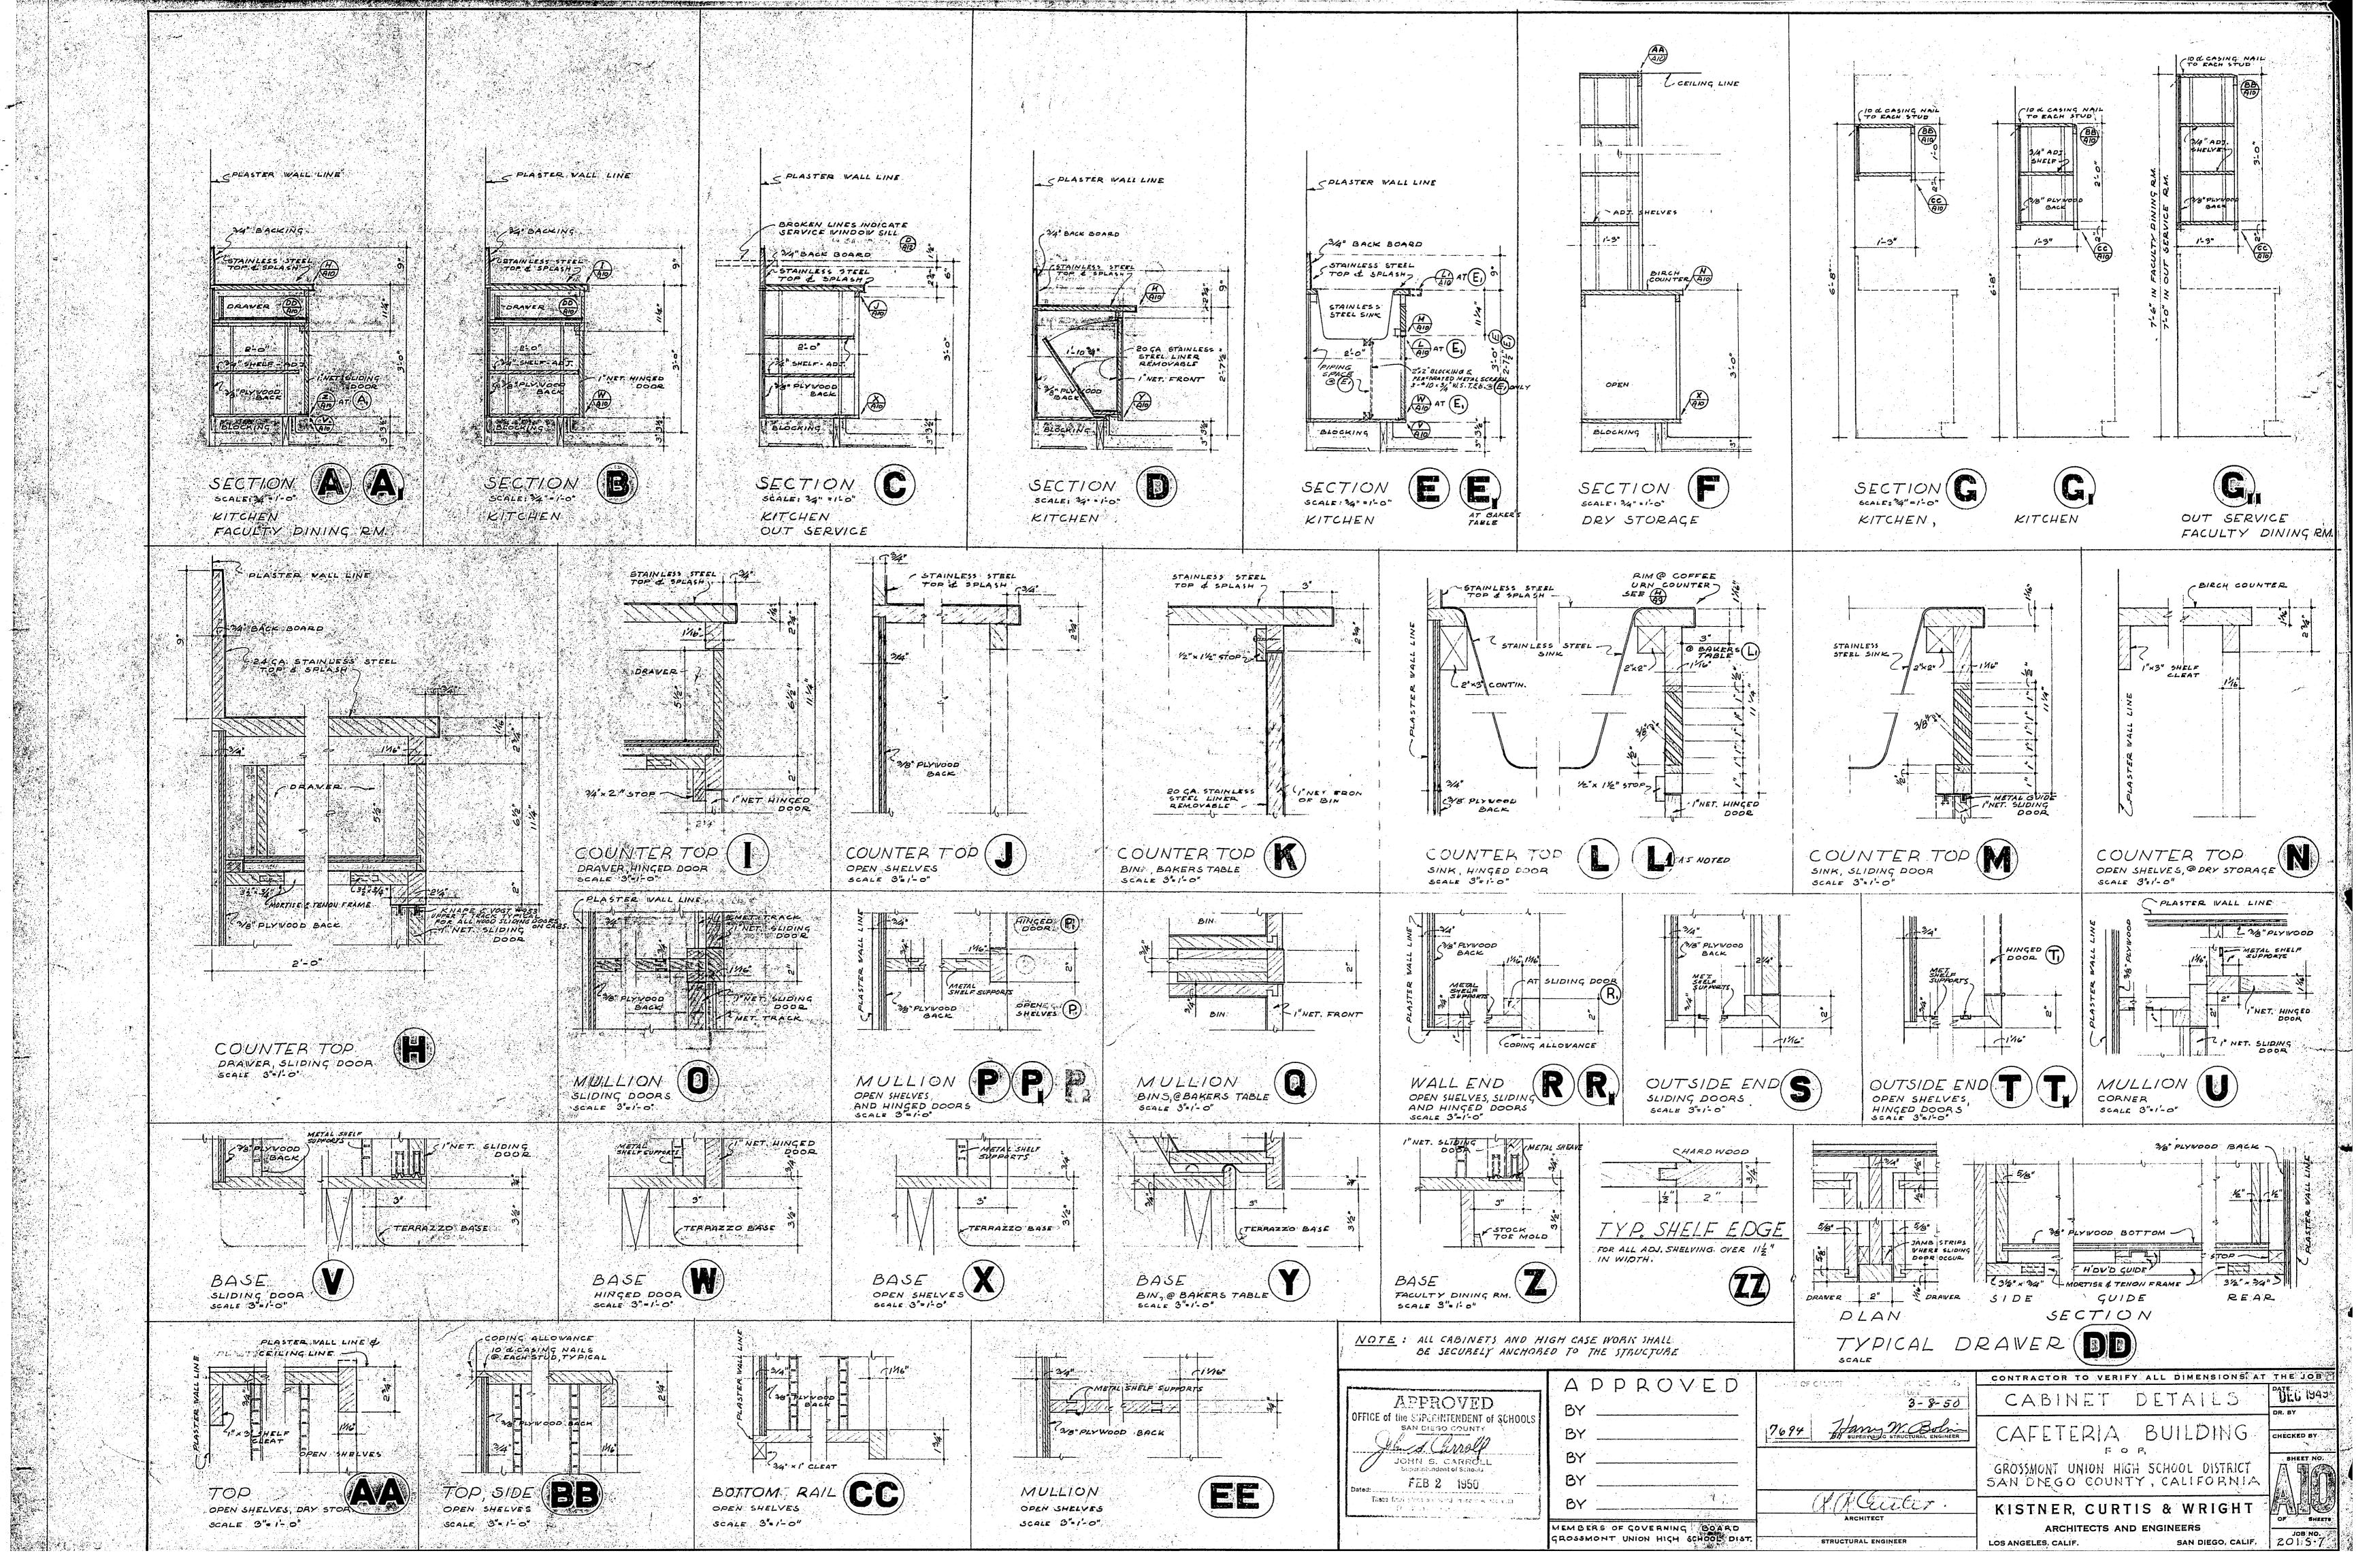


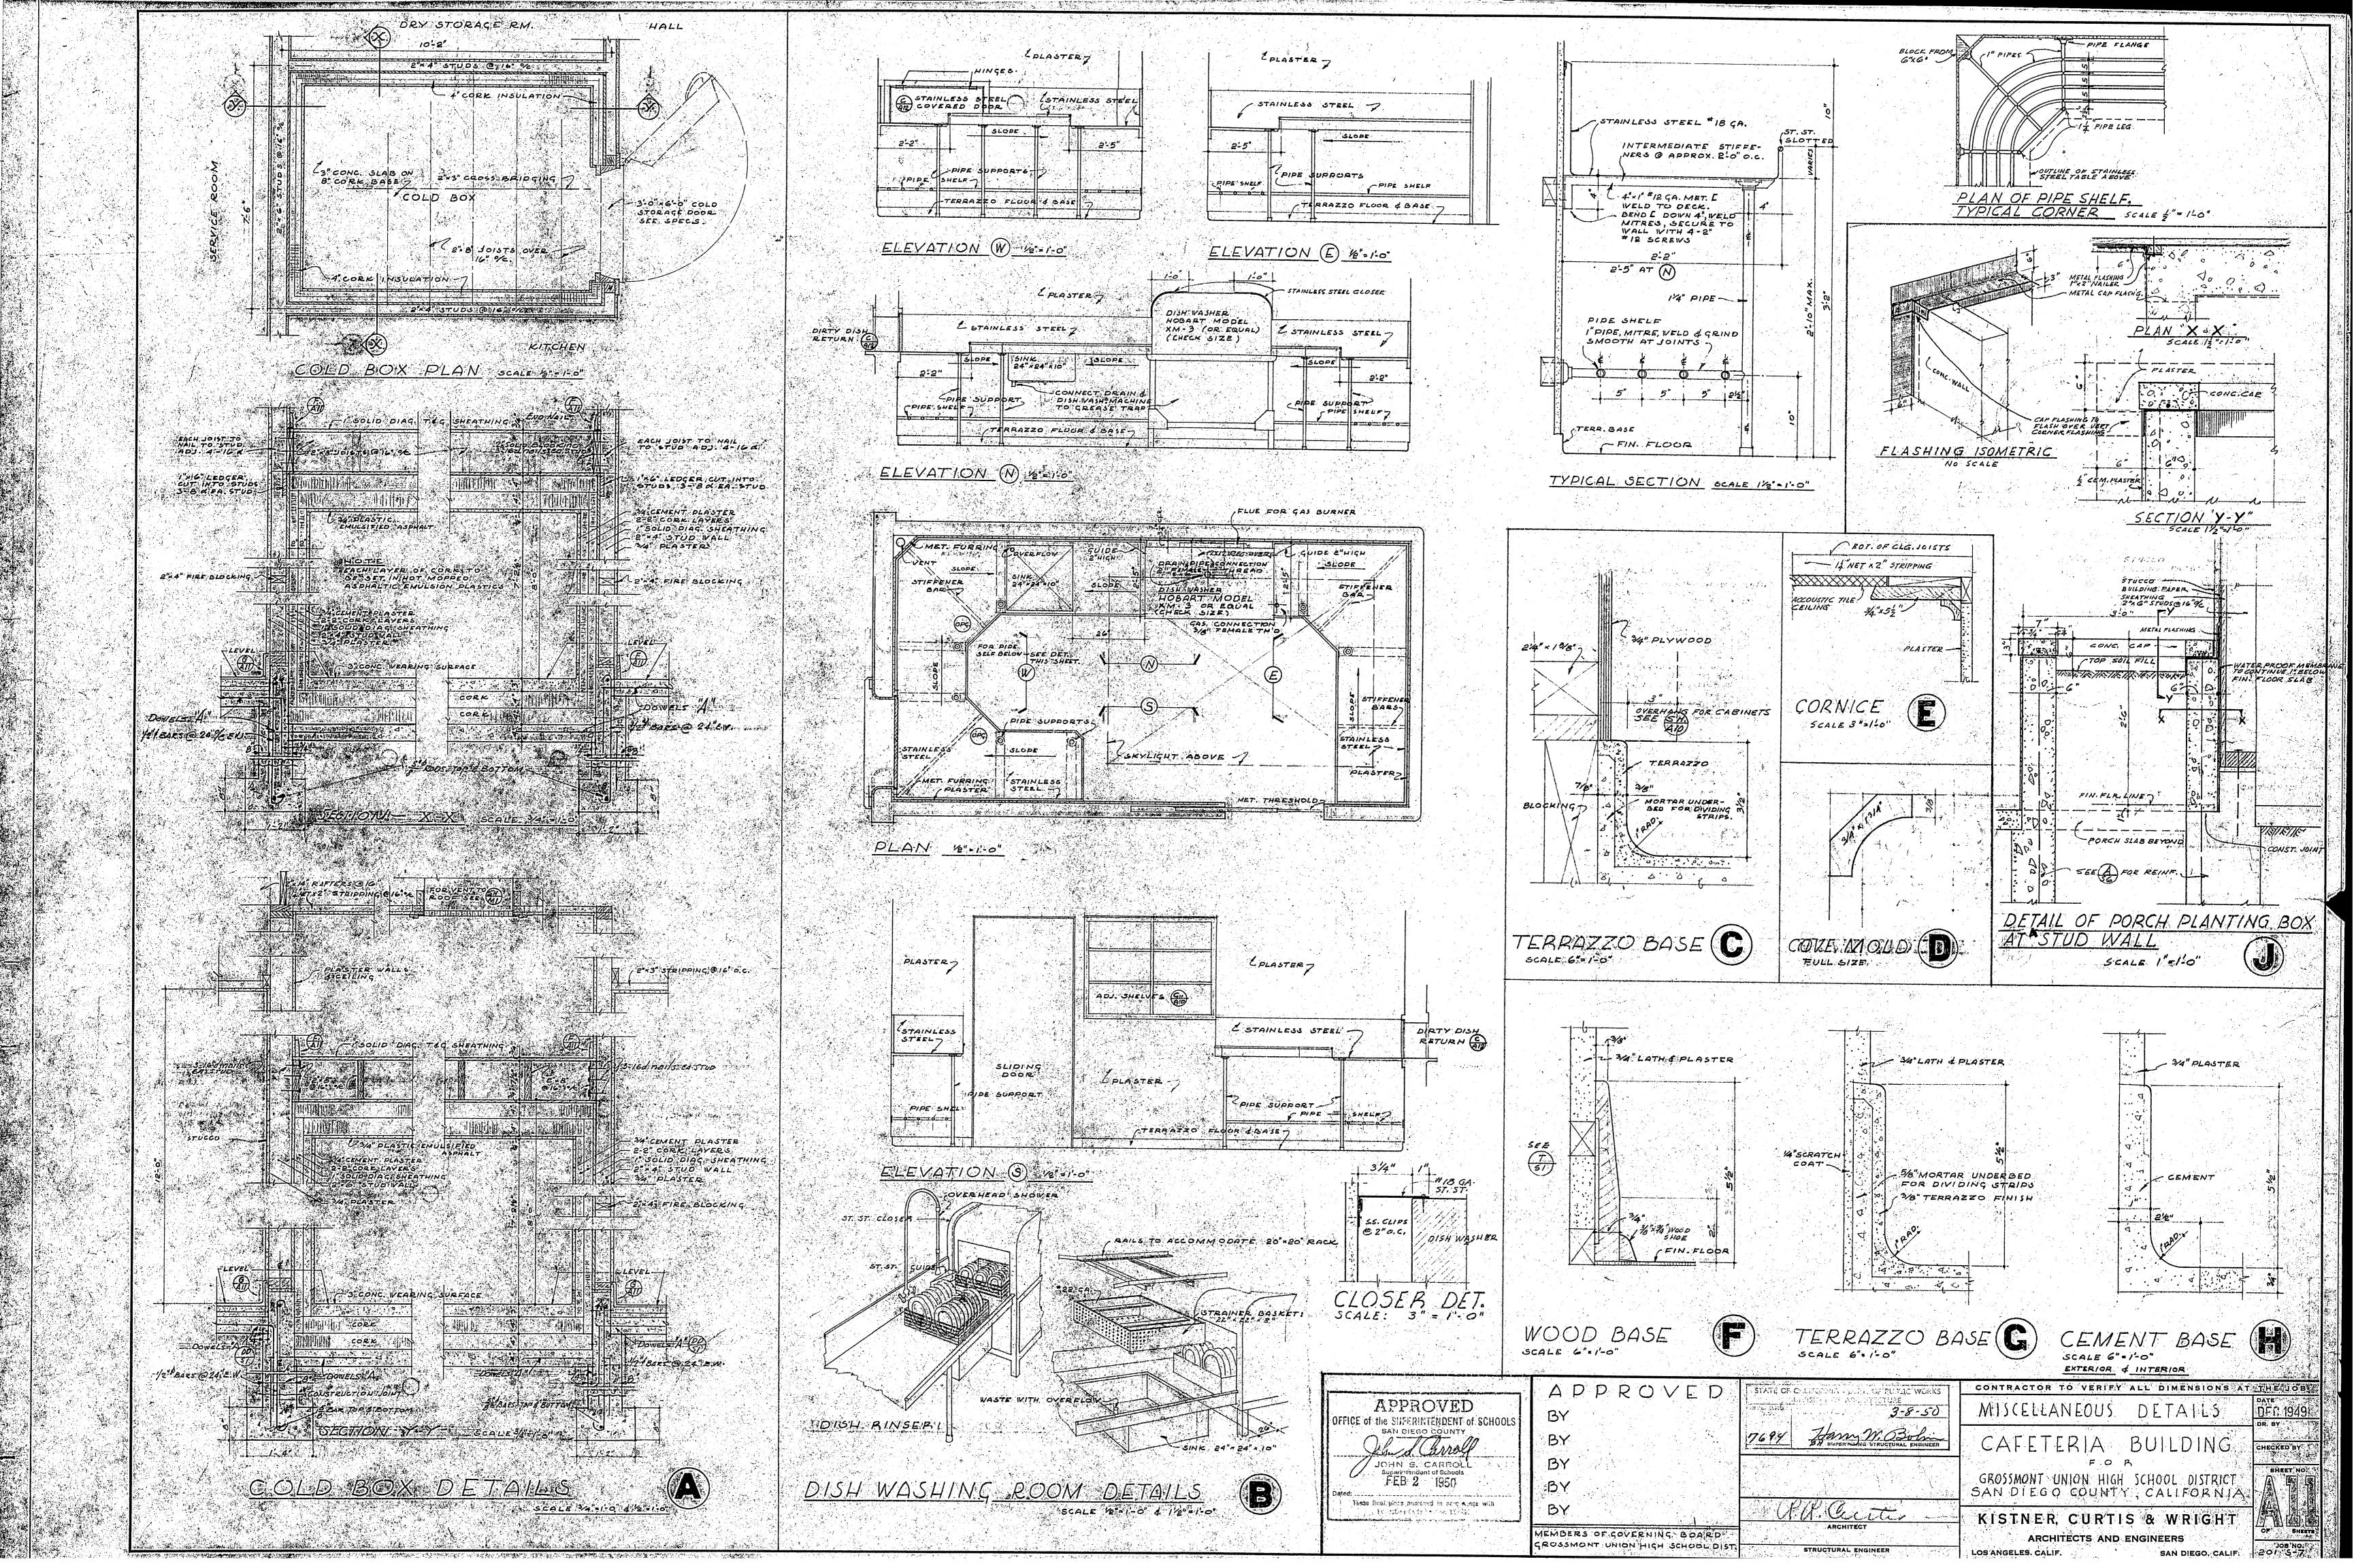


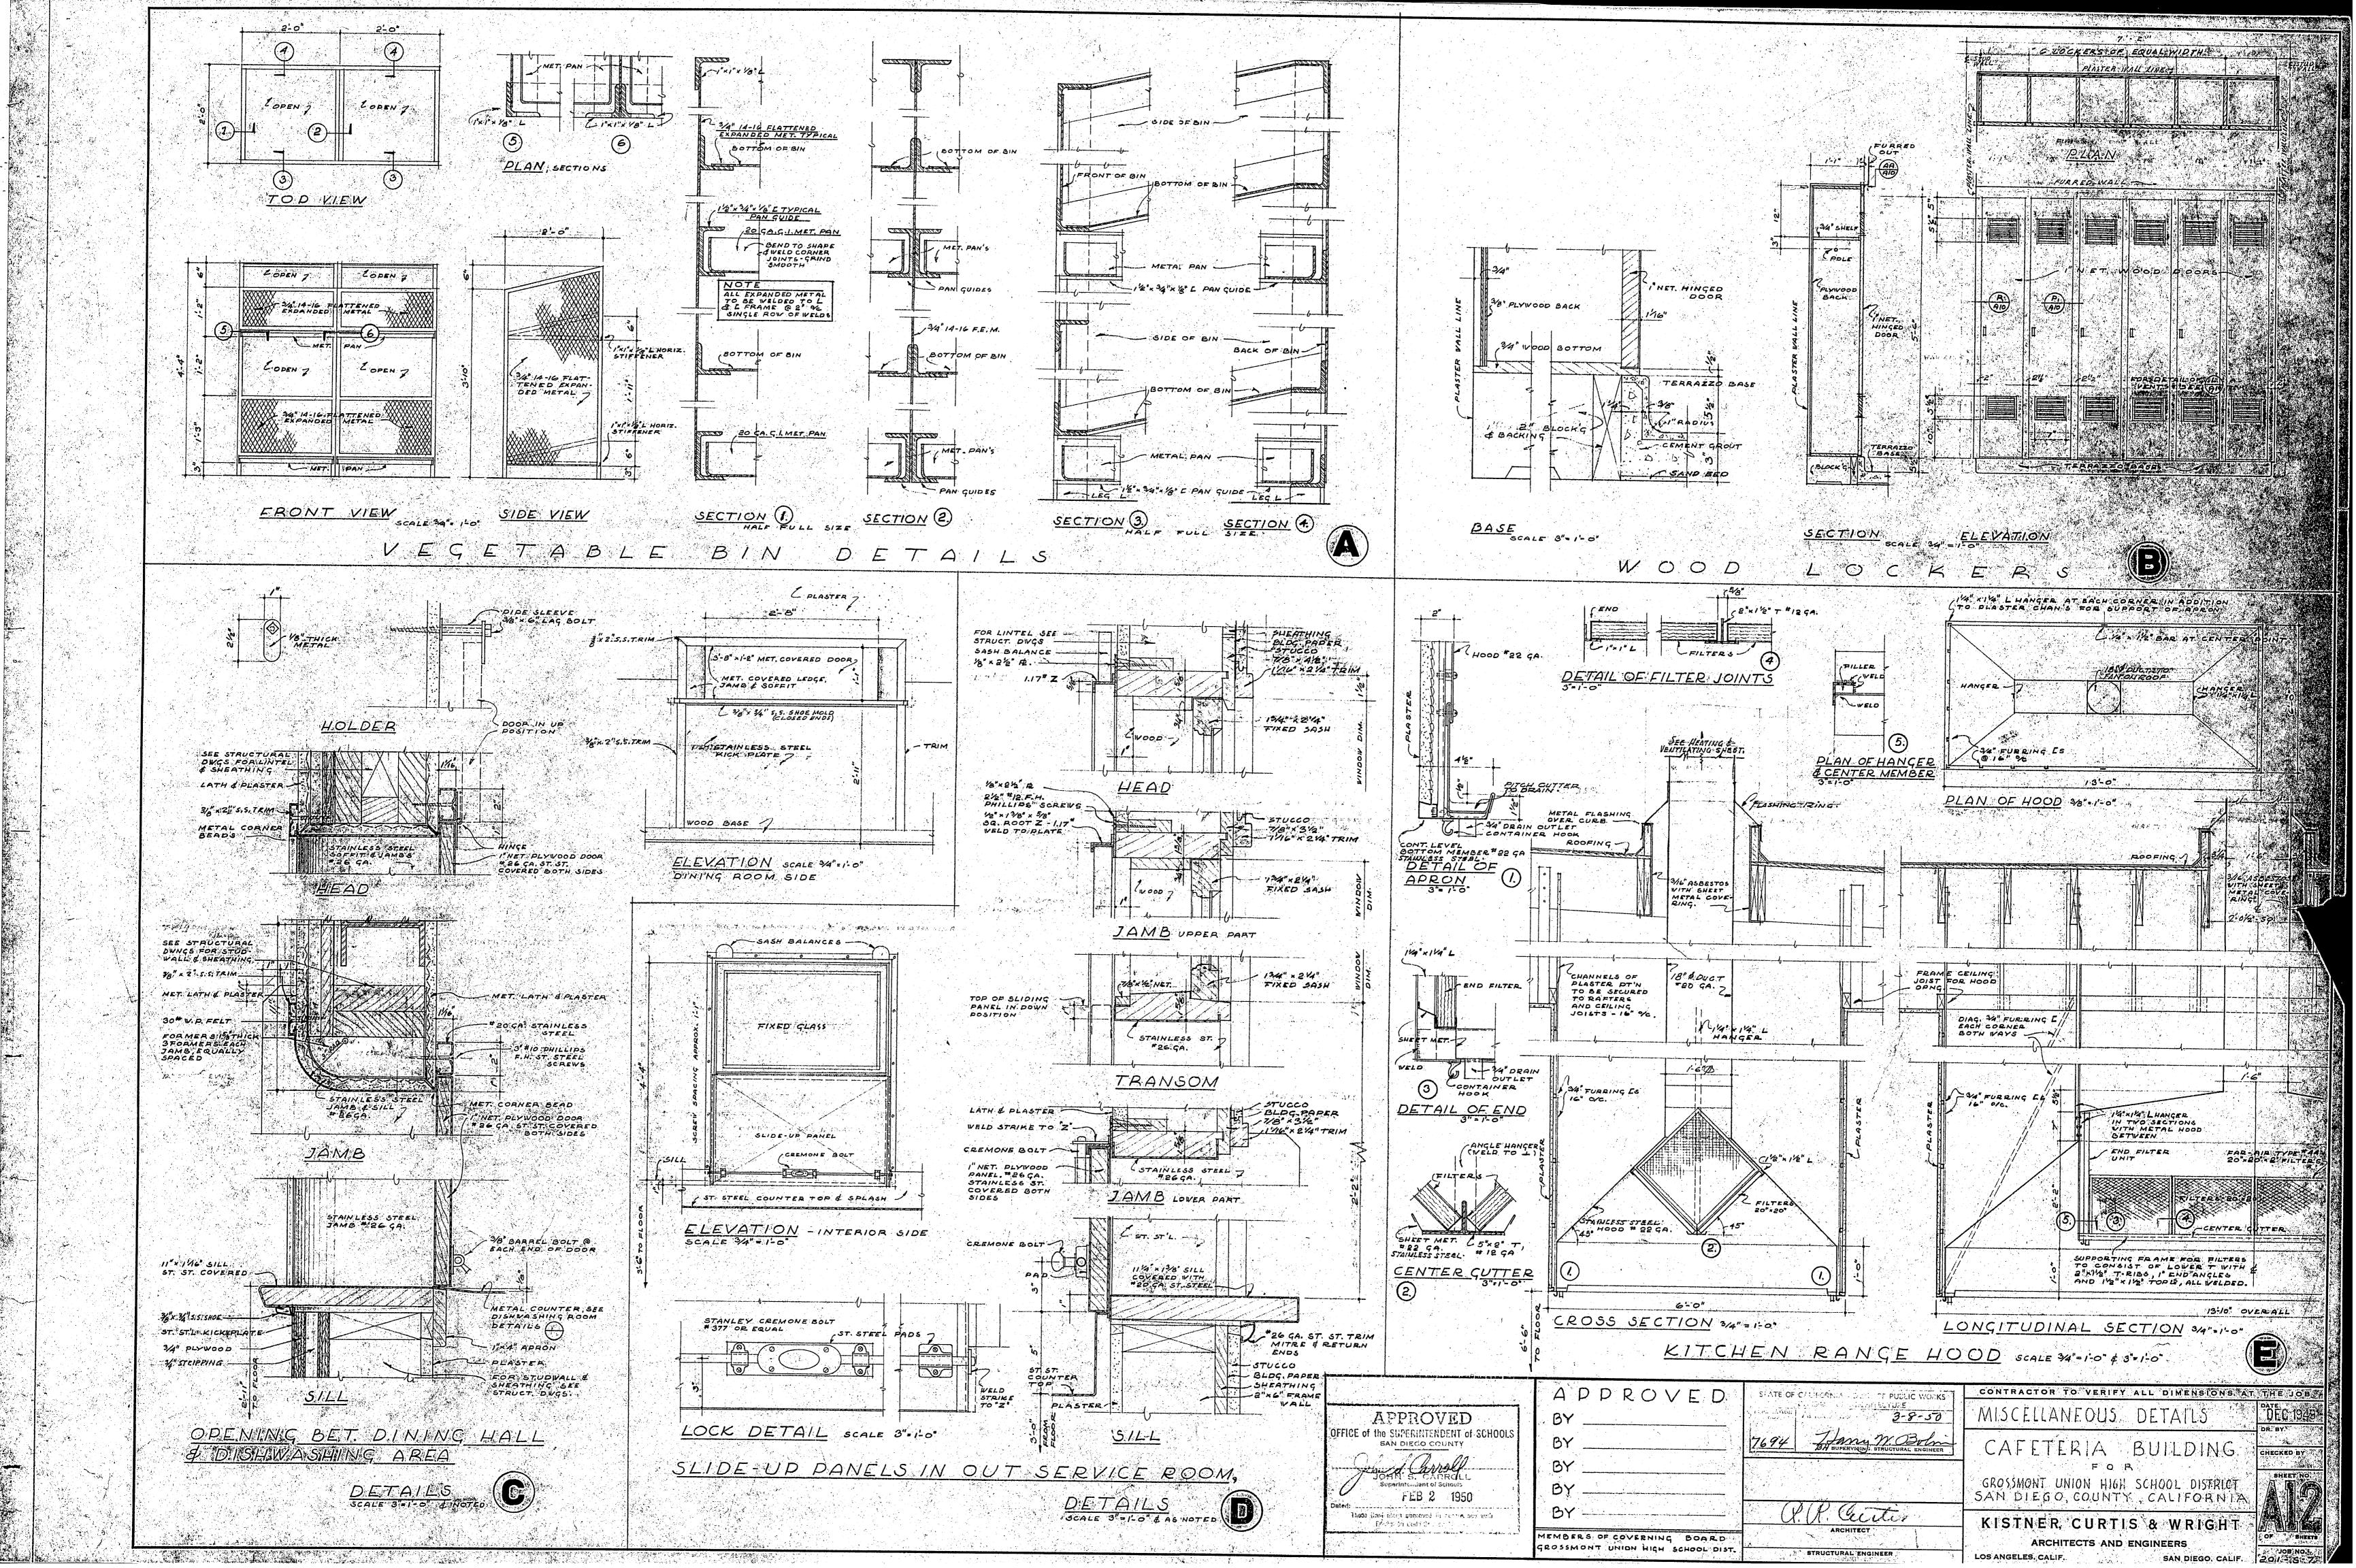


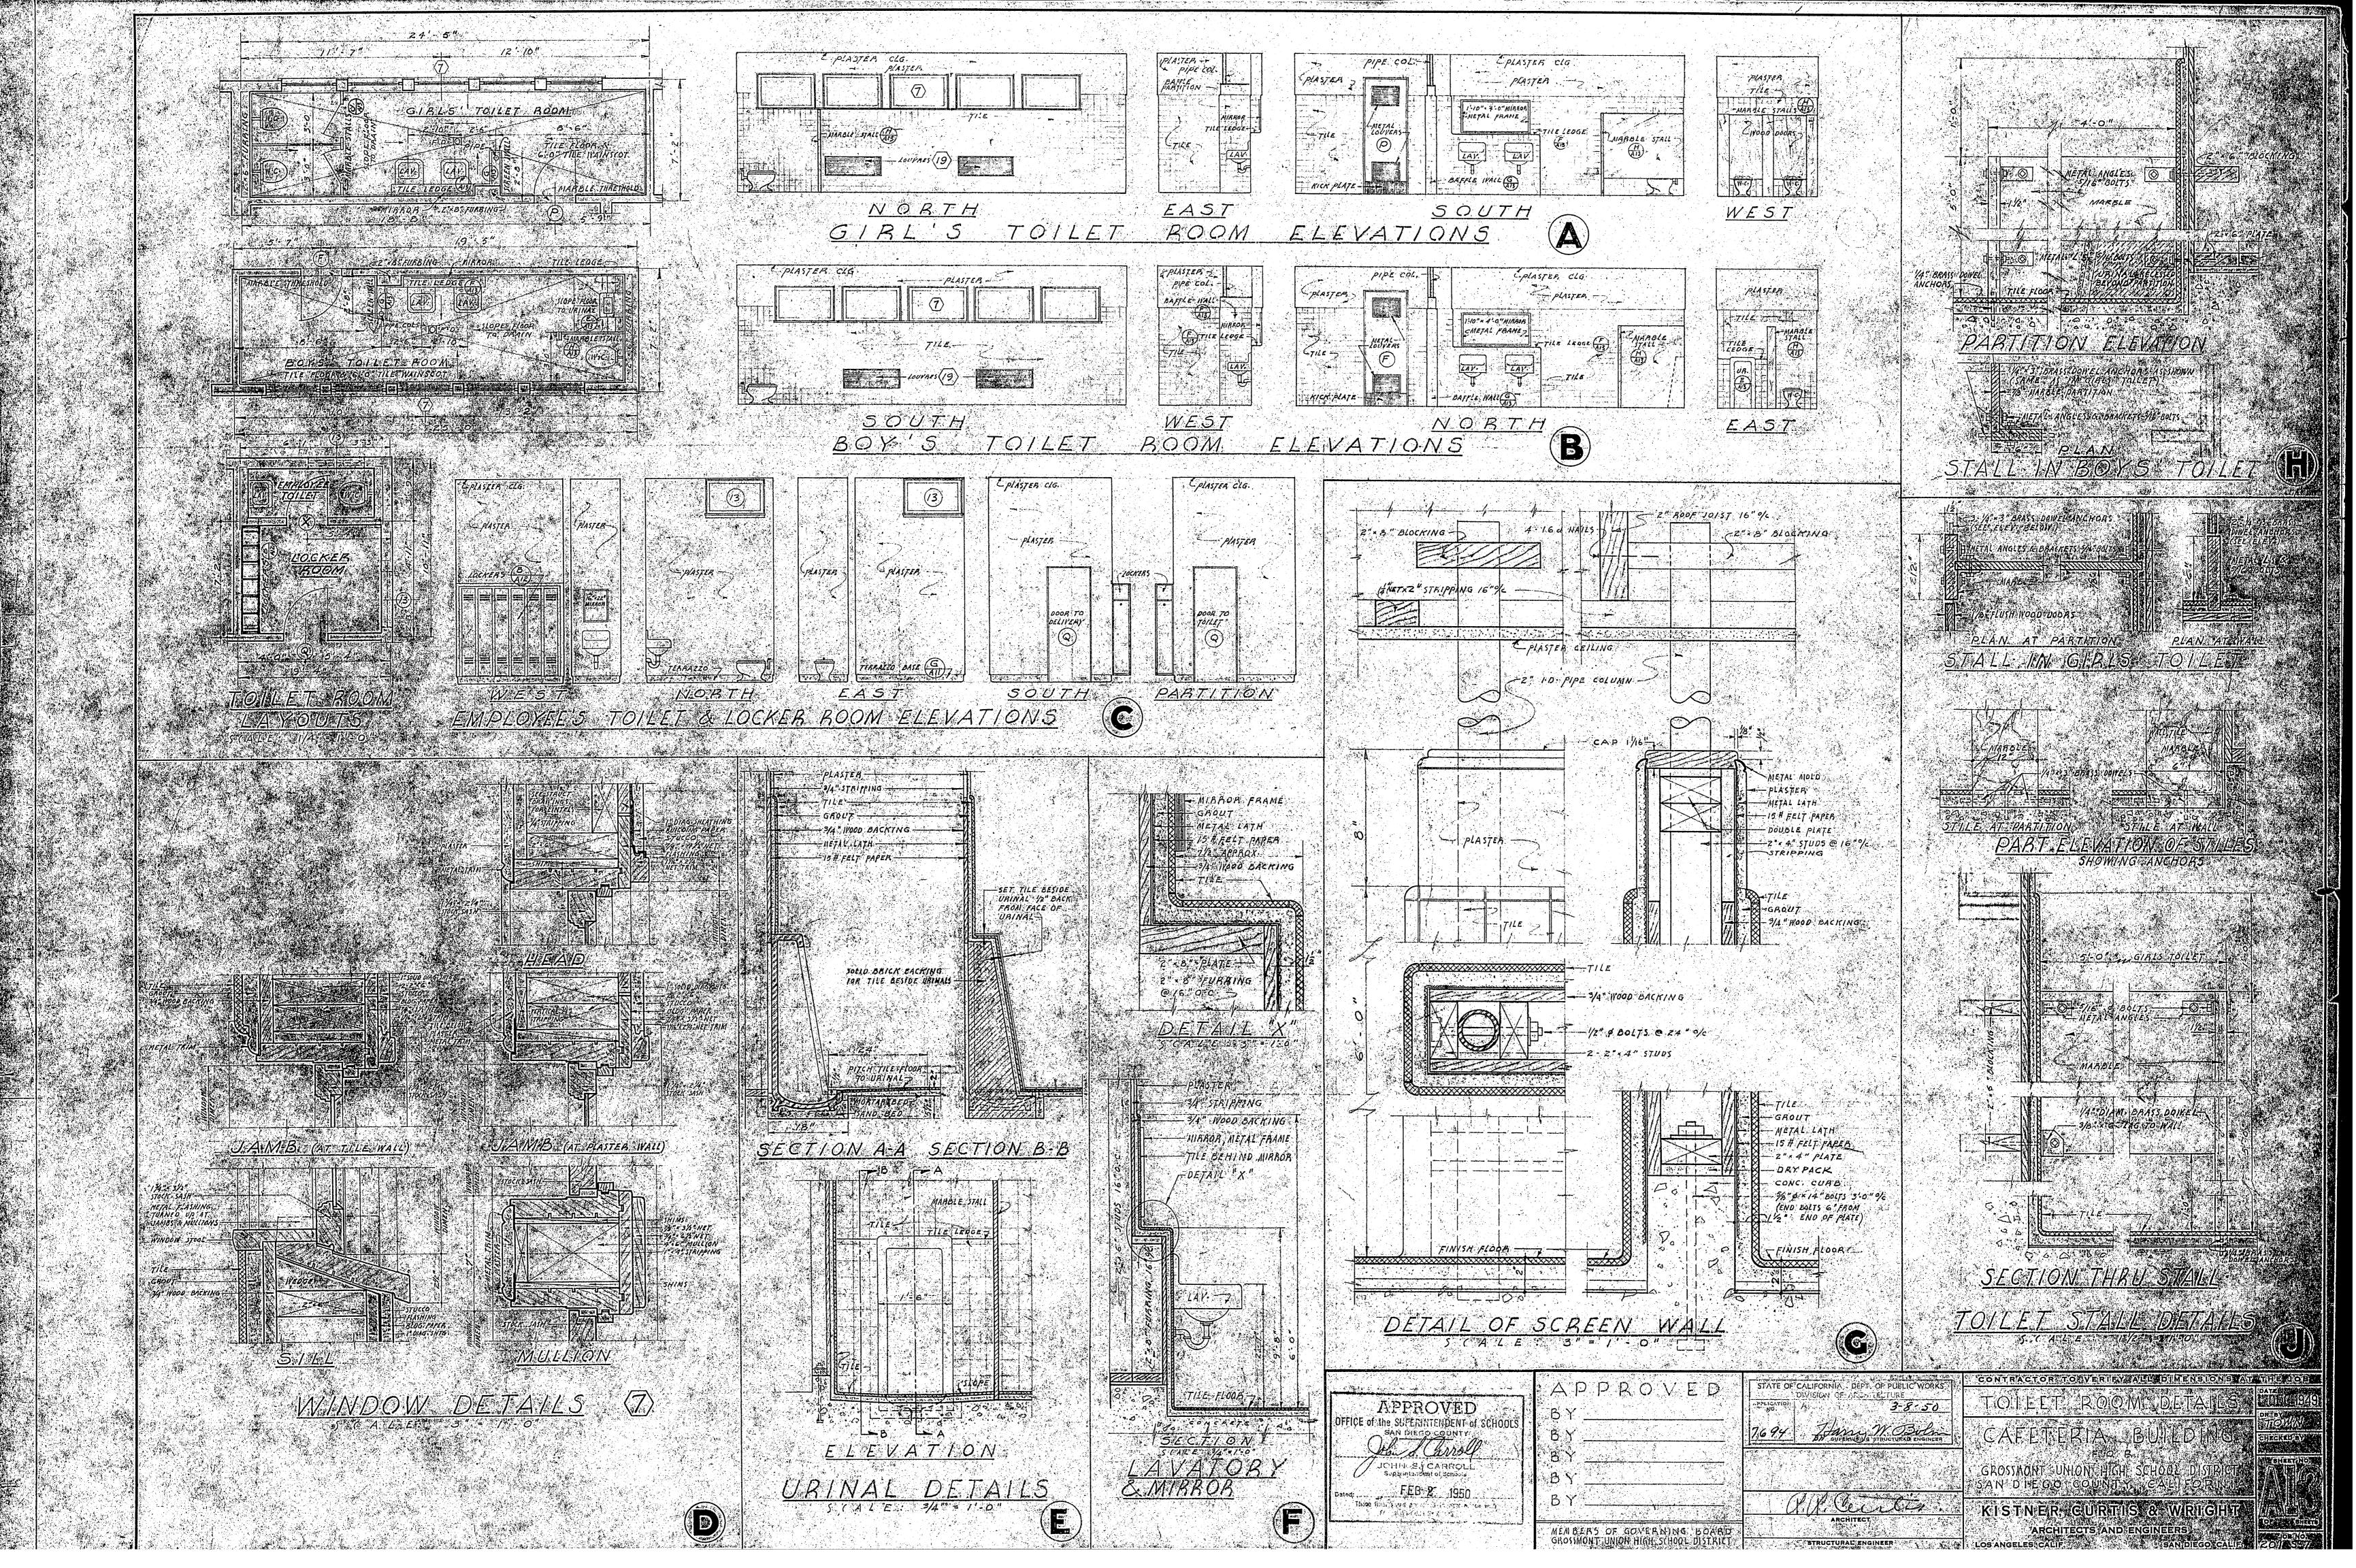


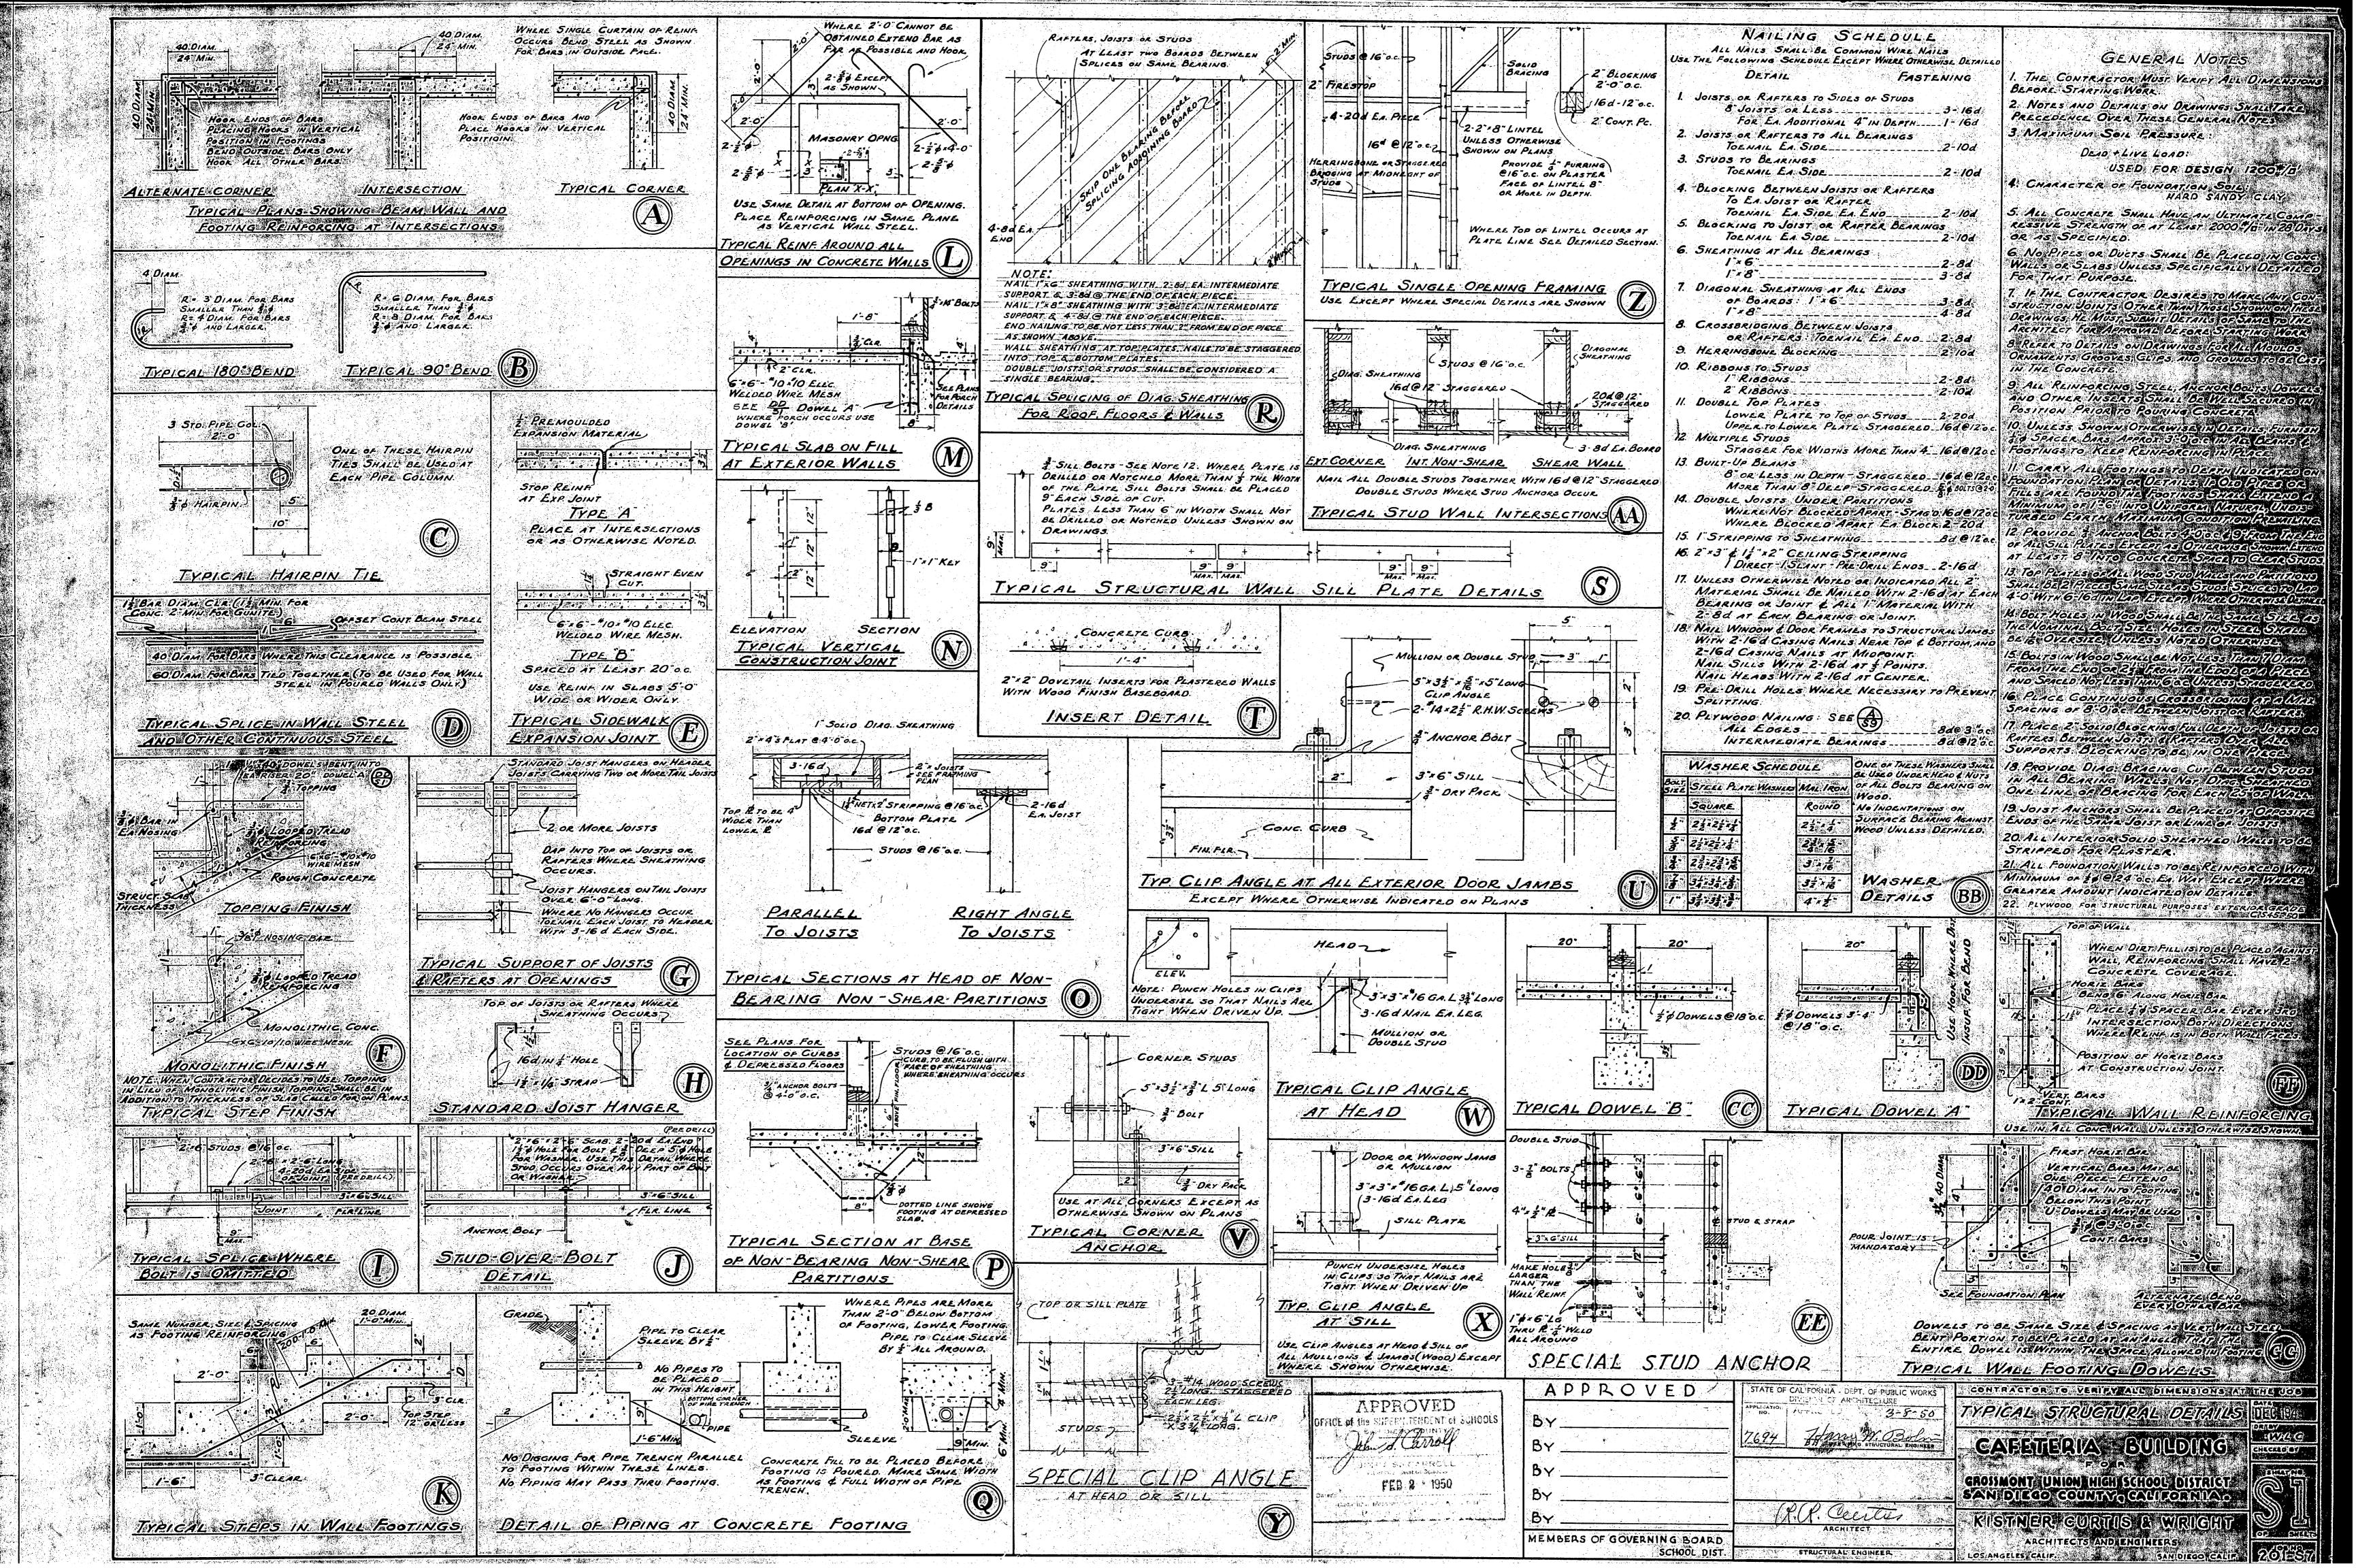


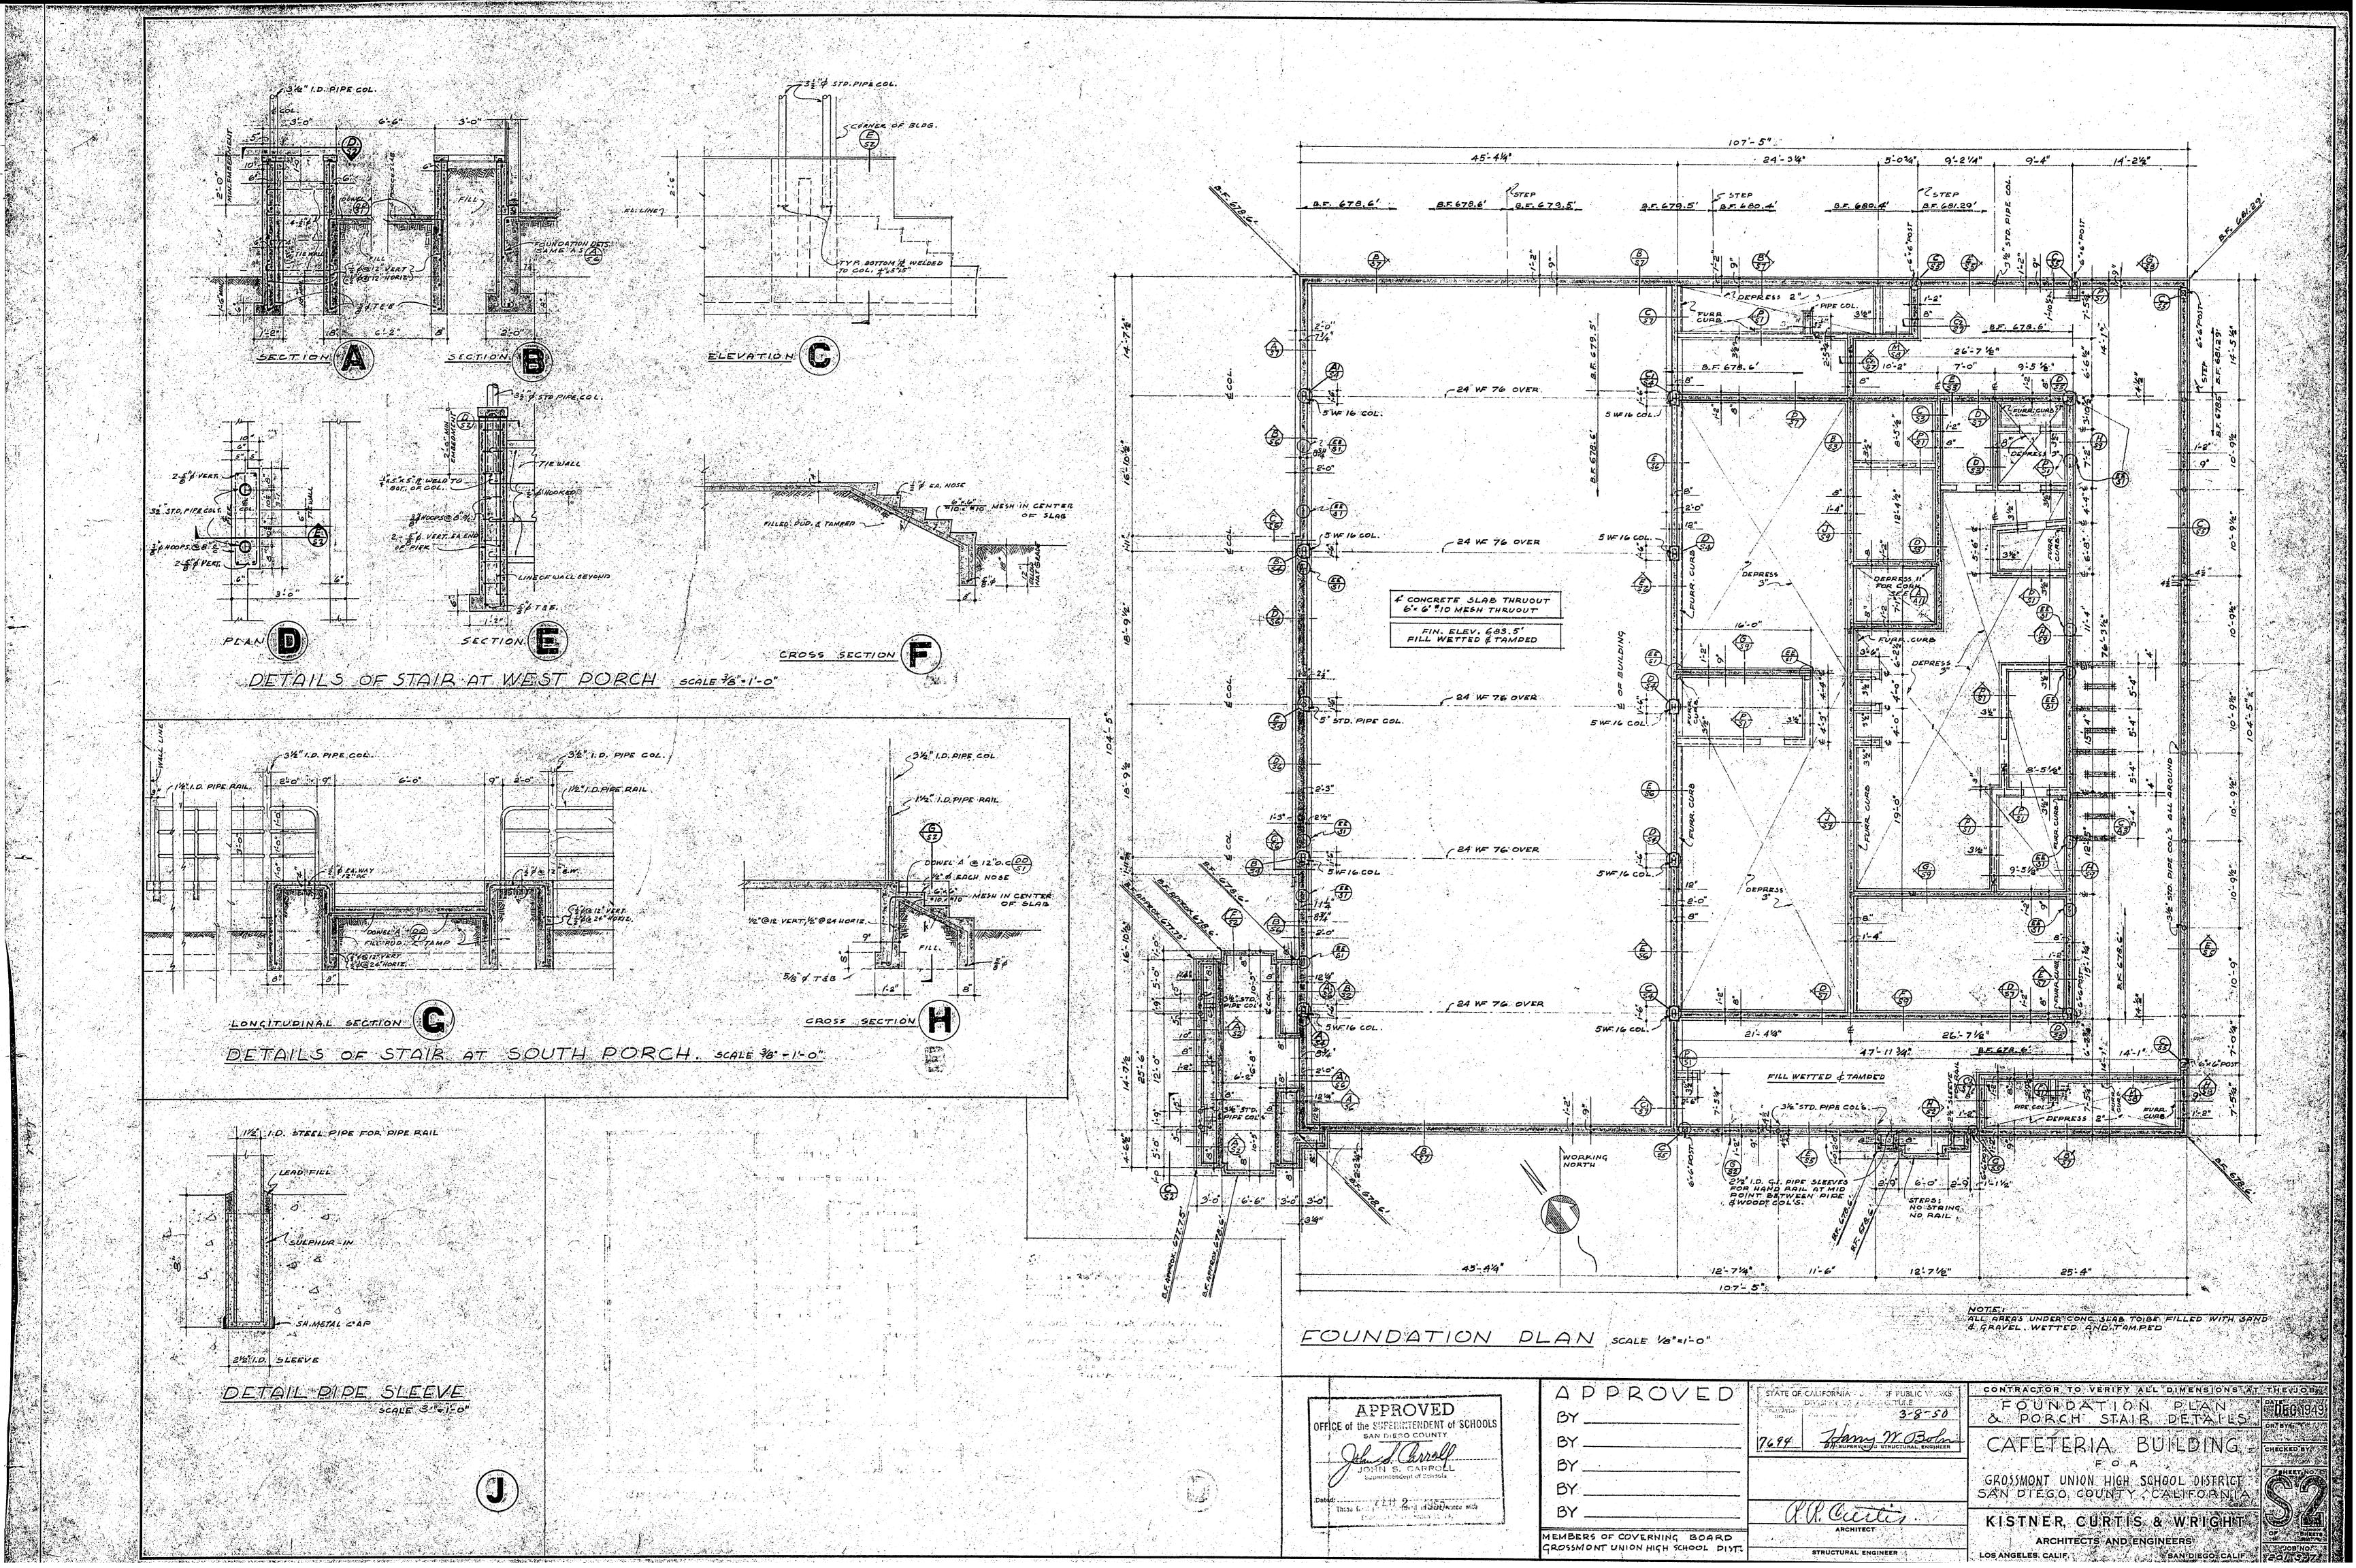


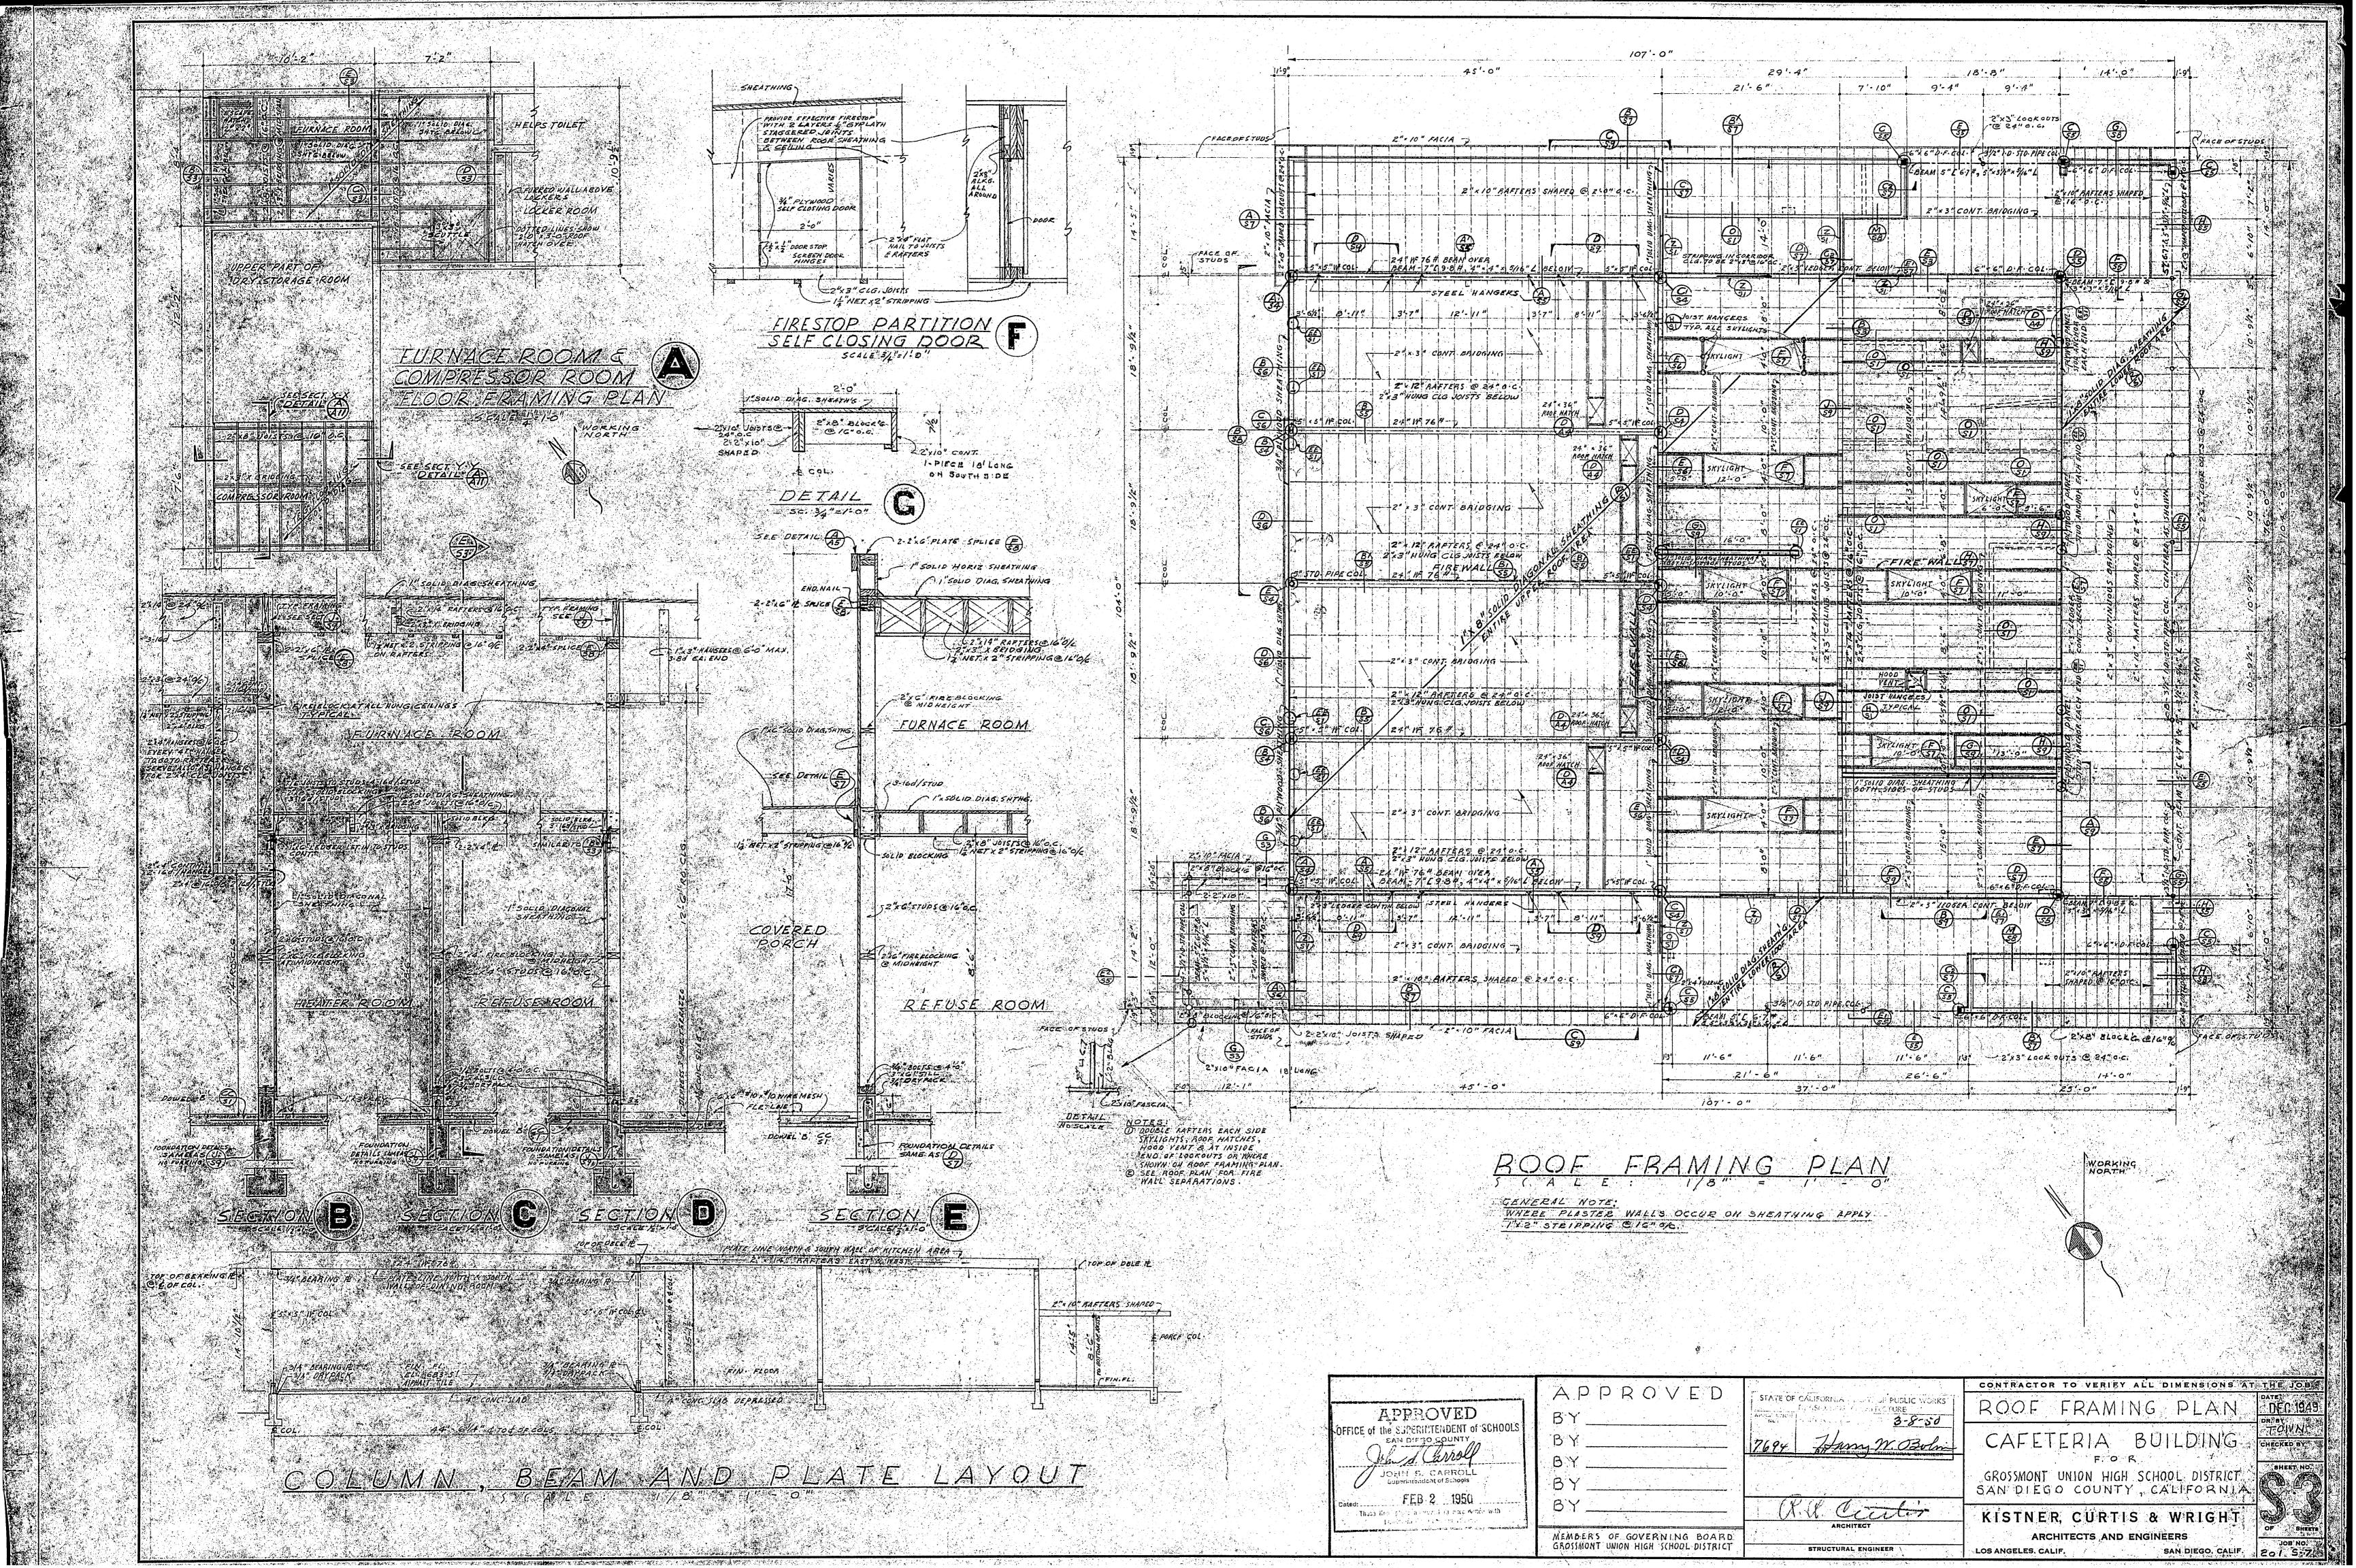


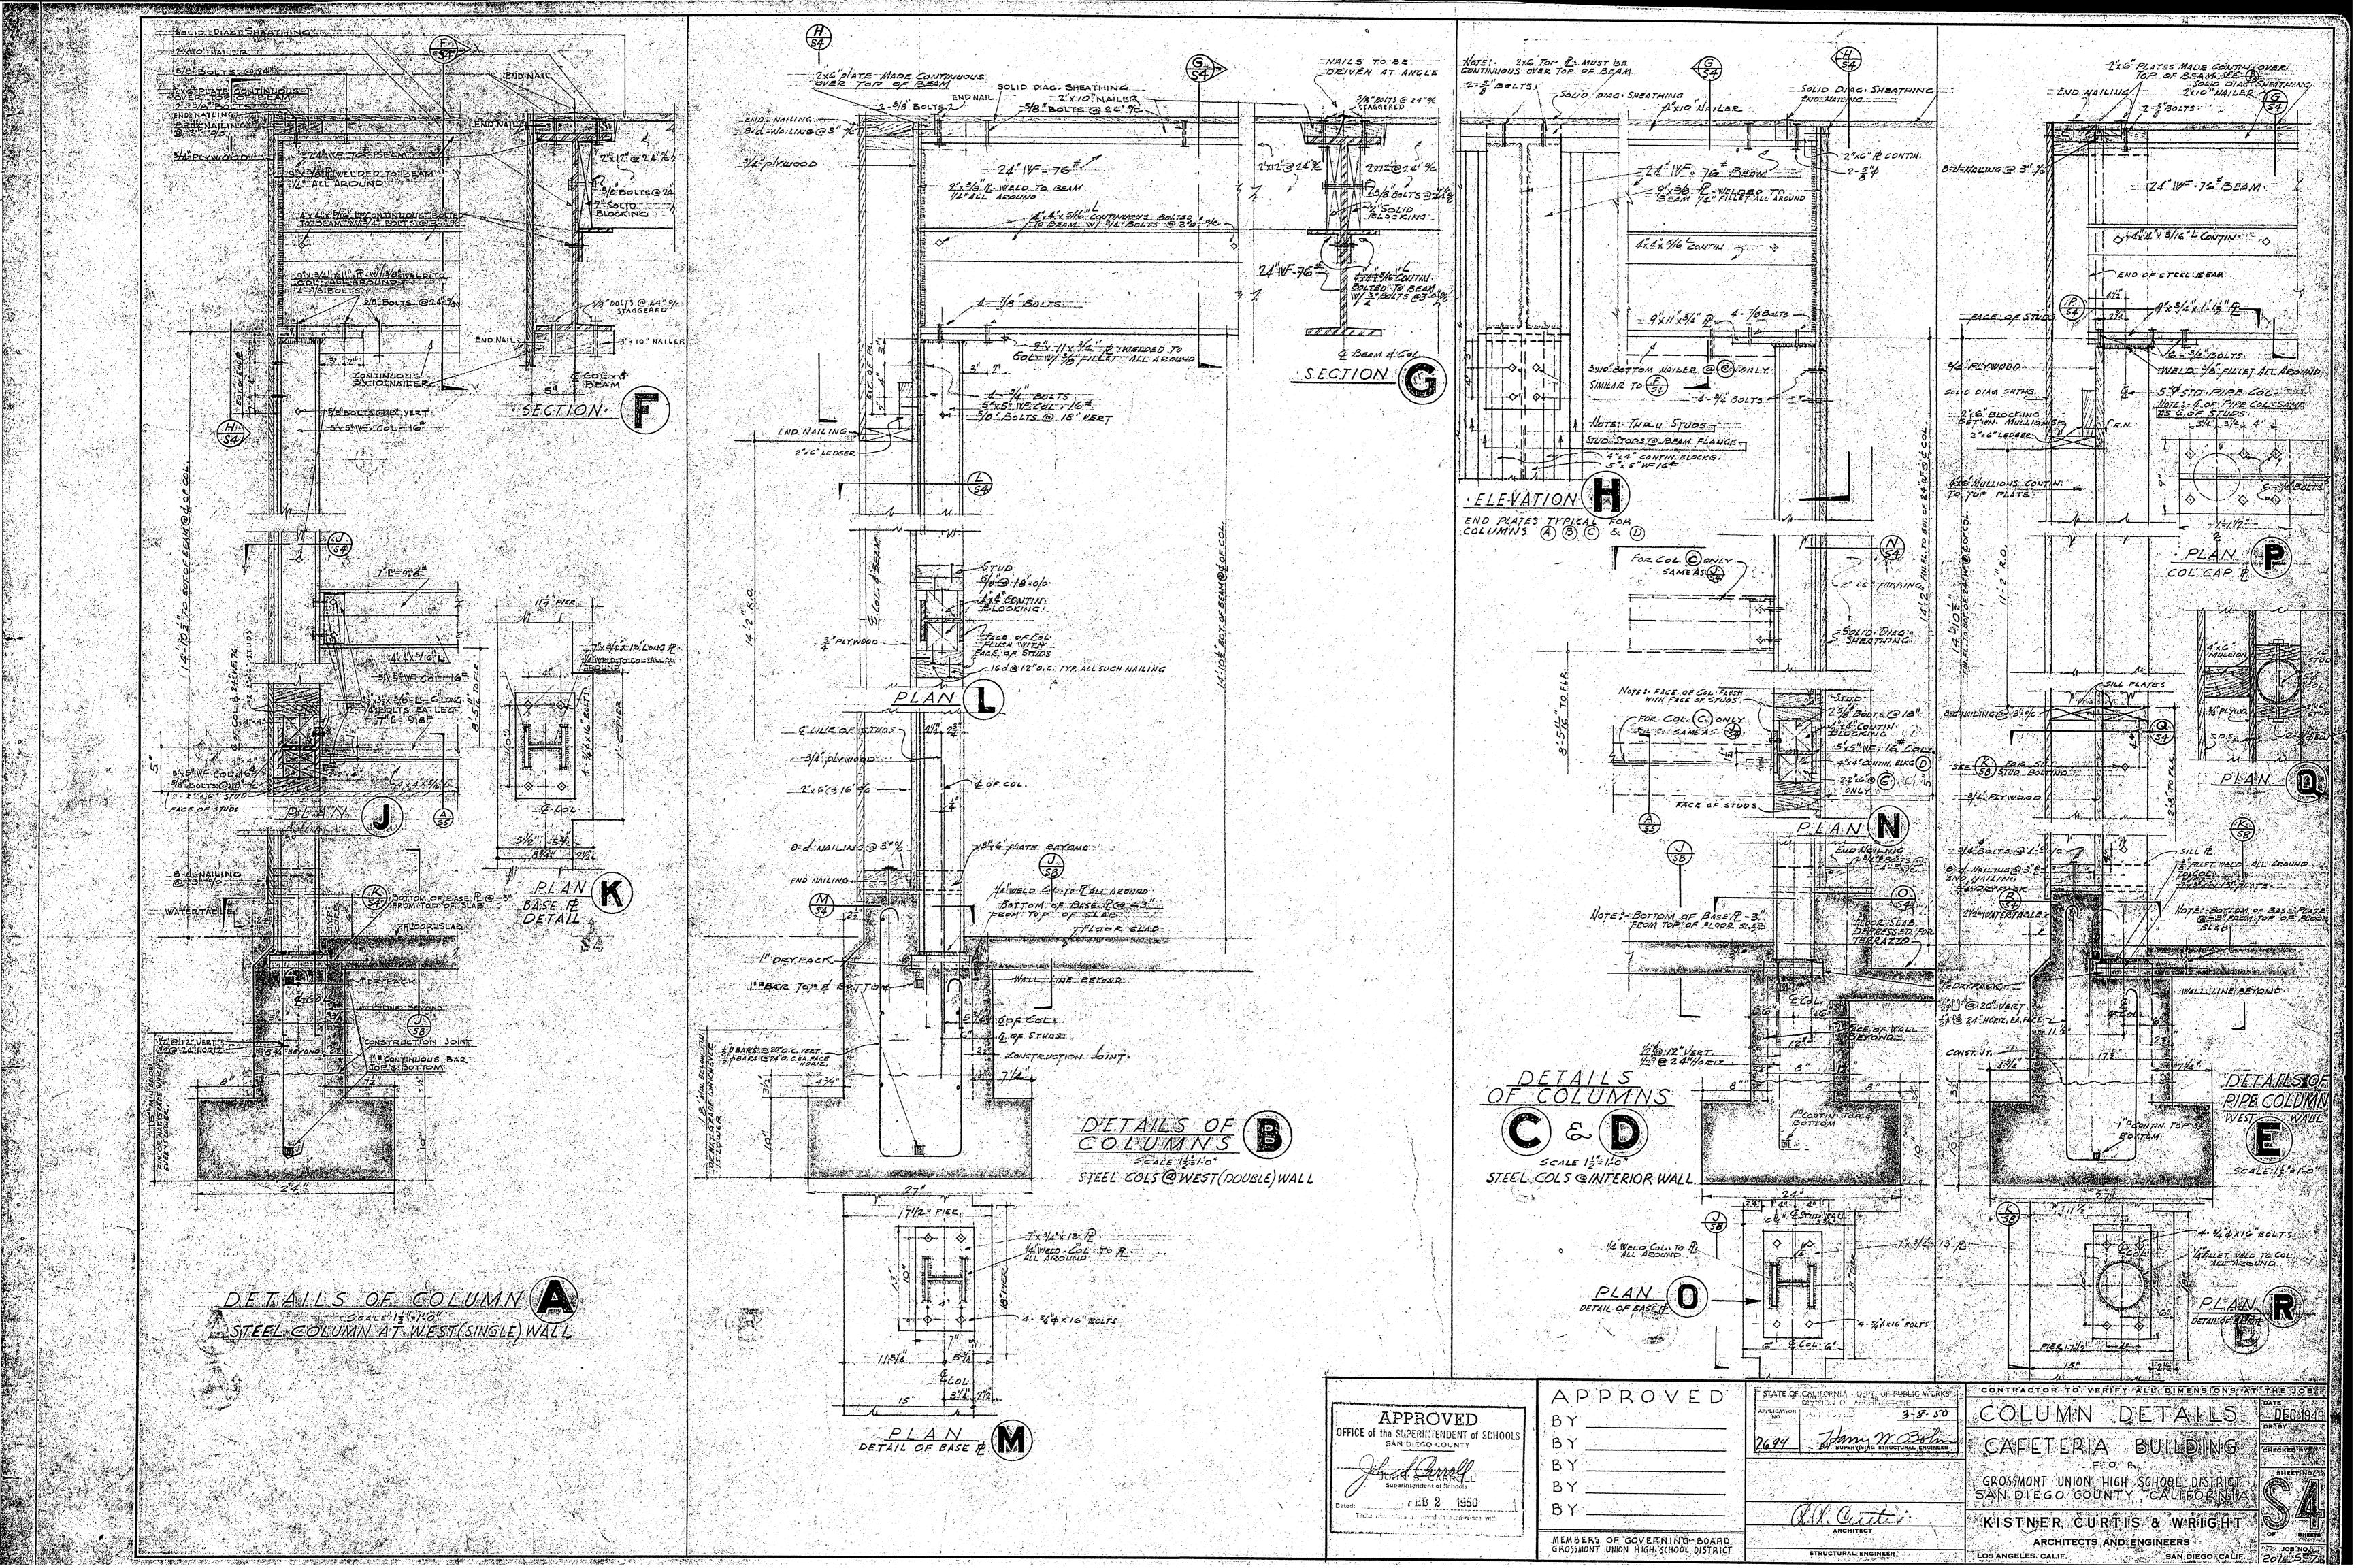


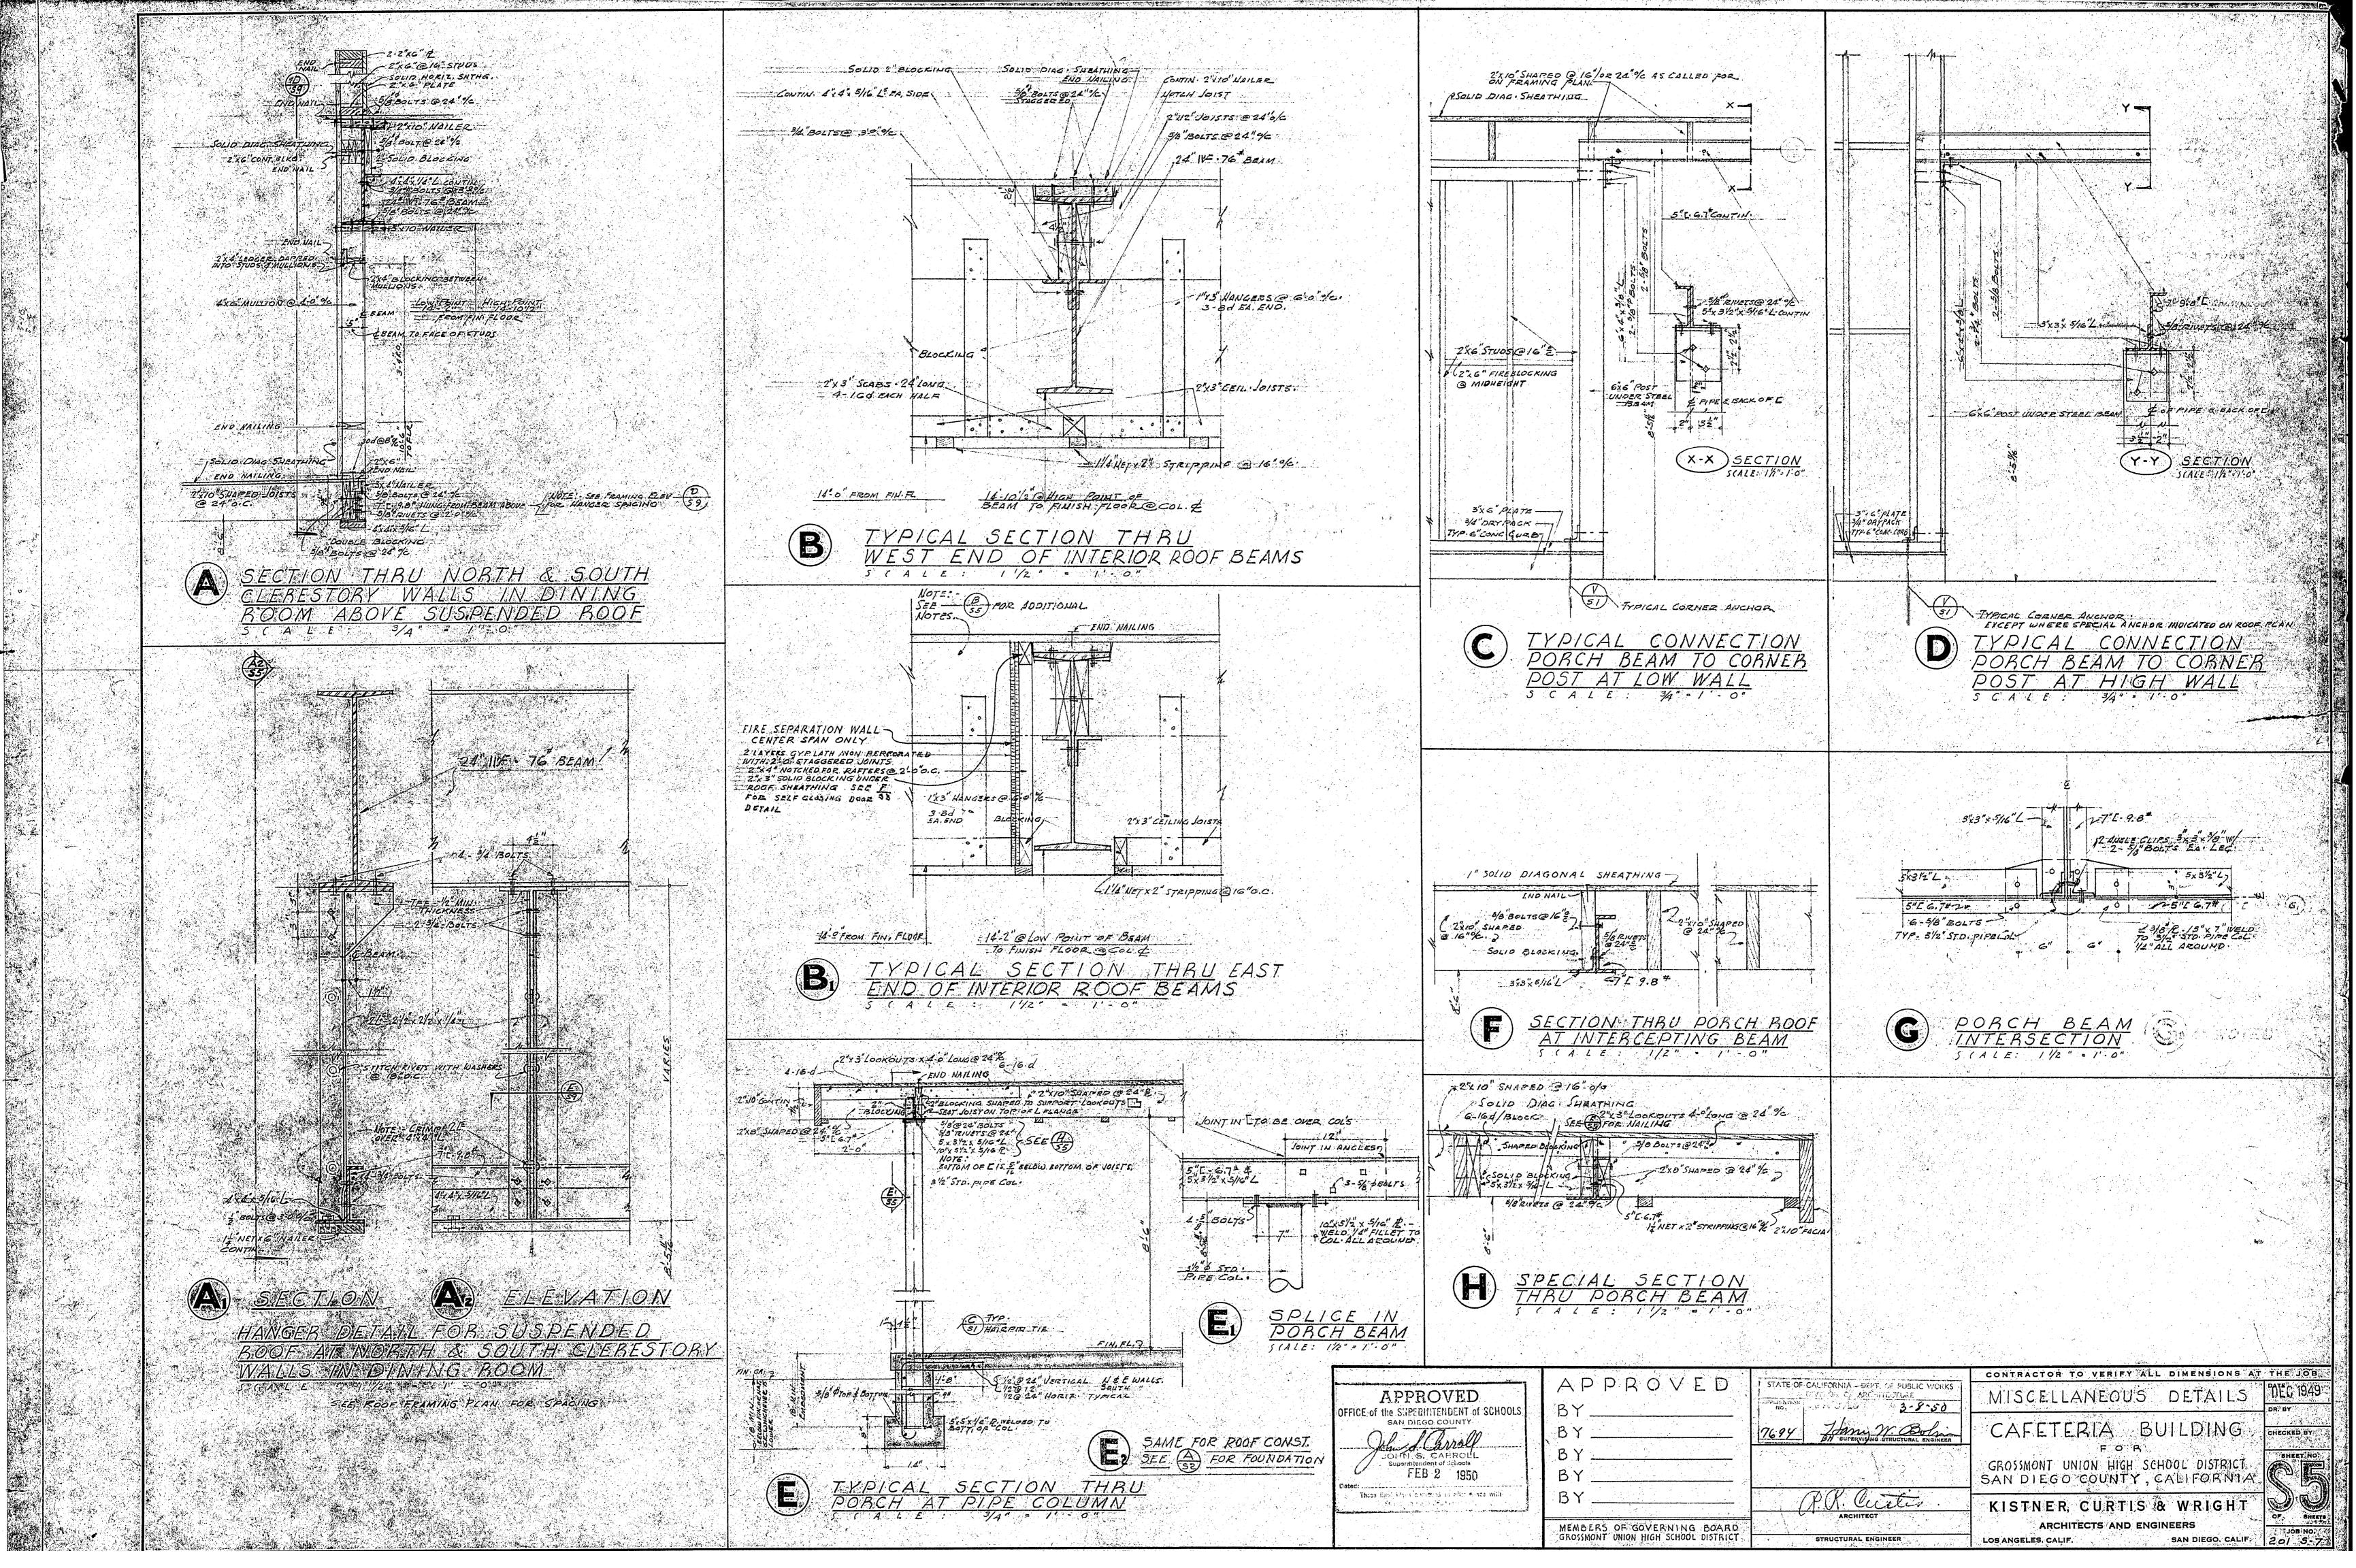


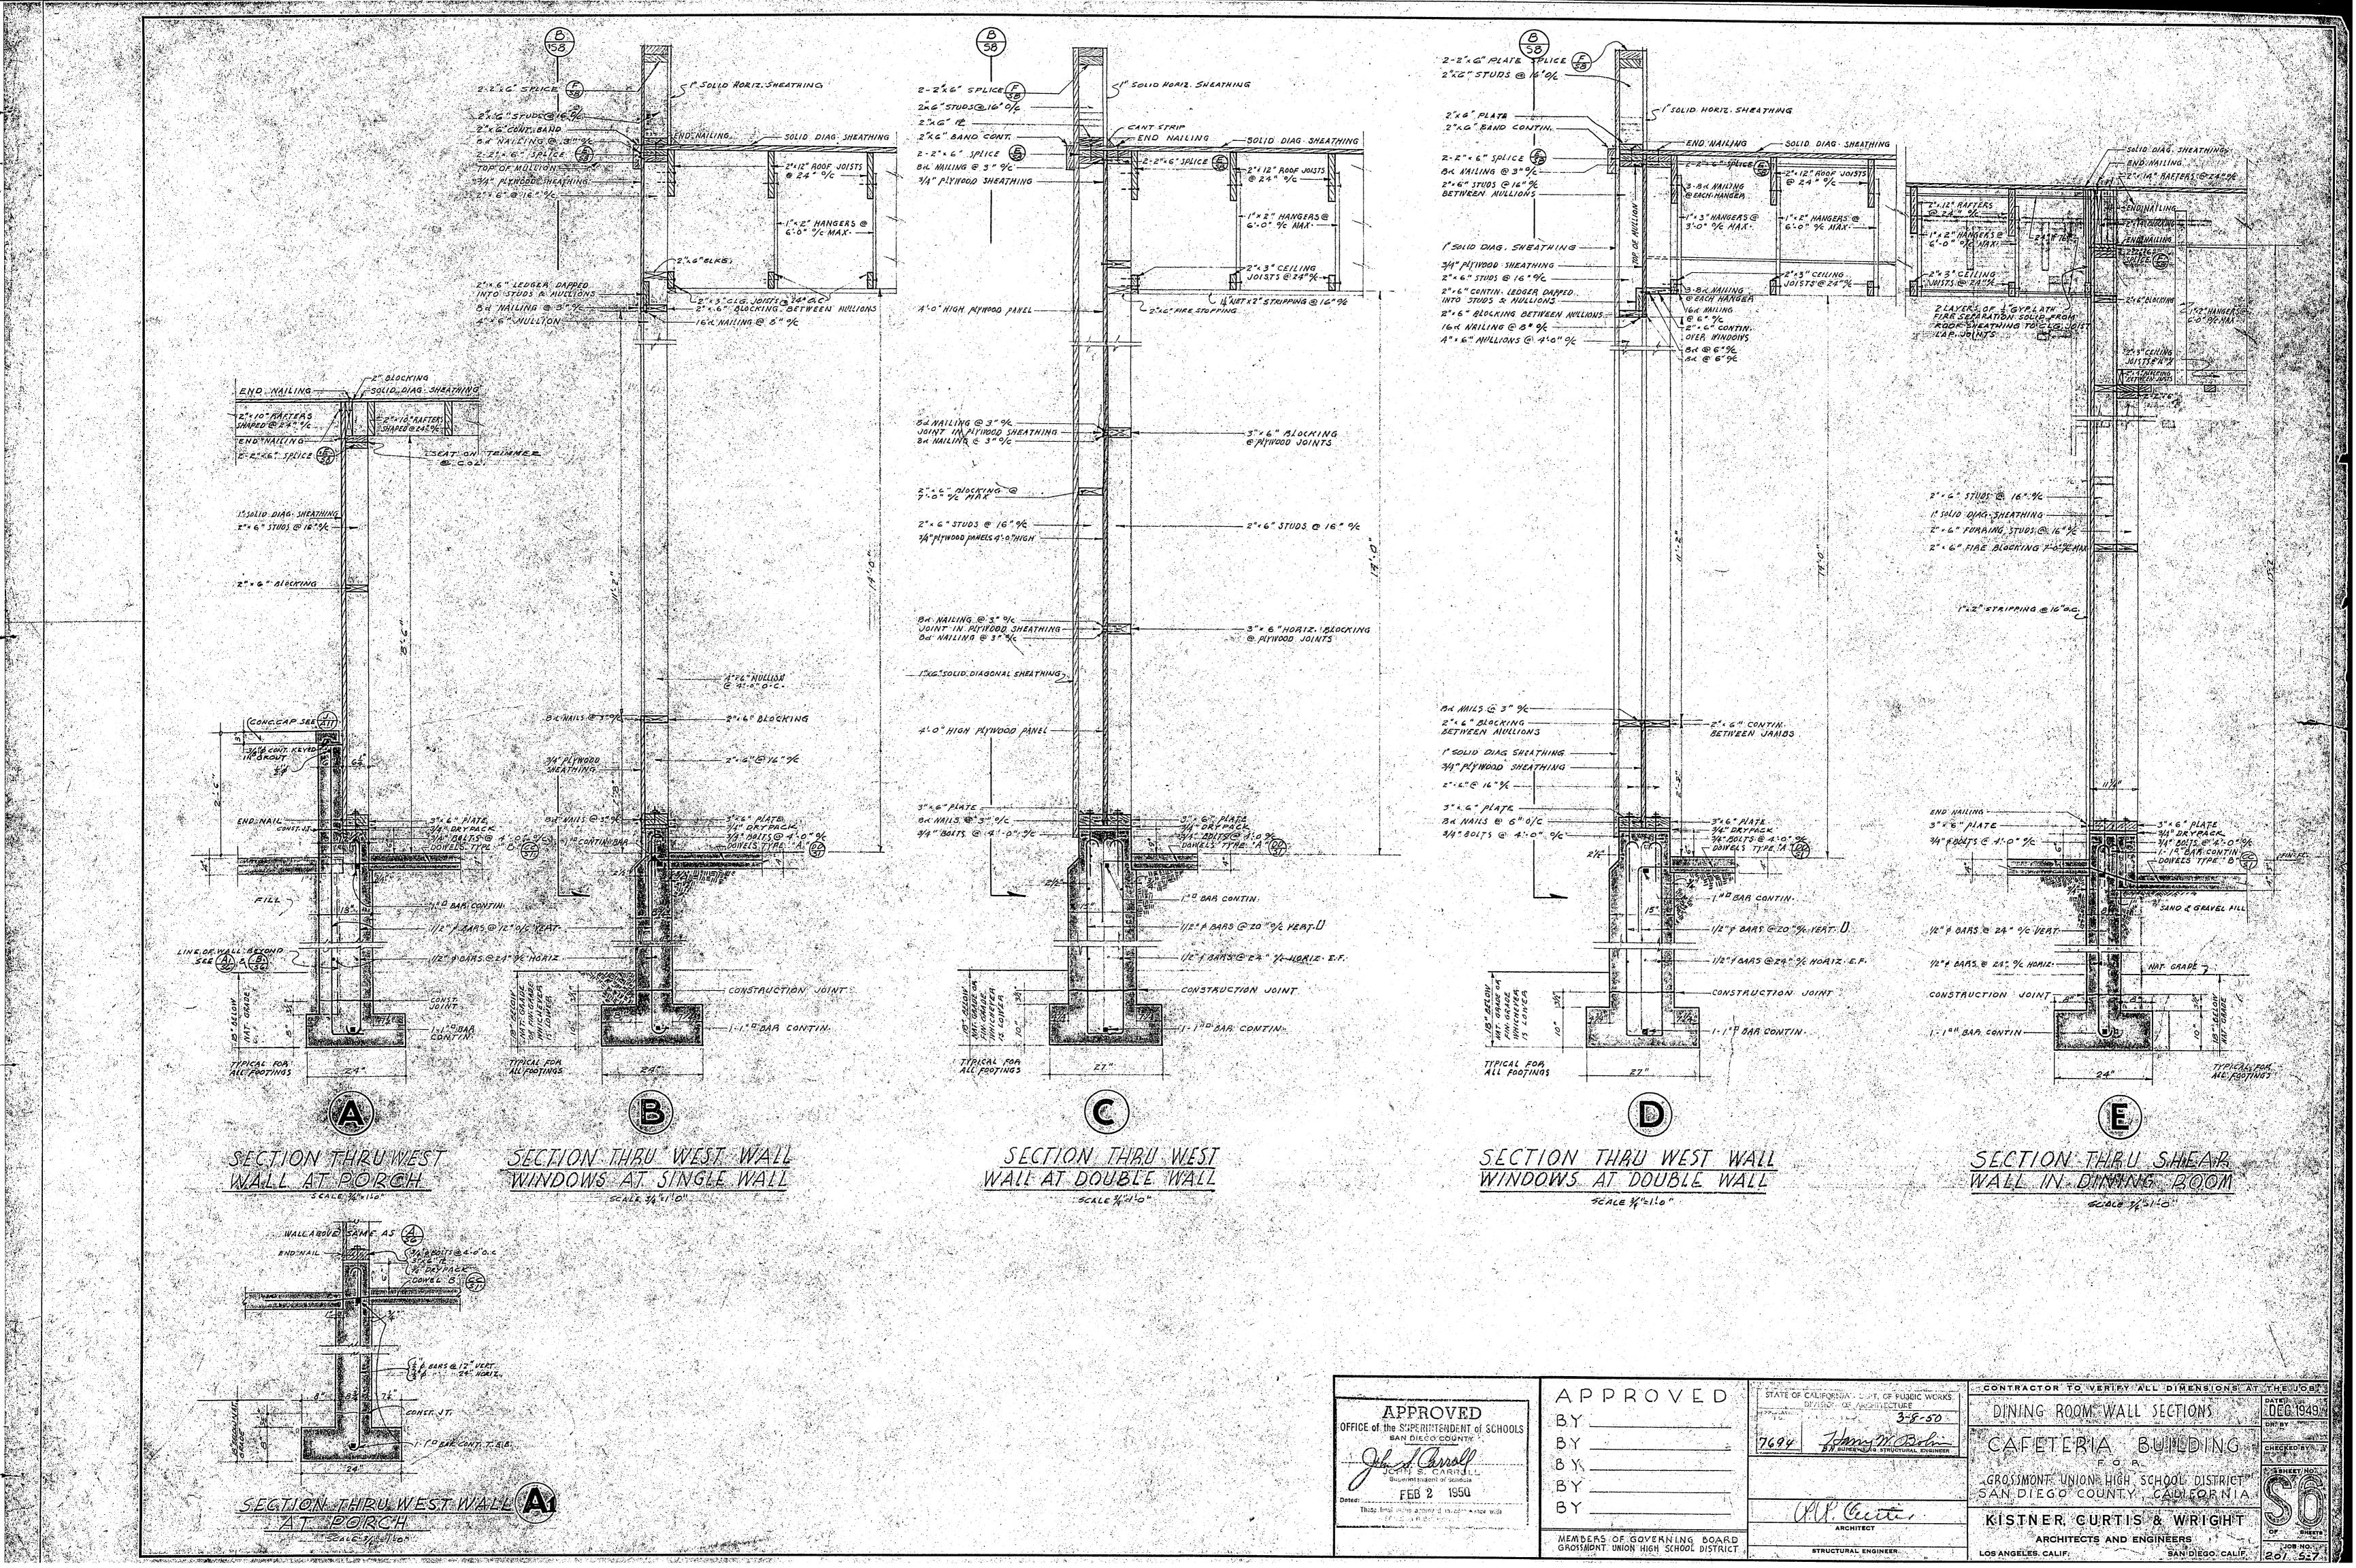


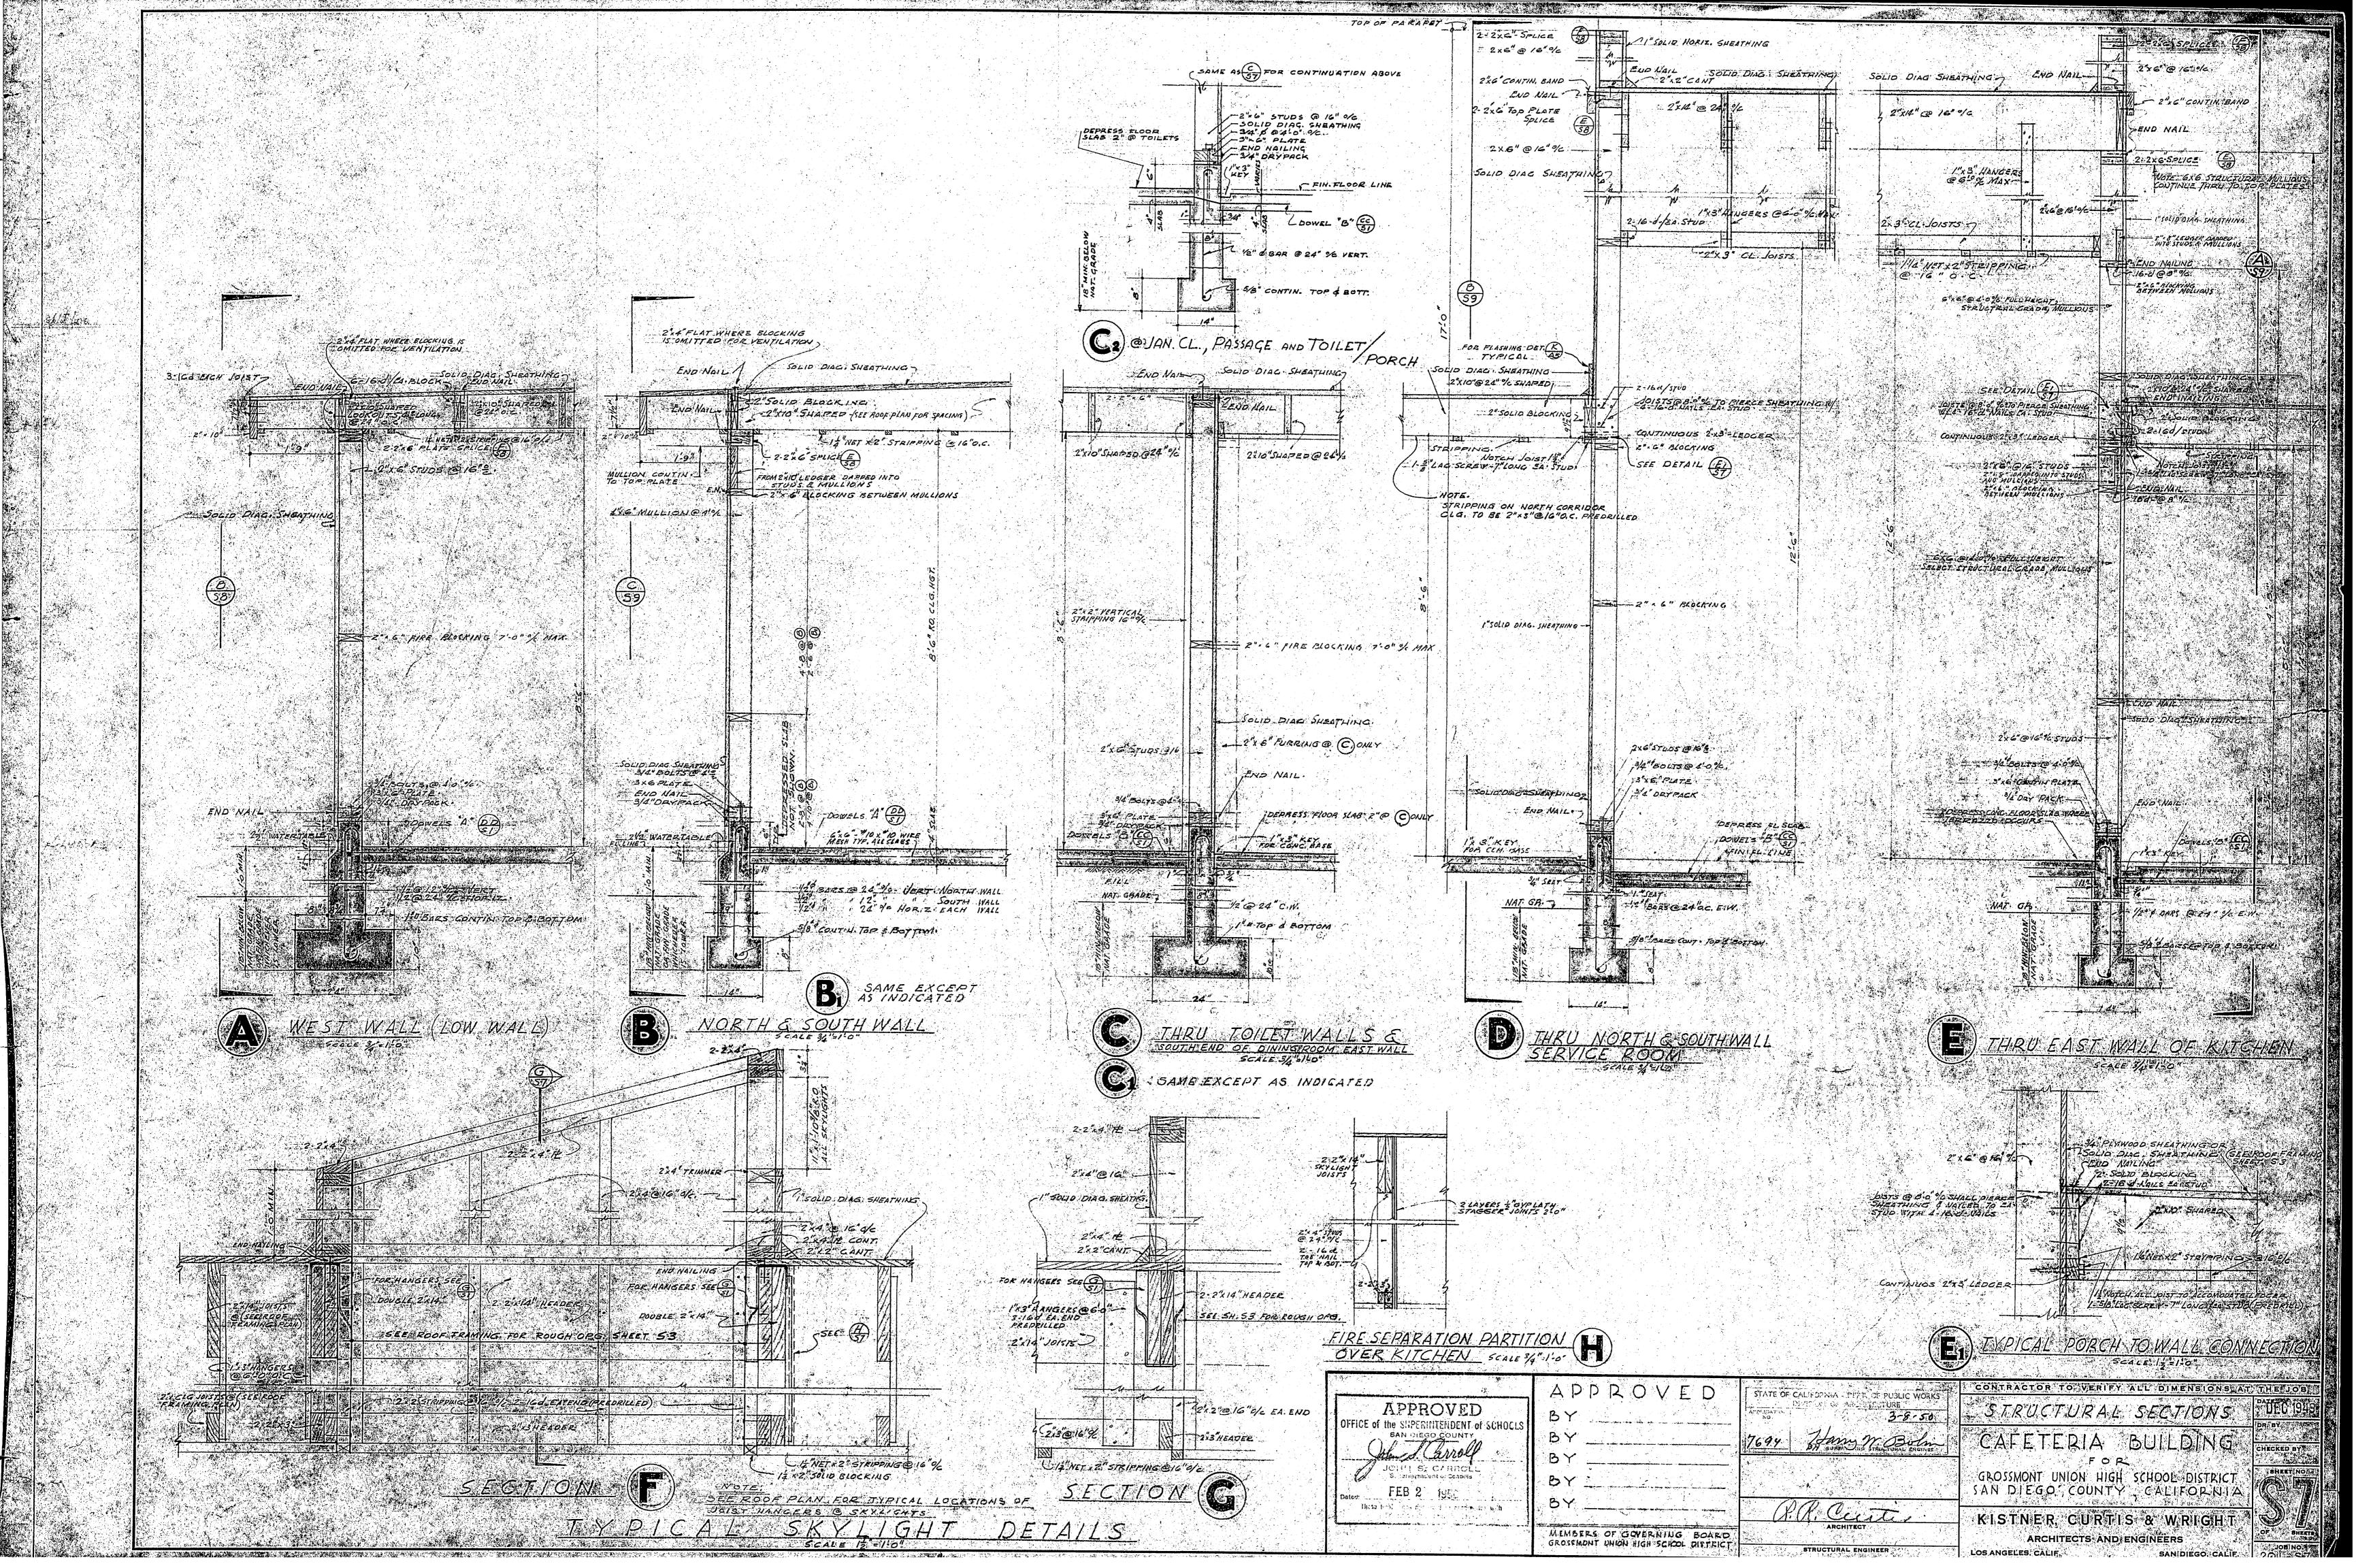


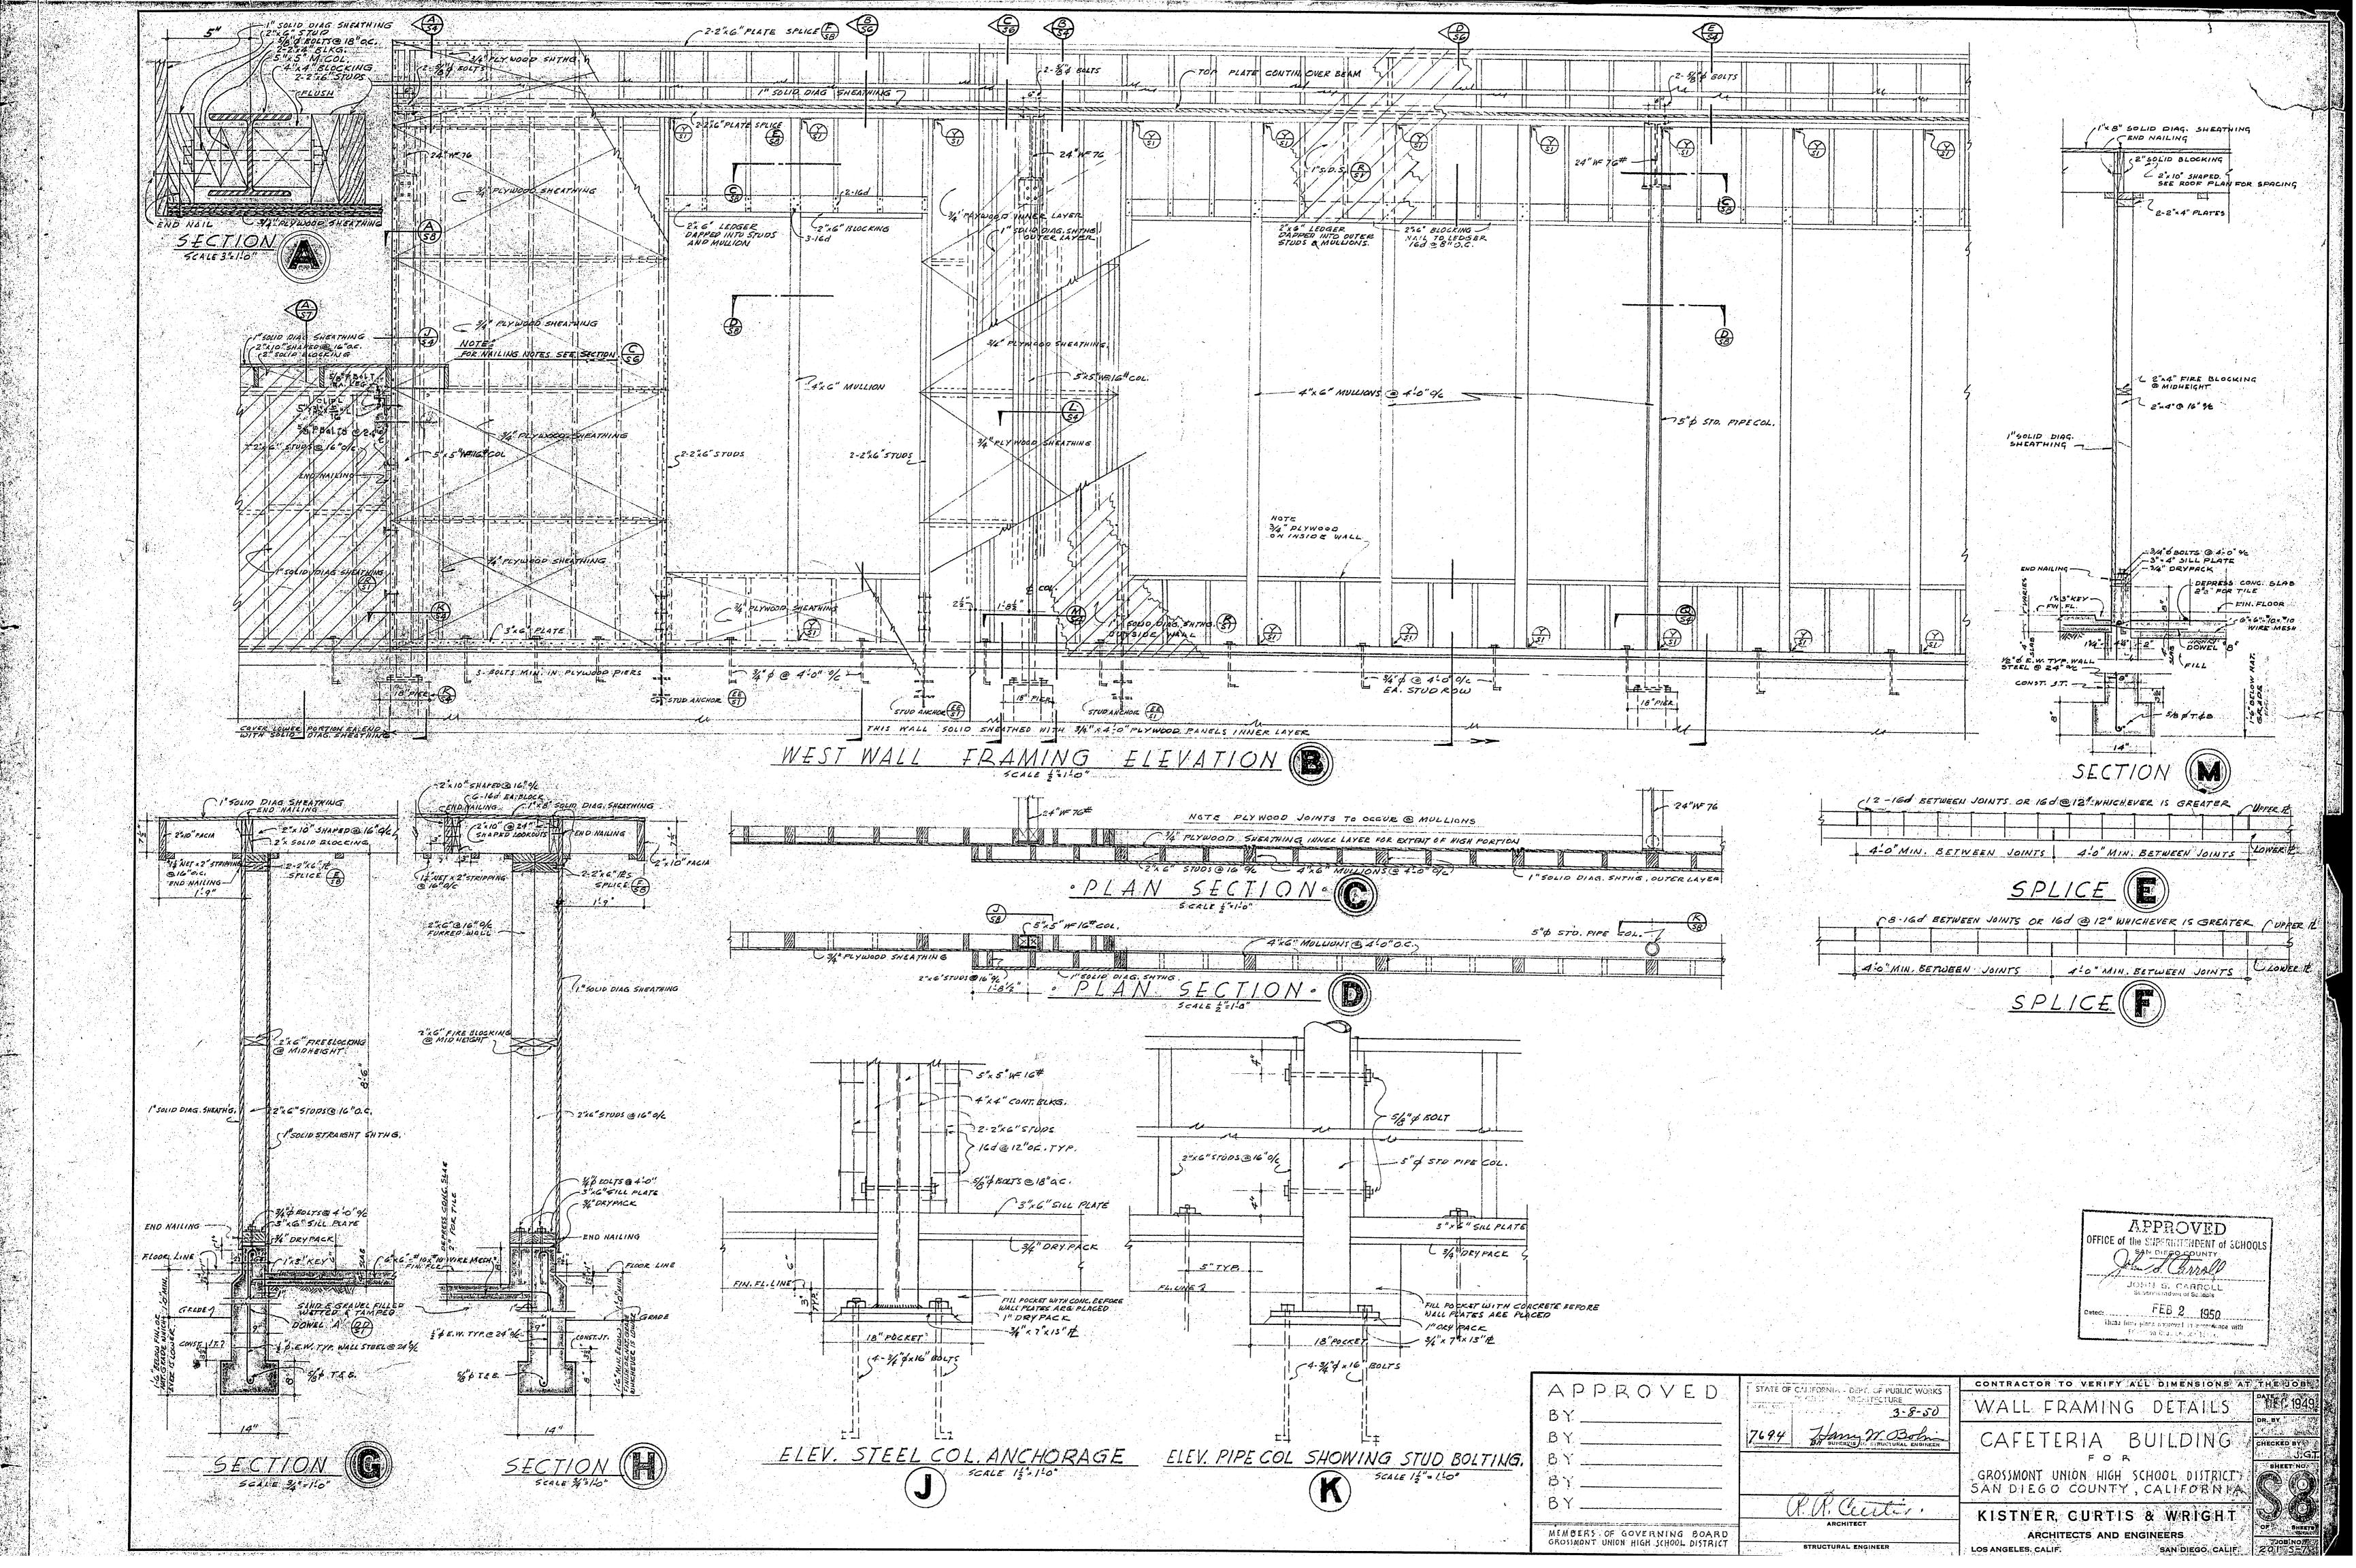


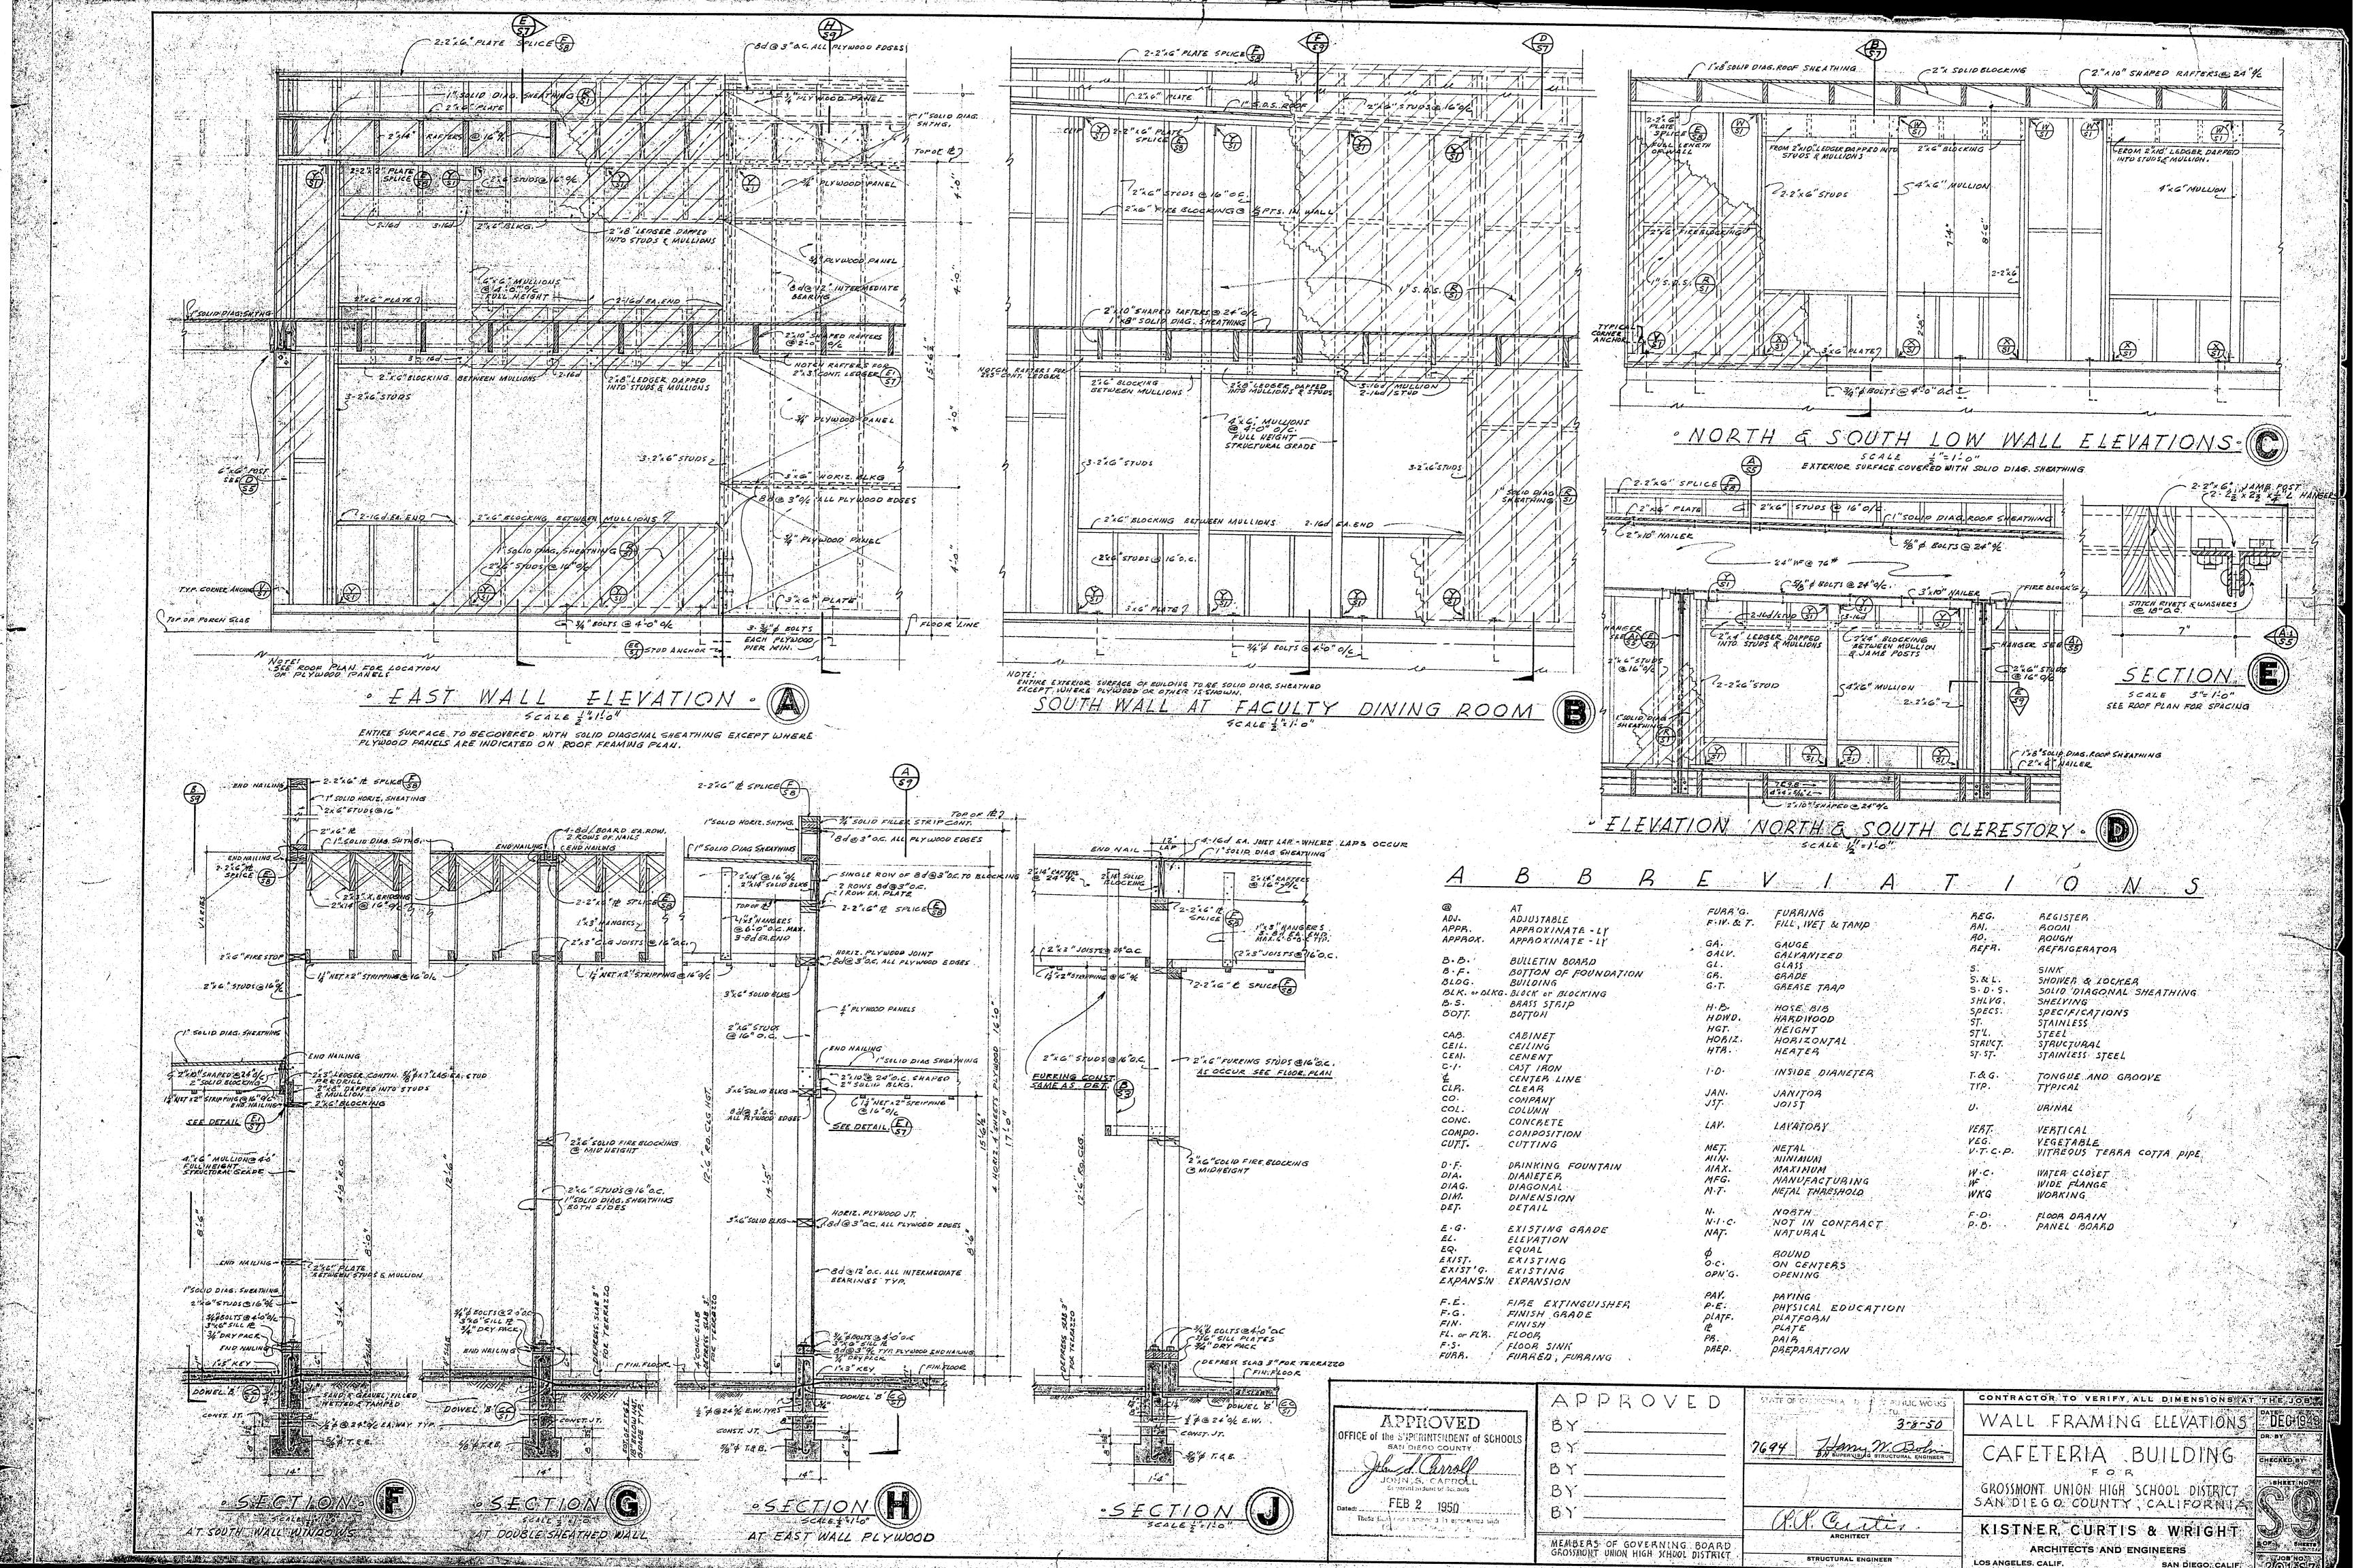

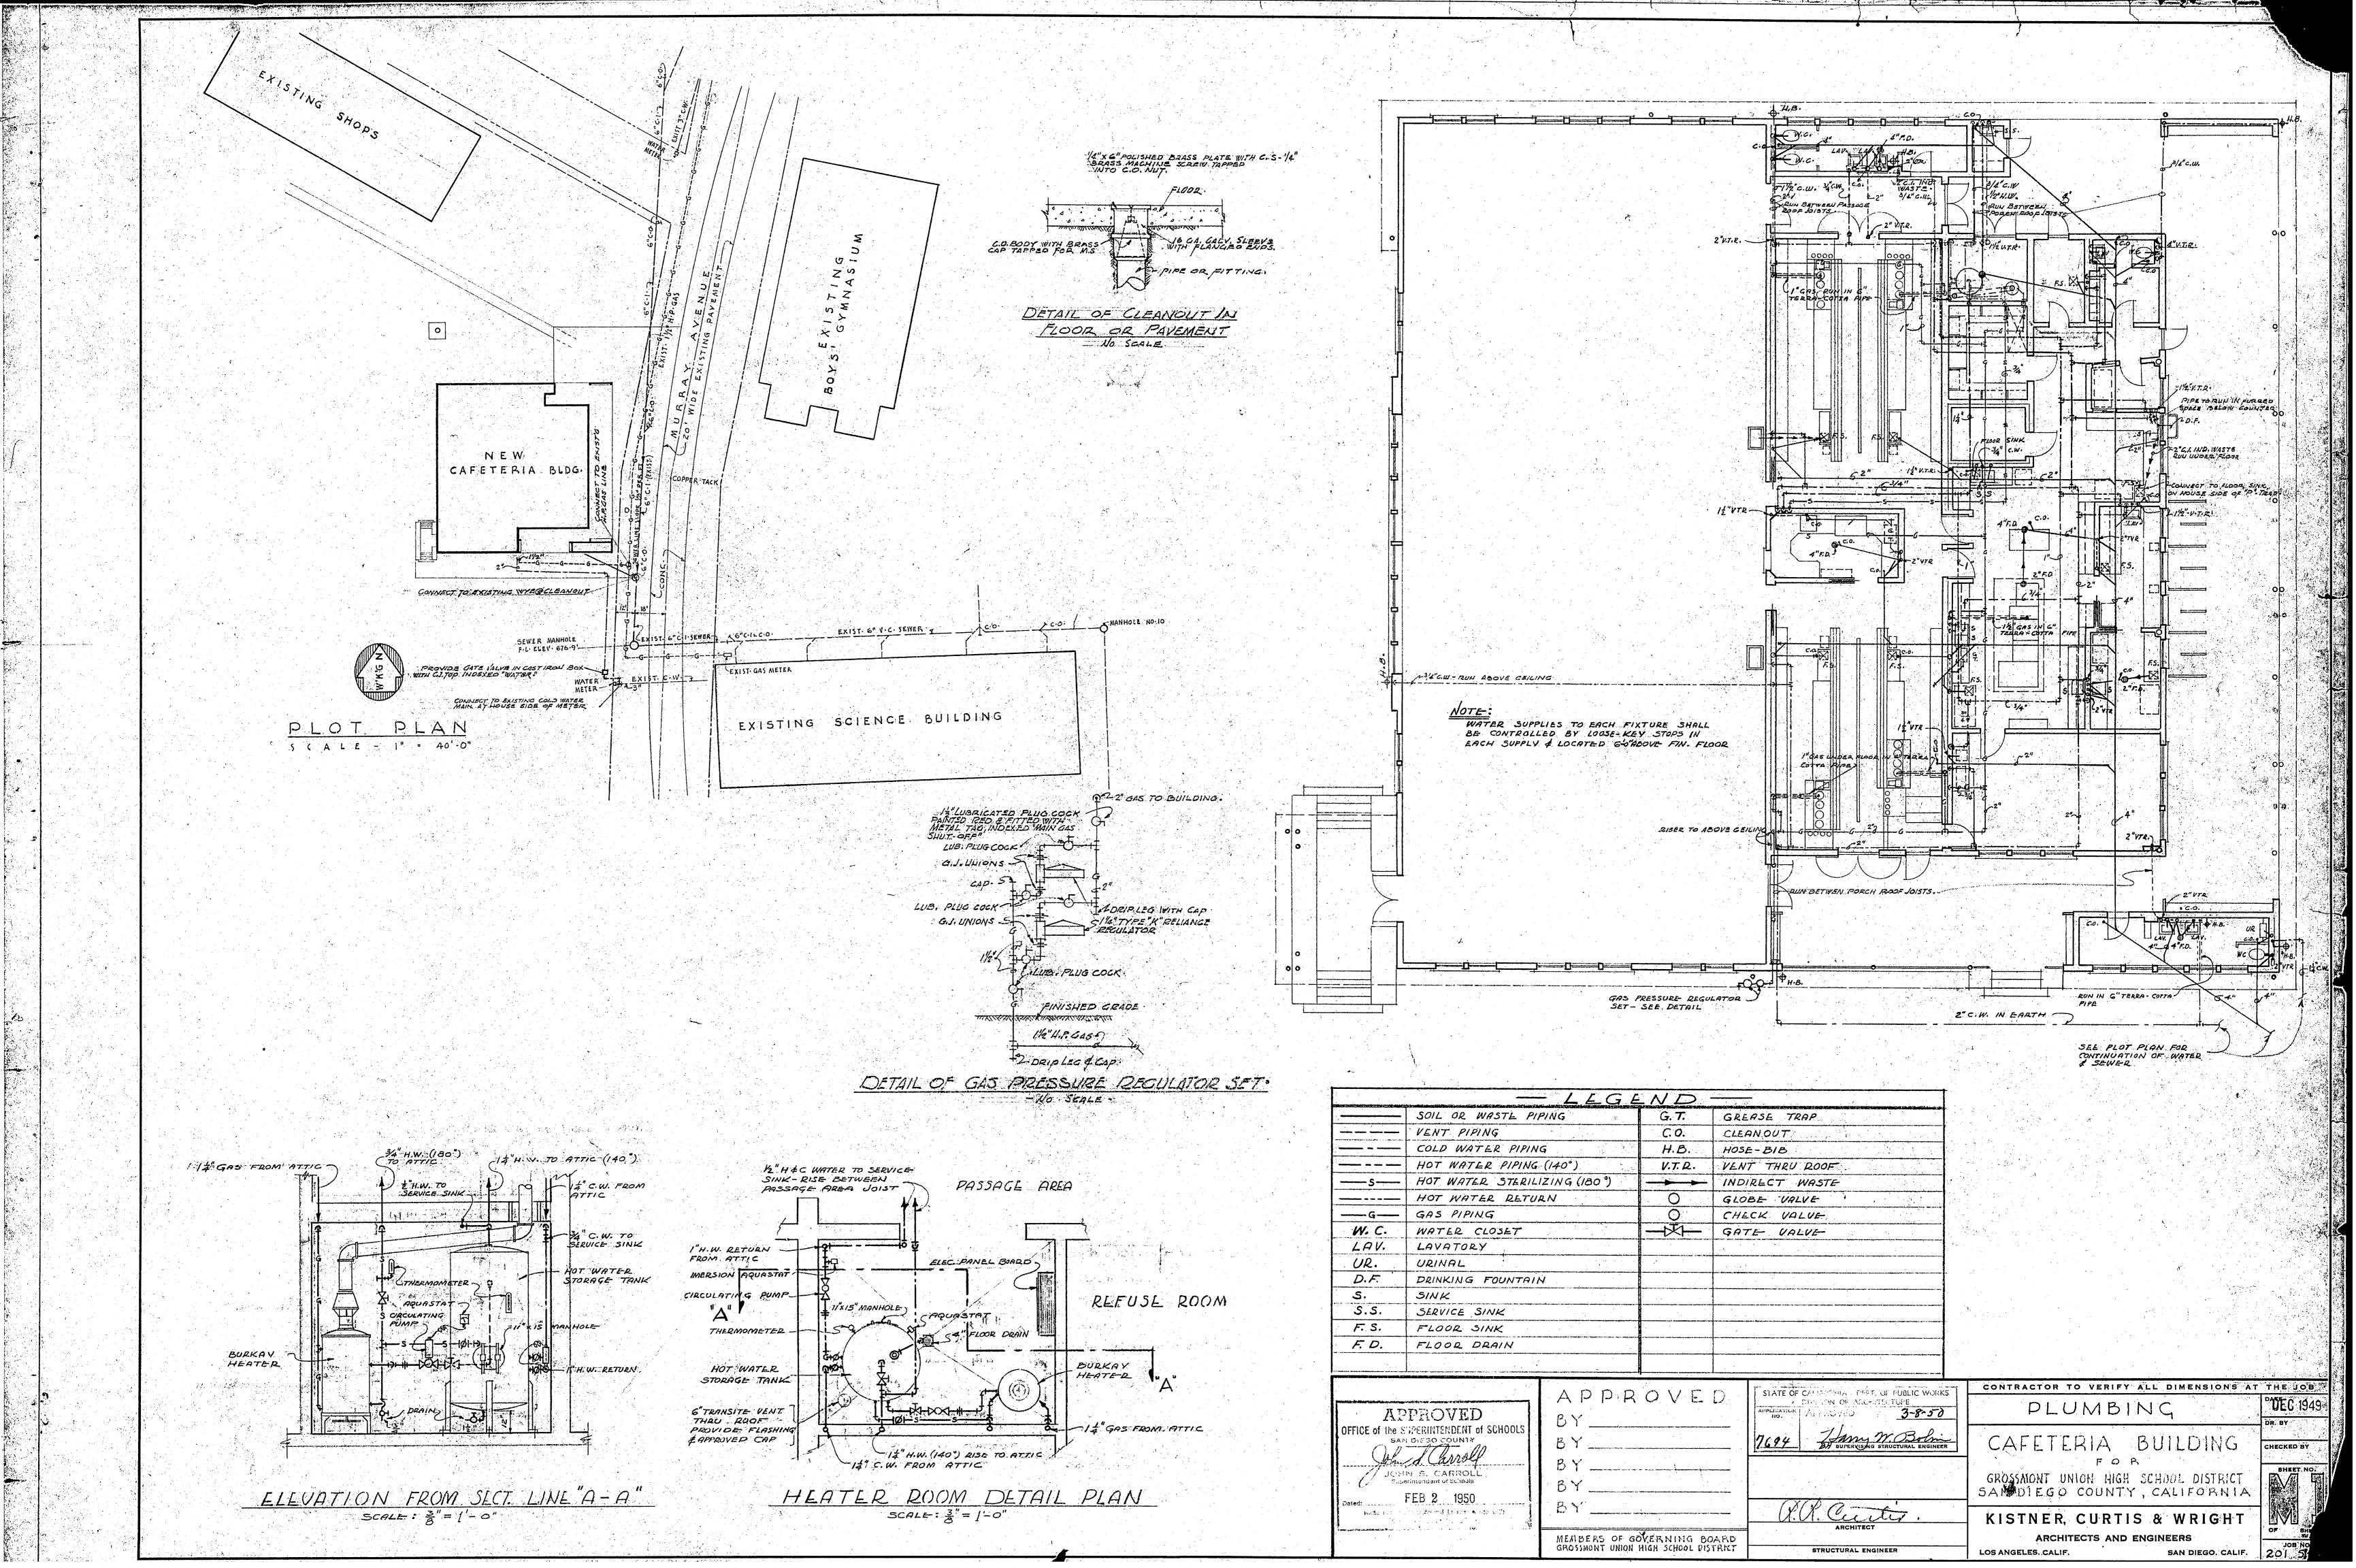

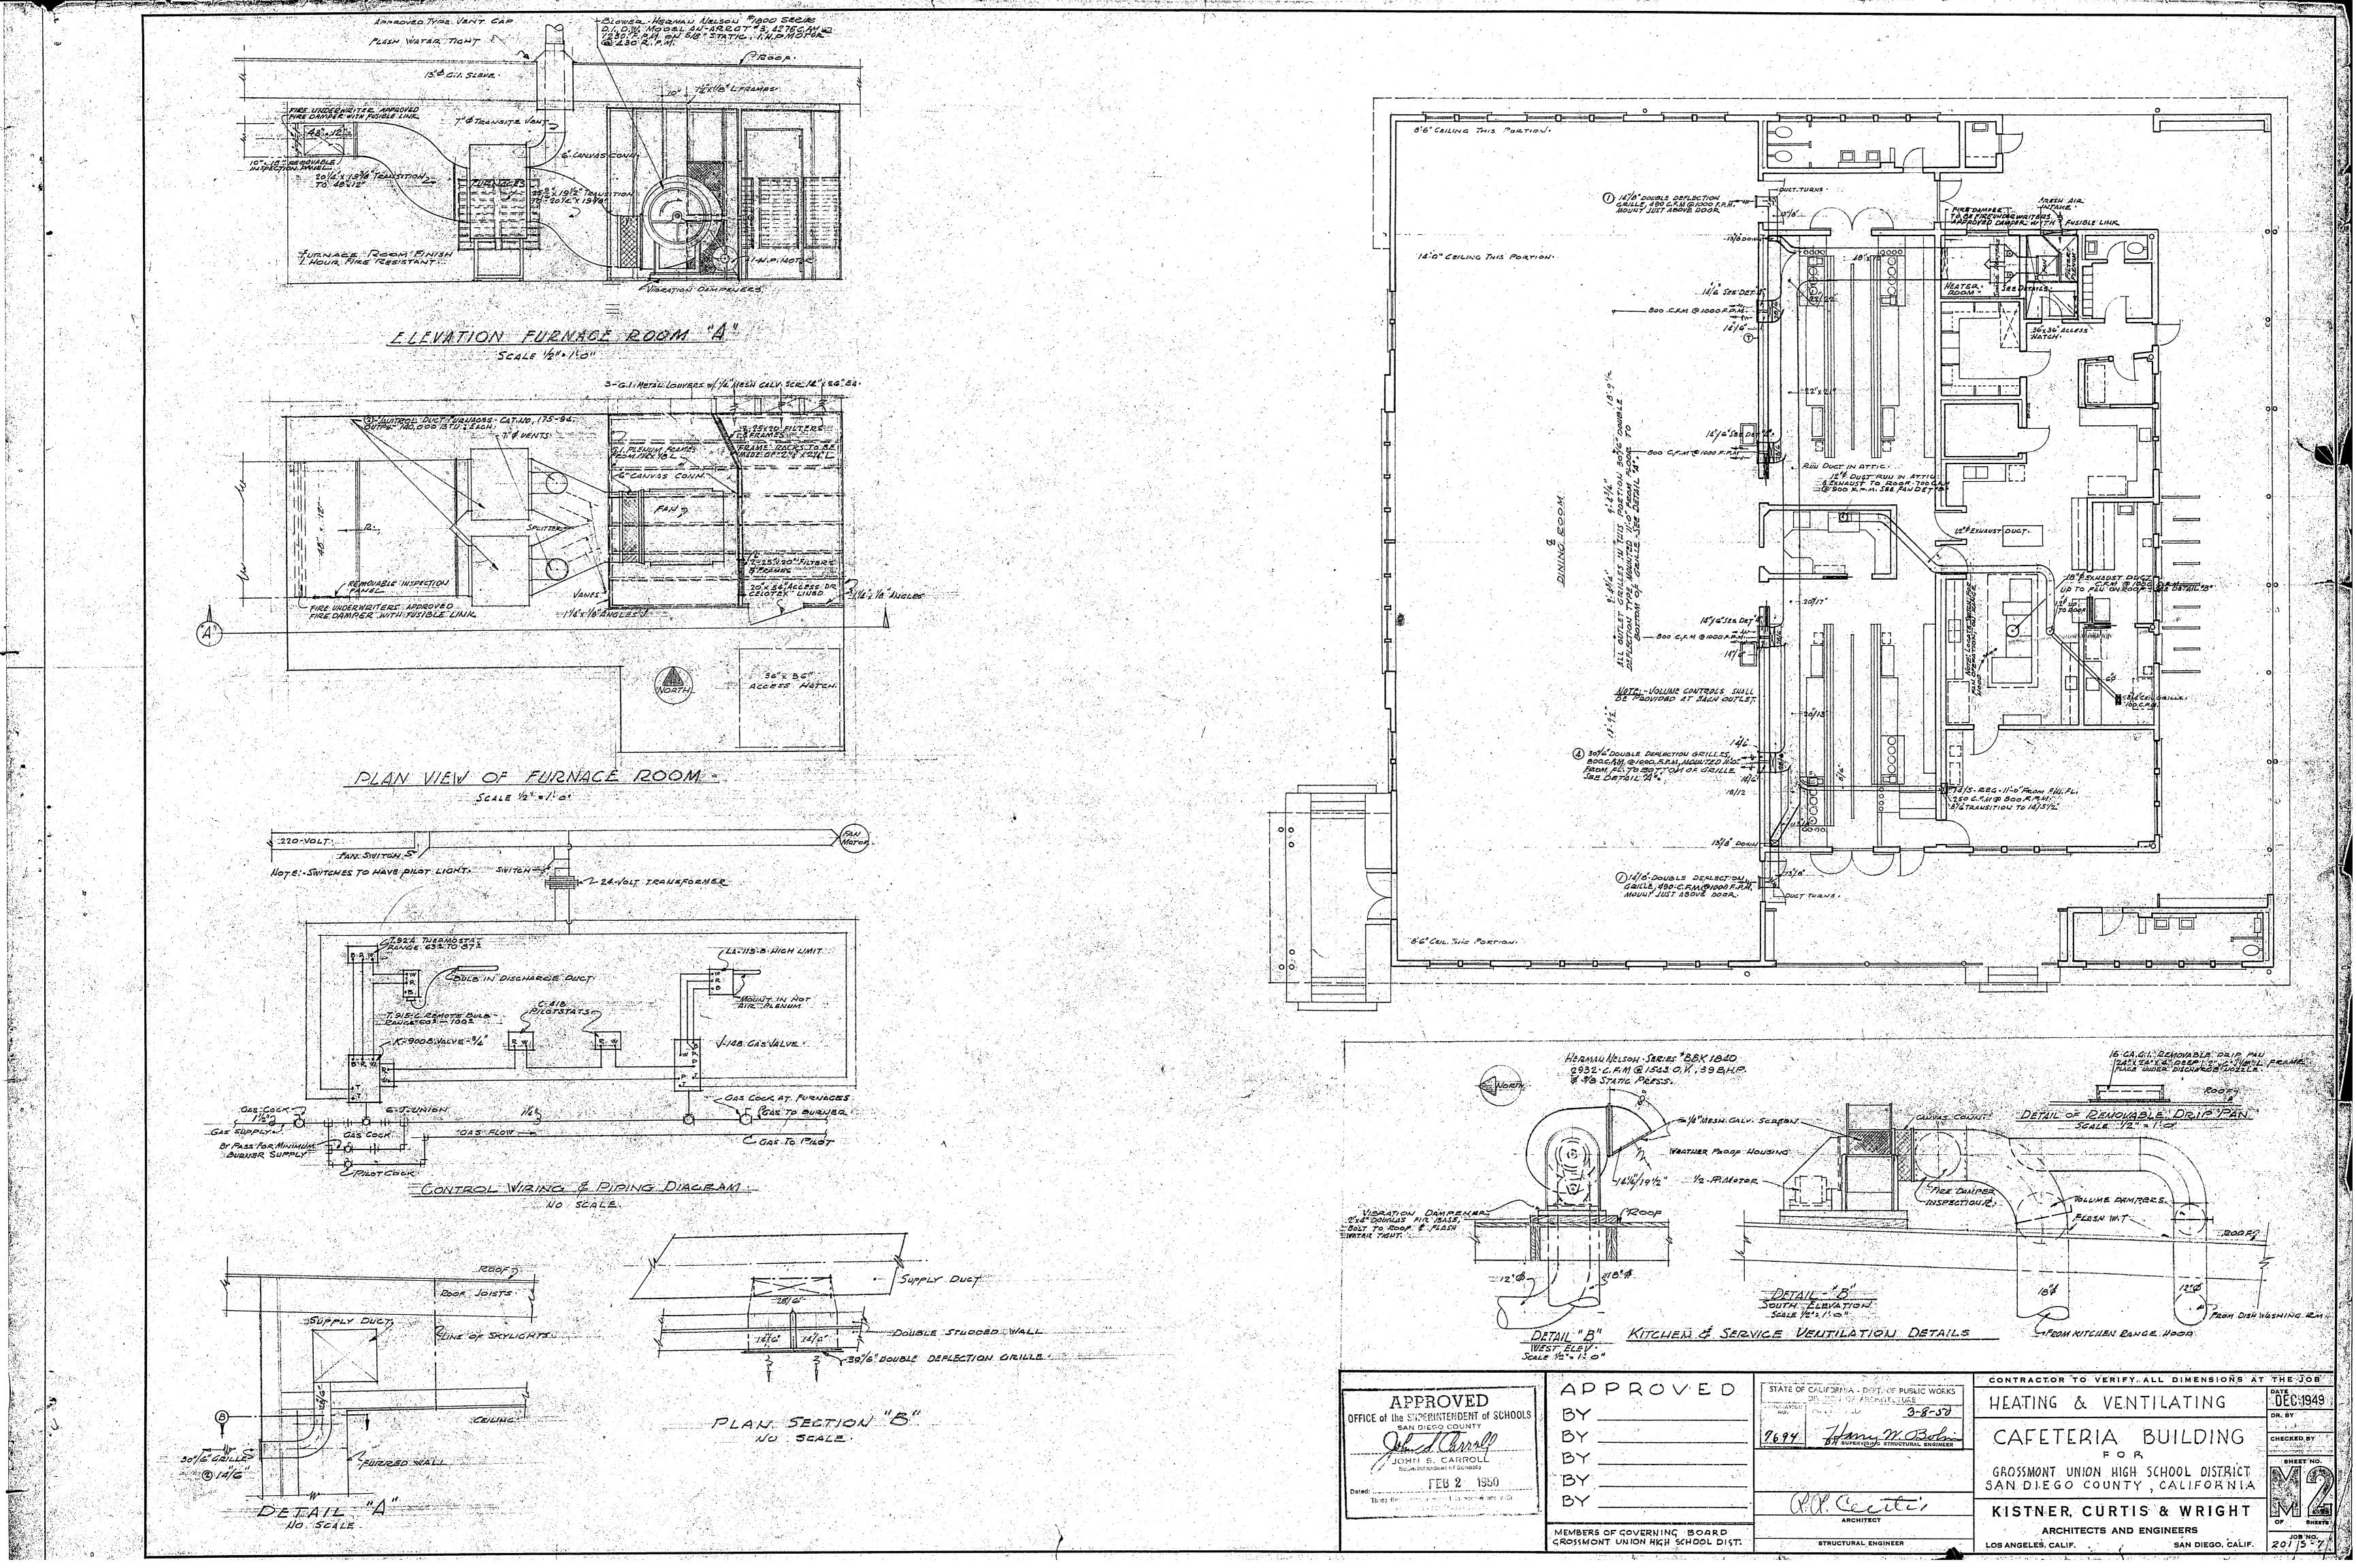

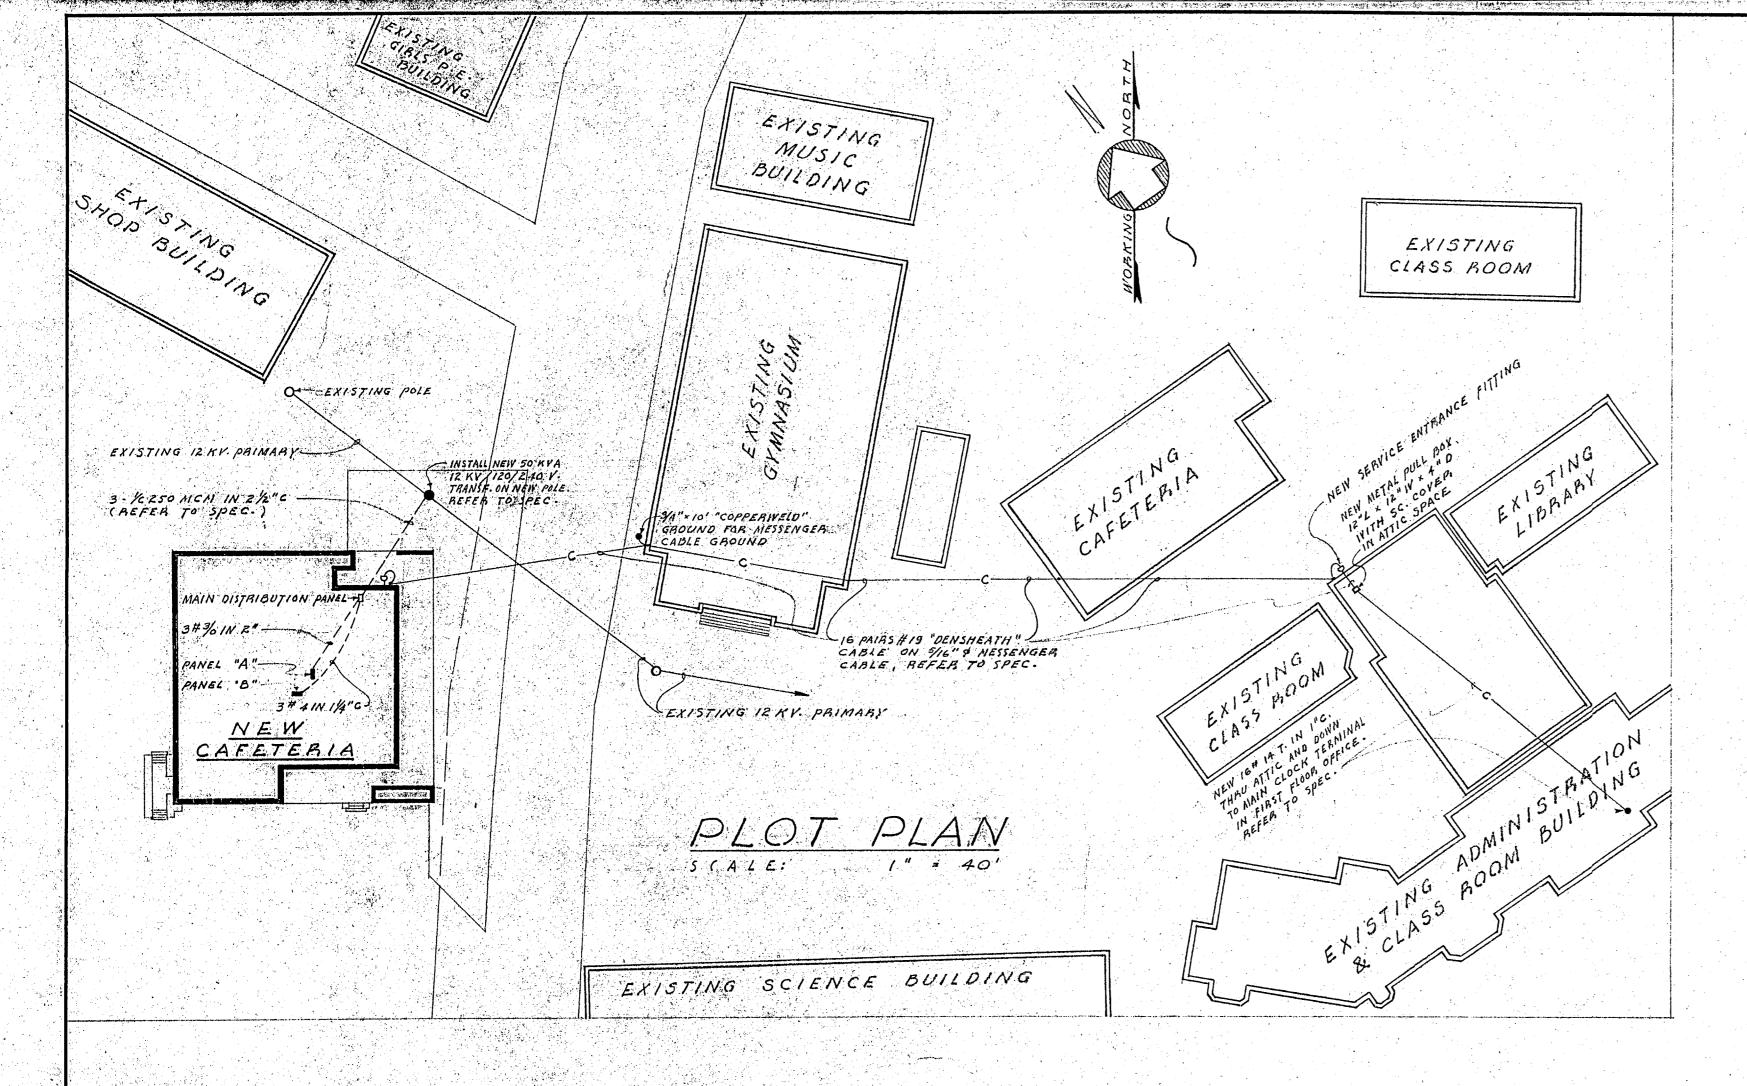

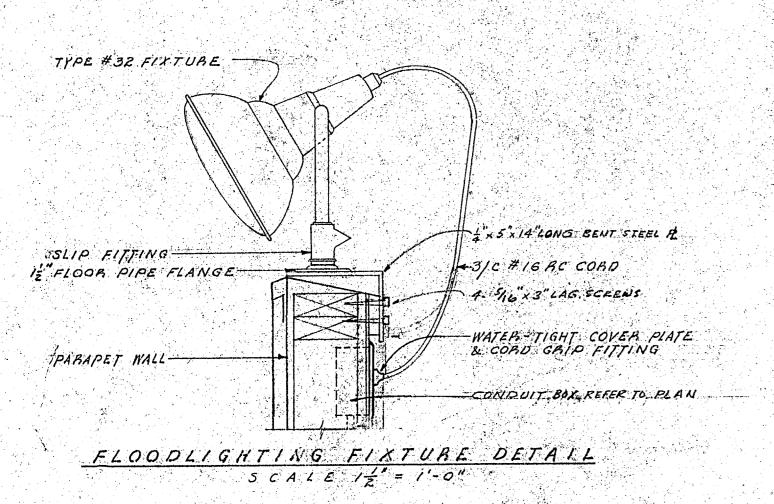

	TING		EL "A	·
CIRCUIT NUMBER	OF OUTLETS	BUS A"	WATTS BUS "B"	CIRCUIT BREAKER
1	Z	1500		20A., IP.
2	2		1500	
3	2	1500		
4	2		1500	
5	2	1500		
6	2		1500	
7	2	1500		
. 8	2.		1500	
9	2	1500		ļ
10	.5		1000	15A., IP.
11	2	1000		15 A., 1P.
12	3	1800	1500	20A., IP.
1.3	6	1200	750	15 A, IP.
14	2	~~~	750	
15	2	750		
16	3		450	
17	5	600	1300	
18	<i>A</i>	1000	1 500	
19		1000	1200	-
20	<u>ර</u> 3	450	1200	
22	4	730	650	
23	<i>A</i> .	600		
24	4		600	
2.5	4	600		
26		41-41-1-1-1-1-1-1-1-1-1-1-1-1-1-1-1-1-1		
27	1	600	600	15A-, 2P.
28	The state of the s			
29		500	500	15A., 2P.
30	1		1000	15A., IP
31	1 43	50.0	 	15A., IP
32				
33		600	600	15 A., 2P
34				
35	"	600	600	15A,2P
36	5		750	15A, IP
37	4	600		15A, 1P
38	A CONTRACTOR OF THE PROPERTY O		ļ	
39		600	600	15 A., 2P
40	SPARE		500	20A,1P
4.1	SPACE ONLY			
42	SPACE ONLY			
TOTAL	S	17,700	18,600	
TOTAL	4	W = 152 AM		

NOTES


- 1 SUBSCRIPTS OF a, b, c, ETC. AT SIVITCH SYMBOLS ARE TO DIFFERENTIATE CONTROLLING SWITCHES.
- 2 +4'-6" INDICATES A MOUNTING HEIGHT OF 4'-6" FROM FLOOR TO CENTER OF OUTLET OR EQUIPMENT.
- 3 2-750 W-1- AS PANEL AT A FIXTURE INDICATES
 THE FOLLOWING: Z = NUMBER OF FIXTURES;
 750 W = IVATTAGE PER FIXTURE; I = FIXTURE TYPE;
 A5 = CIRCUIT NUMBER; PANEL = LIGHTS CONTROLLED
 AT PANEL,
- 4 MH = FIXTURE MOUNTING HEIGHT FLOOP, TO BOTTOM OF FIXTURE.
- 5 CROSS HATCHES ON A CONDUIT BUN INDICATE THE NUMBER OF CONDUCTORS. CONDUIT RUNS WITHOUT CROSS HATCHES OR NOTATION SHALL BE 2 # 12 IN /2"C.
- 6 MININUAL WIRE SIZE FOR 120 OR 240 VOLT CIRCUITS SHALL BE # A · IV · G ·
- 7 ALL CONDUIT SIZES SHALL CONFORM TO THE REQUIREMENTS OF THE CALIFORNIA "ELECTRICAL SAFETY ORDERS" UNLESS NOTED AS LARGER.
- 8 CONTRACTOR SHALL VERIFY MOUNTING HEIGHT OF ALL OUTLETS BEFORE INSTALLATION.
- 9 INSTALLATION OF JUNCTION BOXES, FOR PUBLIC ADDRESS SPEAKERS ON TOP OF PARAPET WALL, SHALL BE SIMILAR TO THAT REQUIRED FOR THE FLOODLIGHTS
- 10 INSTALL REQUIRED TERMINALS IN THE MAIN TERMINAL CABINET (FOR CLOCK SYSTEM) AND LACE NEW AND EXISTING CONDUCTORS IN A NEAT & HORKMANLIKE MANNER. CONTRACTOR SHALL VISIT THE SITE AND VERIFY ALL REQUIREMENTS
- 11. THE NEW 50 KYA TRANSFORMER SHALL BE CONNECTED TO THE PRIMARY OVERHEAD LINE IN SUCH A MANNER THAT PHASE LOADS (CONNECTED TRANSFORMER CAPACITY) WILL BE AS NEARLY BALANCED AS POSSIBLE. CONTRACTOR SHALL VERIFY AND BEPORT FINDINGS TO THE ARMITECT.

LIGH	TING	PANE	L "B"	
CIRCUIT NUMBER	NUMBER OF	BUS "A"	: WATTS BUS "B"	CIRCUIT
1	3	1500		20A., 1P.
Z	7 · · ·		1400	15A., 1P
3	5	1000		
4	3		1150	
5	5	750		
6	3		450	
7	1	650		
రి	1	The state of the s	600	
9	1,	600		
10	,	500	500	154 00
11	er er i er er i e	. 300	300	15A.,2P
12	Z	and the second s	750	15A,1P
13	2	750		
. 14	5		750	
15	4	600		
16	4		600	
17	3 .	450	:	
18				
19		600	600	16A,ZP
20	SPARE	* ************************************	500	15A,1P
21	SPACE ONLY			
2.2	SPACE ONLY			
23	SPACE ONLY	1		
2.4	SPACE ONLY			
TOTALS		7400	7300	Sir- Minimum distriction grangings and


SYMBOLS


	•	
		LIGHTING OUTLET - IN CEILING
		FLUSH LIGHTING FIXTURE
	+0	LIGHTING OUTLET - WALL MOUNTING
	+0-	FLOODLIGHT
		DUPLEX CONVENIENCE OUTLET, +12" UNLESS OTHERWISE NOTES
	 0	COMBINATION 1-ZW & 1-3W "TWISTLOCK" CONVENIENCE OUTLET, +12" UNLESS DIHERWISE NOTED
	-	ZZO Y. POWER OUTLET - POLARIZED, +12"UNLESS OTHERIVISE NOTED
	0	JUNCTION BOX
	0	MOTOB - AS NOTEO
	3	MANUAL, FLUSH MOUNTED, MOTOR STARTING SWITCH +4'-6" UNLESS OTHERWISE NOTED
	+7	THERMOSTAT, + 5'-0"
		SURFACE MOUNTED CABINET OR EQUIPMENT AS NOTED
		FLUSH MOUNTED CABINET OR EQUIPMENT AS NOTED
		LIGHTING & I & POWER PANEL, FLUSH MOUNTED
	10	SECONDARY CLOCK, + 9'-0" UNLESS NOTED OTHERWISE
		CORRIDOR BELL
		YARD HORN
24 . 24 .	- Z	BREAK GLASS FIRE REPORTING STATION, + 4'.6"
	 @	VANITOR CALL BELL, 8" DIAMETER, WEATHER - PROOF
	\forall	PUBLIC ADDRESS SPEAKER OUTLET + 11-0" UNLESS NOTED OTHERIVISE
	+	PUBLIC TELEPHONE OUTLET, + 12"
•	s	70GGLE SIVITCH . + 4'.6"
	50	TOGGLE SWITCH & PILOT LIGHT, +41-6"
	SK	KEY OPERATED TOGGLE SHITCH, +4'-6"
		CONDUIT BUN - CONCEALED IN WALL OR CEILING
:		CONDUIT BUN - UNDERGROUND OR IN FLOOR SLAB
		CONDUIT BUN - EXPOSED
	¢	CLOCK SYSTEM CONDULT BUN
	——A——	PUBLIC ADDRESS SYSTEM CONDUIT BUN
	T	PUBLIC TELEPHONE SYSTEM CONDUIT BUN


	APPROVED	SHATE OF CALIFORNIA - Date - DE PUBLIC WORKS	CONTRACTOR TO VERIFY ALL DIMENSIONS AT THE JOB
APPROVED	BY	3-8-20	ELECTRICAL PLOT PLAN DEC 194
OFFICE of the SUPERINTENDENT of SCHOOLS SAN DIEGO COUNTY	BY	7694 Jany W Bulin	CAFETERIA BUILDING CHECKED BY
JOHN S. CARROLL	BY	DI SUPERVISING STRUCTURAL ENGINEER	FOR
Superinterident of Sciencis	BY		GROSSMONT UNION HIGH SCHOOL DISTRICT
These linter planes present it in proceedings with a control with the cont	BY	& R. Cutin	KISTNER, CURTIS & WRIGHT
	MEMBERS OF GOVERNING BOARD GROSSMONT UNION HIGH SCHOOL DIST.	ARCHITECT STRUCTURAL ENGINEER	ARCHITECTS AND ENGINEERS LOS ANGELES, CALIF. SAN DIEGO, CALIF. 201.5-7

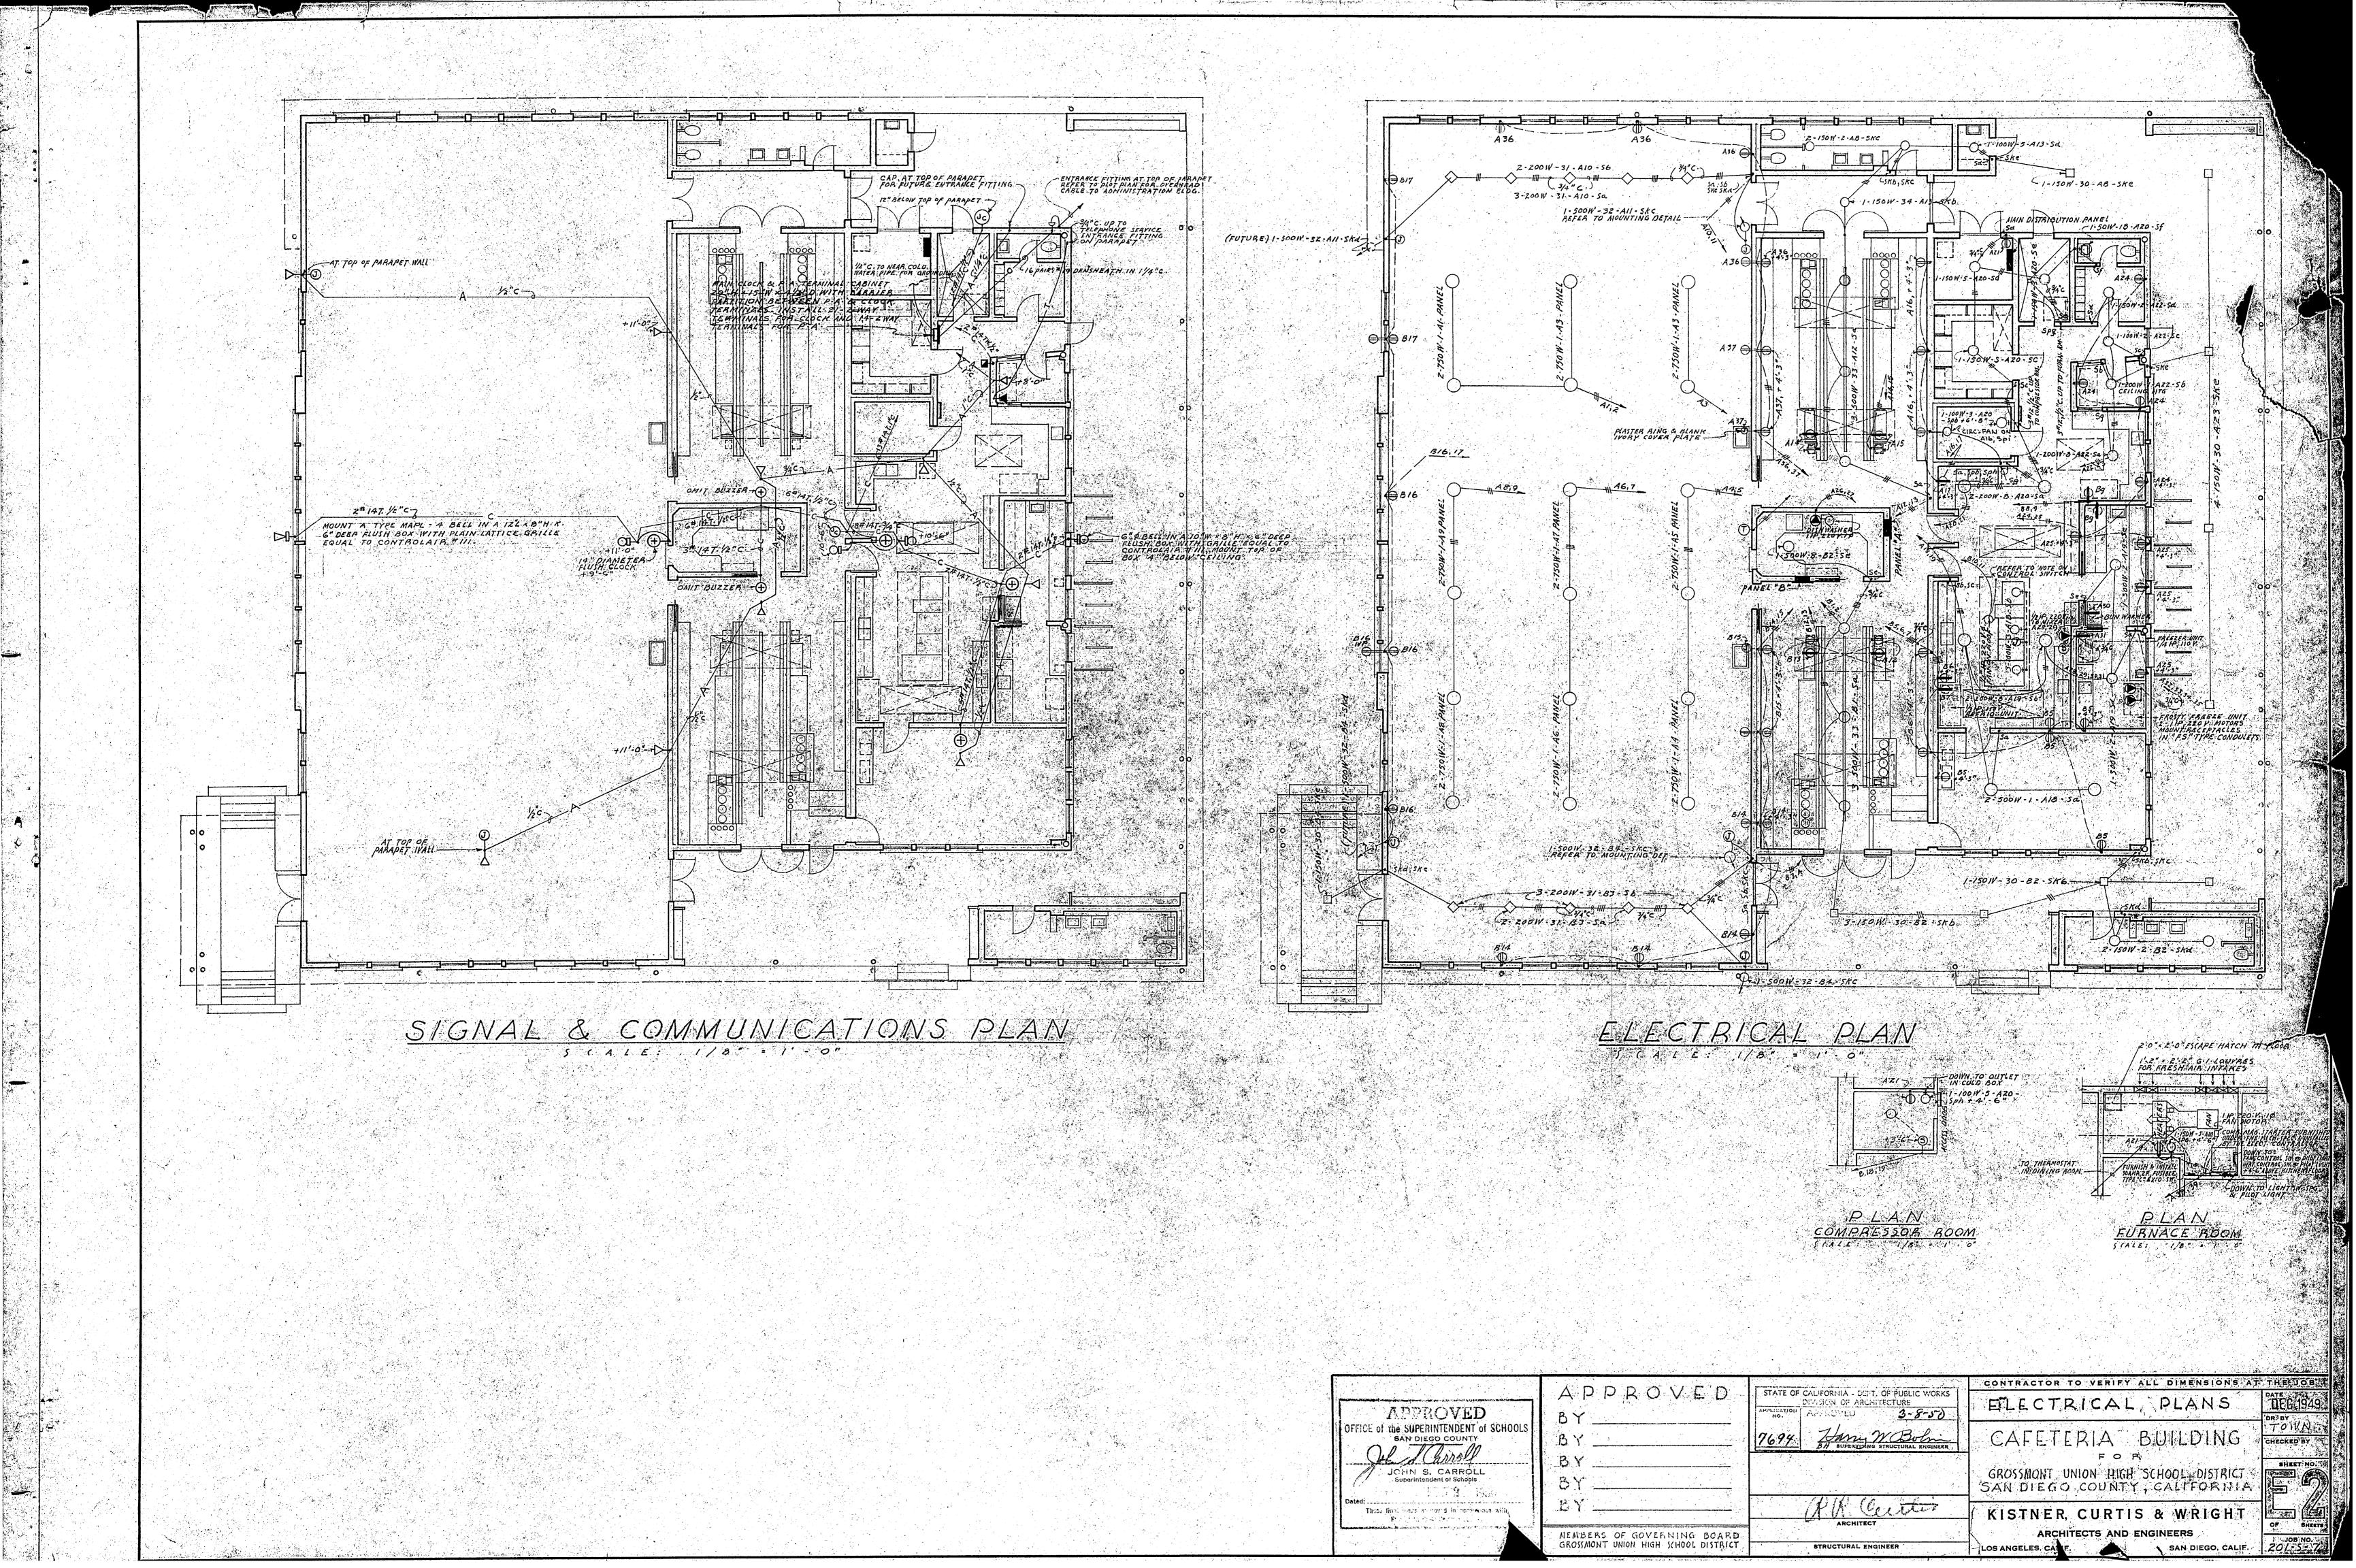



INTENTIONALLY LEFT BLANK

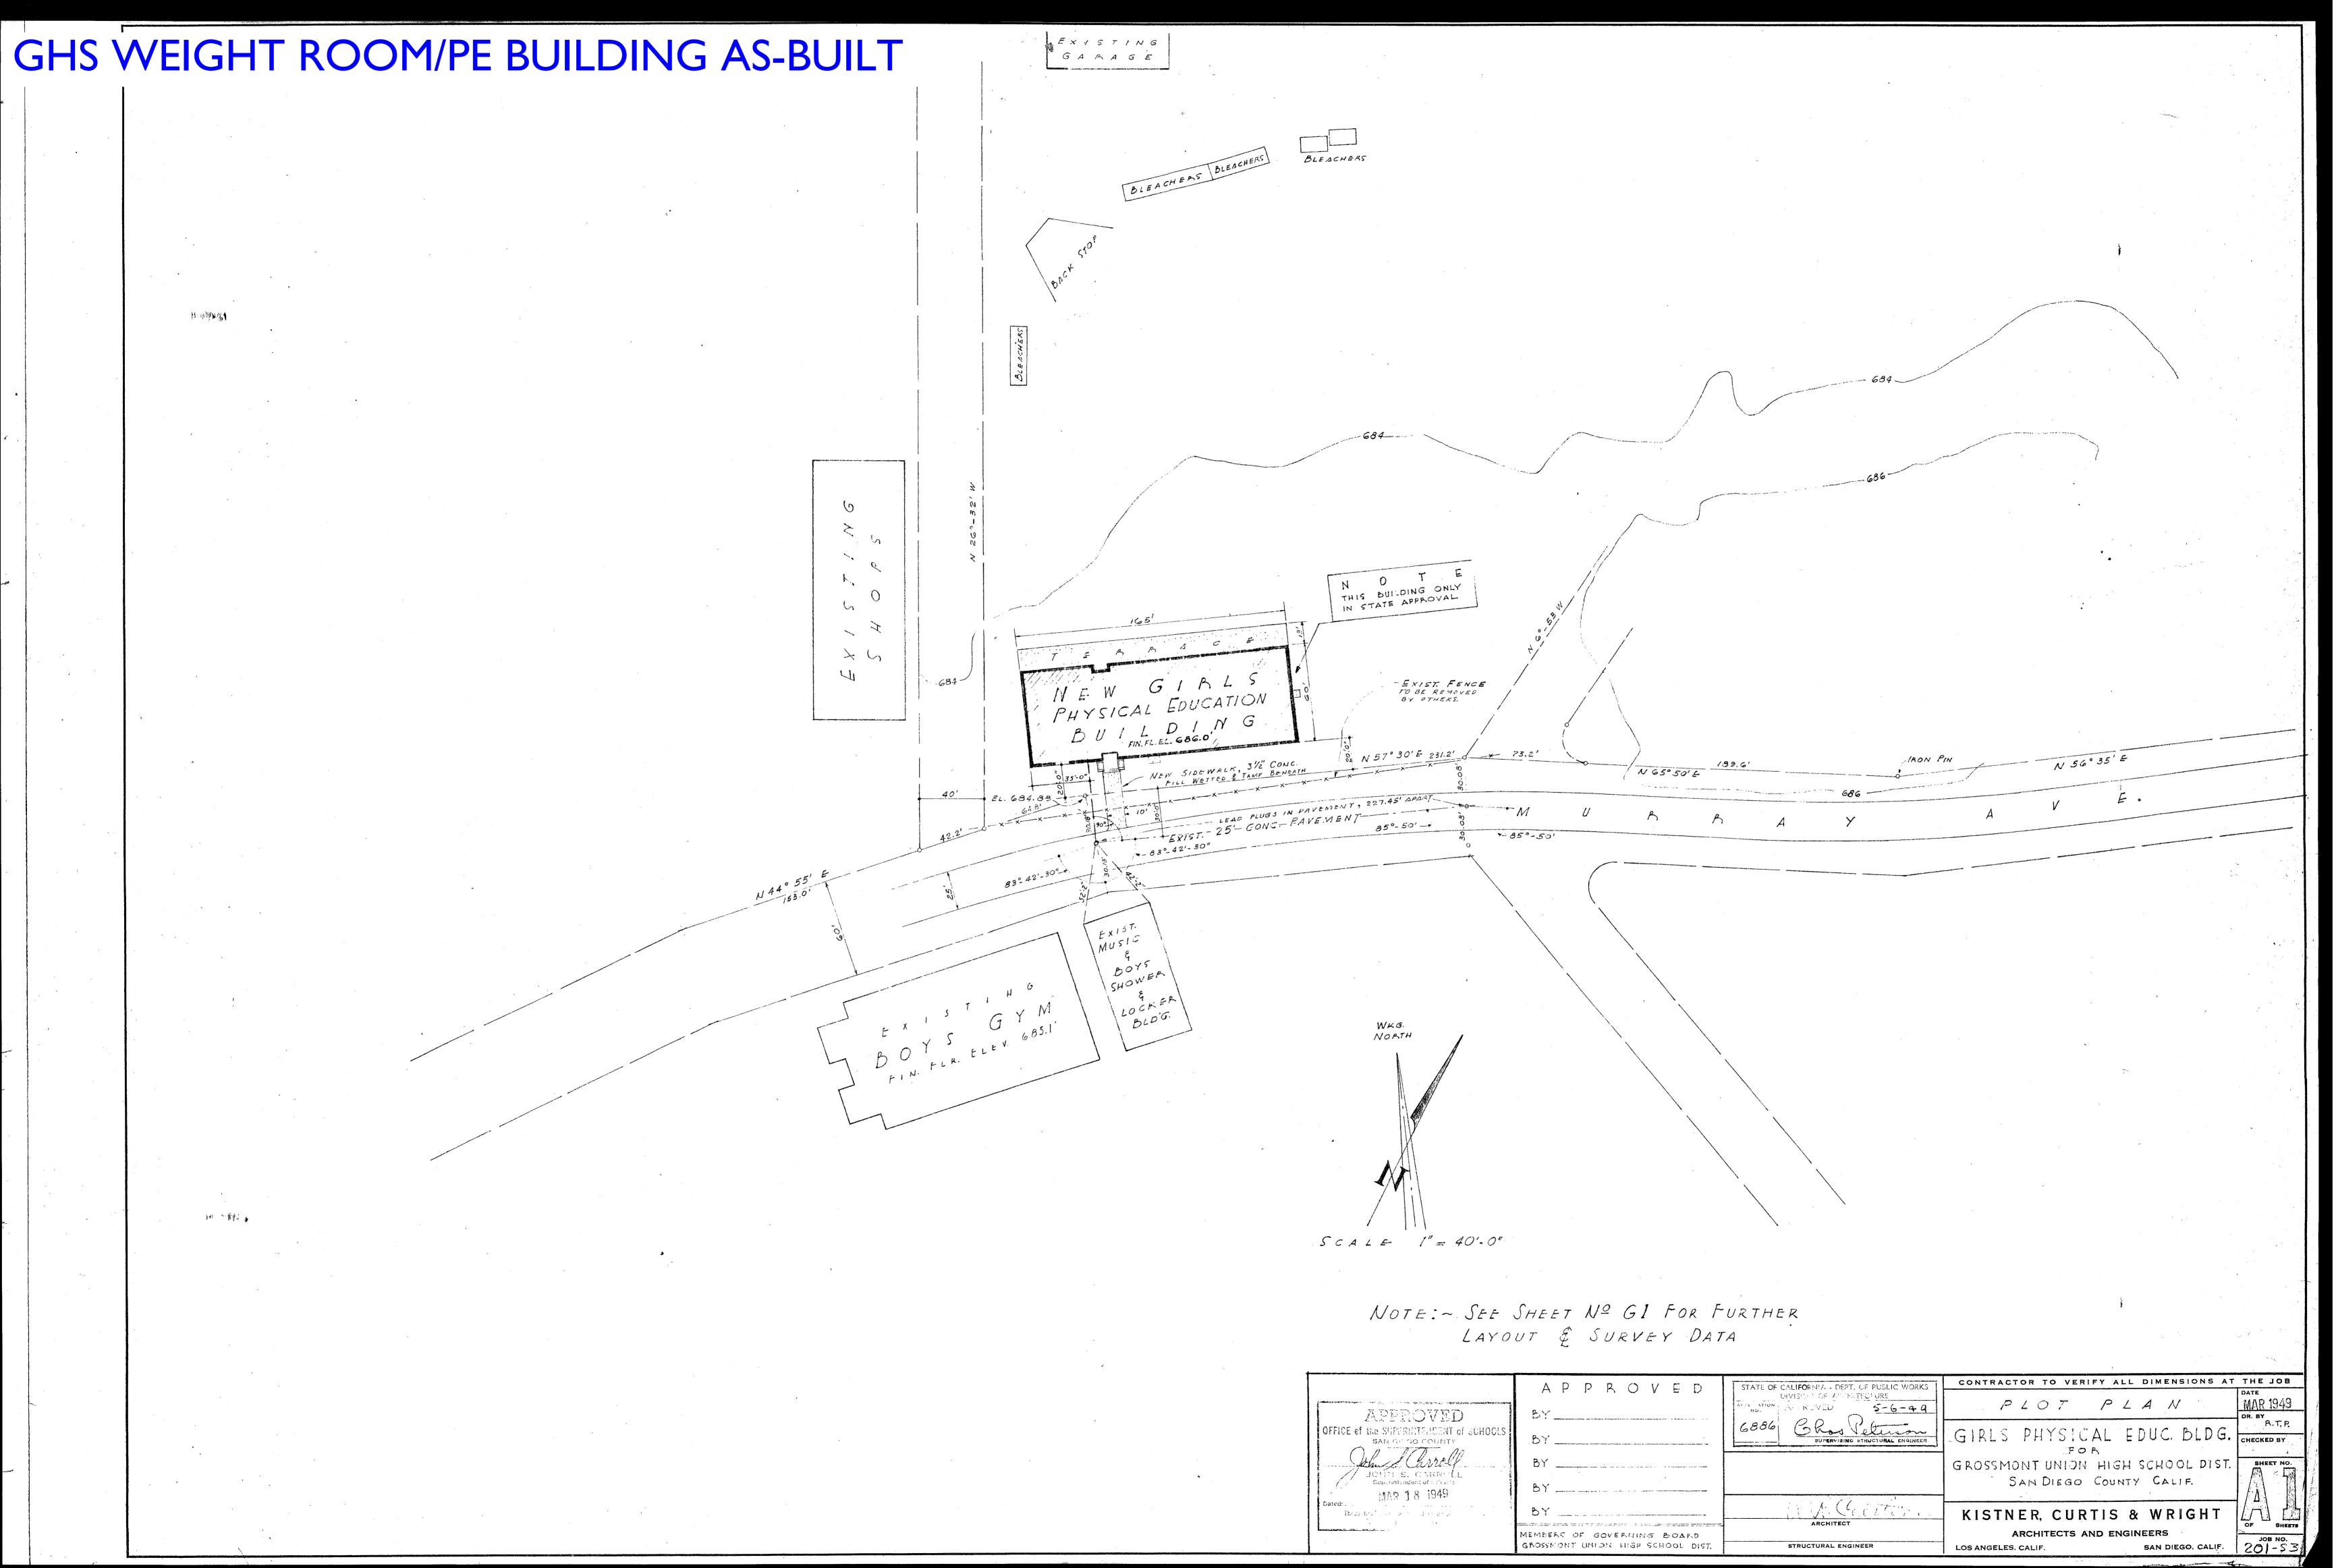


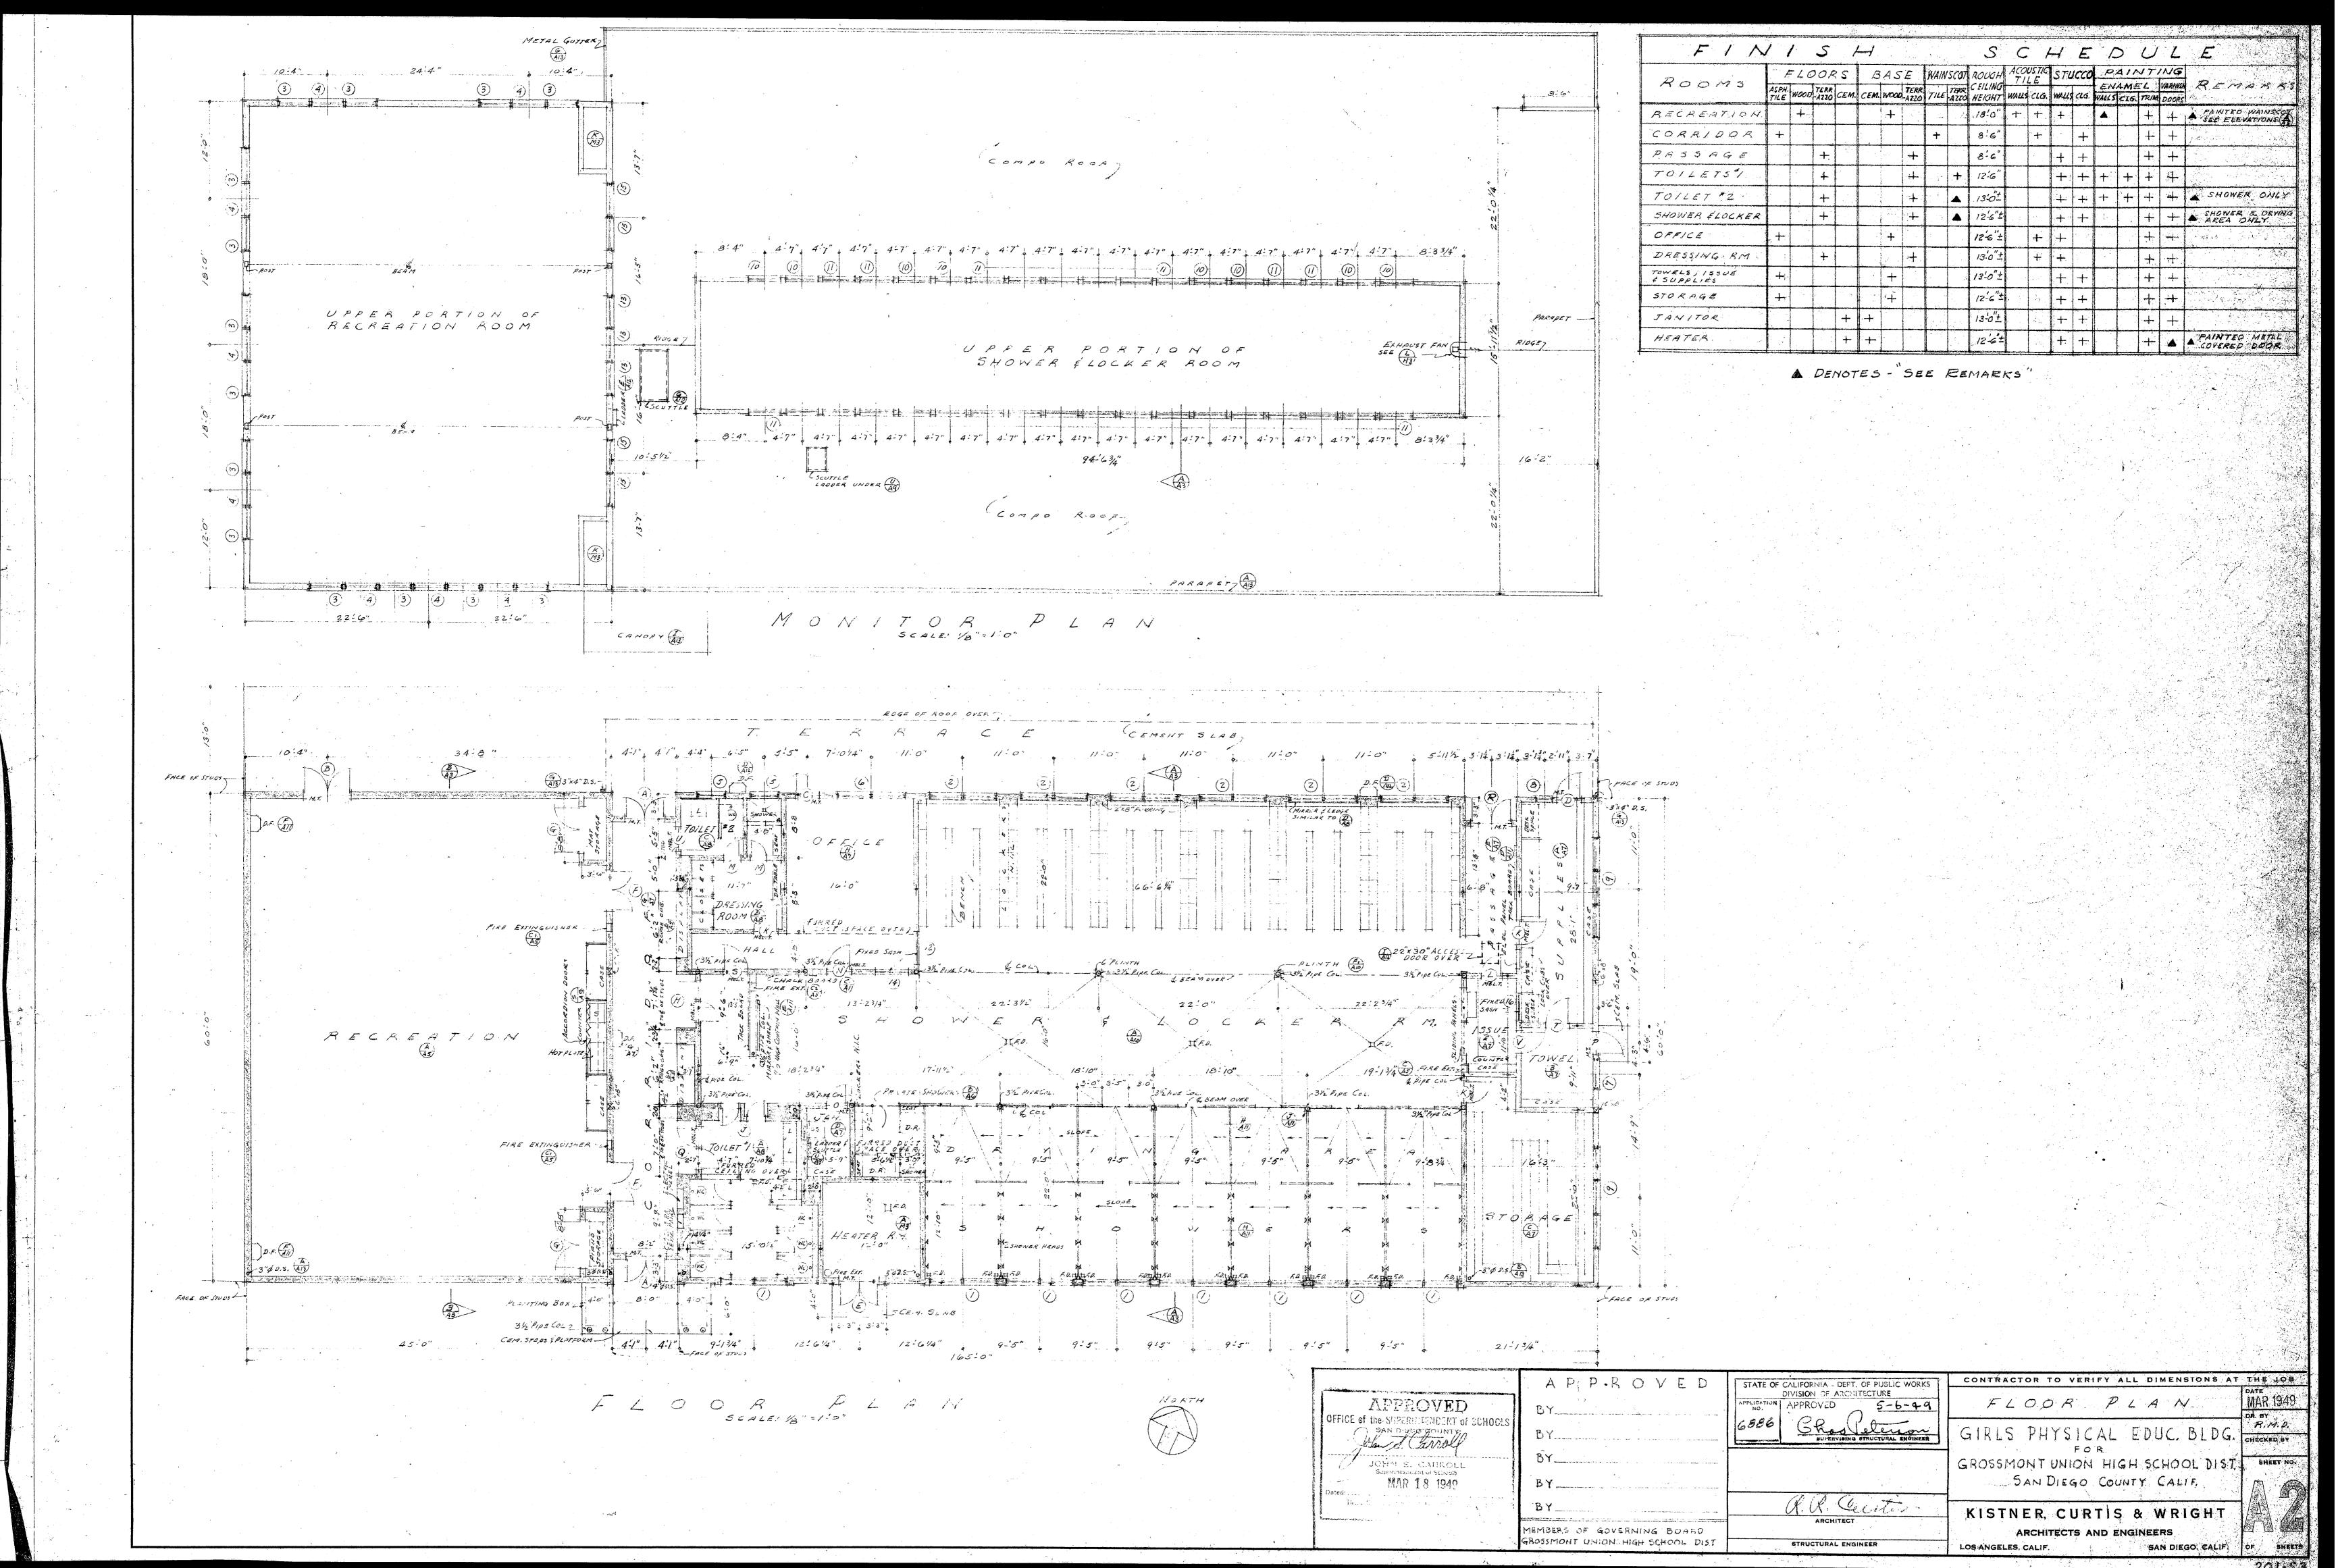


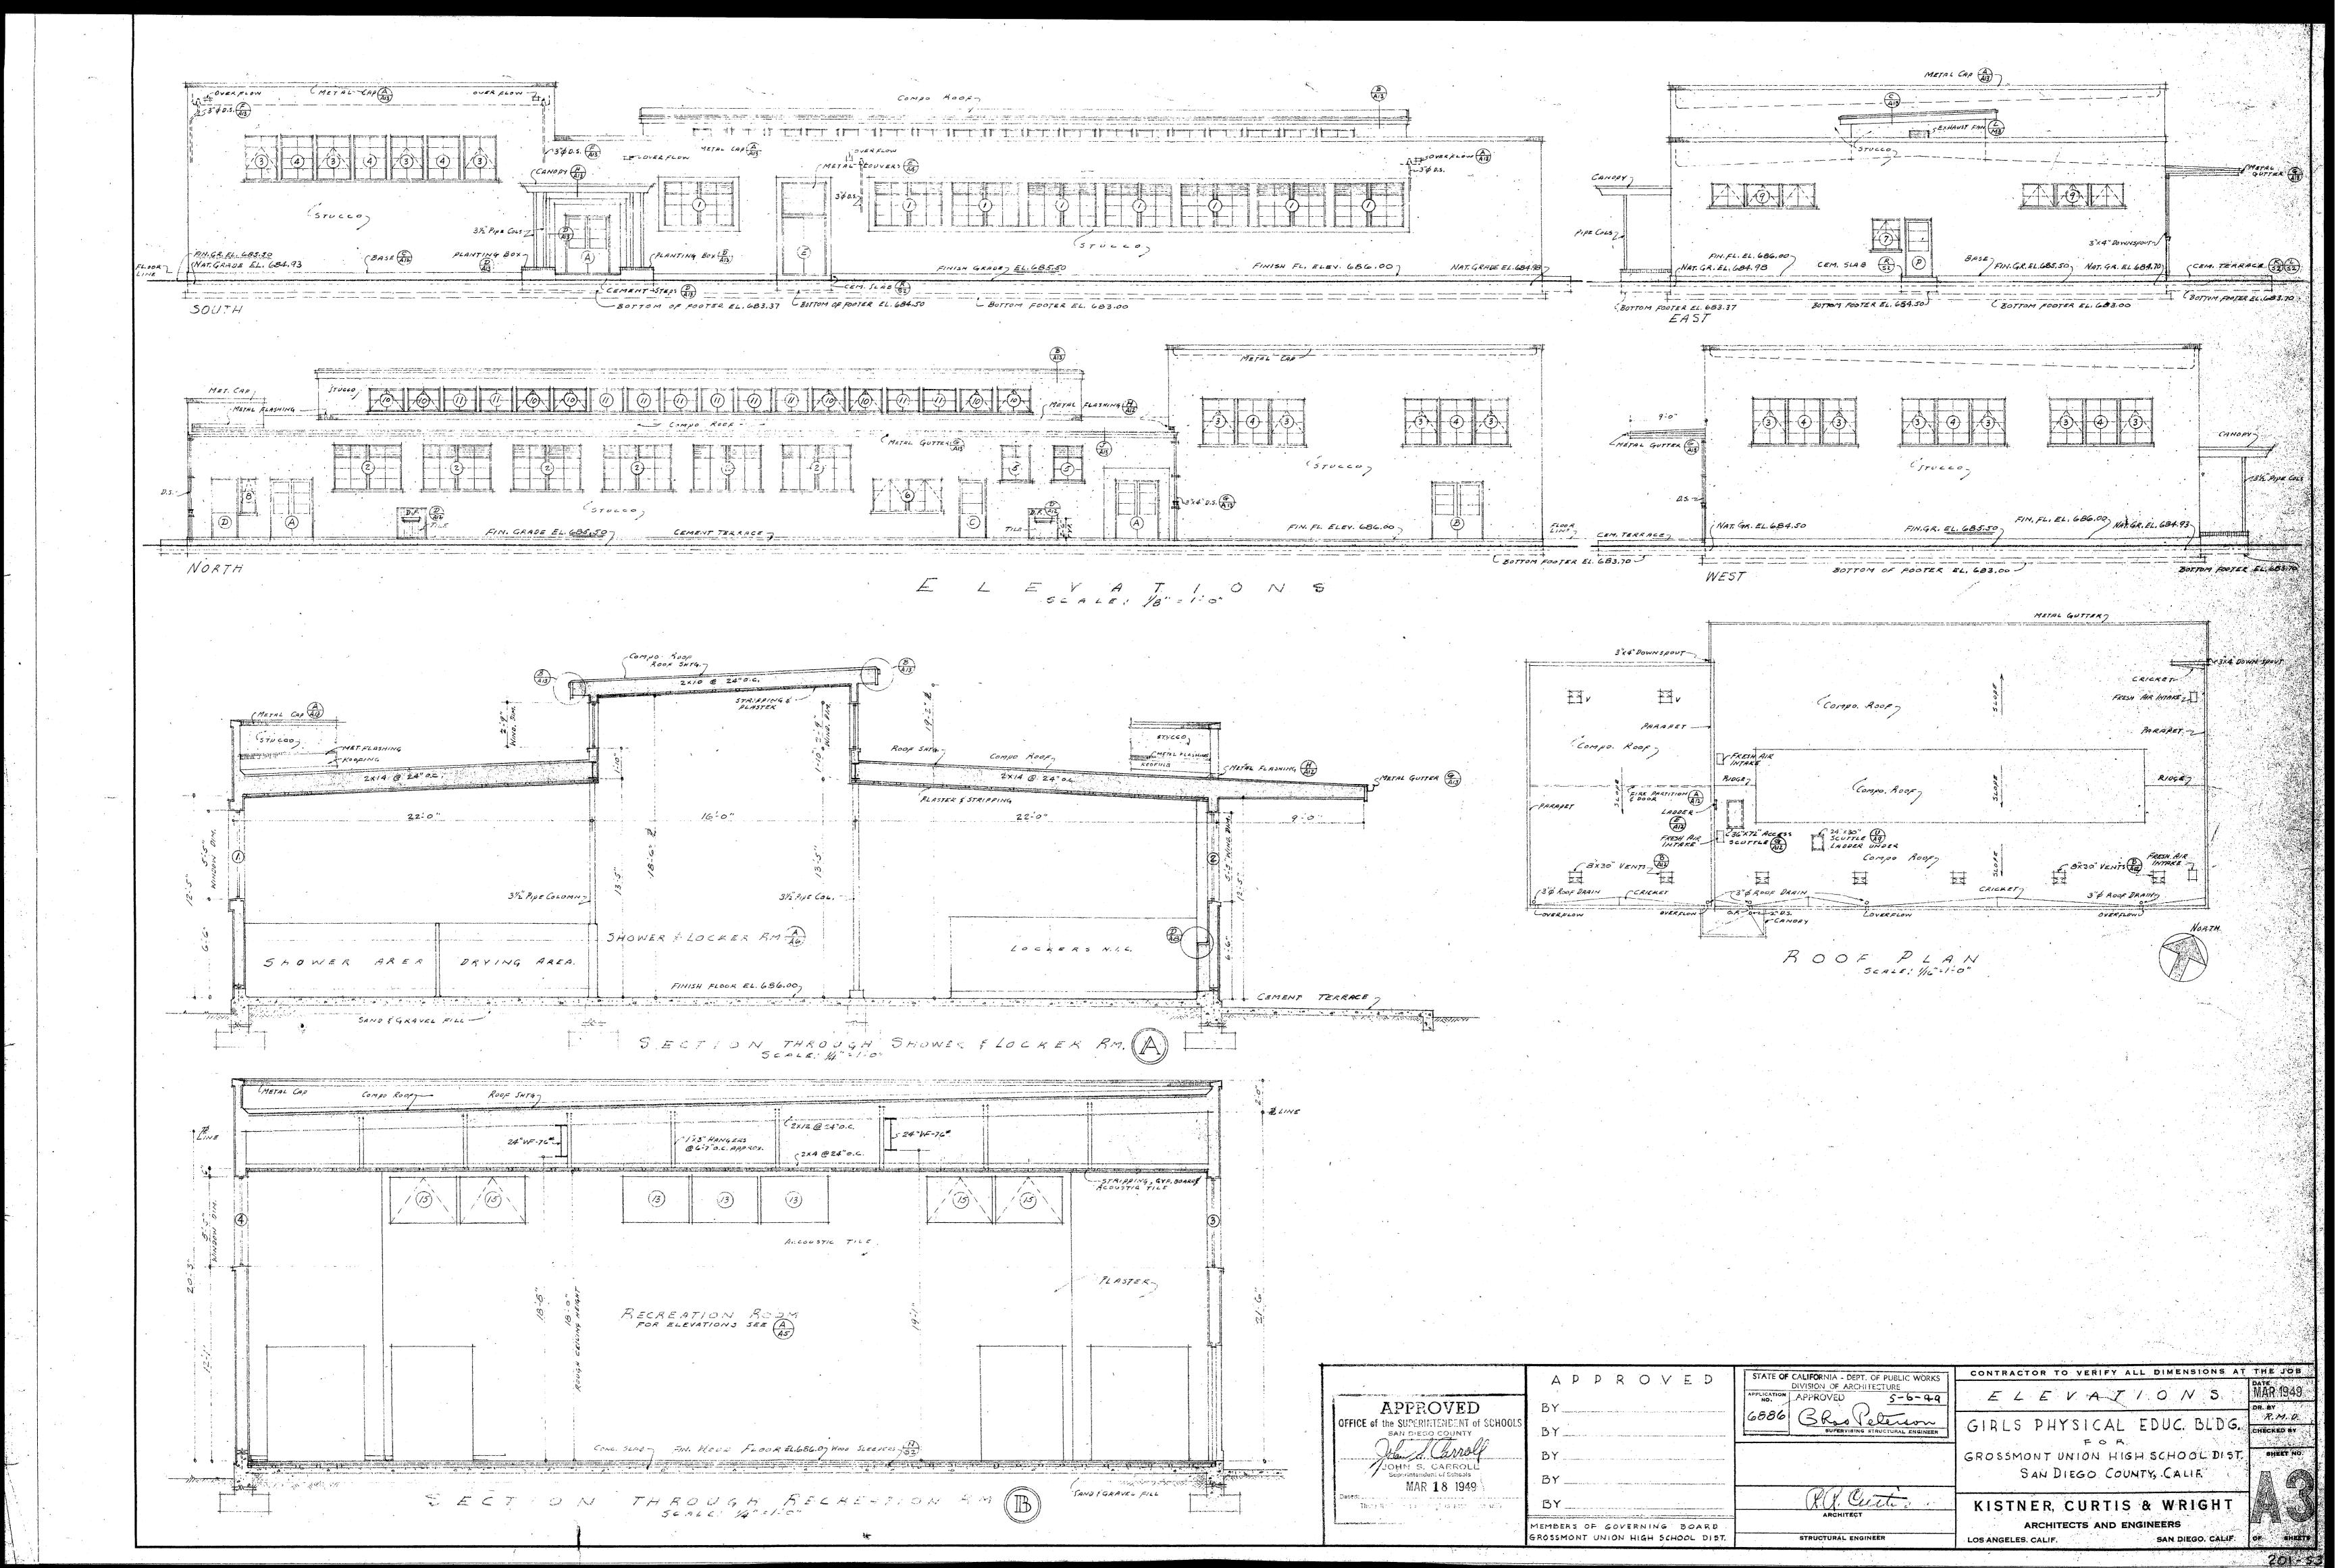


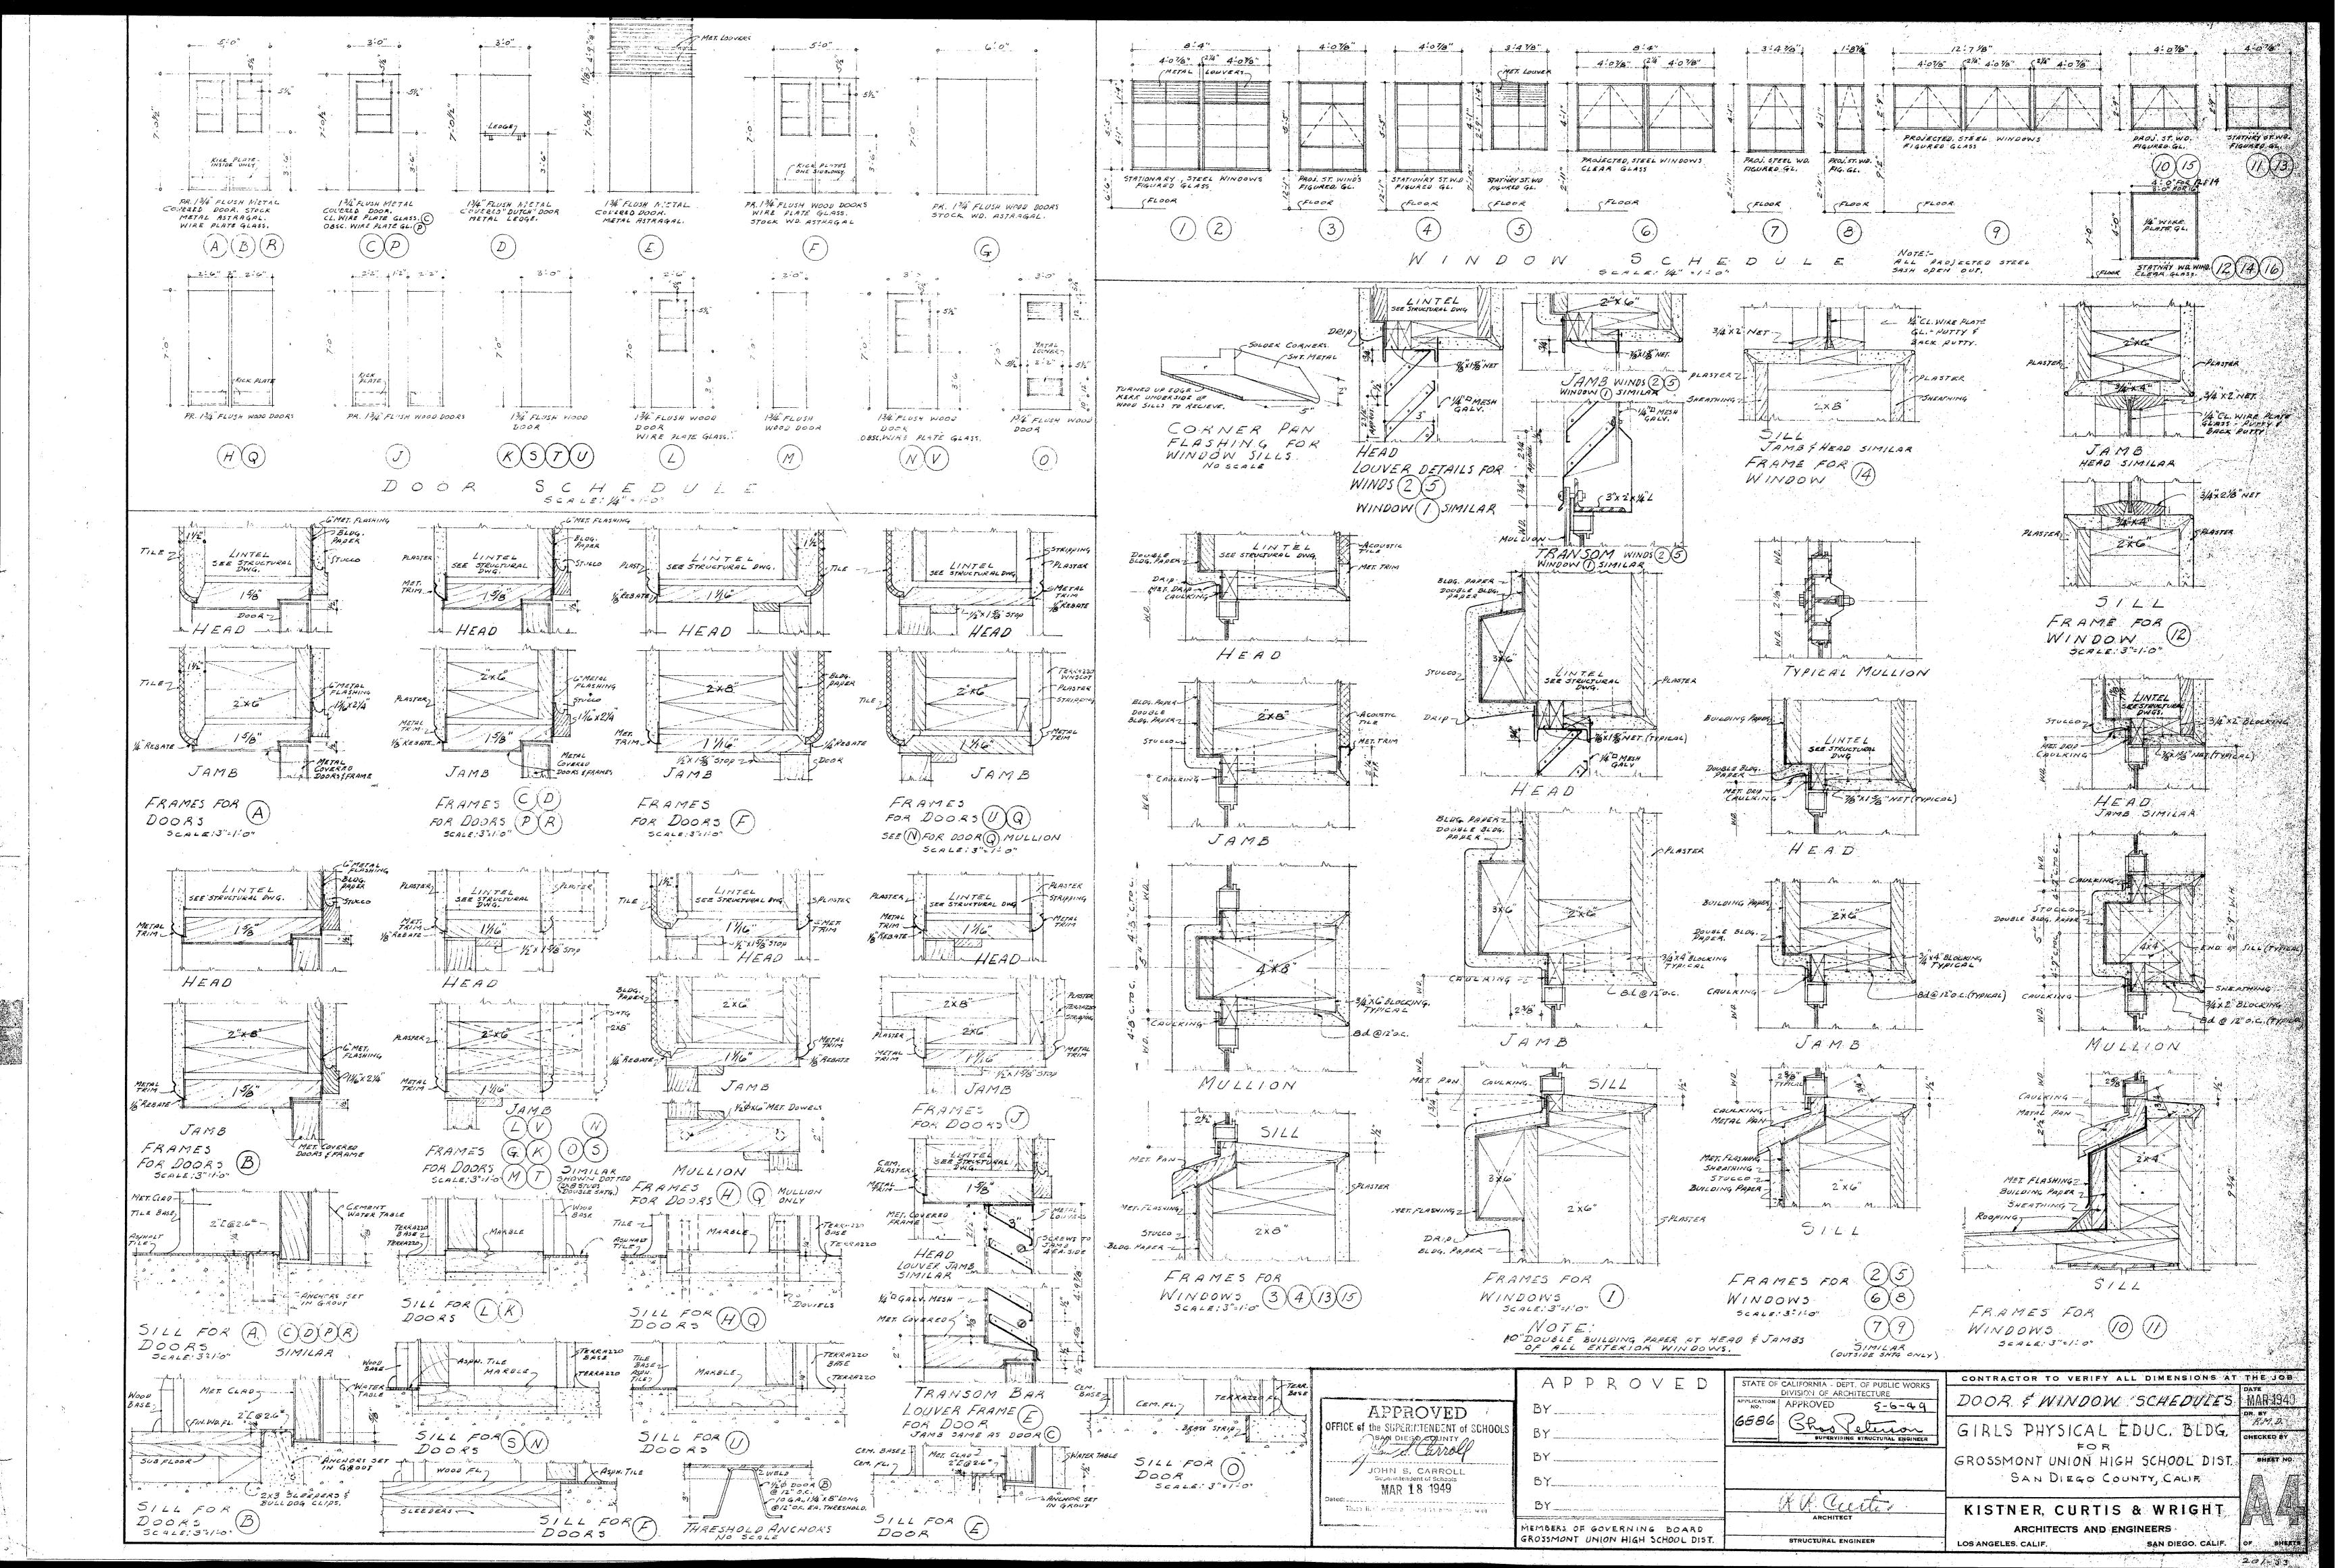


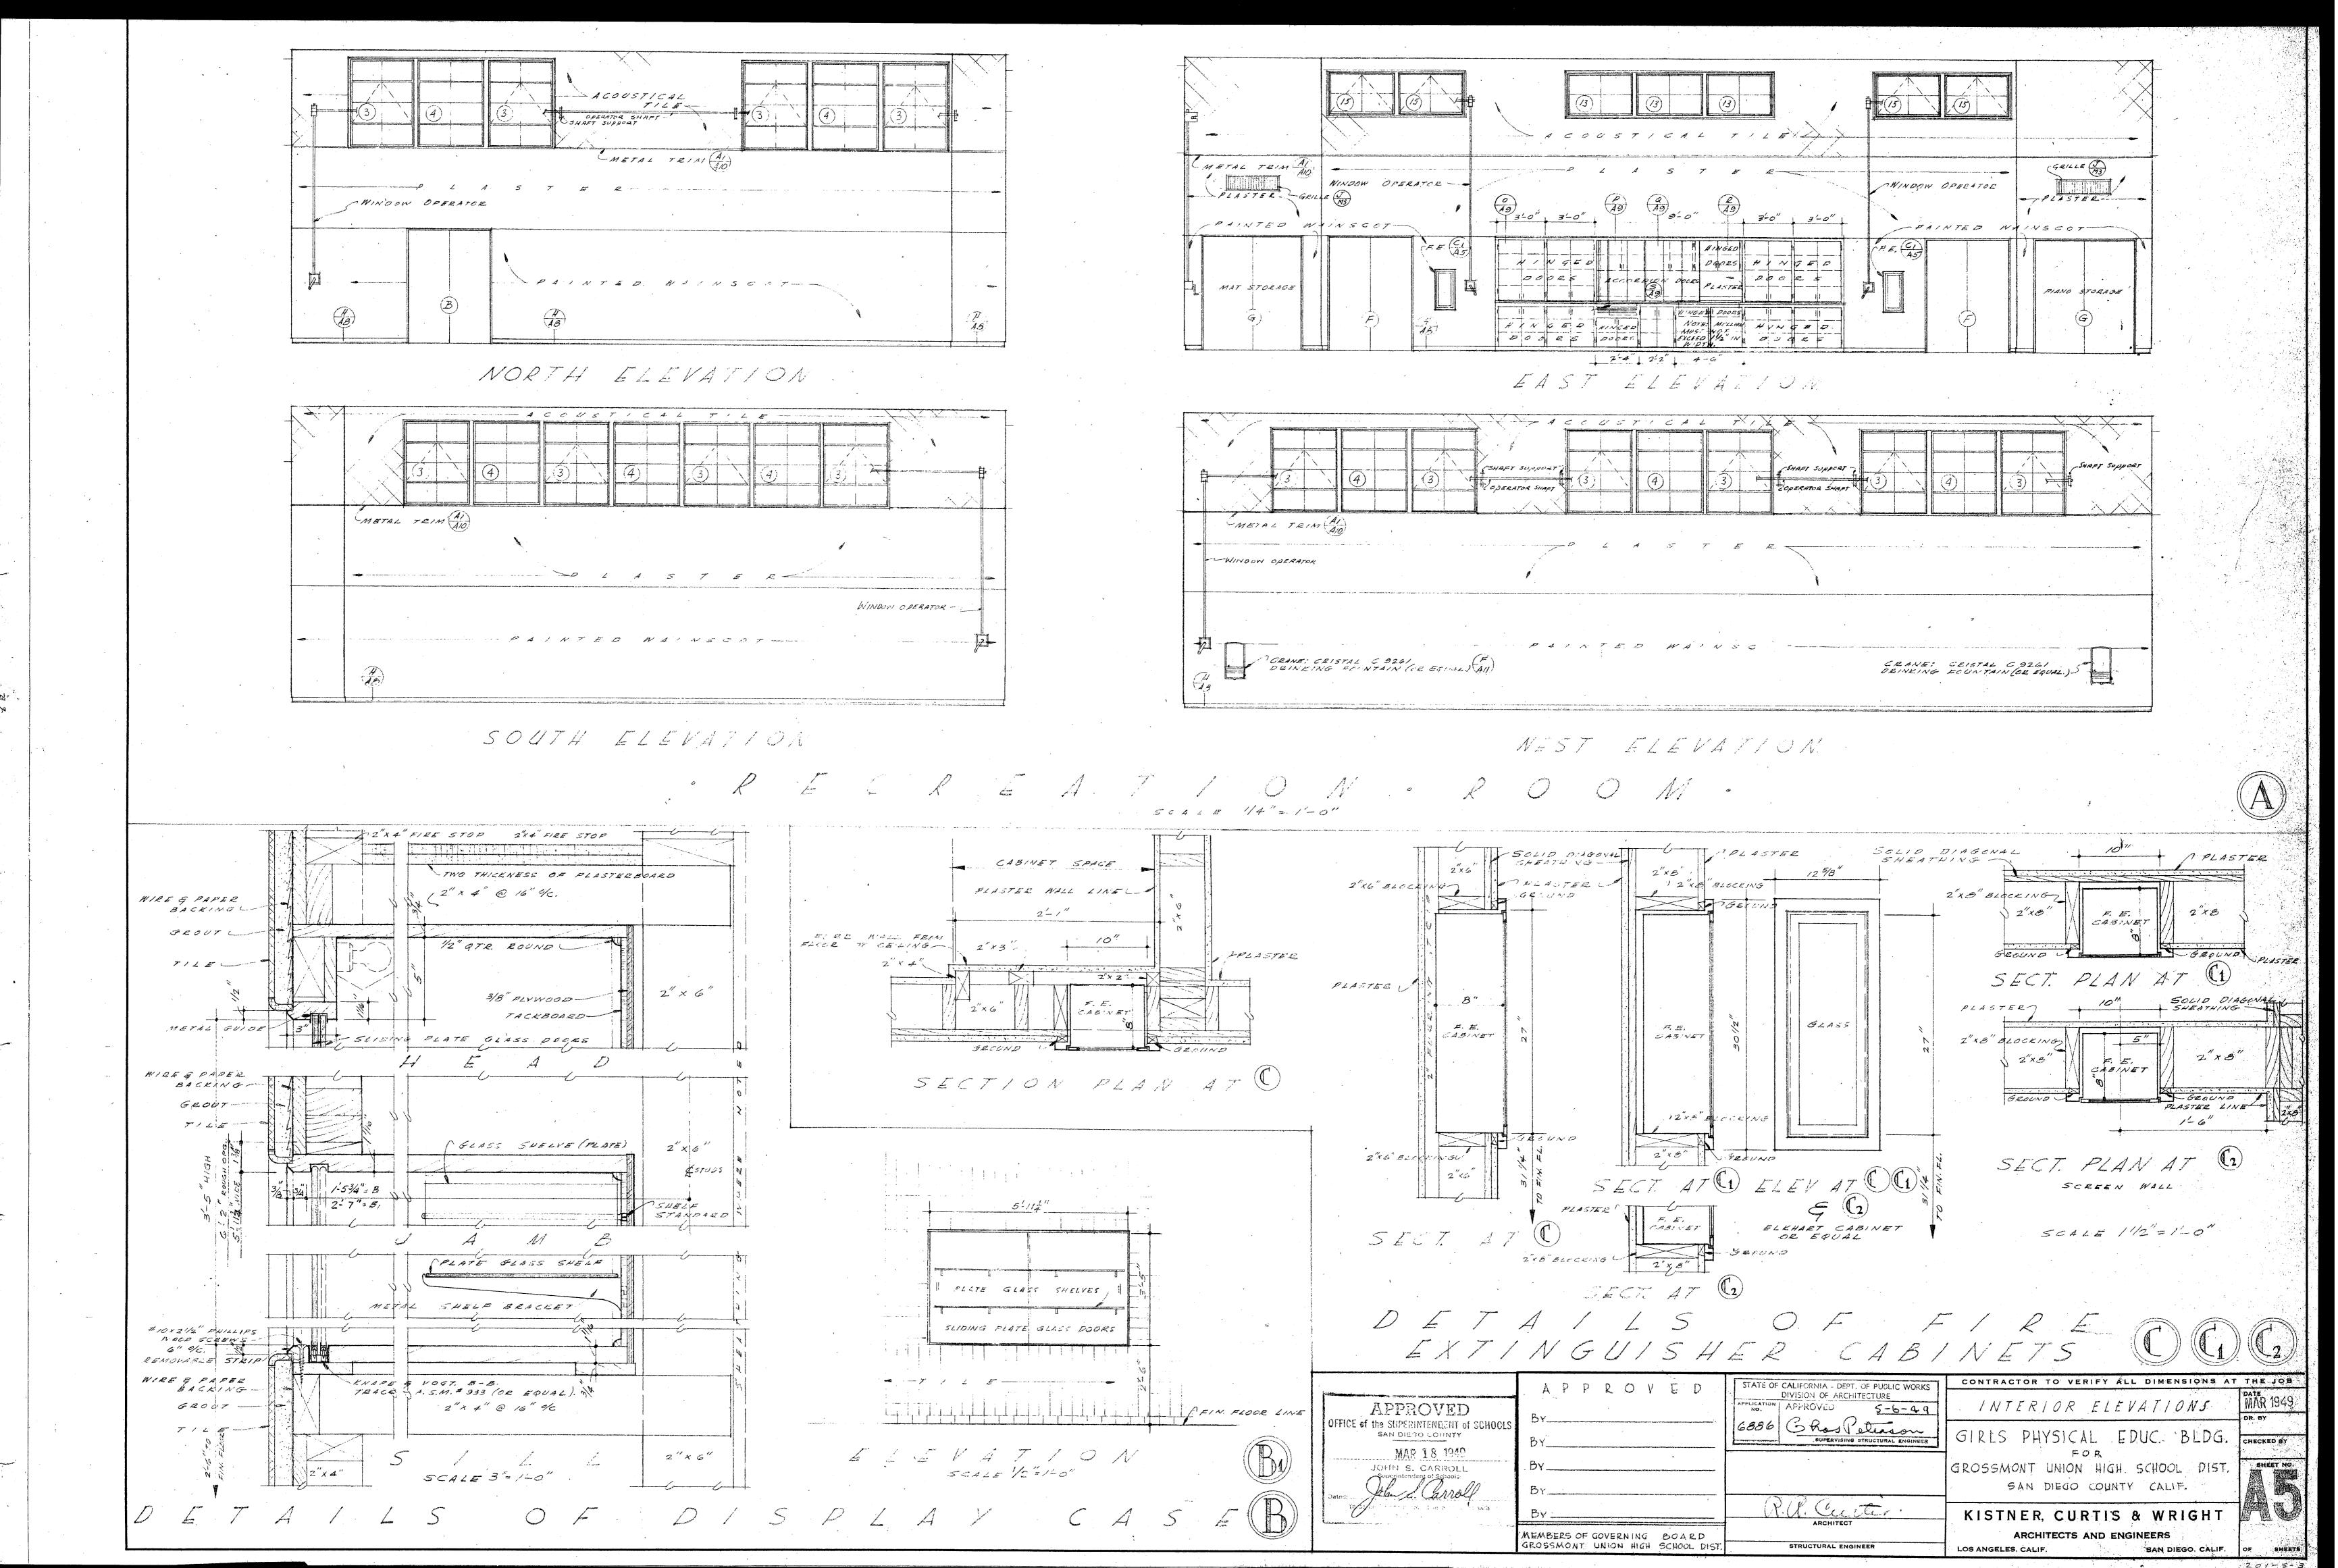


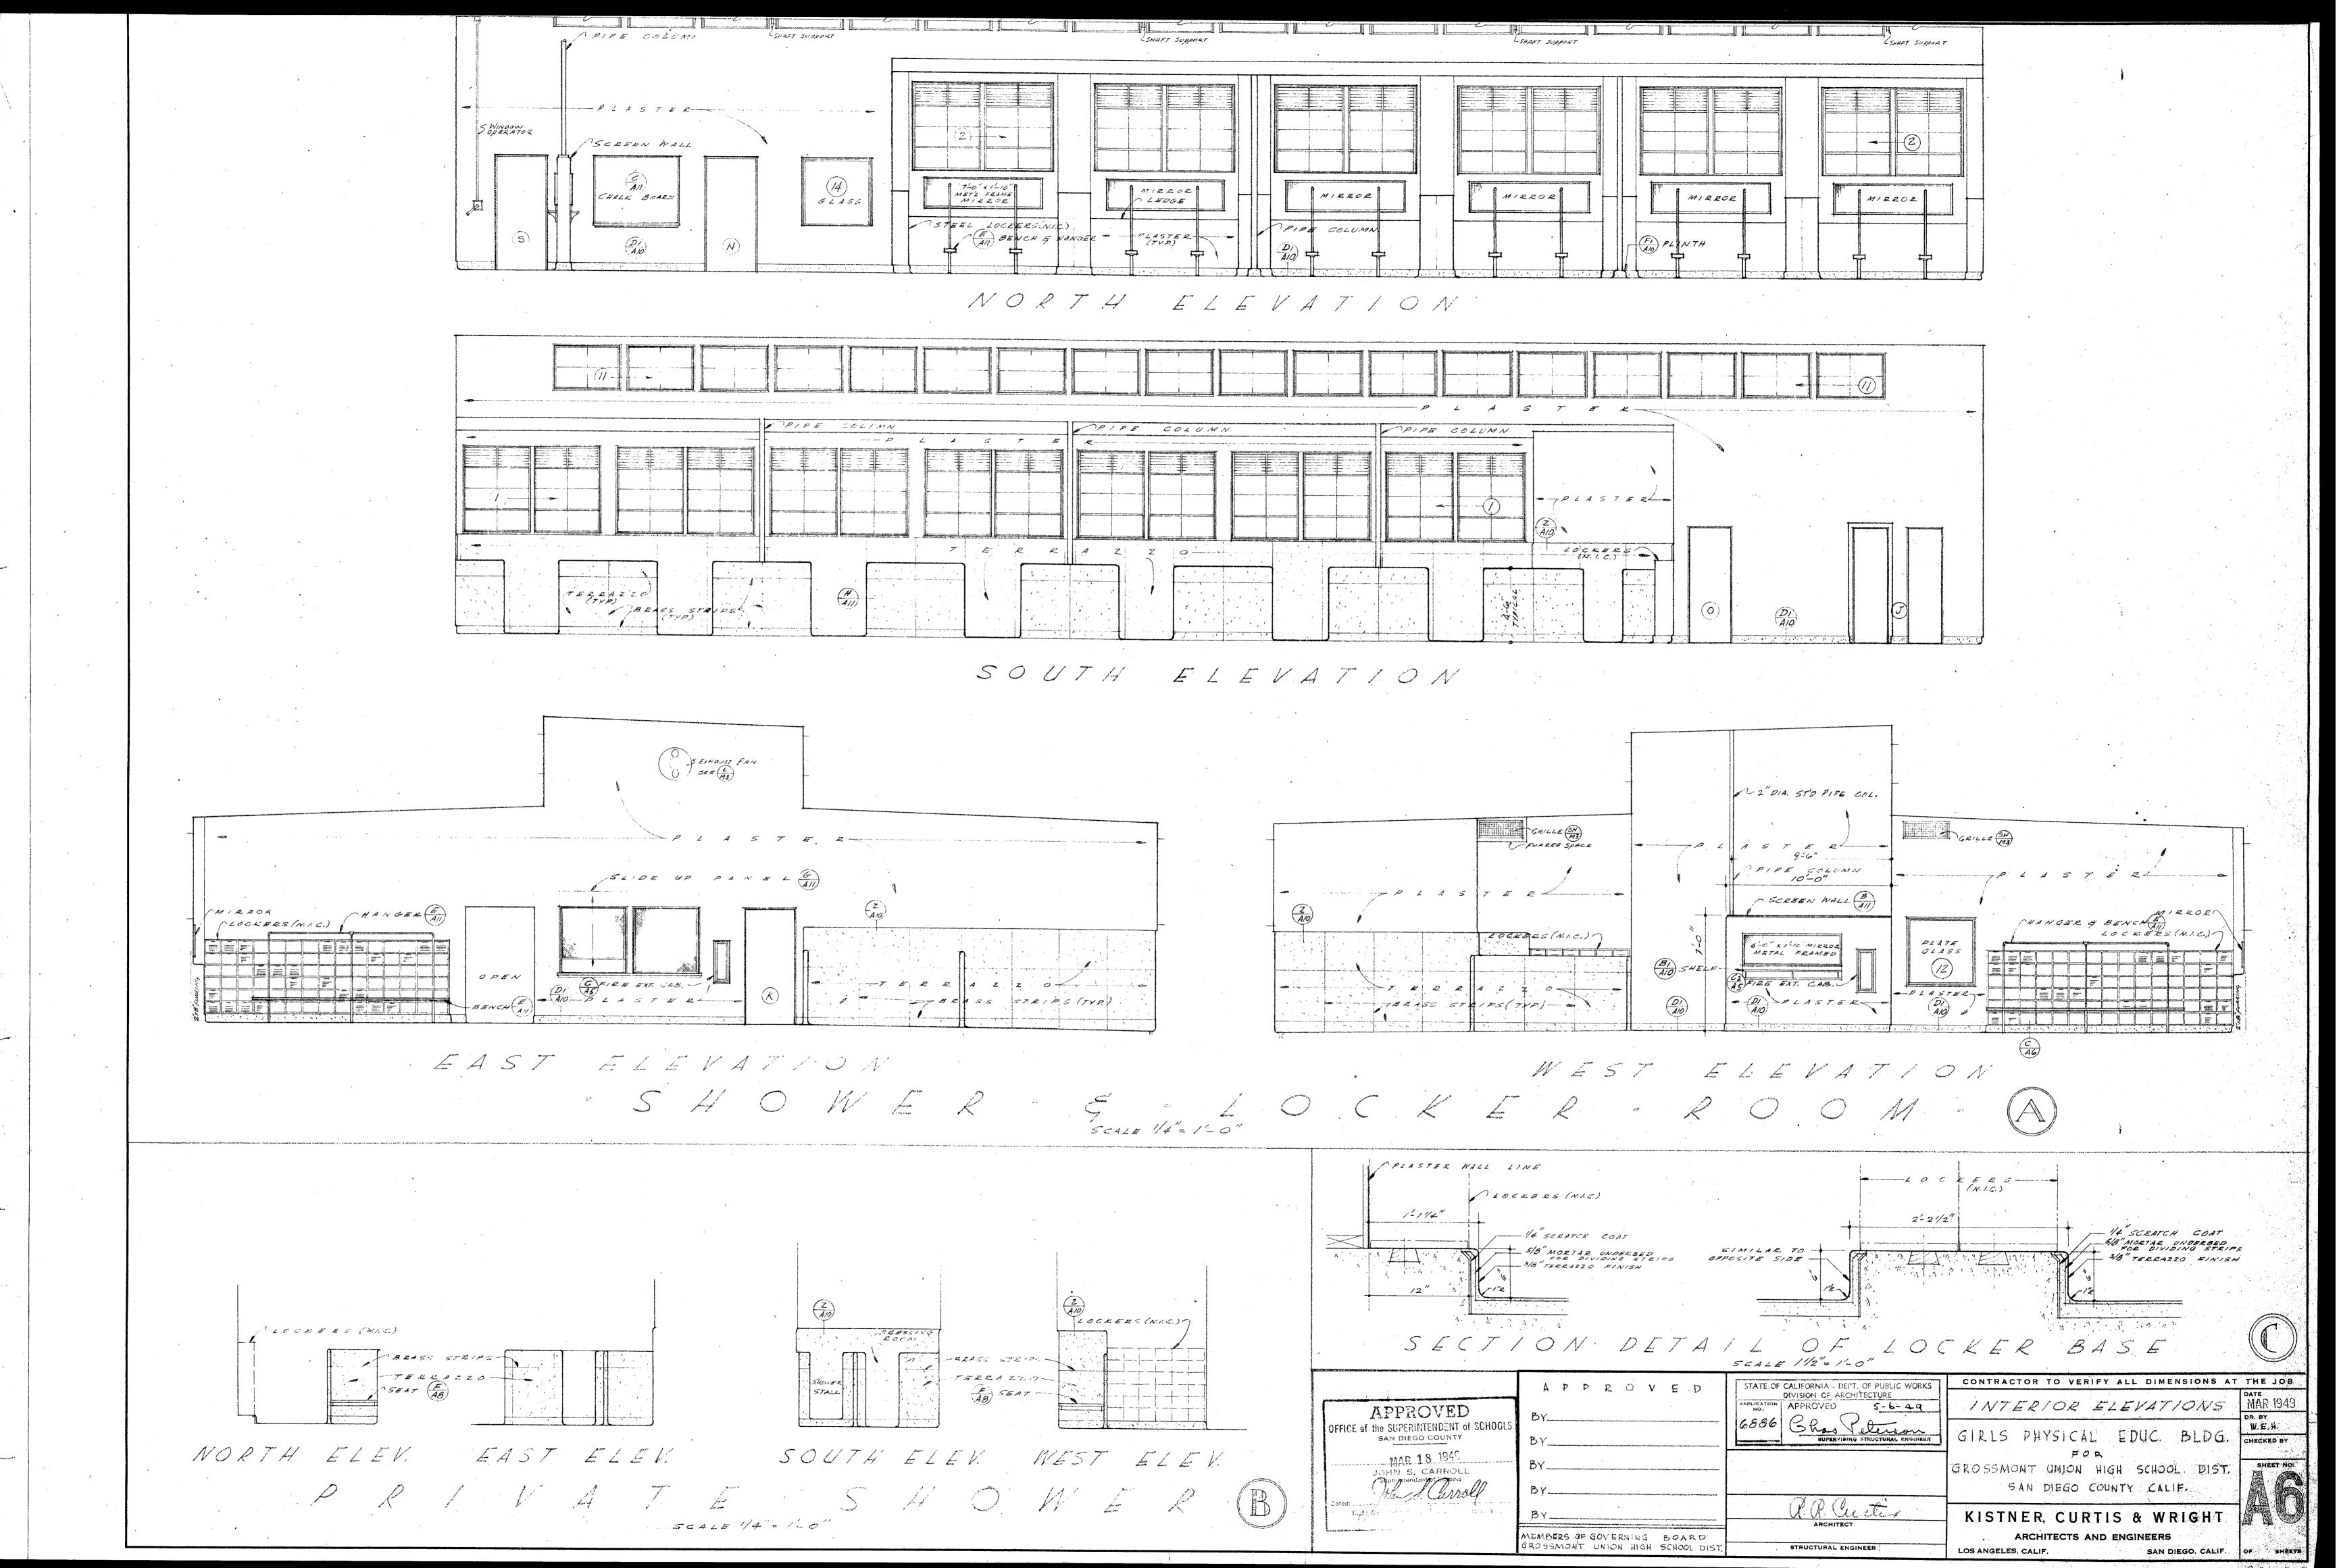


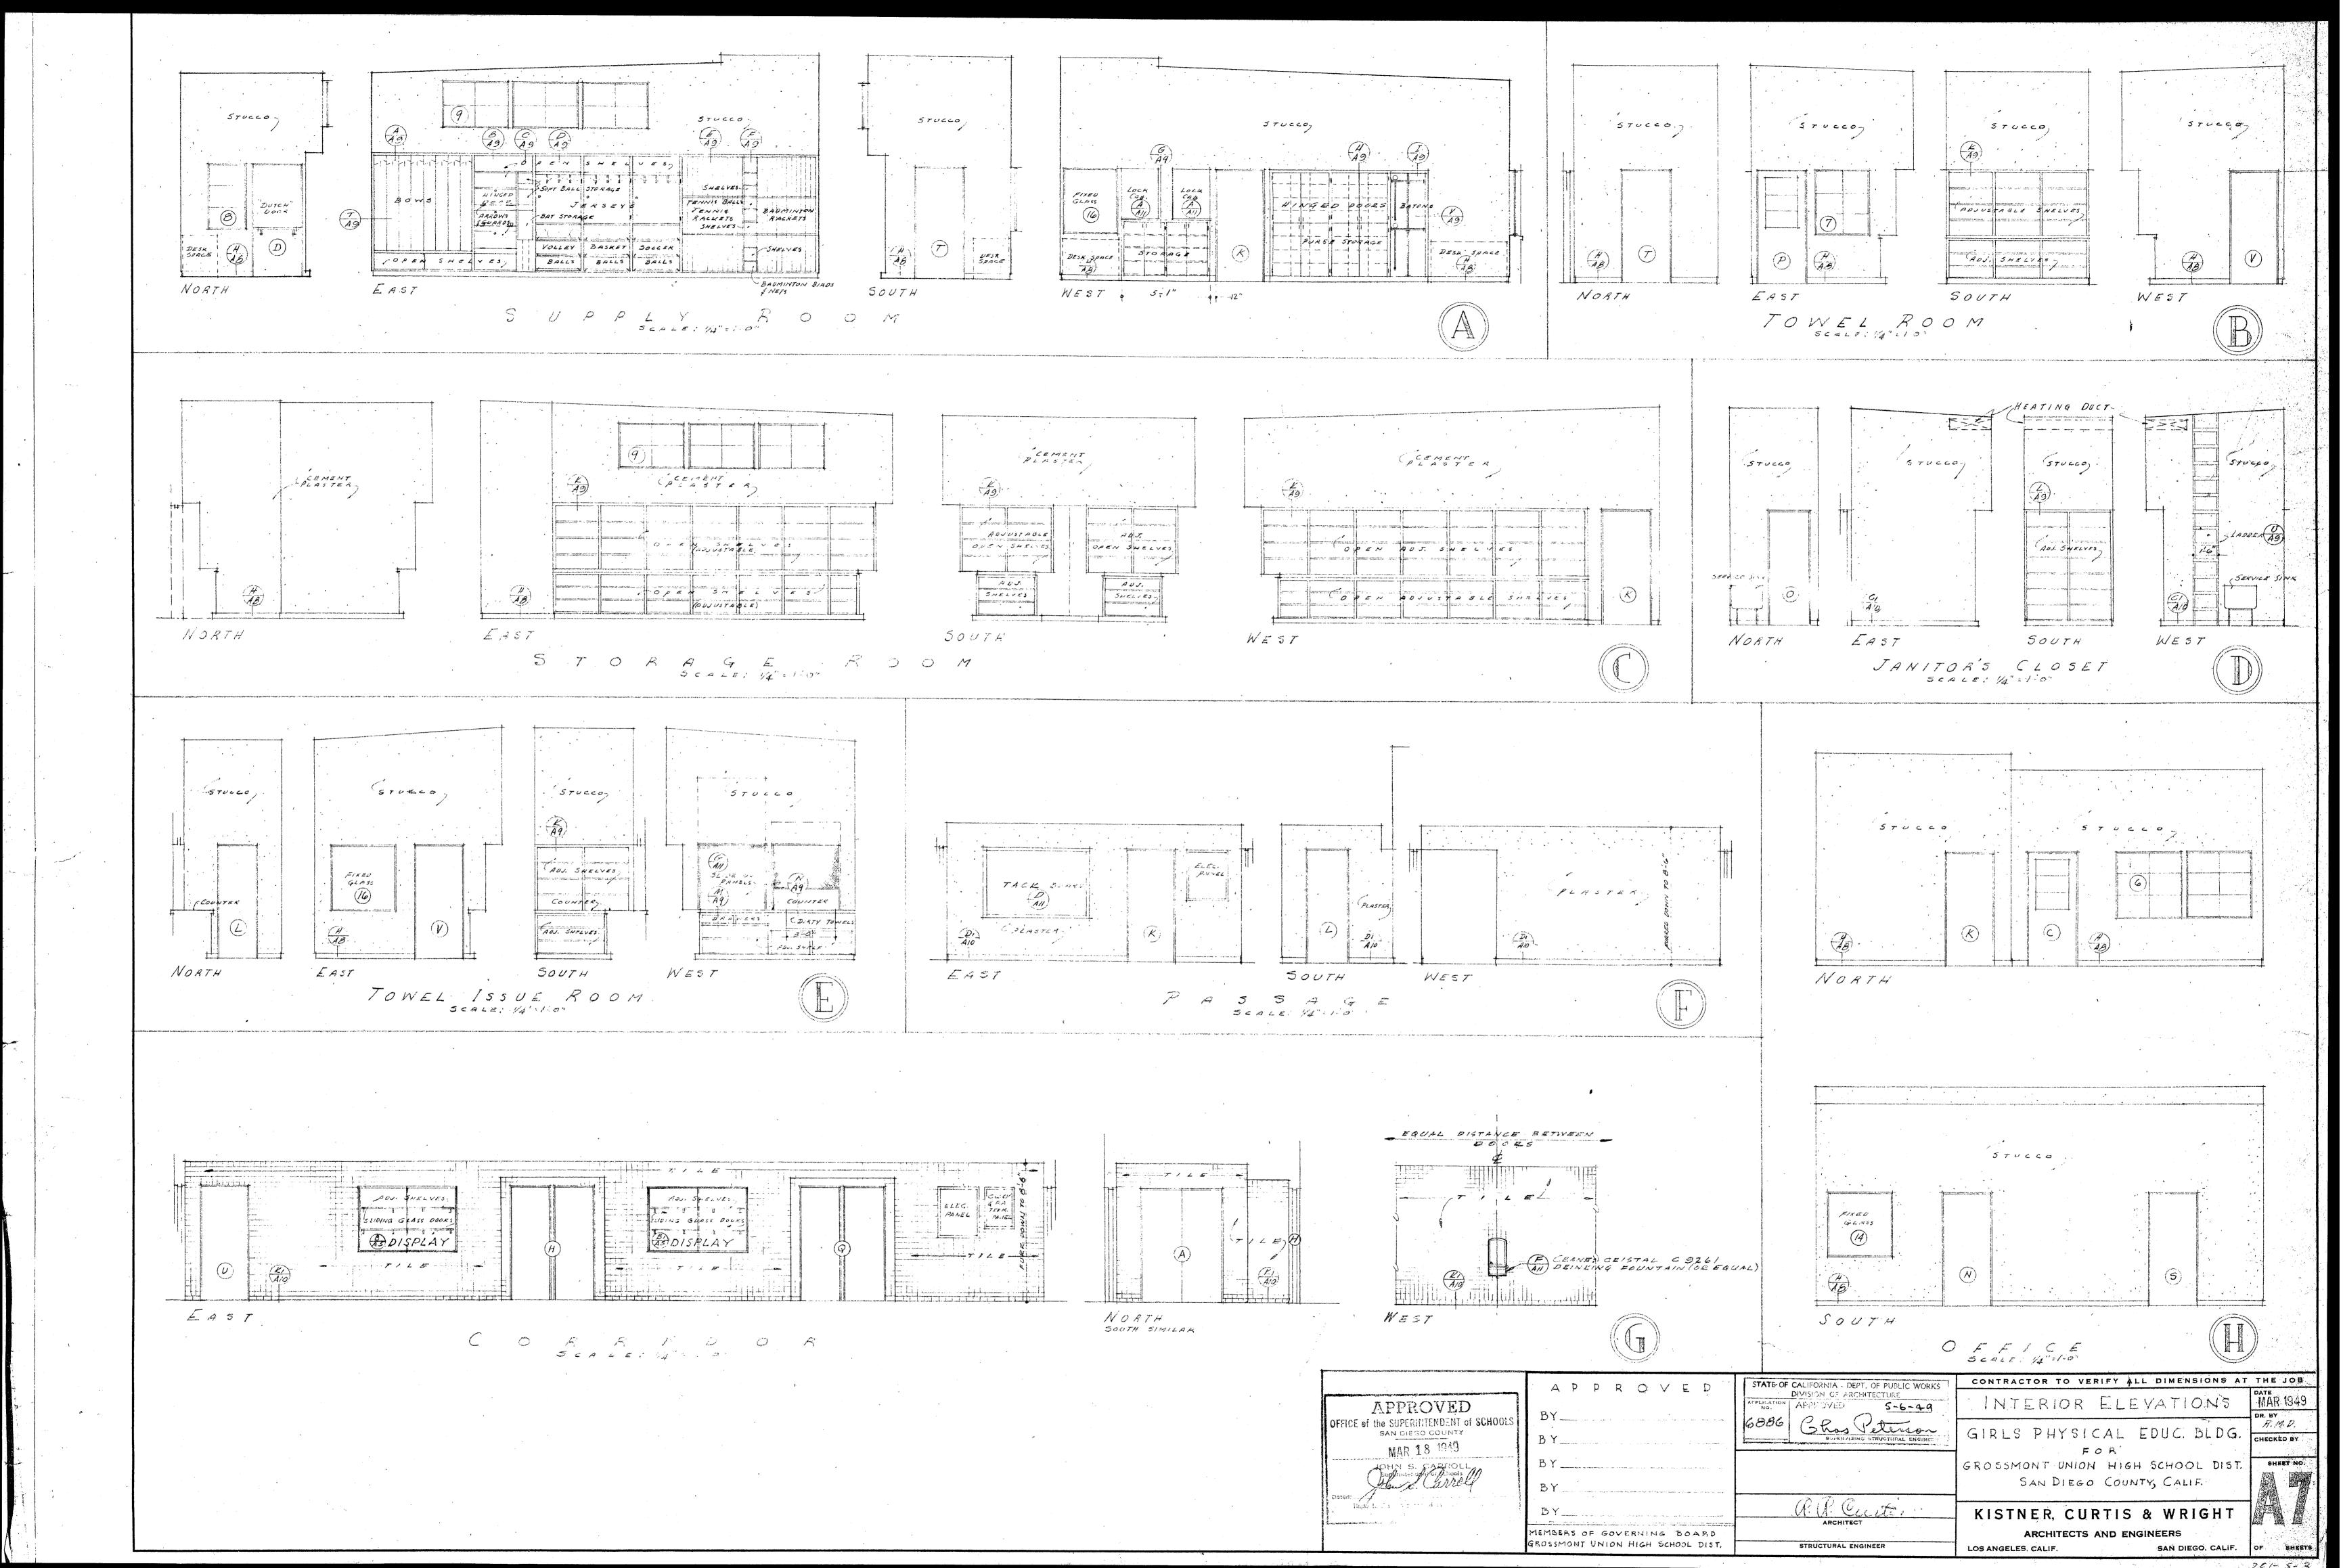


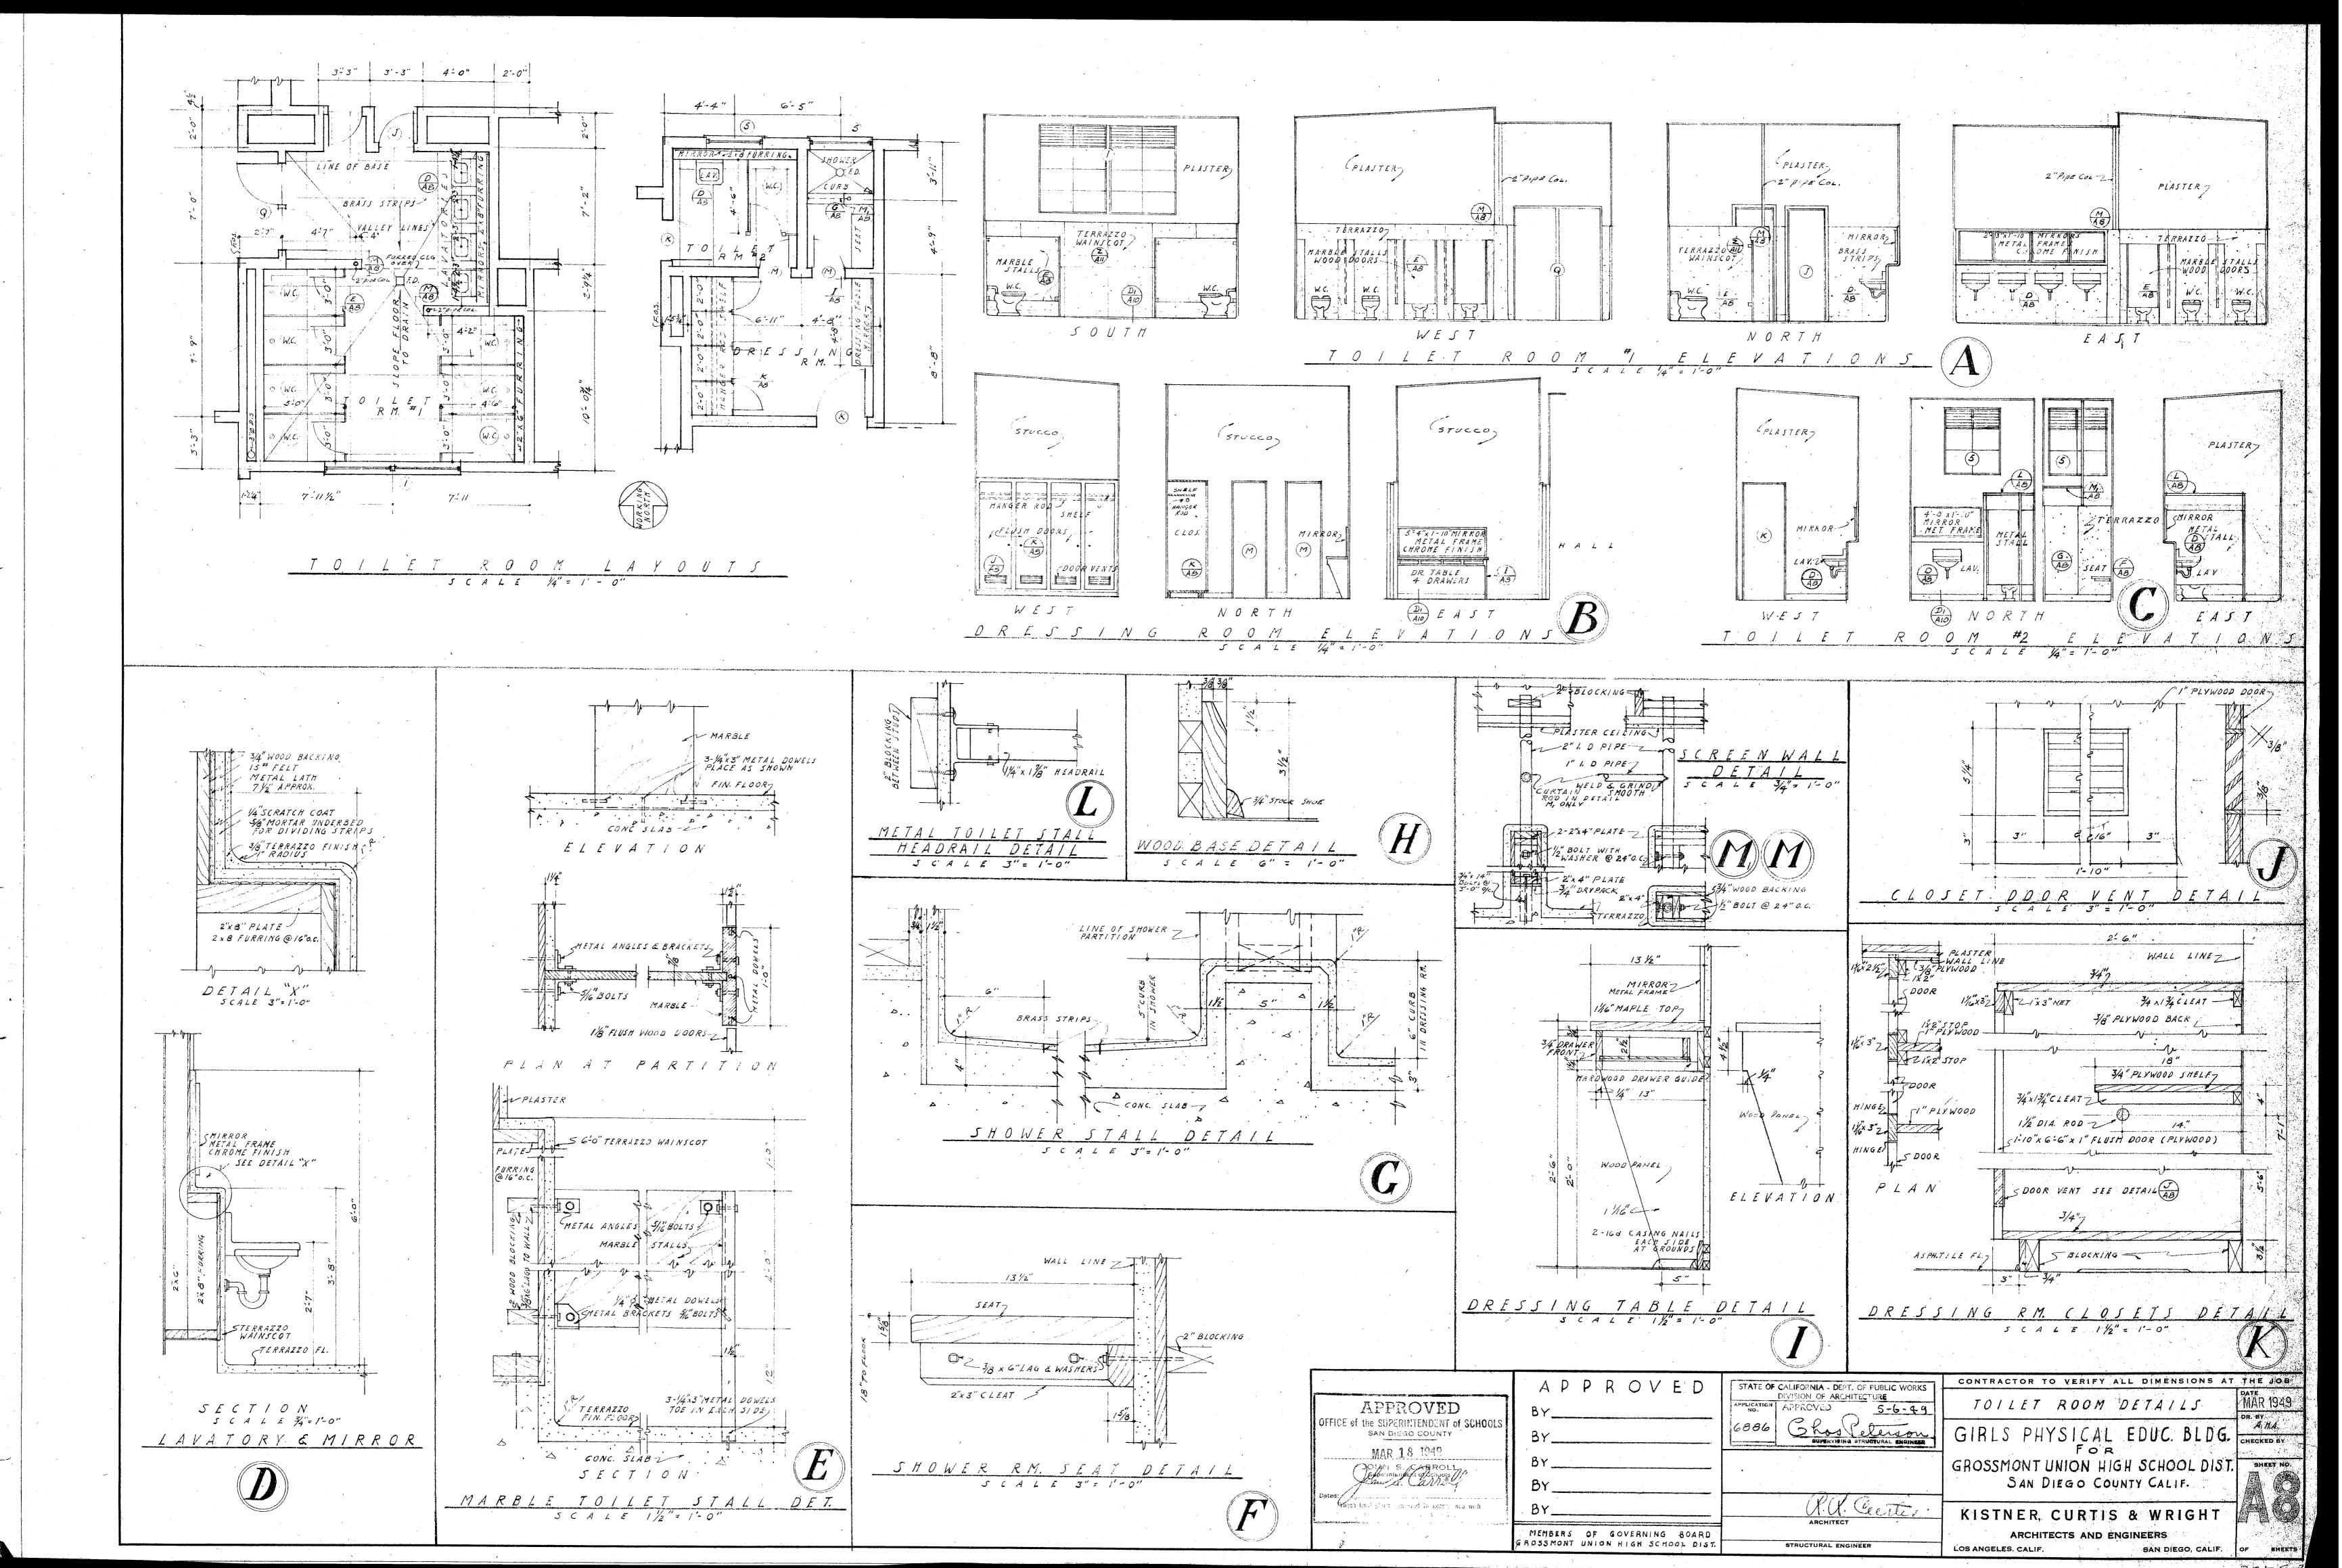


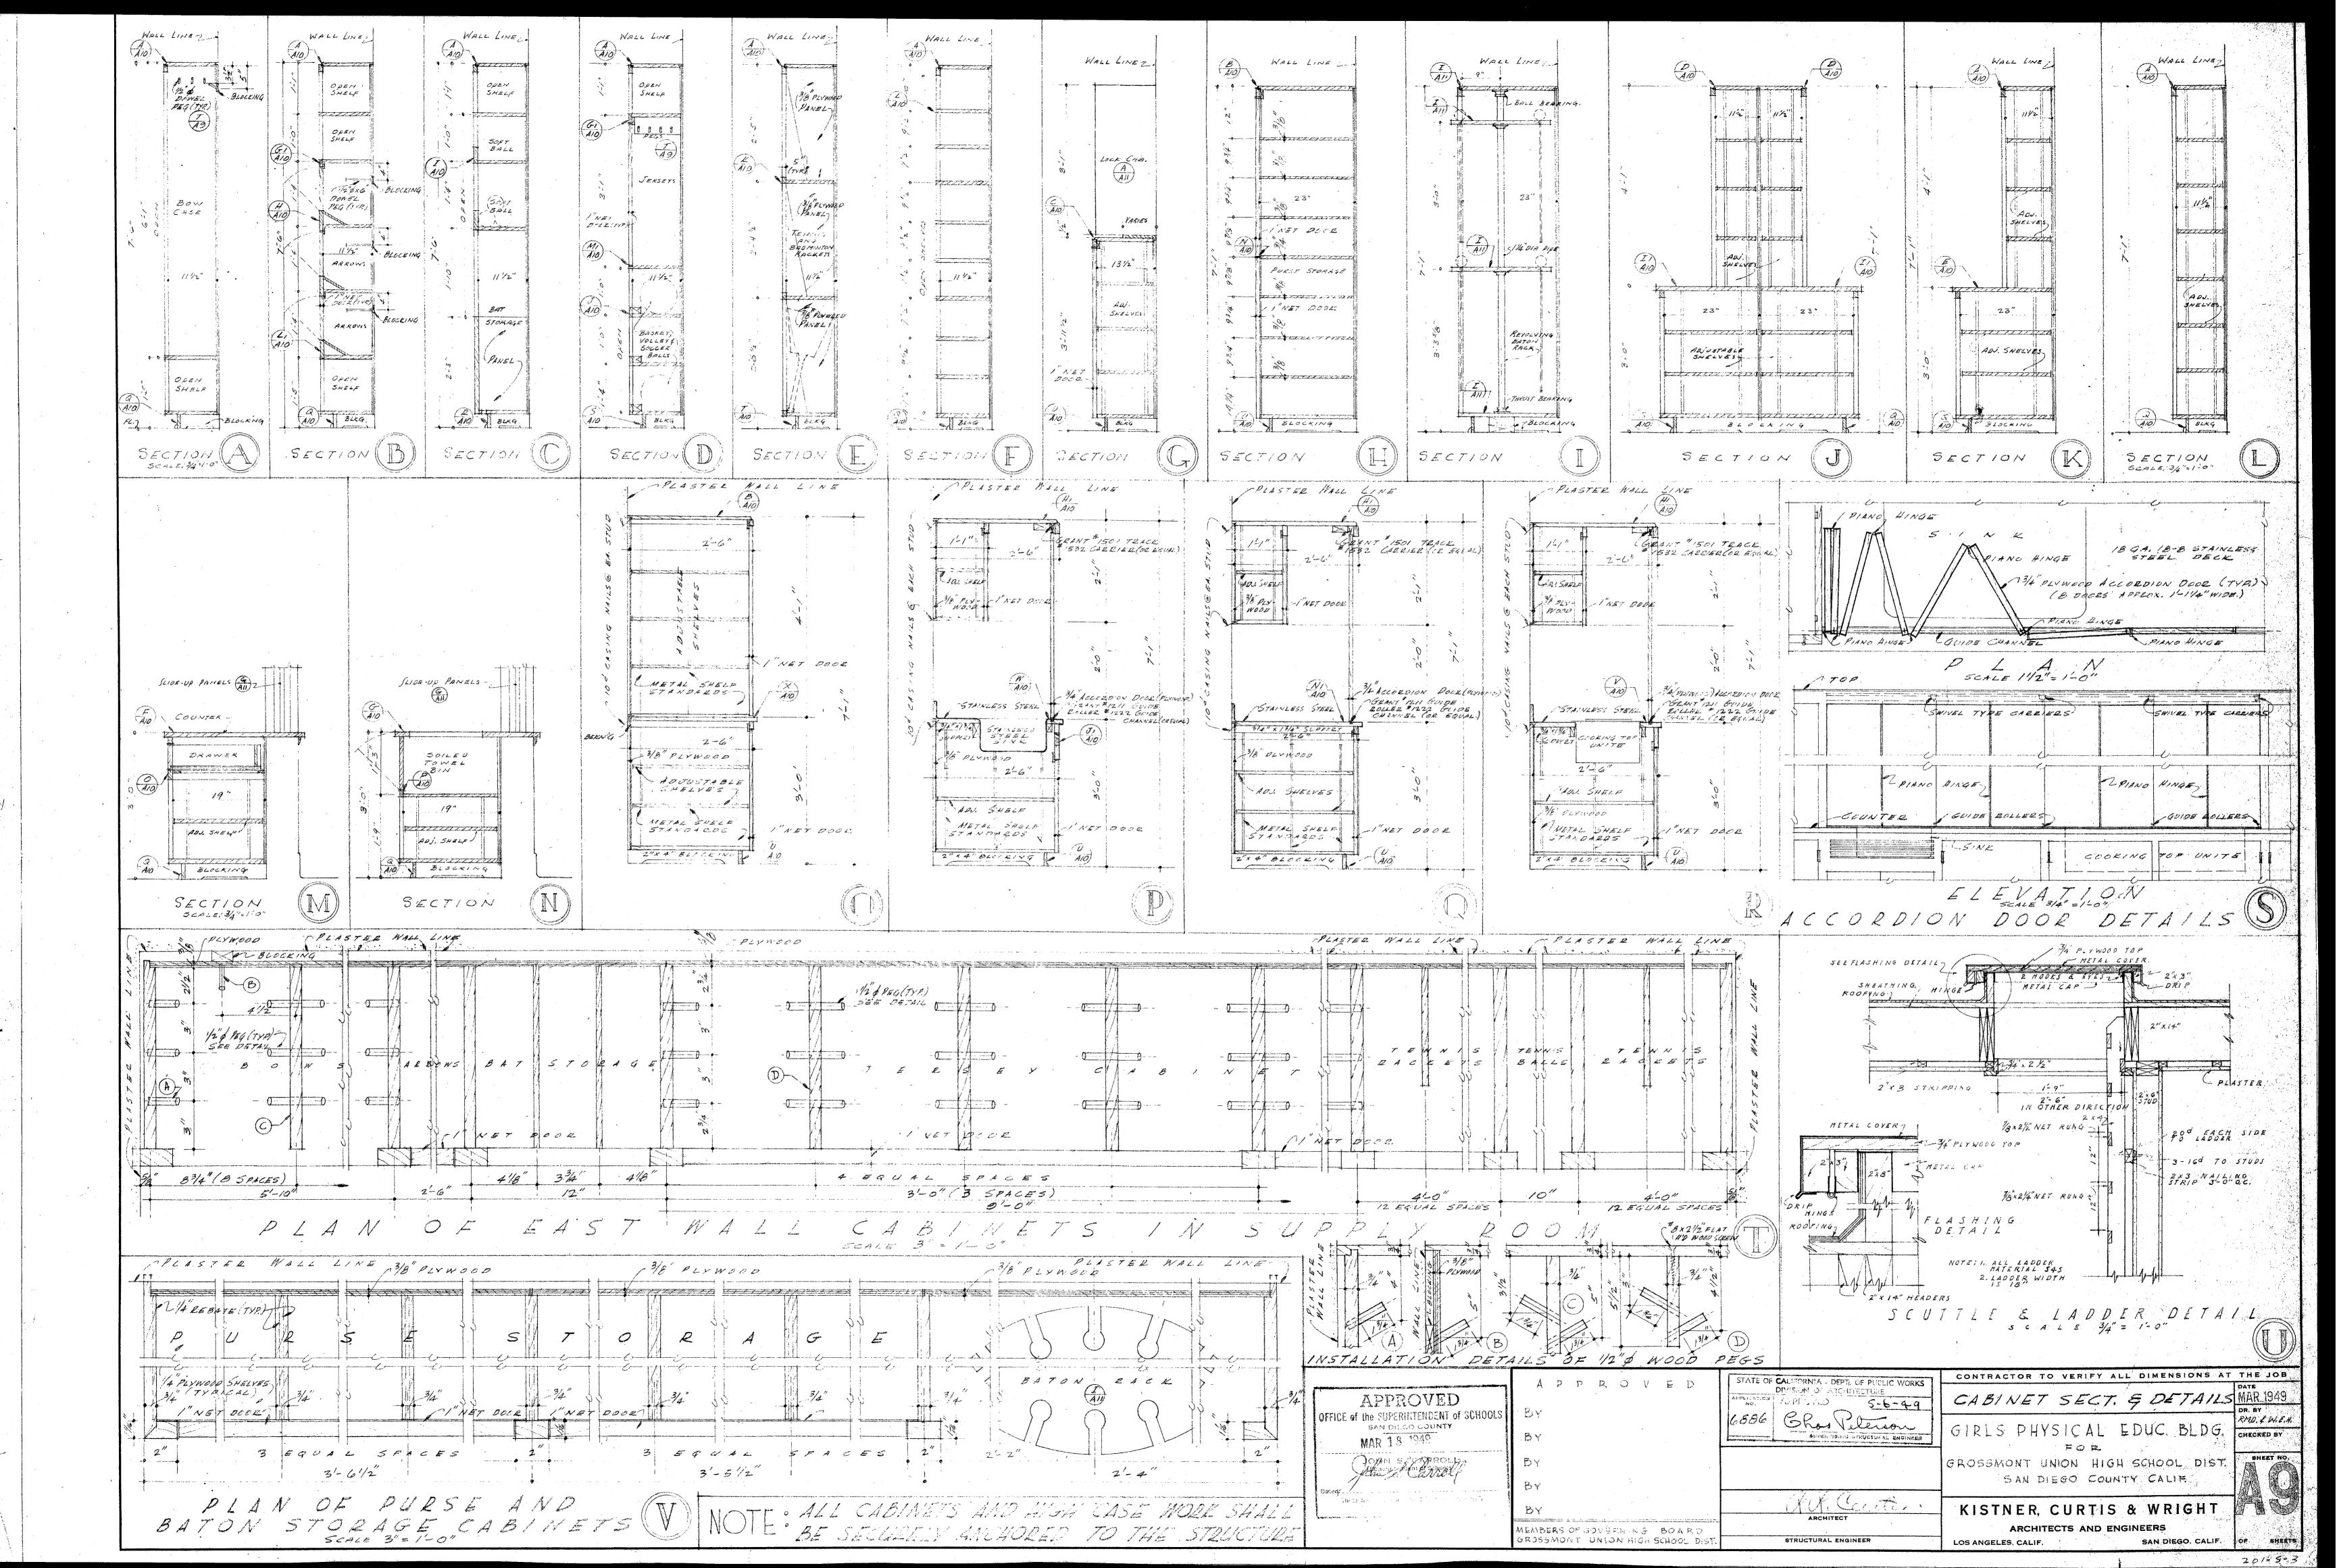


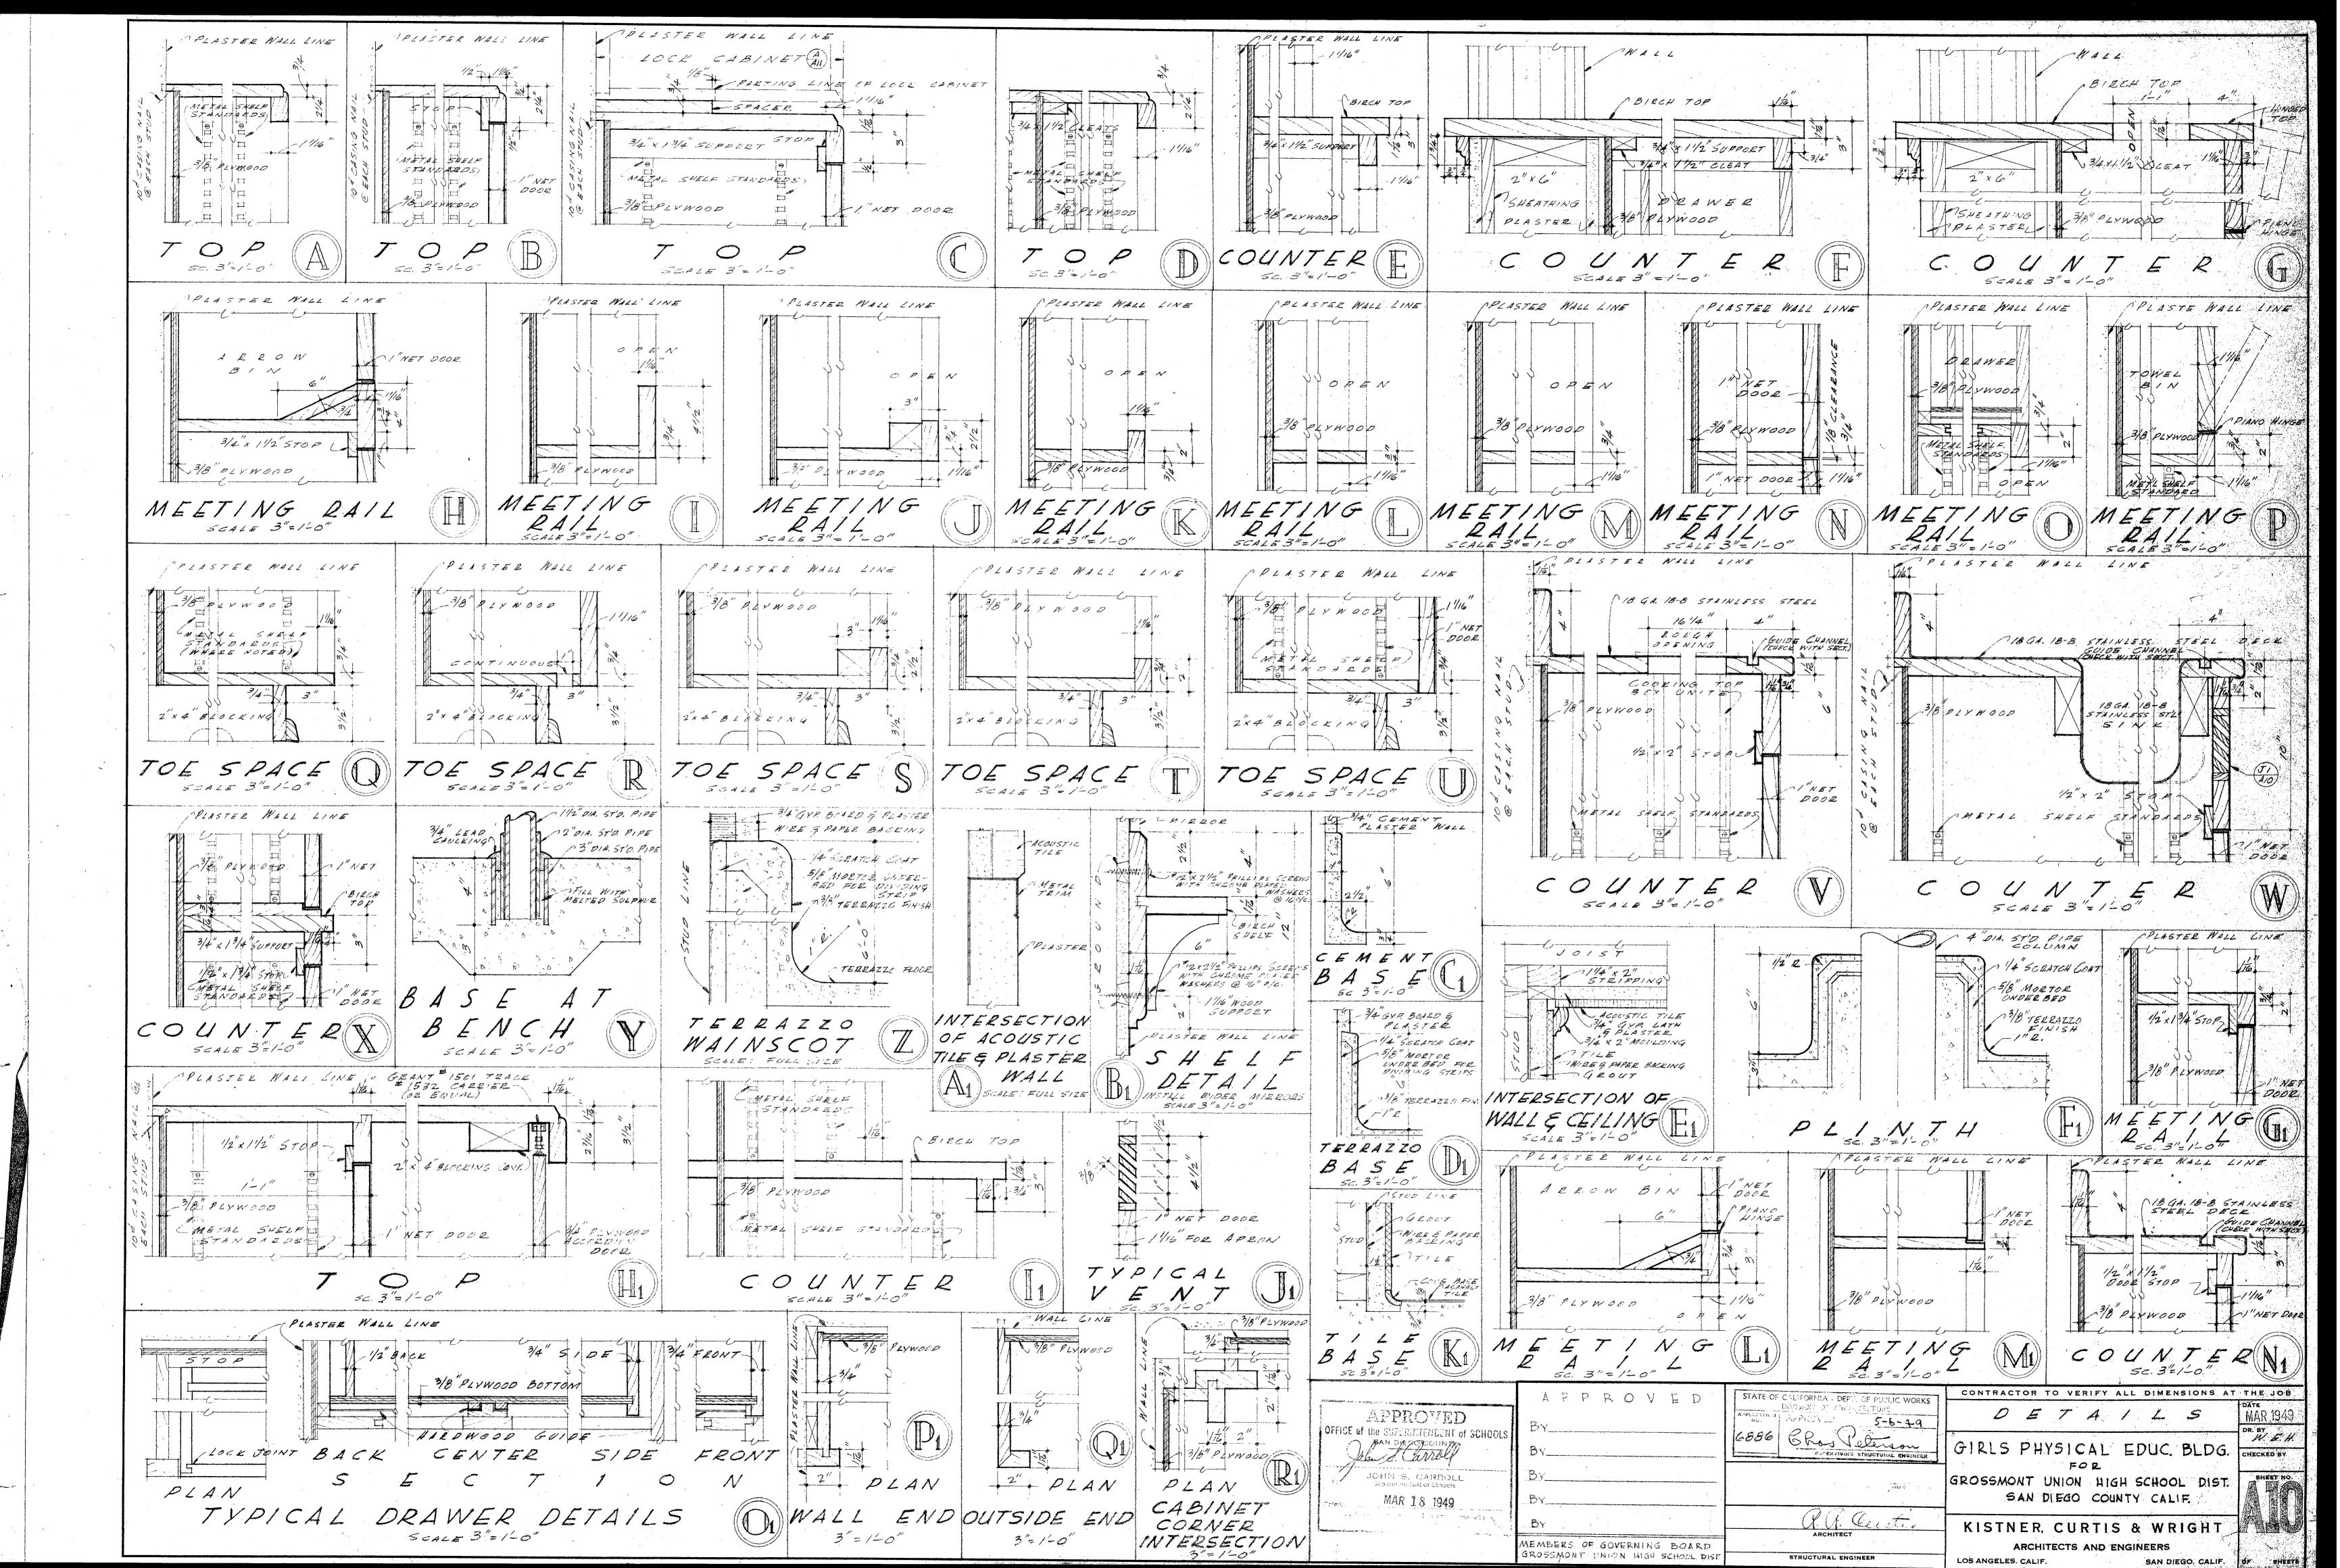


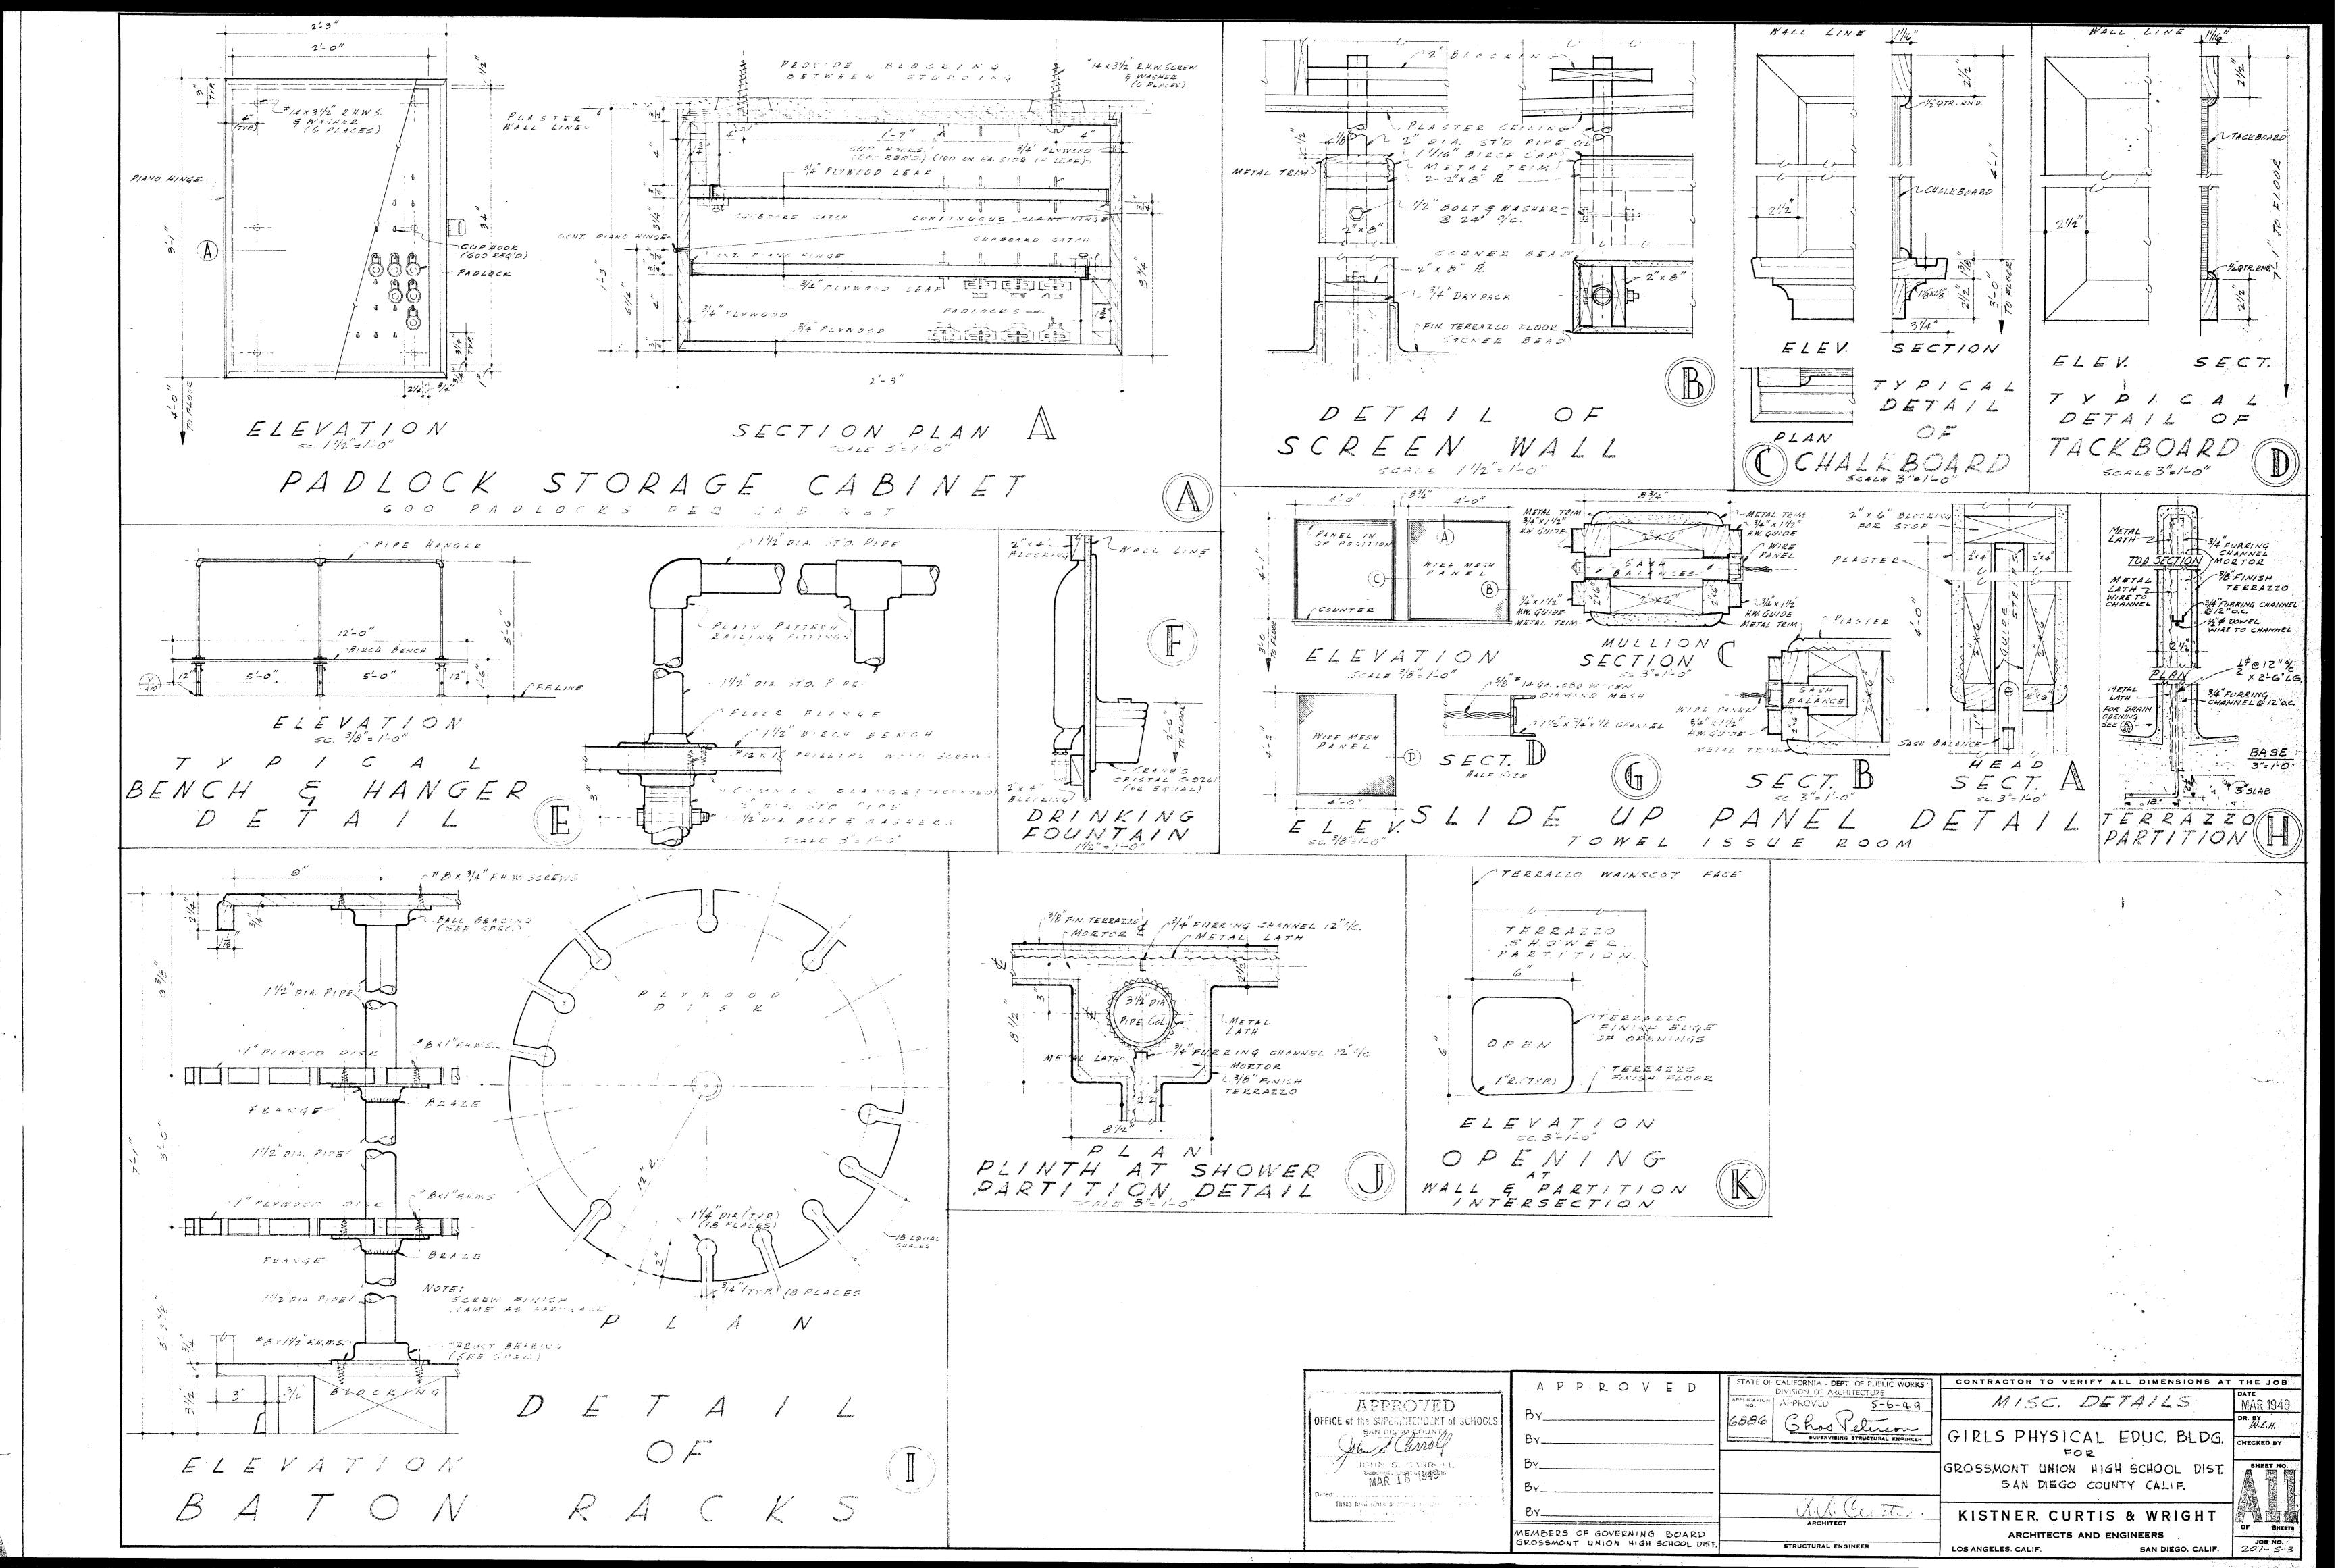


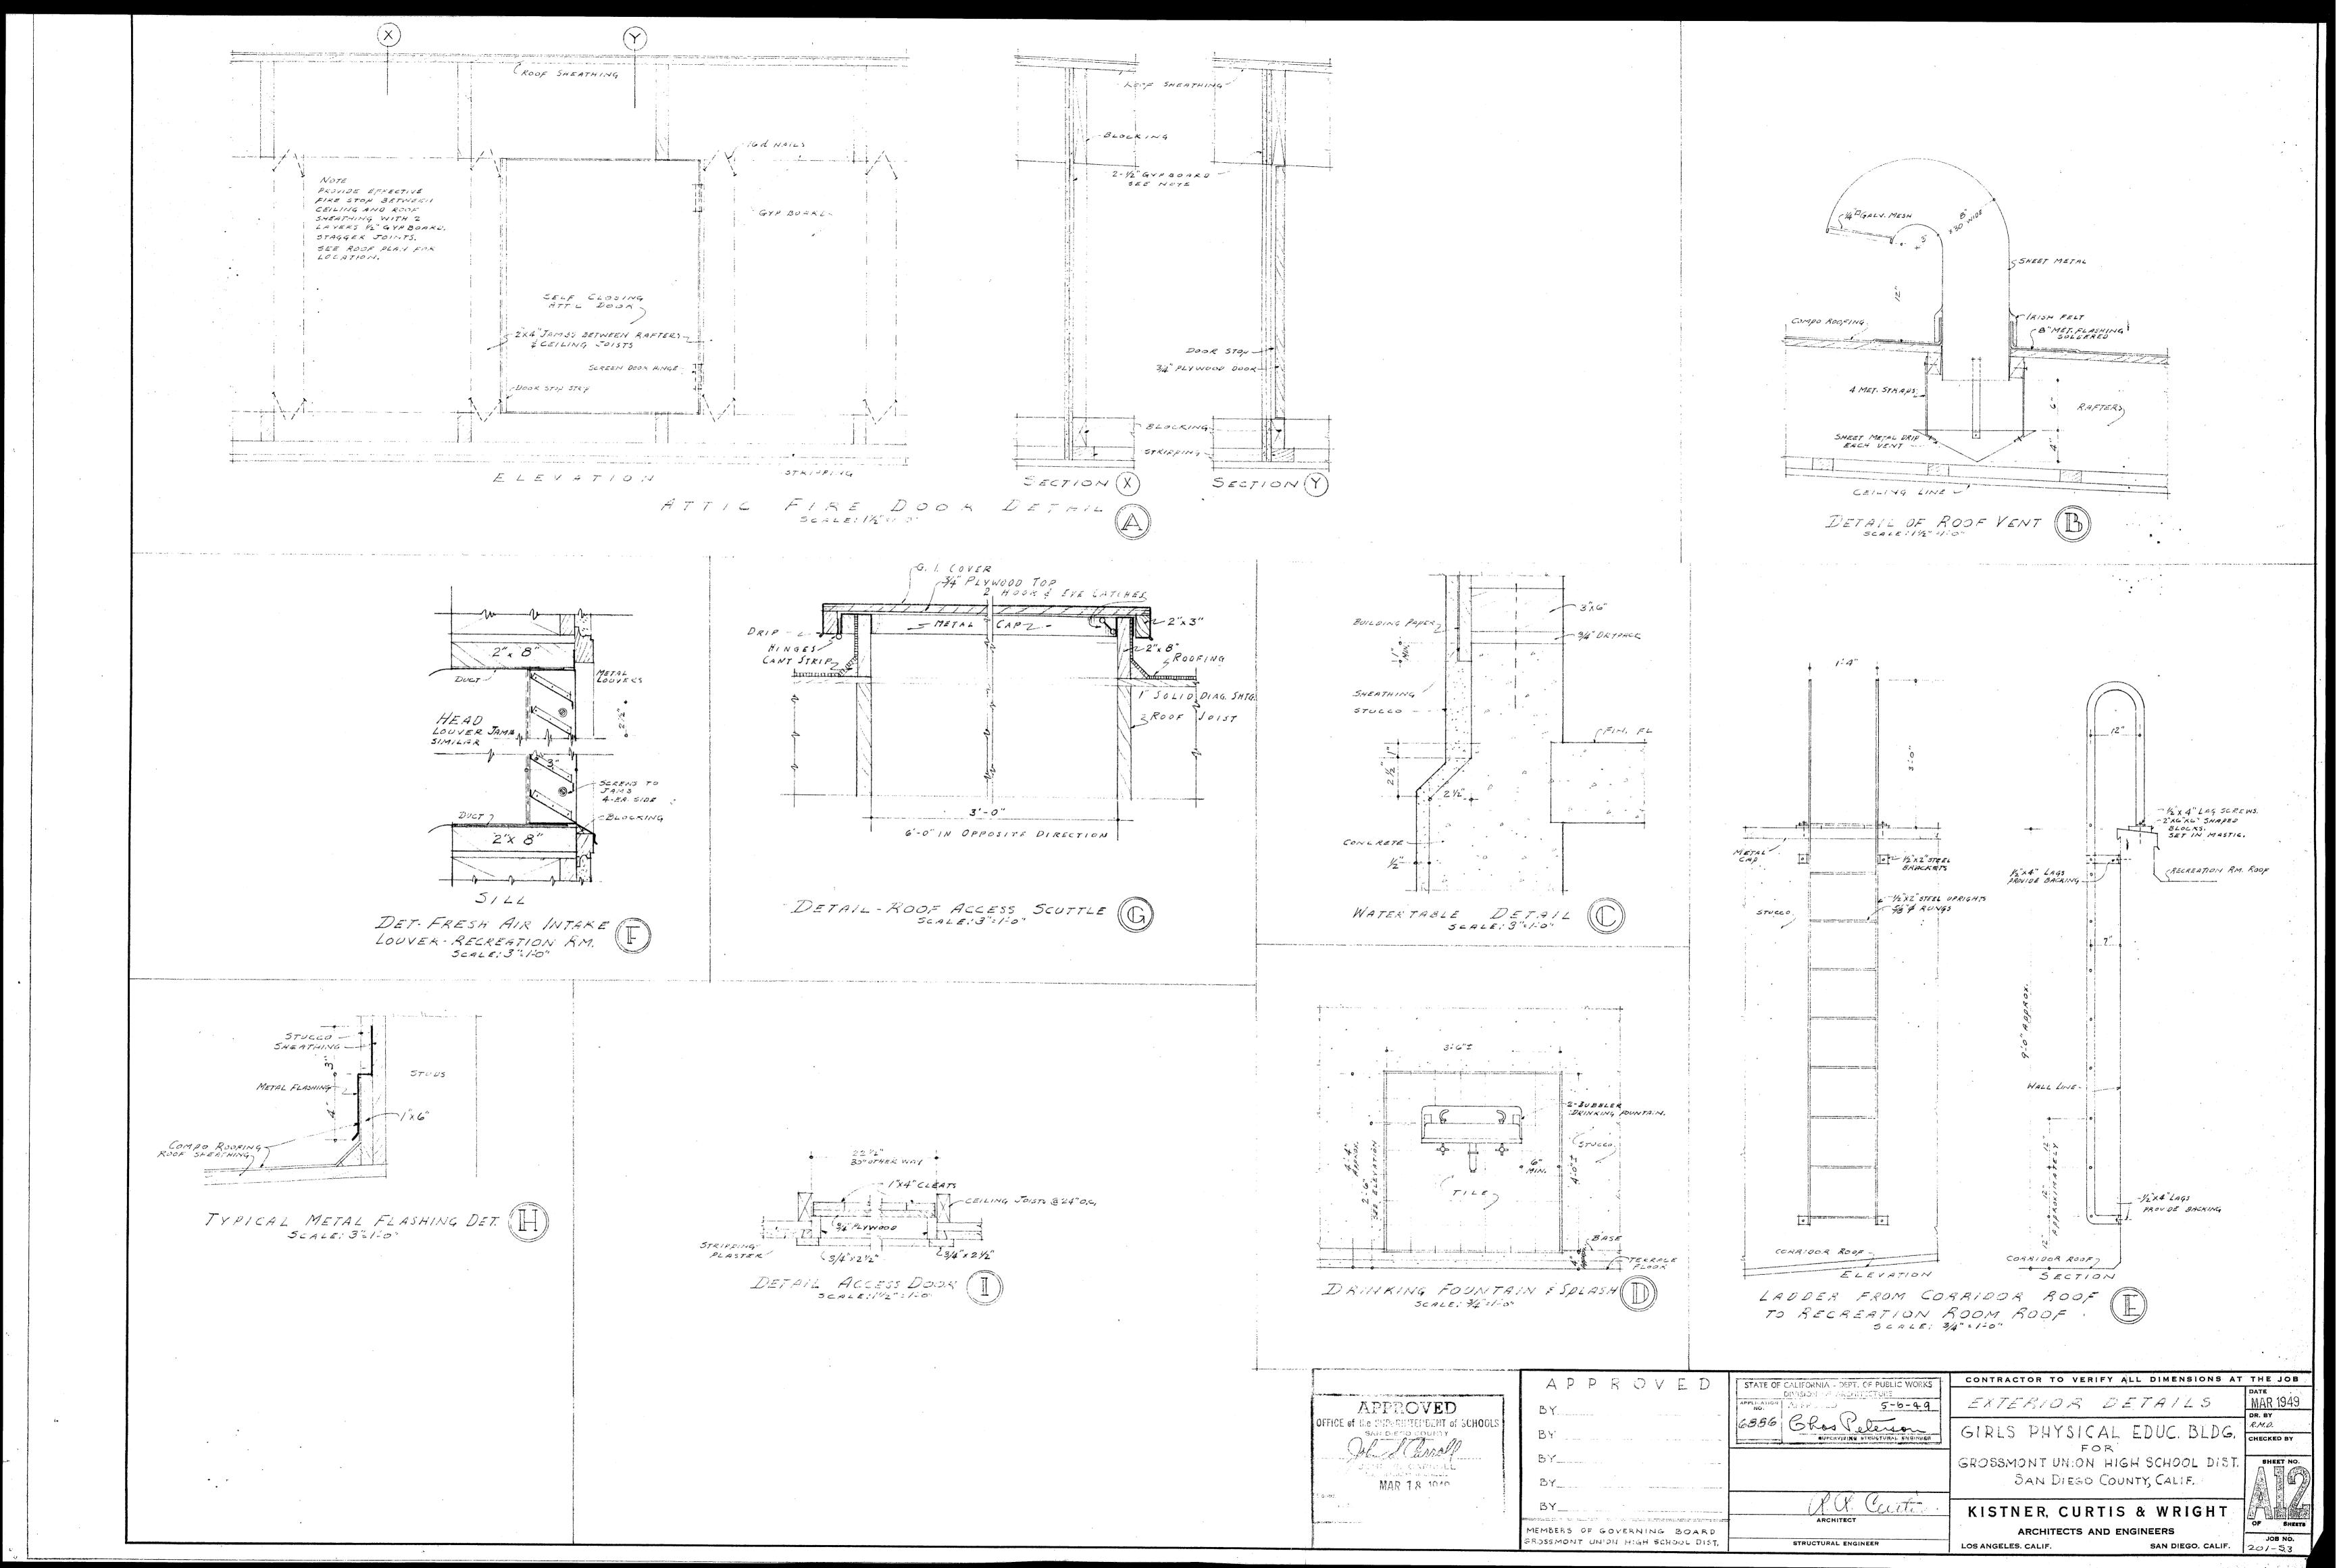


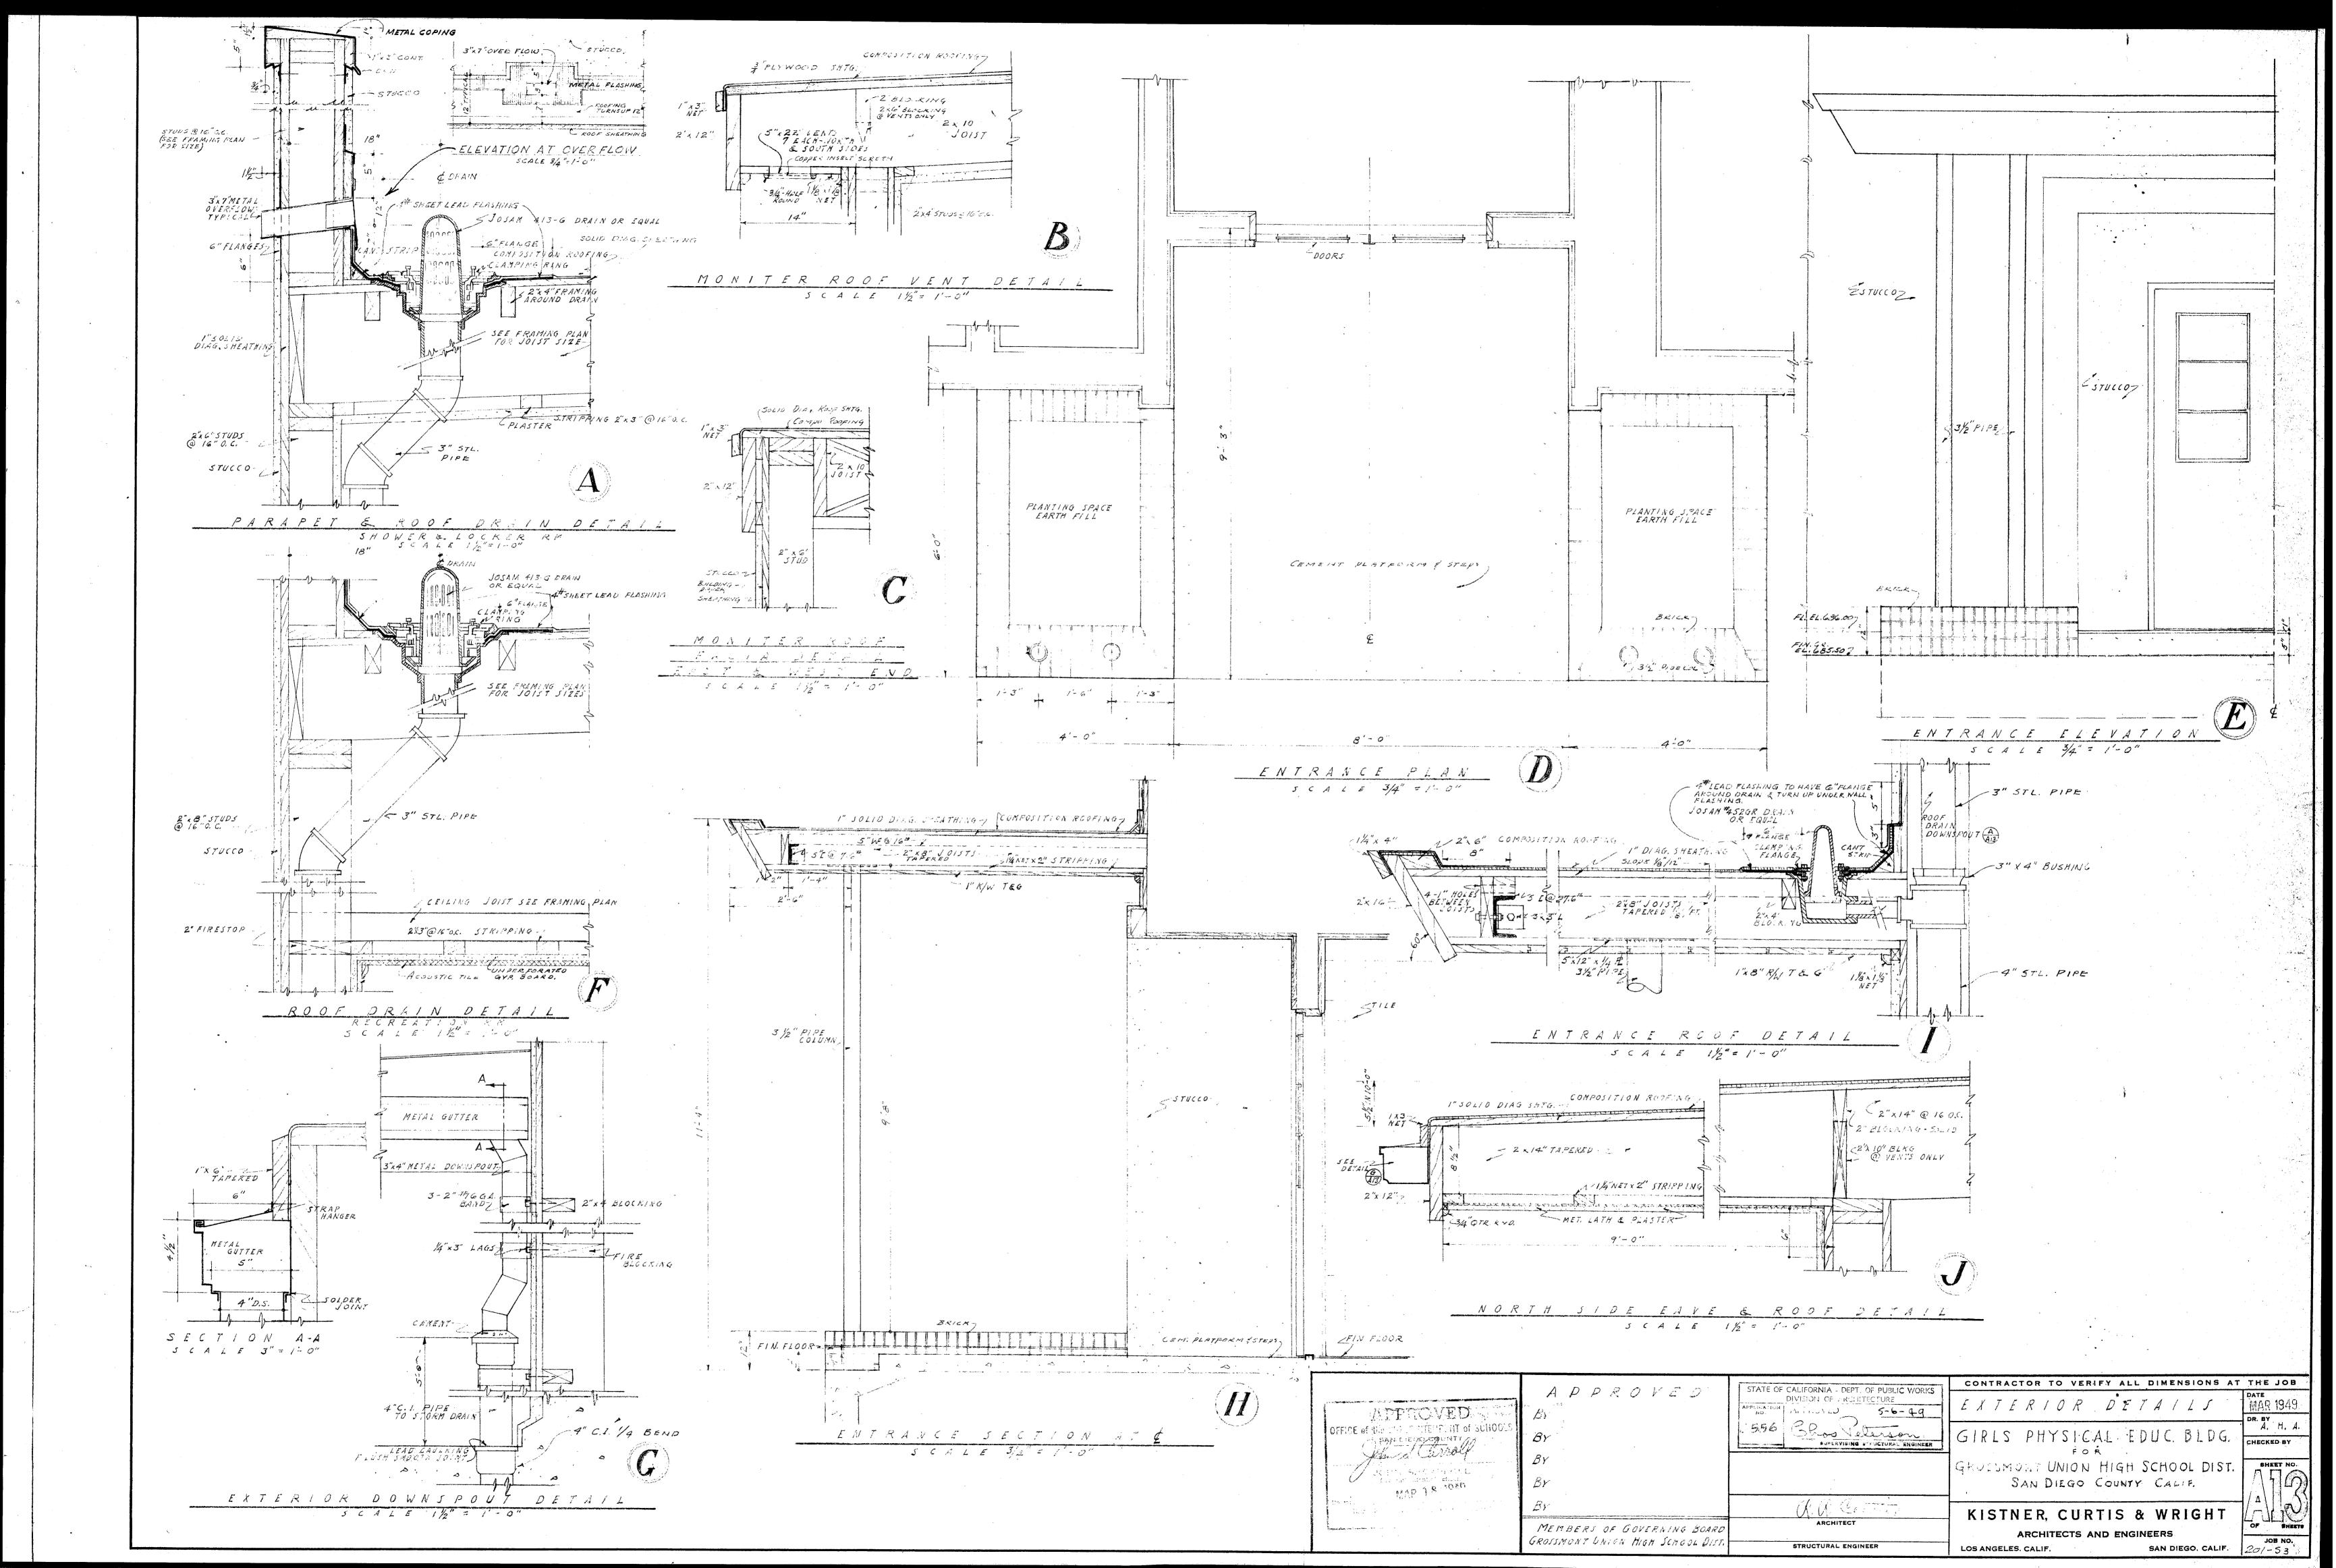


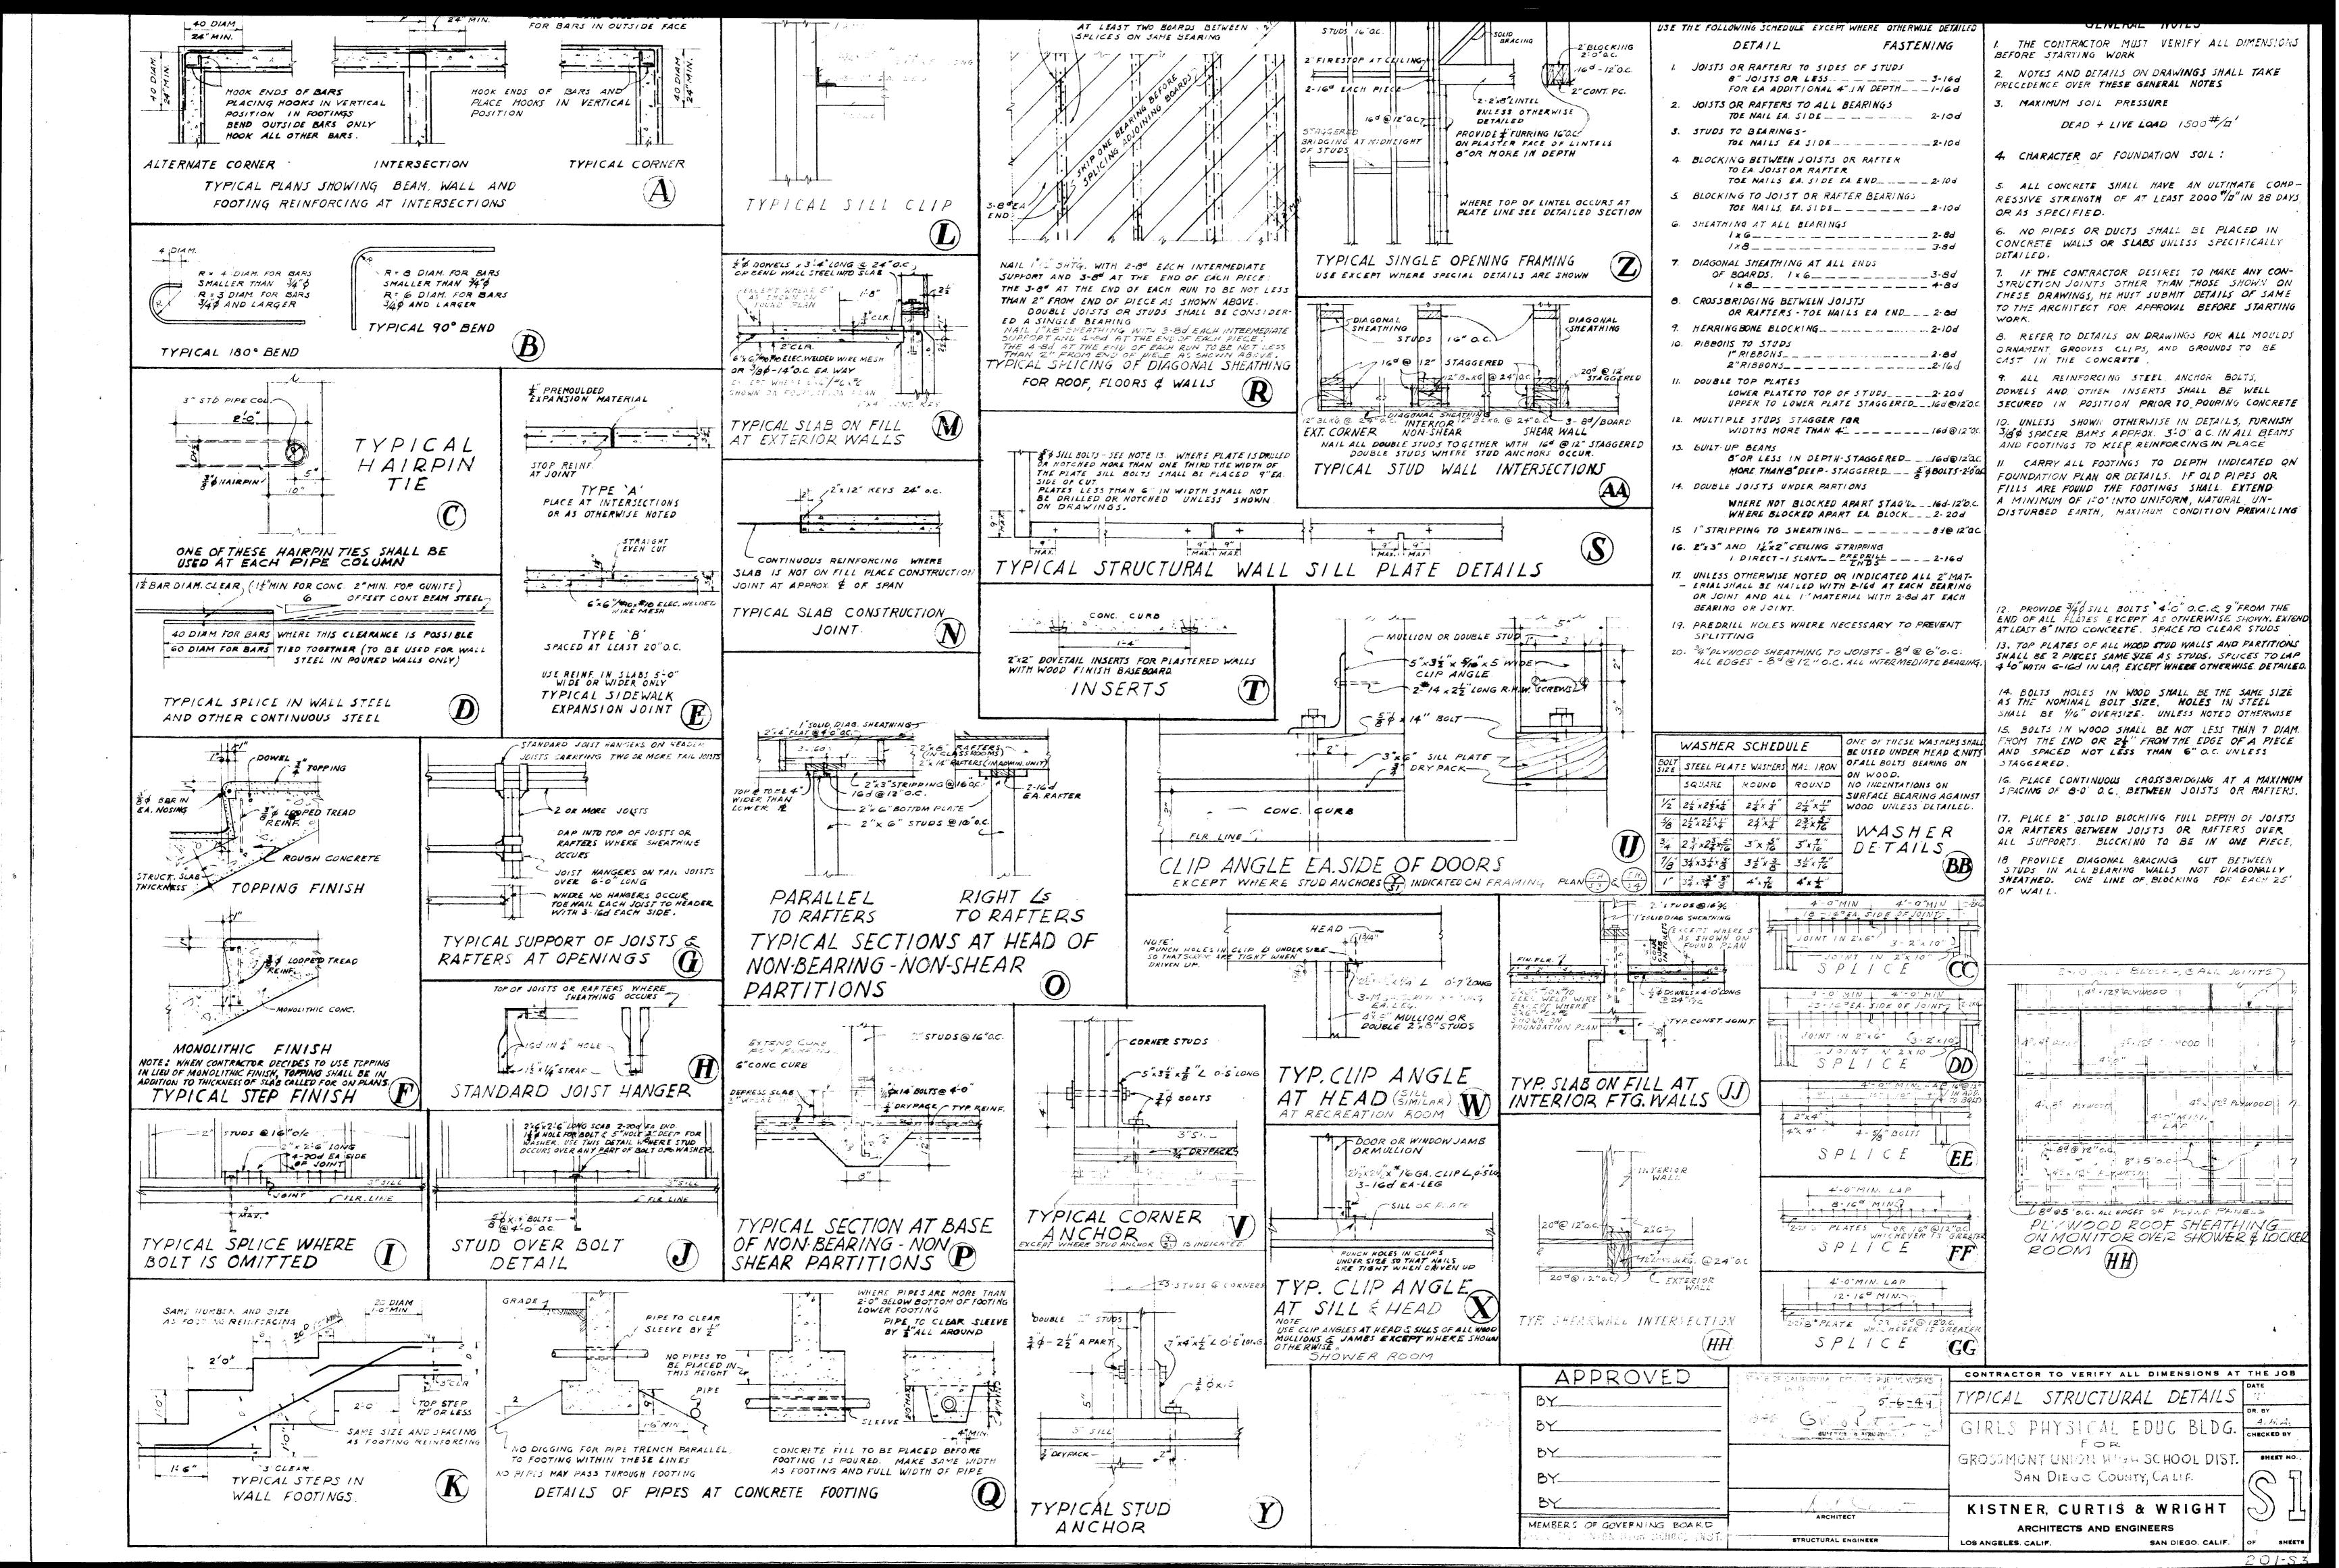

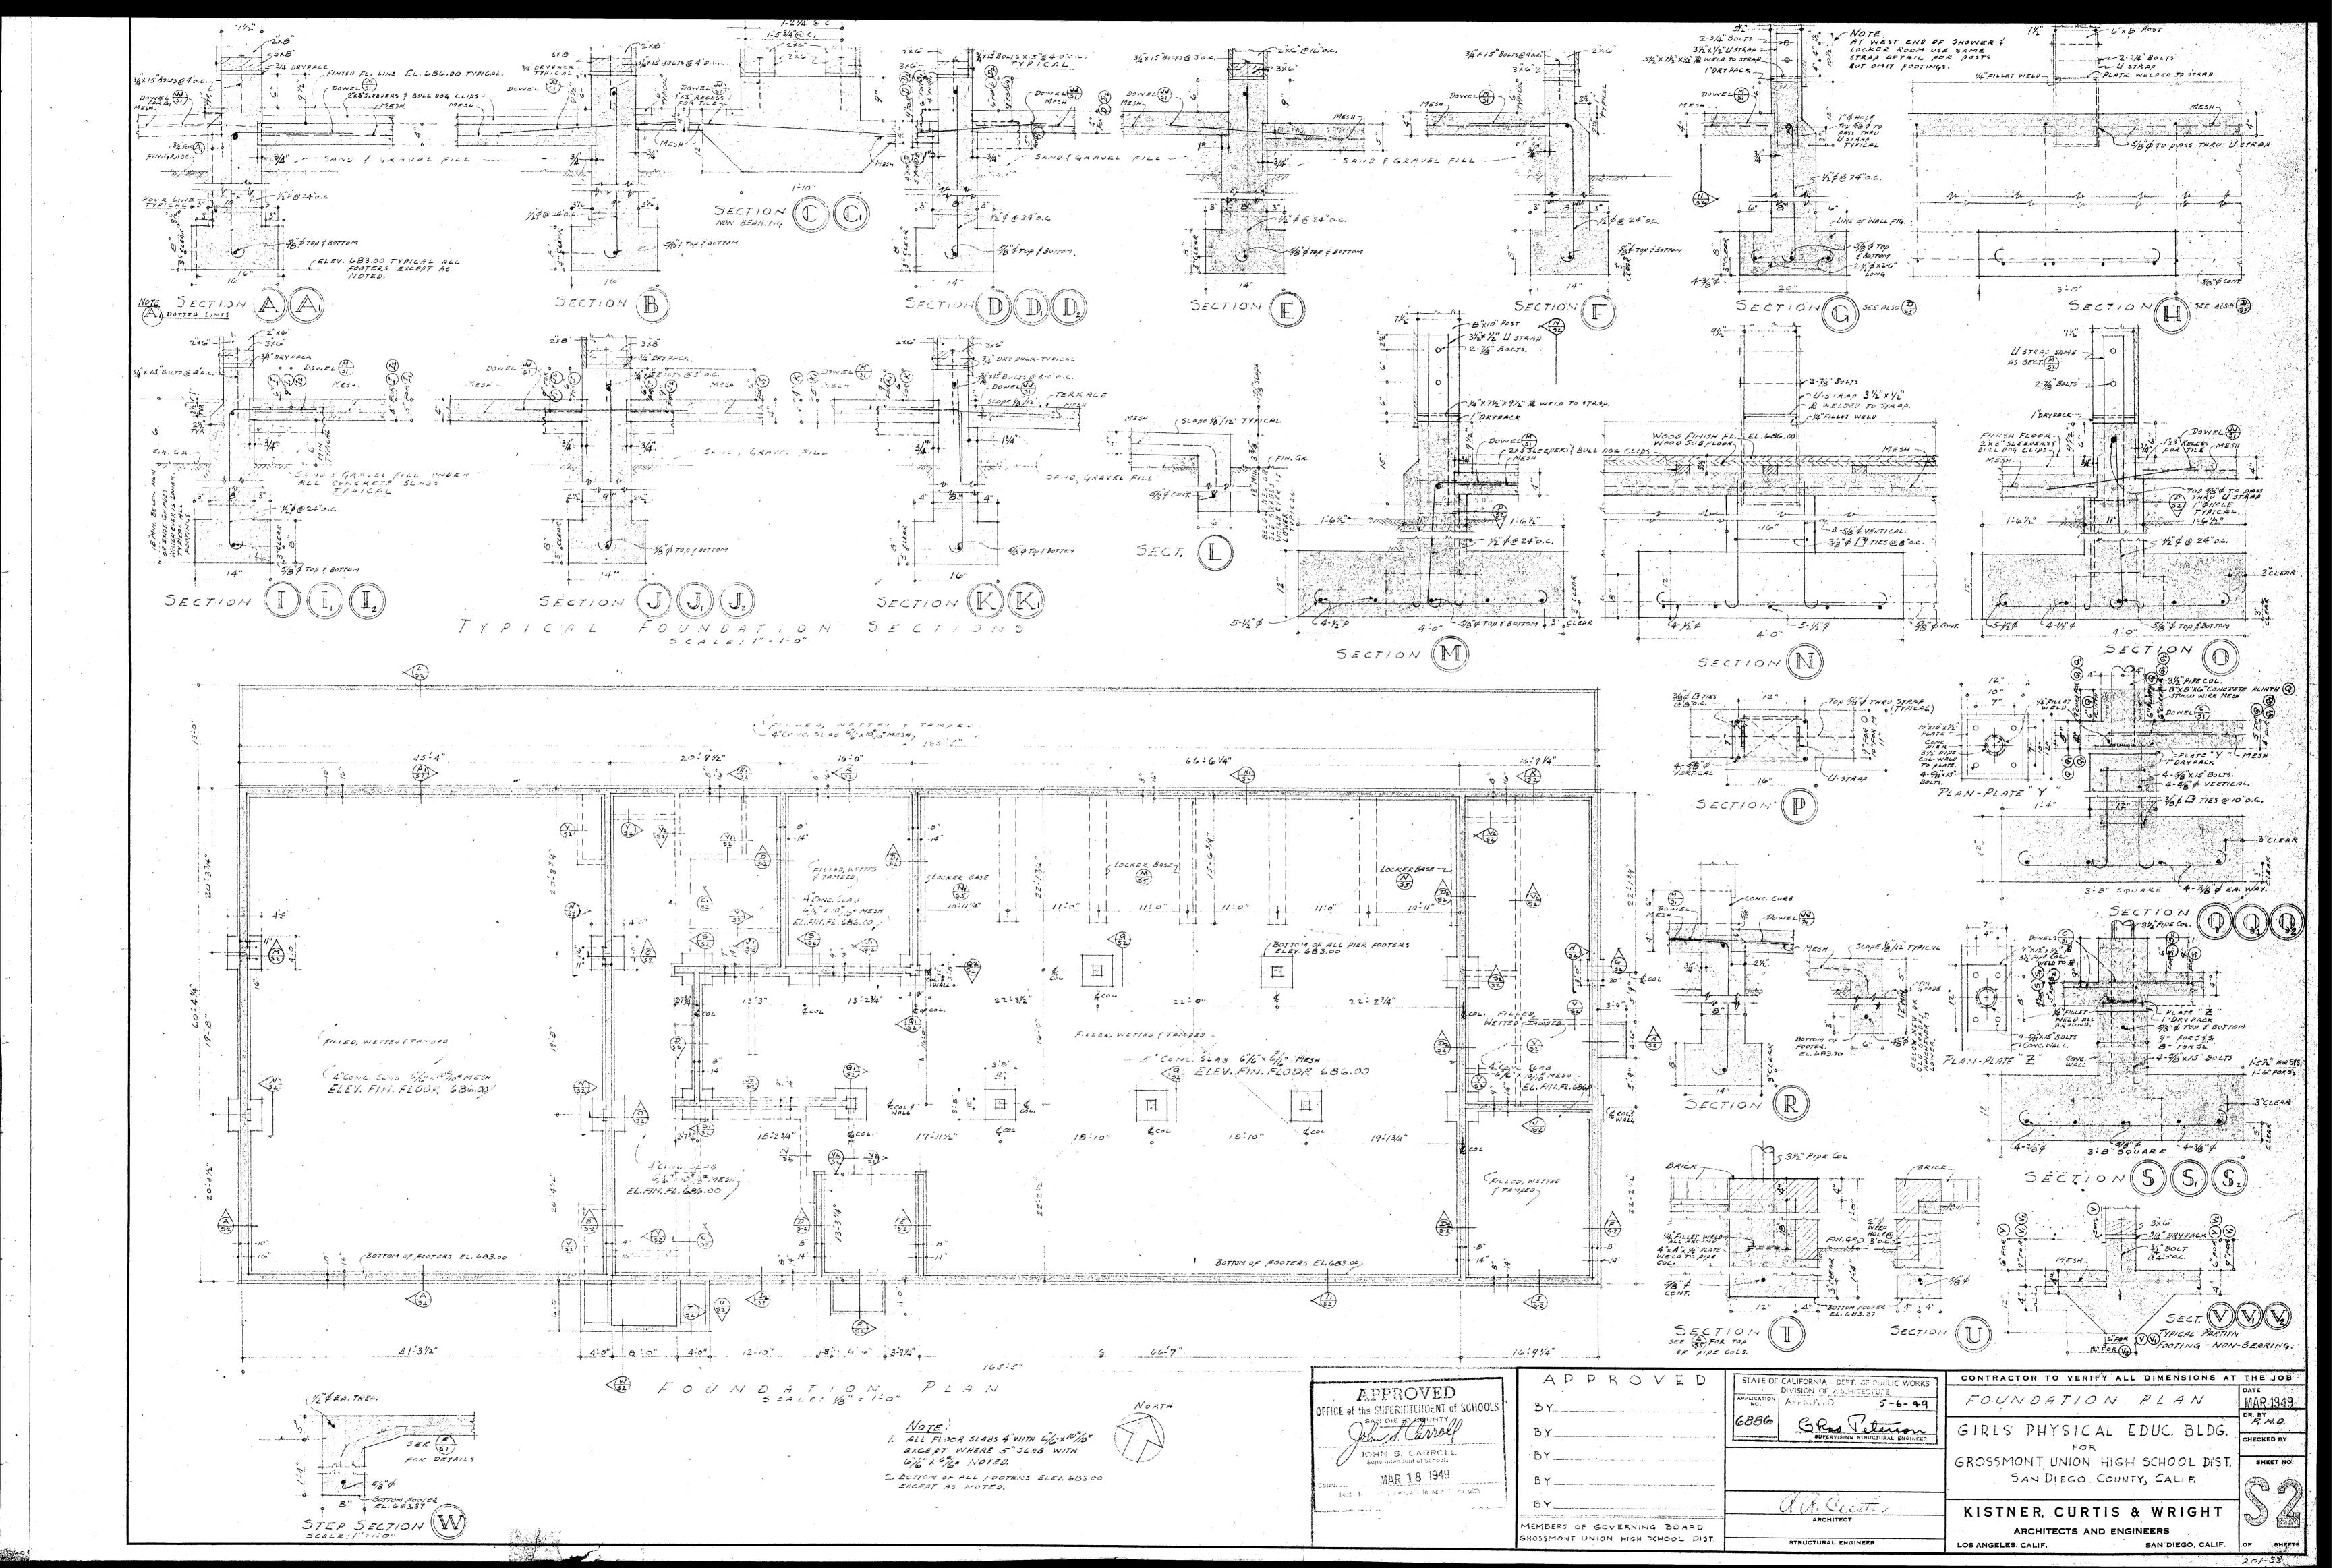

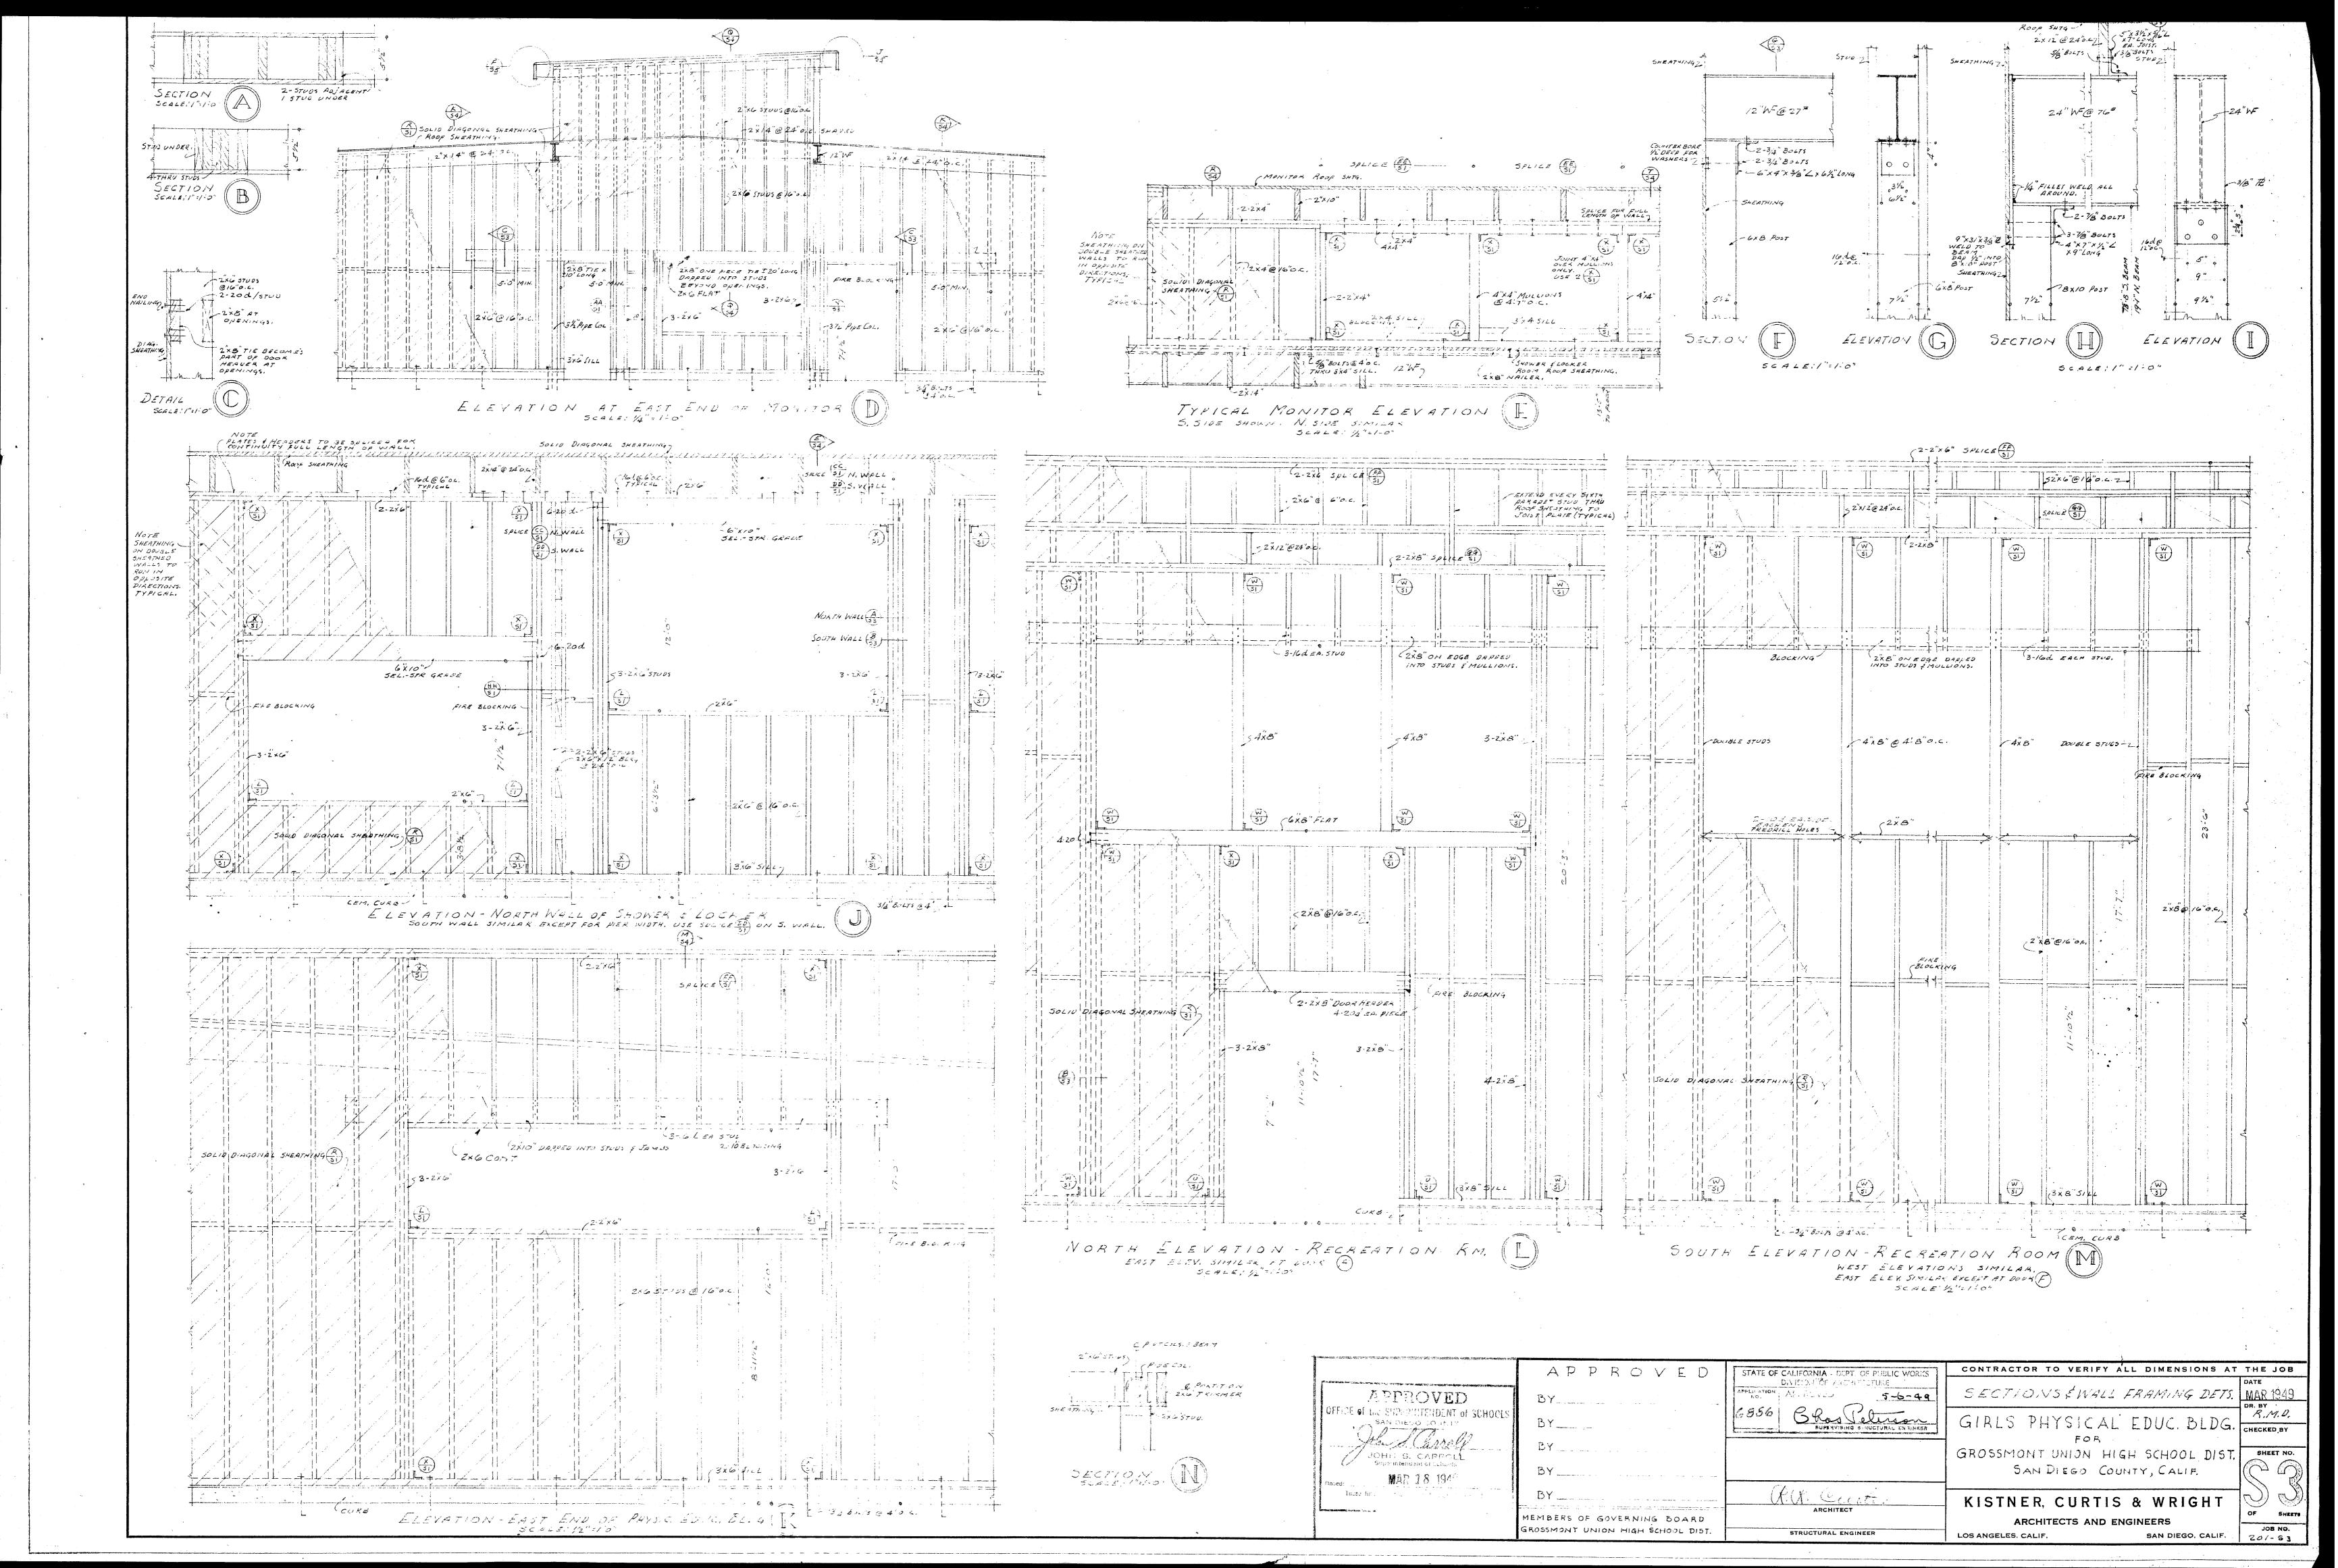

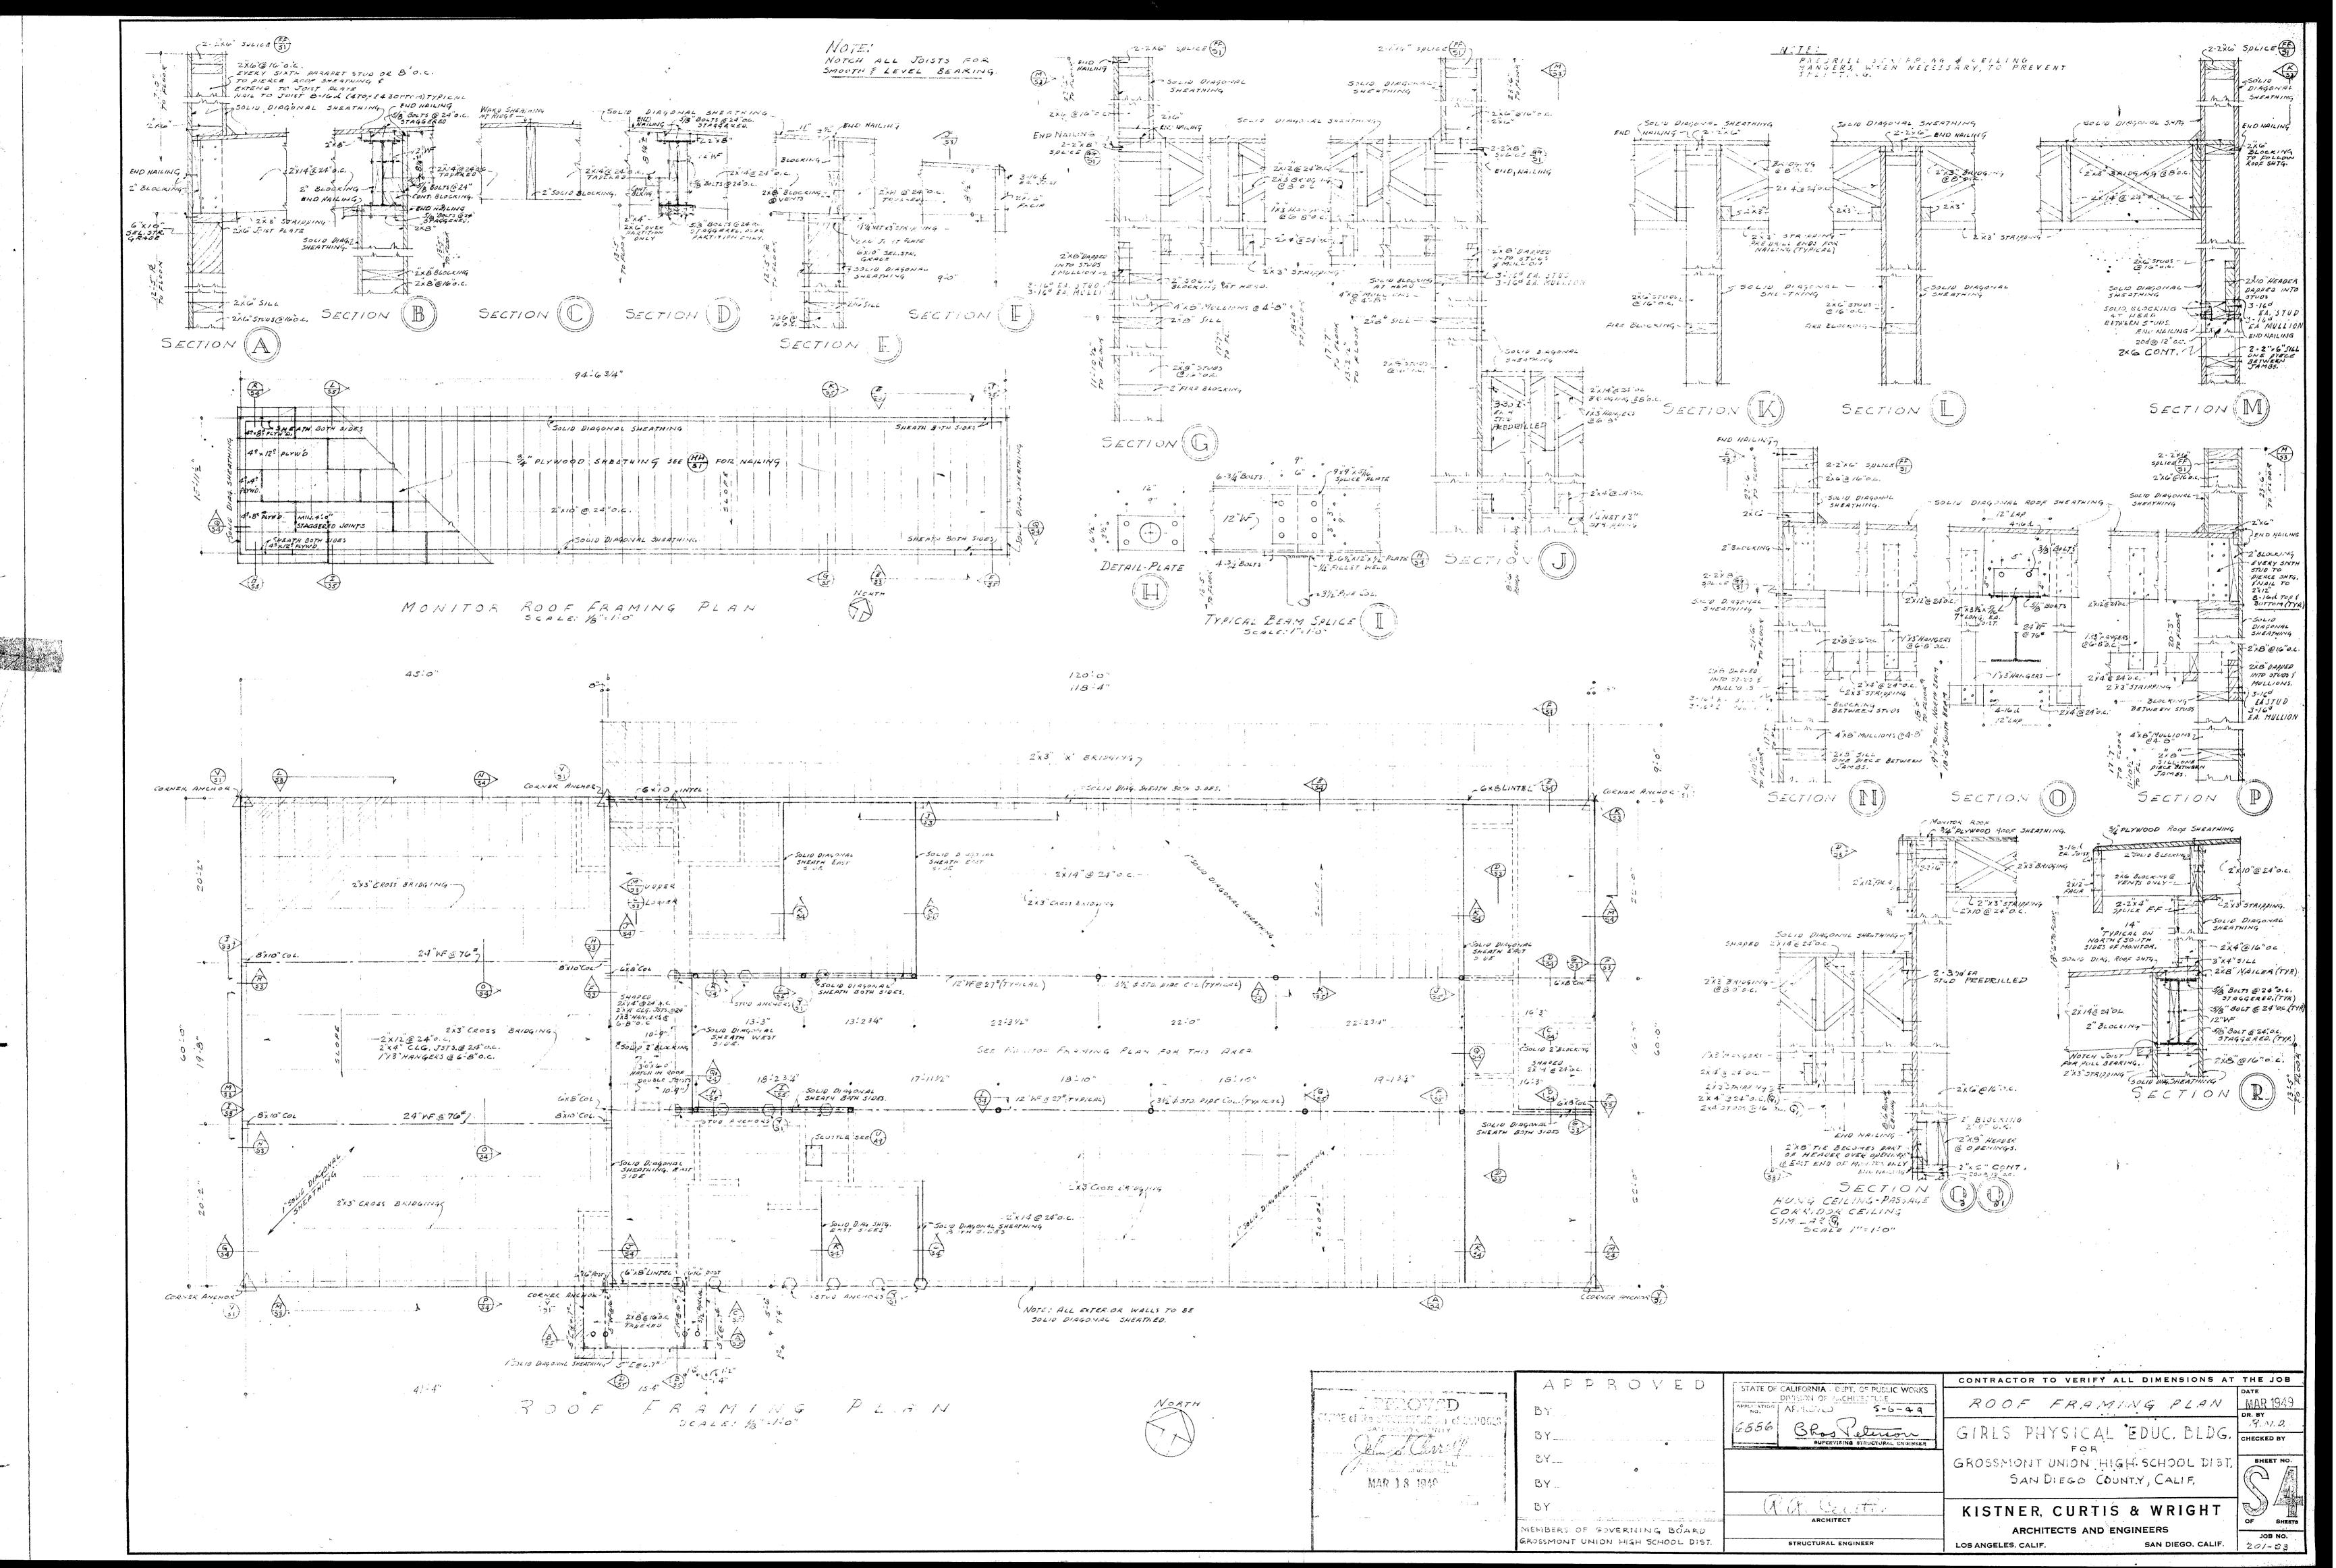

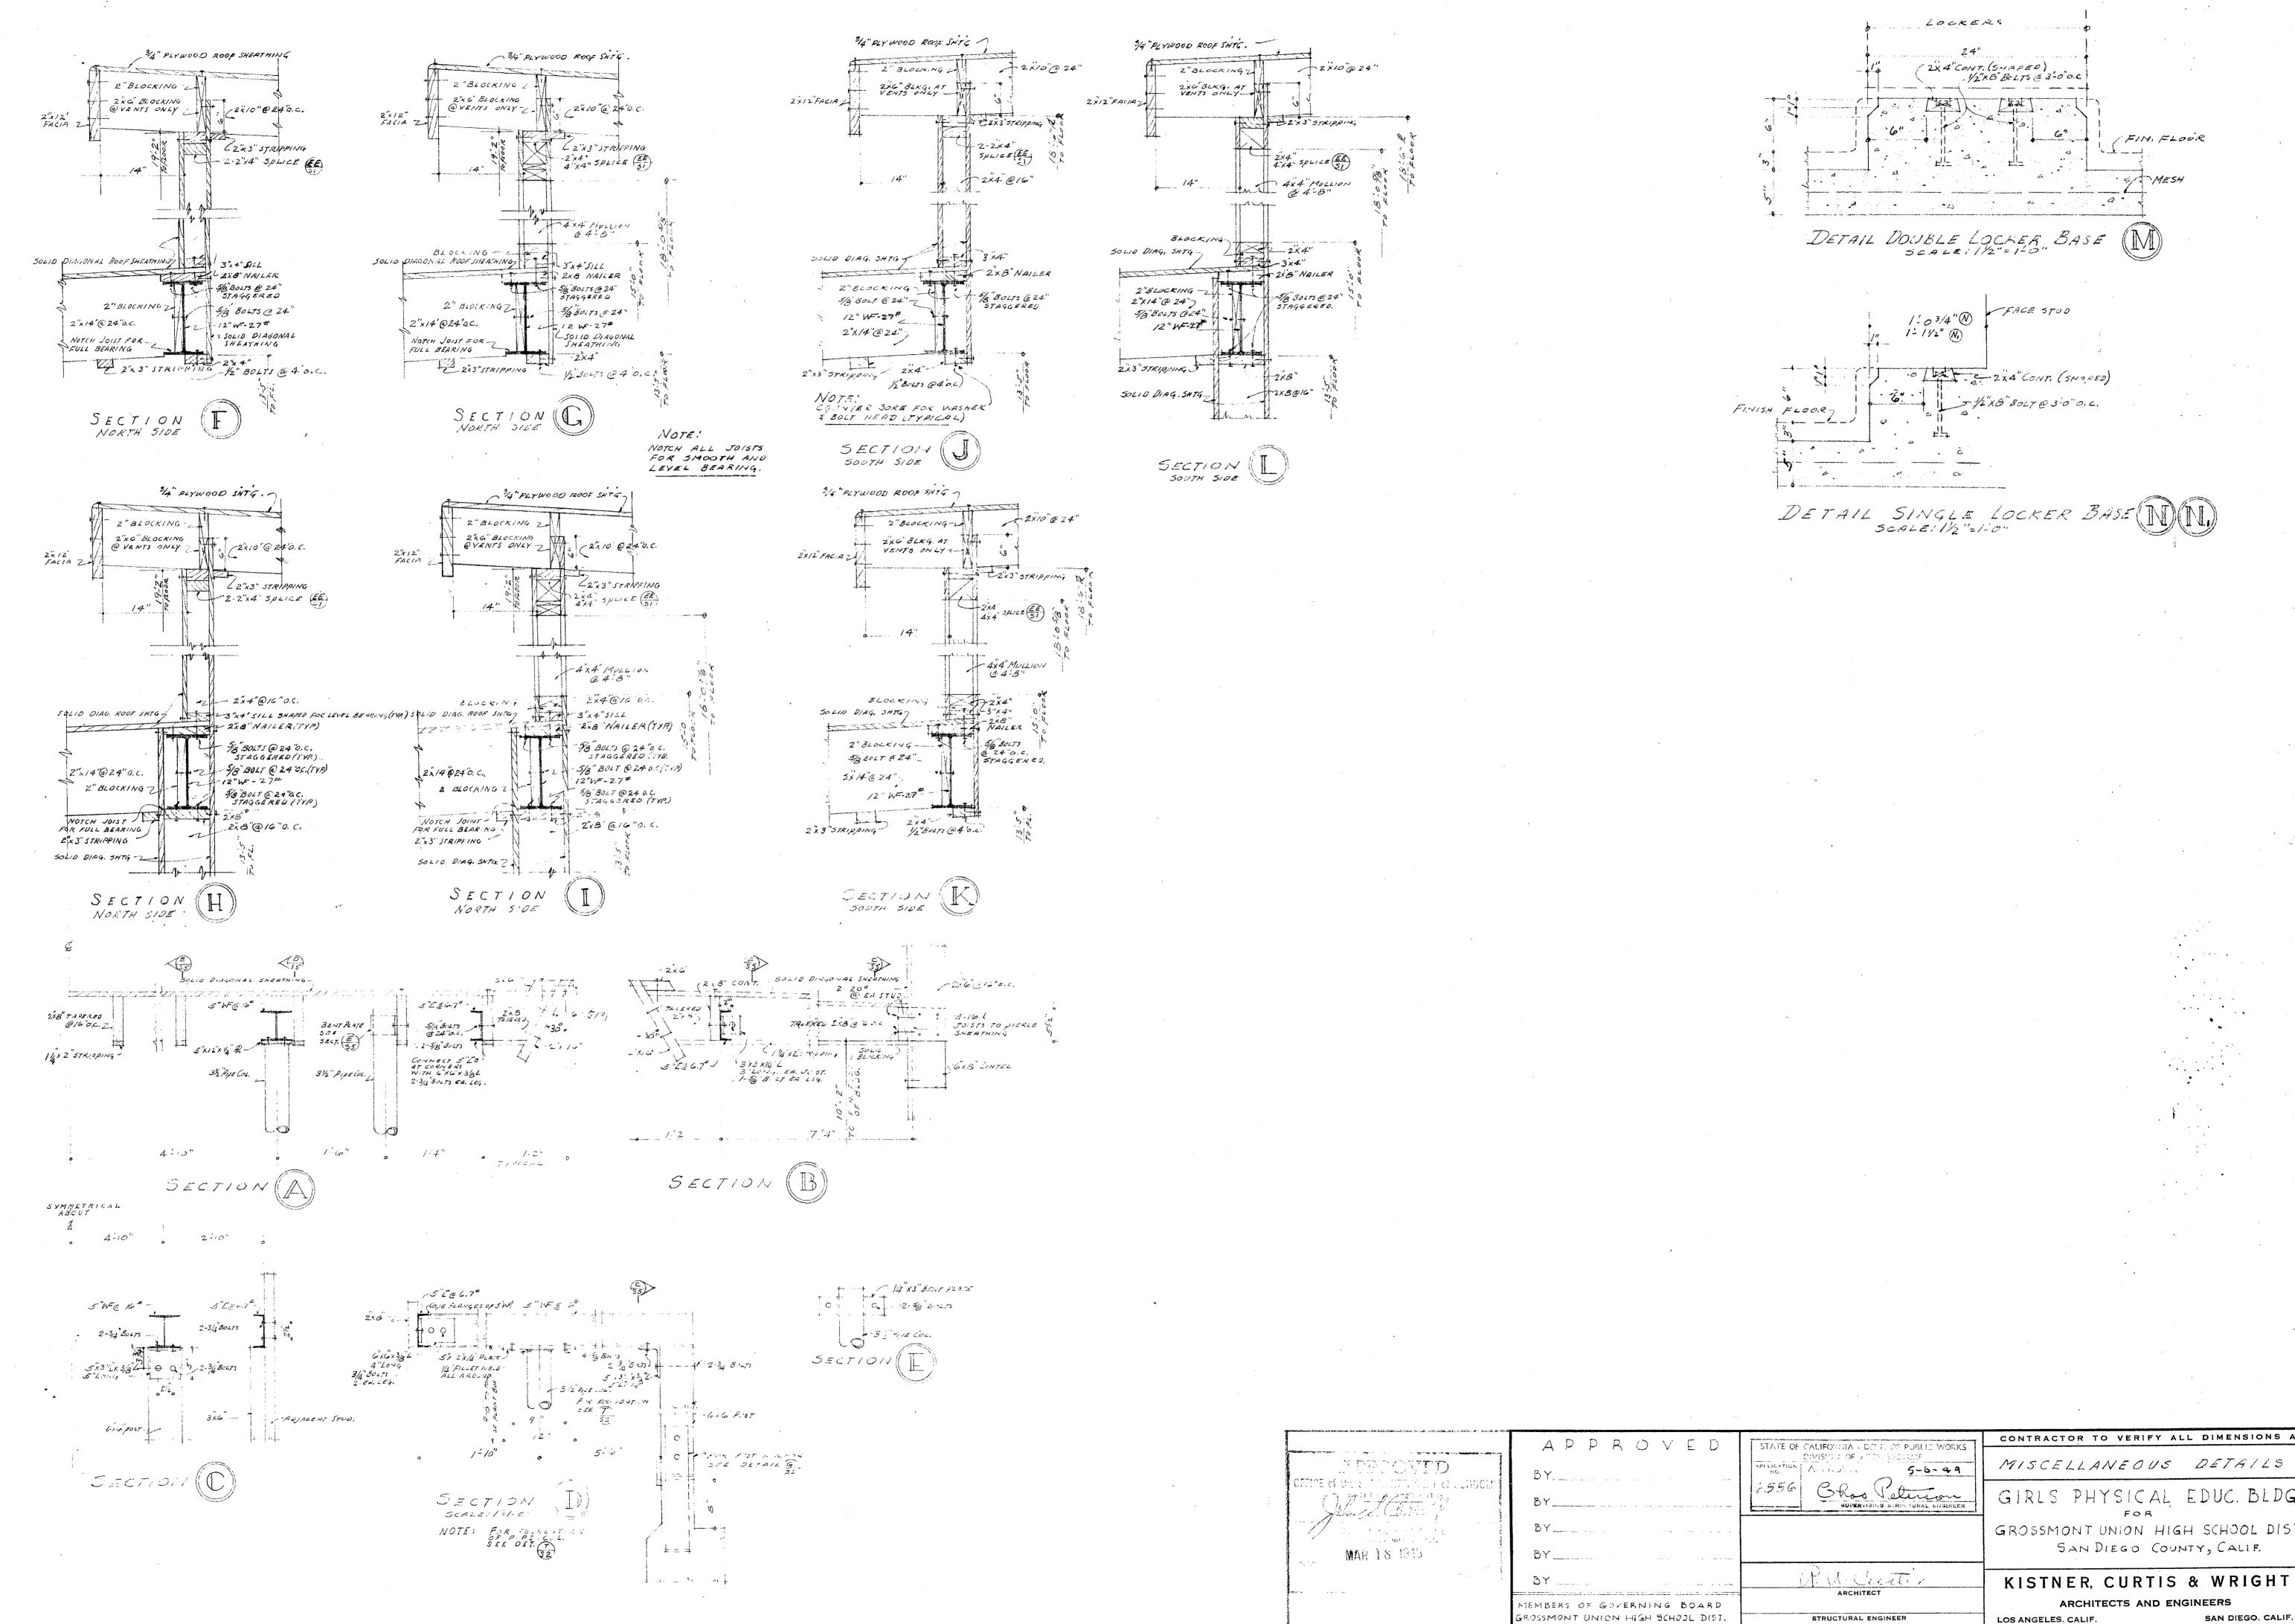

CONTRACTOR TO VERIFY ALL DIMENSIONS AT THE JOB R.M.D. GIRLS PHYSICAL EDUC. BLDG.


SAN DIEGO COUNTY, CALIF.


SAN DIEGO, CALIF.

ARCHITECTS AND ENGINEERS

FIM. FLOOR

MESH

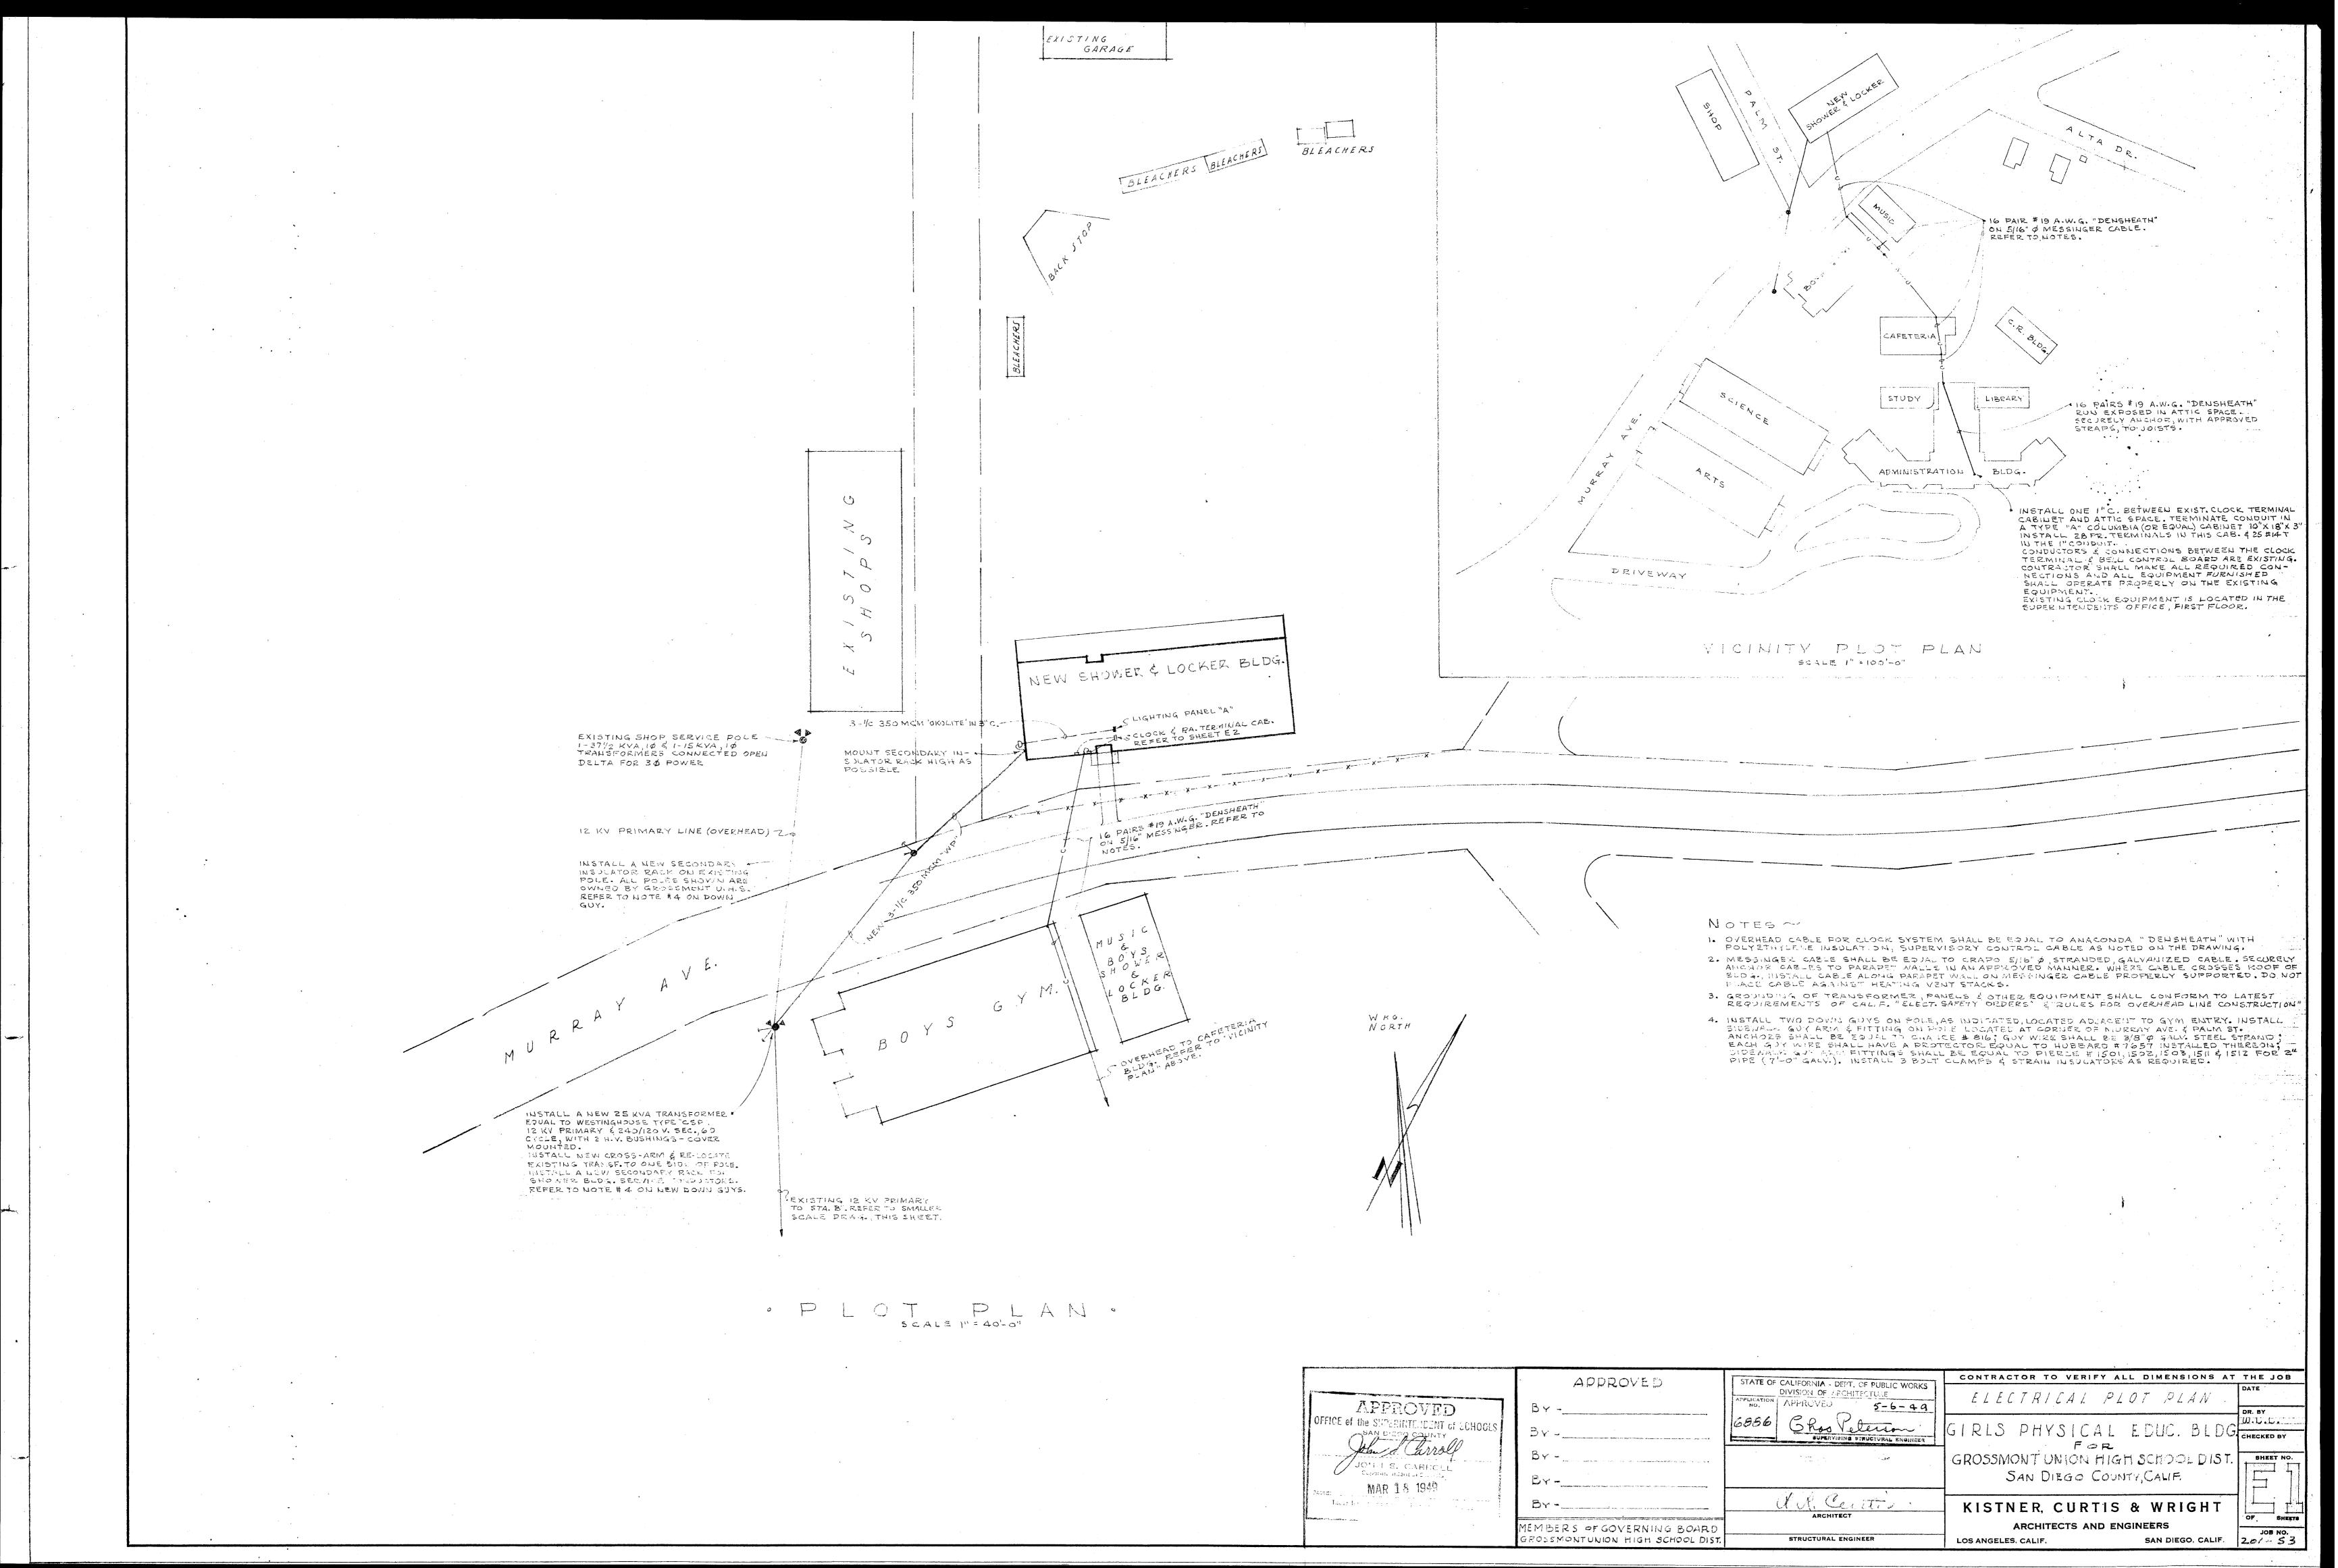

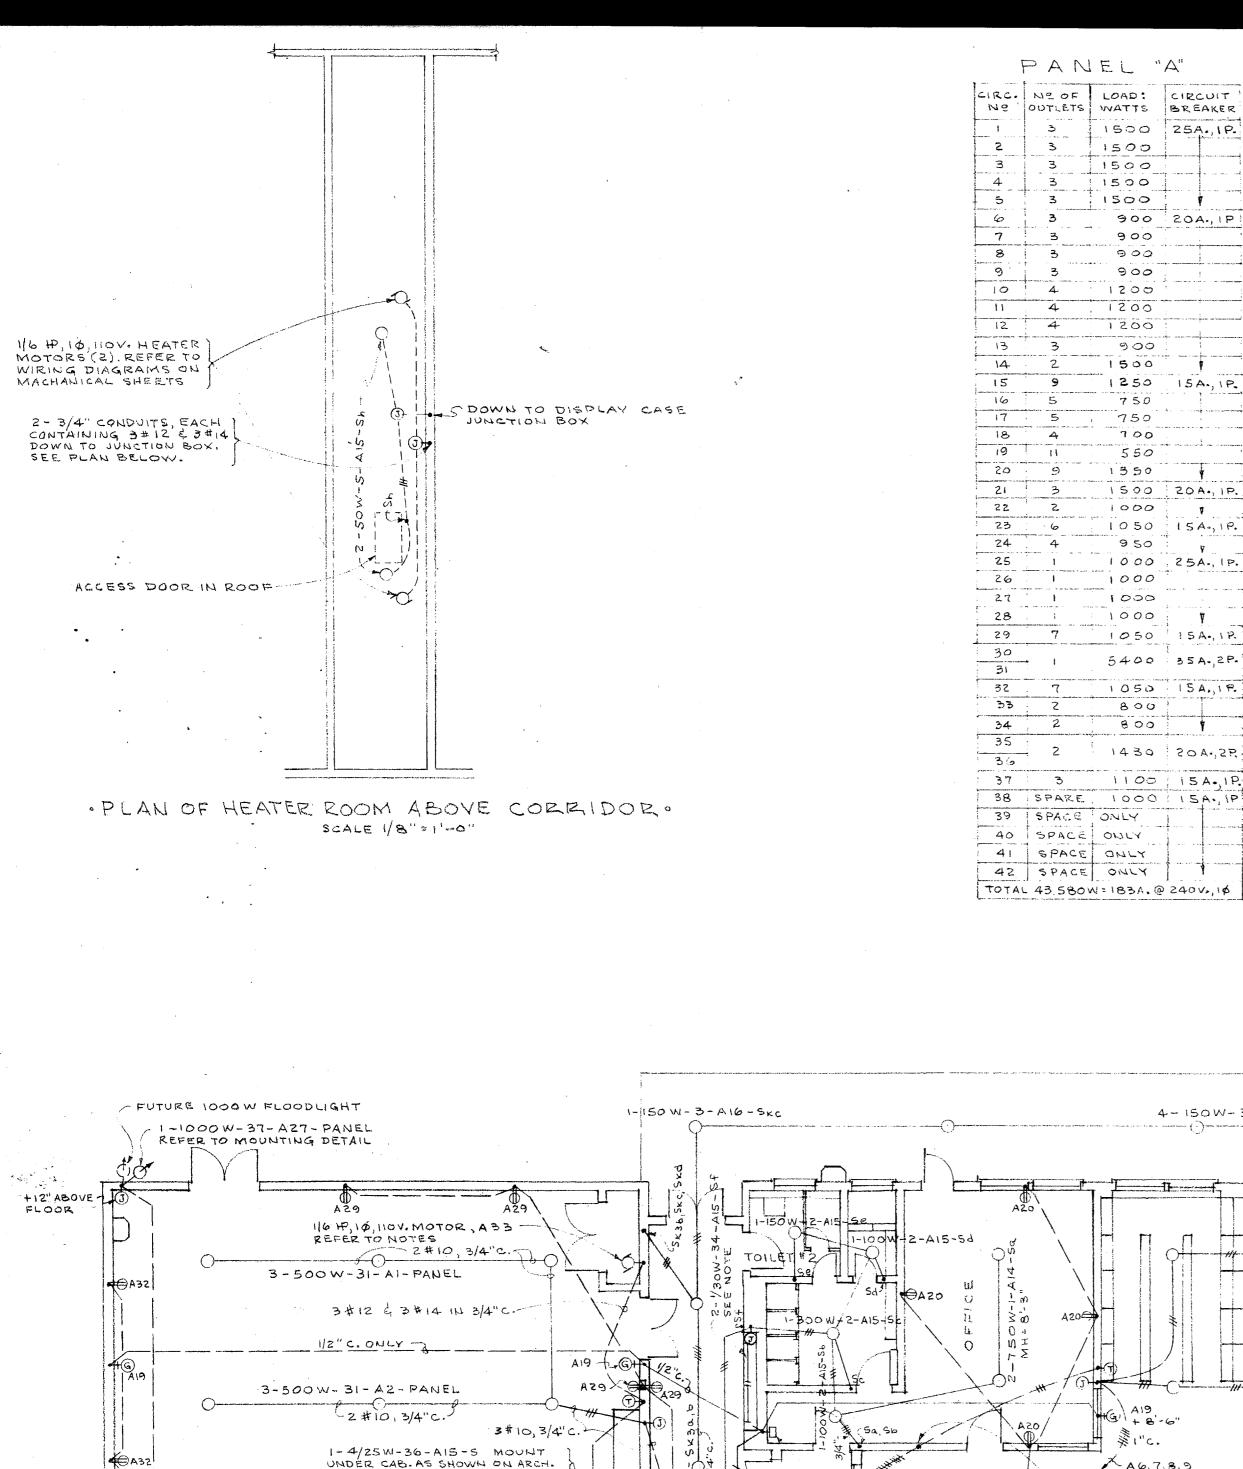

14

23

25

26

27

32

33 :

34

37

800

800


38 SPARE 1000 154. 1P


39 SPACE ONLY

40 SPACE ONLY 41 SPACE ONLY 42 SPACE ONLY

1430 20A,2P

1100 | 15 A. IP.

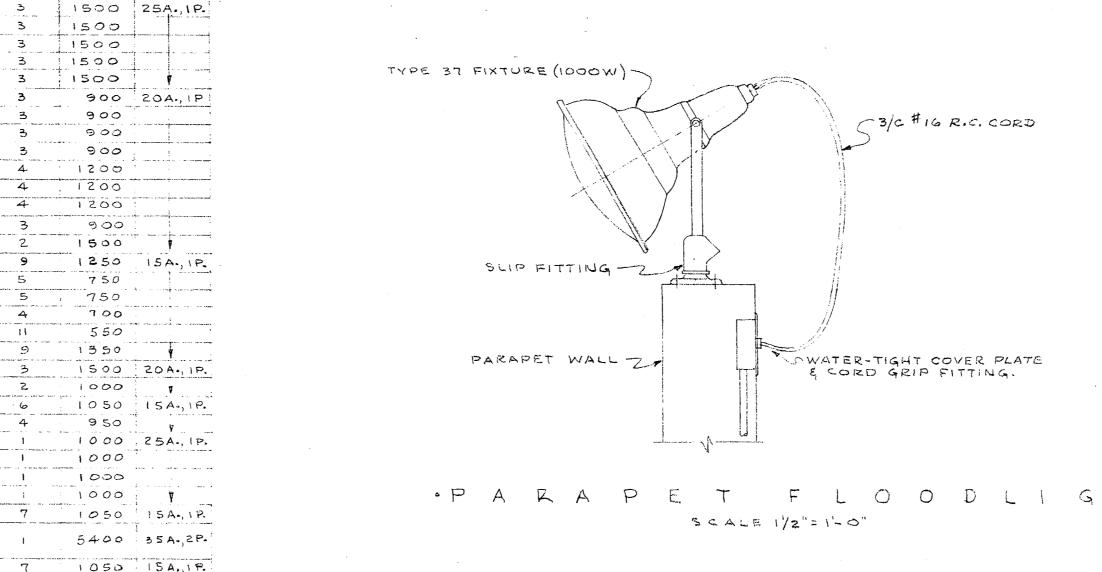

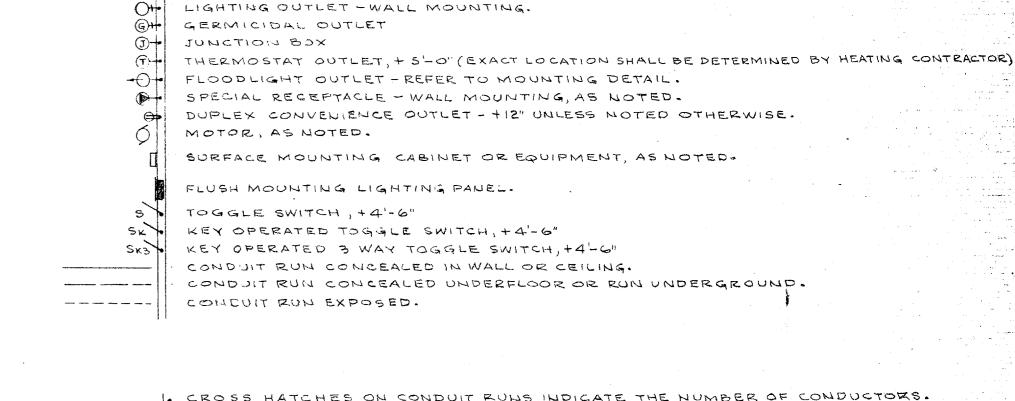

LIGHTING OUTLET - IN CEILING .

UNLESS HOTED AS LARGER.

1. CROSS HATCHES ON CONDUIT RUNS INDICATE THE NUMBER OF CONDUCTORS. 2. CONDUIT RUNS WITHOUT CROSS HATCHES SHALL BE 2 4 12 A.W.G. IN I/Z"CONDUIT. 3. MINIMUM WIRE SIZE FOR 120 OR 240 VOLT WIRING SHALL BE # 12 A.W.G. UNLESS NOTED OTHER-

5. SUBSCRIPTS OF a,b,c, ETC. AT SWITCH SYMBOLS ARE TO DIFFERENTIATE SWITCHES. 6. +4-6" INDICATES MOUNTING HEIGHT OF 4-6" FROM FLOOR TO CENTER OF OUTLET OR

EQUIPMENT. 7. 3-500 W-31-A1-PANEL, AT A FIXTURE INDICATES : 3 = NUMBER OF FIXTURES ; 500 W=

WITH THE UNIT HEATERS & INSTALL THE SWITCHES AT LOCATIONS INDICATED.


WATTAGE PER FIXTURE ; 31 = FIXTURE TYPE ; A1 = CIRCUIT NUMBER ; PANEL = CIRCUIT CONTROLLED AT PANEL CIRCUIT BREAKER.

4. ALL CONDUIT SIZES SHALL CONFORM TO THE "CALIFORNIA ELECTRICAL SAFETY ORDERS"

8. MH = FIXTURE MOUNTING HEIGHT - FLOOR TO BOTTOM OF FIXTURE. 9. THE ELECTRICAL CONTRACTOR SHALL REMOVE THE TWO-SPEED SWITCHES FURNISHED

10. ALL TYPE 2 FIXTURES SHALL HAVE MOUNTING HEIGHT OF 101-0"

II. UNIT HEATER CONTROL WIRING SHALL BE INSTAULED AS INDICATED ON WIRING DIAGRAMS - REFER TO HEATING PLANS.

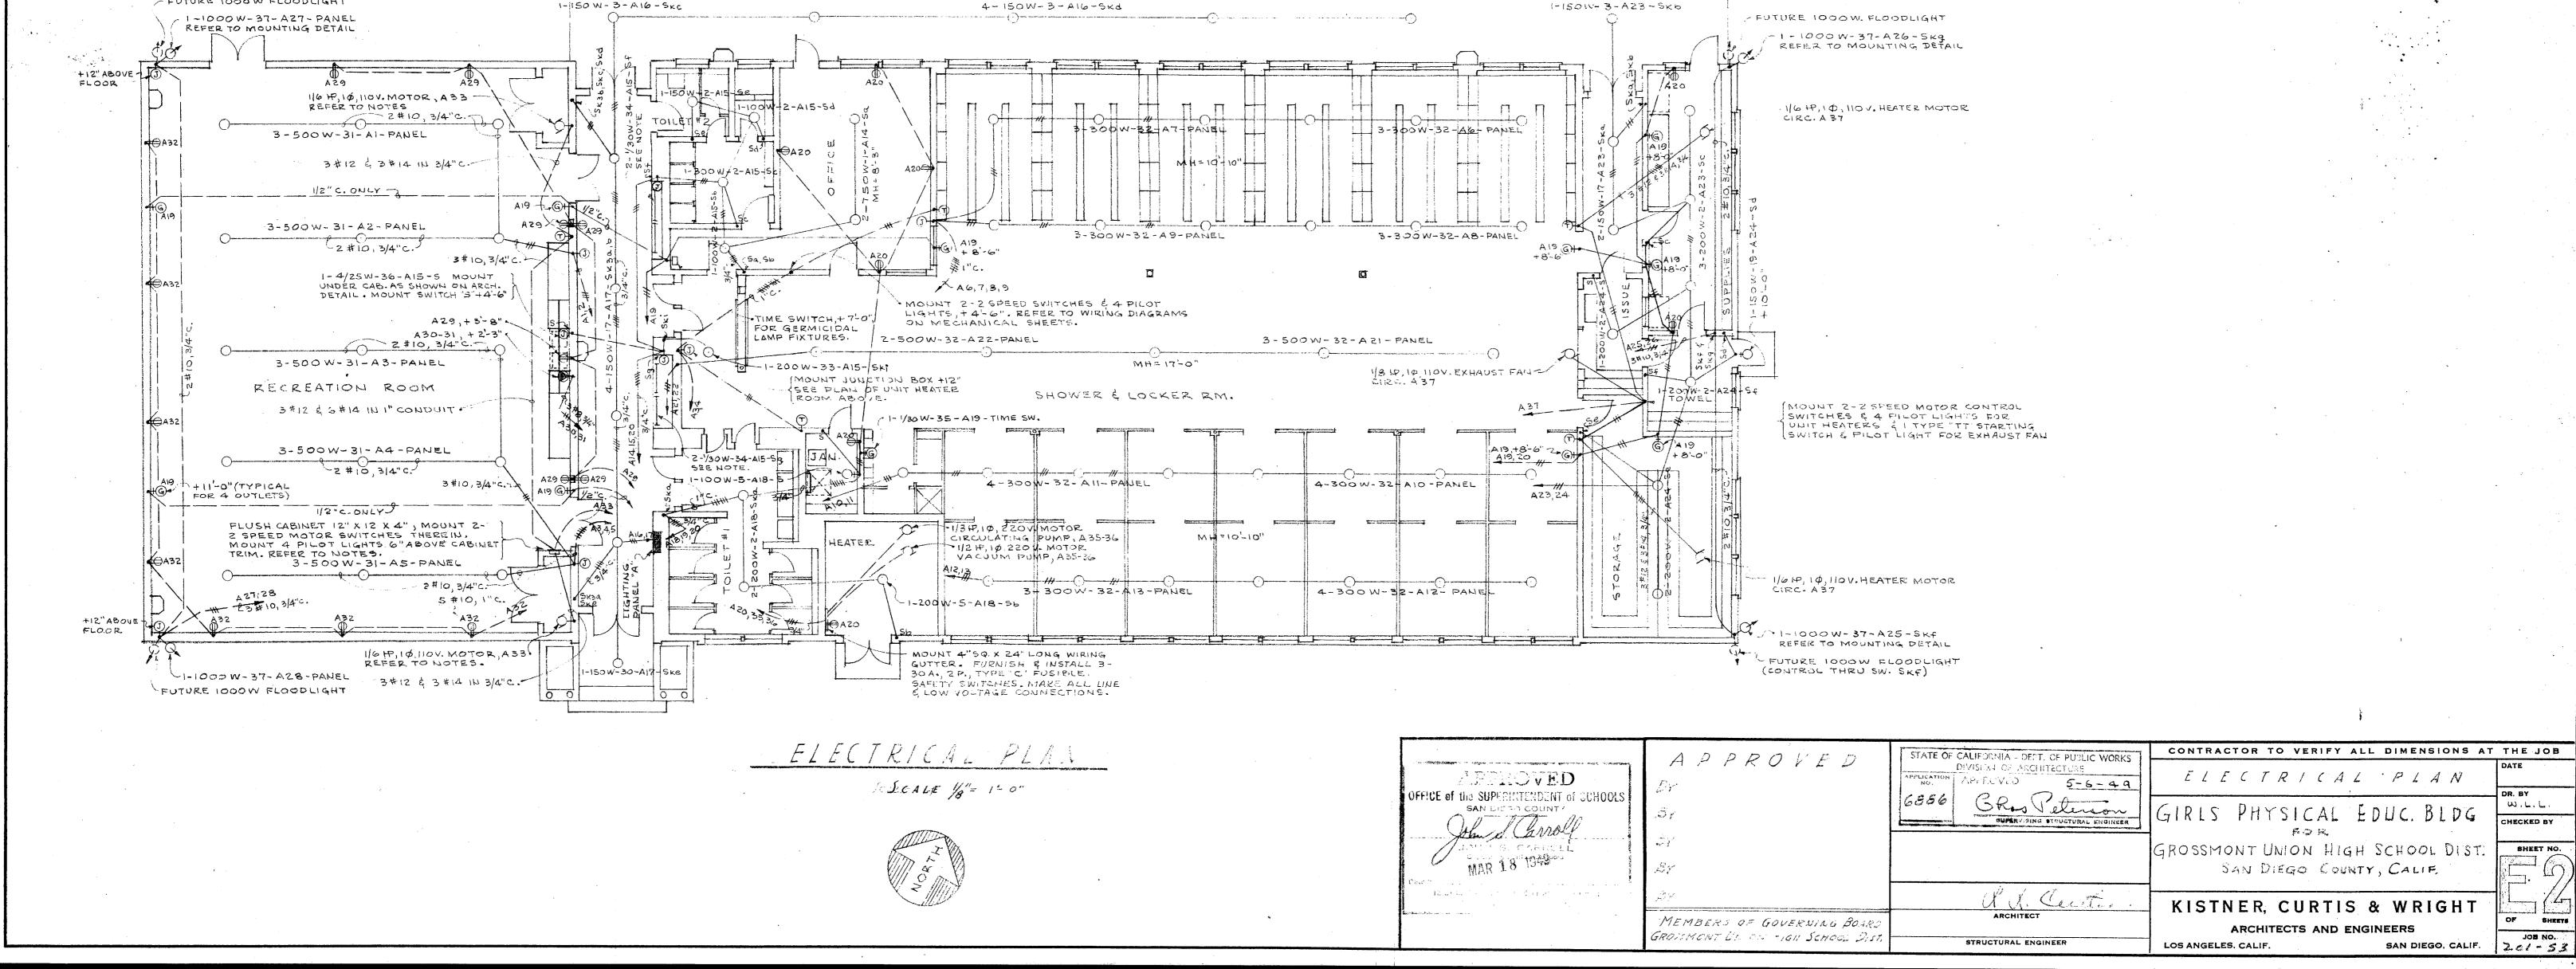

PUBLIC ADDRESS SPEAKER OUTLET, +11-0" UNLESS NOTED OTHERWISE. PUBLIC TELEPHONE OUTLET, + 12".

YARD HORN , DUAL PROJECTOR; MOUNT AS NOTED.

Of CORRIDOR BELL MOUNT AS NOTED.

SECONDARY CLOCK, +9'-0" UNLESS NOTED OTHERWISE.

BREAK - GLASS FIRE REPORTING STATION, + 4'-6" JUNCTION BOX, + 12" UNLESS NOTED OTHERWISE.

- A- PUBLIC ADDRESS SYSTEM CONDUIT. ----- PROGRAM CLOCK SYSTEM CONDUIT.


--- T--- PUBLIC TELEPHONE SYSTEM CONDUIT.

1. REFER TO PLOT PLAN FOR CONNECTIONS TO MAIN BLDG. EQUIPMENTS. 2. THE TERMINAL CABINET SHALL HAVE A METAL PARTITION OR BARRIER BETWEEN THE P.A. & CLOCK SYSTEMS. THE FOULDWING TERMINALS SHALL BE INSTALLED IN THE CABINET: 21 TWO WAY FOR PUBLIC ADDRESS & 21 TWO WAY FOR THE CLOCK SYSTEM.

BE GROUNDED BY A # 6 BARE COPPER CONDUCTOR CONNECTED TO NEAREST COLD WATER PIPE.

4. OMIT THE BUZZER IN THE RECREATION RM. & SHOWER RM. CLOCKS.



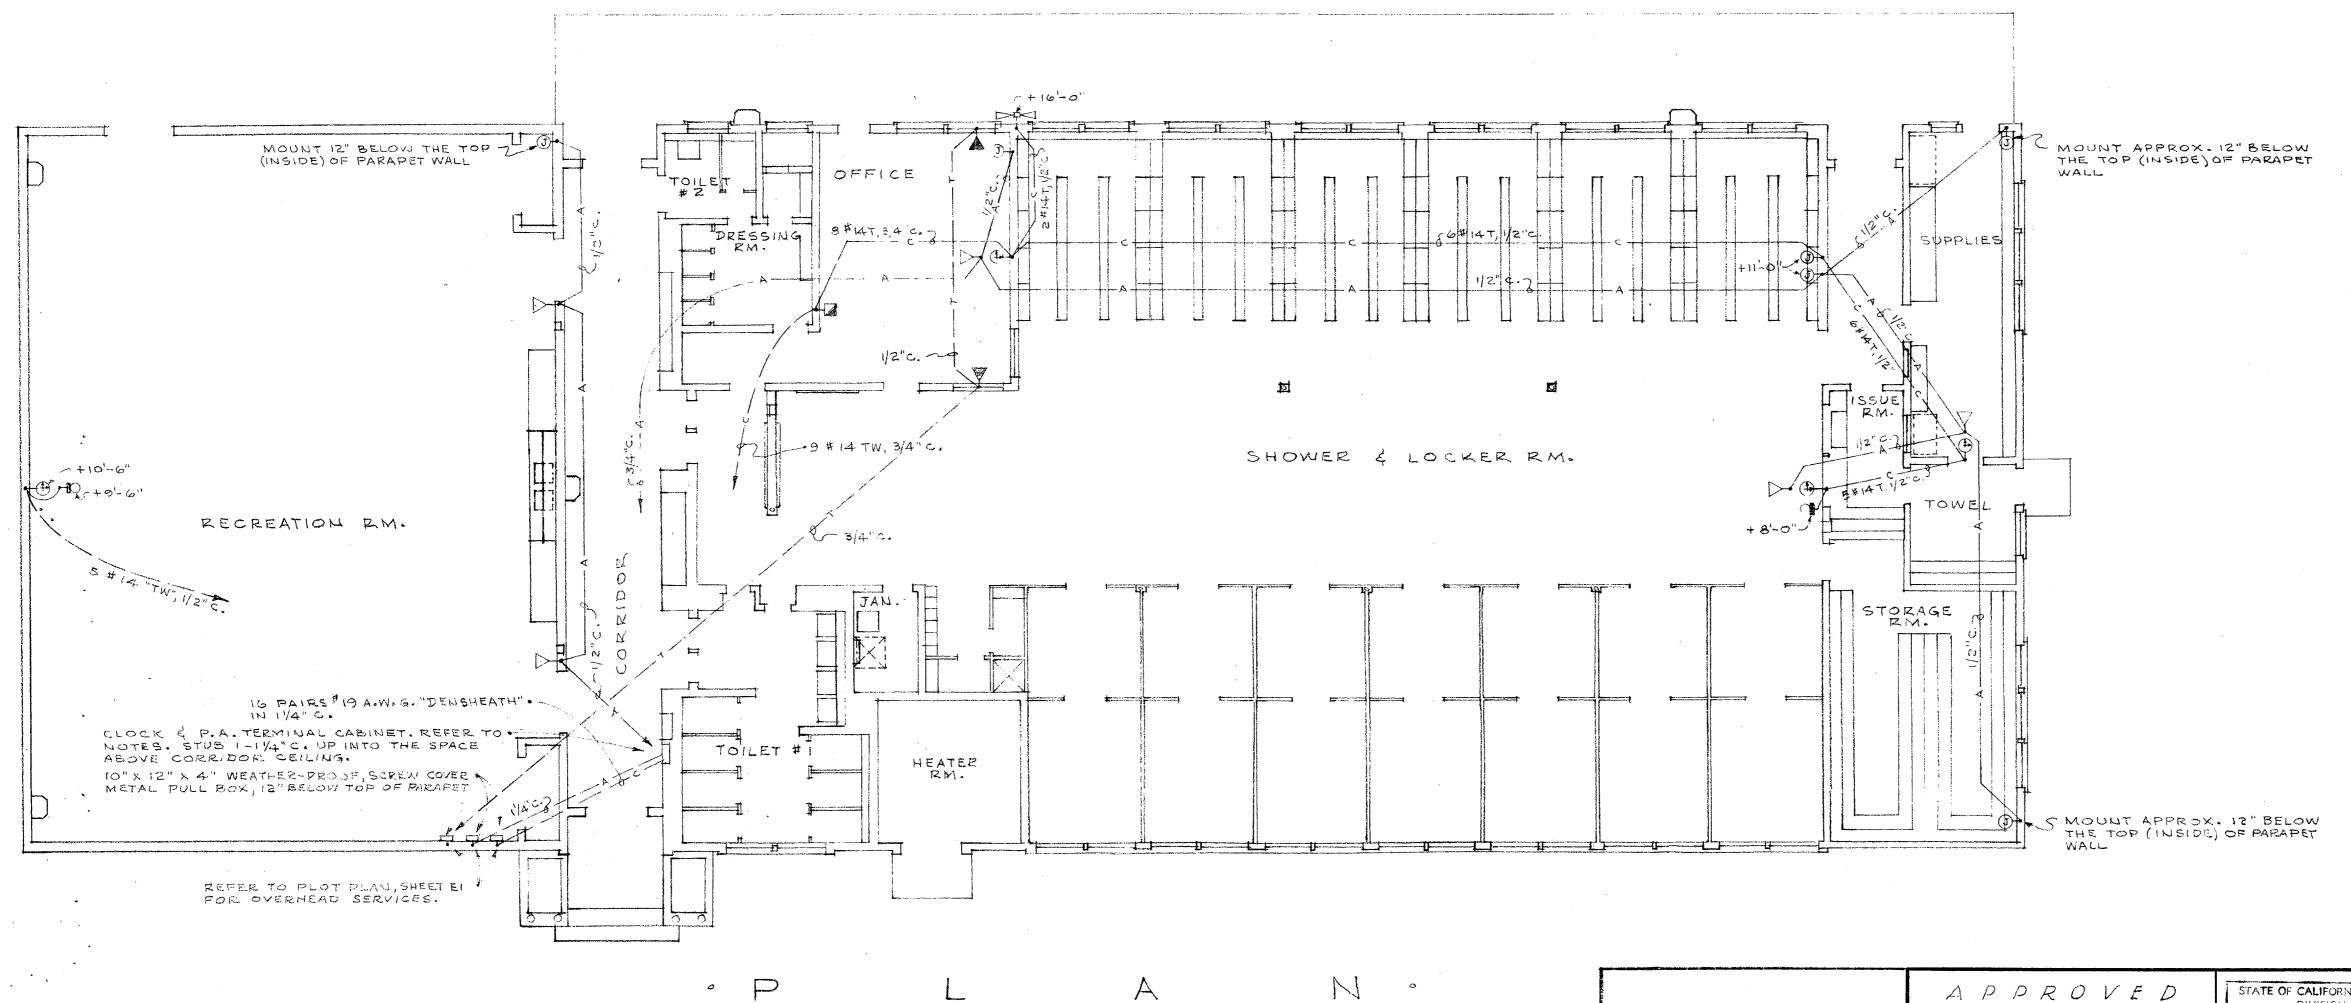

SCALE 1/8'=1'-0"

CPPLOVED OFFICE of the SUPERINTEREDIAT of CUHOOLS SAN FAL TO COMMITY

APPROVED MEMBERS OF GOVERNING BOARD

GROSSMONT UNION HIGH SCHOOL DIST.

STATE OF CALIFORNIA - DEPT. OF PUBLIC WORKS DIVISION OF ARCHITECTURE PUBLIC ADDRESS SYSTEM, SIGNAL & COMMUNICATIONS PLAN 5-6-49

STRUCTURAL ENGINEER


GIRLS PHYSICAL EDUC. BLDG. GROSSMONT UNION HIGH SCHOOL DIST. SAN DIEGO COUNTY CALIF.


CONTRACTOR TO VERIFY ALL DIMENSIONS AT THE JOB


KISTNER, CURTIS & WRIGHT ARCHITECTS AND ENGINEERS


LOS ANGELES. CALIF.

SAN DIEGO, CALIF.

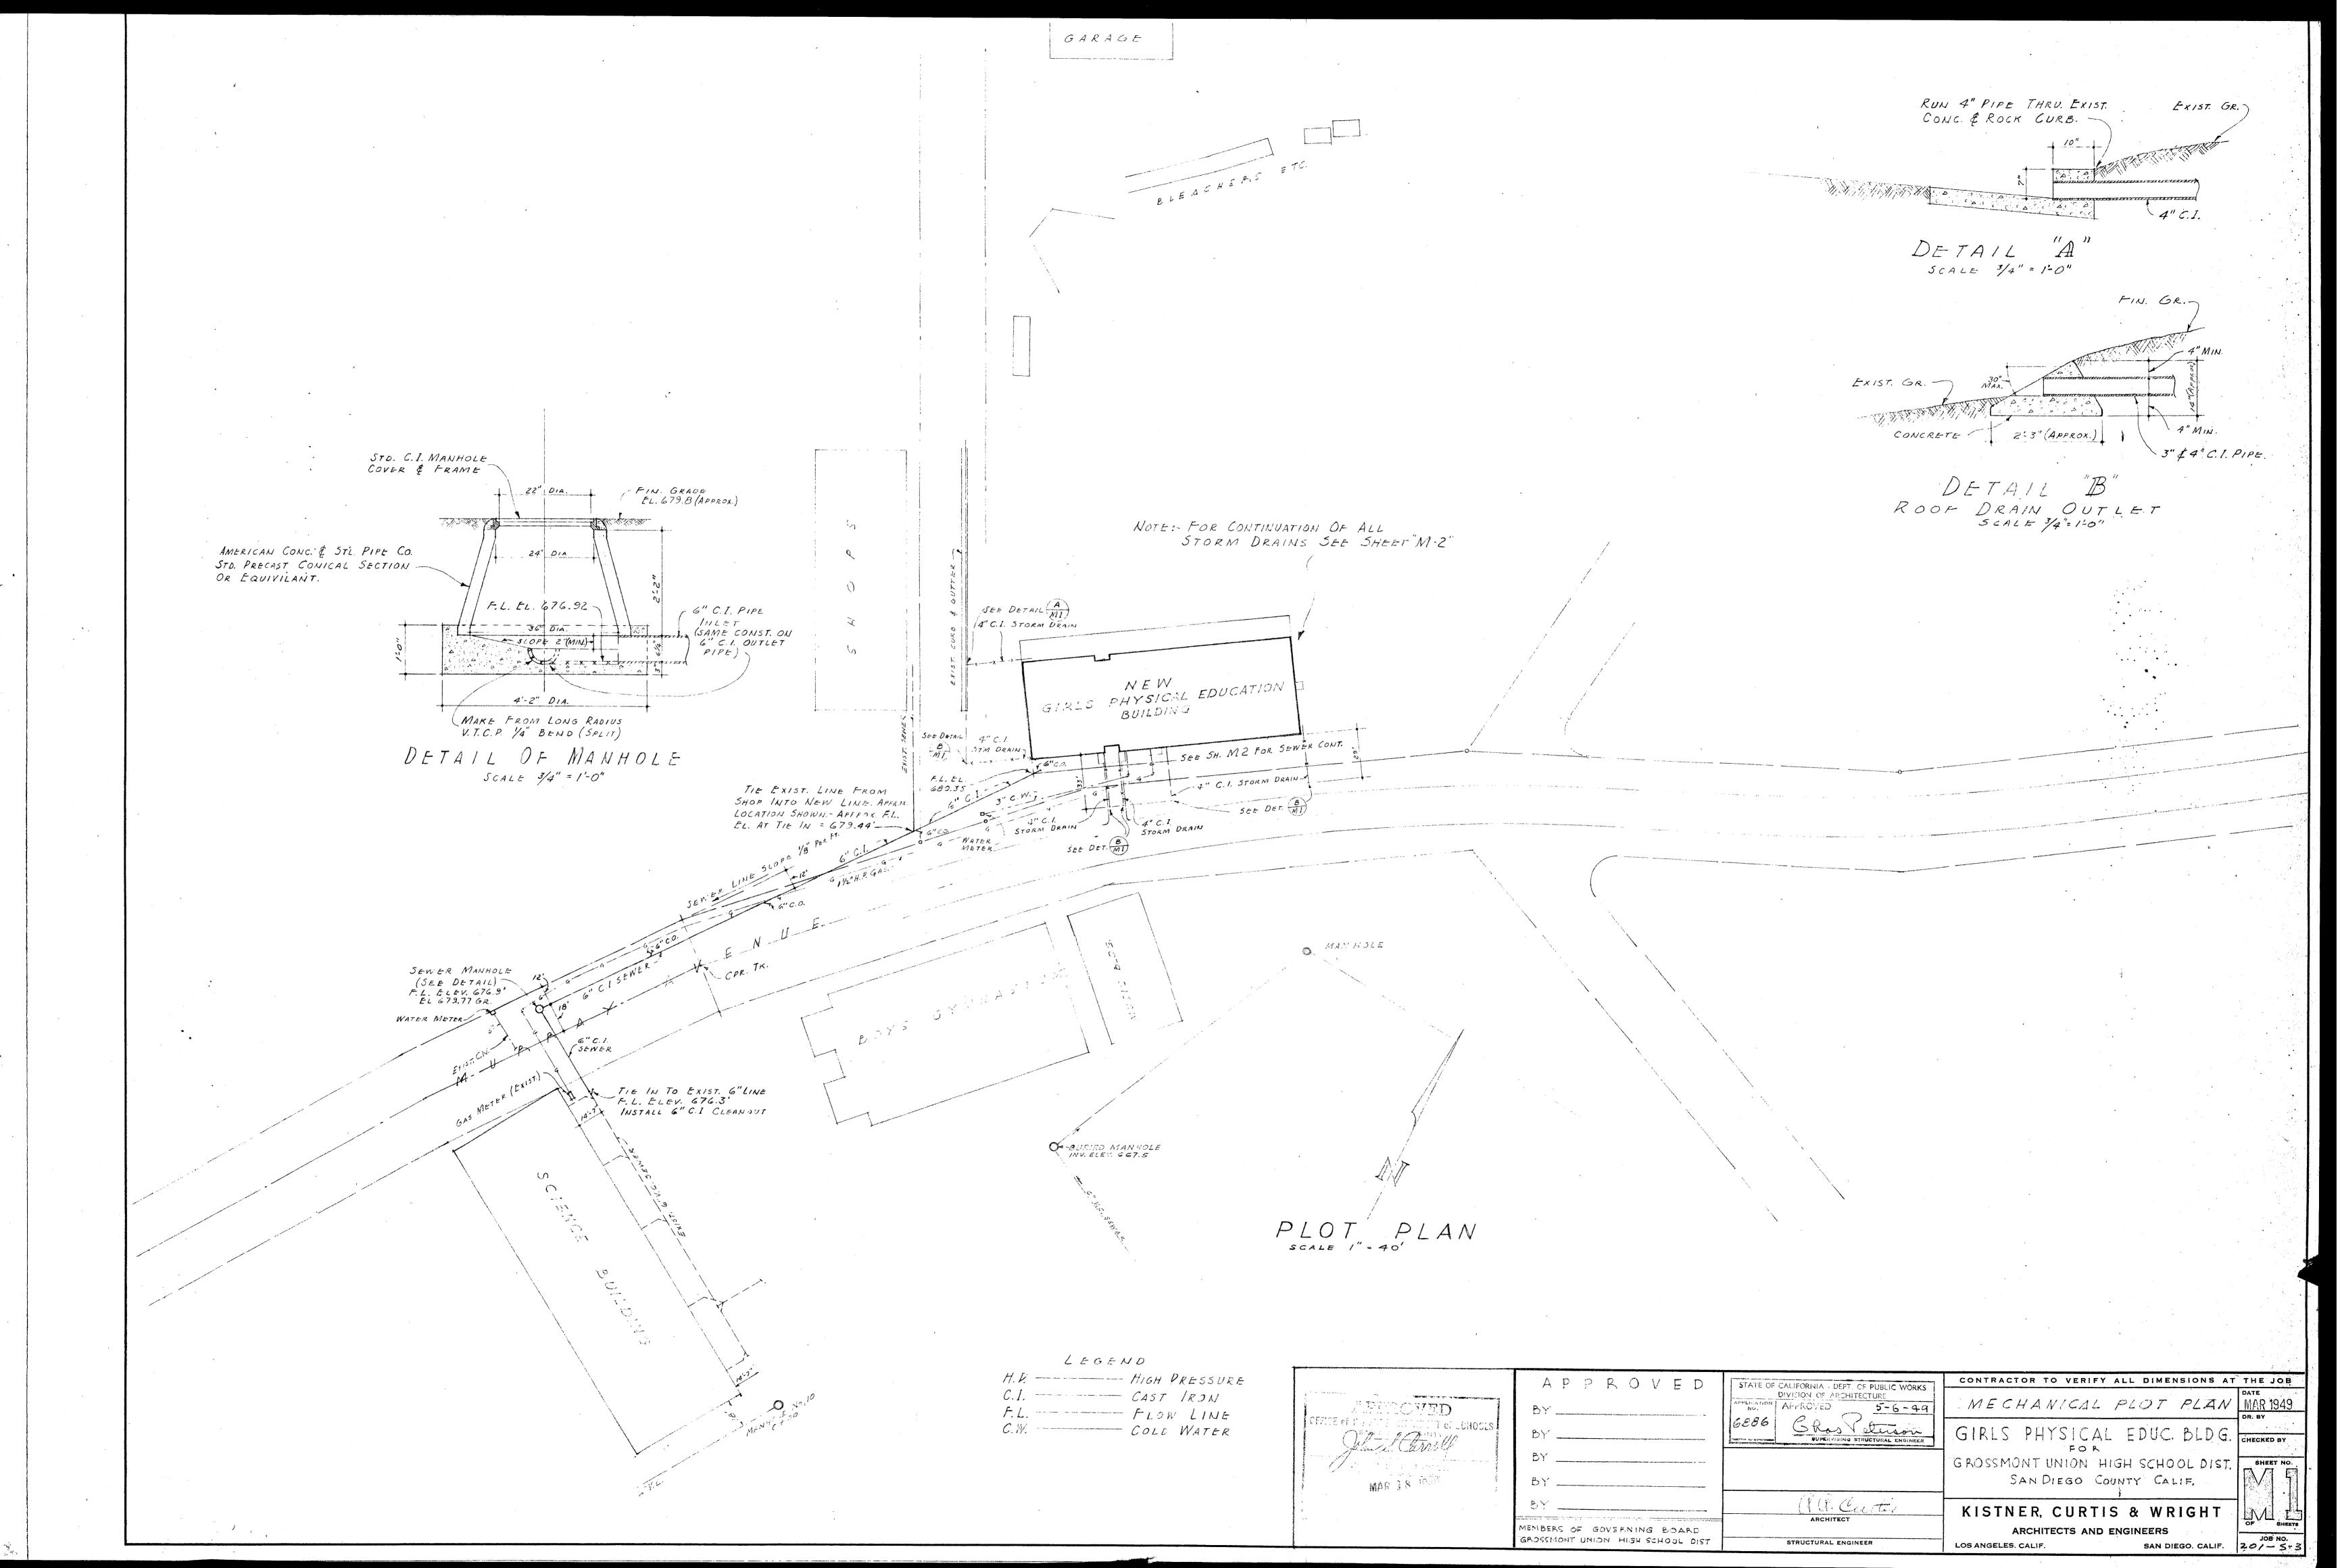

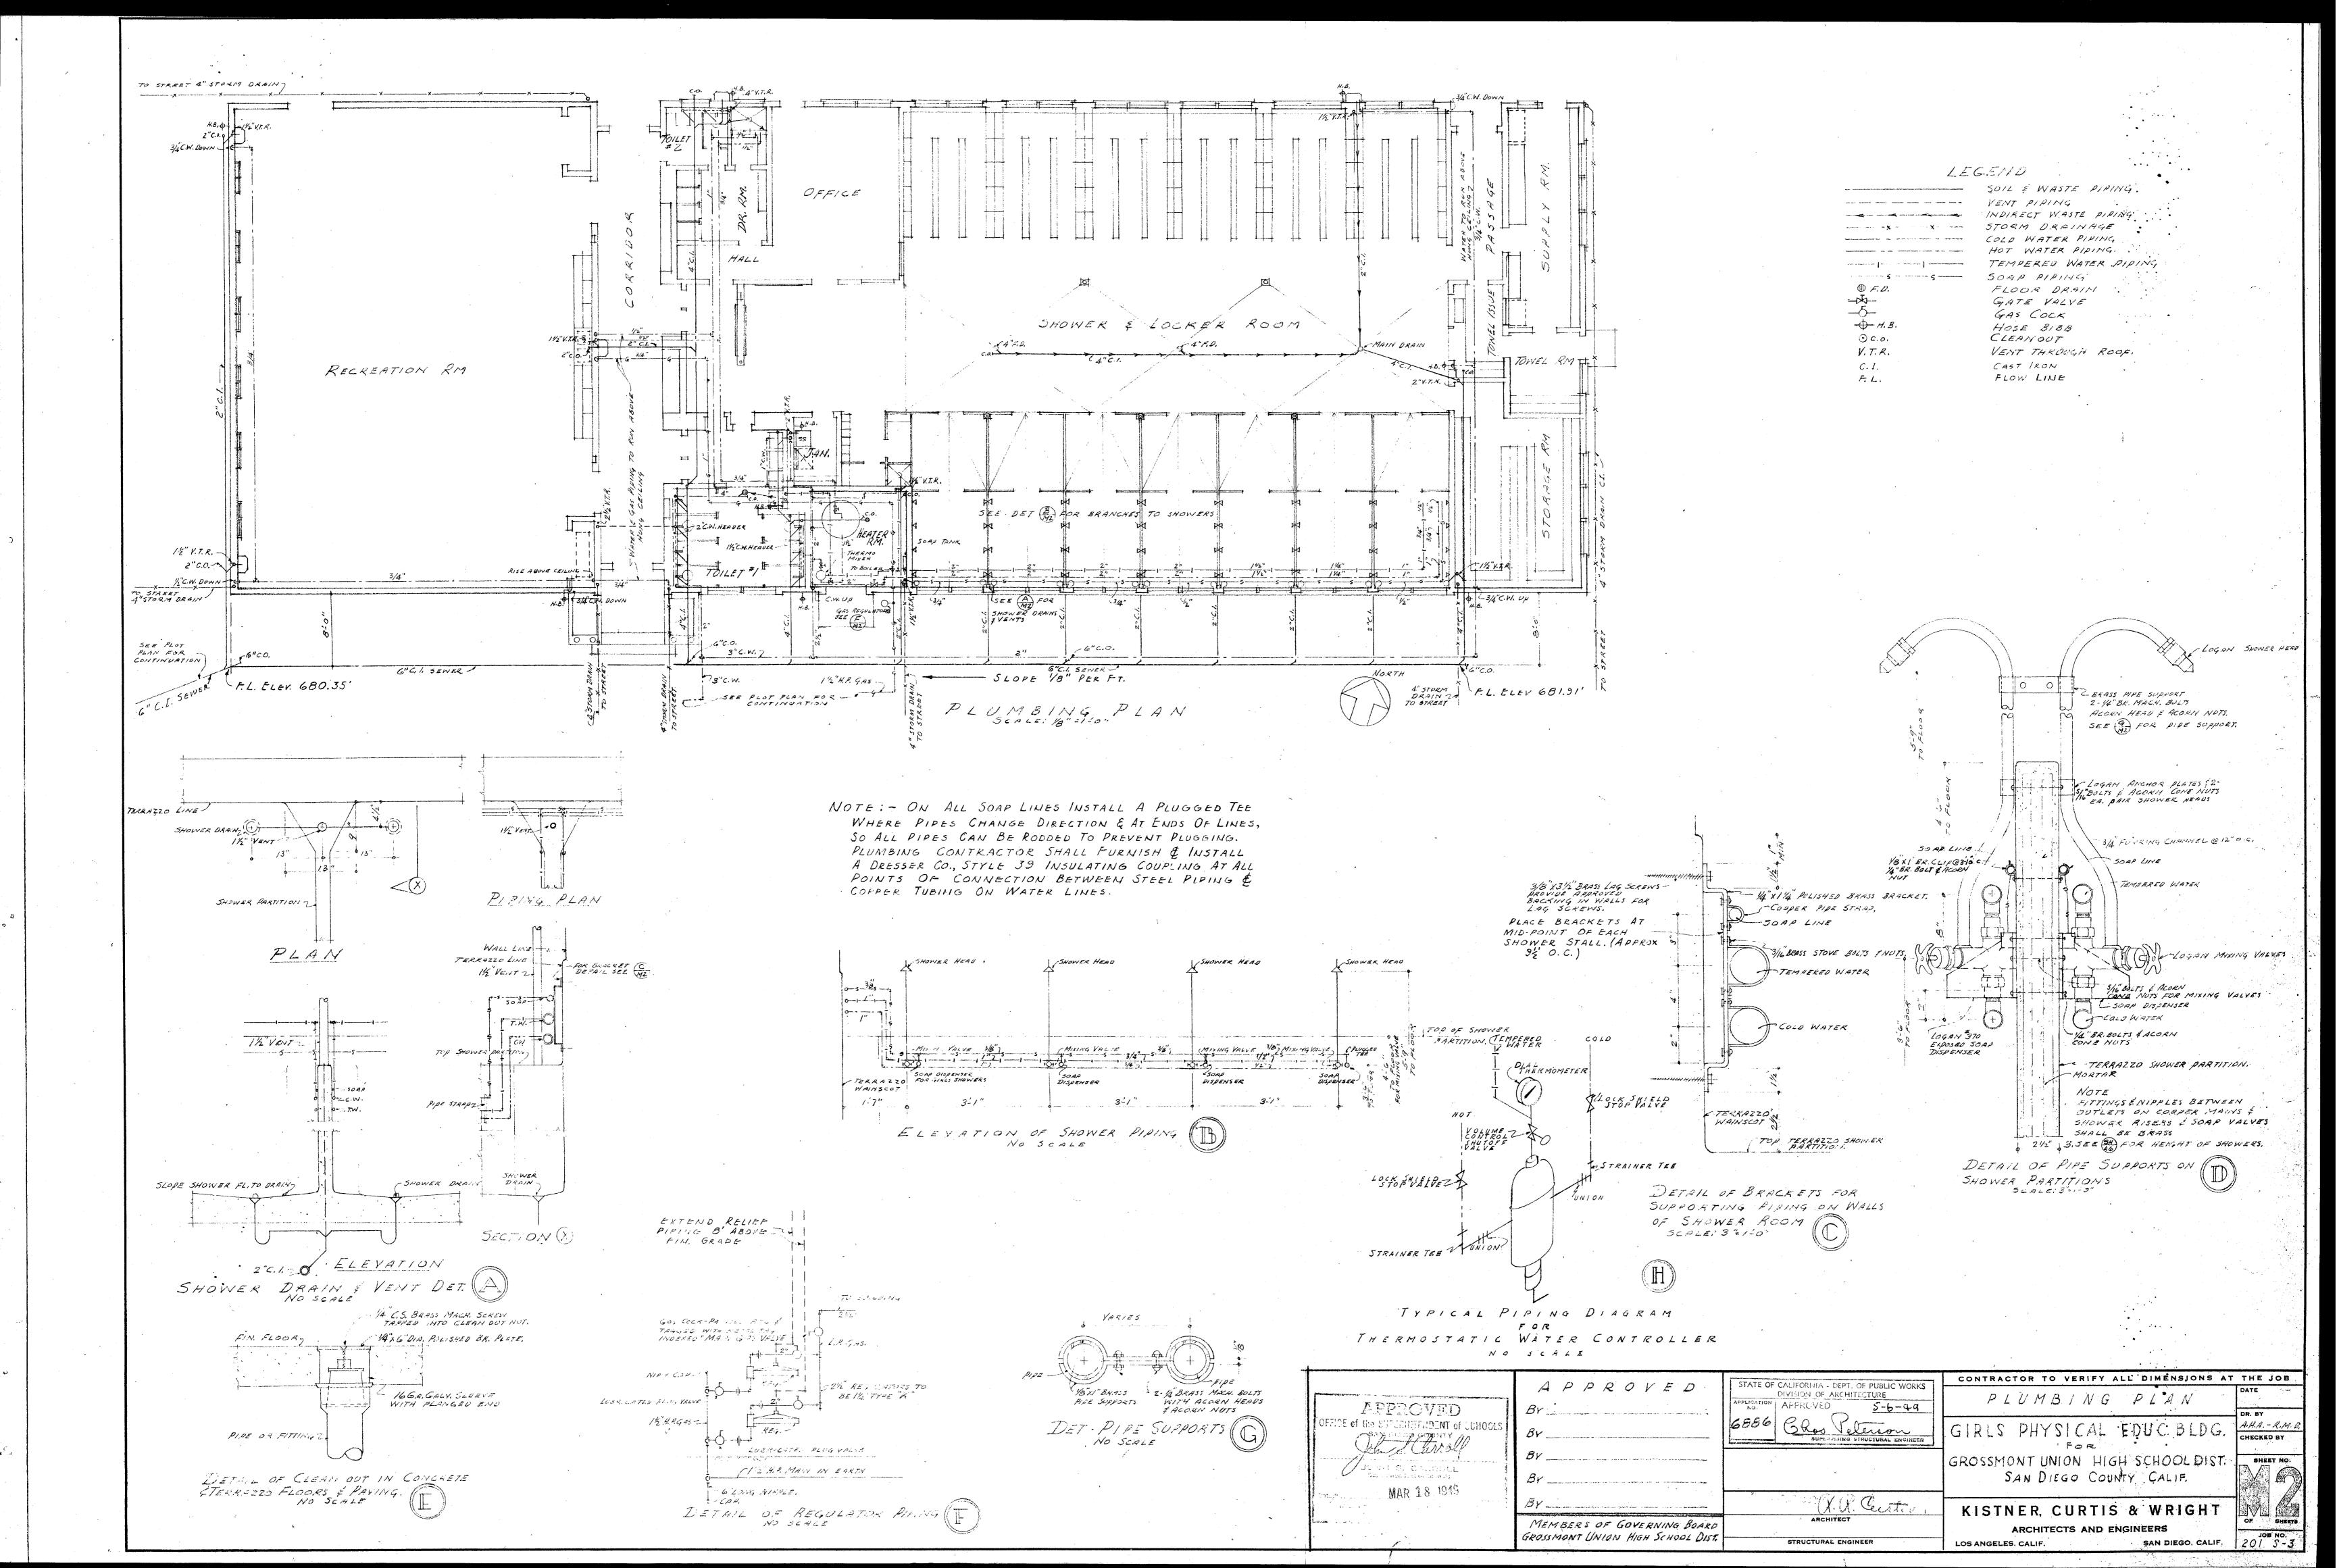

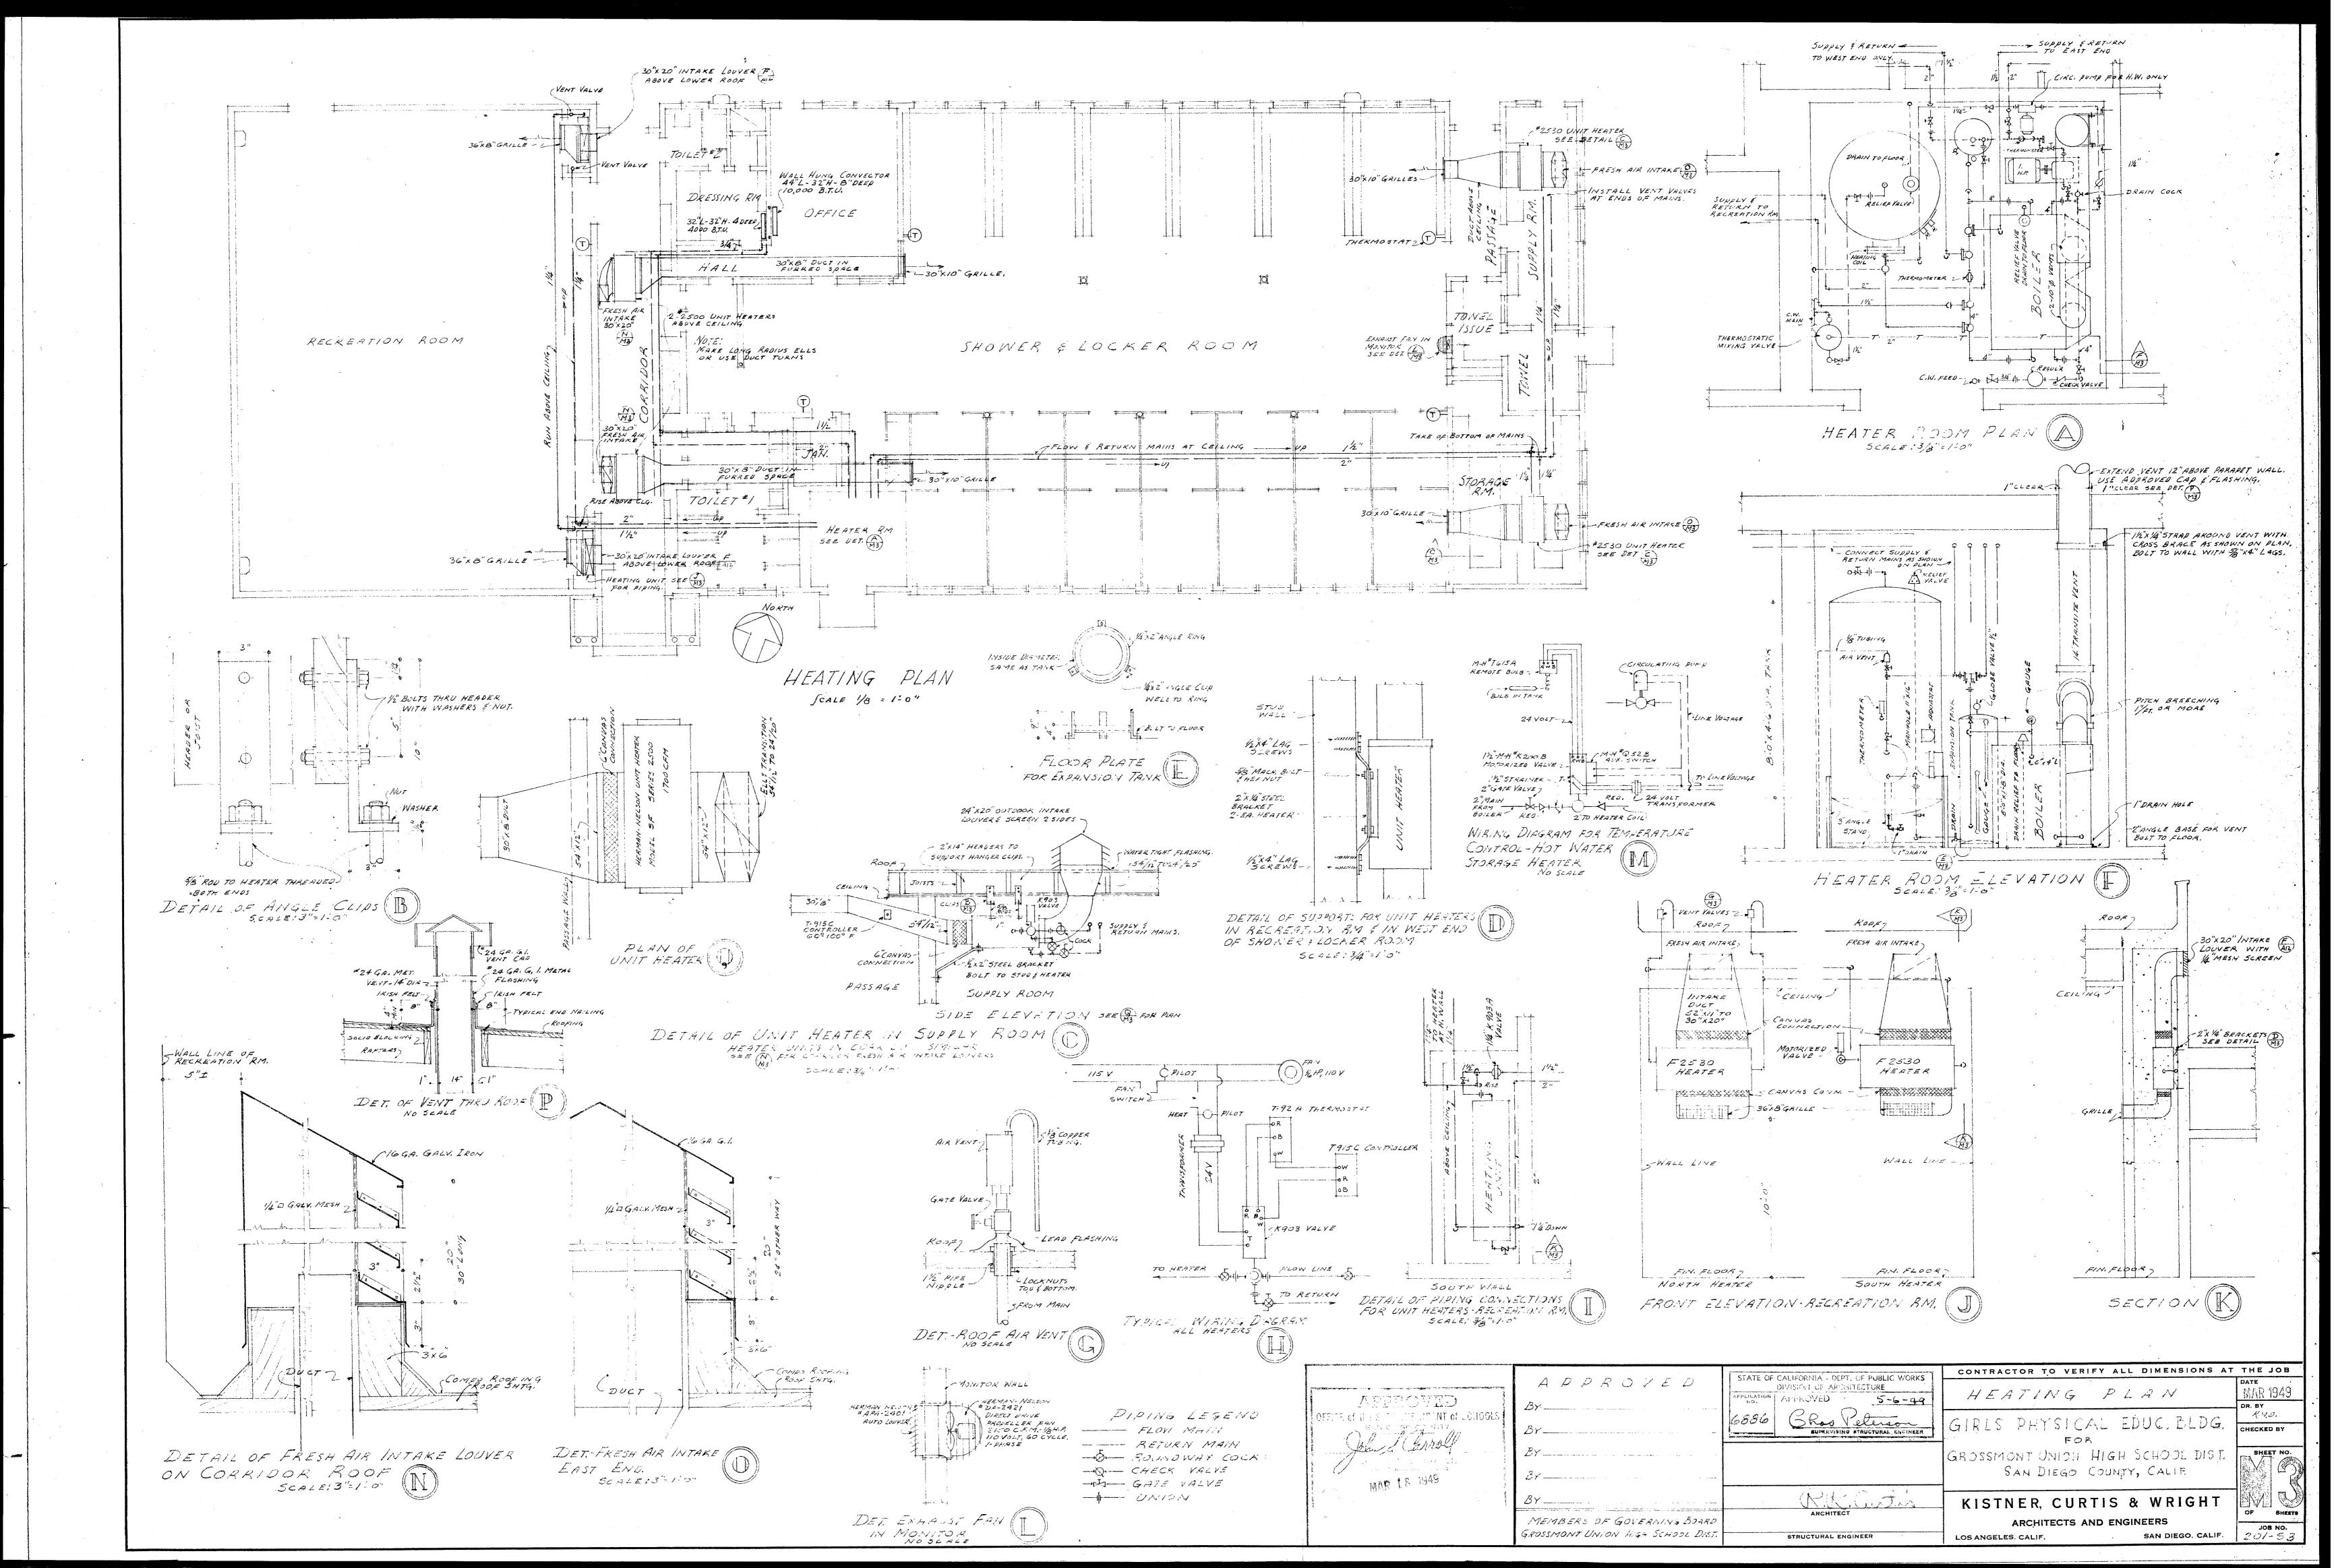

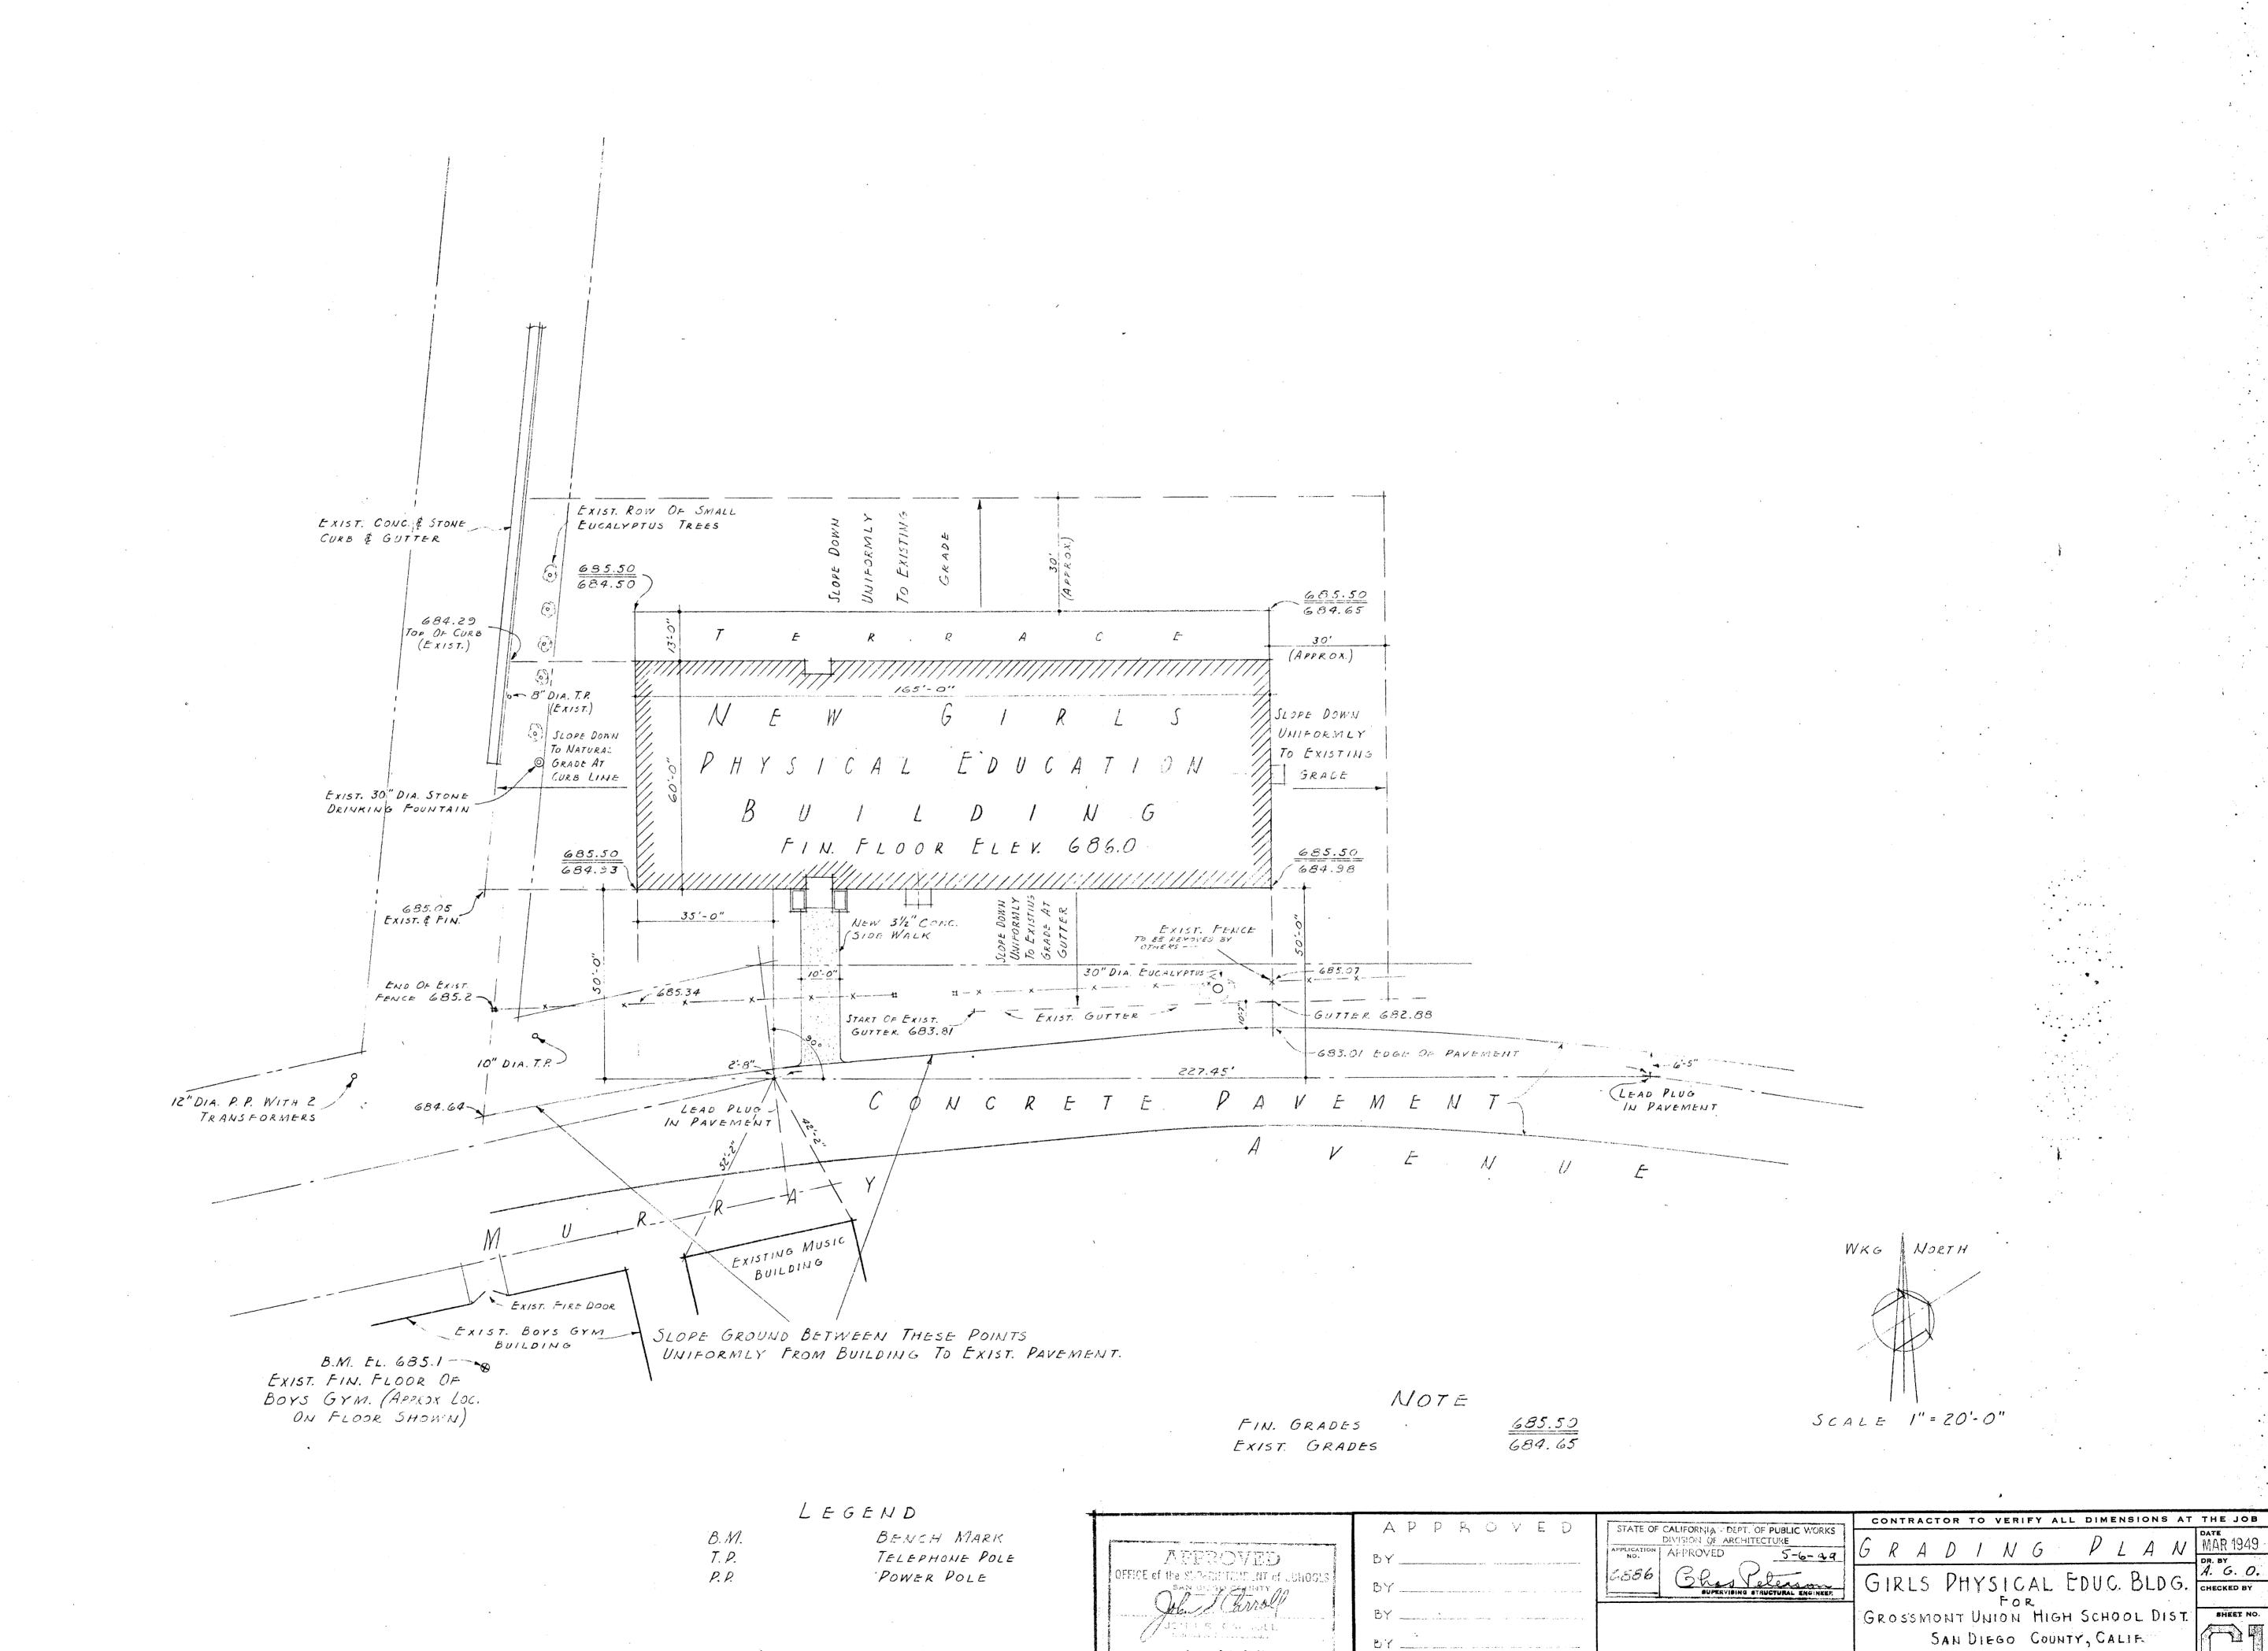

KISTNER, CURTIS & WRIGHT

ARCHITECTS AND ENGINEERS SAN DIEGO, CALIF. 201-5-3 LOS ANGELES, CALIF.

A.V. Cectar


STRUCTURAL ENGINEER

MEMBERS OF GOVERNING BOARD

GROSSMONT UNION HIGH SCHOOL DIST.

INTENTIONALLY LEFT BLANK

FERENCE KEYNOTES	BUIL	LDING MASTER KEYNOTES LIST		ILDING MASTER KEYNOTES LIST	APPLICABLE CODES		SHEET INDEX V	/UL. 1	
SION 01 - GENERAL	03 30 00.01	CAST IN PLACE COLORED CONCRETE	10 28 13.01 10 28 13.02 10 28 13.03	RECESSED TOILET TISSUE DISPENSER SURFACE MOUNTED SOAP DISPENSER RECESSED ELECTRIC HAND DRYER	THIS PROJECT SHALL CONFORM TO THE FOLLOWING CODES: CALIFORNIA CODE OF REGULATIONS, TITLE 5 EDUCATION CODE,	SHEETS TITLE	SHEETS STRUCTUR	RAL SHEETS T24	0
00 - SUMMARY	03 31 16.01 04 22 00.01	NWT CONCRETE. REFERENCE STRUCTURAL DRAWINGS CONCRETE MASONRY UNITS. REFERENCE WALL TYPES AND STRUCTURAL DRAWINGS	10 28 13.03 10 28 13.06 10 28 13.07	RECESSED ELECTRIC HAND DRYER SURFACE MOUNTED SANITARY NAPKIN DISPOSAL RECESSED TOILET SEAT COVER DISPENSER	TITLE 19 PUBLIC SAFETY CODE AND STATE FIRE MARSHAL REGULATIONS	A-0.1 TITLE SHEET A-0.2 VOL 1 SHEET INDEX, PROJECT DIRECTORY, CODES, KEYNOTES, ABBREVIATIONS,	S-1.1 STRUCTURAL NOTES S-1.2 TYPICAL DETAILS S-1.3 TYPICAL DETAILS	T24-1.0 TITLE 24 CALCULATIONS T24-1.1 TITLE 24 CALCULATIONS	S
0.01 - NEW BUILDING UNDER THIS APPLICATION AND CONTRACT SEPARATE BOYS AND GIRLS ACCESSIBLE RESTROOMS UNDER THIS APPLICATION AND CONTRACT	04 22 00.02	CONCRETE MASONRY UNIT EXPANSION JOINT. REFERENCE 'STRUCTURAL DETAIL 10/S-1.2	10 28 13.09 10 28 13.10.1	SURFACE MOUNTED PAPER TOWEL DISPENSER STAFF ONLY 42 INCH LONG GRAB BAR REF. DETAIL 20/A-10.7	PARTIAL LIST OF APPLICABLE CODES 2016 CALIFORNIA ADMINISTRATIVE CODE, PART 1, TITLE 24 C.C.R. 2016 CALIFORNIA BUILDING CODE (CBC), PART 2, TITLE 24 C.C.R.	SYMBOLS SHEETS CIVIL	S-A2.1 DANCE FOUNDATION PLAN S-A2.2 DANCE ROOF FRAMING PLAN	T24-1.1 TITLE 24 CALCULATIONS T24-1.2 TITLE 24 CALCULATIONS T24-1.3 TITLE 24 CALCULATIONS	
0.03 - SEPARATE MENS AND WOMENS ACCESSIBLE RESTROOMS UNDER THIS APPLICATION AND CONTRACT	04 22 00.03 04 22 00.04	CONCRETE MASONRY VENEER REFERENCE WALL TYPES ON SHEET A-10.2 CONCRETE MASONRY JOINT REFERENCE DETAIL 3/A-10.2.1	10 28 13.10.2 10 28 13.11	36 INCH LONG GRAB BAR REF. DETAIL 19/A-10.7 MOP RACK	(2015 INTERNATIONAL BUILDING CODE VOLUMES 1-2 AND 2016 CALIFORNIA AMENDMENTS) 2016 CALIFORNIA ELECTRICAL CODE (CEC), PART 3, TITLE 24 C.C.R. (2014 NATIONAL ELECTRICAL CODE AND 2016 CALIFORNIA AMENDMENTS)	C-100 DEMOLITION PLAN	S-A2.3 DANCE CMU WALL ELEVATION S-A2.4 DANCE MOMENT FRAME ELEV	NS T24-1.4 TITLE 24 CALCULATIONS /ATIONS T24-1.5 TITLE 24 CALCULATIONS	
0.04 - EXISTING BUILDING TO REMAIN, NOT UNDER CONTRACT SCOPE OF WORK, PROTECT, PATCH AND REPAIR AS AFFECTED BY NEW CONTRACT WORK.	04 52 30.01	MASONRY VENEER UNITS. REFERNCE WALL TYPES AND STRUCTURAL DRAWINGS	10 28 13.12 10 44 00.01	MIRROR. REFERENCE DETAL 23/A-10.7 FOR MOUNTING HEIGHT SEMI-RECESSED FIRE EXTINGUISHER CABINET AND FIRE EXTINGUSIHER REF. DETAIL 7/A-10.2	2016 CALIFORNIA MECHANICAL CODE (CMC) PART 4, TITLE 24 C.C.R. (2015 UNIFORM MECHANICAL CODE AND 2016 CALIFORNIA AMENDMENTS)	C-101 GRADING PLAN 1 C-102 GRADING PLAN 2	S-B2.1 THEATRE FOUNDATION PLAN S-B2.2 MEZZANINE/LOW ROOF/ FLOO	OR FRAMING PLAN T24-1.7 TITLE 24 CALCULATIONS	
10.05 - LOCATION OF FIRE SPRINKLER RISER ROOM 10.06 - LOADING DOCK, REF. DETAIL 17/A-10.1.4.	05 12 00.01 05 12 00.02	EXPOSED STRUCTURAL STEEL. REFERENCE STRUCTURAL DRAWINGS STRUCTURAL STEEL COLUMN. REFERENCE STRUCTURAL DRAWINGS	10 51 13.01 10 51 13.02	3 TIER METAL LOCKERS REF. DETAILS 14 and 15/A-10.2.1 ACCESSIBLE BENCH REFERENCE DETAIL 22/A-10.7	2016 CALIFORNIA PLUMBING CODE (CPC), PART 5, TITLE 24 C.C.R. (2015 UNIFORM PLUMBING CODE AND 2016 CALIFORNIA AMENDMENTS) 2016 CALIFORNIA ENERGY CODE (CEC), PART 6, TITLE 24 C.C.R.	C-103 UTILITY PLAN 1 C-104 UTILITY PLAN 2 C-105 DETAILS AND SECTIONS	S-B2.3 THEATRE CATWALK/CLOUD FF S-B2.4 THEATRE ROOF FRAMING PLA S-B2.5 THEATRE CMU WALL ELEVATION	AN CHEETS DILIMPING	
00.07 - EXISTING BUILDING TO REMAIN, NOT IN CONTRACT SAFE DISPERSAL AREA AT 5 S.F./OCCUPANT, 50 FT. MIN. CLEAR DISTANCE	05 12 00.03 05 12 00.04	STRUCTURAL STEEL FRAMING. REFERENCE STRUCTURAL DRAWINGS CATWALK STEEL FRAMING. REFERENCE STRUCTURAL SHEET S-B2.3 4" METAL STUD PER PLAN AND WALL TYPE LEGEND ON SHEET A-10.2	10 51 13.03	ACCESSIBLE LOCKER AS INDICATED BY "X" RERERENCE DETAIL 14/A-10.2.1	2016 CALIFORNIA FIRE CODE, PART 9, TITLE 24 C.C.R. (2015 INTERNATIONAL FIRE CODE AND 2016 CALIFORNIA AMENDMENTS) 2016 CALIFORNIA GREEN BUILDING STANDARDS CODE, PART 11, TITLE 24 C.C.R.	C-103 DETAILS AND SECTIONS C-106 STANDARD DETAILS 2 C-107 STANDARD DETAILS 2	S-B2.5 THEATRE CMU WALL ELEVATION S-C2.1 BLACKBOX FOUNDATION PLAN S-C2.2 BLACK BOX ROOF FRAMING PI	N N	
on one of the state of the stat	05 12 00.05 05 12 00.06	4" METAL STUD PER PLAN AND WALL TYPE LEGEND ON SHEET A-10.2 4" METAL STUD SHEAR WALL PER STURUCTURAL DRAWINGS SHEET S-3.2	10 51 13.04 11 16 00.01	LOCKER FILLER PIECE AS INDICATED BY SOILD HATCH LOADING DOCK BUMPERS WASHER	2016 CALIFORNIA REFERENCED STANDARDS, PART 12, TITLE 24 C.C.R. TITLE 19 C.C.R., PUBLIC SAFETY, STATE FIRE MARSHAL REGULATIONS.	C-108 EROSION CONTROL PLAN C-109 HWD PLAN	S-C2.3 BBOX CMU WALL ELEVATIONS S-3.1 FOUNDATION DETAILS	F-1.0 FLUIVIDING SCHEDULES	
00.12 - COLUMN COVER ASSEMBLY FOR NEW BUILDING SEE: 11/A-10.1.4	05 12 00.07	EXPOSED EXTERIOR GALVANIZED STRUCTURAL STEEL. REFERENCE STRUCTURAL DRAWINGS FOR SIZE	11 31 00.01 11 31 00.02 11 52 13.01	DRYER MANUALLY OPERATED PROJECTION SCREEN, WALL MOUNTED PER	2013 ASME A17.1 SAFETY CODE FOR ELEVATORS AND ESCALATORS PARTIAL LIST OF APPLICABLE STANDARDS	SHEETS LANDSCAPE	S-3.2 METAL STUD DETAILS - STADIU S-3.3 FOUNDATION DETAILS	P-1.3 PLUMBING DETAILS P-A2.1 PLUMBING DANCE FLOOR PLAN WASTE AND	
00 - TEMPORARY FACILITIES AND CONTROLS	05 12 00.08 05 30 00.01	METAL STUD WALL BEYOND.REFERENCE WALL TYPE ON SHEET A-B2.1 AND WALL LEGEND ON SHEET A-10.2 STEEL DECKING PER STRUCTURAL DRAWINGS	11 52 13.02	DETAIL 16/A-10.3 ELECTRICALLY OPERATED PROJECTION SCREEN	NFPA 13 AUTOMATIC FIRE SPRINKLER SYSTEMS 2016 EDITION NFPA 14 STANDPIPE AND HOSE SYSTEMS 2013 EDITION NFPA 17 DRY CHEMICAL EXTINGUISHING SYSTEMS 2013 EDITION	L-1 LANDSCAPE IRRIGATION PLAN L-2 LANDSCAPE IRRIGATION DETAILS	S-3.4 FOUNDATION DETAILS S-4.1 MOMENT FRAME DETAILS	CONDENSATE PIPING P-A2.2 PLUMBING DANCE FLOOR PLAN WATER	F
00.A2 - REMOVE CONSTRUCTION SIGN AND REINSTALL PER SHEET A-1.3.2 00.A3 - REINSTALL EXISITING JOB SIGN. CONFIRM LOCATION WITH DISTRICT	05 50 00.00 05 50 00.01	STEEL PARAPET ROOF LADDER. REFERNCE DETAIL 12/A-10.12 PROVIDE STAGE ROOF ACCESS LADDER & CAGE. REFERENCE DETAIL	11 52 13.03 11 52 13.04	WALL MOUNTED VIDEO PROJECTOR PER DETAIL 22/A-10.3 LARGE SCREEN MONITOR 4" MAX PROJECTION. REFERENCE AV DRAWINGS FOR ADDITIONAL INFORMATION	NFPA 17A WET CHEMICAL EXTINGUISHING SYSTEMS 2013 EDITION NFPA 20 STATIONARY PUMPS FOR FIRE PROTECTION 2016 EDITION	L-3 LANDSCAPE PLANTING PLAN SHEETS ARCHITECTURAL	S-4.2 FRAMING DETAILS S-4.3 FRAMING DETAILS S-4.4 FRAMING DETAILS	P-A2.3 PLUMBING DANCE FLOOR PLAN ROOF DRAIN AND GAS PIPING	
	05 50 00.05	2/A-10.12 SHIPS LADDER. REFEFRENCE DETAIL 14/A-10.12 AND SPECIFICATIONS	11 52 13.05 11 52 13.06	WALL MOUNTED VIDEO PROJECTOR. REFERENCE DETAIL 22/A-10.3 AV EQUIPMENT RACK MOUNT INSIDE MEDIA CABINET. REFERENCE AV	NFPA 22 WATER TANKS FOR PRIVATE FIRE PROTECTION 2013 EDITION NFPA 24 PRIVATE FIRE MAINS & THEIR APPURTENANCES 2016 EDITION NFPA 25 STANDARD FOR INSPECTION, TESTING AND 2013 EDITION	A-1.0 OVERALL CAMPUS SITE PLAN	S-5.1 FRAMING DETAILS S-5.2 FRAMING DETAILS	P-A3.1 PLUMBING DANCE ROOF PLAN P-B2.1 PLUMBING THEATER FLOOR PLAN WASTE	
ON 02 - EXISTING CONDITIONS	05 50 00.06 05 50 00.07 05 50 00.09	ANODIZED ALUMINUM PANEL. REFERENCE DETAIL 16/A-10.6 PRE-FINISHED ALUMINUM CORNER GUARDS UP TO 7'-0" A.F.F. INTERIOR STEEL BOOF ACCESS LADDER. REF. DETAIL 20/A-10.4	11 52 13.07	DRAWINGS FOR ADDITIONAL INFORMATION WALL MOUNTED SPEAKER PER DETAIL 1/AV-C5.10	MAINTENANCE OF WATER-BASED FIRE PROTECTION SYSTEMS NFPA 72 NATIONAL FIRE ALARM & SIGNALING 2016 EDITION NFPA 80 FIRE DOORS AND OTHER OPENING PROTECTIVES 2016 EDITION		S-5.3 FRAMING DETAILS S-5.4 FRAMING DETAILS	AND CONDENSATE PIPING P-B2.2 PLUMBING THEATER FLOOR PLAN WATER PIPING	
00 - DEMOLITION 19.A2 - OUTLINE OF FUTURE BUILDING	05 50 00.10 05 50 00.11	SCUPPER REFERENCE DETAIL 27/A-10.4.1 SCUPPER REFERENCE DETAIL 27/A-10.4.1 ROOF PARAPET LADDER. REFERENCE DETAIL 29/A-10.4 AND	11 61 33.01 11 61 43.01	PIPE GRID PER AUDIO VIDEO AND STRUCTURAL DRAWINGS STAGE CURTAINS PER AUDIO VIDEO DRAWINGS AND SPECIFICATIONS	NFPA 92 STANDARD FOR SMOKE CONTROL SYSTEMS 2015 EDITION 2		S-5.5 FRAMING DETAILS S-6.1 METAL STUD DETAILS	P-B2.3 PLUMBING THEATER FLOOR PLAN ROOF DRAIN, GAS PIPING	
LANDSCAPE AREA INCLUDING VEGETATION, TREES AND ROOT SYSTEMS TO 19.A5 - REMAIN, REPAIR AS AFFECTED BY THE WORK, PROTECT, MAINTAIN PER	05 50 00.12	SPECIFICATIONS DIAMOND PLATE CATWALK. REFERENCE STRUCTURAL DRAWINGS	11 61 43.02 12 24 13.01	BLACKBOX CURTAINS PER AUDIO VIDEO DRAWINGS AND SPECIFICATIONS PROVIDE ROLLER WINDOW SHADES	NFPA 2001 CLEAN AGENT FIRE EXTINGUISHING SYSTEMS 2015 EDITION ICC 300 ICC STANDARDS ON BLEACHERS, FOLDING AND TELESCOPING 2012 EDITION SEATING AND GRAND STANDS	The state of the s	S-6.2 METAL STUD DETAILS S-7.1 MISC. DETAILS	P-B3.1 PLUMBING THEATER FLOOR PLAN ROOF DRAIN, GAS PIPING	S
LANDSCAPE DRAWING 19.A11 - FACULTIES DURING AND THROUGH OUT WORK	05 50 00.13 05 50 00.14	BOX BOOM ACCESS LADDER. REFERENCE DETAIL 22/A-10.12 METAL GRATE VENT IN MEDIA CABINET. REFERENCE SPECIFICATIONS	12 24 13.03 12 35 83.03	PROVIDE RECESSED ROLLER SHADES POCKET SHELF AND ROD REFERENCE DETAILS 1,2 AND 5/A-10.5.1	UL 300 FIRE TESTING OF FIRE EXTINGUISHING SYSTEMS FOR PROTECTION 2005 EDITION OF RESTAURANT COOKING AREAS		SHEETS MECHANIC M-1.0 MECHANICAL SCHEDULE	P-C2.1 PLUMBING BLACKBOX FLOOR PLAN WASTE AND CONDENSATE PIPING P-C2.2 PLUMBING BLACKBOX FLOOR PLAN WATER	THE STATE OF THE S
9.A13 - ELECTRICAL VAULT TO REMAIN PROTECT AND MAINTAIN DURING AND THROUGH OUT WORK	05 50 00.15 05 52 50.01	STEEL PARAPET ROOF LADDER. REFERENCE DETAIL 24/A-10.12 INTERIOR METAL GUARDRAIL AND HANDRAIL	12 35 83.13.01	MUSIC LIBRARY SYSTEM. REFERENCE STRUCTURAL AND AVL DRAWINGS	UL 464 AUDIBLE SIGNAL APPLIANCES 2003 EDITION UL 521 HEAT DETECTORS FOR FIRE PROTECTIVE SIGNALING SYSTEMS 1999 EDITION	A-A2.0 DANCE BUILIDNG DIMENSIONED FLOOR PLAN A-A2.1 DANCE BUILDING ANNOTATED FLOOR PLAN	M-1.1 MECHANICAL LEGENDS & NO M-1.2 MECHANICAL DETAILS	DIDINO	6
9.A16 - CONCRETE FLATWORK TO REMAIN 9.A17 - CONCRETE BENCH TO REMAIN	05 52 50.02 05 52 50.06 05 52 50.07	INTERIOR METAL HANDRAIL AND WALL MOUNTING BRACKETS METAL GUARDRAIL. REFERENCE DETAIL 17/A-10.9 METAL GUARDRAIL AND HANDRAIL. REFERENCE DETAIL 9/A-10.9	12 61 00.01 14 42 00.01	FIXED AUDIENCE SEATING. REFERENCE SHEETS A-B2.6 AND A-B2.7 WHEELCHAIR LIFT	Reference code section for NFPA Standards - 2016 CBC (SFM) Chapter 35. See Chapter 35 for State of California amendments to NFPA Standards	A-A2.2 DANCE BUILDING EXIT ANALYSIS AND SIGNAGE PLAN	M-1.3 MECHANICAL DETAILS M-1.3.1 MECHANICAL DETAILS	DRAIN, GAS PIPING P-C3.1 PLUMBING BLACKBOX ROOF PLAN	C1
19.A17 - CONCRETE BENCH TO REMAIN 19.A18 - EXISTING FIRELANE	05 52 50.07 05 52 50.08 05 52 50.09	METAL GUARDRAIL AND HANDRAIL. REFERENCE DETAIL 9/A-10.9 METAL GUARDRAIL ON CATWALK. REFERENCE AVL DRAWINGS METAL CANE DETECTION RAILING. REFERENCE DETAIL 15/A-10.9	14 42 00.02	FULL HEIGHT WHEELCHAIR LIFT. REFERENCE DETAIL 5/A-10.11 ACCESSIBLE WHEELCHAIR LIFT. REFERENCE DETAIL 23/A-10.10 DOWNSPOUT NOZZELAT CMU WALL, REFERENCE DETAIL 18/A-10.6	DDO IECT DIDECTORY	A-A2.3 DANCE BUILDING ENLARGED RESTROOMS A-A3.0 DANCE BUILDING REFLECTED CEILING PLAN A-A4.0 DANCE BUILDING ROOF PLAN	M-1.4 MECHANICAL CONTROLS M-1.5 MECHANICAL CONTROLS		ALE O
19.A19 - EXISTING SITE WALL TO REMAIN. PATCH AND REPAIR AS NEEDED. PAINT WALL TO MATCH FRAZEE, CL 2931W, SOYA	05 52 50.10 06 10 00.04	INTERIOR METAL HANDRAIL REFERNCE DETAIL 1/A-10.13 3/4" THICK AA GRADE PLAYWOOD SHELF. REFERENCE DETAIL	22 20 00.01	AND PLUMBING DRAWINGS DOWNSPOUT NOZZEL AT METAL STUD WALL. REFERENCE DETAIL	PROJECT DIRECTORY	A-A4.0 DANCE BUILDING TROOF LEAN A-A5.0 DANCE BUILDING EXTERIOR ELEVATIONS A-A6.0 DANCE BUILDING SECTIONS			
19.A20 - REMOVE EXITING PORTION OF SITE WALL. INCLUDING BUT NOT LIMITED TO FOOTING. 19.C4 - REMOVE ELECTRICAL VAULT PER ELECTRICAL DRAWINGS		INTERIOR ELEVATIONS AND DETAIL 2/A-10.5.1 FOR SIMILAR CONDITION	22 20 00.03	19/A-10.6 AND PLUMBING DRAWINGS ACCESSIBLE DRINKING FOUNTAIN PER DETAIL 17/A-10.7	Client / District:Landscape Architect:Electrical Engineer:Grossmont Union School DistrictGeorge Mercer AssociatesTurpin & Rattan1100 Murray Dr.4730 Palm Avenue #2104719 Palm Ave.	A-A6.1 DANCE BUILDING SECTIONS A-A7.1 DANCE BUILDING WALL SECTIONS			
9.C4 - REMOVE ELECTRICAL VAULT PER ELECTRICAL DRAWINGS 9.D1 - SAW CUT AND REMOVE ALL LAYERS OF ASPHALT PAVING, BASE AND UNDERLAYMENT, CURBS, EDGING, PETROMAT	06 20 00.01 06 20 00.02	WORK COUNTER. REFERENCE DETAIL 18/A-10.5.1 WALL CAP. REFERENCE DETAIL 23/A-10.2.1 COUNTERTOR	22 20 00.04 22 20 00.06	ACCESSIBLE LAVATORY PER DETAIL 23/A-10.7 ACCESSIBLE ADULT WATER CLOSET PER DETAIL 18/A-10.7	El Cajon, CA 92020 La Mesa, CA 91941 La Mesa, CA 91941 Phone: (619) 644-8151 Phone: (619) 463-7876 Phone: (619) 466-6224	A-A7.2 DANCE BUILDING WALL SECTIONS A-A9.0 DANCE BUILDING INTERIOR ELEVATIONS	REFERENCE KEYNOTES BUILDING MASTER	ER KEYNOTES LIST BUILDING MASTER KEYNOTES LIST APPLICABLE CODES 191 H9 056 DOOR MACHITE PROTOGOM MESTROOM GENTRACATION SIGN PEAR 192 H9 056 DOOR MACHITE PROTOGOM OF STRUCTURE SIGN PEAR 11 HE 1972 CHARGE OF STRUCTURE SIGN PEAR 11 HE 1	SHEET INDEX VOL. 2 SHEETS ACOUSTICS SHEETS ACOUSTICS SHEETS ACOUSTICS
19.D5 - REMOVE VEGETATION, TREES, ROOT SYSTEMS, PER LANDSCAPE DRAWING, CLEAR GRUB AND GRADE	06 41 00.01 06 41 00.03 06 41 00.04	COUNTERTOP CASEWORK MEDIA CABINET CASEWORK REFERENCE DETAIL 4/A-10.5 FOR	22 20 00.07 22 20 00.08	STANDARD ADULT WATER CLOSET ACCESSIBLE ADULT URINAL PER DETAIL 24/A-10.7	Fax: (619) 463-7860 Fax: (619) 466-6233 Architect: Sprotte + Watson Architecture Structural Engineer: Acoustic Engineer:	A-A9.1 DANCE BUILDING INTERIOR ELEVATIONS A-A9.2 DANCE BUILDING INTERIOR ELEVATIONS	DISSOCIAL DISSOCIAL	## 25 CONCRETE 15 1 60 15	
SAW CUT AND REMOVE ALL LAYERS OF ASPHALT AND CONCRETE PAVING, BASE AND UNDERLAYMENT, CURBS, EDGING, PETROMAT. THIS DRIVE WAS AN OLD HIGHWAY AND THERE IS A MINIMUM 9" CONCRETE UNDER THE	06 41 00.04	ANCHORAGE TO WALL STORAGE CABINET. REFERNCE DETAIL 7/A-10.5.1	22 20 00.10 22 20 00.11 22 20 00 13	ACCESSIBLE SINK REFERENCE DETAIL 8/A-10.5 MOP SINK FLOOR DRAIN. REFERNCE PLUMBING DRAWINGS	450 S. Melrose Rd., Suite 200 Wiseman + Rohy Structural Engineers Idibri Vista, CA 92081-6664 9915 Mira Mesa Blvd., Suite 200 1935 N marshall Ave.	A-A9.3 DANCE BUILDING INTERIOR ELEVATIONS A-B2.0 THEATER BUILDING DIMENSIONED FLOOR PLAN	1110/CG	ONLY REFERENCE QUAL AND 23 121 131 132 132 133 132 133	Building B – AV Pariet Delaits Building B – Ceres Course Riging Details Building B – Ceres Course Riging Details Building B – Nove Lett Course Propriet Details Building B – Nove Lett Course Riging Building B – AV Schemations
INITIAL PAVING LAYER. REMOVE CONCRETE RAMP INCLUDING ASSOCIATED RETAINING WALLS,	06 41 00.06 06 41 00.08	COUNTER PER DETAIL 19/A-10.5 DRESSING ROOM COUNTER AND DRAWERS. REFERENCE DETAIL	22 20 00.13 22 20 00.14 22 20 00.15	FLOOR DRAIN. REFERNCE PLUMBING DRAWINGS MOP SINK. REFERENCE PLUMBING DRAWINGS ROOF DRAIN AND OVERFLOW DRAIN PER DETAIL 5/A-10.4	Phone (760) 639-4120 San Diego, CA 92131 El Cajon, CA 92020 Fax (760) 639-4125 Phone: (858) 536-5166 Phone: (619) 596-4800 Fax: (858) 536-5163	A-B2.1 THEATER BUILDING ANNOTATED FLOOR PLAN A-B2.2 THEATER BUILDING AUDIO CONTROL PLAN A-B2.2 THEATER BUILDING EXIT ANALYSIS AND SIGNAGE	DI SO DI AJ - REVISTALI, EXISTING JOB SIGN, CONFIRMI OCATION WITH DISTRICT 03 30 00 01 STEEL DEGNIS PER SITE (\$50 0.00) STEEL PARAPET ROOF LE	200 200	47.04 (Judong III - AV Schemanian 87.10 Budong II - Marcan Schemania 87.10 Budong II - Marcan Schemania 87.10 Budong II - Marcan Schemanian 87.12 Budong II - Schemanian 87.12 Budong III - Schemanian 87.13 Budong III - Schemanian 87.14 Budong III - Schemanian 87.15 Budong III - Marcan Schemanian 87.16 Budong III - AV Pend Challa
9.D8 FOOTINGS, UNDERLAYMENTS, LANDINGS, AND RAILINGS SAW CUT AND REMOVE ALL LAYERS OF CONCRETE PAVING AND OR	06 41 00.09	23/A-10.5 COSTUME COUNTER AND DRAWERS. REFERENCE DETAIL 27/A-10.5	22 20 00.15 22 20 00.16 22 20 00.17	WATER HEATER PER PLUMBING DRAWINGS EYE WASH, REFERENCE PLUMBING DRAWINGS	Civil Engineer: Cherry Engineering Mechanical/Plumbing Engineer: Fire Protection: Cosco Fire Protection	A-B2.3 THEATER BUILDING EXIT ANALYSIS AND SIGNAGE PLAN A-B2.4 THEATER BUILDING ENLARGED PLAN - CATWALK	SECOND S	ACCESSE DIOMNA DIOR REPROVES DELLA	C-2.00 Bulding C - AV Pend Chesis Bulding C - AV Neuring Petals C-2.55 Bulding C - AV Read Resident C-2.55 Bulding C - AV Read Resident C-2.56 Bulding C - AV Send Resident C-2.61 Bulding C - AV Send Resident C-2.62 Bulding C - AV Send Resident C-2.63 Bulding C - AV Send Resident C-2.64 Bulding C - AV Send Resident C-2.65 Bulding C - AV Send Resident C-2.65 Bulding C - AV Send Resident C-2.65 Bulding C - Bulding Resident C-2.65 Buld
19.D12 - REMOVE CONCRETE BENCH FOOTING AND SLAB	06 41 00.10 06 41 00.11	WORKSTATION COUNTER AT CURTAIN WALL PER DETAIL 25/A-10.5.1 COUNTER AT PASS THRU WINDOW. REFERENCE DETAIL 10/A-10.5	22 20 00.17	DEEP UTILITY SINK, REFERENCE PLUMBING DRAWINGS ROOF DRAIN PER DETAIL 5/A-10.4 (SIM)	12721 Palm Avenue Merrick and Associates 4990 Greencraig Lane Poway, CA 92064 9606 Tierra grande Road #206 San Diego, CA 92123 Phone: (858) 231-4372 San Diego, CA 92126 Phone: (858) 444-2000	A-B2.5 THEATER BUILDING ENLARGED PLANS A-B2.6 THEATER SEATING PLAN AND DETAILS	24 19.54	MAX. REFERENCE STRUCTURAL DAVANCES 118 2102 118 2	SNEETS ACOUSTICS RIGGING 100 Rigging holes & Leginds 11:10 Bulding 1- Higging Flour Plans 13:10 Bulding 1- Higging Flour Plans 13:10 Bulding 1- Stopp Rigging Section 14:10 Bulding 1- Stopp Rigging Layers 14:10 Bulding 1- Stopp
19.D19 - REMOVE BOLLARD AND ASSOCIATED ITEMS SUCH A FOOTINGS, CHAINS ETC	06 41 00.12 06 41 00.13 07 54 00.01	WOOD PEG BOARD WORK STATION COUNTER PER DETAIL 22/A-10.5. OMIT BACK SPLASH THERMOPLASTIC ROOFING ASSEMBLY REFERENCE DETAIL 9/A-10.4	23 20 00.01 23 20 00.02	ROOF TOP MÉCHANICAL UNIT, RÉFERENCE MECHANICAL DRAWINGS MECHANICAL DUCTING, REFERENCE MECHANICAL DRAWINGS	Phone: (858) 549-9980	A-B2.7 THEATER AISLE LIGHTING PLAN A-B3.0 THEATER BUILDING REFLECTED CEILING PLAN	24 11364 SECTION OF THE PRINCIPAL AND AND PRINCIPAL AND SECTION OF THE P	Control Cont	27.00 Budding 6- Stopp Royal Debit 12.10 Budding 6- Stopp Royal Sometis 12.10 Budding 6- Stan Six Pipe Core 12.11 Budding 6- Stan Six Pipe Core 11 Budding 6- Stan Six Pipe Core 12.12 Budding 6- Stan Six Pipe Core 13.12 STAN SIX
9.D20 - REMOVE VEGITATION, TREES, ROOTS AND SOIL AS REQUIRED FOR NEW RETENTION BASIN, REF. CIVIL. REMOVE WOOD PLANTER, FOOTINGS AND ALL ASSOCIATED ITEMS,	07 54 00.01 07 54 00.02 07 54 00.03	RIDGID INSULATION OVER METAL DECK ROOF WALKWAY PADS. REFERENCE SPECIFICATIONS	23 20 00.03 23 20 00.04	MECHANICAL AIR SUPPLY, REFERENCE MECHANCIAL DRAWINGS MECHANICAL RETURN AIR, REFERENCE MECHANICAL DRAWINGS	VICINITY MAP	A-B3.1 THEATER BUILDING RELECTED CEILING PLAN - CLOUDS	CALIFORM CONTRATO	DEMANDS	All Thesistal upting Aurisia (las Schoule Thesistal Upting Pla Schoule AC2 Thesistal Upting Pla Schoule AC3 This Budge 3 - Thesistal Upting Place Schoules AC3 Thesistal Upting Place Schoules AC3 Thesistal Upting Place Thesistal Upting School Thesistal Upting School Thesistal Upting School Thesistal Upting Place Thesista
9.D21 - PROTECT TREE AND ROOT STRUCTURE DURING DEMOLITION.	07 54 00.03	CONTRASTING COLOR ADHERED PVC SINGLE PLY PVC CLASS "A" MEMBRANE BUILDING NUMBER AT 6'-3" HEIGHT WITH LINES 14"-16"	23 20 00.05 26 00 00.05	MECHANICAL DIFFUSER/REGISTER/GRILL, REFERENCE MECHANICAL DRAWINGS EXTERIOR CEILING LIGHT FIXTURE. REFERENCE DETAIL 20/A-10.3.	W. NESTAMO OR	A-B4.0 THEATER BUILDING ROOF PLAN A-B5.0 THEATER BUILDING EXTERIOR ELEVATIONS A-B5.1 THEATER BUILDING EXTERIOR ELEVATIONS	24 1 1007 0.4 10070 0.4	AND GOALDESS SET (FESTIC) (FESTION 19): (FESTION 1)	C500 Building C1-Treativa Lighting Sention Lodding C1-Treativa Lighting Sentimate SHEETS FIRE PROTECTION STEP AN STEP
DN 03 - CONCRETE	07 54 00.05	WIDE FOR AERIAL IDENTIFICATION PVC WARNING STRIP. REFERENCE DETAIL 10/A-10.4.2	26 00 00.05	COORDINATE THE INSTALLATION OF FIXTURE HOUSING AND WIRE TIES PRIOR TO INSTALLATION OF FINISHES.	W. MAIR ST. VV. MAIN ST.	A-B5.1 THEATER BUILDING EXTERIOR ELEVATIONS A-B6.0 THEATER BUILDING SECTIONS A-B6.1 THEATER BUILDING SECTIONS	10 00 CONCENTE 10 0	FOR AGENINA SET TENTACE COTTA, A 19-18 1 22 2010 15 10 COT TIMEN TO DESCRIPTION TO COTTAIN TO COTTA	AASS CANCERLED A PCP PADD THAN PRESIDENCE PROPRIATA HARD THAN PRESIDENCE PROPRIATA HARD THAN PRESIDENCE PROPRIATA COST SEASON CONTROL PROPRIATA BLACK BACKELDING C PCP BLACK BACKELDING C PCP CALCULATIONS CALCULATIONS CALCULATIONS CALCULATIONS
00 CONCRETE -	07 61 00.02 07 61 00.04	METAL SOFFIT PANEL PRE-FINISHED GALVANIZED SHEET METAL PARAPET COPING	26 00 00.06	CEILING MOUNTED INTERIOR LIGHTING FIXTURE AT ACT CEILING REFEREENCE DETAIL 6/A-10.3.1 AND ELECTRICAL DRAWINGS		A-B6.1 THEATER BOILDING SECTIONS A-B6.2 THEATER STAIRS AND SECTIONS A-B6.3 THEATER STADIUM SEATING SECTIONS AND	0.4750/04 PROFESSION PROF	MOD SIGH 1641, PRIFECT CO. 13 0 0 0 0 1 1 1 1 1 1 1 1 1 1 1 1 1 1	SYMB 101 DOOR OPPOS REFERM A43
00.01 - CAST IN PLACE SCORED CONCRETE CAST IN PLACE CONCRETE BENCH/SEAT WALL, REFERENCE DETAIL	07 62 00.01 07 62 00.03	PRE-FINISHED GALVANIZED SHEET METAL FASCIA PRE-FINISHED GALVANIZED SHEET METAL PARAPET CAP FLASHING PRE-FINISHED	26 00 00.08 26 00 00.09	WALL MOUNTED CLOCK, REFERENCE ELECTRICAL DRAWINGS WALL MOUNTED INTERIOR LIGHTING FIXTURE. REFERENCE	MARAY DR.	DETAILS A-B6.4 BUILDING SECTIONS	TYP 19 182 SERVICE SEAL	### ADD FAME #	VI WROOM THE RETERENT AUTENION STATE OF STATE BY THE STATE OF STAT
00.03 - 26/A-10.1.3 CONCRETE RETAINING WALL, STRUCTURAL DETAIL 8/S3.4. FOOTING PER	07 72 00.01	2'-6" X 3'-0" ROOF ACCESS HATCH AND ROOF ACCESS LADDER SAFETY POST REF. DETAIL 20/A-10.4	26 00 00.10	ELECTRICAL DRAWINGS. WALL MOUNTED EXTERIOR PUBLIC ADDRESS SPEAKER. REFERENCE ELECTRICAL DRAWINGS	W. WASHINGTON AVE	A-B7.1 THEATER BUILDING WALL SECTIONS A-B7.2 THEATER BUILDING WALL SECTIONS	50 50 N 1971 A MACEVAL 50 0 1 10 10 10 10 10 10 10 10 10 10 10 1		HARTA SECTION COI PER 1
00.05 - STRUCTURAL DETAIL 3/S3.4. REFERNCE DETAIL 24/A-10.1.4 FOR WATERPROOFIING PROVIDE 6" CONCRETE CURB. REFERENCE DETAIL 15/A-10.1.3 AND CIVIL	07 72 00.02 07 72 00.03	SMOKE/HATCH VENT REFERENCE DETAIL 13/A-10.4.1 ROOF HATCH SAFETY RAIL. REFERENCE DETAIL 4/A-10.13 AND	26 00 00.11 26 00 00.12	ELECTRICAL PANEL BOARD. REFERENCE ELECTRICAL DRAWINGS ELECTRICAL FIRE ALARM CABINET. REFERENCE ELECTRICAL	MILDEN ST WASHINGTON	A-B9.0 THEATER BUILDING INTERIOR ELEVATIONS A-B9.1 THEATER BUILDING INTERIOR ELEVATIONS	19 00 FRANCE 18 19 00	Committee CFL Committee	SEMENT SECTIONS PARTY SUAL DAY SECTION PRESERVE 2011 DO SECTION PRESERVE 2012 DOS SECTION PRESERVE 2013 DOS SECTION PRESERVE 2013 DOS SECTION PRESERVE 2013 DOS SECTION PRESERVE 2014 DOS SECTION PRESERVE 2014 DOS SECTION PRESERVE 2015 DOS SECTION PRESERVE 2016 DOS SECTION PRESERVE 2017 DOS SECTION PRESERVE
00.06 - PROVIDE 6 CONCRETE CORB. REFERENCE DETAIL 13/A-10.1.3 AND CIVIL 10.00.07 - EXPANSION JOINT. REF. DETAIL 18/A-10.1.3	07 95 13.02	SPECIFICATIONS SEISMIC SEAL HOLLOW METAL DOOR AND FRAME	26 00 00.13	DRAWINGS RECESSED INTERIOR CEILING MOUNTED 6" WIDE x 12' LONG LIGHTING		A-B9.2 THEATER BUILDING INTERIOR ELEVATIONS A-B9.3 THEATER BUILDING INTERIOR ELEVATIONS	22 (1981)	ACTION CONTROL OF THE PLANT OF	PART 3 HANGE DESCRIPTION OF MUTURE REPORTED AND ADDRESS OF SECTION OF SECTION AND ADDRESS OF SECTION ADDRES
00.08 COLORED CONCRETE PATH OF TRAVEL. COLOR GRAPHITE GRACE PRODUCTS OR EQUAL.	08 11 13.01 08 11 13.02 08 31 13.03	FIRE RATED HOLLOW METAL DOOR AND FRAME CEILING ACCESS PANEL. REFERINCE DETAIL 15/A-10.3		FIXTURE. REFERENCE ELECTRICAL DRAWINGS.	MURRAY DR MURRAY DR	A-B9.4 THEATER BUILDING INTERIOR ELEVATIONS A-C2.0 BLACKBOX BUILDING DIMENSIONED FLOOR PLAN A-C2.1 BLACKBOX BUILDING ANNOTATED FLOOR PLAN	23 100 - PRIVICE AND GOTES 02 20003 02	REPUBLIC ECANA 64-106	ROUM NAME ASSESSMENT AND ASSESSMENT ASSESSME
	08 33 23.01 08 33 23.02	OVERHEAD COILING SERVICE DOOR OVERHEAD COILING SECURITY DOOR, REFERENCE DETAIL 7/A-10.5.1			GROSSMONT HIGH SCHOOL 1100 MURRAY DR. EL CAJON, CA 92020	A-C2.1 BLACKBOX BUILDING ANNOTATED FLOOR FLAN A-C2.2 BLACKBOX BUILDING EXIT ANALYSIS AND SIGNAGE PLAN	COMMON STACKLE AT DAR IN	Table Act Discord of Local Full Full Control Full Contr	DEFFERRED 1. WINDOWSTSTEMS WITH SPANS
ION 05 - METALS	08 43 13.01 08 44 13.01	GLAZED ALUMINUM FRAMED STORFRONT GLAZED ALUMINUM CURTAIN WALL		IS 2018 CIVIL A	(619) 668-6000	A-C2.3 BLACKBOX BUILDING ENLARGED RESTROOMS A-C3.0 BLACKBOX BUILDING REFLECTED CEILING PLAN	PROJECT GENERAL NOTES PROJECT GENERAL NOTES STATE OF THE STATE OF TH	PRINCEIANS AND GALLS C. Come Saam F.A. File Edispution Internal Control Control C. Come Saam F.A. File Edispution Internal Control	PROJEC
00 - METAL FABRICATIONS 00.04 - REMOVABLE, LOCKING BOLLARDS, REFERENCE DETAIL 13/A-10.1.4.	08 51 00.01 08 80 00.01	SLIDING OPERABLE WINDOW SPANDREL INSULATED GLAZING UNIT				A-C4.0 BLACKBOX BUILDING ROOF PLAN A-C5.0 BLACKBOX BUILDING EXTERIOR ELEVATIONS	AND PROPRIES AND ADDRESS OF THE CONTROL ONCE AND ADDRESS OF TH	ALS CASE OF THE PROPERTY OF TH	THE PROJECT CONSISTS OF THE CONSTITUTE AND CONSTITU
00.05 - PROVIDE FLAG POLE PER DETAIL 19/A-10.1.4	08 83 00.01 08 83 00.02	WALL MOUNTED CHANGING ROOM MIRROR. REFERENCE DETAIL 15/A-10.13 MIRROR. REFERENCE DETAIL 19/A-10.5 FOR MOUNTING INFORMATION			LEMON AVE.	A-C6.0 BLACKBOX BUILDING SECTIONS A-C7.1 BLACKBOX BUILDING WALL SECTIONS	TOTAL DUT NO. 1 THE CONTROL OF THE C	TOTAL CONTROL STATE STAT	
50 - METAL RAILINGS	08 83 00.02 08 83 00.03 08 83 00.04	MIRROR ELECTRICAL OUTLET COVER. WALL MOUNTED DANCE MIRROR. REFERENCE DETAIL 4/A-10.2.1			NIS	A-C7.2 BLACKBOX BUILDING WALL SECTIONS A-C9.0 BLACKBOX BUILDING INTERIOR ELEVATIONS A-C9.1 BLACKBOX BUILDING INTERIOR ELEVATIONS	ARCHITECTURAL SHEETS (9 S	Sheets) 1 SHEET INDEX	
50.05 - GALV. STEEL PIPE HANDRAIL SYSTEM REF. DETAIL 9/A-10.1.3	09 24 00.01 09 24 00.02	CEMENT PLASTERING SYSTEM INTERGAL COLOR AND PAINT CEMENT PLASTER 1/2-INCH EXPANSION REVEAL. REFERENCE DETAIL		ADDD	TATIONIO	A-C9.1 BLACKBOX BUILDING INTERIOR ELEVATIONS A-C9.2 BLACKBOX BUILDING INTERIOR ELEVATIONS A-C9.3 BLACKBOX BUILDING INTERIOR ELEVATIONS		ed two AV sheets to the index. AV-c1.50 & AV-C7.51.	
50.06 - TYPICAL 4' OPENING.	09 24 00.05	12/A-10.6 CEMENT PLASTER 2-INCH EXPANSION REVEAL. REFERENCE DETAIL		ABBRI	EVIATIONS	A-8.0 DOOR SCHEDULE A-8.1 WINDOW TYPES	MODIFICATION 2: Add	keynote T58	
ION 10 - SPECIALTIES	09 24 00.07	12/A-10.6 CEMENT PLASTER CONTROL JOINT 11/A-10.6	&	AND D Drain GND.	Ground P Paint T. Tread	A-8.2 FINISH SCHEDULE A-10.1.1 ENLARGED RAMP, STAIRS, PLANS AND SECTIONS		A-1U.3 /	Marie Control of the
00 - SPECIALTIES	09 29 00.01 09 29 00.02	GYPSUM BOARD REFERENCE WALL TYPES AND SPECIFICATIONS HIGH IMPACT GYPSUM BOARD UP TO 8'-0" A.F.F REFERENCE WALL TYPES AND SPECIFICATIONS	@ CI	Angle DBL. Double GPDW. At DEPT. Department GR. Center Line DET. Detail G.V.	Gypsum Drywall PAV. Paving T.B. Towel Bar Grade P.C. Precast Concrete T&B Top and Bottom Gate Valve P.C.C. Portland Cement T.C. Top of Concrete /	A-10.1.2 ENLARGED RAMP STAIRS, PLANS AND SECTIONS A-10.1.3 SITE DETAILS		2 KEYNOTE REFERENCE, PERIMETER NUMBERS REFERENCE TYPES RESPONSIBLE PARTY	ed Post Principal
00.02 - RECESSED KNOX BOX	09 29 00.05	DASHED LINE INDICATES CEILING GYPSUM BOARD CLOUDS ABOVE. REFERENCE SHEET A-B3.1	Ø A.B.	Diameter D.F. Drinking Fountain GYP. Anchor Bolt DIA Diameter GWB.	Gypsum Concrete Curb Gypsum Wall Board P.H.P Partial Height TEL. Telephone	A-10.1.4 SITE DETAILS A-10.2 PLAN DETAILS		▲ SIM	STAN INSCRIPTION
ON 32 - EXTERIOR IMPROVEMENTS	09 29 00.06	FRAMED GYPSUM BOARD CEILNG. REFERENCE DETAIL 18/A-10.3 FOR FRAMING	A.A. A/C	Above DIM. Dimension Asphalt Concrete DISP. Dispenser H.B. Air Conditioning DMT. Demountable H.B.	Partition TEM. Tempered Hose Bibb PL. Plate TER. Terrazzo Hollow Core P/L Property Line T.F. Top of Footing	A-10.2.1 PLAN DETAILS A-10.3 REFLECTED CEILING PLAN DETAILS	A	BUILDING SECTION REFERENCE. A101	
16 - FLEXIBLE PAVING	09 29 00.07	GYPSUM FINISH THEATER CELING CLOUD A. REFRERNCE DETAIL 11/A-10.3.1 GYPSUM FINISH THEATER CELING CLOUD B. REFRERNCE DETAIL	ACOUS. A.C.T.	Acoustical DN. Down HD. Acoustical Ceiling D.O. Door Opening HDR.	HeadP.LAM.Plastic LaminateT>ongue and GrooveHeaderPLAS.PlasterTHKThick	A-10.3.1 REFLECTED CEILING PLAN DETAILS A-10.4 ROOF DETAILS A-10.4.1 ROOF DETAILS		DETAIL ELEVATION REFERENCE.	REVIS
16.01 - ASPHALT PAVING ASSEMBLY PER CIVIL DRAWINGS	09 29 00.08 09 30 00.01	12/A-10.3.1 CERAMIC TILE REFERENCE FINISH SCHEDULE ON SHEET A-8.2	A.D. ADJ.	Area Drain Dr. Drain HDW. Area Drain D.S. Downspout H.M. Adjustable DWG. Drawing HNDRL	Hollow Metal PWD. Plywood T.O.R. Top of Roof Handrail PLBG. Plumbing T.O.S. Top of Structure	A-10.4.1 ROOF DETAILS A-10.4.2 ROOF DETAILS A-10.5 CASEWORK DETAILS	TDN:1	FINISHES DESIGNATION (WHERE OCCURS) REFERENCE PLANS, AND INTERIOR ELEVATIONS	1 10-31-18
00 - CURBS AND GUTTERS	09 30 00.02 09 30 00.03	CERAMIC TILE ACCENT BAND REFERENCE DETAIL 5/A-10.6 CERAMIC TILE BASE. REFERENCE DETAIL 8/A-10.6	AGGR. AFF	Aggregate DWR. Drawer HORIZ. Above Finish Floor H.V.A.C. Aluminum (E) Existing	Horizontal P.O.C. Point of Connection T.P. Top of Pavement Heating, Ventilation P.P. Power Pole T.P.D. Toilet Paper & Air Conditioning PRCST. Precast Dispenser	A-10.5 CASEWORK DETAILS A-10.5.1 CASEWORK DETAILS A-10.6 FINISH AND SOUND CONTROL DETAILS		INTERIOR ELEVATIONS. FURNISHINGS, FIXTURES AND EQUIPMENT DESIGNATION REFERENCE	ADDENDA
00.03 - CONCRETE FLATWORK PER LEGEND ON THIS SHEET. SEE 18/A-10.1.3 FOR CONCRETE JOINTS	09 30 00.06 09 30 00.07	PORCELAIN TILE REFERENCE FINISH SCHEDULE ON SHEET A-8.2 TILE PATTERN PER DETAIL 10/A-10.6	AL. A.P. APPROX.	Access Panel E East Approximate EA. Each I.D.	P.S.I. Pounds per T.S. Top of Slab Inside Diameter Square Inch T.T.B. Telephone Terminal	A-10.7 ACCESS AND SIGNAGE DETAILS A-10.8 DOOR AND WINDOW DETAILS		FFE SCHEDULE ON SHEET A-0.2	
	09 30 00.08	EXTERIOR CERAMIC TILE WAINSCOT. REFERENCE DETAIL 30/A-10.6 EXTERIOR PROCELAIN TILE. REFERENCE DETAIL 15/A-10.6	ARCH. A.S.C.	Architectural E.A. Exhaust Fan I.E. Above Suspended EF. Each Face I.F. Ceiling E.J. Expansion Joint IN.	Invert Elevation PT. Point Backboard Inside Face P.T.D. Paper Towel T.V. Television Inch Dispenser T.W. Top of Wall	A-10.8.1 DOOR DETAILS A-10.8.2 DOOR AND WINDOW DETAILS	<u> </u>	ADDENDUM, RFI OR ASI DESIGNATION. ROOM NAME, NUMBER AND ELEVATION DESIGNATION, REFERENCE	To the state of th
	09 30 00.09	ACOUSTICAL CEILING THE (ACT) 24"x40"		Automated Sprinkler ELEC. Electrical INC.		A-10.8.3 DOOR AND WINDOW DETAILS		PLANS AND INTERIOR ELEV. SHEETS N/A = NO ELEVATION PERIMETER NUMBERS REFERENCE WALL ELEVATIONS.	
0.05 - CURB CUTS PER CIVIL DRAWINGS 0 - FENCES AND GATES	09 30 00.09 09 51 00.01 09 51 00.03	ACOUSTICAL CEILING TILE (ACT) 24"x48" CONTINUOUS MAIN T BAR AT EDGE OF LIGHT FIXTURE STAC CLIP AT T BAB INTERUPTION, REFERENCE DETAIL 27A/A-10.3.1	A.S. ASPH.	Asphalt ELEV. Elevator INFO.	Include P.T/R. Combination Paper TYP. Typical Information Towel Dispenser / Insulation Waste Recentacle VAR Varies	A-10.9 STAIR AND LIFT DETAILS		FEMILIER INDIVIDENS REFERENCE WALL ELEVATIONS.	APPR
00.05 - CURB CUTS PER CIVIL DRAWINGS 00 - FENCES AND GATES 13.03 - GATE PER GATE SCHEDULE SHEET A-1.1	09 30 00.09 09 51 00.01 09 51 00.03 09 51 00.04 09 51 00.05		AUTO. BD.		Information Towel Dispenser / Insulation Waste Receptacle VAR. Varies Interior PTN. Partition V.B. Vapor Barrier Invert PVMT. Pavement VERT. Vertical	A-10.10 STAIR AND LIFT DETAILS A-10.11 STAIR AND LIFT DETAILS	OL	L 2 F 100 OCCUPANCY LOAD, OCCUPANCY FACTOR, AND SQUARE FOOTAGE	IDENTIFICA
00.05 - CURB CUTS PER CIVIL DRAWINGS 00 - FENCES AND GATES 13.03 - GATE PER GATE SCHEDULE SHEET A-1.1 13.05 - GATE PER SCHEDULE SHEET A-1.1 (PAIR)	09 30 00.09 09 51 00.01 09 51 00.03 09 51 00.04	CONTINUOUS MAIN T BAR AT EDGE OF LIGHT FIXTURE STAC CLIP AT T BAR INTERUPTION. REFERENCE DETAIL 27A/A-10.3.1 CONTINUOUS CROSS T BAR FIBERGLASS REINFORCED WALL PANELS WOOD FLOORING OVER DEPRESSED CONCRETE SLAB. FINISH PER FINISH SCHEDULE ON SHEET A-8.2		Asphalt ELEV. Elevator INFO. Automatic EMER. Emergency INSUL. ENCL. Enclosure INT. Board E.P. Electrical Panelboard INV. Below Finish Grade EQ. Equal Bituminous EQUIP. Equipment JAN.	Information Towel Dispenser / Insulation Waste Receptacle VAR. Varies Interior PTN. Partition V.B. Vapor Barrier Invert PVMT. Pavement VERT. Vertical VEST. Vestibule Janitor Q.T. Quarry Tile V.I.F. Verify in Field	A-10.10 STAIR AND LIFT DETAILS	OL	CCUPANCY LOAD, OCCUPANCY FACTOR, AND SQUARE FOOTAGE DESIGNATION, REFERENCE EXIT ANALYSIS PLANS ON SHEET A-2.4.	DIV. OF THE ST
0 - FENCES AND GATES 3.03 - GATE PER GATE SCHEDULE SHEET A-1.1 3.05 - GATE PER SCHEDULE SHEET A-1.1 (PAIR) 0 - PLANTS 0.02 - LANDSCAPE REGION PER LANDSCAPE DRAWINGS	09 30 00.09 09 51 00.01 09 51 00.03 09 51 00.04 09 51 00.05 09 54 53.01 09 64 00.01 09 65 00.01	CONTINUOUS MAIN T BAR AT EDGE OF LIGHT FIXTURE STAC CLIP AT T BAR INTERUPTION. REFERENCE DETAIL 27A/A-10.3.1 CONTINUOUS CROSS T BAR FIBERGLASS REINFORCED WALL PANELS WOOD FLOORING OVER DEPRESSED CONCRETE SLAB. FINISH PER FINISH SCHEDULE ON SHEET A-8.2 RESILIENT BASE PER FINISH SCHEDULE TILE FLOORING SEE A-8.2	AUTO. BD. B.F.G. BITUM. BLDG. BLK. BLKG	Asphalt ELEV. Elevator INFO. Automatic EMER. Emergency INSUL. ENCL. Enclosure INT. Board E.P. Electrical Panelboard INV. Below Finish Grade EQ. Equal Bituminous EQUIP. Equipment JAN. Building E.W. Each Way JST. Block E.W.C. Electric Water Cooler JT. Blocking EH. Exhaust	Information Towel Dispenser / Insulation Waste Receptacle VAR. Varies Interior PTN. Partition V.B. Vapor Barrier Invert PVMT. Pavement VERT. Vertical VEST. Vestibule Janitor Q.T. Quarry Tile V.I.F. Verify in Field Joist V.T.R. Vent Through Roof Joint R Riser V.W.R. Vinyl Wall Covering RAD Radius	A-10.10 STAIR AND LIFT DETAILS A-10.11 STAIR AND LIFT DETAILS A-10.12 LADDER DETAILS	OL	1 100 DESCRIPTION DESCRIPTION SALES OF ANALYSIS DI ANG ON CUEET A GA	DIV. OF THE ST OFFICE OF REGI
0 - FENCES AND GATES 3.03 - GATE PER GATE SCHEDULE SHEET A-1.1 3.05 - GATE PER SCHEDULE SHEET A-1.1 (PAIR) 0 - PLANTS 0.02 - LANDSCAPE REGION PER LANDSCAPE DRAWINGS	09 30 00.09 09 51 00.01 09 51 00.03 09 51 00.04 09 51 00.05 09 54 53.01 09 64 00.01 09 65 00.01 09 65 00.02 09 65 13.01 09 68 13.01	CONTINUOUS MAIN T BAR AT EDGE OF LIGHT FIXTURE STAC CLIP AT T BAR INTERUPTION. REFERENCE DETAIL 27A/A-10.3.1 CONTINUOUS CROSS T BAR FIBERGLASS REINFORCED WALL PANELS WOOD FLOORING OVER DEPRESSED CONCRETE SLAB. FINISH PER FINISH SCHEDULE ON SHEET A-8.2 RESILIENT BASE PER FINISH SCHEDULE TILE FLOORING SEE A-8.2 VINYL STAIR NOSING PER DETAILS 4 AND 5/A-10.9 TILE CARPETING 24"x24"	AUTO. BD. B.F.G. BITUM. BLDG. BLK. BLKG B.M. BM	Asphalt ELEV. Elevator INFO. Automatic EMER. Emergency INSUL. ENCL. Enclosure INT. Board E.P. Electrical Panelboard INV. Below Finish Grade EQ. Equal Bituminous EQUIP. Equipment JAN. Building E.W. Each Way JST. Block E.W.C. Electric Water Cooler JT. Blocking EH. Exhaust Bench Mark EXPO. Exposed KIT. Beam EXP. Expansion K.P.	Information Towel Dispenser / Insulation Waste Receptacle VAR. Varies Interior PTN. Partition V.B. Vapor Barrier Invert PVMT. Pavement VERT. Vertical VEST. Vestibule Janitor Q.T. Quarry Tile V.I.F. Verify in Field Joist V.T.R. Vent Through Roof Joint R Riser V.W.R. Vinyl Wall Covering RAD Radius Kitchen R.D. Roof Drain W. West Kick Plate REF. Reference W/ With	A-10.10 STAIR AND LIFT DETAILS A-10.11 STAIR AND LIFT DETAILS A-10.12 LADDER DETAILS	OL	DESIGNATION, REFERENCE EXIT ANALYSIS PLANS ON SHEET A-2.4.	DIV. OF THE ST OFFICE OF REGU 04-1
0 - FENCES AND GATES 3.03 - GATE PER GATE SCHEDULE SHEET A-1.1 3.05 - GATE PER SCHEDULE SHEET A-1.1 (PAIR) 0 - PLANTS 0.02 - LANDSCAPE REGION PER LANDSCAPE DRAWINGS 0.03 - AT GRADE PLANTER	09 30 00.09 09 51 00.01 09 51 00.03 09 51 00.04 09 51 00.05 09 54 53.01 09 64 00.01 09 65 00.01 09 65 00.02 09 65 13.01 09 68 13.01 09 77 23.01	CONTINUOUS MAIN T BAR AT EDGE OF LIGHT FIXTURE STAC CLIP AT T BAR INTERUPTION. REFERENCE DETAIL 27A/A-10.3.1 CONTINUOUS CROSS T BAR FIBERGLASS REINFORCED WALL PANELS WOOD FLOORING OVER DEPRESSED CONCRETE SLAB. FINISH PER FINISH SCHEDULE ON SHEET A-8.2 RESILIENT BASE PER FINISH SCHEDULE TILE FLOORING SEE A-8.2 VINYL STAIR NOSING PER DETAILS 4 AND 5/A-10.9 TILE CARPETING 24"x24" VINYL FABRIC-WRAPPED/TACKWALL PANEL. REFERENCE DETAIL 3/A-10.6	AUTO. BD. B.F.G. BITUM. BLDG. BLK. BLKG	Asphalt ELEV. Elevator INFO. Automatic EMER. Emergency INSUL. ENCL. Enclosure INT. Board E.P. Electrical Panelboard INV. Below Finish Grade EQ. Equal Bituminous EQUIP. Equipment JAN. Building E.W. Each Way JST. Block E.W.C. Electric Water Cooler JT. Blocking EH. Exhaust Bench Mark EXPO. Exposed KIT. Beam EXP. Expansion K.P. Bottom of Structure EXT. Exterior KVA. Bearing Brick FAS. Fasten(er)	Information Insulation Interior Invert Invert Janitor Joist Joint Kitchen Kilovolt Amperes Kilowatt REINF. Kilowatt Interior Invert PTN. Partition Waste Receptacle VAR. Varies VAR. Vinyl Walrourier VEST. Vestibule V.I.F. Verify in Field V.T.R. Vent Through Roof V.W.R. Vinyl Wall Covering W. West With With With Water Closet W.A.O. Wall Cleanout Wood	A-10.10 STAIR AND LIFT DETAILS A-10.11 STAIR AND LIFT DETAILS A-10.12 LADDER DETAILS A-10.13 DETAILS	OL OF 15	DESIGNATION, REFERENCE EXIT ANALYSIS PLANS ON SHEET A-2.4. T INDICATES LOCATION OF TEMPERED SAFETY GLAZING.	DIV. OF THE ST OFFICE OF REGU 04-1
0.05 - CURB CUTS PER CIVIL DRAWINGS 0 - FENCES AND GATES 3.03 - GATE PER GATE SCHEDULE SHEET A-1.1 3.05 - GATE PER SCHEDULE SHEET A-1.1 (PAIR) 0 - PLANTS 0.02 - LANDSCAPE REGION PER LANDSCAPE DRAWINGS 0.03 - AT GRADE PLANTER DN 33 - UTILITIES 0.01 - BACK FLOW PREVENTOR	09 30 00.09 09 51 00.01 09 51 00.03 09 51 00.04 09 51 00.05 09 54 53.01 09 64 00.01 09 65 00.01 09 65 00.02 09 65 13.01 09 68 13.01	CONTINUOUS MAIN T BAR AT EDGE OF LIGHT FIXTURE STAC CLIP AT T BAR INTERUPTION. REFERENCE DETAIL 27A/A-10.3.1 CONTINUOUS CROSS T BAR FIBERGLASS REINFORCED WALL PANELS WOOD FLOORING OVER DEPRESSED CONCRETE SLAB. FINISH PER FINISH SCHEDULE ON SHEET A-8.2 RESILIENT BASE PER FINISH SCHEDULE TILE FLOORING SEE A-8.2 VINYL STAIR NOSING PER DETAILS 4 AND 5/A-10.9 TILE CARPETING 24"x24" VINYL FABRIC-WRAPPED/TACKWALL PANEL. REFERENCE DETAIL 3/A-10.6 1" THICK SOUND-ABSORPTIVE PANELS REFERENCE SPECIFICATIONS, FINISH SCHEDULE AND DETAIL 26/A-10.5 MOLDED GEOMETRIC DIFFUSER PANELS REFERENCE	AUTO. BD. B.F.G. BITUM. BLDG. BLK. BLKG B.M. BM	Asphalt ELEV. Elevator INFO. Automatic EMER. Emergency INSUL. ENCL. Enclosure INT. Board E.P. Electrical Panelboard INV. Below Finish Grade EQ. Equal Bituminous EQUIP. Equipment JAN. Building E.W. Each Way JST. Block E.W.C. Electric Water Cooler JT. Blocking EH. Exhaust Bench Mark EXPO. Exposed KIT. Beam EXP. Expansion K.P. Bottom of Structure EXT. Exterior KVA. Bearing Brick FAS. Fasten(er) Bottom F.A. Fire Alarm MAS. British Thermal Unit F.B. Face Brick MAT'L	Information Insulation Interior Invert Invert Insulation Interior Invert	A-10.10 STAIR AND LIFT DETAILS A-10.11 STAIR AND LIFT DETAILS A-10.12 LADDER DETAILS	OL OF 15	DESIGNATION, REFERENCE EXIT ANALYSIS PLANS ON SHEET A-2.4.	IDENTIFICA DIV. OF THE ST. OFFICE OF REGU O4-11 A.C F.L.S DATE:
O.05 - CURB CUTS PER CIVIL DRAWINGS O - FENCES AND GATES 3.03 - GATE PER GATE SCHEDULE SHEET A-1.1 3.05 - GATE PER SCHEDULE SHEET A-1.1 (PAIR) O - PLANTS O - PLANTS O - LANDSCAPE REGION PER LANDSCAPE DRAWINGS O - AT GRADE PLANTER ON 33 - UTILITIES O - BACK FLOW PREVENTOR	09 30 00.09 09 51 00.01 09 51 00.03 09 51 00.04 09 51 00.05 09 54 53.01 09 64 00.01 09 65 00.02 09 65 13.01 09 68 13.01 09 77 23.01 09 84 13.01 09 84 16.01	CONTINUOUS MAIN T BAR AT EDGE OF LIGHT FIXTURE STAC CLIP AT T BAR INTERUPTION. REFERENCE DETAIL 27A/A-10.3.1 CONTINUOUS CROSS T BAR FIBERGLASS REINFORCED WALL PANELS WOOD FLOORING OVER DEPRESSED CONCRETE SLAB. FINISH PER FINISH SCHEDULE ON SHEET A-8.2 RESILIENT BASE PER FINISH SCHEDULE TILE FLOORING SEE A-8.2 VINYL STAIR NOSING PER DETAILS 4 AND 5/A-10.9 TILE CARPETING 24"x24" VINYL FABRIC-WRAPPED/TACKWALL PANEL. REFERENCE DETAIL 3/A-10.6 1" THICK SOUND-ABSORPTIVE PANELS REFERENCE SPECIFICATIONS, FINISH SCHEDULE AND DETAIL 26/A-10.5 MOLDED GEOMETRIC DIFFUSER PANELS REFERENCE SPECIFICATIONS AND DETAIL 26/A-10.5 MARKERBOARD. MOUNT PER DETAIL 13 & 17/A-10.5	AUTO. BD. B.F.G. BITUM. BLDG. BLK. BLKG B.M. BM B.O.S. BRG. BRK. BTM.	Asphalt ELEV. Elevator INFO. Automatic EMER. Emergency INSUL. ENCL. Enclosure INT. Board E.P. Electrical Panelboard INV. Below Finish Grade EQ. Equal Bituminous EQUIP. Equipment JAN. Building E.W. Each Way JST. Block E.W.C. Electric Water Cooler JT. Blocking EH. Exhaust Bench Mark EXPO. Exposed KIT. Beam EXP. Expansion K.P. Bottom of Structure EXT. Exterior KVA. Bearing FAS. Fasten(er) Bottom F.A. Fire Alarm MAS. British Thermal Unit F.B. Face Brick MAT'L F.C.O. Floor Cleanout MAX. Conduit F.D. Floor Drain M.C. Cabinet FDN. Foundation MECH.	Information Insulation Interior Interior Invert Inv	A-10.10 STAIR AND LIFT DETAILS A-10.11 STAIR AND LIFT DETAILS A-10.12 LADDER DETAILS A-10.13 DETAILS	OL OF 15	DESIGNATION, REFERENCE EXIT ANALYSIS PLANS ON SHEET A-2.4. T INDICATES LOCATION OF TEMPERED SAFETY GLAZING.	DIV. OF THE ST OFFICE OF REGU 04-11 A.C F.L.S DATE: DESCR
0.05 -	09 30 00.09 09 51 00.01 09 51 00.03 09 51 00.04 09 51 00.05 09 54 53.01 09 64 00.01 09 65 00.02 09 65 13.01 09 68 13.01 09 77 23.01 09 84 13.01	CONTINUOUS MAIN T BAR AT EDGE OF LIGHT FIXTURE STAC CLIP AT T BAR INTERUPTION. REFERENCE DETAIL 27A/A-10.3.1 CONTINUOUS CROSS T BAR FIBERGLASS REINFORCED WALL PANELS WOOD FLOORING OVER DEPRESSED CONCRETE SLAB. FINISH PER FINISH SCHEDULE ON SHEET A-8.2 RESILIENT BASE PER FINISH SCHEDULE TILE FLOORING SEE A-8.2 VINYL STAIR NOSING PER DETAILS 4 AND 5/A-10.9 TILE CARPETING 24"x24" VINYL FABRIC-WRAPPED/TACKWALL PANEL. REFERENCE DETAIL 3/A-10.6 1" THICK SOUND-ABSORPTIVE PANELS REFERENCE SPECIFICATIONS, FINISH SCHEDULE AND DETAIL 26/A-10.5 MOLDED GEOMETRIC DIFFUSER PANELS REFERENCE SPECIFICATIONS AND DETAIL 26/A-10.5 CUSTOM LINED GRID MARKERBOARD MOUNT PER DETAIL	AUTO. BD. B.F.G. BITUM. BLDG. BLK. BLKG B.M. BM B.O.S. BRG. BRK. BTM. B.T.U. C CAB C.B. C.D.	Asphalt ELEV. Elevator INFO. Automatic EMER. Emergency INSUL. ENCL. Enclosure INT. Board E.P. Electrical Panelboard INV. Below Finish Grade EQ. Equal Bituminous EQUIP. Equipment JAN. Building E.W. Each Way JST. Block E.W.C. Electric Water Cooler JT. Blocking EH. Exhaust Bench Mark EXPO. Exposed KIT. Beam EXP. Expansion K.P. Bottom of Structure EXT. Exterior KVA. Bearing Brick FAS. Fasten(er) Bottom F.A. Fire Alarm MAS. British Thermal Unit F.B. Face Brick MAT'L F.C.O. Floor Cleanout MAX. Conduit F.D. Floor Drain M.C. Cabinet FDN. Foundation MECH. Catch Basin F.A. Fire Extinguisher MFR. Ceiling Diffuser F.A.C. Fire Extinguisher M.H.	Information	A-10.10 STAIR AND LIFT DETAILS A-10.11 STAIR AND LIFT DETAILS A-10.12 LADDER DETAILS A-10.13 DETAILS MATERIAL SYSMBOL	_S 1.	DEFFERRED APPROVALS WINDOW SYSTEMS WITH SPANS GREATER THAN 10'-0". FABRICTION OF DEFFERED SUBMITTAL ITEMS SHALL NOT	DIV. OF THE ST OFFICE OF REGU 04-1 A.C F.L.S DATE: VOL 1 SHE PROJECT D
0.05 -	09 30 00.09 09 51 00.01 09 51 00.03 09 51 00.04 09 51 00.05 09 54 53.01 09 64 00.01 09 65 00.02 09 65 13.01 09 68 13.01 09 77 23.01 09 84 13.01 10 11 00.01 10 11 00.04 10 11 00.05	CONTINUOUS MAIN T BAR AT EDGE OF LIGHT FIXTURE STAC CLIP AT T BAR INTERUPTION. REFERENCE DETAIL 27A/A-10.3.1 CONTINUOUS CROSS T BAR FIBERGLASS REINFORCED WALL PANELS WOOD FLOORING OVER DEPRESSED CONCRETE SLAB. FINISH PER FINISH SCHEDULE ON SHEET A-8.2 RESILIENT BASE PER FINISH SCHEDULE TILE FLOORING SEE A-8.2 VINYL STAIR NOSING PER DETAILS 4 AND 5/A-10.9 TILE CARPETING 24"x24" VINYL FABRIC-WRAPPED/TACKWALL PANEL. REFERENCE DETAIL 3/A-10.6 1" THICK SOUND-ABSORPTIVE PANELS REFERENCE SPECIFICATIONS, FINISH SCHEDULE AND DETAIL 26/A-10.5 MOLDED GEOMETRIC DIFFUSER PANELS REFERENCE SPECIFICATIONS AND DETAIL 26/A-10.5 CUSTOM LINED GRID MARKERBOARD MOUNT PER DETAIL 17/A-10.5 CUSTOM HALF LINED GRID MARKERBOARD. MOUNT PER DETAIL 17/A-10.5 TACTILE ROOM IDENTIFICATION MESSAGE SIGN PER DETAIL 8/A-10.7	AUTO. BD. B.F.G. BITUM. BLDG. BLK. BLKG B.M. BM B.O.S. BRG. BRK. BTM. B.T.U. C CAB C.B. C.D. CEM CER C.F.	Asphalt ELEV. Elevator INFO. Automatic EMER. Emergency INSUL. ENCL. Enclosure INT. Board E.P. Electrical Panelboard INV. Below Finish Grade EQ. Equal Bituminous EQUIP. Equipment JAN. Building E.W. Each Way JST. Block E.W.C. Electric Water Cooler JT. Blocking EH. Exhaust Bench Mark EXPO. Exposed KIT. Beam EXP. Expansion K.P. Bottom of Structure EXT. Exterior KVA. Bearing KW Brick FAS. Fasten(er) Bottom F.A. Fire Alarm MAS. British Thermal Unit F.B. Face Brick MAT'L F.C.O. Floor Cleanout MAX. Conduit F.D. Floor Drain M.C. Cabinet FDN. Foundation MECH. Catch Basin F.A. Fire Extinguisher M.F. Ceiling Diffuser F.A.C. Fire Extinguisher M.H. Ceramic F.B. Finish Floor MIR. Cubic Feet F.C. Finish Grade MISC.	Information Insulation Waste Receptacle VAR. Varies Vapor Barrier Vertical	A-10.10 STAIR AND LIFT DETAILS A-10.11 STAIR AND LIFT DETAILS A-10.12 LADDER DETAILS A-10.13 DETAILS MATERIAL SYSMBOL	_S 1.	DEFFERRED APPROVALS WINDOW SYSTEMS WITH SPANS GREATER THAN 10'-0". FABRICTION OF DEFFERED SUBMITTAL ITEMS SHALL NOT BE STARTED UNTIL CONTRACTOR'S DRAWINGS, SPECIFICATIONS AND ENGINEERING CALCULATIONS FOR THE ACTUAL SYSTEMS TO	DIV. OF THE STOFFICE OF REGION OF THE STOFFICE OF THE ST
O0.05 - CURB CUTS PER CIVIL DRAWINGS	09 30 00.09 09 51 00.01 09 51 00.03 09 51 00.04 09 51 00.05 09 54 53.01 09 64 00.01 09 65 00.02 09 65 13.01 09 68 13.01 09 77 23.01 09 84 13.01 09 84 16.01 10 11 00.01 10 11 00.04 10 11 00.05 10 14 00.03 10 14 00.04 10 14 00.05	CONTINUOUS MAIN T BAR AT EDGE OF LIGHT FIXTURE STAC CLIP AT T BAR INTERUPTION. REFERENCE DETAIL 27A/A-10.3.1 CONTINUOUS CROSS T BAR FIBERGLASS REINFORCED WALL PANELS WOOD FLOORING OVER DEPRESSED CONCRETE SLAB. FINISH PER FINISH SCHEDULE ON SHEET A-8.2 RESILIENT BASE PER FINISH SCHEDULE TILE FLOORING SEE A-8.2 VINYL STAIR NOSING PER DETAILS 4 AND 5/A-10.9 TILE CARPETING 24"x24" VINYL FABRIC-WRAPPED/TACKWALL PANEL. REFERENCE DETAIL 3/A-10.6 1" THICK SOUND-ABSORPTIVE PANELS REFERENCE SPECIFICATIONS, FINISH SCHEDULE AND DETAIL 26/A-10.5 MOLDED GEOMETRIC DIFFUSER PANELS REFERENCE SPECIFICATIONS AND DETAIL 26/A-10.5 CUSTOM LINED GRID MARKERBOARD MOUNT PER DETAIL 17/A-10.5 CUSTOM HALF LINED GRID MARKERBOARD. MOUNT PER DETAIL 17/A-10.5 TACTILE ROOM IDENTIFICATION MESSAGE SIGN PER DETAIL 8/A-10.7 TACTILE EXIT IDENTIFICATION SIGN PER DETAIL 13/A-10.7	BD. B.F.G. BITUM. BLDG. BLK. BLKG B.M. BM B.O.S. BRG. BRK. BTM. B.T.U. C CAB C.B. C.D. CEM CER C.F. C.F.M.	Asphalt ELEV. Elevator INFO. Automatic EMER. Emergency INSUL. ENCL. Enclosure INT. Board E.P. Electrical Panelboard INV. Below Finish Grade EQ. Equal Bituminous EQUIP. Equipment JAN. Building E.W. Each Way JST. Block E.W.C. Electric Water Cooler JT. Blocking EH. Exhaust Bench Mark EXPO. Exposed KIT. Beam EXP. Expansion K.P. Bottom of Structure EXT. Exterior KVA. Bearing Brick FAS. Fasten(er) Bottom F.A. Fire Alarm MAS. British Thermal Unit F.B. Face Brick MAT'L F.C.O. Floor Cleanout MAX. Conduit F.D. Floor Drain M.C. Cabinet FDN. Foundation MECH. Catch Basin F.A. Fire Extinguisher MFR. Ceiling Diffuser F.A.C. Fire Extinguisher MFR. Ceiling Diffuser F.A.C. Fire Extinguisher MIR. Ceramic F.B. Finish Floor MIR. Cubic Feet F.C. Finish Grade MISC. Cubic Feet F.C. Finish Grade MISC. Cubic Feet F.D. Fire Hydrant M.O. Minute F.D. Fire Hydrant M.O. Minute	Information Insulation Insulation Interior Invert I	A-10.10 STAIR AND LIFT DETAILS A-10.11 STAIR AND LIFT DETAILS A-10.12 LADDER DETAILS A-10.13 DETAILS MATERIAL SYSMBOL MASONRY CONCRETE P	_S 1.	DEFFERRED APPROVALS WINDOW SYSTEMS WITH SPANS GREATER THAN 10'-0". FABRICTION OF DEFFERED SUBMITTAL ITEMS SHALL NOT BE STARTED UNTIL CONTRACTOR'S DRAWINGS, SPECIFICATIONS	DIV. OF THE ST OFFICE OF REGU O4-11 A.C F.L.S DATE: VOL 1 SHE PROJECT D CODES, K ABBREV
O0.05 - CURB CUTS PER CIVIL DRAWINGS O0 - FENCES AND GATES 13.03 - GATE PER GATE SCHEDULE SHEET A-1.1 13.05 - GATE PER SCHEDULE SHEET A-1.1 (PAIR) O0 - PLANTS O0.02 - LANDSCAPE REGION PER LANDSCAPE DRAWINGS O0.03 - AT GRADE PLANTER ION 33 - UTILITIES O0.01 - BACK FLOW PREVENTOR O0.02 - HELIX EASEMENT PROJECT GENERAL NOTES	09 30 00.09 09 51 00.01 09 51 00.03 09 51 00.04 09 51 00.05 09 54 53.01 09 64 00.01 09 65 00.02 09 65 13.01 09 68 13.01 09 77 23.01 09 84 13.01 09 84 16.01 10 11 00.01 10 11 00.04 10 11 00.05 10 14 00.03 10 14 00.04	CONTINUOUS MAIN T BAR AT EDGE OF LIGHT FIXTURE STAC CLIP AT T BAR INTERUPTION. REFERENCE DETAIL 27A/A-10.3.1 CONTINUOUS CROSS T BAR FIBERGLASS REINFORCED WALL PANELS WOOD FLOORING OVER DEPRESSED CONCRETE SLAB. FINISH PER FINISH SCHEDULE ON SHEET A-8.2 RESILIENT BASE PER FINISH SCHEDULE TILE FLOORING SEE A-8.2 VINYL STAIR NOSING PER DETAILS 4 AND 5/A-10.9 TILE CARPETING 24"x24" VINYL FABRIC-WRAPPED/TACKWALL PANEL. REFERENCE DETAIL 3/A-10.6 1" THICK SOUND-ABSORPTIVE PANELS REFERENCE SPECIFICATIONS, FINISH SCHEDULE AND DETAIL 26/A-10.5 MOLDED GEOMETRIC DIFFUSER PANELS REFERENCE SPECIFICATIONS AND DETAIL 26/A-10.5 CUSTOM LINED GRID MARKERBOARD MOUNT PER DETAIL 17/A-10.5 CUSTOM HALF LINED GRID MARKERBOARD. MOUNT PER DETAIL 17/A-10.5 TACTILE ROOM IDENTIFICATION MESSAGE SIGN PER DETAIL 8/A-10.7 TACTILE EXIT IDENTIFICATION SIGN PER DETAIL 13/A-10.7	AUTO. BD. B.F.G. BITUM. BLDG. BLK. BLKG B.M. BM B.O.S. BRG. BRK. BTM. B.T.U. C CAB C.B. C.D. CEM CER C.F.	Asphalt ELEV. Elevator INFO. Automatic EMER. Emergency INSUL. ENCL. Enclosure INT. Board E.P. Electrical Panelboard INV. Below Finish Grade EQ. Equal Bituminous EQUIP. Equipment JAN. Building E.W. Each Way JST. Block E.W.C. Electric Water Cooler JT. Blocking EH. Exhaust Bench Mark EXPO. Exposed KIT. Beam EXP. Expansion K.P. Bottom of Structure EXT. Exterior KVA. Bearing KW Brick FAS. Fasten(er) Bottom F.A. Fire Alarm MAS. British Thermal Unit F.B. Face Brick MAT'L F.C.O. Floor Cleanout MAX. Conduit F.D. Floor Drain M.C. Cabinet FDN. Foundation MECH. Catch Basin F.A. Fire Extinguisher M.F. Ceiling Diffuser F.A.C. Fire Extinguisher M.F. Ceramic F.B. Finish Floor MIR. Cubic Feet F.C. Finish Grade MISC. Cubic Feet F.C. Fire Hydrant M.O.	Information Insulation Interior Invert Inver	A-10.10 STAIR AND LIFT DETAILS A-10.11 STAIR AND LIFT DETAILS A-10.12 LADDER DETAILS A-10.13 DETAILS MATERIAL SYSMBOL MASONRY CONCRETE P STEEL ROUGH WOOD R	_S 1.	DEFFERED APPROVALS WINDOW SYSTEMS WITH SPANS GREATER THAN 10'-0". FABRICTION OF DEFFERED SUBMITTAL ITEMS SHALL NOT BE STARTED UNTIL CONTRACTOR'S DRAWINGS, SPECIFICATIONS AND ENGINEERING CALCULATIONS FOR THE ACTUAL SYSTEMS TO TO BE INSTALLED HAVE BEEN ACCEPTED AND SIGNED BY THE ARCHITECT	DIV. OF THE ST OFFICE OF REGU O4-11 A.C F.L.S DATE: VOL 1 SHE PROJECT D CODES, K ABBREV SYMI
O0.05 - CURB CUTS PER CIVIL DRAWINGS 00 - FENCES AND GATES 13.03 - GATE PER GATE SCHEDULE SHEET A-1.1 13.05 - GATE PER SCHEDULE SHEET A-1.1 (PAIR) 00 - PLANTS 00.02 - LANDSCAPE REGION PER LANDSCAPE DRAWINGS 00.03 - AT GRADE PLANTER ION 33 - UTILITIES 00.01 - BACK FLOW PREVENTOR 00.02 - HELIX EASEMENT PROJECT GENERAL NOTES CHANGES TO THE APPROVED DRAWINGS OR SPECIFICATION SHALL BE MADE BY AN ADDENDA OR A CONSTRUCTION CHANGE DOCUMENT (C.C.D.) APPROVED BY THE DIVISION OF THE STATE ARCHITECT	09 30 00.09 09 51 00.01 09 51 00.03 09 51 00.04 09 51 00.05 09 54 53.01 09 64 00.01 09 65 00.02 09 65 13.01 09 68 13.01 09 77 23.01 09 84 16.01 10 11 00.01 10 11 00.04 10 11 00.05 10 14 00.03 10 14 00.04 10 14 00.05 10 14 00.06	CONTINUOUS MAIN T BAR AT EDGE OF LIGHT FIXTURE STAC CLIP AT T BAR INTERUPTION. REFERENCE DETAIL 27A/A-10.3.1 CONTINUOUS CROSS T BAR FIBERGLASS REINFORCED WALL PANELS WOOD FLOORING OVER DEPRESSED CONCRETE SLAB. FINISH PER FINISH SCHEDULE ON SHEET A-8.2 RESILIENT BASE PER FINISH SCHEDULE TILE FLOORING SEE A-8.2 VINYL STAIR NOSING PER DETAILS 4 AND 5/A-10.9 TILE CARPETING 24"x24" VINYL FABRIC-WRAPPED/TACKWALL PANEL. REFERENCE DETAIL 3/A-10.6 1" THICK SOUND-ABSORPTIVE PANELS REFERENCE SPECIFICATIONS, FINISH SCHEDULE AND DETAIL 26/A-10.5 MOLDED GEOMETRIC DIFFUSER PANELS REFERENCE SPECIFICATIONS AND DETAIL 26/A-10.5 MARKERBOARD. MOUNT PER DETAIL 13 & 17/A-10.5 CUSTOM LINED GRID MARKERBOARD MOUNT PER DETAIL 17/A-10.5 TACTILE ROOM IDENTIFICATION MESSAGE SIGN PER DETAIL 8/A-10.7 TACTILE EXIT ROUTE IDENTIFICATION SIGN PER DETAIL 13/A-10.7 FIRE RISER ROOM IDENTIFICATION SIGN PER DETAIL 15/A-10.7 WALL MOUNTED TACTILE RESTROOM IDENTIFICATION SIGN PER DETAILS 10/A-10.7 DOOR MOUNTED PICTOGRAM RESTROOM IDENTIFICATION SIGN PER DETAILS 5/A-10.7	BD. B.F.G. BITUM. BLDG. BLK. BLKG B.M. BM B.O.S. BRG. BRK. BTM. B.T.U. C CAB C.B. C.D. CEM CER C.F. C.F.M.	Asphalt Automatic EMER. Emergency INSUL. ENCL. Enclosure INT. Board E.P. Electrical Panelboard INV. Below Finish Grade EQ. Equal Bituminous EQUIP. Equipment JAN. Building E.W. Each Way JST. Block E.W.C. Electric Water Cooler JT. Blocking EH. Exhaust Exposed KIT. Beam EXP. Expansion K.P. Bottom of Structure EXT. Exterior KVA. Bearing Fick FAS. Fasten(er) Bottom F.A. Fire Alarm MAS. British Thermal Unit F.B. Face Brick MAT'L F.C.O. Floor Cleanout MAX. Conduit F.D. Floor Drain M.C. Cabinet FDN. Foundation MECH. Catch Basin F.A. Fire Extinguisher MFR. Ceiling Diffuser F.A.C. Fire Extinguisher MFR. Ceiling Diffuser F.B. Finish Floor MIR. Cubic Feet per F.D. Fire Hydrant M.O. Minute F.D. Fire Hydrant M.O. Minute F.D. Fire Hydrant M.O. Minute F.D. Fire Hodrant MTD Corner Guard FIN. Finish MTL. Cast Iron F.L. Floor Cast Iron Pipe FLUOR Fluorescent N.I.C.	Information Insulation Interior Insulation Invert I	A-10.10 STAIR AND LIFT DETAILS A-10.11 STAIR AND LIFT DETAILS A-10.12 LADDER DETAILS A-10.13 DETAILS MATERIAL SYSMBOL MASONRY CONCRETE P STEEL ROUGH WOOD FRAMING	S 1. PLASTER	DEFFERED APPROVALS WINDOW SYSTEMS WITH SPANS GREATER THAN 10'-0". FABRICTION OF DEFFERED SUBMITTAL ITEMS SHALL NOT BE STARTED UNTIL CONTRACTOR'S DRAWINGS, SPECIFICATIONS AND ENGINEERING CALCULATIONS FOR THE ACTUAL SYSTEMS TO TO BE INSTALLED HAVE BEEN ACCEPTED AND SIGNED BY THE ARCHITECT OR STRUCURAL ENGINEER OF RECORD AND APROVED BY DSA	DIV. OF THE STOFFICE OF REGION OF THE STOFFICE OF REGION OF THE STOFFICE OF REGION OF THE STOFFICE OF THE STOF
O0.05 - CURB CUTS PER CIVIL DRAWINGS 00 - FENCES AND GATES 13.03 - GATE PER GATE SCHEDULE SHEET A-1.1 13.05 - GATE PER SCHEDULE SHEET A-1.1 (PAIR) 100 - PLANTS 100.02 - LANDSCAPE REGION PER LANDSCAPE DRAWINGS 100.03 - AT GRADE PLANTER 100.01 - BACK FLOW PREVENTOR 100.02 - HELIX EASEMENT PROJECT GENERAL NOTES CHANGES TO THE APPROVED DRAWINGS OR SPECIFICATION SHALL BE MADE BY AN ADDENDA OR A CONSTRUCTION CHANGE DOCUMENT (C.C.D.) APPROVED BY THE DIVISION OF THE STATE ARCHITECT ALL WORK SHALL CONFORM TO TITLE 24, CALIFORNIA CODE OF REGULATIONS (CCR).	09 30 00.09 09 51 00.01 09 51 00.03 09 51 00.04 09 51 00.05 09 54 53.01 09 64 00.01 09 65 00.02 09 65 13.01 09 68 13.01 09 77 23.01 09 84 16.01 10 11 00.01 10 11 00.04 10 11 00.05 10 14 00.03 10 14 00.04 10 14 00.05 10 14 00.06 10 14 00.07	CONTINUOUS MAIN T BAR AT EDGE OF LIGHT FIXTURE STAC CLIP AT T BAR INTERUPTION. REFERENCE DETAIL 27A/A-10.3.1 CONTINUOUS CROSS T BAR FIBERGLASS REINFORCED WALL PANELS WOOD FLOORING OVER DEPRESSED CONCRETE SLAB. FINISH PER FINISH SCHEDULE ON SHEET A-8.2 RESILIENT BASE PER FINISH SCHEDULE TILE FLOORING SEE A-8.2 VINYL STAIR NOSING PER DETAILS 4 AND 5/A-10.9 TILE CARPETING 24"x24" VINYL FABRIC-WRAPPED/TACKWALL PANEL. REFERENCE DETAIL 3/A-10.6 1" THICK SOUND-ABSORPTIVE PANELS REFERENCE SPECIFICATIONS, FINISH SCHEDULE AND DETAIL 26/A-10.5 MOLDED GEOMETRIC DIFFUSER PANELS REFERENCE SPECIFICATIONS AND DETAIL 26/A-10.5 MARKERBOARD. MOUNT PER DETAIL 13 & 17/A-10.5 CUSTOM LINED GRID MARKERBOARD MOUNT PER DETAIL 17/A-10.5 CUSTOM HALF LINED GRID MARKERBOARD. MOUNT PER DETAIL 17/A-10.5 TACTILE ROOM IDENTIFICATION MESSAGE SIGN PER DETAIL 8/A-10.7 TACTILE EXIT ROUTE IDENTIFICATION SIGN PER DETAIL 13/A-10.7 FIRE RISER ROOM IDENTIFICATION SIGN PER DETAIL 15/A-10.7 WALL MOUNTED TACTILE RESTROOM IDENTIFICATION SIGN PER DETAILS 10/A-10.7 DOOR MOUNTED PICTOGRAM RESTROOM IDENTIFICATION SIGN PER DETAILS 5/A-10.7 OCCUPANCY LOAD IDENTIFICATION SIGN PER DETAIL 11/A-10.7 ASSISTIVE LISTENING DEVICE SIGN PER DETAIL 11/A-10.7	AUTO. BD. B.F.G. BITUM. BLDG. BLK. BLKG B.M. BM B.O.S. BRG. BRK. BTM. B.T.U. C CAB C.B. C.D. CEM CER C.F. C.F.M. C.G. C.I. C.I.P CKT.BKR CLG. CLR. C.M.U.	Asphalt Automatic EMER. Emergency INSUL. ENCL. Enclosure INT. Board E.P. Electrical Panelboard INV. Below Finish Grade E.Q. Equal Bituminous EQUIP. Equipment JAN. Building E.W. Each Way JST. Block E.W.C. Electric Water Cooler JT. Blocking EH. Exhaust Bench Mark EXPO. Exposed KIT. Bearing KW British Thermal Unit F.A. Fire Alarm MAS. British Thermal Unit F.B. Face Brick MAT'L F.C.O. Floor Cleanout MAX. Conduit F.D. Foundation MECH. Catch Basin F.A. Fire Extinguisher MFR. Ceiling Diffuser F.A.C. Fire Extinguisher MIN. Cement Ceramic F.B. Finish Floor MIR. Cubic Feet per F.D. Fire Hydrant M.O. Minute F.D.C. Fire Hydrant M.C. Cast-in-place or FLR. Floor Clear of Misson F.C. Fire Cast Iron Pipe FLUOR Floor Eace of Stud N.T.S.	Information Insulation Interior Invert Inver	A-10.10 STAIR AND LIFT DETAILS A-10.11 STAIR AND LIFT DETAILS A-10.12 LADDER DETAILS A-10.13 DETAILS MATERIAL SYSMBOL MASONRY CONCRETE P STEEL ROUGH WOOD R	S 1. PLASTER	DEFFERED APPROVALS WINDOW SYSTEMS WITH SPANS GREATER THAN 10'-0". FABRICTION OF DEFFERED SUBMITTAL ITEMS SHALL NOT BE STARTED UNTIL CONTRACTOR'S DRAWINGS, SPECIFICATIONS AND ENGINEERING CALCULATIONS FOR THE ACTUAL SYSTEMS TO TO BE INSTALLED HAVE BEEN ACCEPTED AND SIGNED BY THE ARCHITECT OR STRUCURAL ENGINEER OF RECORD AND APROVED BY DSA (CBC, TITLE 24, PART 1 SECTION 4-317(g)))	DIV. OF THE ST OFFICE OF REGU O4-11 A.C. F.L.S DATE: DESCF VOL 1 SHE PROJECT D CODES, K ABBREV SYMI DA 09-2
O0.05 - CURB CUTS PER CIVIL DRAWINGS 00 - FENCES AND GATES 13.03 - GATE PER GATE SCHEDULE SHEET A-1.1 13.05 - GATE PER SCHEDULE SHEET A-1.1 (PAIR) 00 - PLANTS 00.02 - LANDSCAPE REGION PER LANDSCAPE DRAWINGS 00.03 - AT GRADE PLANTER SION 33 - UTILITIES 00.01 - BACK FLOW PREVENTOR 00.02 - HELIX EASEMENT PROJECT GENERAL NOTES CHANGES TO THE APPROVED DRAWINGS OR SPECIFICATION SHALL BE MADE BY AN ADDENDA OR A CONSTRUCTION CHANGE DOCUMENT (C.C.D.) APPROVED BY THE DIVISION OF THE STATE ARCHITECT	09 30 00.09 09 51 00.01 09 51 00.03 09 51 00.04 09 51 00.05 09 54 53.01 09 64 00.01 09 65 00.02 09 65 13.01 09 68 13.01 09 77 23.01 09 84 13.01 10 11 00.01 10 11 00.04 10 11 00.05 10 14 00.05 10 14 00.05 10 14 00.06 10 14 00.07 10 14 00.08 10 14 00.08	CONTINUOUS MAIN T BAR AT EDGE OF LIGHT FIXTURE STAC CLIP AT T BAR INTERUPTION. REFERENCE DETAIL 27A/A-10.3.1 CONTINUOUS CROSS T BAR FIBERGLASS REINFORCED WALL PANELS WOOD FLOORING OVER DEPRESSED CONCRETE SLAB. FINISH PER FINISH SCHEDULE ON SHEET A-8.2 RESILIENT BASE PER FINISH SCHEDULE TILE FLOORING SEE A-8.2 VINYL STAIR NOSING PER DETAILS 4 AND 5/A-10.9 TILE CARPETING 24"x24" VINYL FABRIC-WRAPPED/TACKWALL PANEL. REFERENCE DETAIL 3/A-10.6 1" THICK SOUND-ABSORPTIVE PANELS REFERENCE SPECIFICATIONS, FINISH SCHEDULE AND DETAIL 26/A-10.5 MOLDED GEOMETRIC DIFFUSER PANELS REFERENCE SPECIFICATIONS AND DETAIL 26/A-10.5 CUSTOM LINED GRID MARKERBOARD MOUNT PER DETAIL 17/A-10.5 CUSTOM HALF LINED GRID MARKERBOARD. MOUNT PER DETAIL 17/A-10.5 TACTILE ROOM IDENTIFICATION MESSAGE SIGN PER DETAIL 8/A-10.7 TACTILE EXIT IDENTIFICATION SIGN PER DETAIL 13/A-10.7 TACTILE EXIT ROUTE IDENTIFICATION SIGN PER DETAIL 15/A-10.7 WALL MOUNTED TACTILE RESTROOM IDENTIFICATION SIGN PER DETAIL 15/A-10.7 WALL MOUNTED TACTILE RESTROOM IDENTIFICATION SIGN PER DETAILS 10/A-10.7 DOOR MOUNTED PICTOGRAM RESTROOM IDENTIFICATION SIGN PER DETAILS 10/A-10.7 OCCUPANCY LOAD IDENTIFICATION SIGN PER DETAIL 11/A-10.7 ASSISTIVE LISTENING DEVICE SIGN PER DETAIL 21/A-10.7 QUANTITY OF ALD PER ELECTRICAL 8" HIGH METAL LETTERS. MOUNT TO CMU PER DETAIL 23/A-10.13 AND	AUTO. BD. B.F.G. BITUM. BLDG. BLK. BLKG B.M. BM B.O.S. BRG. BRK. BTM. B.T.U. C CAB C.B. C.D. CEM CER C.F. C.F.M. C.G. C.I. C.I.P CKT.BKR CLG. CLR. C.M.U. CNTR. C.O.	Asphalt Automatic EMER. Emergency INSUL. Board E.P. Electrical Panelboard INV. Below Finish Grade EQ. Equal Bituminous EQUIP. Equipment JAN. Building E.W. Each Way JST. Block E.W.C. Electric Water Cooler Blocking EH. Exhaust Bench Mark EXPO. Exposed KIT. Beam EXP. Expansion K.P. Bottom of Structure EXT. Exterior KVA. Bearing Brick FAS. Fasten(er) Bottom F.A. Fire Alarm MAS. British Thermal Unit F.B. Face Brick MAT'L F.C.O. Floor Cleanout MAX. Conduit F.D. Floor Drain M.C. Cabinet FDN. Foundation MECH. Catch Basin F.A. Fire Extinguisher M.F. Ceiling Diffuser F.A.C. Fire Extinguisher M.H. Ceramic F.B. Finish Floor MIR. Cubic Feet F.C. Finish Grade MISC. Cubic Feet F.C. Finish Grade MISC. Cubic Feet F.C. Finish Grade MISC. Corner Guard FIN. Finch Floor MID. Cast Iron F.L. Flow Line MUL. Cast Iron F.L. Flow Line MUL. Cast Iron Fipe FLUOR Fluorescent N.C. Ceiling F.O.F Face of Concrete N.I.C. Celling F.O.F Face of Stud N.T.S. Concrete Masonry Unit F.O.S. Face of Masonry NOM. Concrete Masonry Unit F.O.S. Face of Stud N.T.S. Cleanout FTT. Foot O.A.	Information Insulation Waste Receptacle VAR. Varies Interior PTN. Partition V.B. Vapor Barrier VERT. Vertical VERT. Vertical VERT. Vertical VI.J.F. Verify in Field V.J.F. Verify in Verify in Verify in Verify in Very in	A-10.10 STAIR AND LIFT DETAILS A-10.11 STAIR AND LIFT DETAILS A-10.12 LADDER DETAILS A-10.13 DETAILS MATERIAL SYSMBOL MASONRY CONCRETE STEEL ROUGH WOOD FRAMING	DOLYWOOD 1. 1. 1. PLYWOOD	DEFFERED APPROVALS WINDOW SYSTEMS WITH SPANS GREATER THAN 10'-0". FABRICTION OF DEFFERED SUBMITTAL ITEMS SHALL NOT BE STARTED UNTIL CONTRACTOR'S DRAWINGS, SPECIFICATIONS AND ENGINEERING CALCULATIONS FOR THE ACTUAL SYSTEMS TO TO BE INSTALLED HAVE BEEN ACCEPTED AND SIGNED BY THE ARCHITECT OR STRUCURAL ENGINEER OF RECORD AND APROVED BY DSA	DIV. OF THE ST OFFICE OF REGU O4-11 A.C. F.L.S DATE: DESCR VOL 1 SHE PROJECT D CODES, KI ABBREV SYME DA 09-2
O0.05 - CURB CUTS PER CIVIL DRAWINGS 00 - FENCES AND GATES 13.03 - GATE PER GATE SCHEDULE SHEET A-1.1 13.05 - GATE PER SCHEDULE SHEET A-1.1 (PAIR) 100 - PLANTS 100.02 - LANDSCAPE REGION PER LANDSCAPE DRAWINGS 100.03 - AT GRADE PLANTER SION 33 - UTILITIES 100.01 - BACK FLOW PREVENTOR 100.02 - HELIX EASEMENT PROJECT GENERAL NOTES CHANGES TO THE APPROVED DRAWINGS OR SPECIFICATION SHALL BE MADE BY AN ADDENDA OR A CONSTRUCTION CHANGE DOCUMENT (C.C.D.) APPROVED BY THE DIVISION OF THE STATE ARCHITECT ALL WORK SHALL CONFORM TO TITLE 24, CALIFORNIA CODE OF REGULATIONS (CCR). A PROJECT INSPECTOR EMPLOYED BY THE DISTRICT (OWNER) AND APPROVED BY THE DIVISION OF STATE ARCHITECT SHALL PROVIDE CONTINUOUS INSPECTION OF THE WORK. THE DUTIES OF THE INSPECTOR ARE DEFINED IN SECTION 4-338, PART 1, TITLE 24, CCR; CLASS 1. FOOD SERVICE FACILITIES SHALL COMPLY WITH ALL LOCAL HEALTH	09 30 00.09 09 51 00.01 09 51 00.03 09 51 00.04 09 51 00.05 09 54 53.01 09 64 00.01 09 65 00.02 09 65 13.01 09 68 13.01 09 77 23.01 09 84 13.01 10 11 00.01 10 11 00.04 10 11 00.05 10 14 00.03 10 14 00.04 10 14 00.05 10 14 00.06 10 14 00.07 10 14 00.08 10 14 00.09 10 14 00.10	CONTINUOUS MAIN T BAR AT EDGE OF LIGHT FIXTURE STAC CLIP AT T BAR INTERUPTION. REFERENCE DETAIL 27A/A-10.3.1 CONTINUOUS CROSS T BAR FIBERGLASS REINFORCED WALL PANELS WOOD FLOORING OVER DEPRESSED CONCRETE SLAB. FINISH PER FINISH SCHEDULE ON SHEET A-8.2 RESILIENT BASE PER FINISH SCHEDULE TILE FLOORING SEE A-8.2 VINYL STAIR NOSING PER DETAILS 4 AND 5/A-10.9 TILE CARPETING 24"x24" VINYL FABRIC-WRAPPED/TACKWALL PANEL. REFERENCE DETAIL 3/A-10.6 1" THICK SOUND-ABSORPTIVE PANELS REFERENCE SPECIFICATIONS, FINISH SCHEDULE AND DETAIL 26/A-10.5 MOLDED GEOMETRIC DIFFUSER PANELS REFERENCE SPECIFICATIONS AND DETAIL 26/A-10.5 CUSTOM LINED GRID MARKERBOARD MOUNT PER DETAIL 17/A-10.5 CUSTOM LINED GRID MARKERBOARD. MOUNT PER DETAIL 17/A-10.5 TACTILE ROOM IDENTIFICATION MESSAGE SIGN PER DETAIL 8/A-10.7 TACTILE EXIT ROUTE IDENTIFICATION SIGN PER DETAIL 13/A-10.7 FIRE RISER ROOM IDENTIFICATION SIGN PER DETAIL 15/A-10.7 WALL MOUNTED TACTILE RESTROOM IDENTIFICATION SIGN PER DETAILS 10/A-10.7 DOOR MOUNTED PICTOGRAM RESTROOM IDENTIFICATION SIGN PER DETAILS 5/A-10.7 OCCUPANCY LOAD IDENTIFICATION SIGN PER DETAIL 11/A-10.7 ASSISTIVE LISTENING DEVICE SIGN PER DETAIL 21/A-10.7 QUANTITY OF ALD PER ELECTRICAL	AUTO. BD. B.F.G. BITUM. BLDG. BLK. BLKG B.M. BM B.O.S. BRG. BRK. BTM. B.T.U. C CAB C.B. C.D. CEM CER C.F. C.F.M. C.G. C.I. C.I.P CKT.BKR CLG. CLR. C.M.U. CNTR. C.O.	Asphalt Automatic EMER. Emergency INSUL. ENCL. Enclosure INT. Board E.P. Electrical Panelboard INV. Below Finish Grade E.Q. Equal Bituminous EQUIP. Equipment JAN. Building E.W. Each Way JST. Block E.W.C. Electric Water Cooler JT. Blocking EH. Exhaust Bench Mark EXPO. Exposed KIT. Bearing KW British Thermal Unit F.A. Fire Alarm MAS. British Thermal Unit F.B. Face Brick MAT'L F.C.O. Floor Cleanout MAX. Conduit F.D. Foundation MECH. Catch Basin F.A. Fire Extinguisher MFR. Ceiling Diffuser F.A.C. Fire Extinguisher MIN. Cement Ceramic F.B. Finish Floor MIR. Cubic Feet per F.D. Fire Hydrant M.O. Minute F.D.C. Fire Hydrant M.C. Cast-in-place or FLR. Floor Clear of Misson F.C. Fire Cast Iron Pipe FLUOR Floor Eace of Stud N.T.S.	Information Insulation Waste Receptacle VAR. Varies Interior PTN. Partition V.B. Vapor Barrier VERT. Vertical VEST. Vestibule V.T.F. Vertical	A-10.10 STAIR AND LIFT DETAILS A-10.11 STAIR AND LIFT DETAILS A-10.12 LADDER DETAILS A-10.13 DETAILS MATERIAL SYSMBOL MASONRY CONCRETE STEEL ROUGH WOOD FRAMING RIGID INSULATION, BATT INSULATION G	DOLOGE 15 1. PLASTER PLYWOOD THE PRO "B" AND "	DEFFERRED APPROVALS WINDOW SYSTEMS WITH SPANS GREATER THAN 10'-0". FABRICTION OF DEFFERED SUBMITTAL ITEMS SHALL NOT BE STARTED UNTIL CONTRACTOR'S DRAWINGS, SPECIFICATIONS AND ENGINEERING CALCULATIONS FOR THE ACTUAL SYSTEMS TO TO BE INSTALLED HAVE BEEN ACCEPTED AND SIGNED BY THE ARCHITECT OR STRUCURAL ENGINEER OF RECORD AND APROVED BY DSA (CBC, TITLE 24, PART 1 SECTION 4-317(g))) PROJECT SCOPE	DIV. OF THE ST. OFFICE OF REGU O4-11 A.C. F.L.S DATE: DESCR VOL 1 SHE PROJECT D CODES, KI ABBREVI SYME DA 09-2 JO JO
00 - FENCES AND GATES 13.03 - GATE PER GATE SCHEDULE SHEET A-1.1 13.05 - GATE PER SCHEDULE SHEET A-1.1 (PAIR) 00 - PLANTS 00.02 - LANDSCAPE REGION PER LANDSCAPE DRAWINGS 00.03 - AT GRADE PLANTER SION 33 - UTILITIES 00.01 - BACK FLOW PREVENTOR 00.02 - HELIX EASEMENT CHANGES TO THE APPROVED DRAWINGS OR SPECIFICATION SHALL BE MADE BY AN ADDENDA OR A CONSTRUCTION CHANGE DOCUMENT (C.C.D.) APPROVED BY THE DIVISION OF THE STATE ARCHITECT ALL WORK SHALL CONFORM TO TITLE 24, CALIFORNIA CODE OF REGULATIONS (CCR), CCR), CPT DE CONSTRUCTION CHANGE DOCUMENT (C.C.D.) BY THE DIVISION OF STATE ARCHITECT SHALL PROVIDE CONTINUOUS BY THE DIVISION OF STATE ARCHITECT SHALL PROVIDE CONTINUOUS BY THE DIVISION OF STATE ARCHITECT SHALL PROVIDE CONTINUOUS INSPECTION 4-338, PART 1, TITLE 24, CCR; CLASS 1. POOD SERVICE FACILITIES SHALL COMPLY WITH ALL LOCAL HEALTH REQUIREMENTS. AND CALIFORNIA UNIFORM RETAIL FOOD FACILITIES LAWS. DRINKING WATER SHALL COMPLY WITH ALL LOCAL HEALTH REQUIREMENTS AND CALIFORNIA UNIFORM RETAIL FOOD FACILITIES LAWS. DRINKING WATER SHALL COMPLY WITH ALL LOCAL HEALTH REQUIREMENTS AND CALIFORNIA UNIFORM RETAIL FOOD FACILITIES LAWS. DRINKING WATER SHALL COMPLY WITH ALL LOCAL HEALTH DEPARTMENT REQUIREMENTS.	09 30 00.09 09 51 00.01 09 51 00.03 09 51 00.04 09 51 00.05 09 54 53.01 09 64 00.01 09 65 00.02 09 65 13.01 09 68 13.01 09 77 23.01 09 84 13.01 10 11 00.01 10 11 00.04 10 11 00.05 10 14 00.03 10 14 00.04 10 14 00.05 10 14 00.06 10 14 00.07 10 14 00.08 10 14 00.09 10 14 00.10 10 14 00.10	CONTINUOUS MAIN T BAR AT EDGE OF LIGHT FIXTURE STAC CLIP AT T BAR INTERUPTION. REFERENCE DETAIL 27A/A-10.3.1 CONTINUOUS CROSS T BAR FIBERGLASS REINFORCED WALL PANELS WOOD FLOORING OVER DEPRESSED CONCRETE SLAB. FINISH PER FINISH SCHEDULE ON SHEET A-8.2 RESILIENT BASE PER FINISH SCHEDULE TILE FLOORING SEE A-8.2 VINYL STAIR NOSING PER DETAILS 4 AND 5/A-10.9 TILE CARPETING 24"x24" VINYL FABRIC-WRAPPED/TACKWALL PANEL. REFERENCE DETAIL 3/A-10.6 1" THICK SOUND-ABSORPTIVE PANELS REFERENCE SPECIFICATIONS, FINISH SCHEDULE AND DETAIL 26/A-10.5 MOLDED GEOMETRIC DIFFUSER PANELS REFERENCE SPECIFICATIONS AND DETAIL 26/A-10.5 MARKERBOARD. MOUNT PER DETAIL 13 & 17/A-10.5 CUSTOM LINED GRID MARKERBOARD MOUNT PER DETAIL 17/A-10.5 CUSTOM HALF LINED GRID MARKERBOARD. MOUNT PER DETAIL 17/A-10.5 TACTILE EXIT IDENTIFICATION MESSAGE SIGN PER DETAIL 8/A-10.7 TACTILE EXIT ROUTE IDENTIFICATION SIGN PER DETAIL 13/A-10.7 FIRE RISER ROOM IDENTIFICATION SIGN PER DETAIL 15/A-10.7 WALL MOUNTED TACTILE RESTROOM IDENTIFICATION SIGN PER DETAILS 10/A-10.7 DOOR MOUNTED PICTOGRAM RESTROOM IDENTIFICATION SIGN PER DETAILS 5/A-10.7 OCCUPANCY LOAD IDENTIFICATION SIGN PER DETAIL 11/A-10.7 ASSISTIVE LISTENING DEVICE SIGN PER DETAIL 21/A-10.7 QUANTITY OF ALD PER ELECTRICAL 8" HIGH METAL LETTERS. MOUNT TO CMU PER DETAIL 23/A-10.13 AND METAL STUD PER DETAIL 16/A-10.1.4 20" HIGH METAL LETTERS. MOUNT TO CMU PER DETAIL 23/A-10.13 AND METAL STUD PER DETAIL 16/A-10.1.4 CALIFORNIA DISTINGUISHED SCHOOL SIGNAGE. MOUNT PER DETAIL 16/A-10.1.4	AUTO. BD. B.F.G. BITUM. BLDG. BLK. BLKG B.M. BM B.O.S. BRG. BRK. BTM. B.T.U. C CAB C.B. C.D. CEM CER C.F. C.F.M. C.G. C.I. C.I.P CKT.BKR CLG. CLR. C.M.U. CNTR. C.O. CONC. CTR. CTSK.	Asphalt Automatic ELEV. Elevator INFO. INSUL. EMER. Emergency INSUL. ENCL. Enclosure INT. Board E.P. Electrical Panelboard INV. Below Finish Grade EQ. Equal Bituminous EQUIP. Equipment JAN. Building E.W. Each Way JST. Block E.W.C. Electric Water Cooler JT. Blocking EH. Exhaust Exposed KIT. Beam EXP. Expansion K.P. Bottom of Structure EXT. Exterior KVA. Bearing Fine American MAS. British Thermal Unit F.B. Face Brick MAT'L F.C.O. Floor Cleanout MAX. Conduit F.D. Floor Cleanout MAX. Conduit F.D. Floor Drain M.C. Cabinet FDN. Foundation MECH. Catch Basin F.A. Fire Extinguisher MFR. Ceiling Diffuser F.A.C. Fire Extinguisher MIN. Ceramic F.B. Finish Floor MIR. Cubic Feet F.C. Finish Grade MISC. Cubic Feet F.C. Finish Grade MISC. Cubic Feet F.C. Finish Grade MISC. Cubic Feet F.D. Fire Hydrant M.O. Minute F.D. Floor Floor Cleanout MTD. Cast Iron F.L. Flow Line MUL. Cast Iron F.L. Flow Line MUL. Cast Iron F.C. Fine Concrete N.I.C. Ceiling F.O.F Face of Concrete N.I.C. Ceiling F.O.F Face of Stud N.T.S. Counter F.O.F. Face of Stud N.T.S. Counter F.O.F. Face of Stud N.T.S. Counter F.D. Fire Fire Fire Fire Fire Fire Fire Fire	Information Insulation Uses Receptacle VAR. Varies Uses Interior PTN. Partition V.B. Vapor Barrier VERT. Vertical VERT. Vertify in Field V.I.F. Verify in Field VII.F. Verify in Field V.I.F. Verify in Field V.I.F. Verify in V	A-10.10 STAIR AND LIFT DETAILS A-10.11 STAIR AND LIFT DETAILS A-10.12 LADDER DETAILS A-10.13 DETAILS MASONRY CONCRETE STEEL ROUGH WOOD FRAMING RIGID INSULATION, INSULATION INSULATION INSULATION RIGID INSULATION INS	PLASTER PLYWOOD THE PRO "B" AND " DEMOLIT	DEFFERRED APPROVALS WINDOW SYSTEMS WITH SPANS GREATER THAN 10'-0". FABRICTION OF DEFFERED SUBMITTAL ITEMS SHALL NOT BE STARTED UNTIL CONTRACTOR'S DRAWINGS, SPECIFICATIONS AND ENGINEERING CALCULATIONS FOR THE ACTUAL SYSTEMS TO TO BE INSTALLED HAVE BEEN ACCEPTED AND SIGNED BY THE ARCHITECT OR STRUCURAL ENGINEER OF RECORD AND APROVED BY DSA (CBC, TITLE 24, PART 1 SECTION 4-317(g))) PROJECT SCOPE DJECT CONSISTS OF: THE CONSTRUCTION OF THE EVENT CENTER; BUILDINGS "A", "C", SITE STAIRS, RAMPS, HARDSCAPE AND LANDSCAPE.	DIV. OF THE ST OFFICE OF REGU O4-11 A.C. F.L.S DATE: DESCR VOL 1 SHE PROJECT D CODES, KI ABBREV SYME DA 09-2 JO 13-03
DO.05 - CURB CUTS PER CIVIL DRAWINGS DO - FENCES AND GATES 13.03 - GATE PER GATE SCHEDULE SHEET A-1.1 13.05 - GATE PER SCHEDULE SHEET A-1.1 (PAIR) DO - PLANTS DO.02 - LANDSCAPE REGION PER LANDSCAPE DRAWINGS DO.03 - AT GRADE PLANTER DO.01 - BACK FLOW PREVENTOR DO.02 - HELIX EASEMENT CHANGES TO THE APPROVED DRAWINGS OR SPECIFICATION SHALL BE MADE BY AN ADDENDA OR A CONSTRUCTION CHANGE DOCUMENT (C.C.D.) APPROVED BY THE DIVISION OF THE STATE ARCHITECT ALL WORK SHALL CONFORM TO TITLE 24, CALIFORNIA CODE OF REGULATIONS (CCR). A PROJECT INSPECTOR EMPLOYED BY THE DISTRICT (OWNER) AND APPROVED BY THE DIVISION OF STATE ARCHITECT SHALL PROVIDE CONTINUOUS INSPECTION OF THE WORK. THE DUTIES OF THE INSPECTOR ARE DEFINED IN SECTION 4-338, PART 1, TITLE 24, CCR, CLASS 1. FOOD SERVICE FACILITIES SHALL COMPLY WITH ALL LOCAL HEALTH REQUIREMENTS AND CALIFORNIA UNIFORM RETAIL FOOD FACILITIES LAWS. DRINKING WATER SHALL COMPLY WITH ALL LOCAL HEALTH DEPARTMENT	09 30 00.09 09 51 00.01 09 51 00.03 09 51 00.04 09 51 00.05 09 54 53.01 09 64 00.01 09 65 00.02 09 65 13.01 09 68 13.01 09 77 23.01 09 84 13.01 09 84 16.01 10 11 00.01 10 11 00.04 10 11 00.05 10 14 00.05 10 14 00.05 10 14 00.07 10 14 00.08 10 14 00.09 10 14 00.10 10 14 00.12	CONTINUOUS MAIN T BAR AT EDGE OF LIGHT FIXTURE STAC CLIP AT T BAR INTERUPTION. REFERENCE DETAIL 27A/A-10.3.1 CONTINUOUS CROSS T BAR FIBERGLASS REINFORCED WALL PANELS WOOD FLOORING OVER DEPRESSED CONCRETE SLAB. FINISH PER FINISH SCHEDULE ON SHEET A-8.2 RESILIENT BASE PER FINISH SCHEDULE TILE FLOORING SEE A-8.2 VINYL STAIR NOSING PER DETAILS 4 AND 5/A-10.9 TILE CARPETING 24"x24" VINYL FABRIC-WRAPPED/TACKWALL PANEL. REFERENCE DETAIL 3/A-10.6 1" THICK SOUND-ABSORPTIVE PANELS REFERENCE SPECIFICATIONS, FINISH SCHEDULE AND DETAIL 26/A-10.5 MOLDED GEOMETRIC DIFFUSER PANELS REFERENCE SPECIFICATIONS AND DETAIL 26/A-10.5 CUSTOM LINED GRID MARKERBOARD. MOUNT PER DETAIL 17/A-10.5 CUSTOM HALF LINED GRID MARKERBOARD. MOUNT PER DETAIL 17/A-10.5 TACTILE ROOM IDENTIFICATION MESSAGE SIGN PER DETAIL 8/A-10.7 TACTILE EXIT IDENTIFICATION SIGN PER DETAIL 13/A-10.7 FIRE RISER ROOM IDENTIFICATION SIGN PER DETAIL 15/A-10.7 WALL MOUNTED TACTILE RESTROOM IDENTIFICATION SIGN PER DETAILS 10/A-10.7 DOOR MOUNTED PICTOGRAM RESTROOM IDENTIFICATION SIGN PER DETAILS 10/A-10.7 OCCUPANCY LOAD IDENTIFICATION SIGN PER DETAIL 11/A-10.7 ASSISTIVE LISTENING DEVICE SIGN PER DETAIL 21/A-10.7 QUANTITY OF ALD PER ELECTRICAL 8" HIGH METAL LETTERS. MOUNT TO CMU PER DETAIL 23/A-10.13 AND METAL STUD PER DETAIL 16/A-10.1.4 20" HIGH METAL LETTERS. MOUNT TO CMU PER DETAIL 23/A-10.13 AND METAL STUD PER DETAIL 16/A-10.1.4 CALIFORNIA DISTINGUISHED SCHOOL SIGNAGE. MOUNT PER DETAIL	AUTO. BD. B.F.G. BITUM. BLDG. BLK. BLKG B.M. BM B.O.S. BRG. BRK. BTM. B.T.U. C CAB C.B. C.D. CEM CER C.F. C.F.M. C.G. C.I. C.I.P CKT.BKR CLG. CLR. C.M.U. CNTR. C.O. CONC. CTR. CTSK.	Asphalt Automatic EMER. Emergency INFO. INSUL. Board E.P. Electrical Panelboard INV. Below Finish Grade EQ. Equal Bituminous EQUIP. Equipment JAN. Bilding E.W. Each Way JST. Block E.W.C. Electric Water Cooler Blocking EH. Exhaust Bench Mark EXPO. Expansion K.P. Bottom of Structure EXT. Exterior KVA. Bearing Brick FAS. Fasten(er) Bottom F.A. Fire Alarm MAS. British Thermal Unit F.B. Face Brick MAT'L Conduit F.D. Floor Drain M.C. Cabinet FDN. Foundation MECH. Catch Basin F.A. Fire Extinguisher MFR. Ceiling Diffuser F.A.C. Fire Extinguisher MFR. Cement Coment Cobic Feet F.C. Finish Floor MIR. Cubic Feet F.C. Finish Floor MIR. Minute F.D.C. Fire Hydrant M.O. Minute F.D.C. Fire Hydrant M.O. Minute F.D.C. Fire Hydrant M.O. Cast Iron F.L. Floor Cast Iron F.L. Floor Cast Iron Pipe FLUOR Fluorescent N.C. Collear F.O.M Face of Finish NO. Clear F.O.M Face of Finish NO. Concrete Masonry Unit F.O.S. Face of Stud N.T.S. Colleanout F.T. Foot O.A. Concrete GA. Gauge O.D.	Information Interior PTN. Partition V.B. Varies Interior PTN. Partition V.B. Vapor Barrier VERT. Vertical VEST. Vestibule V.T.F. Vertical V.T.	A-10.10 STAIR AND LIFT DETAILS A-10.11 STAIR AND LIFT DETAILS A-10.12 LADDER DETAILS A-10.13 DETAILS MASONRY CONCRETE STEEL ROUGH WOOD FRAMING RIGID INSULATION, INSULATION INSULATION INSULATION RIGID INSULATION INS	DOLOGE 15 1. PLASTER PLYWOOD THE PRO "B" AND "	DEFFERRED APPROVALS WINDOW SYSTEMS WITH SPANS GREATER THAN 10'-0". FABRICTION OF DEFFERED SUBMITTAL ITEMS SHALL NOT BE STARTED UNTIL CONTRACTOR'S DRAWINGS, SPECIFICATIONS AND ENGINEERING CALCULATIONS FOR THE ACTUAL SYSTEMS TO TO BE INSTALLED HAVE BEEN ACCEPTED AND SIGNED BY THE ARCHITECT OR STRUCURAL ENGINEER OF RECORD AND APROVED BY DSA (CBC, TITLE 24, PART 1 SECTION 4-317(g))) PROJECT SCOPE DJECT CONSISTS OF: THE CONSTRUCTION OF THE EVENT CENTER; BUILDINGS "A", "C", SITE STAIRS, RAMPS, HARDSCAPE AND LANDSCAPE.	DIV. OF THE ST OFFICE OF REGU O4-1 A.C. F.L.S DATE: DESCF VOL 1 SHE PROJECT D CODES, K ABBREV SYMI DA 09-2 JO JO

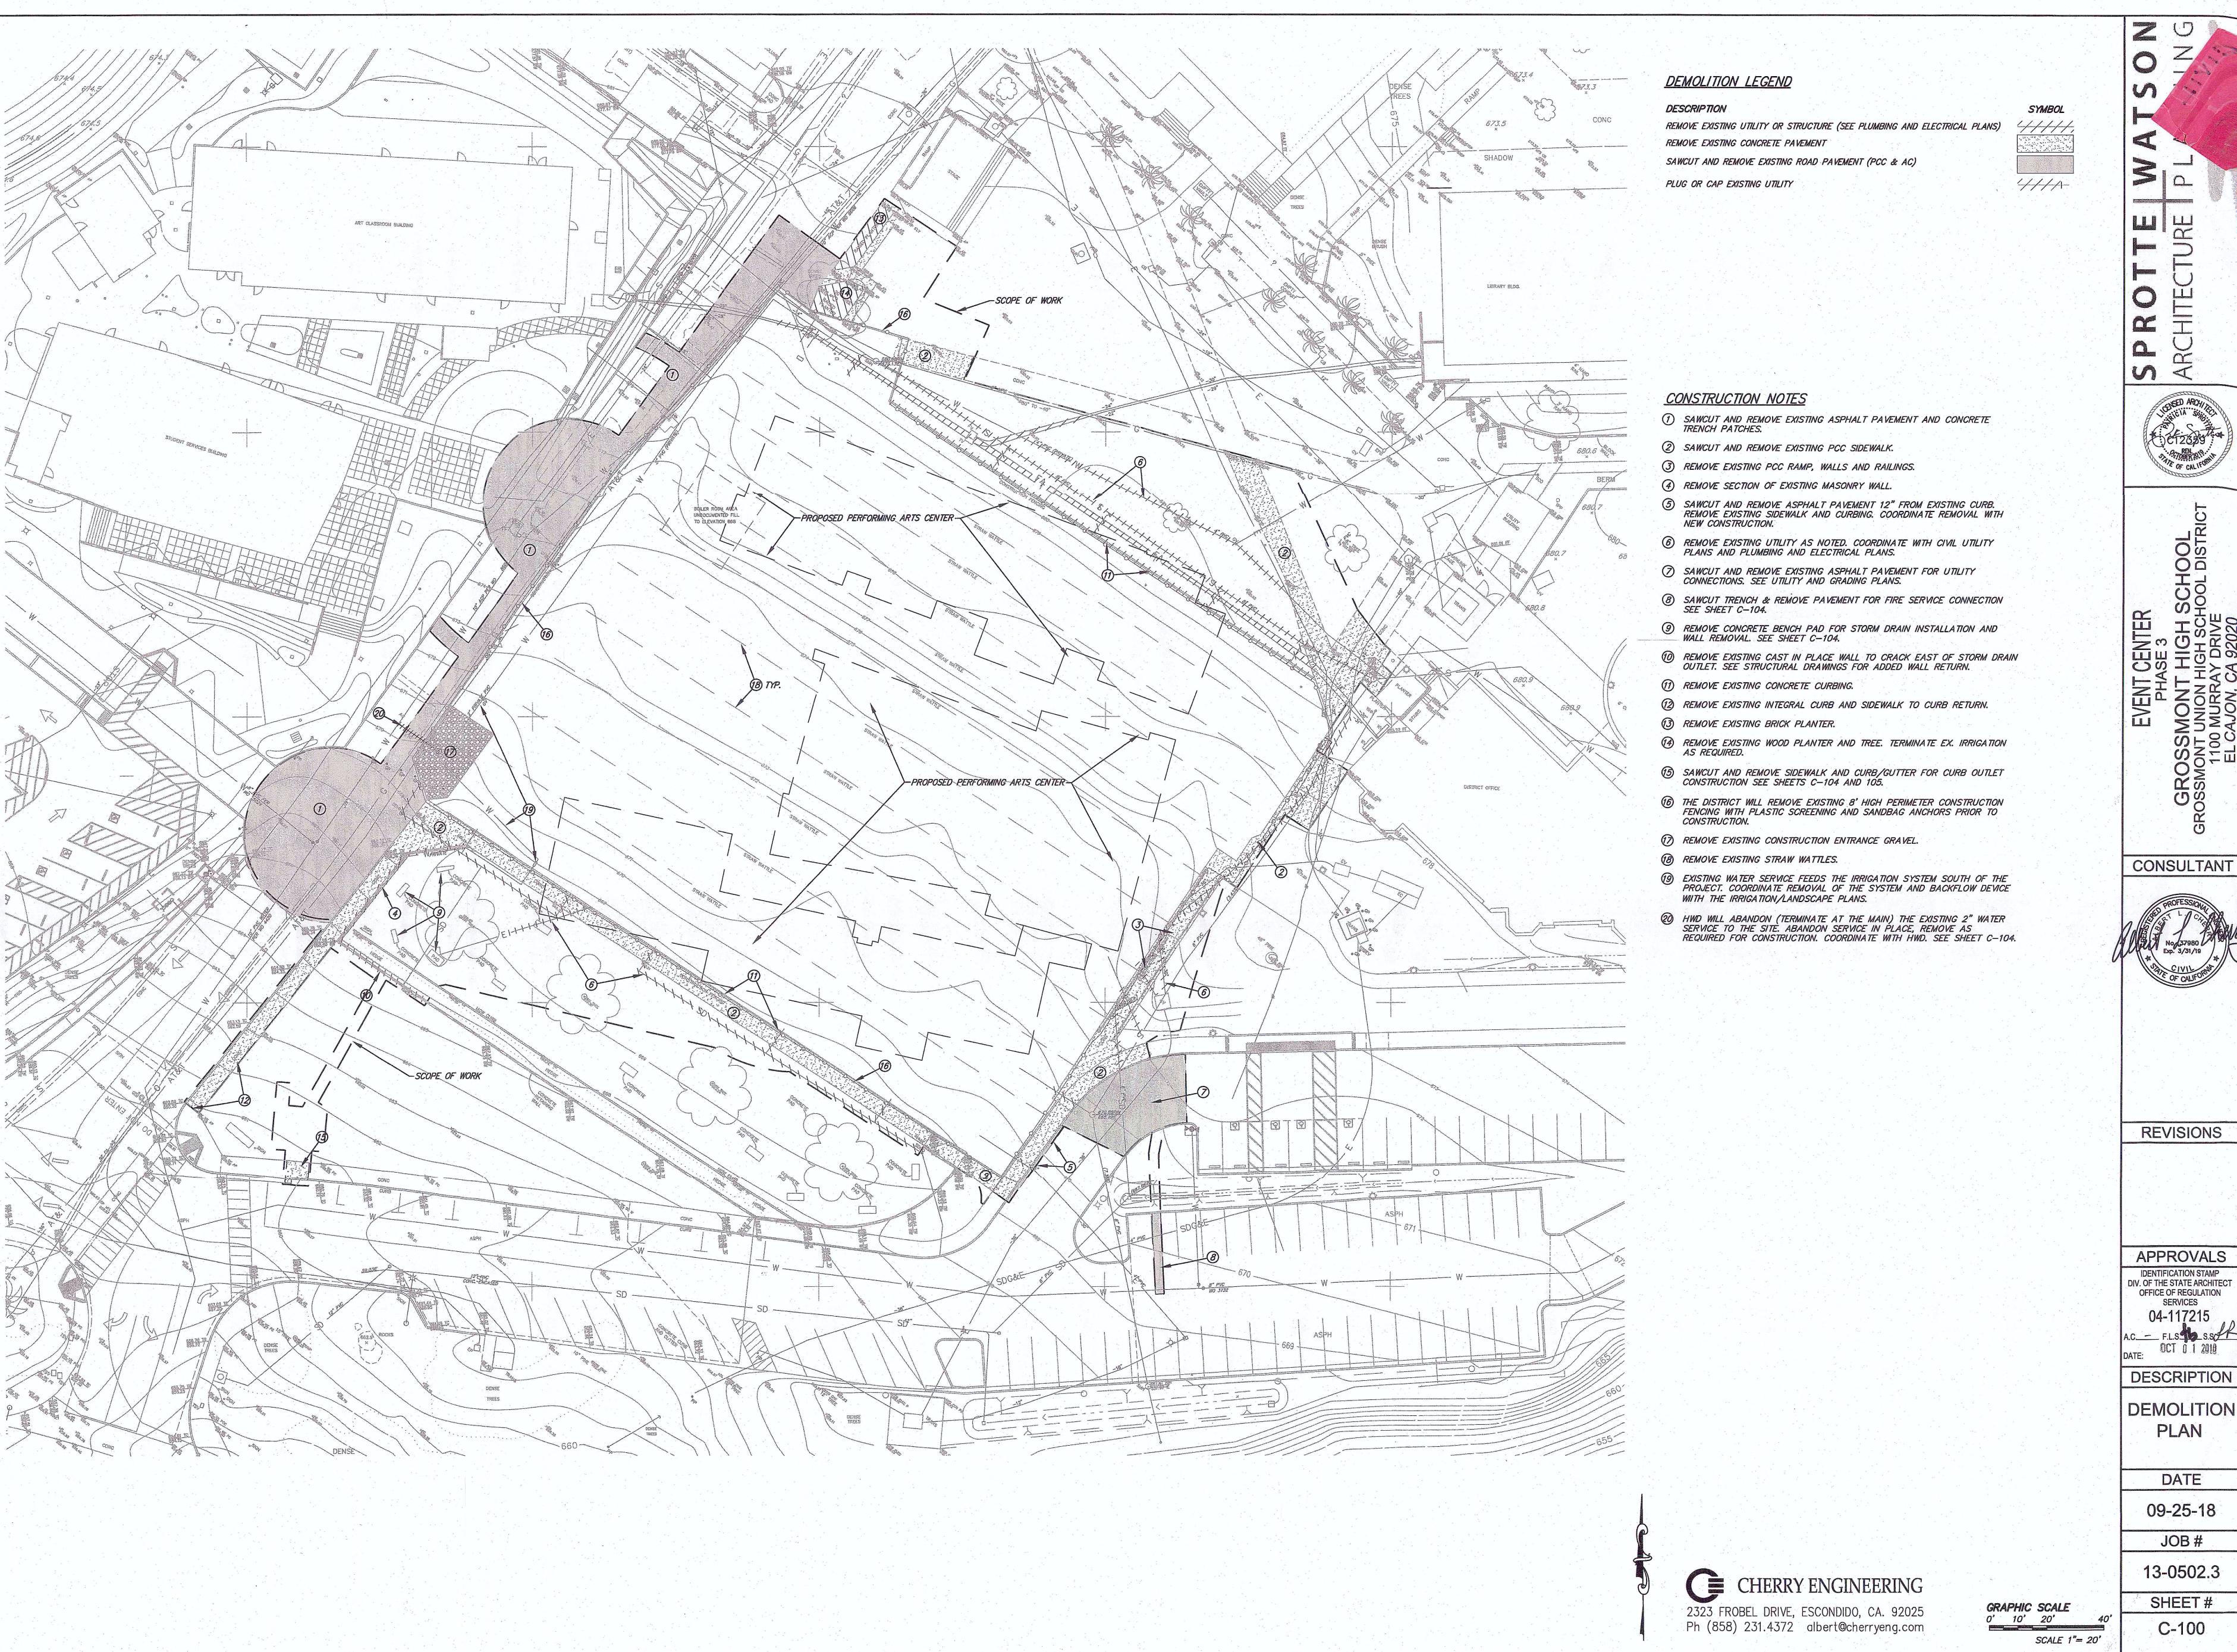

0

REVISIONS

APPROVALS IDENTIFICATION STAMP DIV. OF THE STATE ARCHITECT OFFICE OF REGULATION

OCT 0 1 2010 DESCRIPTION

DEMOLITION PLAN

DATE


09-25-18

JOB# 13-0502.3


SHEET#


C-100


P:\grossmont\cad\DRAW2\C-100 DEMOLITION PLAN.dwg

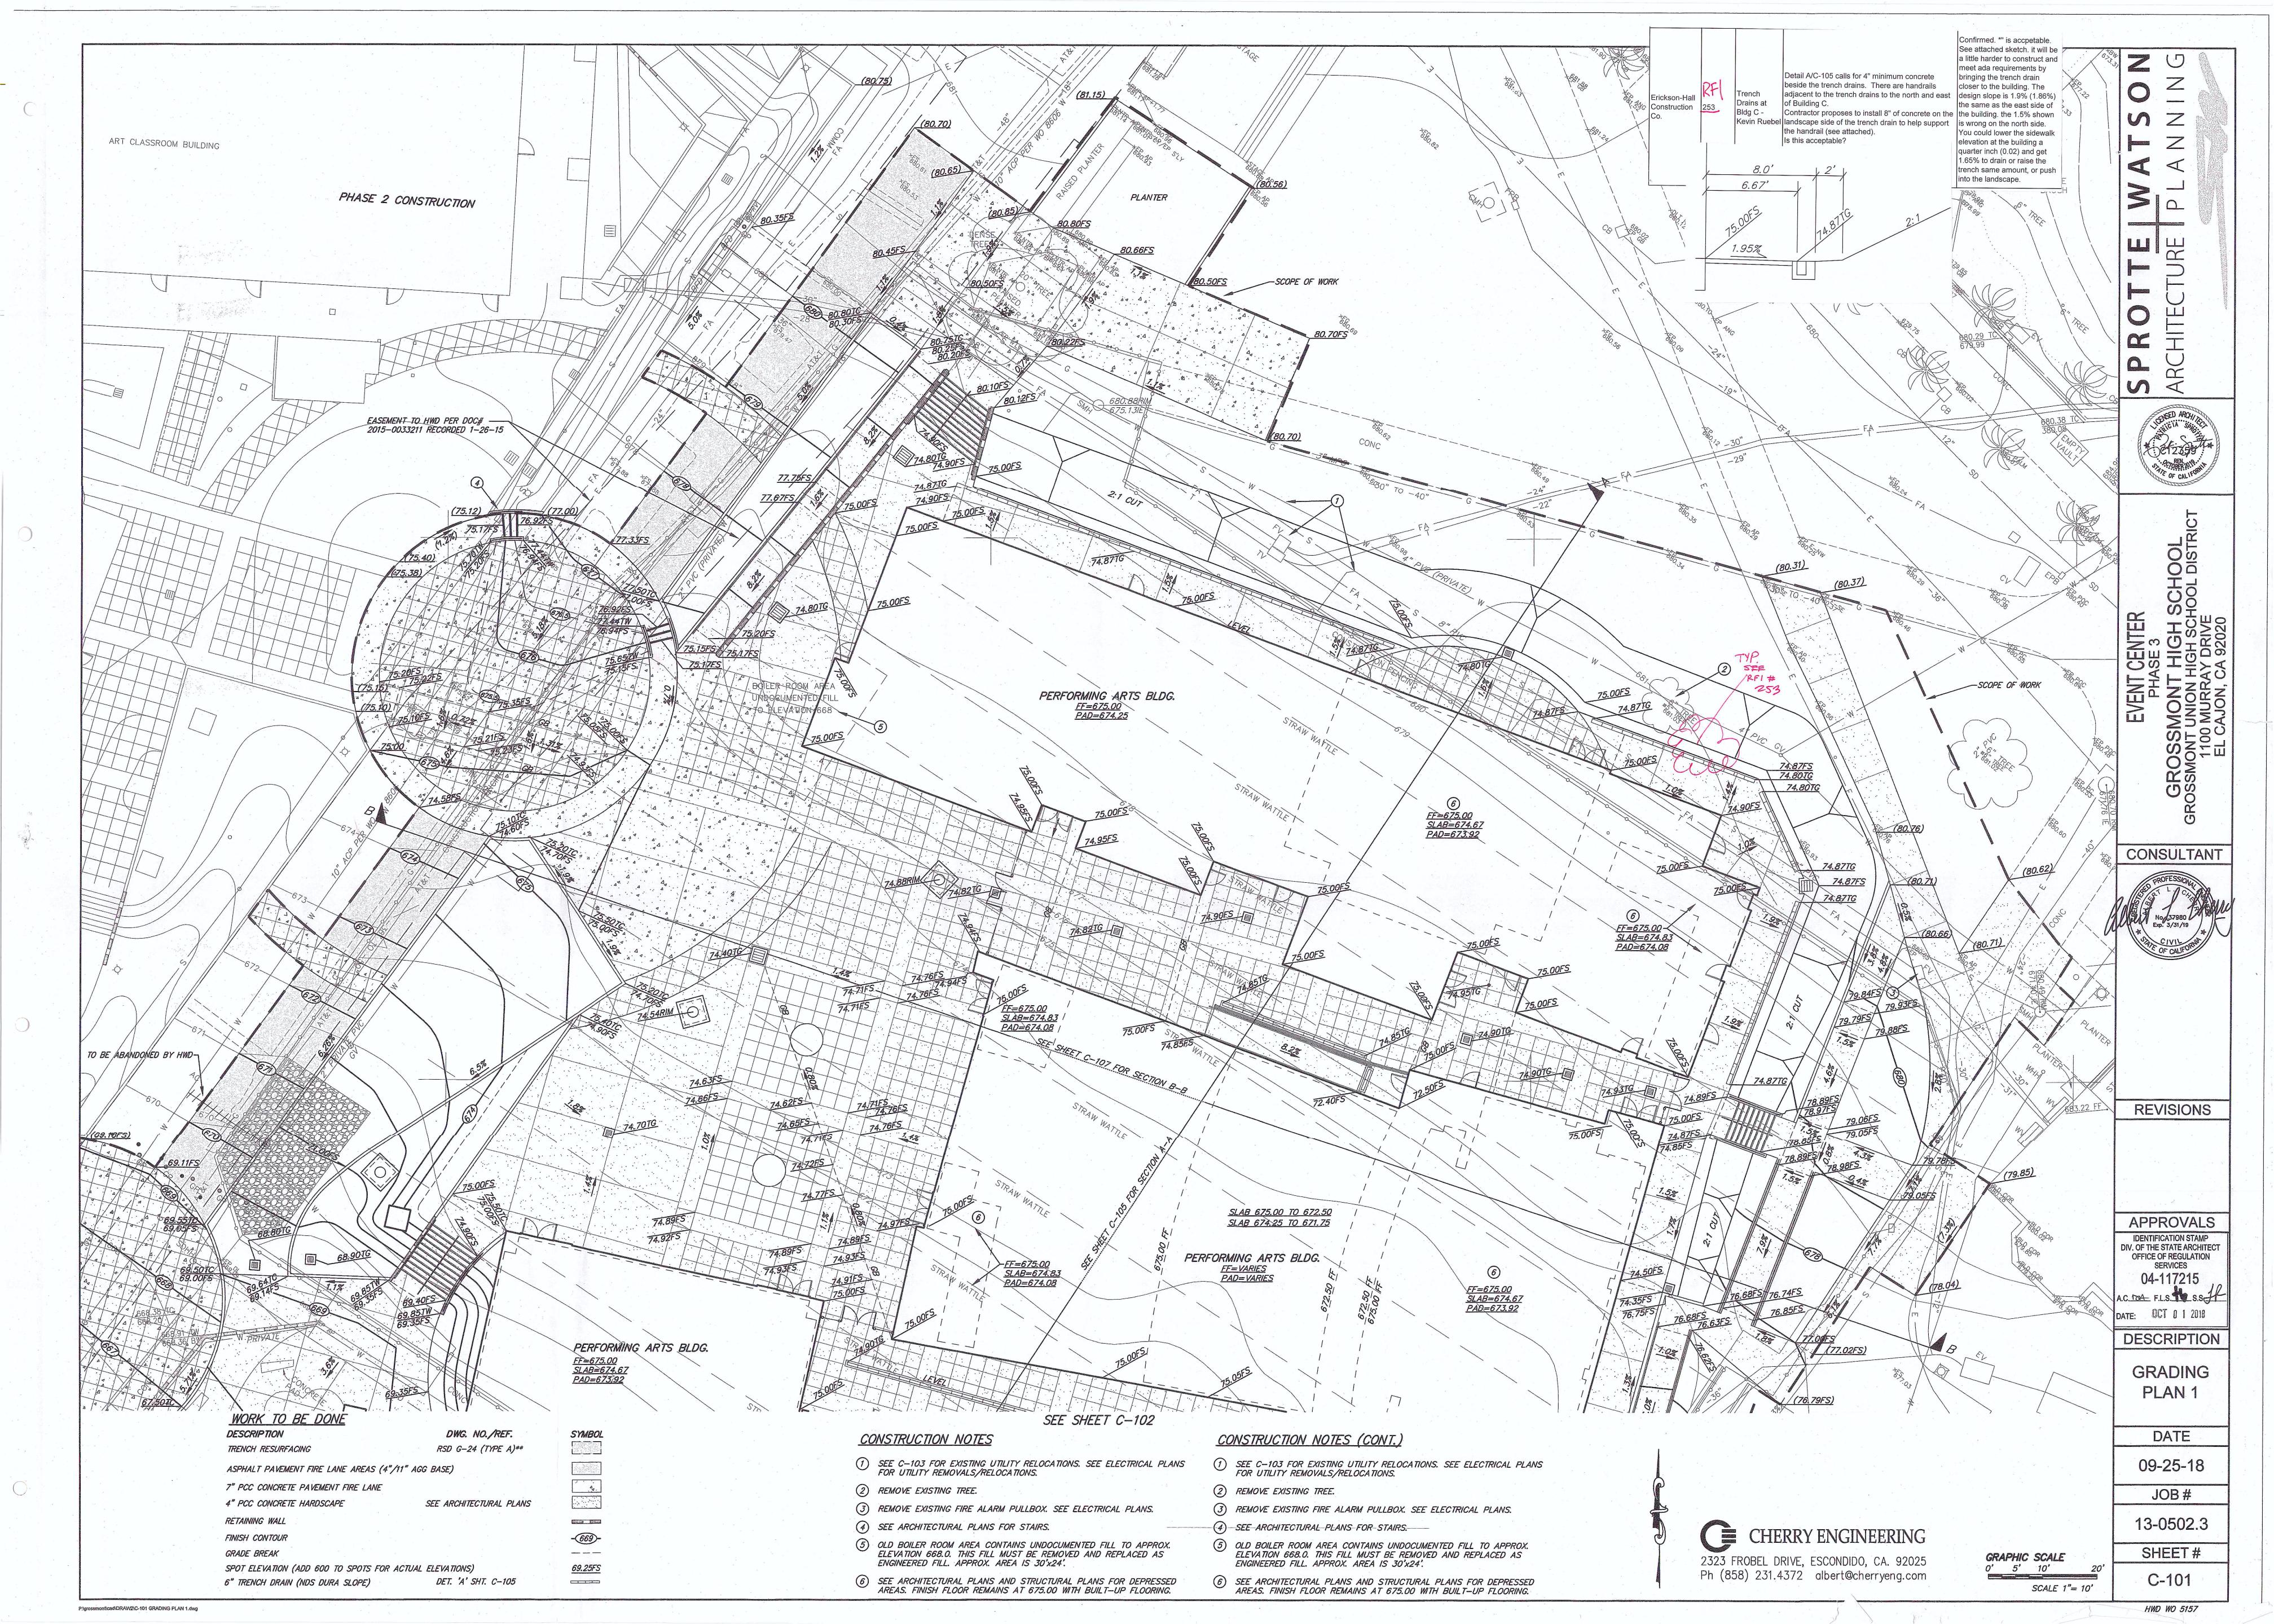





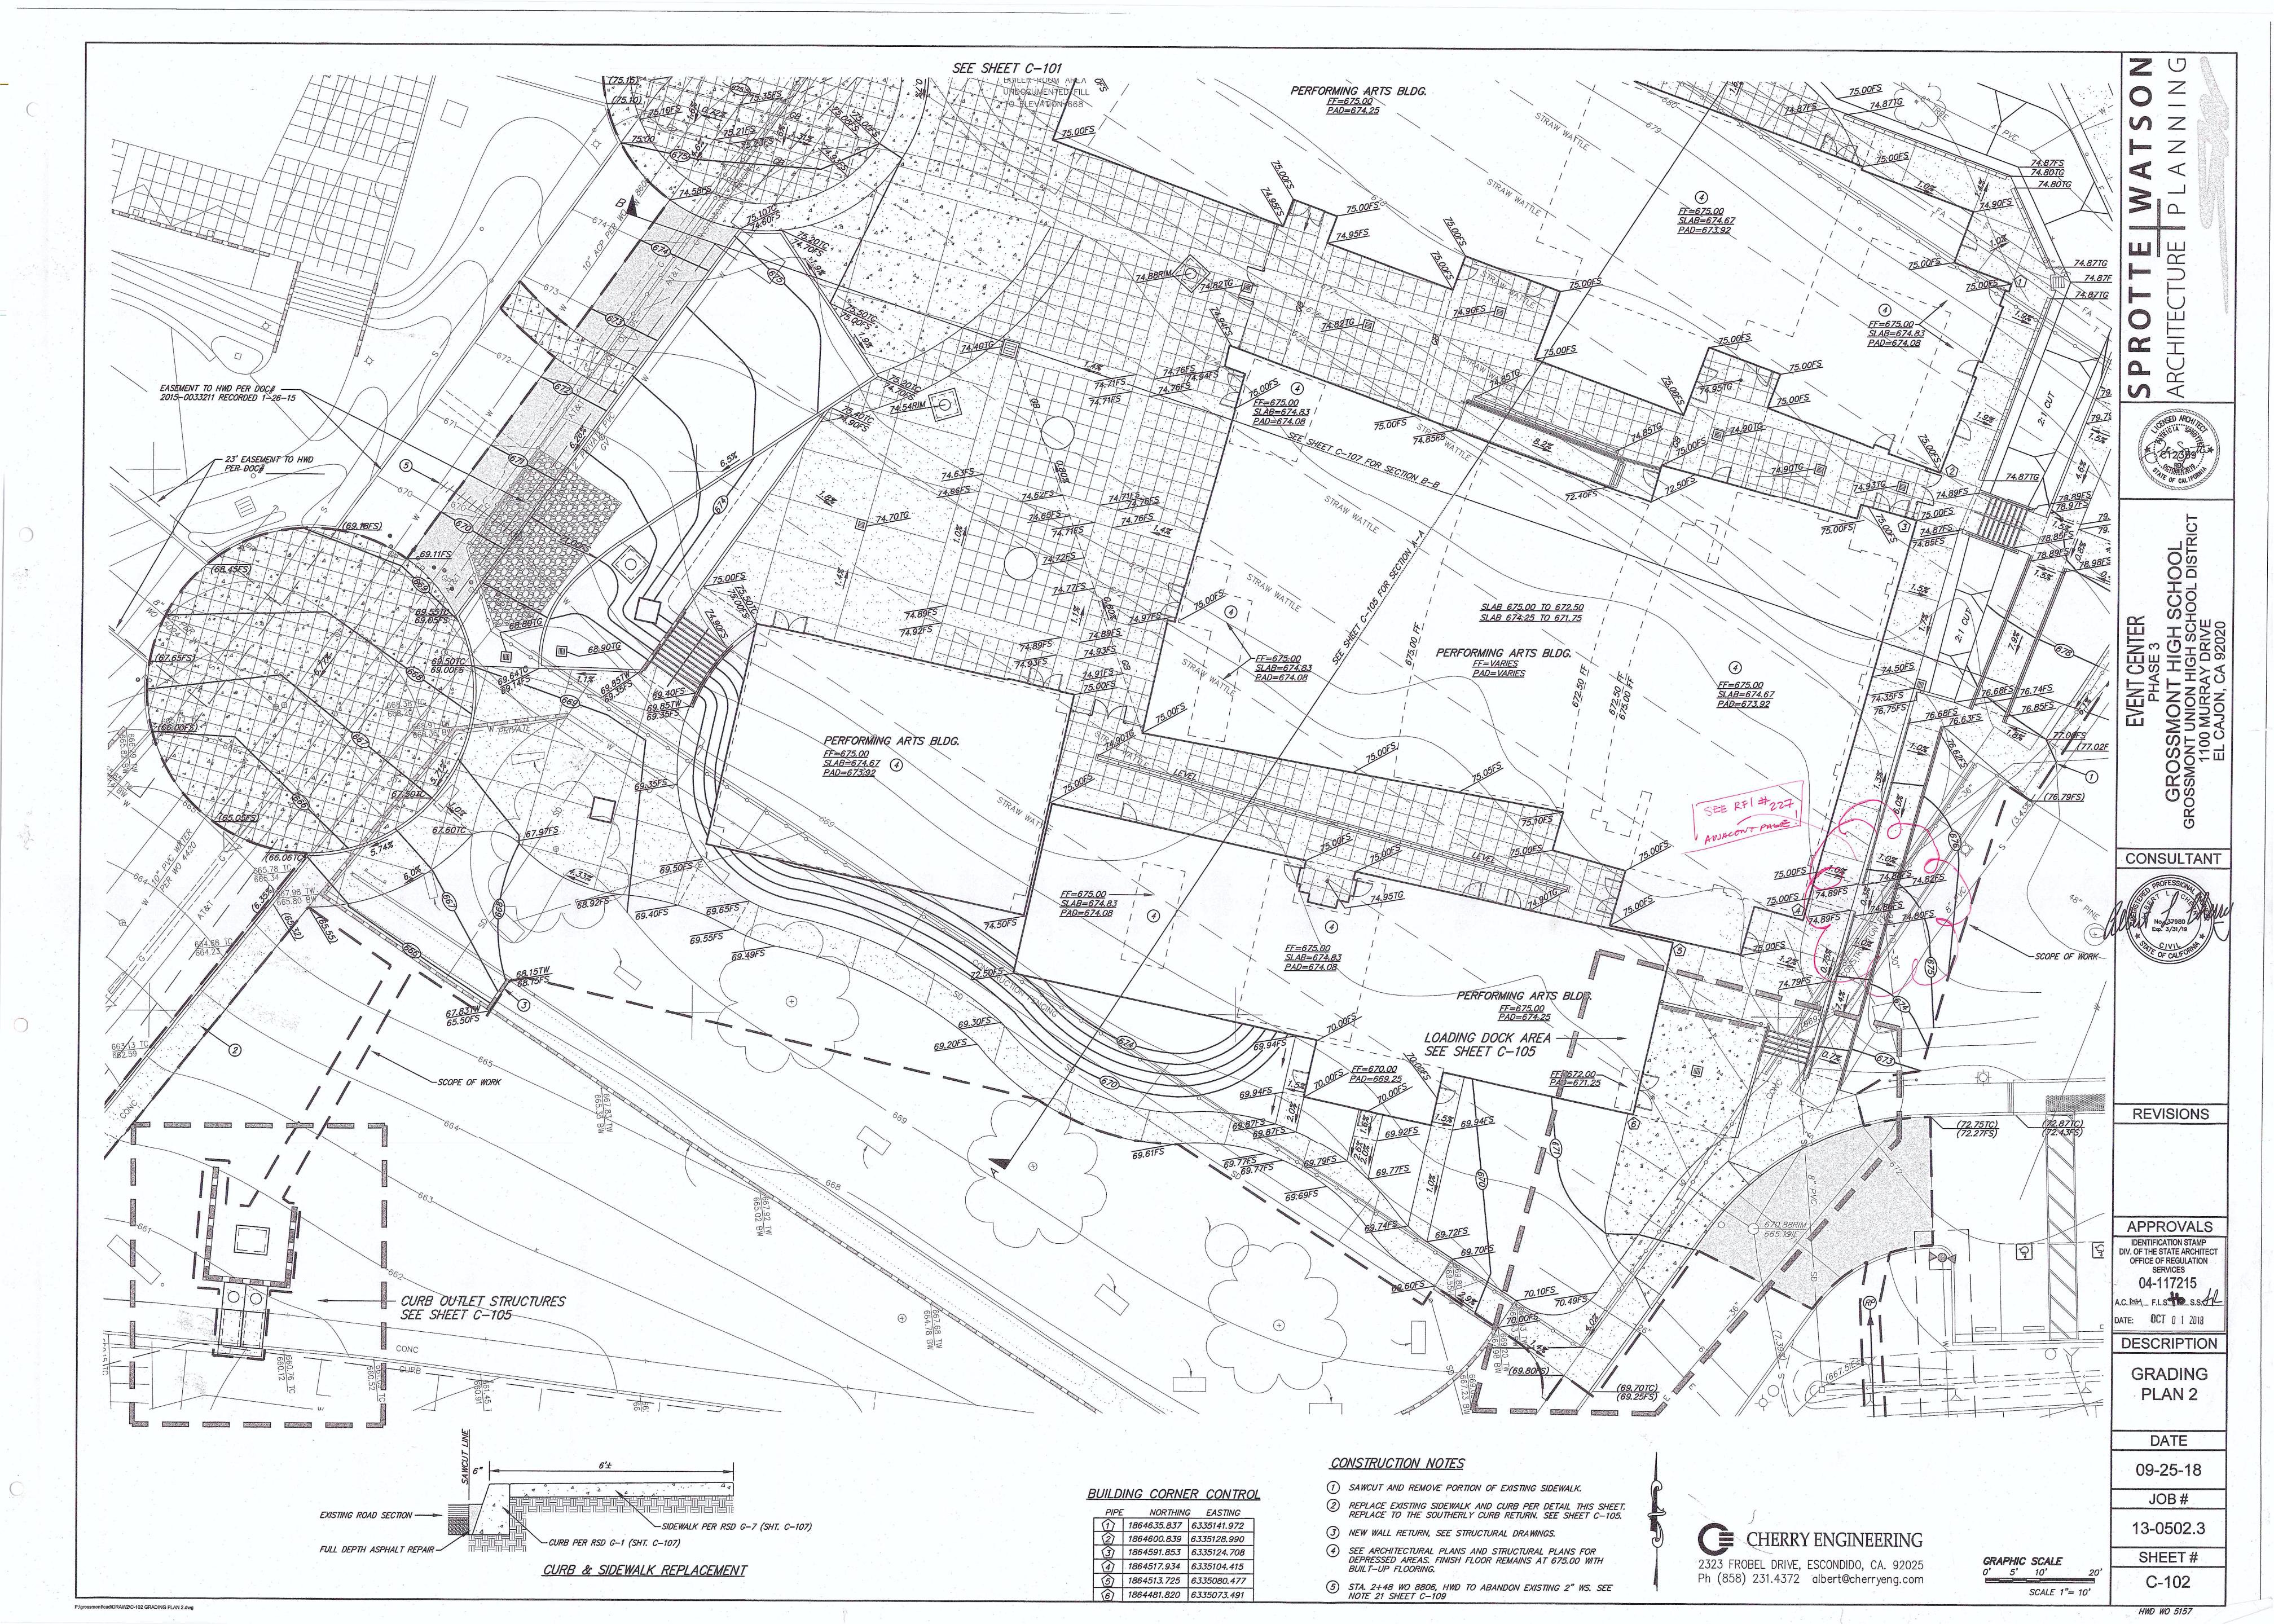


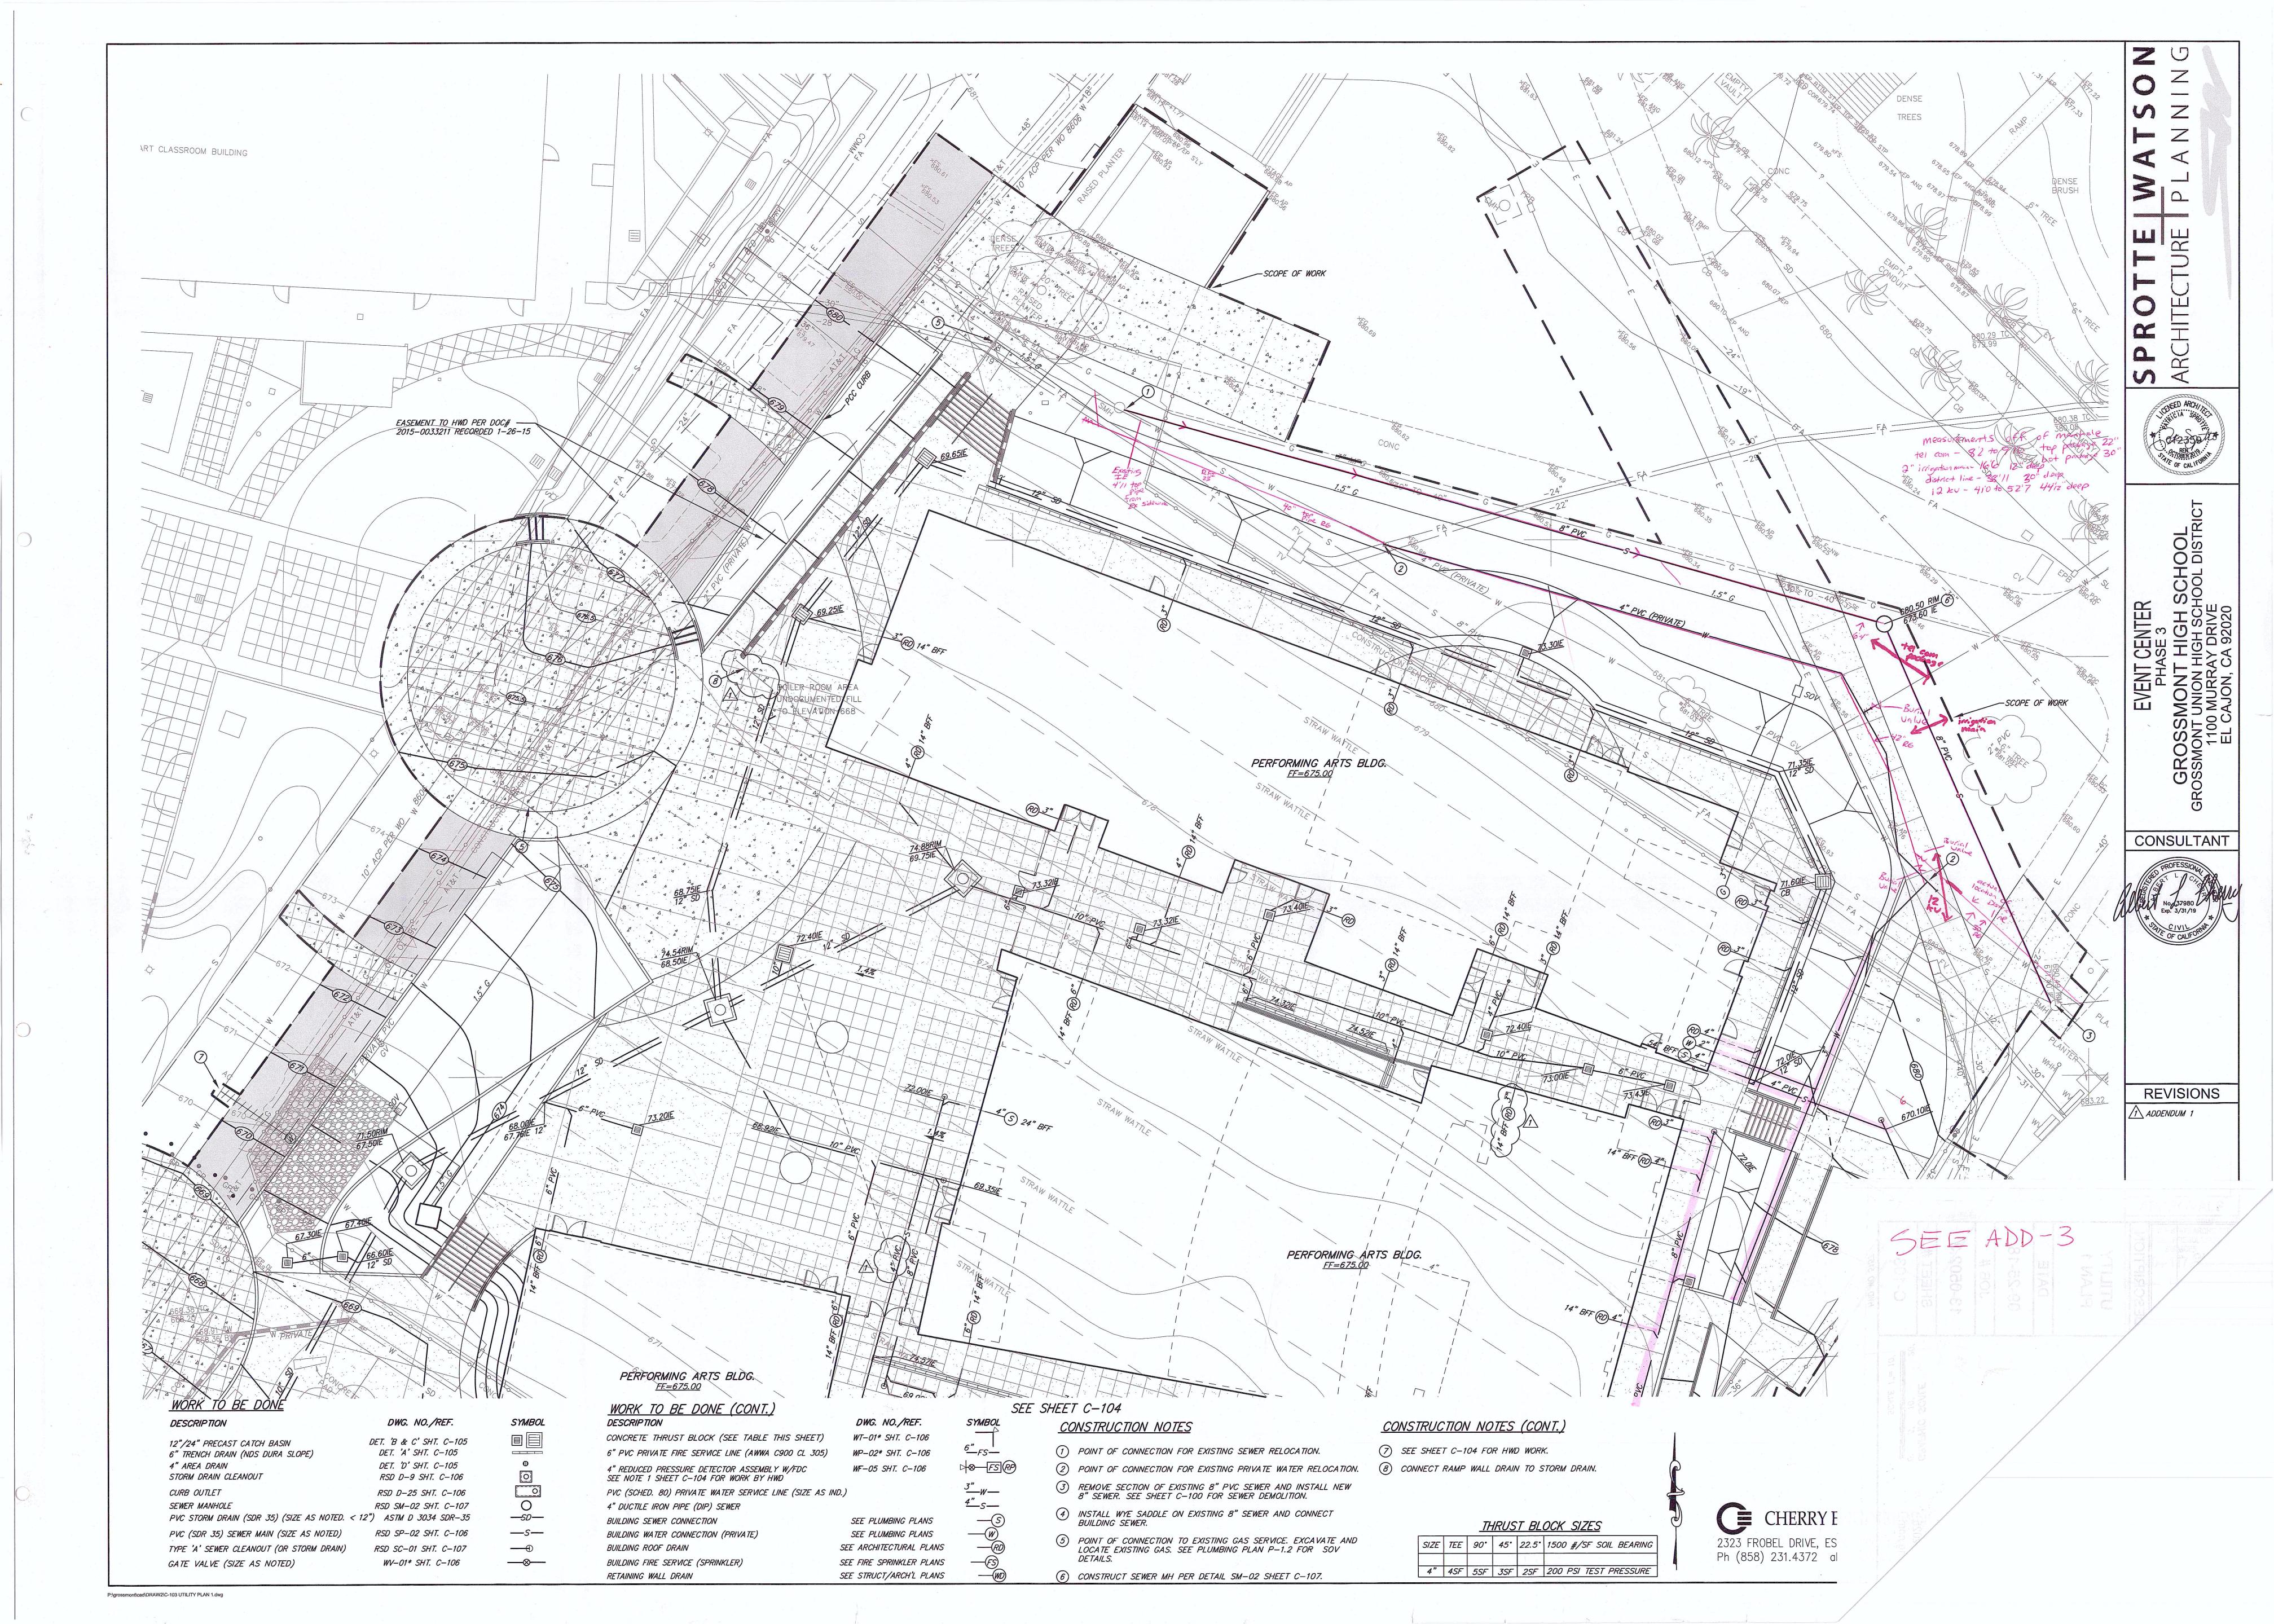

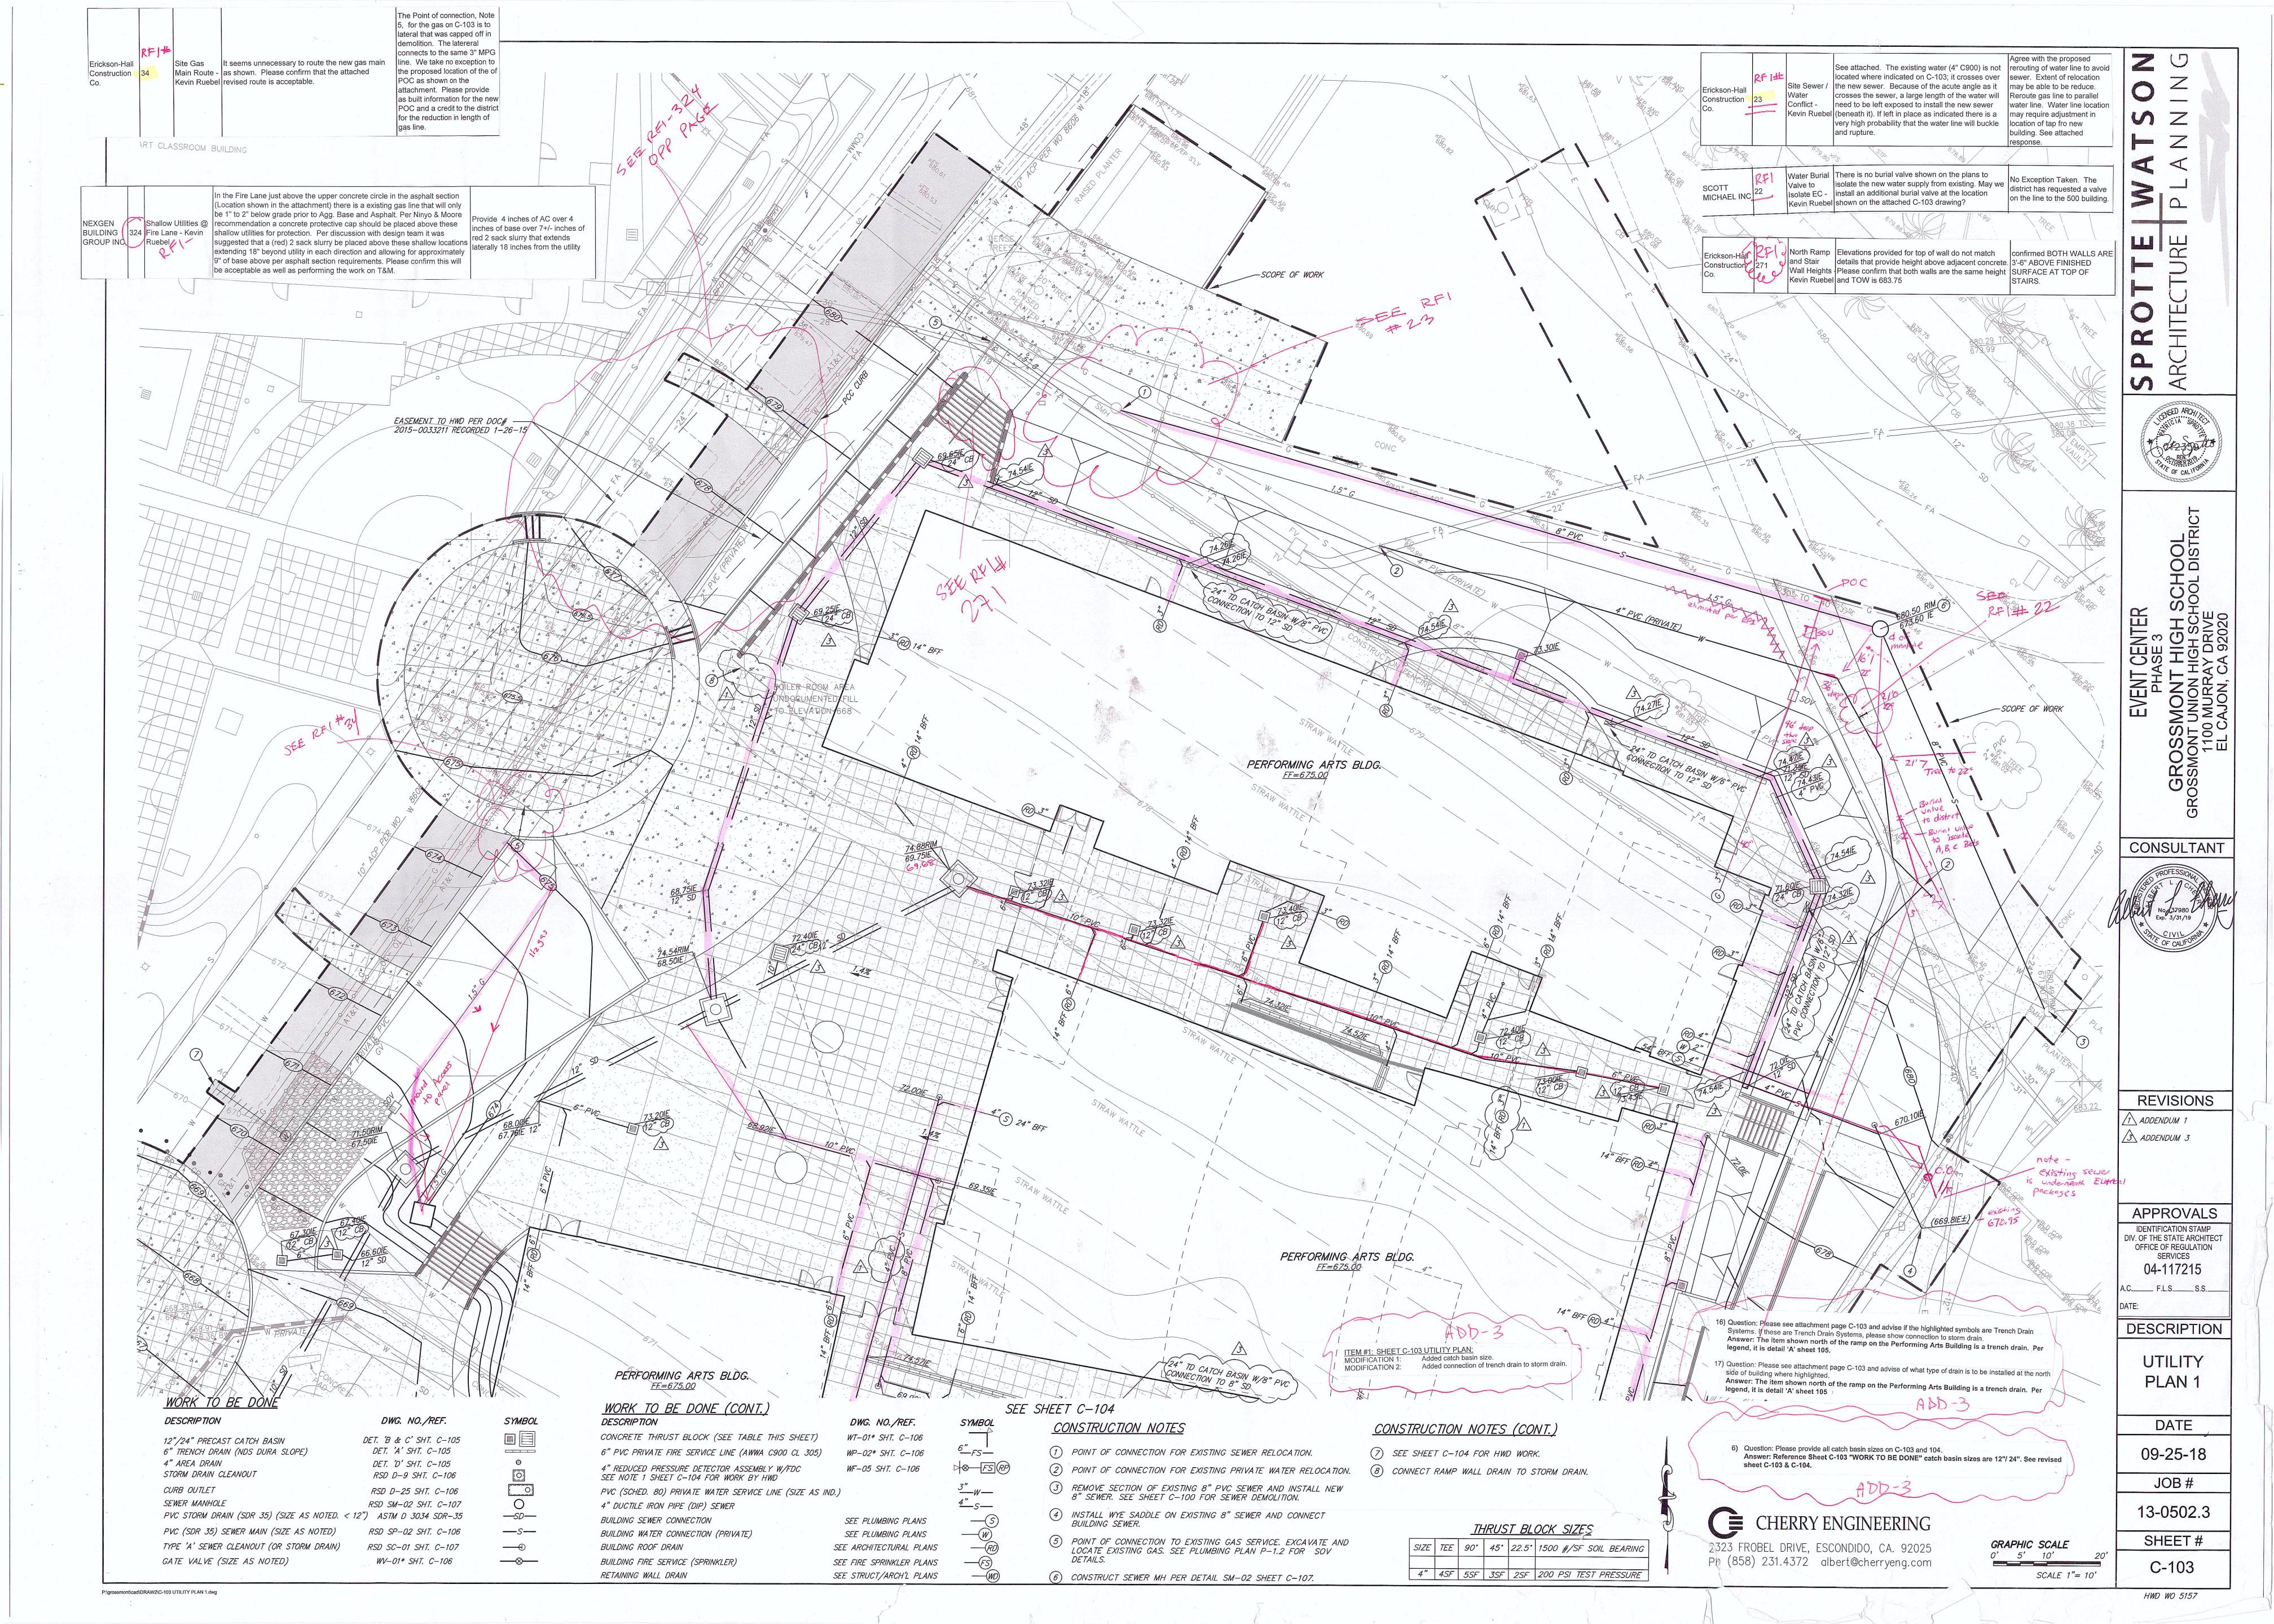


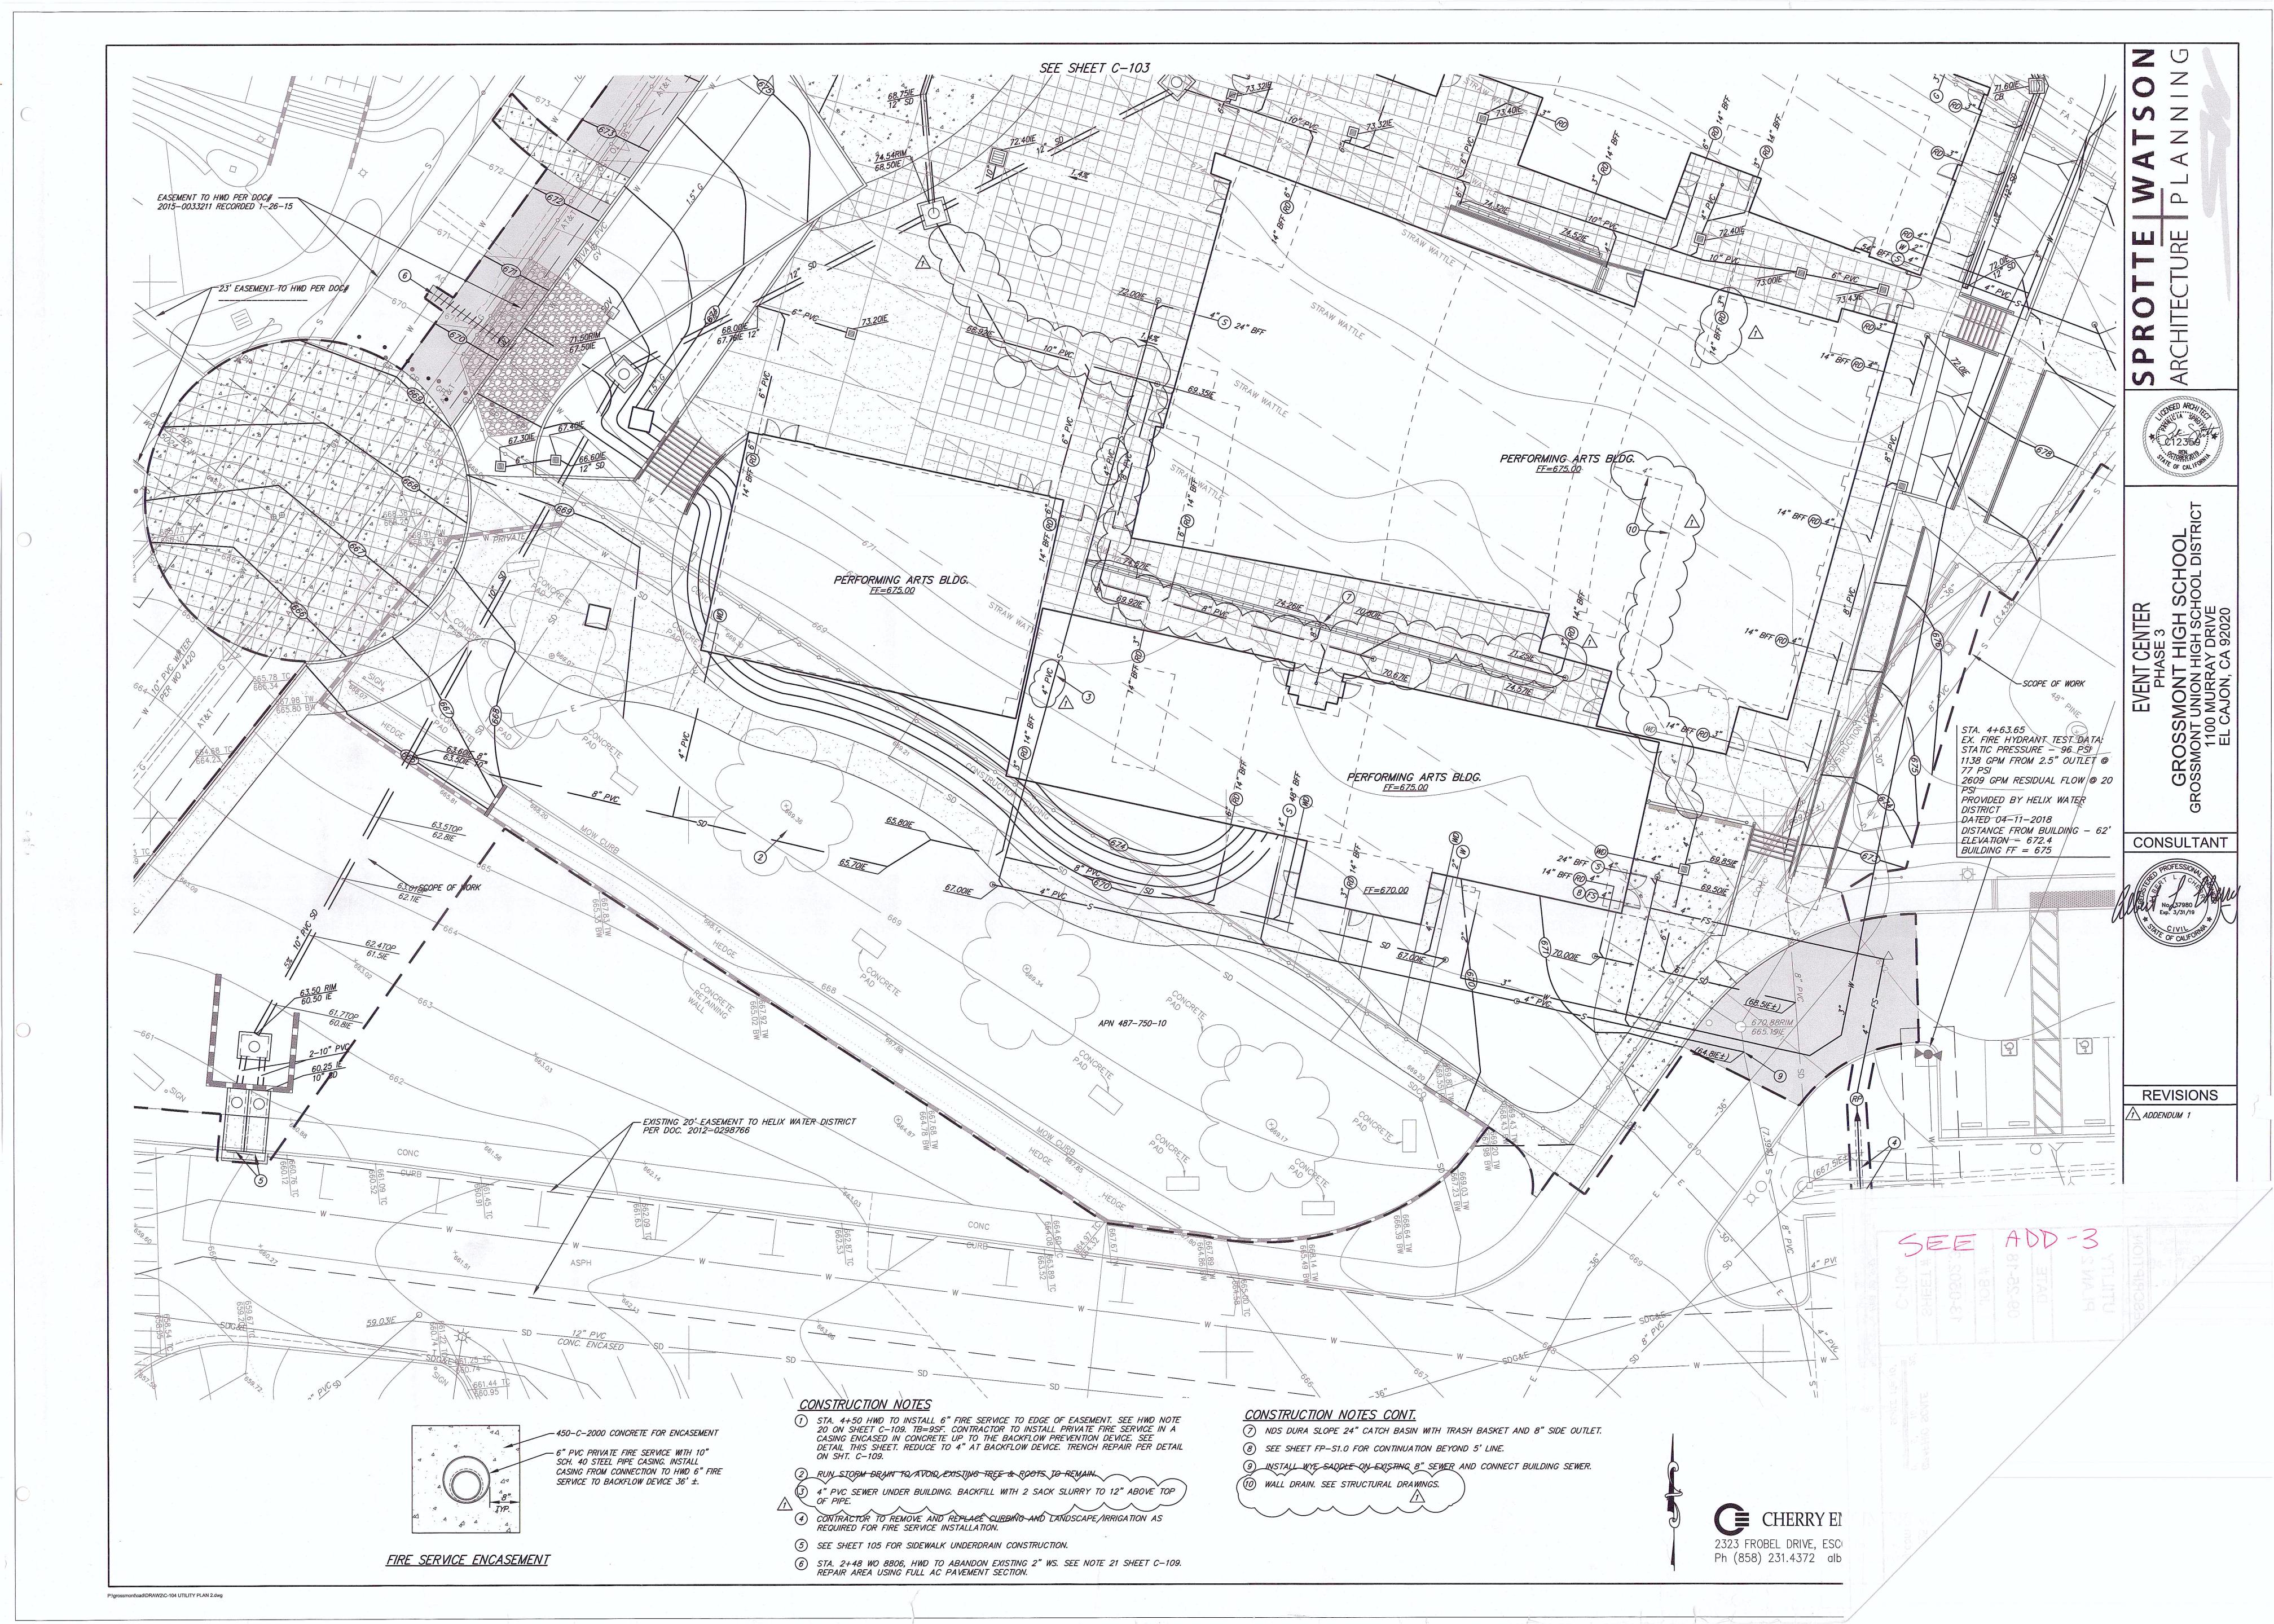

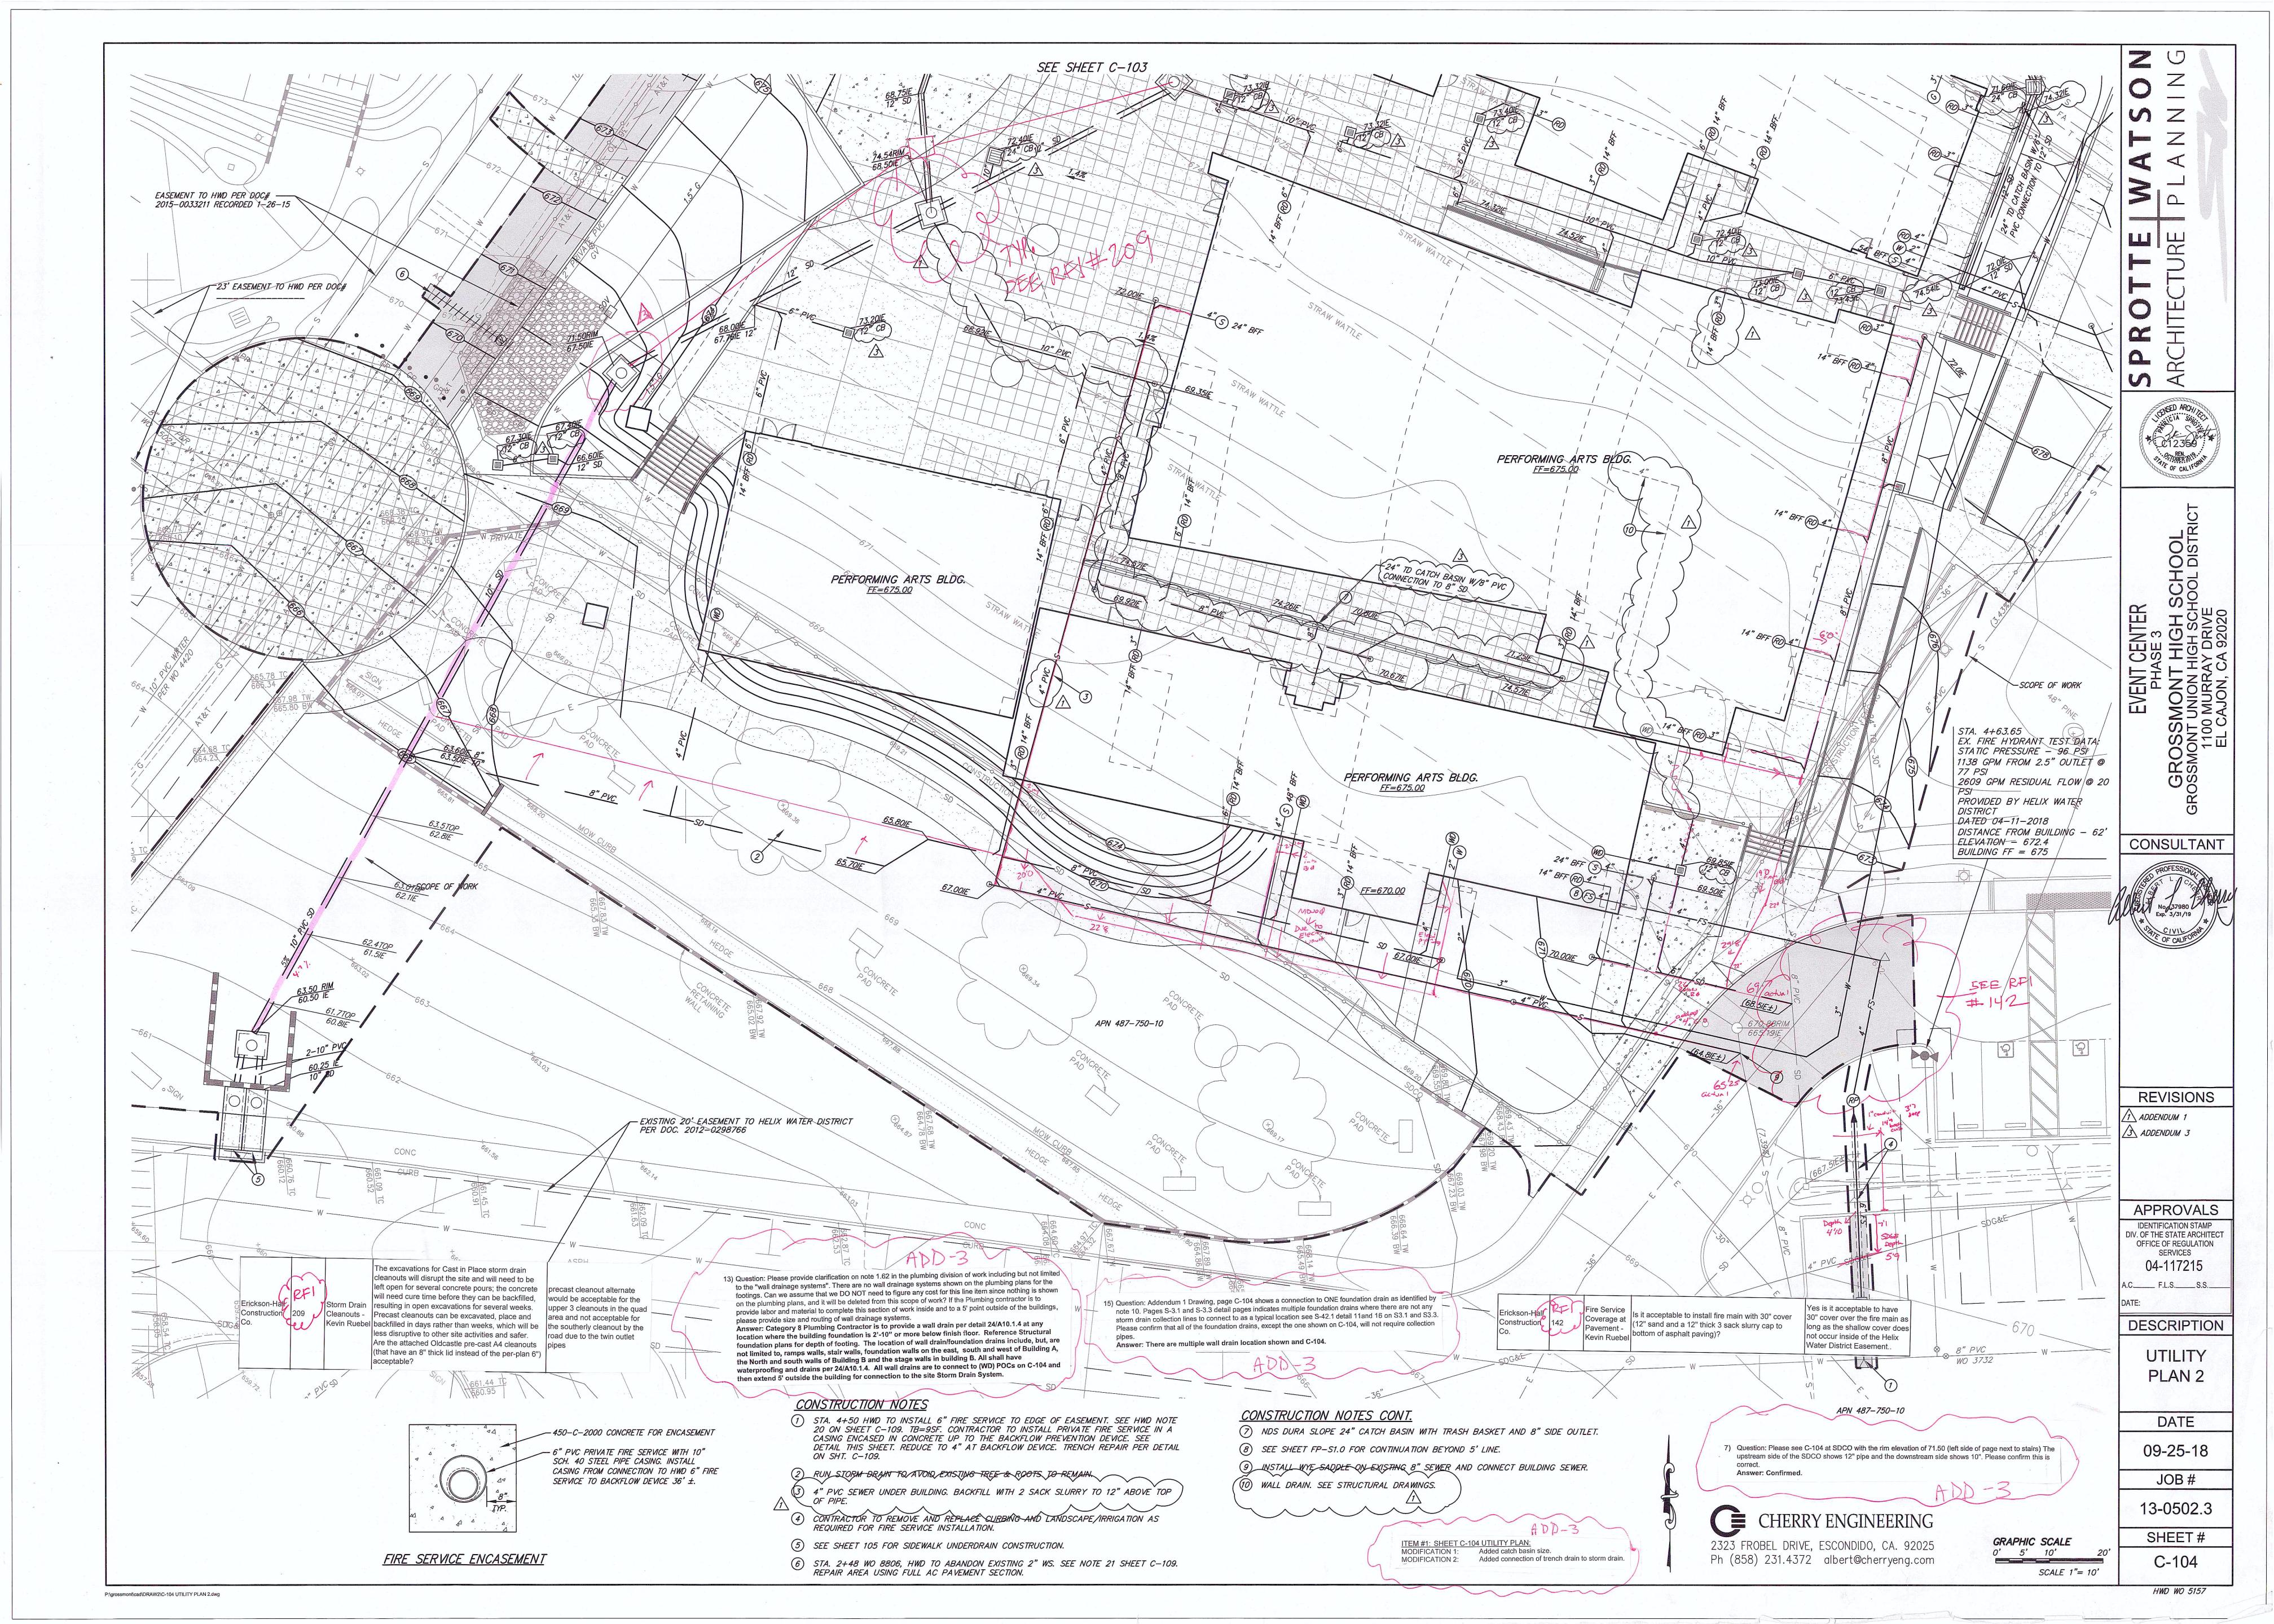

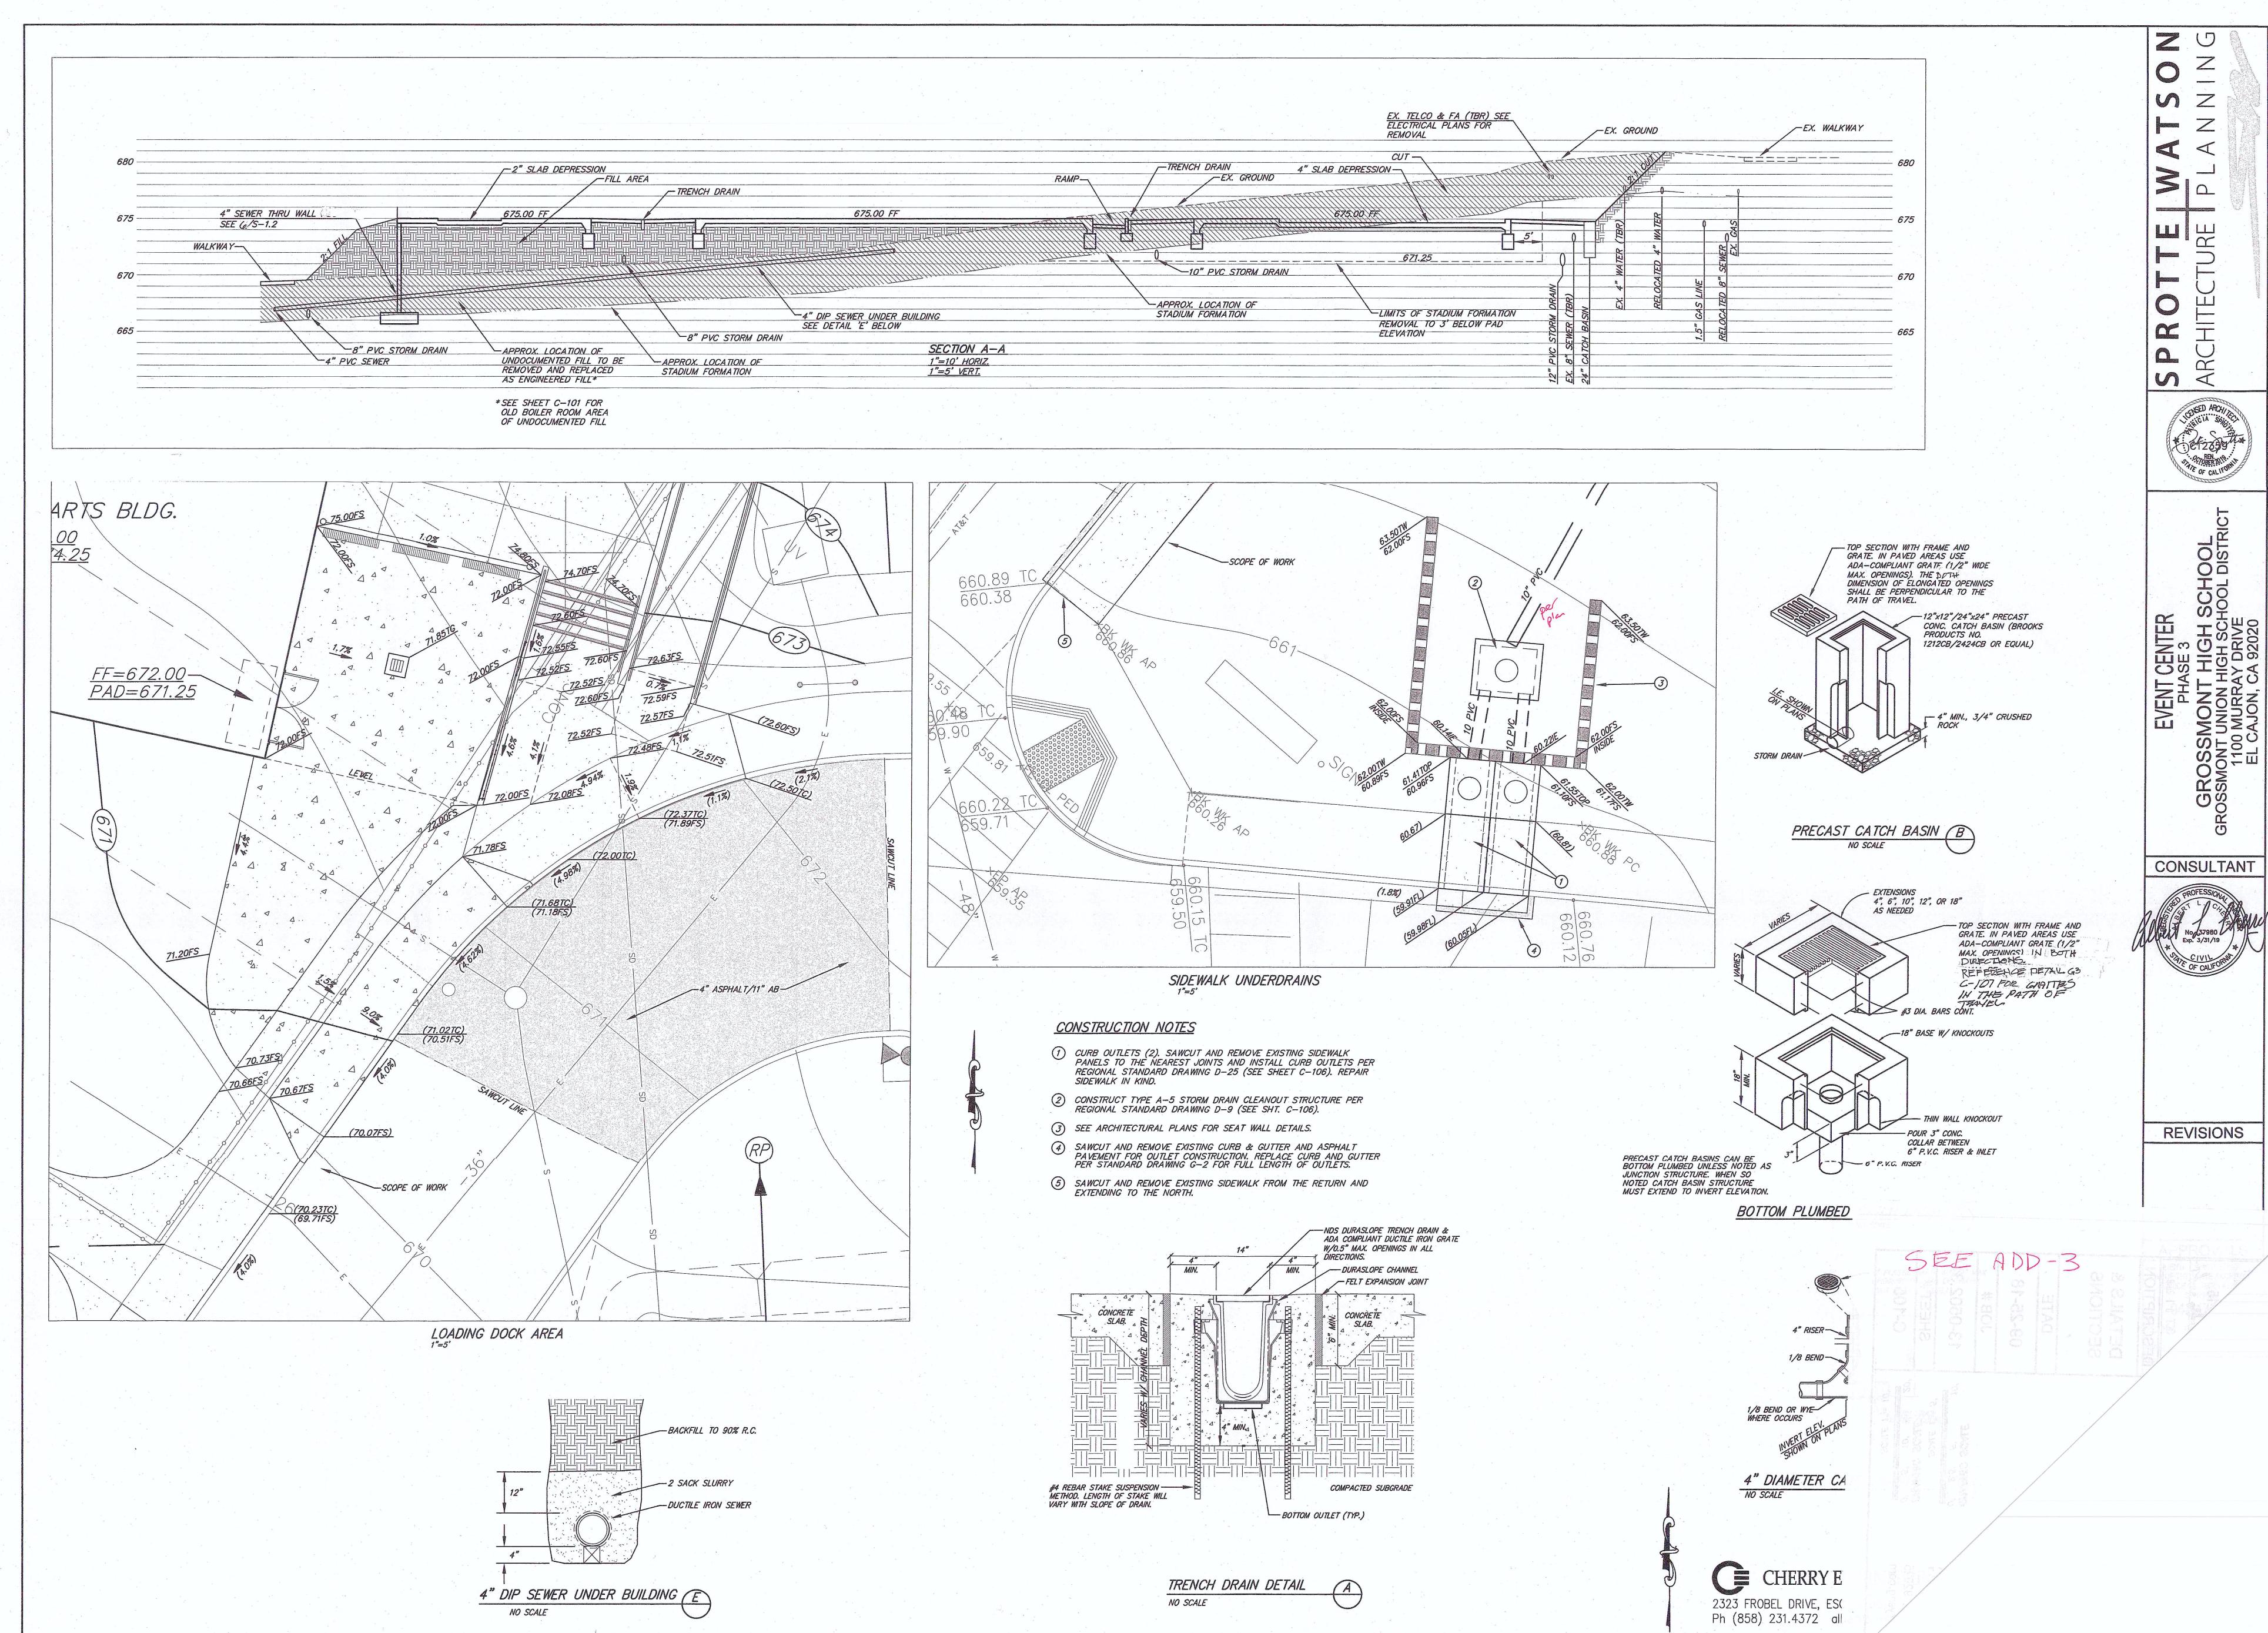

P:\grossmont\cad\DRAW2\C-105 DETAILS & SECTIONS.dwg

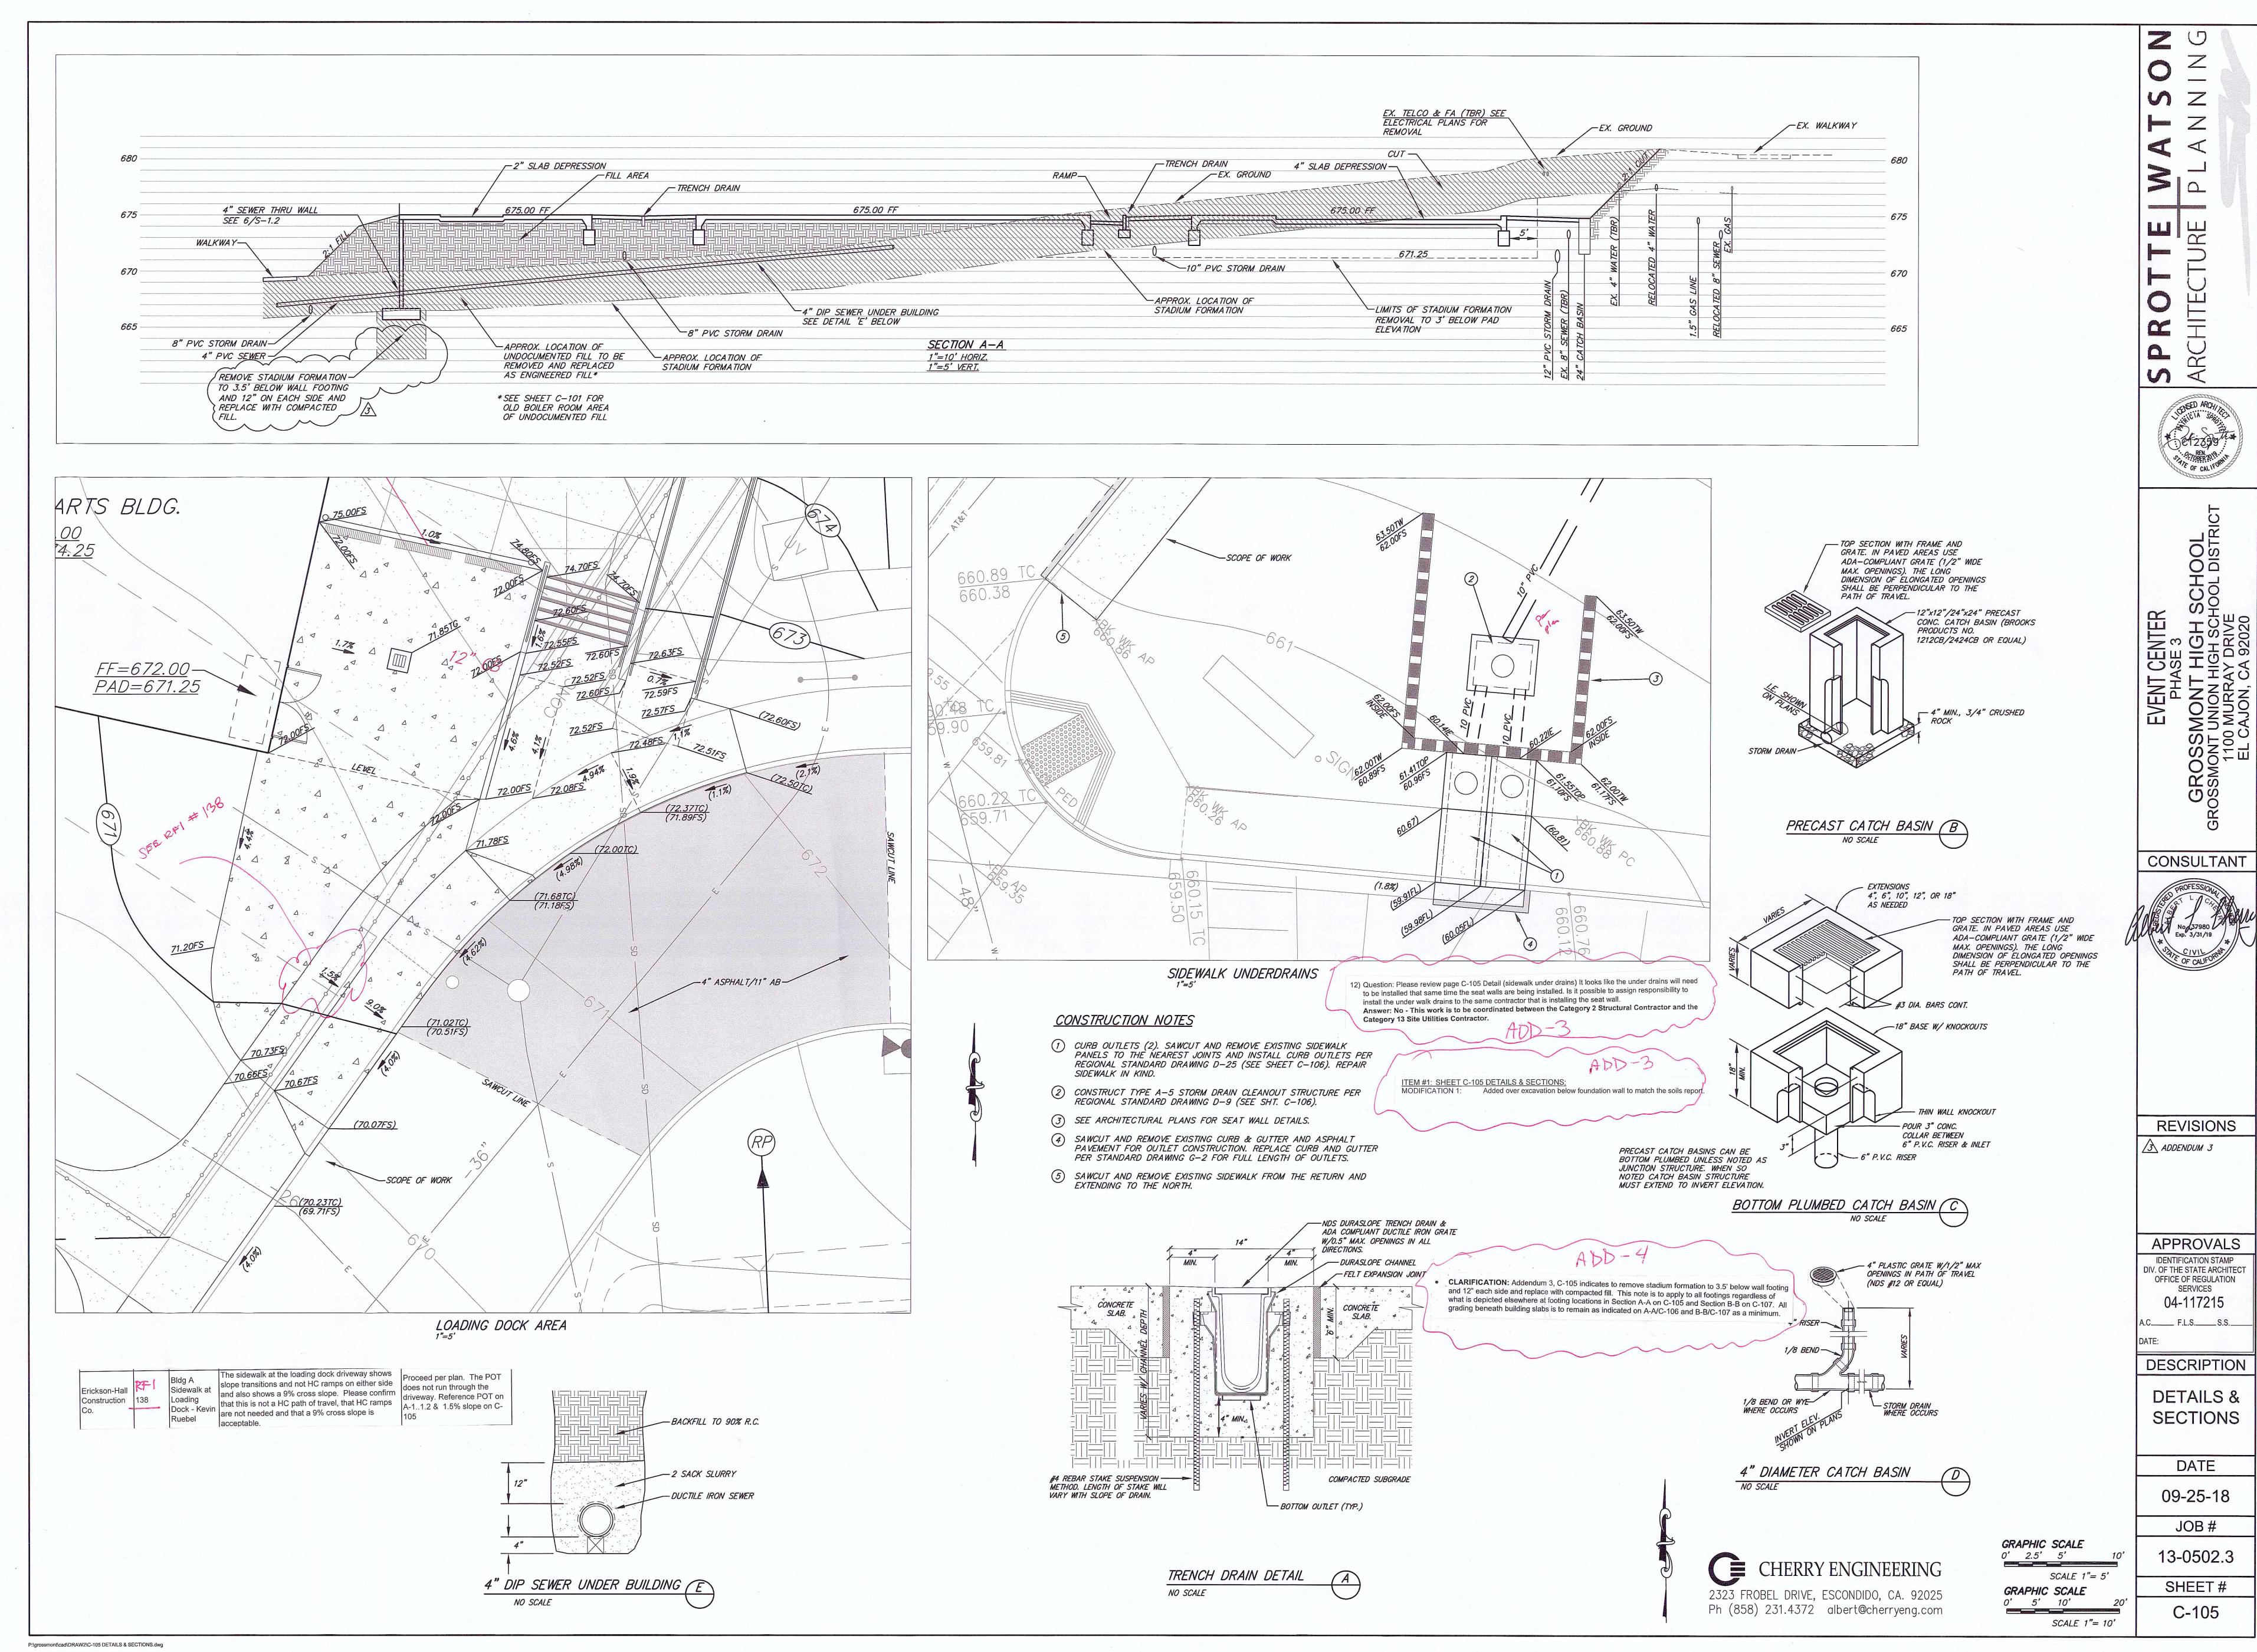

APPROVALS IDENTIFICATION STAMP DIV. OF THE STATE ARCHITECT OFFICE OF REGULATION SERVICES 04-117215

OCT 0 1 2018 DESCRIPTION


STANDARD DETAILS


> DATE 09-26-18

JOB# 13-0502.3


SHEET#

C-106

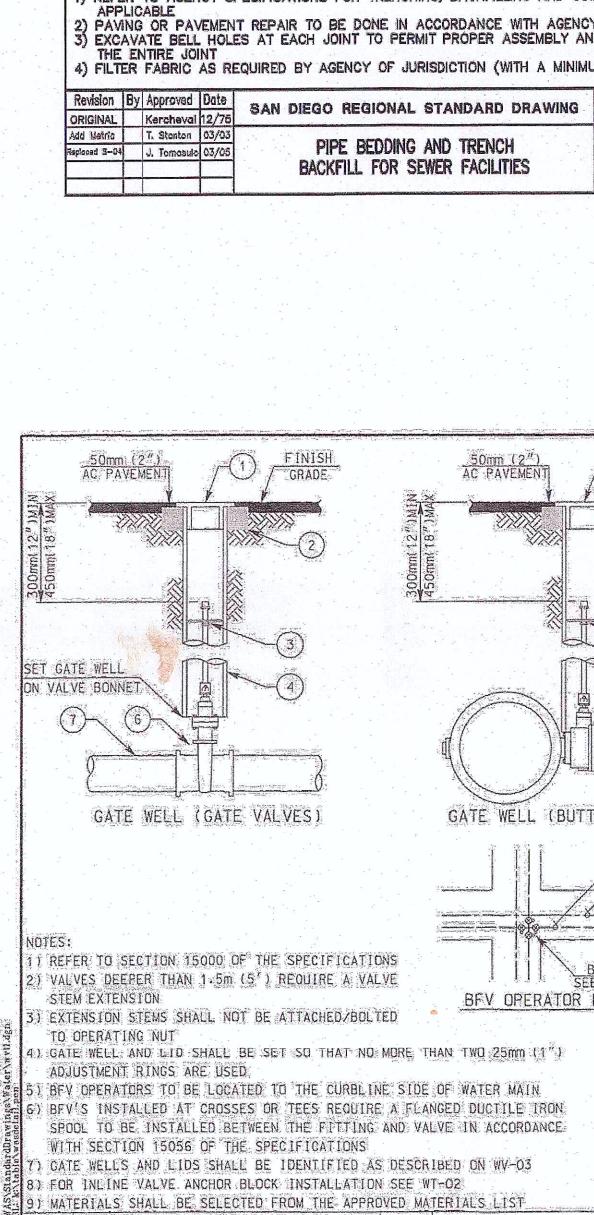

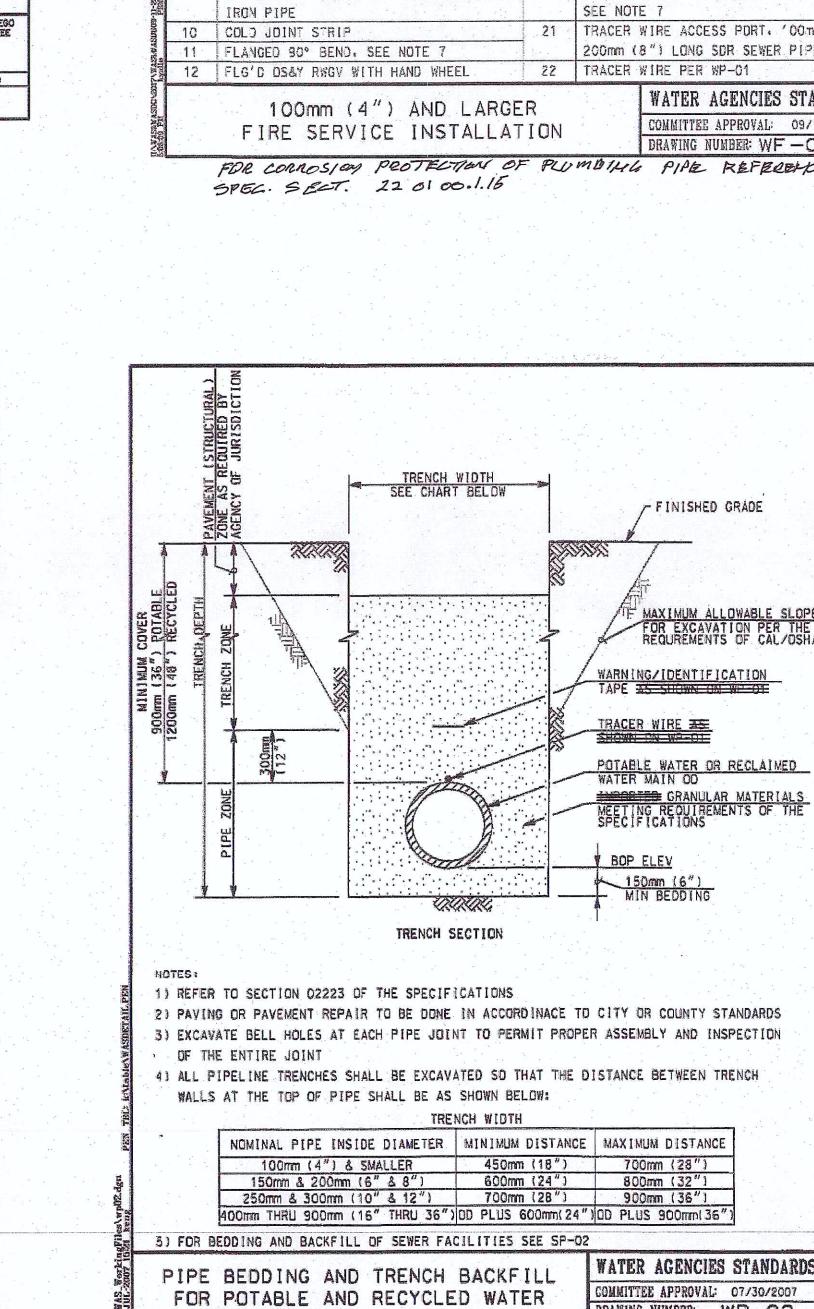

SPECIFICATIONS

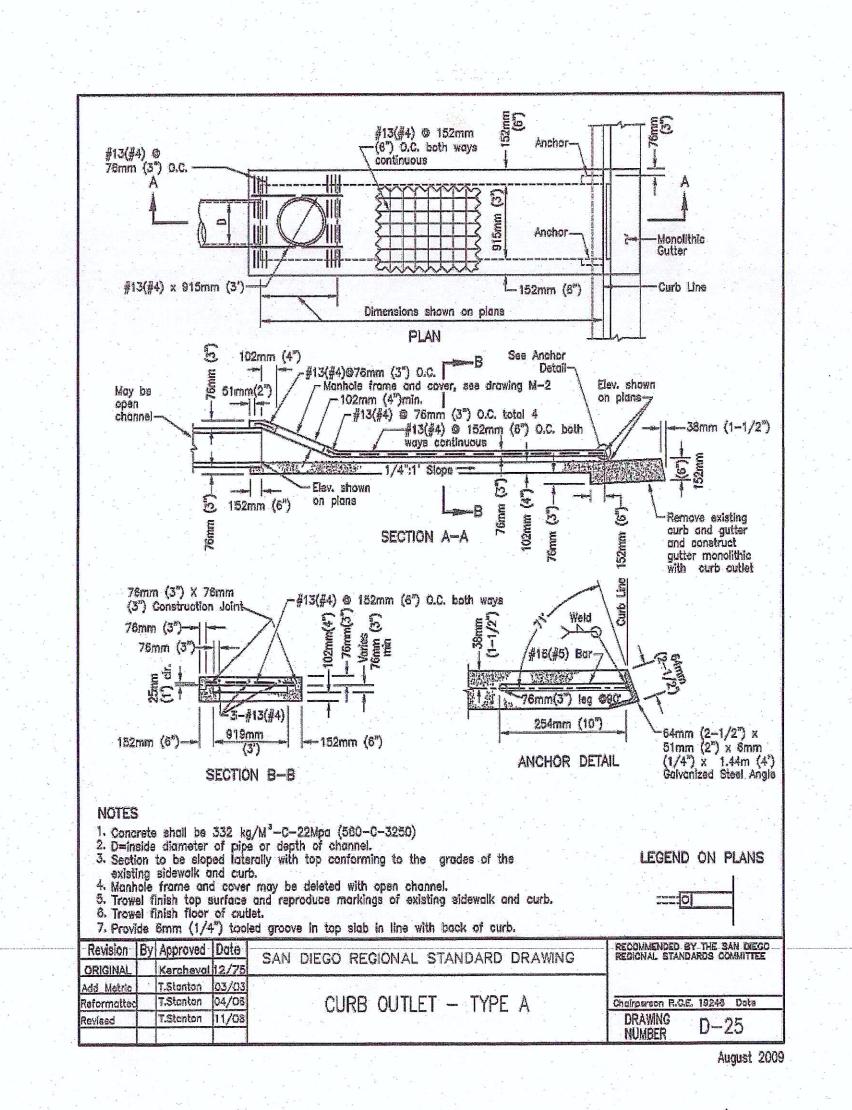

1) REFER TO SECTION 15112 OF THE SPECIFICATIONS

ACCESSIBLE FOR INSPECTION. REPAIR, AND USAGE

15 300mm (12") MINIMUM AND 500mm (24") MAXIMUM

REQUIREMENTS OF THE WATER AGENCY STANDARDS

(24") TO BE APPROVED BY DISTRICT ENGINEER

FOR DETAILS REGARDING THE INSTALLATION OF

FIRE SERVICES SEE WF-05. SHEET 1 OF 2

100mm (4") AND LARGER

FIRE SERVICE INSTALLATION

BY THE FIRE DEPARTMENT OF JURISDICTION

FIRE DEPARTMENT OF JURISDICTION

WATER AGENCY STANDARDS

BY THE DISTRICT ENGINEER

OR EASEMENT

17100 BACKFILL IS REQUIRED

2) INSTALL WARNING/IDENTIFICATION TAPE TO THE TABLE OF THE PARTY OF TH

3) LOCATION OF FIRE SERVICES SHALL BE AS DIRECTED BY THE FIRE DEPARTMENT OF JURISDICTION. FIRE SERVICES SHOULD BE LOCATED IN SUCH A MANNER THAT WILL ALLOW THE DEVICE TO BE READILY

4) TAMPER SWITCH: AUTOMATIC RESET, CHAIN WITH KNOW LOCK, AND

5) BALL VALVE TEST COCKS SHALL BE PROVIDED AND LOCATED PER THE MANUFACTURES RECOMMENDATIONS AND THE REQUIREMENTS OF THE

8) INSTALL FIRE SERVICES SO THAT THE DISTANCE BETWEEN THE BOTTON OF THE RELIEF DIAPHRAGM AND THE CONCRETE SLAB OR FINISH GRADE

7) INSTALL AN ANGLE PRESSURE REDUCING VALVE IN LIEU OF THE FIRST

8) INSTALL PIPE AND RELATED APPURTENANCES IN THIS AREA PER THE

9) INSTALL PIPE AND RELATED APPURTENANCES IN THIS AREA AS REQUIRED

10) ABOVE GROUND APPURTENANCES SHALL BE PAINTED AND IDENTIFIED AS

11) TESTING SHALL BE CONDUCTED AS CALLED FOR IN SECTION 15112 OF THE SPECIFICATIONS PRIOR TO ACCEPTANCE BY THE DISTRICT

13 MATERIALS SHALL BE SELECTED FROM THE APPROVED MATERIALS LIST

WHEN INSTALLED WITH OR BY A WALL OR ANY OTHER OBSTRUCTIONS

16) INSTALL A CASING ENCASED IN CONCRETE WHEN THE DISTANCE BETWEEN

12 CONNECTIONS TO STEEL MAINS SHALL BE IN ACCORDANCE WITH SECTION 15061

14) DISTRICT RESPONSIBILITY ENDS AT EDGE OF PROPERTY LINE. RIGHT OF WAY.

15)1200mm (24") MINIMUM CLEARANCE SHALL BE MAINTAINED ALL AROUND PAD

P/L. R/W OR EDGE OF EASEMENT AND THE RISER TO RPDA EXCEEDS GOOM

(24"). NO CONNECTIONS OF ANY KIND WILL BE PERMITTED IN THIS AREA.

INSPECTION REQUIRED PRIOR TO BACKFILL. LENGTHS IN EXCESS OF GOOMM

REFERENCES TO SPECIFICATIONS ARE WATER AGENCIES' STANDARD

LEGEND ON PLANS

WATER AGENCIES' STANDARDS

COMMITTEE APPROVAL: 09/11/2017


DRAWING NUMBER: WF -05 12 OF 2

CALLED FOR BY THE FIRE DEPARTMENT OF JURISDICTION

90° BEND WHEN SYSTEM STATIC PRESSURE EXCEEDS 1.03 MPG (150 PSI),

WHEN RECOMMENDED BY THE BACKFLOW MANUFACTURER. OR AS REQUIRED


FIRE DEPARTMENT CONNECTION ("FDC") SHALL BE AS REQUIRED BY THE

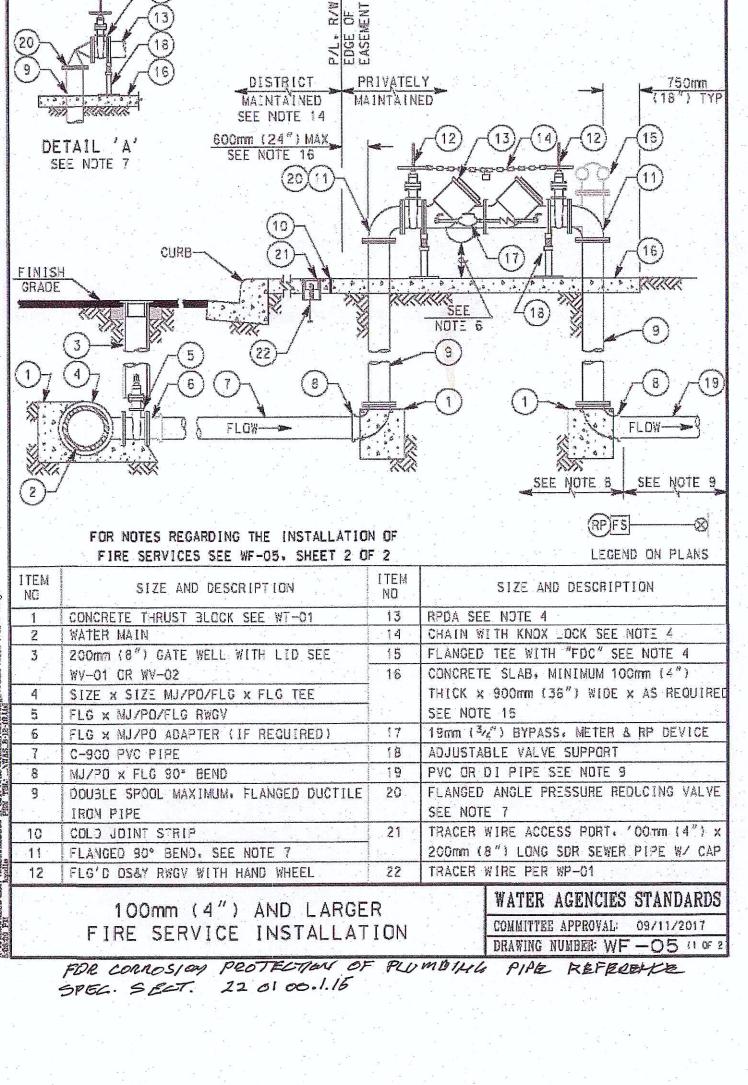


FINISHED GRADE

DRAWING NUMBER: WP-02

REFERENCES TO SPECIFICATIONS ARE WATER AGENCIES' STANDARD

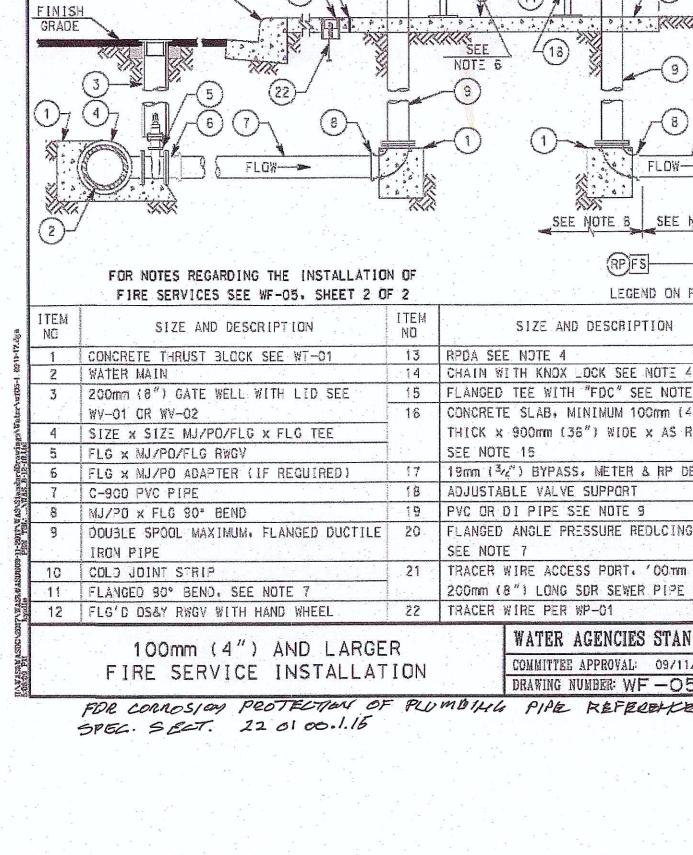

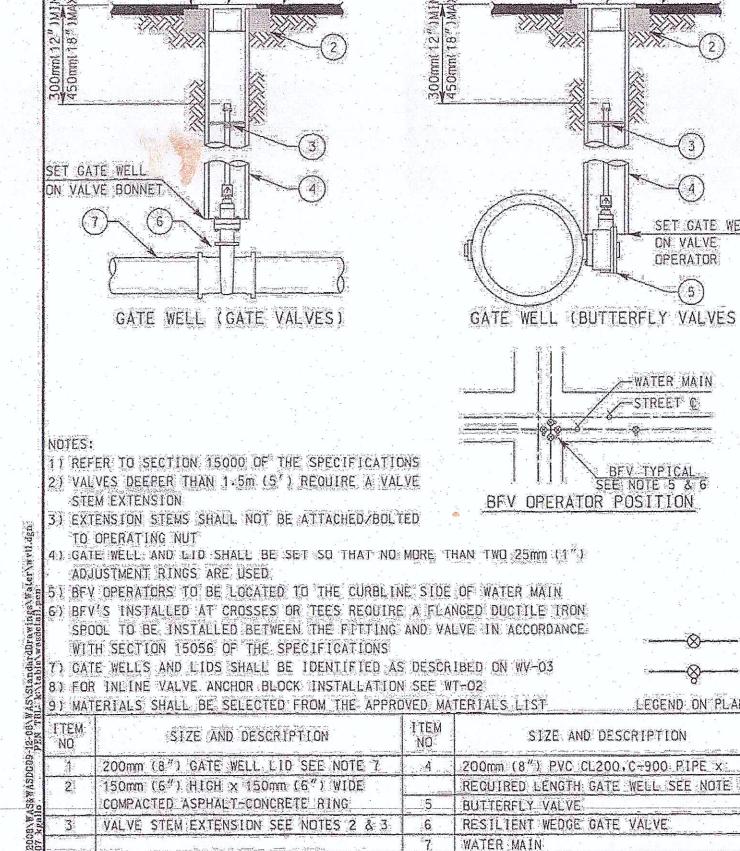


GATE WELL INSTALLATION, TYPE

FOR VALVES 100mm (4") AND LARGER

REFERENCES TO SPECIFICATIONS ARE WATER AGENCIES' STANDARD



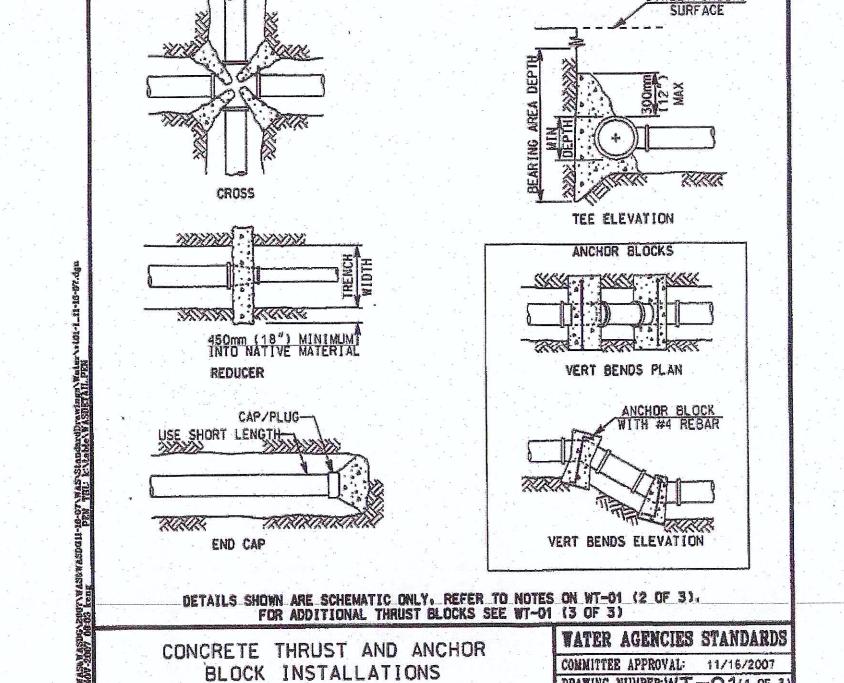

381mm (15") (Typ.)

PIPE DIA.

1. See Standard Drawing D-11 for additional notes and details.
2. Concrete base shall be 332kg/M²-C-22Mpa (560-C-3250)
3. All precast components shall be reinforced with 6.35mm (1/4") diameter steel, wound spirally on 102mm (4") centers.
4. All joints shall be set in Class 6 mortar.
5. Ministria 73mm (1 1/2") places consists between reinforcing and

Maintain 38mm (1 1/2") clear spacing between reinforcing and surface unless otherwise noted.

Add Metric T. Stanton 03/01

Reformatted T. Stanton 04/08

8. Exposed edges of concrete shall be rounded with a radius of 13mm (1/2"). 7. Manhals cover to be designated "Storm Ordin".

Revision By Approved Date

CRIGINAL Kerchavol 12/75 SAN DIEGO REGIONAL STANDARD DRAWING

STORM DRAIN CLEANOUT - TYPE A

A 4 up to 991mm (39") 1.22m (4') 1.22m (4') 1.83m (6')

A 5 1.1m (42") to 1.22m (48") 1.52m (5') 1.22m (4') 1.83m (6')

A 6 1.30m (51") to 1.50m (60") 1.83m (6') 1.22m (4') 1.83m (6')


A 7 1.60m (63") to 1.80m (72") 2.13m (7') 1.22m (4') 2.13m (7')

A 8 1,90m (75") to 2.13m (84") 2.44m (8') 1.22m (4') 2.44m (8')

LEGEND ON PLANS

Chairperson R.C.E. 19246 Date
DRAWING
NUMBER
D-9

DRAWING NUMBER:WT-O111 OF 3

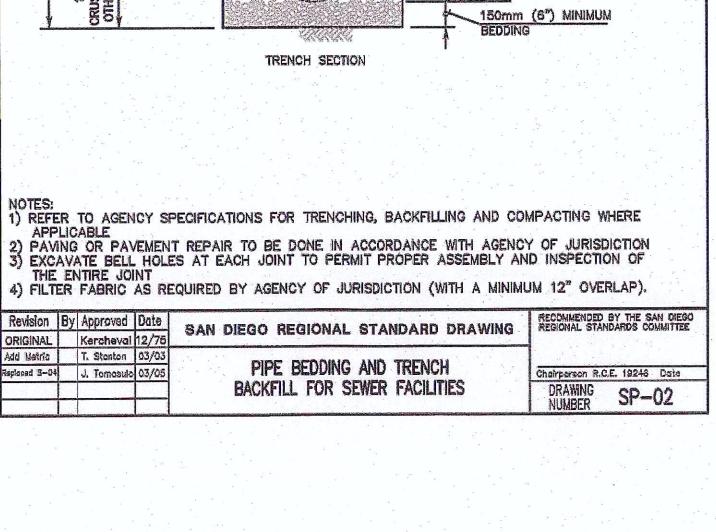

SEWER MAIN OD PLUS 300mm (12") MINIMUM, 400mm (16") MAXIMUM

OF THE SPECIFICATIONS

TAPE AS SHOWN ON SP-01. DEPTH PER AGENCY REQUIREMENT

SET GATE W

ON VALVE OPERATOR


LEGEND ON PLAN


WATER AGENCIES STANDARDS


COMMITTEE APPROVAL: 12/31/2003


DRAWING NUMBER: WV-O1

WARNING/IDENTIFICATION

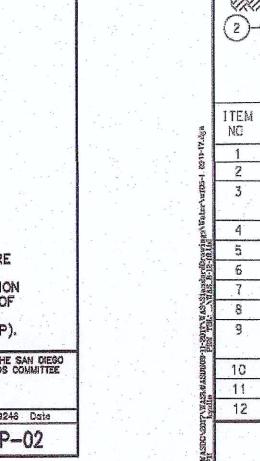


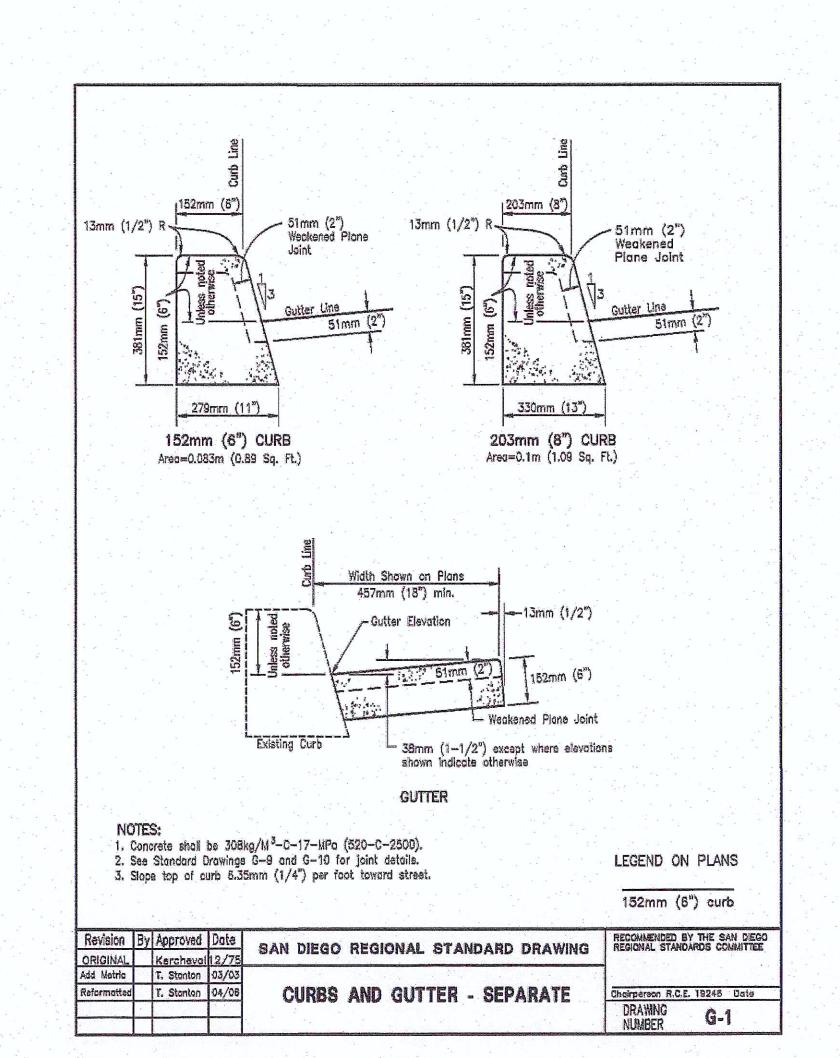


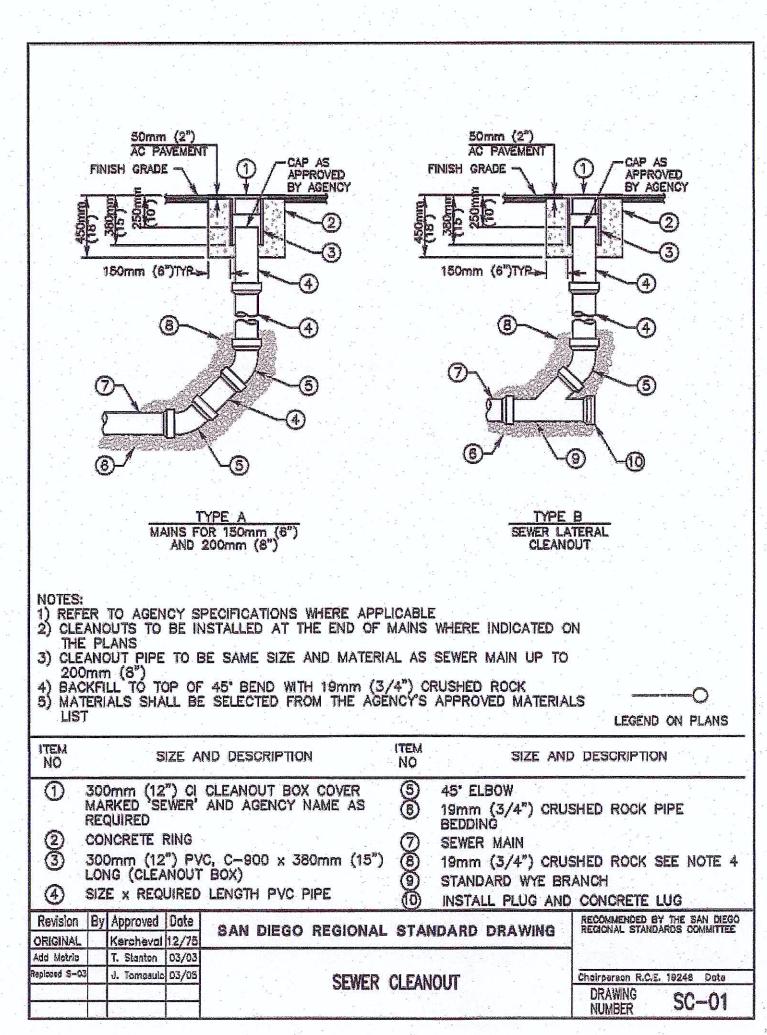


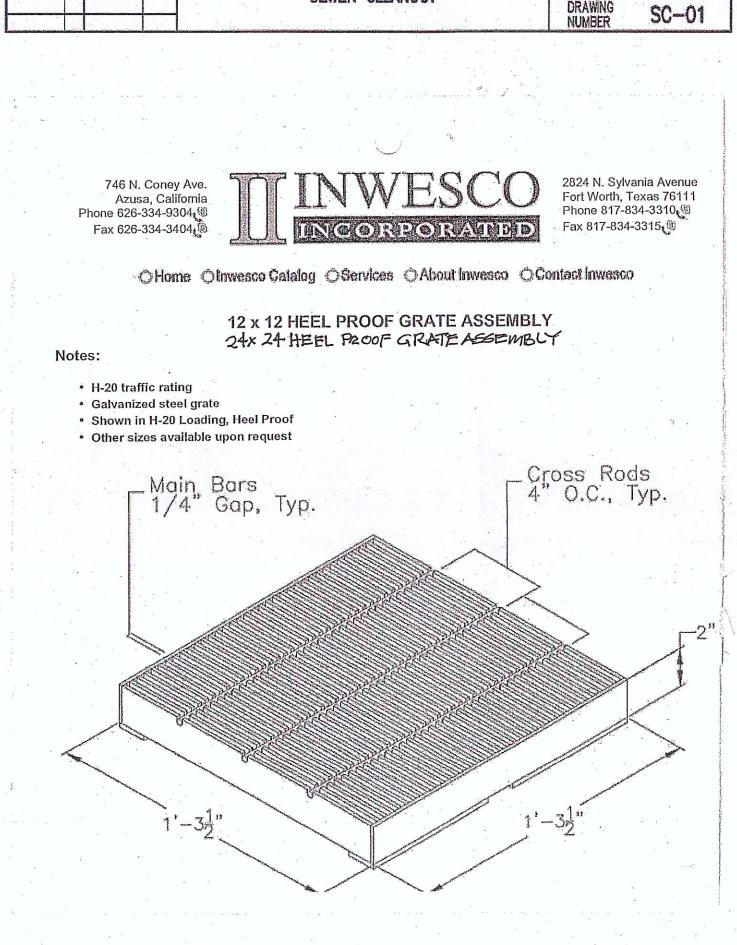


STORM DRAIN GRATE

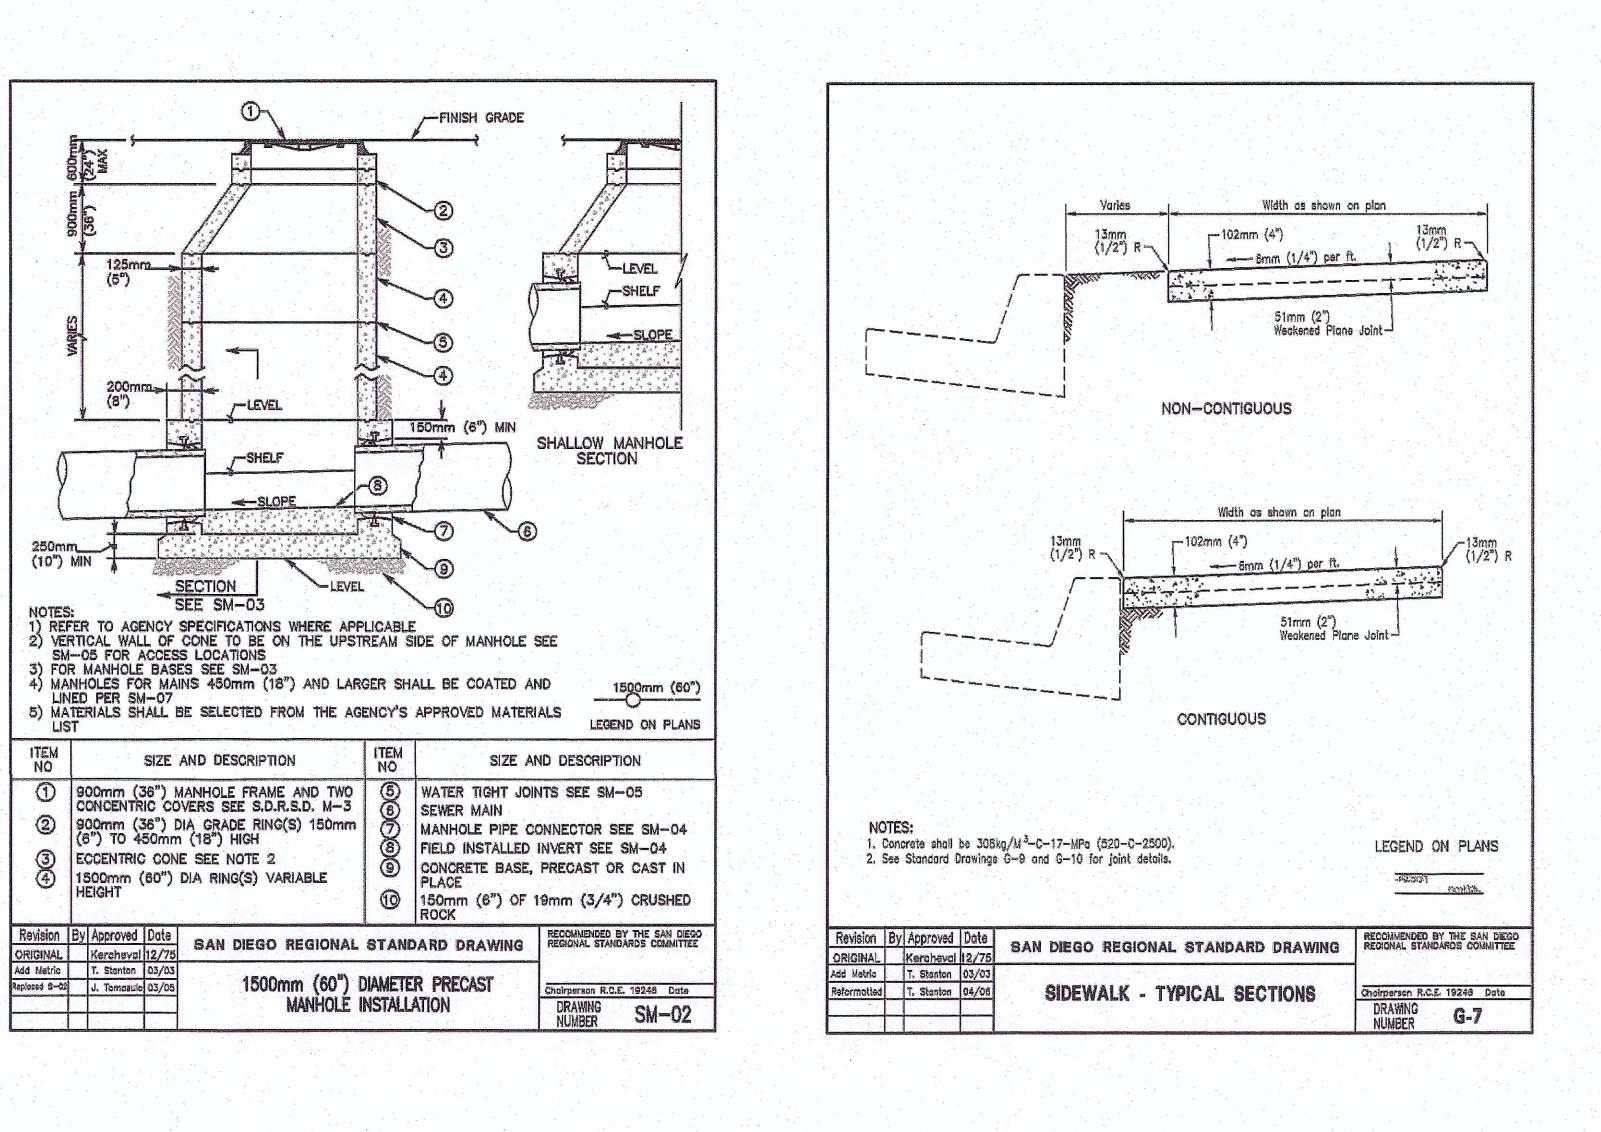

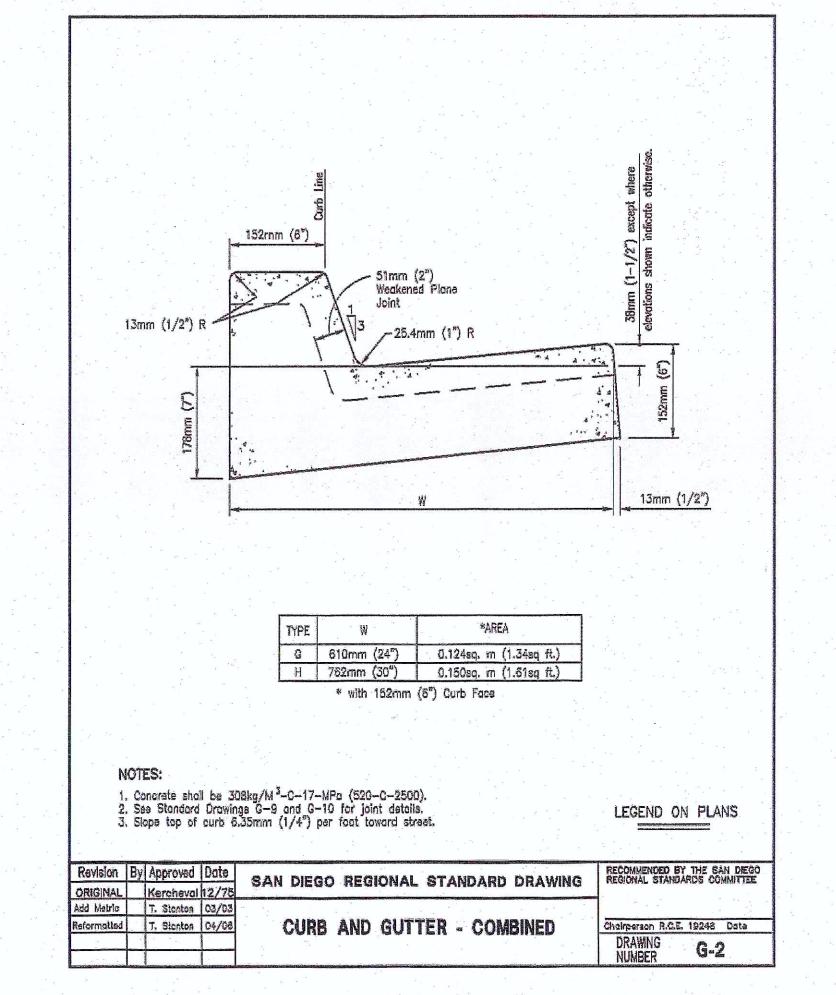

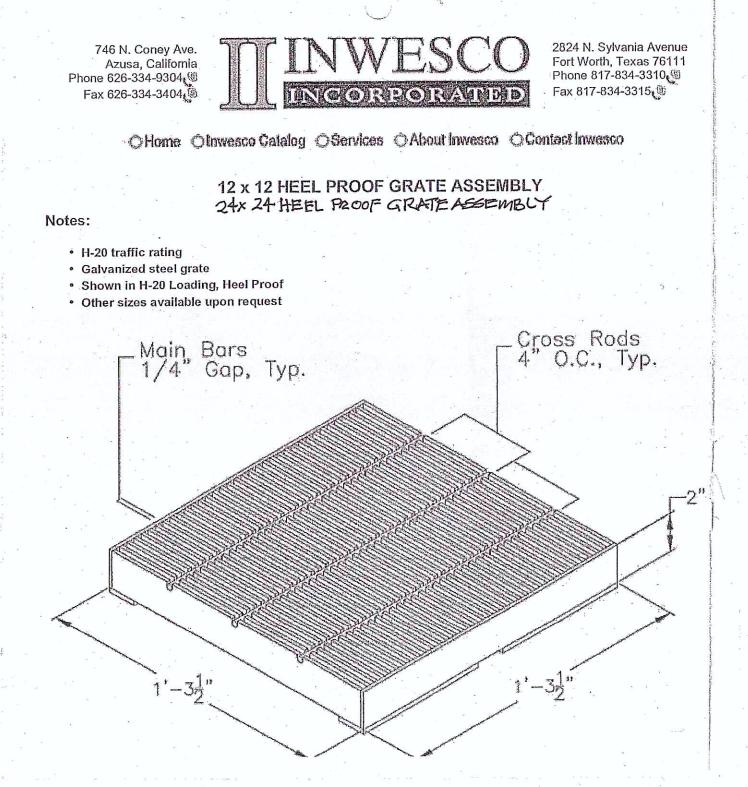

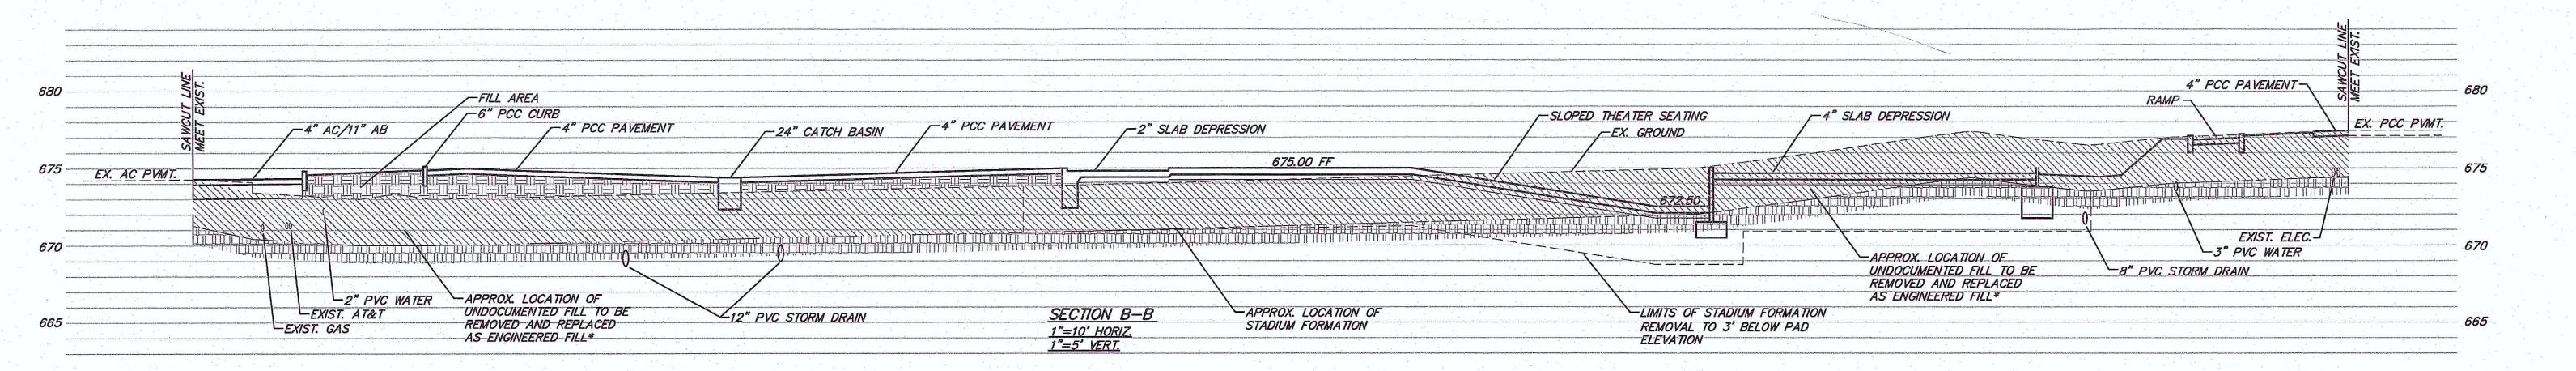

G3

CHERRY ENGINEERING 2323 FROBEL DRIVE, ESCONDIDO, CA. 92025 Ph (858) 231.4372 albert@cherryeng.com

-뿞 T

CONSULTANT

REVISIONS

APPROVALS IDENTIFICATION STAMP DIV. OF THE STATE ARCHITECT OFFICE OF REGULATION SERVICES 04-117215 DATE: QCT 0 1 2018. DESCRIPTION

STANDARD DETAILS

DATE


09-26-18

JOB# 13-0502.3


SHEET# C-107




EROSION CONTROL LEGEND CONSTRUCTION FENCING WITH STRAW WATTLE DET. 'D' GRAVEL BAG CHECK DAM DET. 'E' GRAVEL BAG INLET PROTECTION

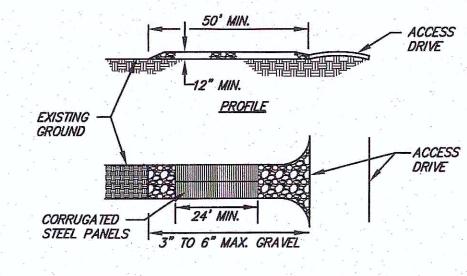


STABILIZED CONSTRUCTION ENTRANCE (A)

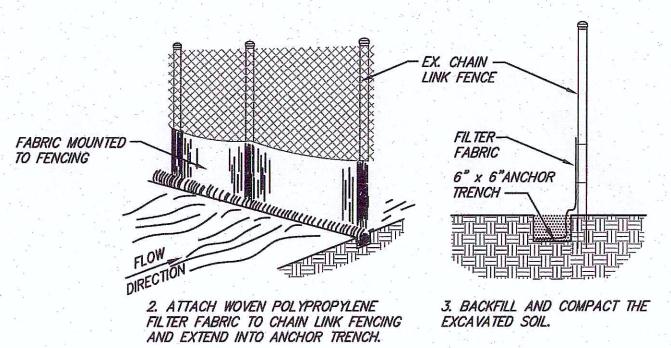


SILT FENCE LINEAR SEDIMENT BARRIER B
(CASQA SE-1) NOT TO SCALE

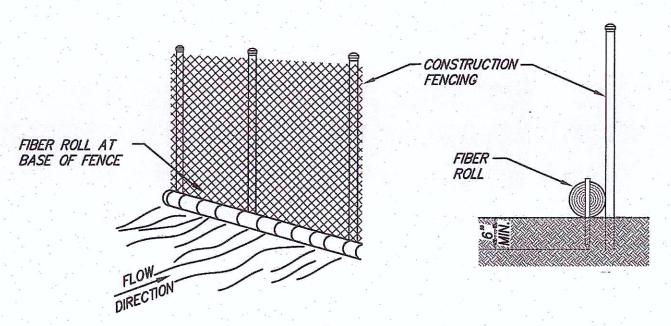

FIBER ROLL LINEAR SEDIMENT BARRIER (C)
(CASQA SE-5) NOT TO SCALE

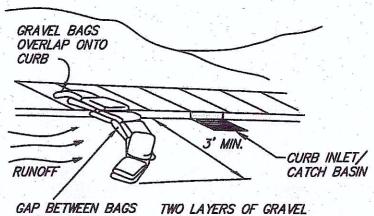

GAP BETWEEN BAGS TWO LAYERS OF GRAVEL ACTS AS SPILLWAY BAGS WITH ENDS OVERLAPPED

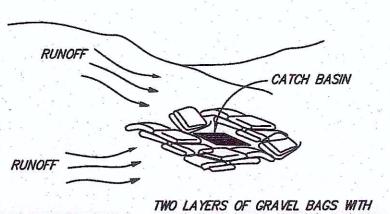

TWO LAYERS OF GRAVEL BAGS WITH
GAP BETWEEN BAGS ENDS OVERLAPPED TYPICAL AROUND
ACTS AS SPILLWAY DRAIN STRUCTURES AND STRAIGHT RUNS.

GRAVEL BAG INLET PROTECTION (E)
(CASQA SE-10) NOT TO SCALE



CHERRY ENGINEERING

2323 FROBEL DRIVE, ESCONDIDO, CA. 92025
Ph (858) 231.4372 albert@cherryeng.com

GRAPHIC SCALE
0' 10' 20' 40'

SCALE 1"= 20'

GROSSMONT UNION 1100 MURR EL CAJON,

CONSULTANT

REVISIONS

APPROVALS IDENTIFICATION STAMP DIV. OF THE STATE ARCHITECT OFFICE OF REGULATION SERVICES 04-117215

DATE: OCT 0 1 2018 DESCRIPTION


EROSION CONTROL

PLAN DATE

09-25-18

JOB# 13-0502.3

SHEET# C-108

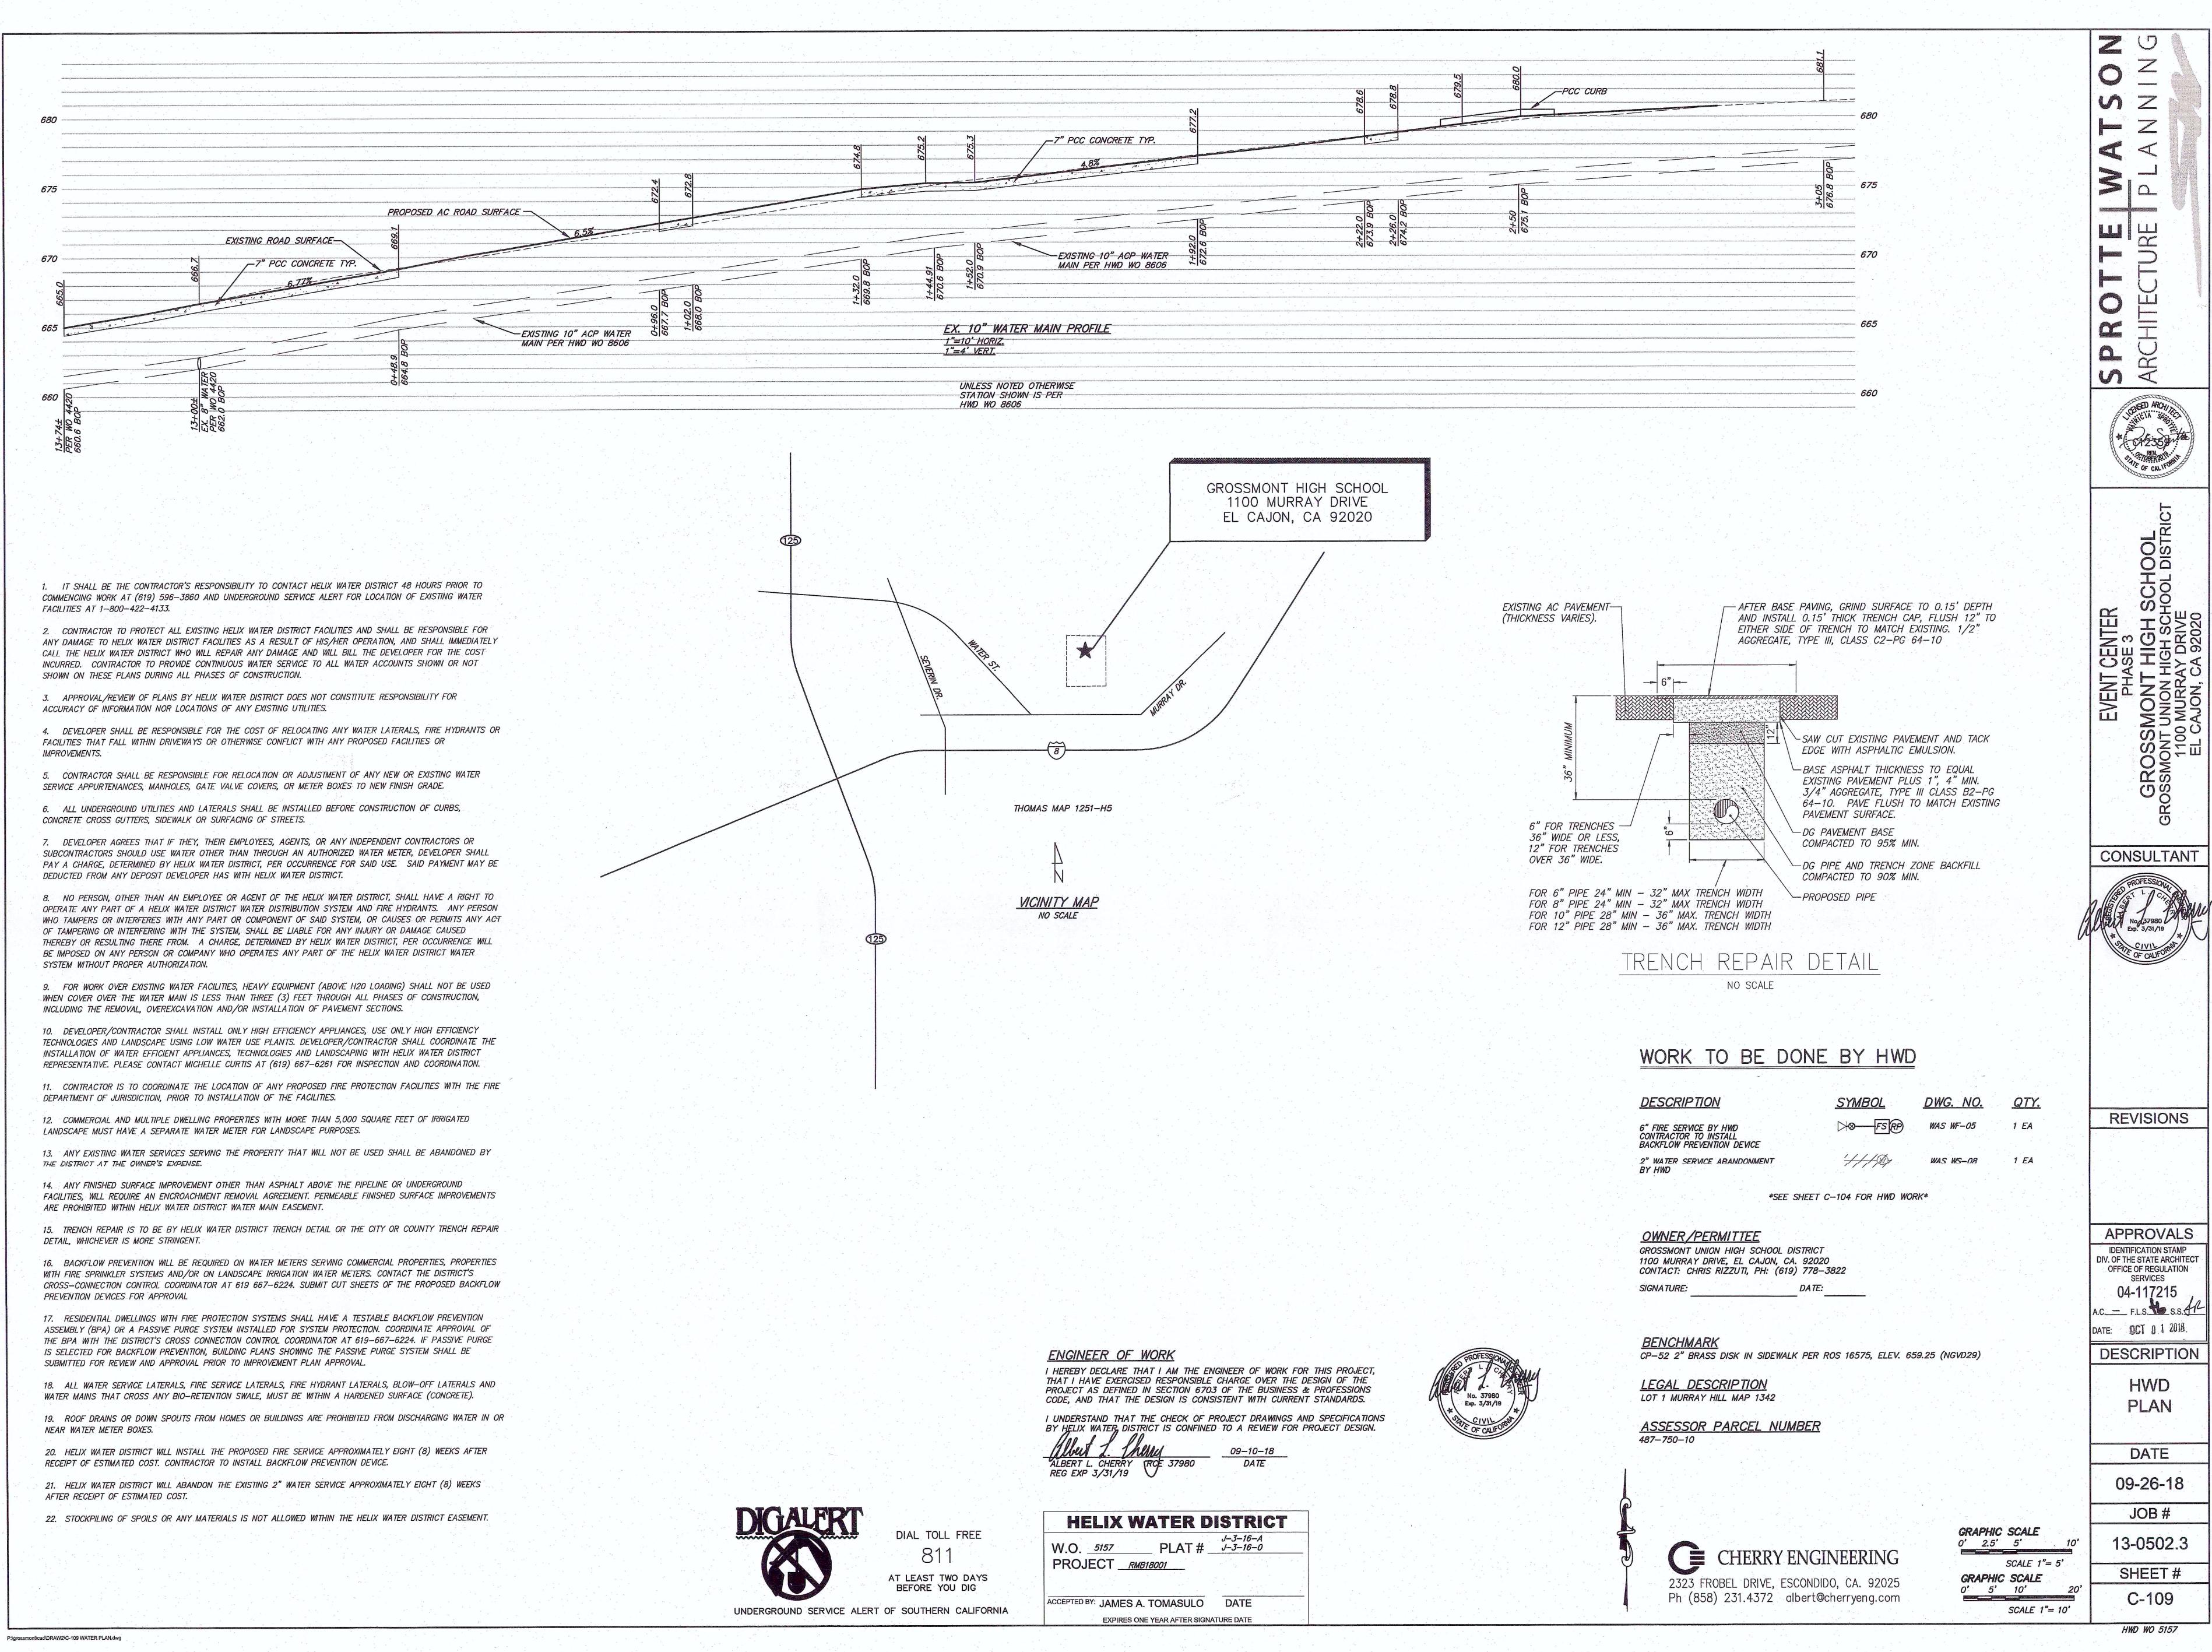

INTENTIONALLY LEFT BLANK