

SPECIAL NOTES:

- THE FOLLOWING NOTES ARE PROVIDED TO GIVE DIRECTIONS TO THE CONTRACTOR BY THE ENGINEER OF WORK.
- THE ENGINEER OF WORK SHALL NOT BE RESPONSIBLE FOR THE CONTRACTOR'S FAILURE TO CARRY OUT CONSTRUCTION WORK IN ACCORDANCE WITH THE CONTRACT DOCUMENTS, NOR SHALL THE ENGINEER BE REQUIRED TO SUPERVISE CONDUCT OF THE WORK OF THE CONSTRUCTION PROCEDURES AND SAFETY PROCEDURES FOLLOWED BY THE CONTRACTOR OR SUBCONTRACTORS OR THEIR RESPECTIVE EMPLOYEES OR BY ANOTHER PERSON AT THE JOB SITE OTHER THAN THAT OF THE ENGINEER'S EMPLOYEES.
- THE LOCATIONS OF ANY UNDERGROUND STRUCTURES AS SHOWN ON THESE PLANS HAVE BEEN OBTAINED FROM AVAILABLE RECORDS AND ARE SHOWN FOR THE BENEFIT OF THE CONTRACTOR. THE CONTRACTOR SHALL TAKE ALL NECESSARY PRECAUTIONARY MEASURES TO PROTECT ALL UNDERGROUND OR OVERHEAD STRUCTURES WHETHER SHOWN OR NOT ON THESE DRAWINGS
- FOR ELECTRONIC FILES OF THE HORIZONTAL CONTROL OF ONSITE IMPROVEMENTS, CONTRACTOR SHALL CONTACT THE ENGINEER OF WORK AT (619) 787-5566.
- THE CONTRACTOR SHALL VERIFY THE LOCATION OF AND PROTECT ALL EXISTING IMPROVEMENTS BEFORE AND DURING CONSTRUCTION.
- CONTRACTOR SHALL MAKE EXPLORATION EXCAVATIONS AND LOCATE EXISTING UNDERGROUND UTILITIES SUFFICIENTLY AHEAD OF CONSTRUCTION TO PERMIT REVISIONS TO PLANS IF REVISIONS ARE NECESSARY BECAUSE OF LOCATION OF EXISTING UTILITIES.
- CONSTRUCTION CONTRACTOR AGREES THAT IN ACCORDANCE WITH GENERALLY ACCEPTED CONSTRUCTION PRACTICES, CONSTRUCTION CONTRACTOR WILL BE REQUIRED TO ASSUME SOLE AND COMPLETE RESPONSIBILITY FOR THE JOB SITE CONDITIONS DURING THE COURSE OF CONSTRUCTION OF THE PROJECT INCLUDING SAFETY OF ALL PERSONS AND PROPERTY; THAT THIS REQUIREMENT SHALL BE MADE TO APPLY CONTINUOUSLY AND NOT BE LIMITED TO NORMAL WORKING HOURS, AND CONSTRUCTION CONTRACTOR FURTHER AGREES TO DEFEND, INDEMNIFY AND HOLD DESIGN PROFESSIONAL HARMLESS FROM ANY AND ALL LIABILITY, REAL OR ALLEGED, IN CONNECTION WITH THE PERFORMANCE OF WORK ON THIS PROJECT, EXCEPTING LIABILITY ARISING FROM THE SOLE NEGLIGENCE OF DESIGN PROFESSIONAL.
- IF ANY EXISTING HARDSCAPE OR LANDSCAPE, INCLUDING STRIPING, INDICATED ON THE APPROVED PLANS IS DAMAGED OR REMOVED DURING DEMOLITION OR CONSTRUCTION, IT SHALL BE THE RESPONSIBILITY OF THE CONTRACTOR TO ASSURE THAT IT SHALL BE REPAIRED OR REPLACED IN KIND AND EQUIVALENT SIZE PER THE APPROVED PLANS.
- THE CONTRACTOR SHALL TAKE DUE PRECAUTIONARY MEASURES TO PROTECT ANY EXISTING UTILITIES OR STRUCTURES LOCATED AT THE WORK SITE. IT IS THE CONTRACTOR'S RESPONSIBILITY TO CONTACT THE OWNERS OF UTILITIES OR STRUCTURES PRIOR TO ANY EXCAVATION FOR VERIFICATION AND LOCATION OF UTILITIES AND NOTIFICATION OF COMMENCEMENT OR WORK:

SDG&E-GAS & ELECTRIC	(800) 227-2600
AT&T (UNDERGROUND SERVICE ALERT)	(800) 422-4133
SEWER (RAMONA MUNICIPAL WATER DISTRICT)	(760) 789-1330
WATER (RAMONA MUNICIPAL WATER DISTRICT)	(760) 789-1330

STANDARDS PLANS AND SPECIFICATIONS

THE WORK SHOWN ON THESE PLANS IS TO BE DONE ACCORDING TO THE PROJECT SPECIFICATIONS AND THE FOLLOWING STANDARD SPECIFICATIONS, PLANS, MUNICIPAL CODES, AND DESIGN MANUALS AND GUIDELINES:

STANDARD SPECIFICATIONS:

US DEPT TRANSPORTATION FEDERAL AVIATION ADMINISTRATION STANDARD SPECIFICATIONS FOR CONSTRUCTION OF AIRPORTS AC NO. 150/5370-10H DATED 12/21/2018

STANDARD SPECIFICATIONS FOR PUBLIC WORKS CONSTRUCTION (GREENBOOK), 2024 EDITION

CALIFORNIA DEPARTMENT OF TRANSPORTATION MANUAL OF UNIFORM TRAFFIC CONTROL DEVICES, REV 6, 2018 EDITION

STANDARD PLANS:

SAN DIEGO REGIONAL STANDARD DRAWINGS FOR PUBLIC WORKS CONSTRUCTION, 2022 EDITION

CALIFORNIA DEPARTMENT OF TRANSPORTATION U.S CUSTOMARY STANDARD PLANS, 2023 EDITION

TOPOGRAPHY SOURCE

THE EXISTING TOPOGRAPHY SURVEY AS SHOWN ON THESE PLANS WAS PROVIDED BY THE OWNER ASSOCIATED WITH THE ADJACENT FIRE SUPPRESSANT LOADING PROJECT AS APPROVED BY DAVID B. KAROLY AUGUST 26,2020.

BASIS OF BEARING

HORIZONTAL COORDINATES ON THIS SURVEY ARE EXPRESSED IN THE CALIFORNIA COORDINATE SYSTEM OF 1983, ZONE VI, EPOCH 2010.00. DERIVED FROM OPUS SOLUTIONS AND CONVENTIONAL TRAVERSE.

VERTICAL BENCHMARK

ELEVATIONS ARE EXPRESSED IN NAVD88, GEOID 12B PROCESSED BY CALFIRE.

GRADING AND GEOTECHNICAL SPECIFICATIONS

ALL GRADING SHALL BE DONE UNDER OBSERVATION AND TESTING BY A QUALIFIED CIVIL ENGINEER OR GEOTECHNICAL ENGINEER AND, IF REQUIRED, BOTH A QUALIFIED CIVIL ENGINEER OR GEOTECHNICAL ENGINEER AND AN ENGINEERING GEOLOGIST. ALL GRADING MUST BE PERFORMED IN ACCORDANCE WITH APPLICABLE CITY ORDINANCE AND THE RECOMMENDATIONS AND SPECIFICATIONS SET FORTH A SOILS REPORT OR GEOLOGICAL/GEOTECHNICAL INVESTIGATION ENTITLED:

GEOTECHNICAL INVESTIGATION CAL FIRE RAMONA AIR ATTACK BASE CALIFORNIA, PREPARED BY GEOCON, DATED MAY 11, 2026. PROJECT NO. G3644-42-02

CONSTRUCTION STORM WATER PROTECTION NOTES


TOTAL SITE DISTURBANCE IS OVER AN ACRE

THE PROJECT IS SUBJECT TO MUNICIPAL SEPARATE STORM SEWER SYSTEM (MS4) PERMIT NO. R9-2013-0001 AS AMENDED BY RP-2015-0001 DWQ AND 2015-0100 AND CONSTRUCTION GENERAL PERMIT (CGP) "ORDER NO." 2022-0057-DWG TRADITIONAL RISK LEVEL 2.

ACCORDING TO THE OWNER, THE PROJECT WILL BE INCORPORATED INTO THE CURRENTLY ACTIVE FIRE SUPPRESSANT LOADING PROJECT WITH SUBMISSION OF REVISED NOI AND SWPPP MAPS

WDID# _____ (CONTRACTOR/OWNER TO CONFIRM AND FILL IN PRIOR TO CONSTRUCTION)

CALFIRE RAMONA AIR ATTACK BASE
HELIPADS
CIVIL IMPROVEMENT PLANS

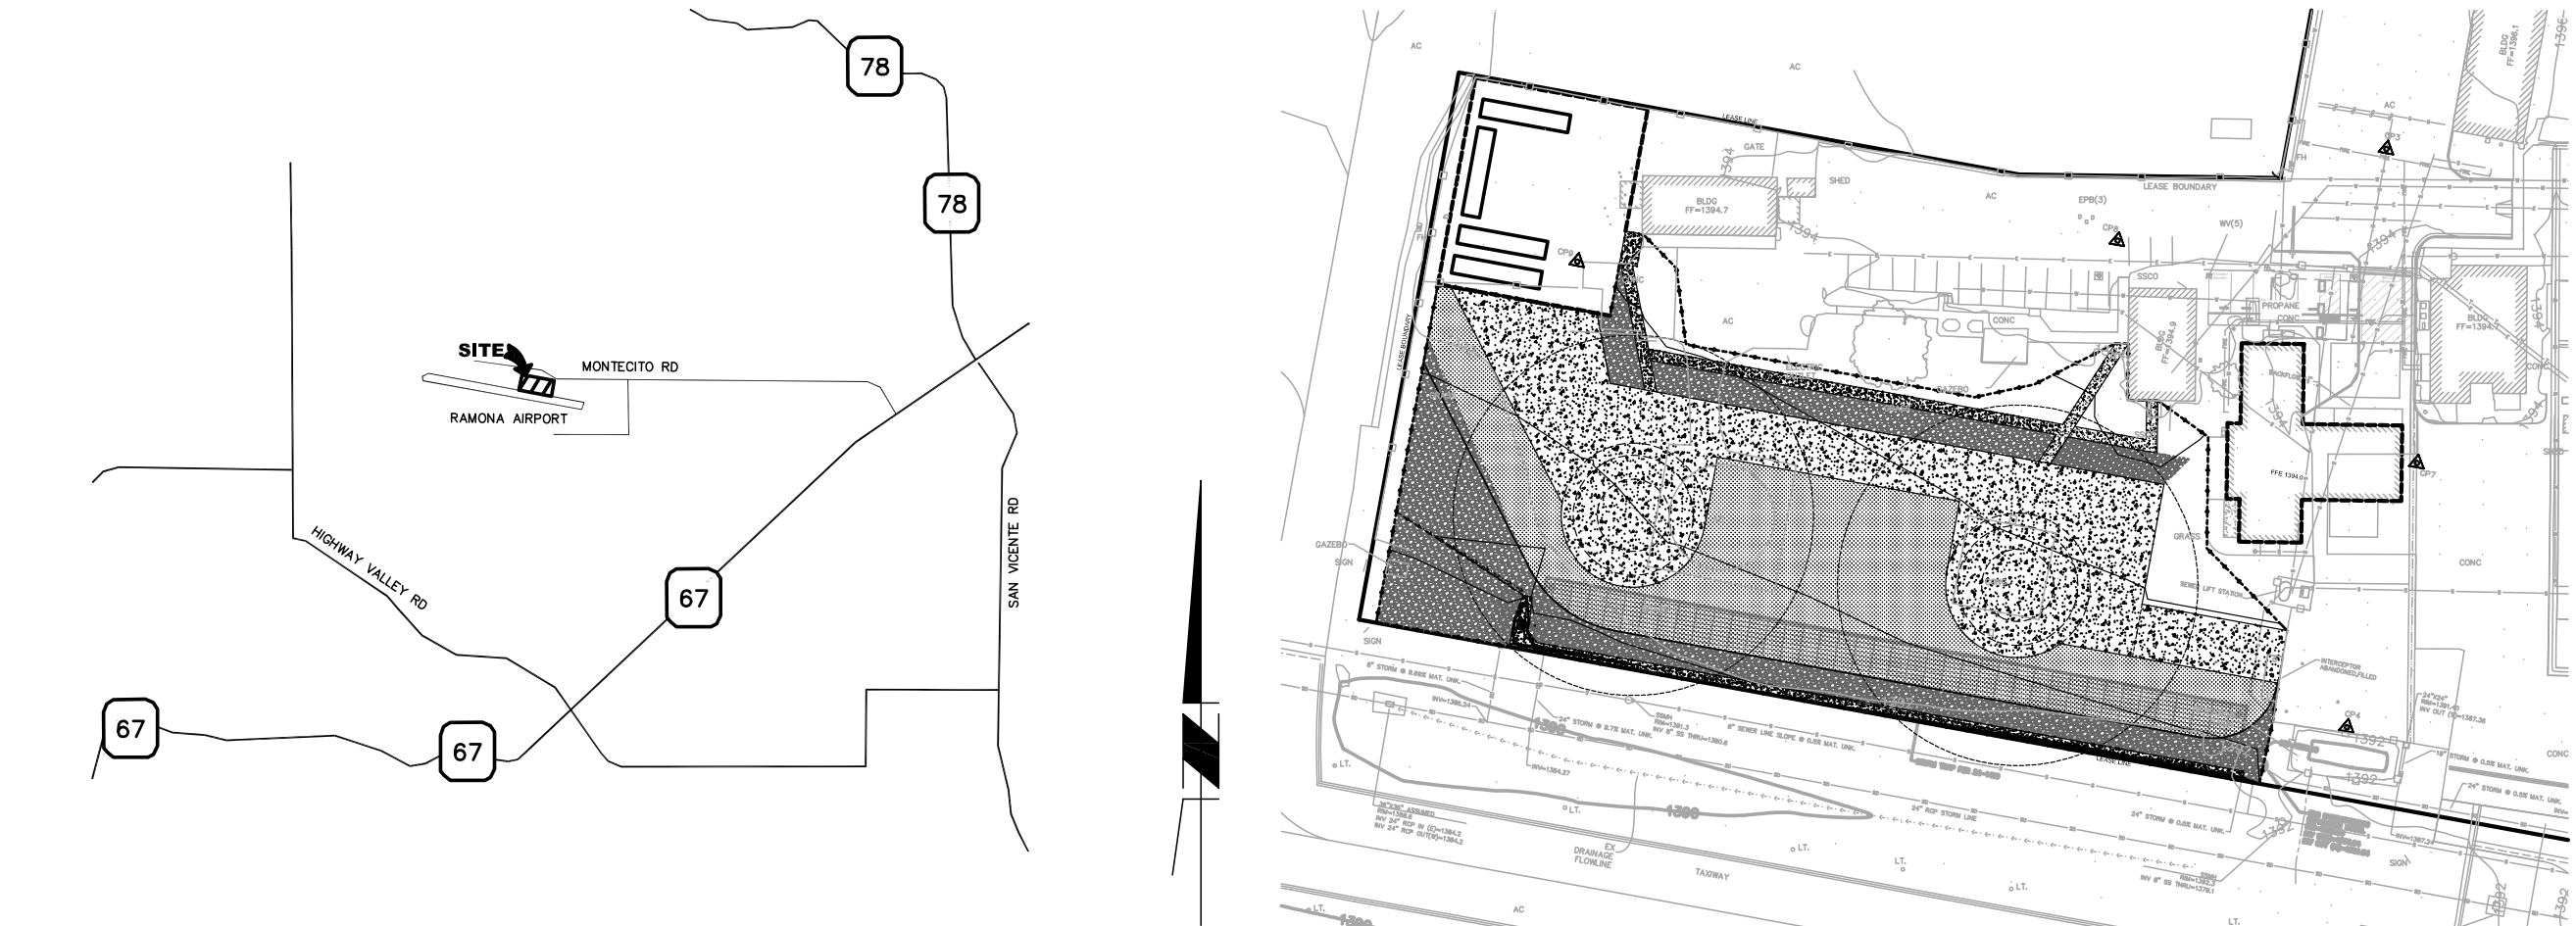

VICINITY MAP

NO SCALE

KEY MAP

NO SCALE

LEGEND

SYMBOL	ITEM
	PROPERTY LINE
	RIGHT OF WAY LINE
	EASMENT

EXISTING

	WATER LINE
	FIRE SERVICE LINE
	IRRIGATION LINE
	SEWER LINE
	STORM DRAIN LINE
	GAS LINE
	COMMUNICATION LINE
	ELECTRIC LINE
	ELEVATION CONTOUR
	WATER VALVE
	ELEC PULL BOX
	LIGHT
	SIGN
	BUILDING
	SPOT ELEVATION
	FIRE HYDRANT
	BENCHMARK
	FOUND MONUMENT
	IRRIGATION CONTROL BOX
	JUNCTION BOX
	SEWER MANHOLE
	STORM DRAIN MANHOLE
	TELEPHONE PEDESTAL
	TRAFFIC SIGNAL PULLBOX
	TREE
	WATER MANHOLE
	WATER METER

PROPOSED

	MAJOR CONTOUR
	MINOR CONTOUR
	SPOT ELEVATION
	SURFACE FLOW DIRECTION
	GRADING DAYLIGHT LINE
	SWALE
	GRADE BREAK
	PORTLAND CEMENT CONCRETE PAVING PER DETAIL 1/C2.0
	PEDESTRIAN CONCRETE PAVING PER DETAIL 2/C2.0
	COBBLE PER PLAN


ABBREVIATIONS

AC	ASPHALTIC CONCRETE	P	PAVEMENT
ACC	ACCESSIBLE	PCC	PORTLAND CEMENT CONCRETE
AD	AREA DRAIN	PIV	POST INDICATOR VALVE
BFP	BACKFLOW PREVENTOR	POC	POINT OF CONNECTION
BW	BOTTOM OF WALL	PB	PULL BOX
CB	CATCH BASIN	PR	PROPOSED
CL	CENTERLINE	RIM	RIM OF STRUCTURE COVER
CO	CLEANOUT	RW	RECYCLED WATER
CONC	CONCRETE	RW	RIGHT OF WAY
CYD	CUBIC YARDS	S	SEWER
EX	EXISTING	SCO	SEWER CLEANOUT
EOP	EDGE OF PAVEMENT	SD	STORM DRAIN
FDC	FIRE DEPARTMENT CONNECTION	SFM	SEWER FORCE MAIN
FFE	FINISH FLOOR ELEVATION	SMH	SEWER MANHOLE
FG	FINISH GRADE	SWPPP	STORM WATER POLLUTION PREVENTION PLAN
FG	FIRE HYDRANT		
FL	FLOWLINE	TB	TOP OF BOX
FS	FIRE SERVICE	TB	THRUST BLOCK
FS	FINISH SURFACE	TC	TOP OF CURB
GB	GRADE BREAK	TD	TRENCH DRAIN
G&O	GRIND AND OVERLAY	TF	TOP OF FOOTING
HH	HANDHOLE	TG	TOP OF GRATE
IE	INVERT ELEVATION	TP	TOP OF PIPE
IRR	IRRIGATION	TW	TOP OF WALL
LF	LINEAR FEET	TYP	TYPICAL
LG	LIP OF GUTTER	W	WATER
LOW	LIMIT OF WORK	WM	WATER METER
		WV	WATER VALVE



AT LEAST TWO DAYS BEFORE YOU DIG

UNDERGROUND SERVICE ALERT OF SOUTHERN CALIFORNIA

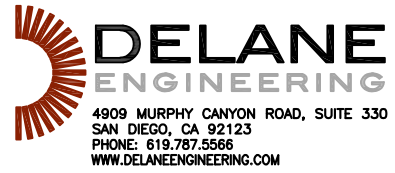

DESCRIPTION:	DATE:
PRELIMINARY DESIGN	03/13/26
50% CONSTRUCTION DOCUMENTS	04/20/26
95% CONSTRUCTION DOCUMENTS	06/02/26
100% CONSTRUCTION DOCUMENTS	06/11/26
PERMITTING SUBMITTAL	06/23/26



PROJECT:

CALIFORNIA DEPARTMENT OF FORESTRY AND FIRE PROTECTION
CAL FIRE RAMONA AIR ATTACK BASE - HELIPAD DESIGN

2498 MONTECITO ROAD,
RAMONA, CALIFORNIA 92065

PROJECT NUMBER:

260101

SHEET TITLE:


CIVIL TITLE SHEET

SHEET NUMBER:

C1.0



- ## 2 PEDESTRIAN CONCRETE PAVEMENT SECTION

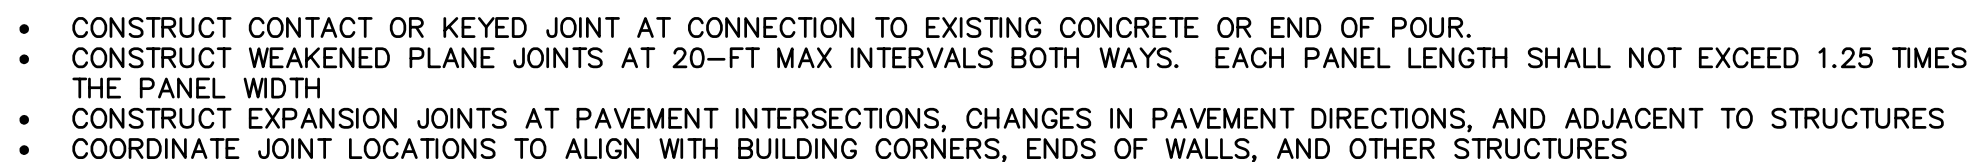

3 | CONCRETE JOINTS



 
A MAX 26" PIPE OPENING CAN BE FIELD CORED AT THE BASE OF MODULE C1 (AS INDICATED IN THE APPROVED SHOP DRAWING FOR THE STORMTRAP SYSTEM AS PART OF THE FIRE SUPPRESSANT PROJECT). THE INVERT OF THE PIPE ITSELF AND/OR THE OPENING MUST BE SET ROUGHLY EQUAL TO THE SYSTEM INVERT (TOP OF THE FLOOR SLAB). MAINTAIN MINIMUM 3'-0" EDGE DISTANCE (MEASURED FROM EDGE OF OPENING TO EITHER END OF THE STORMTRAP MODULE). TO PREVENT CORROSION, EPOXY ALL REINFORCEMENT THAT IS OUR CUT OR OTHERWISE EXPOSED BY THE CORING PROCESS.

PLAN VIEW

ENLARGED PLAN

SCALE 1"=5'





DESCRIPTION:	DATE:
PRELIMINARY DESIGN	03/13/26
50% CONSTRUCTION DOCUMENTS	04/20/26
95% CONSTRUCTION DOCUMENTS	06/02/26
100% CONSTRUCTION DOCUMENTS	06/11/26
PERMITTING SUBMITTAL	06/23/26



PROJECT:
CALIFORNIA DEPARTMENT
OF FORESTRY AND FIRE
PROTECTION
CAL FIRE RAMONA AIR ATTACK BASE
- HELIPAD DESIGN

2498 MONTECITO ROAD,
RAMONA, CALIFORNIA 92065

PROJECT NUMBER: 260101

SHEET TITLE:

EXISTING CONDITIONS AND
CONSTRAINTS MAP

SHEET NUMBER:

C3.0

CONSTRUCTION NOTES

- 1 HELIPAD CONCRETE PAVING PER DET 1/C2.0
- 2 4' COBBLE OVER 3/4" CRUSHED AGGREGATE BASE
- 3 PEDESTRIAN CONCRETE PAVING PER DET 2/C2.0
- 4 TURF PER CALFIRE

NOTE TO CONTRACTOR

CONTRACTOR SHALL VERIFY ALL FIELD CONDITIONS,
INCLUDING STORMTRAP STRUCTURE AND PIPING



1940 GRANITE RIDGE DR, SUITE 100
SAN DIEGO, CA 92123
619.593.9177 | www.coargroup.com



DESCRIPTION:	DATE:
PRELIMINARY DESIGN	03/13/26
50% CONSTRUCTION DOCUMENTS	04/20/26
95% CONSTRUCTION DOCUMENTS	06/02/26
100% CONSTRUCTION DOCUMENTS	06/11/26
PERMITTING SUBMITTAL	06/23/26




PROJECT:
CALIFORNIA DEPARTMENT
OF FORESTRY AND FIRE
PROTECTION
CAL FIRE RAMONA AIR ATTACK BASE
- HELIPAD DESIGN
2498 MONTECITO ROAD,
RAMONA, CALIFORNIA 92065

PROJECT NUMBER:
260101


SHEET TITLE:
GRADING PLAN


SHEET NUMBER:

C4.0

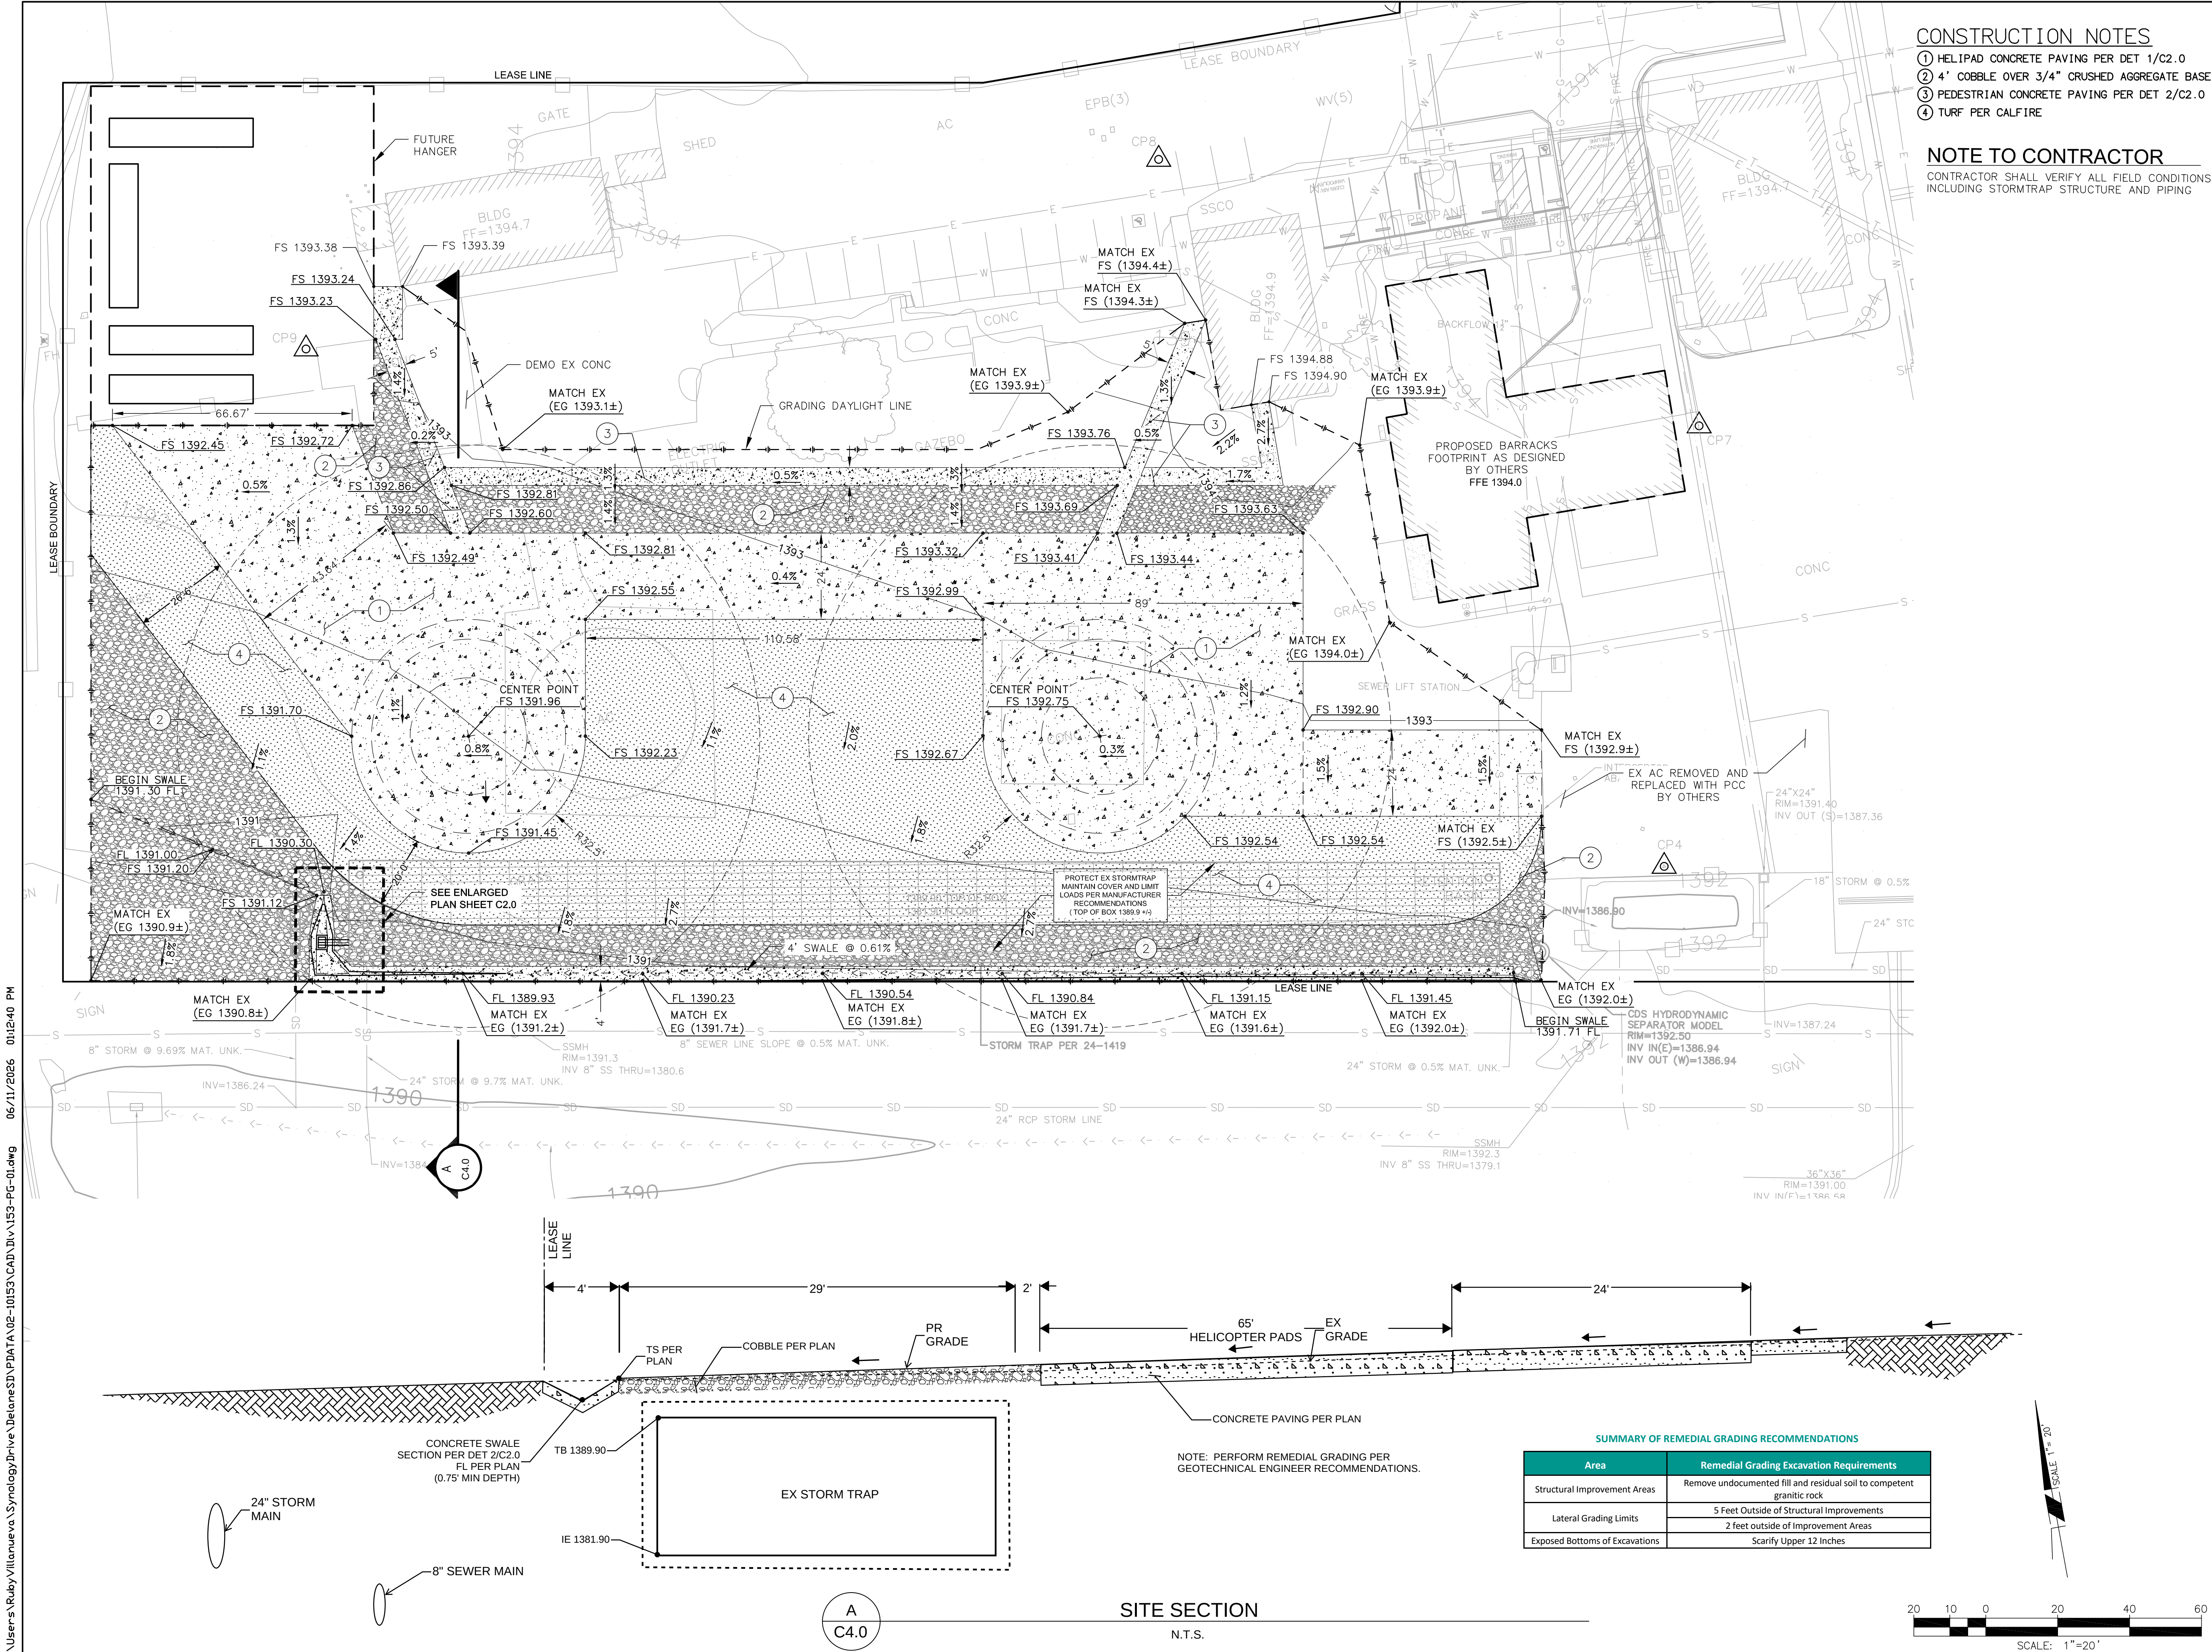

C:\Users\Rudy.Villanueva\OneDrive\Delane\Delane\SD\DATA\02-10153\CAD\DW\153-PG-01.dwg 06/11/2026 01:24:40 PM

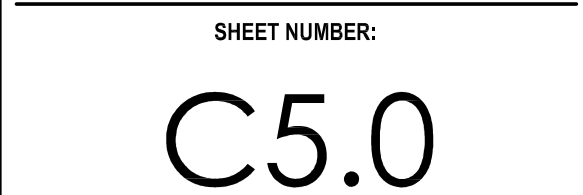

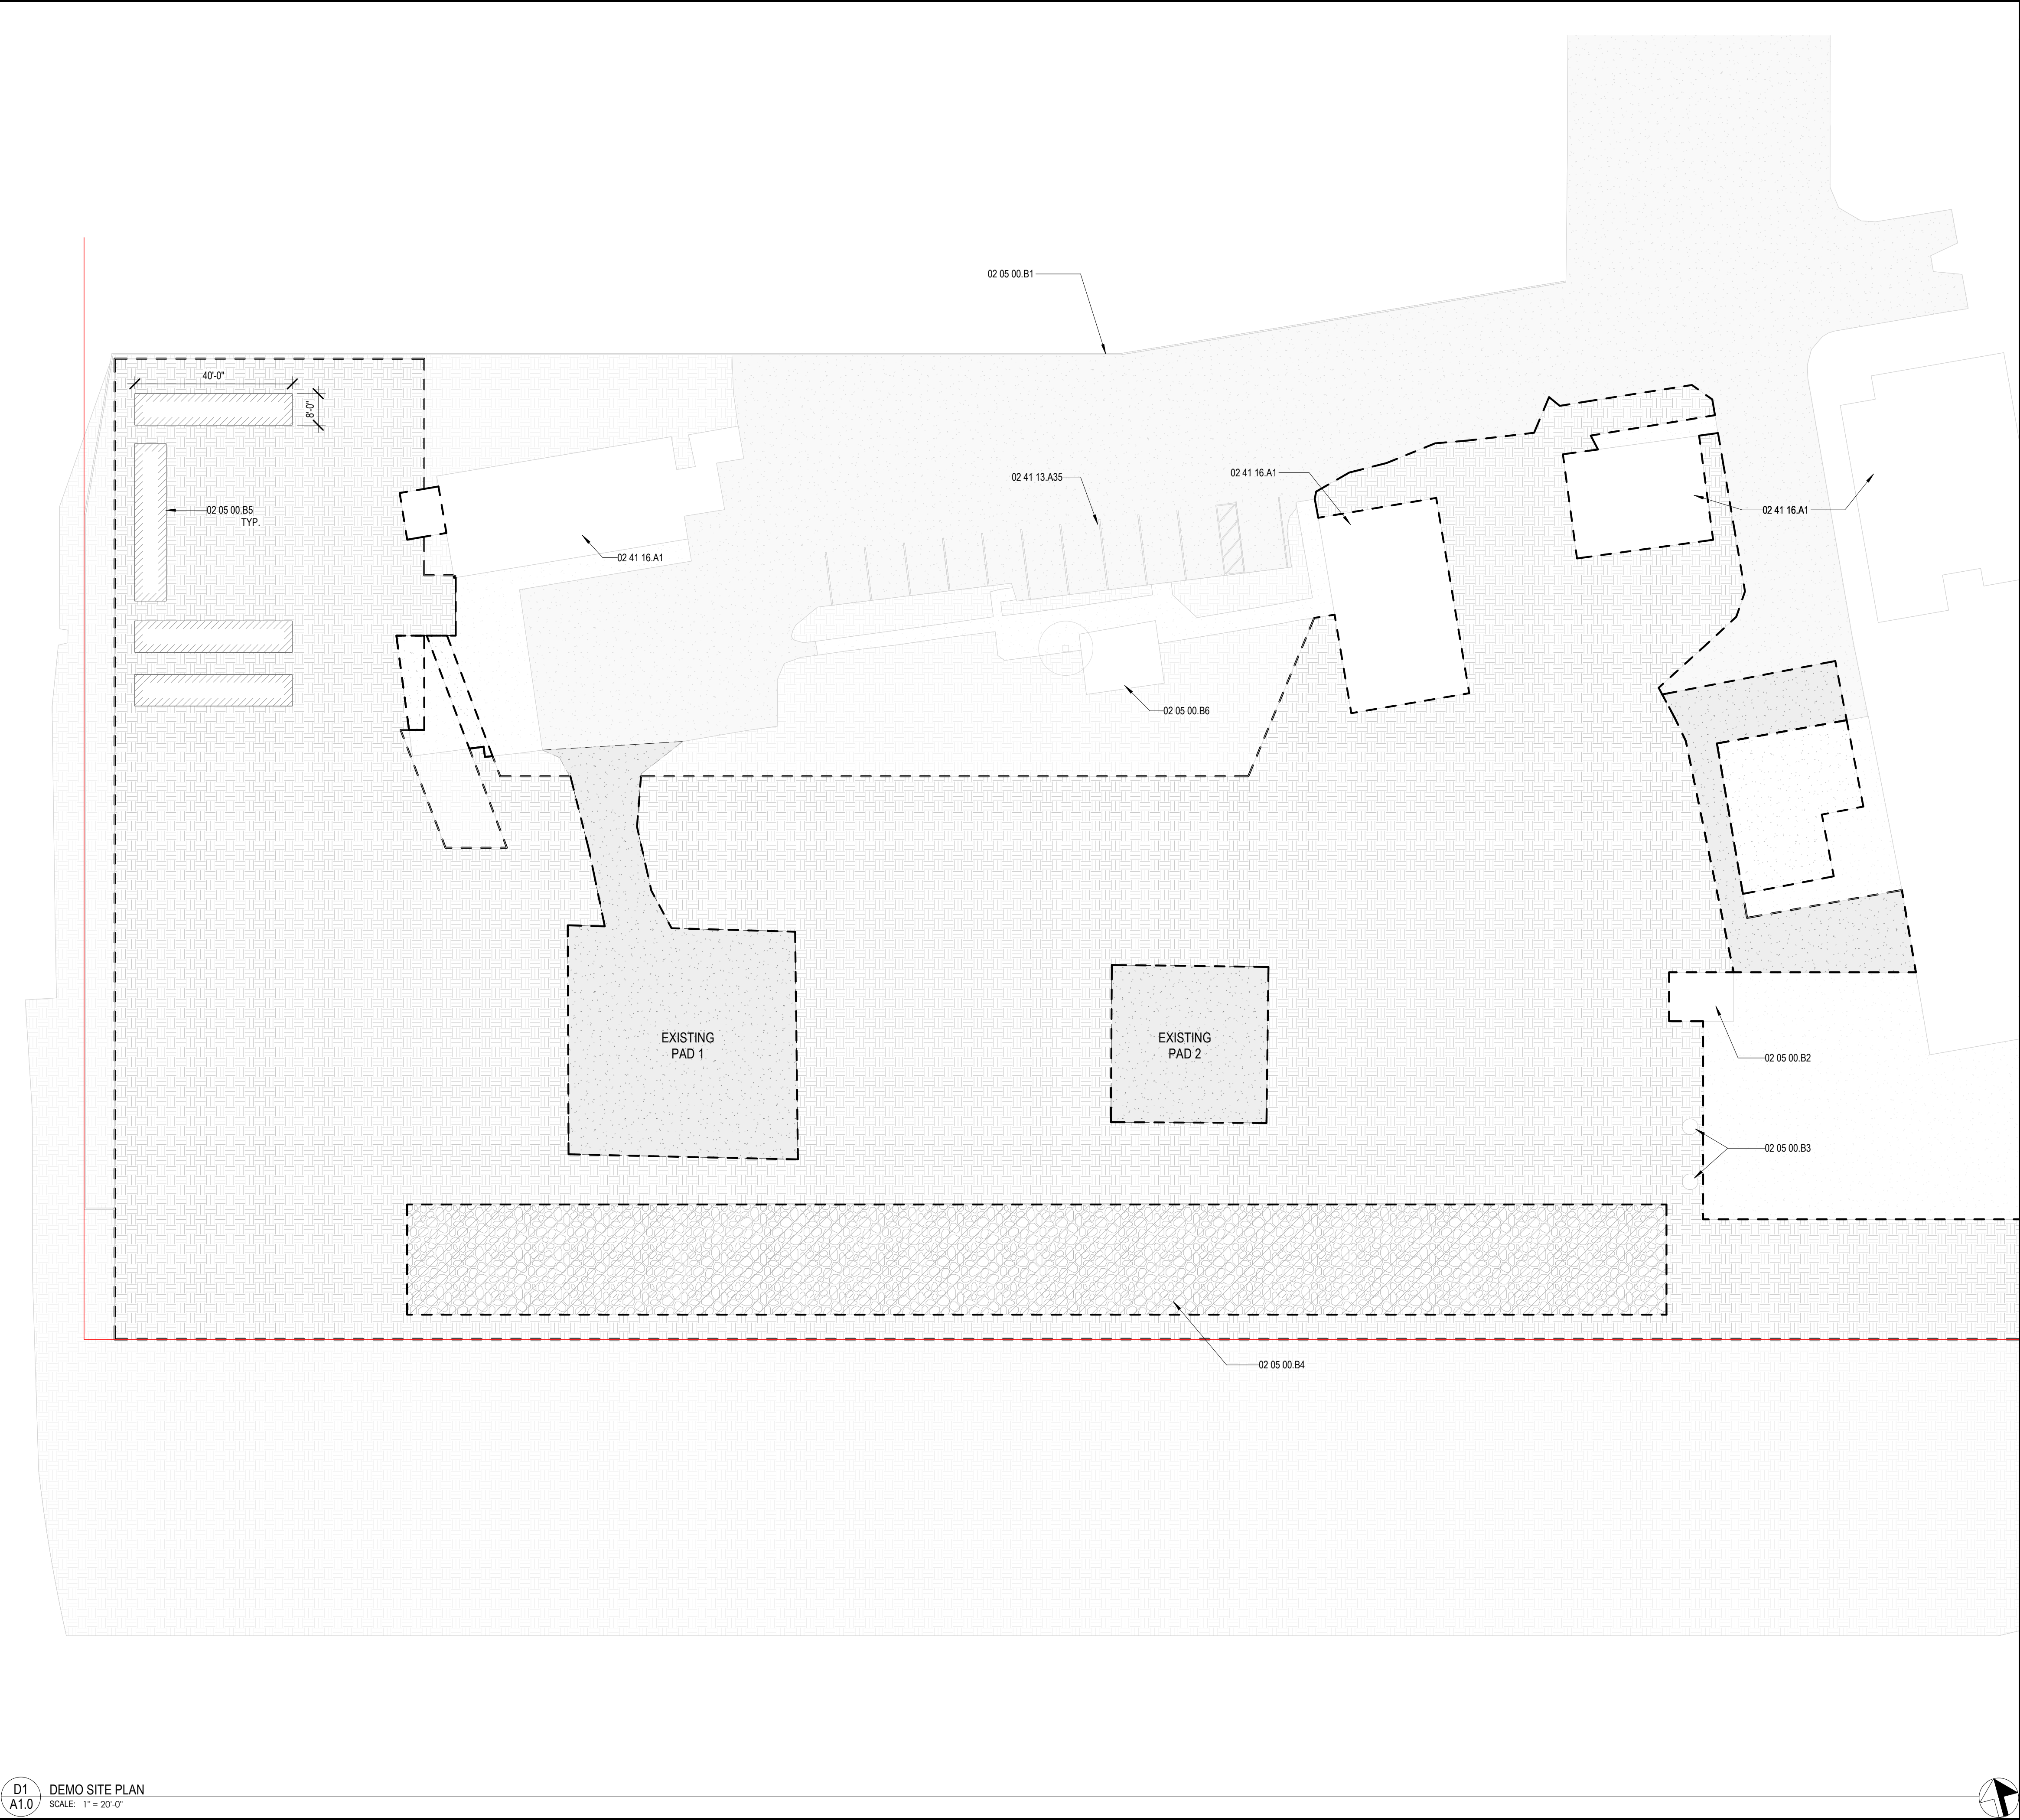

D1 DEMO SITE PLAN
A1.0 SCALE: 1" = 20'-0"

CONSTRUCTION NOTES

- 01 05 00.B5 FUTURE HANGER
- 01 05 00.B6 STORAGE CONTAINER, BY OWNER
- 01 05 00.B7 FUTURE BARRACKS EXPANSION
- 02 05 00.B1 EXISTING SITE WALL TO REMAIN
- 02 05 00.B2 EXISTING SEWER LIFT STATION TO REMAIN
- 02 05 00.B3 EXISTING SEWER MANHOLES ABANDONED
- 02 05 00.B4 EXISTING PRECAST CONCRETE HYDROMODIFICATION VAULT PER "STORMTRAP-03-10-2025"
- 02 05 00.B5 EXISTING CONCRETE PADS FOR CONTAINERS TO REMAIN
- 02 05 00.B6 EXISTING GAZEBO TO REMAIN
- 02 05 00.B7 EXISTING SHED TO REMAIN
- 02 05 00.B8 EXISTING TREE TO REMAIN, PROTECT IN PLACE
- 02 05 00.C1 ACCESS ROAD
- 02 05 00.D1 PROTECTION RADIUS AROUND TREE, SAFE DISTANCE
- 02 41 13.A35 EXISTING PARKING TO REMAIN
- 02 41 16.A1 EXISTING BUILDING TO REMAIN, PROTECT IN PLACE
- 26 01 00.B2 HELIPORT PERIMETER LIGHT, SEE ELECTRICAL
- 26 01 00.B3 LIGHTED WIND CONE, SEE ELECTRICAL
- 32 17 23.B1 TOUCHDOWN POSITION CIRCLE 18" WIDE YELLOW LINE
- 32 17 23.B2 TLOF SIZE/WEIGHT LIMITATION BOX
- 32 17 23.B3 TLOF PERIMETER MARKING 12" WIDE WHITE LINE
- 32 17 23.B4 HELIPORT IDENTIFICATION SYMBOL
- 32 17 23.B5 SEE AC150/5390-2D APPENDIX C FOR THE FORM AND PROPORTIONS OF THE FIGURES

DEMO SITE PLAN LEGEND

- LEASE LIMIT LINE
- EXISTING ASPHALT TO REMAIN
- EXISTING ASPHALT TO BE DEMOED
- EXISTING CONCRETE TO REMAIN
- EXISTING CONCRETE TO BE DEMOED
- EXISTING LANDSCAPE TO REMAIN
- EXISTING LANDSCAPE TO BE DEMOED
- EXISTING STORMTRAP AREA TO REMAIN
- EXISTING BUILDING TO BE DEMOED
- EXISTING TREE TO REMAIN



9640 GRANITE RIDGE DR, SUITE 130
SAN DIEGO, CA 92123
619.668.9177 | www.coargroup.com

DESCRIPTION:	DATE:
PRELIMINARY DESIGN	03/13/26
50% CONSTRUCTION DOCUMENTS	04/20/26
95% CONSTRUCTION DOCUMENTS	06/02/26
100% CONSTRUCTION DOCUMENTS	06/11/26
PERMITTING SUBMITTAL	06/23/26



PROJECT:
CALIFORNIA DEPARTMENT OF FORESTRY AND FIRE PROTECTION
CAL FIRE RAMONA AIR ATTACK BASE - HELIPAD DESIGN
2498 MONTECITO ROAD,
RAMONA, CALIFORNIA 92065

PROJECT NUMBER:
260101

SHEET TITLE:
DEMO SITE PLAN


SHEET NUMBER:
A1.0



01 05 00.05	FUTURE HANGER
01 05 00.06	STORAGE CONTAINER, BY OWNER
01 05 00.07	FUTURE BARRACKS EXPANSION
02 05 00.01	EXISTING SITE WALL TO REMAIN
02 05 00.02	EXISTING SEWER FLIT STATION TO REMAIN
02 05 00.03	EXISTING SEWER MANHOLES ABANDONED
02 05 00.04	EXISTING PRECAST CONCRETE HYDROMODIFICATION VAULT PER STANDARD 05-10-2025
02 05 00.05	EXISTING CONCRETE PADS FOR CONTAINERS TO REMAIN
02 05 00.06	EXISTING GAZEDO TO REMAIN
02 05 00.07	EXISTING SHED TO REMAIN
02 05 00.08	EXISTING TREE TO REMAIN, PROTECT IN PLACE
02 05 00.C1	ACCESS ROAD
02 05 00.D1	PROTECTION RADIOUS AROUND TREE, FREE DISTANCE
02 41 13.A35	EXISTING PARKING TO REMAIN
02 41 16.A1	EXISTING BUILDINGS TO REMAIN, PROTECT IN PLACE
26 01 00.02	HELIPORT PERMITTER LIGHT, SEE ELECTRICAL
26 01 00.03	LIGHTED WINDY CONE, SEE ELECTRICAL
27 13 23.B1	TOUCHDOWN POSITION CIRCLE 18" WIDE YELLOW LINE
27 13 23.B2	10' OF SIZE 18" LIMITATION BOX
27 13 23.B3	TLOF PERMETER MARKING 12" WIDE WHITE LINE
27 13 23.B4	HELIPORT IDENTIFICATION SYMBOL
27 13 23.B5	SEE AC150/5390.2D APPENDIX C FOR THE FORM AND PROPORTIONS OF THE FIGURES

----	OUTLINE OF FUTURE BUILDINGS
----	LEASE LIMIT LINE
----	OUTLINE OF ROTOWASH BOUNDARY
	EXISTING ASPHALT
	EXISTING CONCRETE WALKWAY
	NEW CONCRETE PHASE 1
	NEW CONCRETE PHASE 2
	NEW CONCRETE WALKWAY
	TURF
	EXISTING LANDSCAPE
	3/4" CRUSHED ROCK WITH 4" COBBLE
	EXISTING STORMTRAP AREA
	PANELBOARDS, SEE ELECTRICAL
	LOCKABLE DISCONNECT, SEE ELECTRICAL
•	LIGHTED WIND CONE, SEE ELECTRICAL
	EXISTING TREE ON SITE

DESCRIPTION:	DATE:
PRELIMINARY DESIGN	03/13/26
50% CONSTRUCTION DOCUMENTS	04/20/26
95% CONSTRUCTION DOCUMENTS	06/02/26
100% CONSTRUCTION DOCUMENTS	06/11/26
PERMITTING SUBMITTAL	06/23/26

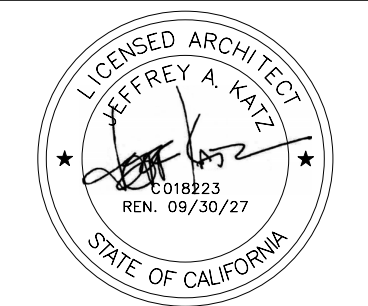

PROJECT:

CALIFORNIA DEPARTMENT
OF FORESTRY AND FIRE
PROTECTION

CAL FIRE RAMONA AIR ATTACK BASE
- HELIPAD DESIGN


2498 MONTECITO ROAD,
RAMONA, CALIFORNIA 92065

PROJECT NUMBER:
260101

SHEET TITLE:
SITE PLAN


SHEET NUMBER:

A1.1

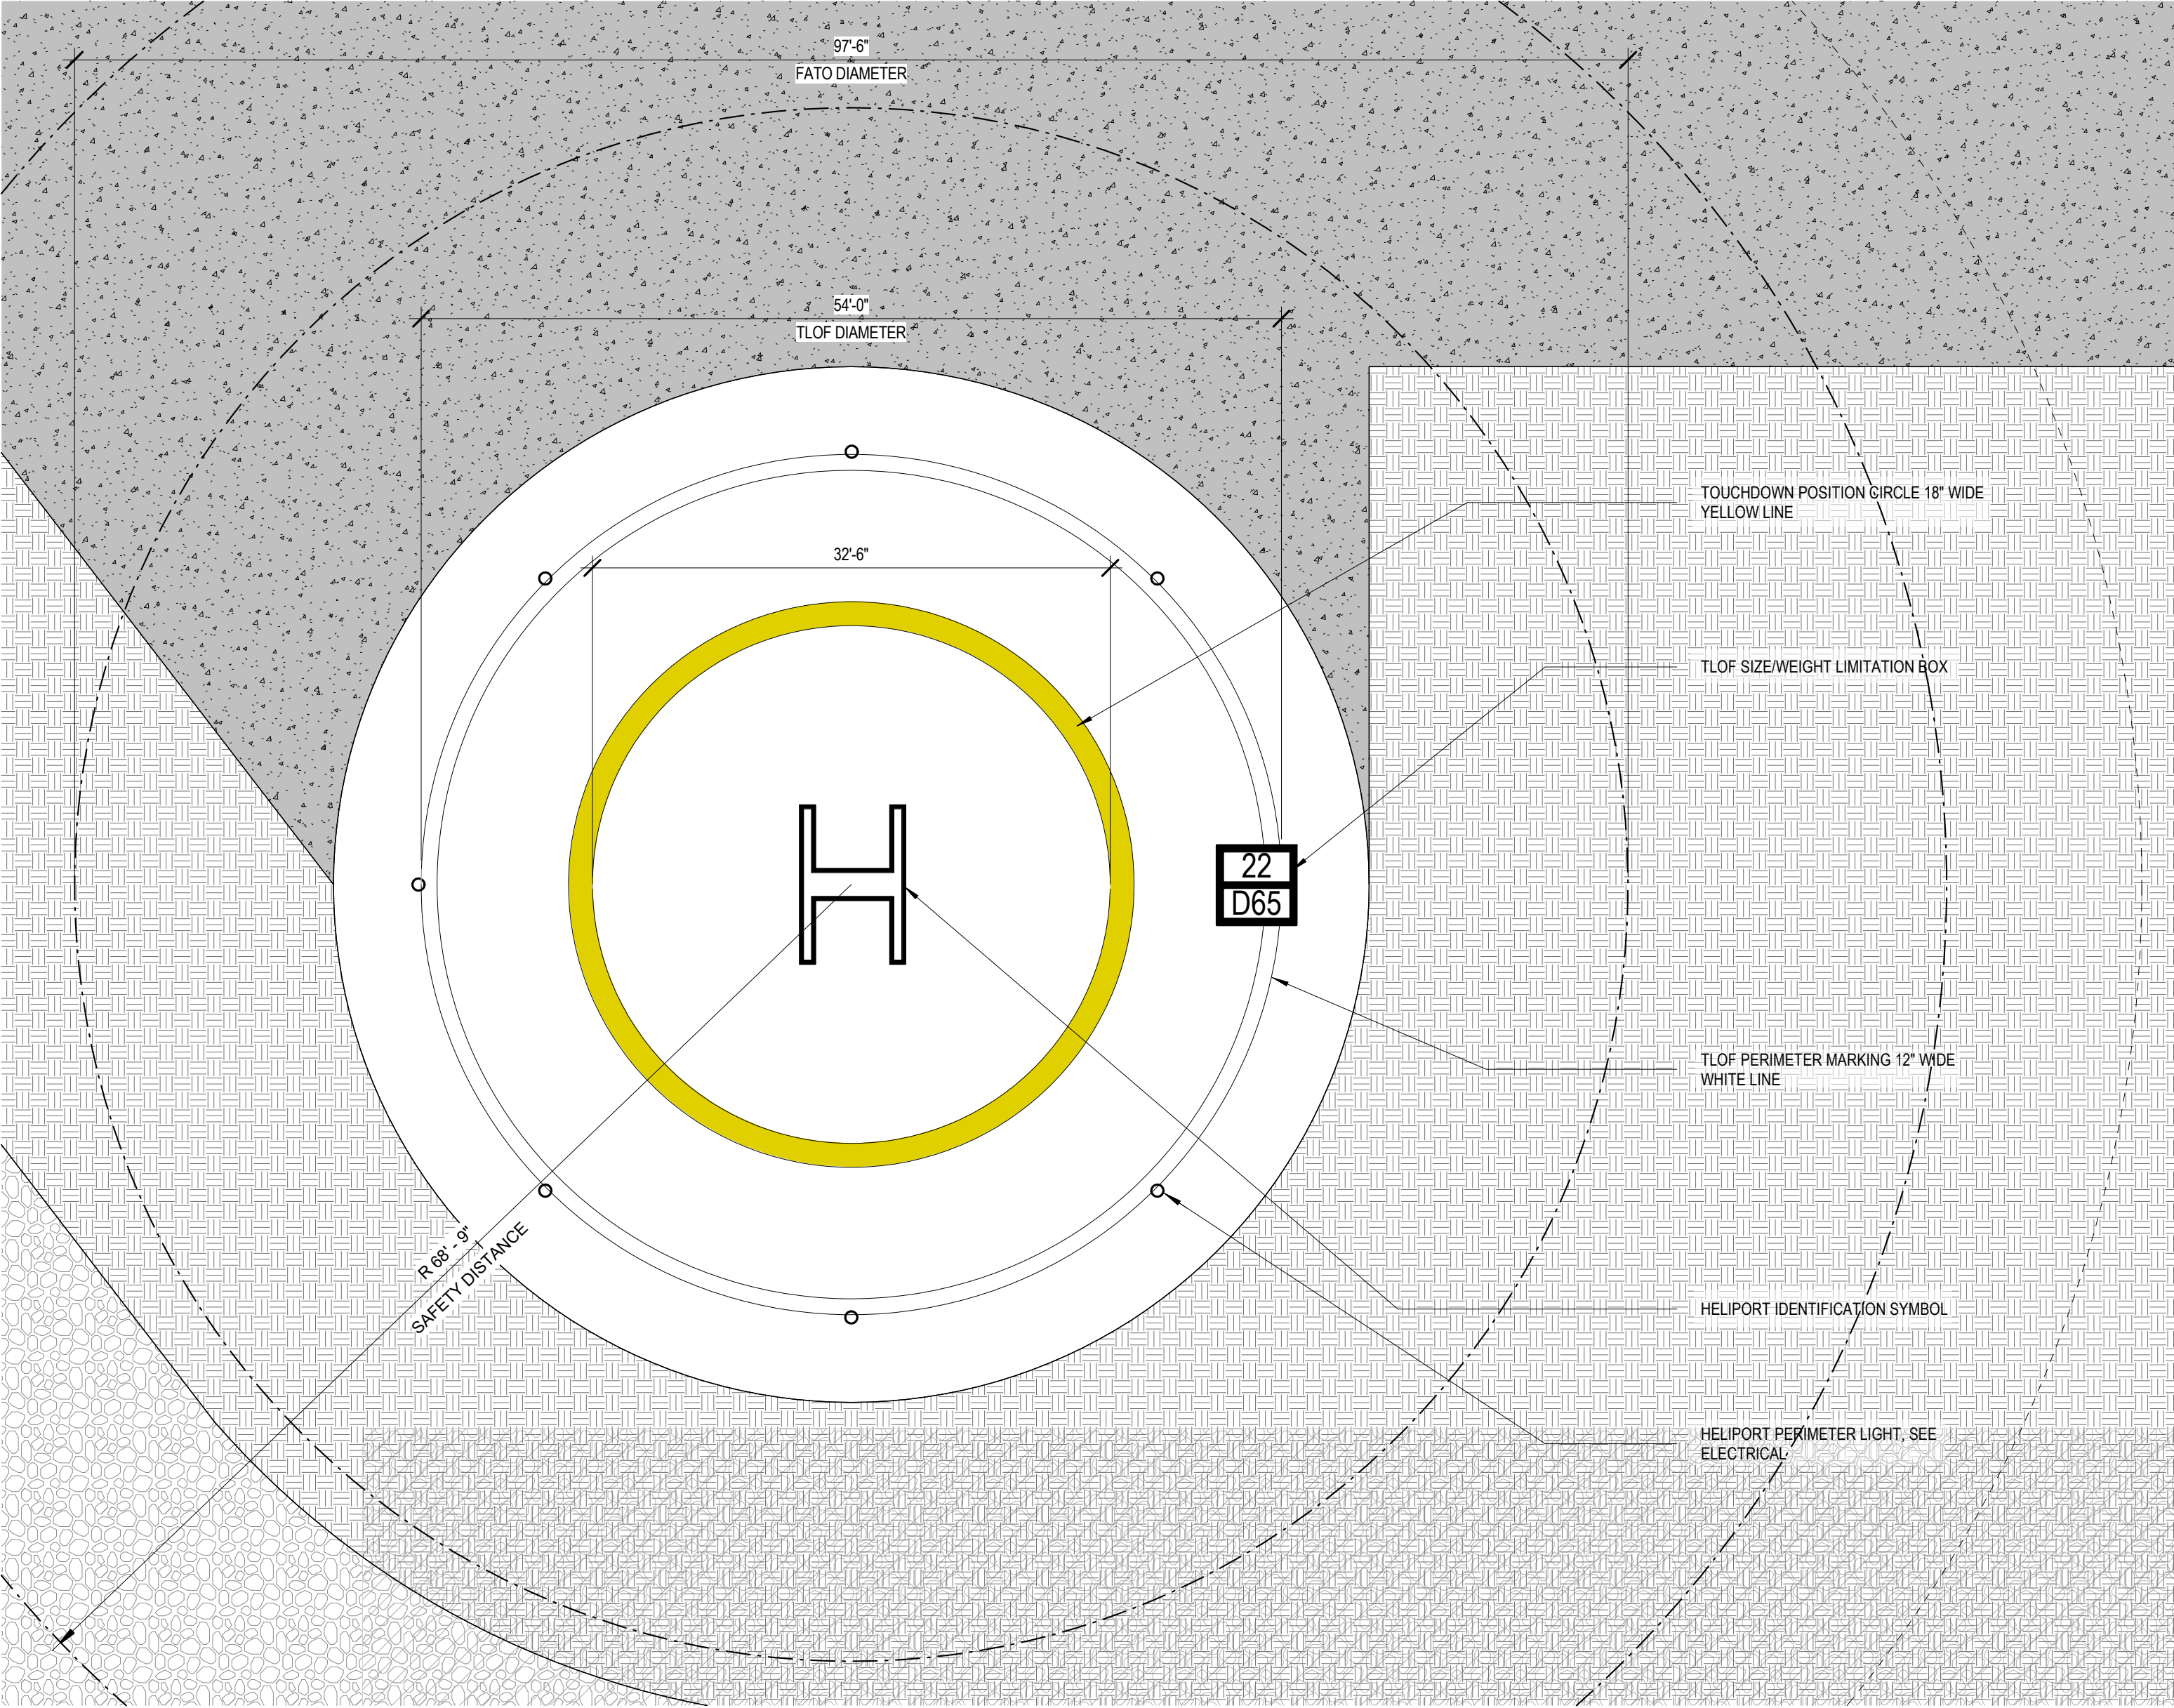


NOTE: SEE FIGURE 4-1. STANDARD TLOF MARKINGS IN THE FAA HELIPORT DESIGN ADVISORY CIRCULAR

B1
A1.2 PHASE 1 HELIPAD MARKINGS
SCALE: 1/8" = 1'-0"

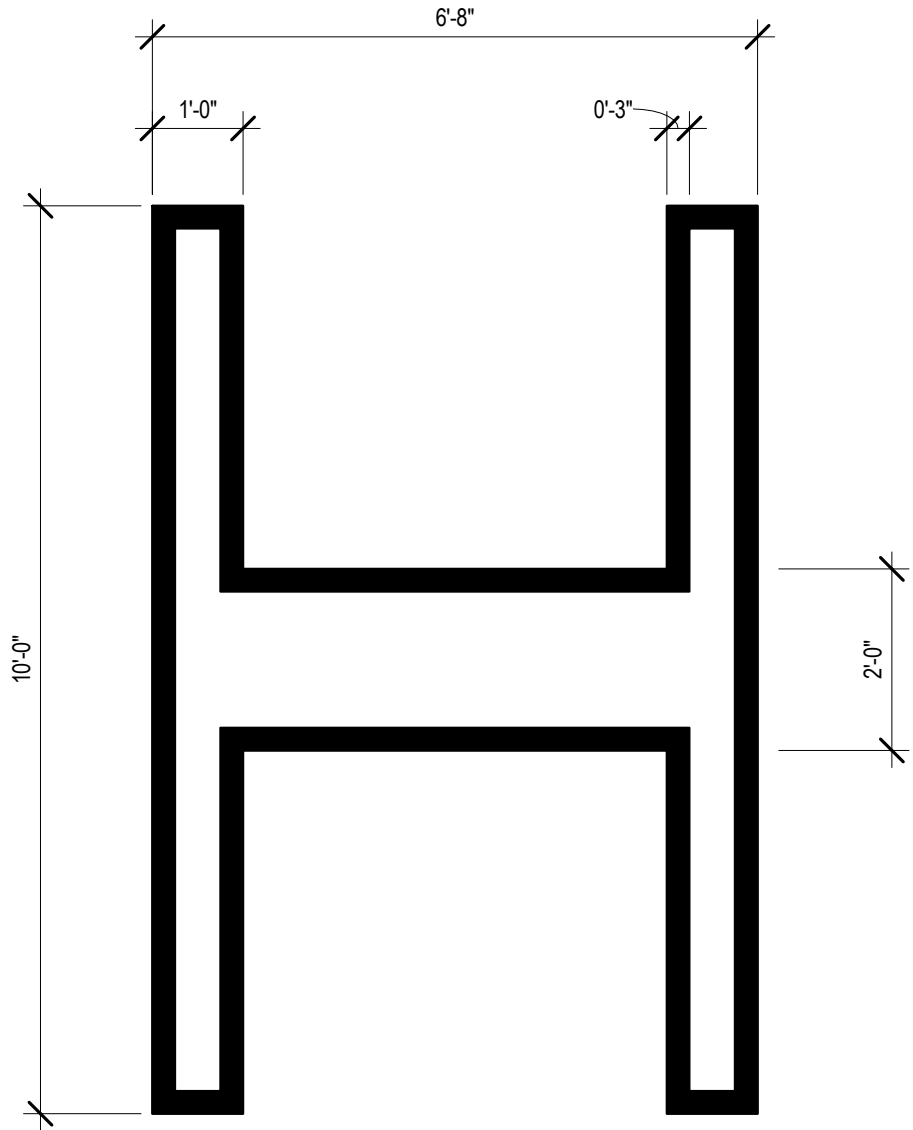

NOTE: BORDER BLACK LINES WITH WHITE INTERIOR

A4
A1.2 HELIPORT IDENTIFICATION SYMBOLS
SCALE: 1/2" = 1'-0"

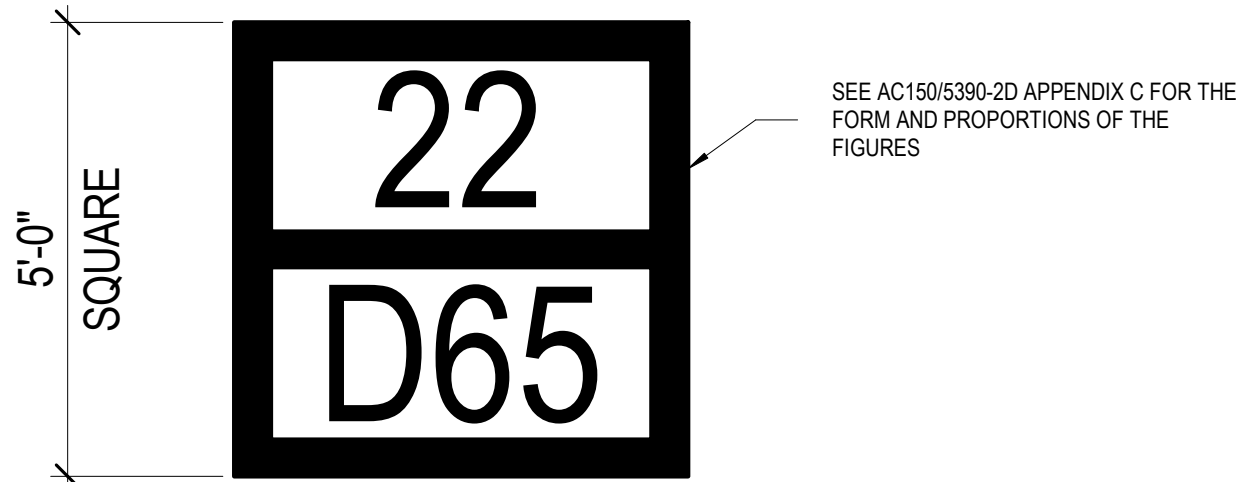

- NOTES:
- CHARACTERS ARE BLACK ON A WHITE BACKGROUND
 - "22" INDICATES MAXIMUM TAKEOFF WEIGHT (22,000 LBS) OF THE DESIGN HELICOPTER.
 - "D65" INDICATES THE OVERALL LENGTH OF THE LARGEST HELICOPTER (65 FT) FOR WHICH THE TLOF IS DESIGNED.

B4
A1.2 TLOF SIZE/WEIGHT LIMITATION BOX
SCALE: 1/2" = 1'-0"

HELIPAD DESIGN CRITERIA

CONTROLLING DIMENSION	65' - 0"
FATO DIAMETER	97' - 6"
TLOF DIAMETER	54' - 0"
SAFETY AREA DIAMETER	137' - 6"
TOTAL UNOBSTRUCTED WIDTH (FATO AND SAFETY AREA)	N/A
TLOF SURFACE MATERIAL	CONCRETE
TLOF SURFACE GRADIENT AND DIRECTION	0.5% ALL DIRECTIONS
CENTER-TO-CENTER TLOF SEPARATION	175' - 7"
LIGHTING ACTIVATION - AVIATION LIGHTING	MANUAL AND R/C
LIGHTING ACTIVATION - WALKWAY AREA LIGHTING	N/A

ABBREVIATIONS:

FATO: FINAL APPROACH AND TAKE OFF AREA
TLOF: TOUCHDOWN AND LIFT OFF

ENLARGED SITE PLAN LEGEND

	NEW CONCRETE PHASE 1
	NEW CONCRETE PHASE 2
	3/4" CRUSHED ROCK WITH 4" COBBLE
	EXISTING STORMTRAP AREA



coar
DESIGN GROUP

9640 GRANITE RIDGE DR, SUITE 130
SAN DIEGO, CA 92123
619-688-9177 | www.coargroup.com

DESCRIPTION:	DATE:
PRELIMINARY DESIGN	03/13/26
50% CONSTRUCTION DOCUMENTS	04/20/26
95% CONSTRUCTION DOCUMENTS	06/02/26
100% CONSTRUCTION DOCUMENTS	06/11/26
PERMITTING SUBMITTAL	06/23/26



 
 
PROJECT:
CALIFORNIA DEPARTMENT OF FORESTRY AND FIRE PROTECTION
CAL FIRE RAMONA AIR ATTACK BASE - HELIPAD DESIGN
2498 MONTECITO ROAD,
RAMONA, CALIFORNIA 92065

PROJECT NUMBER:
260101

SHEET TITLE:
ENLARGED SITE PLAN

SHEET NUMBER:

A1.2

	
9640 GRANITE RIDGE DR. SUITE 120 SAN DIEGO, CA 92123 619.696.9177 www.coargroup.com	
	
DESCRIPTION:	DATE:
PRELIMINARY DESIGN	03/13/26
50% CONSTRUCTION DOCUMENTS	04/20/26
95% CONSTRUCTION DOCUMENTS	06/02/26
100% CONSTRUCTION DOCUMENTS	06/11/26
PERMITTING SUBMITTAL	06/23/26
	
005-190	
PROJECT:	
CALIFORNIA DEPARTMENT OF FORESTRY AND FIRE PROTECTION CAL FIRE RAMONA AIR ATTACK BASE - HELIPAD DESIGN 2498 MONTECITO ROAD, RAMONA, CALIFORNIA 92065	
PROJECT NUMBER:	260101
SHEET TITLE: ELECTRICAL SYMBOLS AND ABBREVIATIONS	
SHEET NUMBER:	
E0.1	

LIGHTING FIXTURE SCHEDULE								
CALLOUT	LAMP	DESCRIPTION	MOUNTING	MANUFACTURER	MODEL	WATTS	VOLTAGE	NOTES
H1	LED	FAA TYPE L-862 GREEN HELIPORT PERIMETER LIGHT	IN-GROUND	POINT LIGHTING	HP2070F	2 W	120 V	
LWC	LED	LIT WIND CONE	POLE	POINT LIGHTING	PWC-8061L-AC-ON	48 W	120 V	

FAULT CURRENT SCHEDULE							
DEVICE	FAULT AT DEVICE	AIC RATING	VOLTAGE	*FEEDER		DIRECTLY CONNECTED MOTOR	MOTOR TOTAL
				SIZE	LENGTH		
(X)USFS-MAIN	40,065	42,000	120 V			0	65
(X)USFS	5,727	10,000	120 V	2/0	177'	0	46
(X)FS1	2,525	10,000	120 V	#1	175'	66	40
LCP	1,906	10,000	120 V	#12	8'-2"	0	25

*EXISTING FEEDER SIZES ARE ESTIMATED AND SHOWN FOR REFERENCE ONLY.

VOLTAGE DROP SCHEDULE						
DEVICE	*FEEDER		BRANCH CIRCUIT			TOTAL VOLTAGE DROP
	VOLTAGE DROP	WIRE SIZE	MAX VOLTAGE DROP	CIRCUIT NUMBER	WIRE SIZE	
(X)USFS-MAIN	0.00%					0.00%
(X)USFS	1.24%	2/0				1.24%
(X)FS1	2.97%	#1	1.97%	23	#10	4.93%
LCP	2.98%	#12	0.19%	3	#12	3.17%

*EXISTING FEEDER SIZES ARE ESTIMATED AND SHOWN FOR REFERENCE ONLY.

FEEDER SCHEDULE	
* DEVICE/AMP	CALLOUT
20	
LCP	3/4"C, 1#12, #12N, #12G
100	
FS1	1-1/4"C, 2#1, #1N, #8G

Branch Panel: LCP

Location: FOREST SERVICE BLDG EXTERIOR

Supply From: FS1

Mounting: Surface

Enclosure: Type 1

Volts: 120V 1P 2W

Phases: 1

Wires: 2

Lug Type: Standard

200% Neutral: No

A.I.C. Rating: 10,000

Mains Type: MLO


Bus Rating: 20

Notes:

* SEE SHEET E3.1 FOR LIGHTING CONTROL PANEL CUTSHEET.

CKT	Circuit Description	Trip	Poles	A		Poles	Trip	Circuit Description	CKT
1	HELIPAD 1 LIGHTING	20 A	1	0.24 kVA	0.24 kVA	1	20 A	HELIPAD 2 LIGHTING	2
3	HELIPORT WIND CONE LIGHTING	20 A	1	0.05 kVA	--	1	--	BUSSED SPACE	4
5	BUSSED SPACE	--	1	--	--	1	--	BUSSED SPACE	6
Total Load:				0.53 kVA					
Total Amps:				4 A					

Load Classification		Connected Load	Demand Factor	Estimated Demand	Panel Totals	
Lighting		0.53 kVA	125.00%	0.66 kVA		
					Total Conn. Load:	0.53 kVA
					Total Est. Demand:	0.66 kVA
					Total Balanced Conn.:	4 A
					Total Est. Demand:	6 A

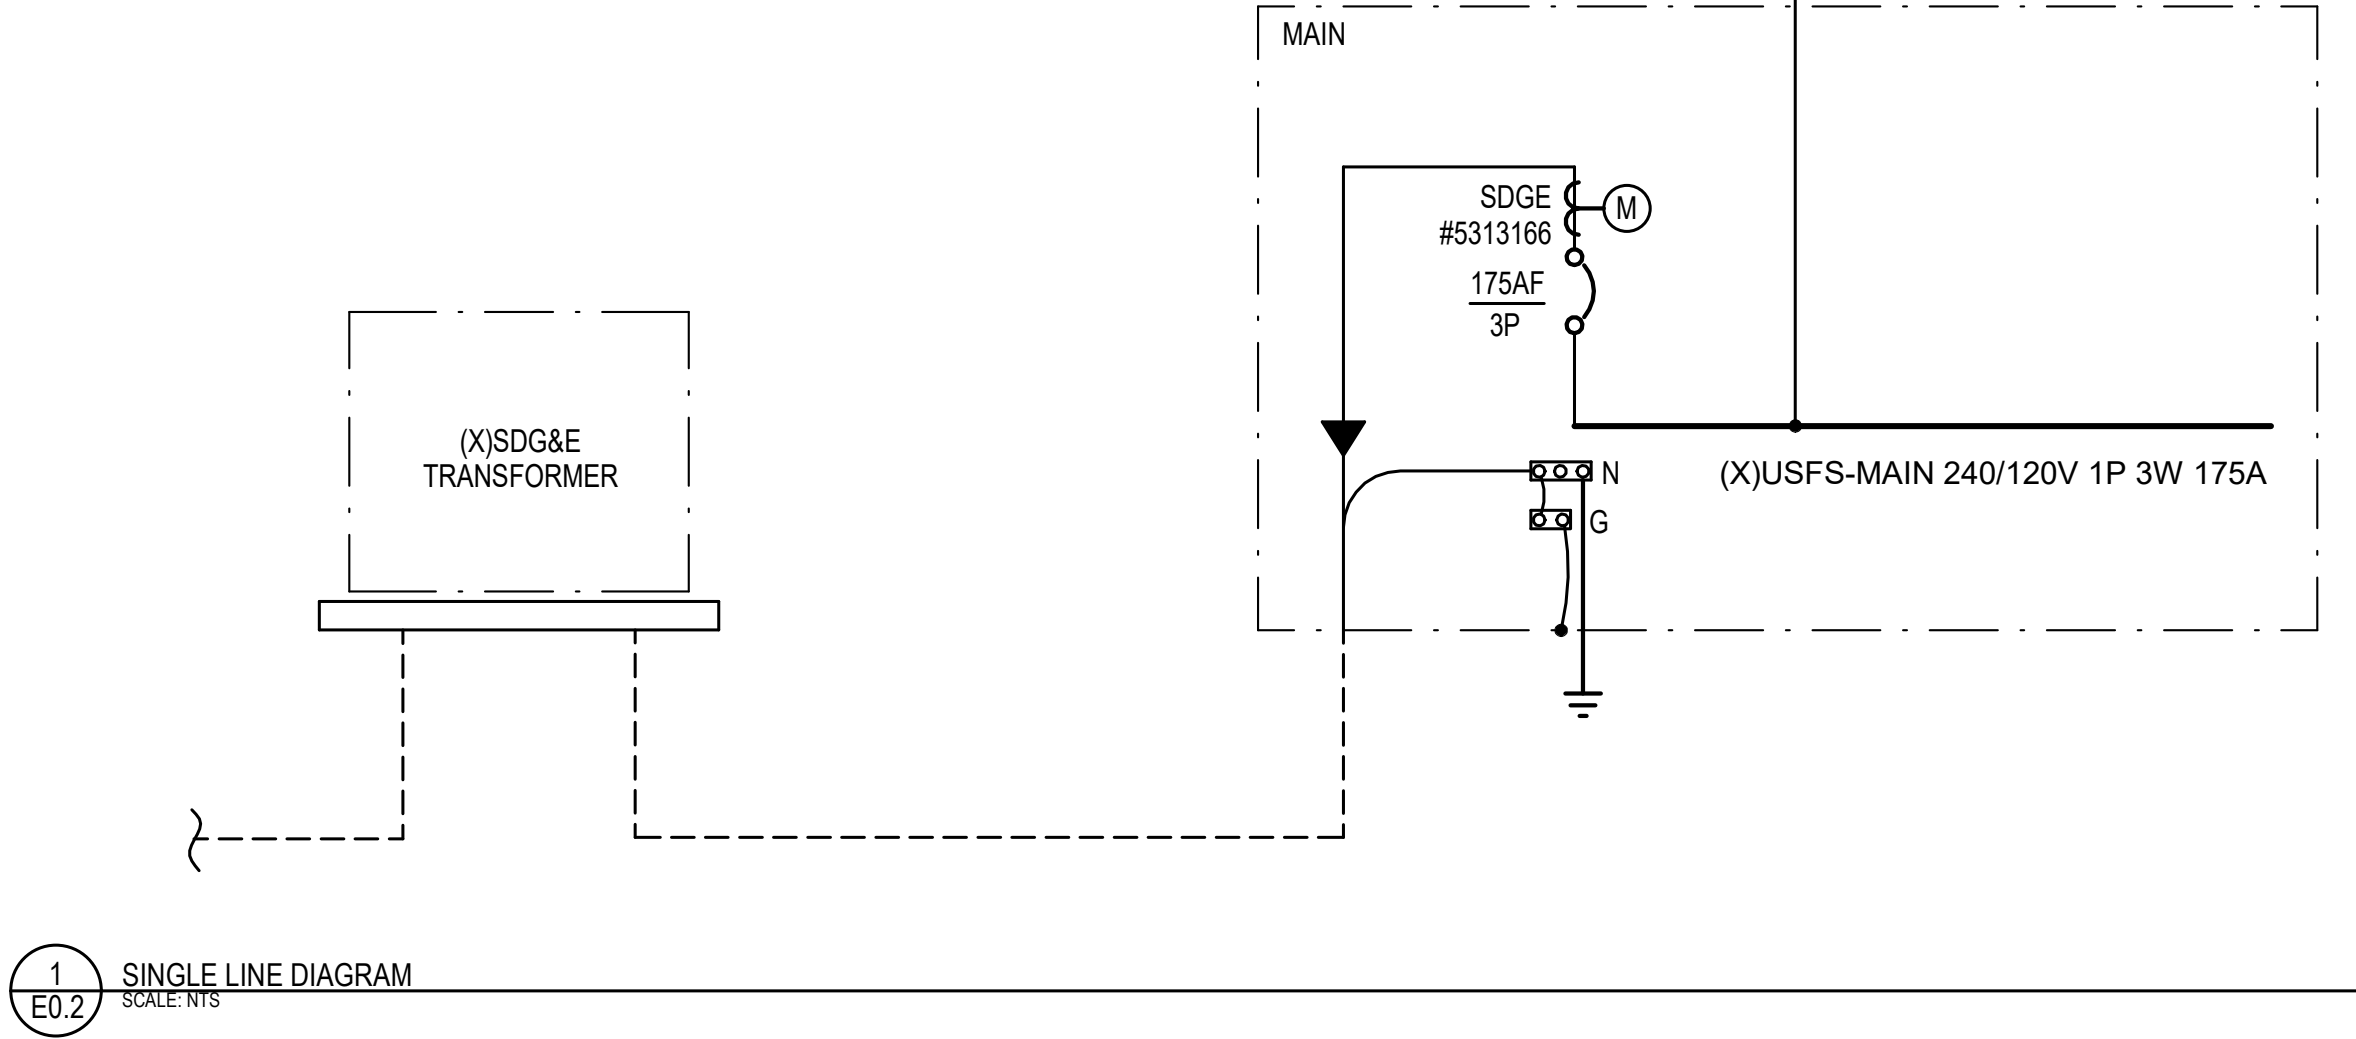

Branch Panel: FS1

Location: FOREST SERVICE BLDG INTERIOR

Supply From: (X)USFS

Mounting: Surface

Enclosure: Type 1

Volts: 240/120V 2P 3W

Phases: 1

Wires: 3

Lug Type: Standard

200% Neutral: No

A.I.C. Rating: 10,000

Mains Type: MLO

Bus Rating: 100

Notes: EXISTING LOAD INFORMATION BASED ON FIELD VERIFICATION

CKT	Circuit Description	Trip	Poles	A		B		Poles	Trip	Circuit Description	CKT
1	MAIN BREAKER	100 A	2	0.00 kVA	--	0.00 kVA	--	1	--	BUSSED SPACE	2
3	--	--	--	--	--	--	--	1	--	BUSSED SPACE	4
5	EXISTING WELDER	20 A	2	1.60 kVA	0.50 kVA	1.60 kVA	0.50 kVA	1	20 A	EXISTING LIGHTS	6
7	--	--	--	--	--	--	--	1	20 A	EXISTING LIGHTS	8
9	EXISTING AC	30 A	2	2.40 kVA	0.54 kVA	2.40 kVA	0.54 kVA	1	20 A	EXISTING RECEPTACLES	10
11	--	--	--	--	--	--	--	1	20 A	EXISTING RECEPTACLES	12
13	EXISTING LIGHTING	20 A	1	0.50 kVA	1.00 kVA	0.50 kVA	0.54 kVA	1	20 A	EXISTING ICE MACHINE	14
15	EXISTING LIGHTING	20 A	1	--	--	--	--	1	20 A	EXISTING RECETACLES	16
17	EXISTING GAS	20 A	1	1.00 kVA	0.00 kVA	1.00 kVA	1.80 kVA	1	20 A	EXISTING SAW SHED	18
19	EXISTING DIESEL	20 A	1	--	--	--	--	1	20 A	EXISTING LIGHTING CONTNOL PANEL	20
21	CONNEX BOX HVAC	20 A	1	1.00 kVA	0.53 kVA	--	--	1	20 A	HELIPORT LIGHTING CONTNOL PANEL	22
23	CONNEX BOX HVAC	20 A	1	--	--	1.00 kVA	--	1	--	BUSSED SPACE	24
Total Load:				9.07 kVA		9.88 kVA					
Total Amps:				76 A		82 A					

Load Classification	Connected Load	Demand Factor	Estimated Demand	Panel Totals
Motor	2.00 kVA	112.50%	2.25 kVA	
Existing Loads	16.42 kVA	100.00%	16.42 kVA	Total Conn. Load: 18.95 kVA
Lighting	0.53 kVA	125.00%	0.66 kVA	Total Est. Demand: 19.33 kVA
				Total Balanced Conn.: 79 A
				Total Est. Demand: 81 A

* PROVIDE NEW BREAKER IN EXISTING PANEL. BREAKER SHALL MEET EXISTING PANEL TYPE, MANUFACTURER AND AIC RATING.

SHEET KEYNOTES

- SEE "FS1" PANEL SCHEDULE FOR ADDED LOADS.
- PROVIDE HELIPORT LIGHTING CONTROL PANEL. SEE SHEET E3.2 FOR CUTSHEETS.

GENERAL NOTES

- ELECTRICAL CONTRACTOR SHALL VERIFY EXISTING CONDITIONS PRIOR TO ROUGH IN.
- ALL EQUIPMENT ON SINGLE LINE DIAGRAM IS EXISTING TO REMAIN. UNO.



9640 GRANITE RIDGE DR, SUITE 130
SAN DIEGO, CA 92123
619-688-9177 | www.coargroup.com



DESCRIPTION: DATE:


PRELIMINARY DESIGN 03/13/26

50% CONSTRUCTION DOCUMENTS 04/20/26

95% CONSTRUCTION DOCUMENTS 06/02/26

100% CONSTRUCTION DOCUMENTS 06/11/26

PERMITTING SUBMITTAL 06/23/26

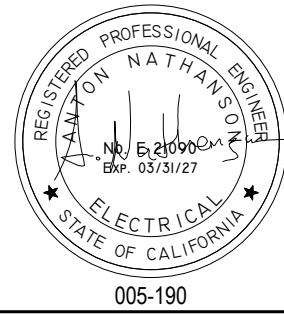

005-190

PROJECT:
CALIFORNIA DEPARTMENT OF FORESTRY AND FIRE PROTECTION
CAL FIRE RAMONA AIR ATTACK BASE - HELIPAD DESIGN
2498 MONTECITO ROAD, RAMONA, CALIFORNIA 92065


PROJECT NUMBER:
260101

SHEET TITLE:
SINGLE LINE DIAGRAM

SHEET NUMBER:

E0.2


GENERAL NOTES - POWER		SHEET KEYNOTES	
A	ELECTRICAL CONTRACTOR SHALL VERIFY EXISTING CONDITIONS PRIOR TO ROUGH IN.	1	PROVIDE NEMA 3R LOCKABLE DISCONNECT FOR STORAGE CONTAINER POWER. TYPICAL OF 2.
		2	SEE SHEET E2.1 FOR ENLARGED HELICOPTER PAD LIGHTING AND POWER PLANS.
		3	PROVIDE NEMA 3R HELIPORT LIGHTING CONTROL PANEL LCP. SEE SHEET E3.2 FOR LIGHTING CONTROL PANEL CUTSHEET.
		4	ROUTE BRANCH CIRCUITS AND CU HELIPORT GROUND CONDUCTORS UNDERGROUND. COORDINATE TRENCHING WITH ARCHITECTURAL/CIVIL DRAWINGS.
		5	NO WORK SHALL OCCUR WITHIN 35' OF EXISTING TREE.

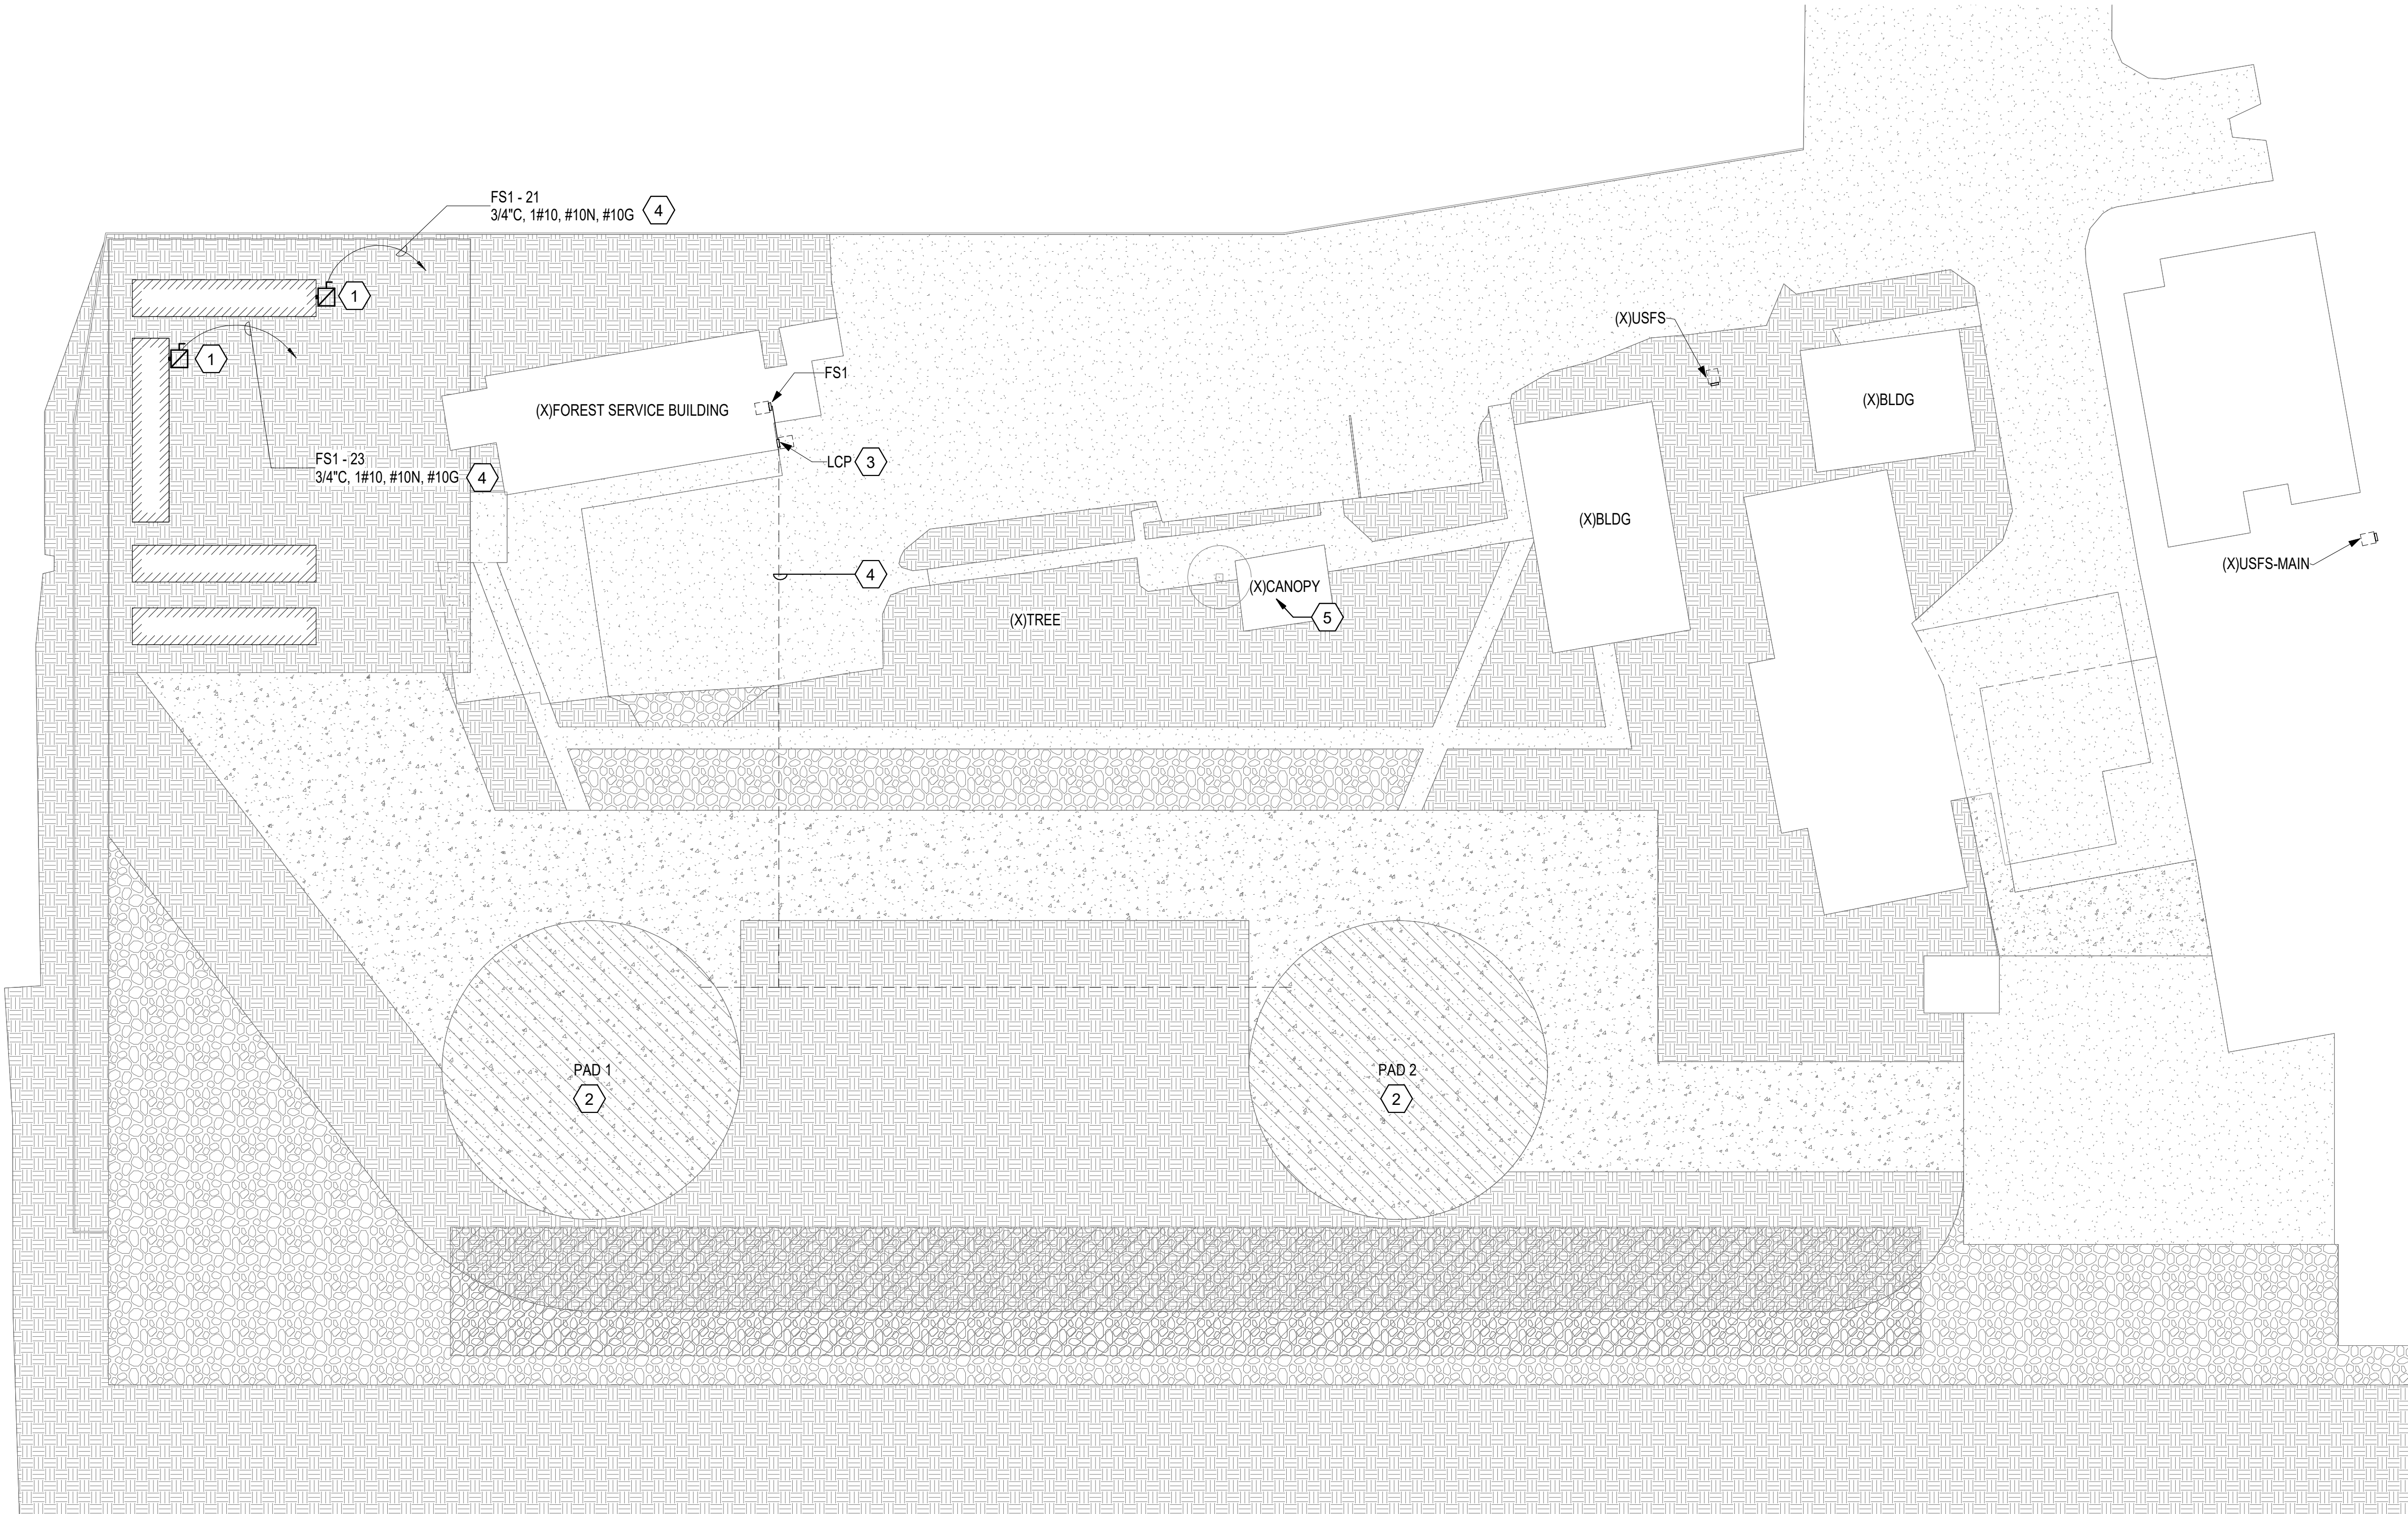

9640 GRANITE RIDGE DR, SUITE 130
SAN DIEGO, CA 92123
619.688.9777 | www.coargroup.com



DESCRIPTION:	DATE:
PRELIMINARY DESIGN	03/13/26
50% CONSTRUCTION DOCUMENTS	04/20/26
95% CONSTRUCTION DOCUMENTS	06/02/26
100% CONSTRUCTION DOCUMENTS	06/11/26
PERMITTING SUBMITTAL	06/23/26

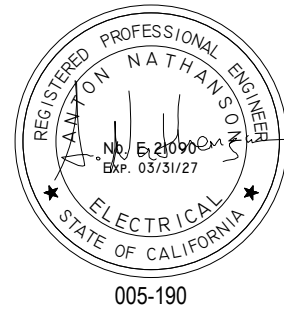


PROJECT:
CALIFORNIA DEPARTMENT
OF FORESTRY AND FIRE
PROTECTION
CAL FIRE RAMONA AIR ATTACK BASE
- HELIPAD DESIGN
2498 MONTECITO ROAD,
RAMONA, CALIFORNIA 92065

PROJECT NUMBER:
260101


SHEET TITLE:
ELECTRICAL SITE PLAN

SHEET NUMBER:

E1.1

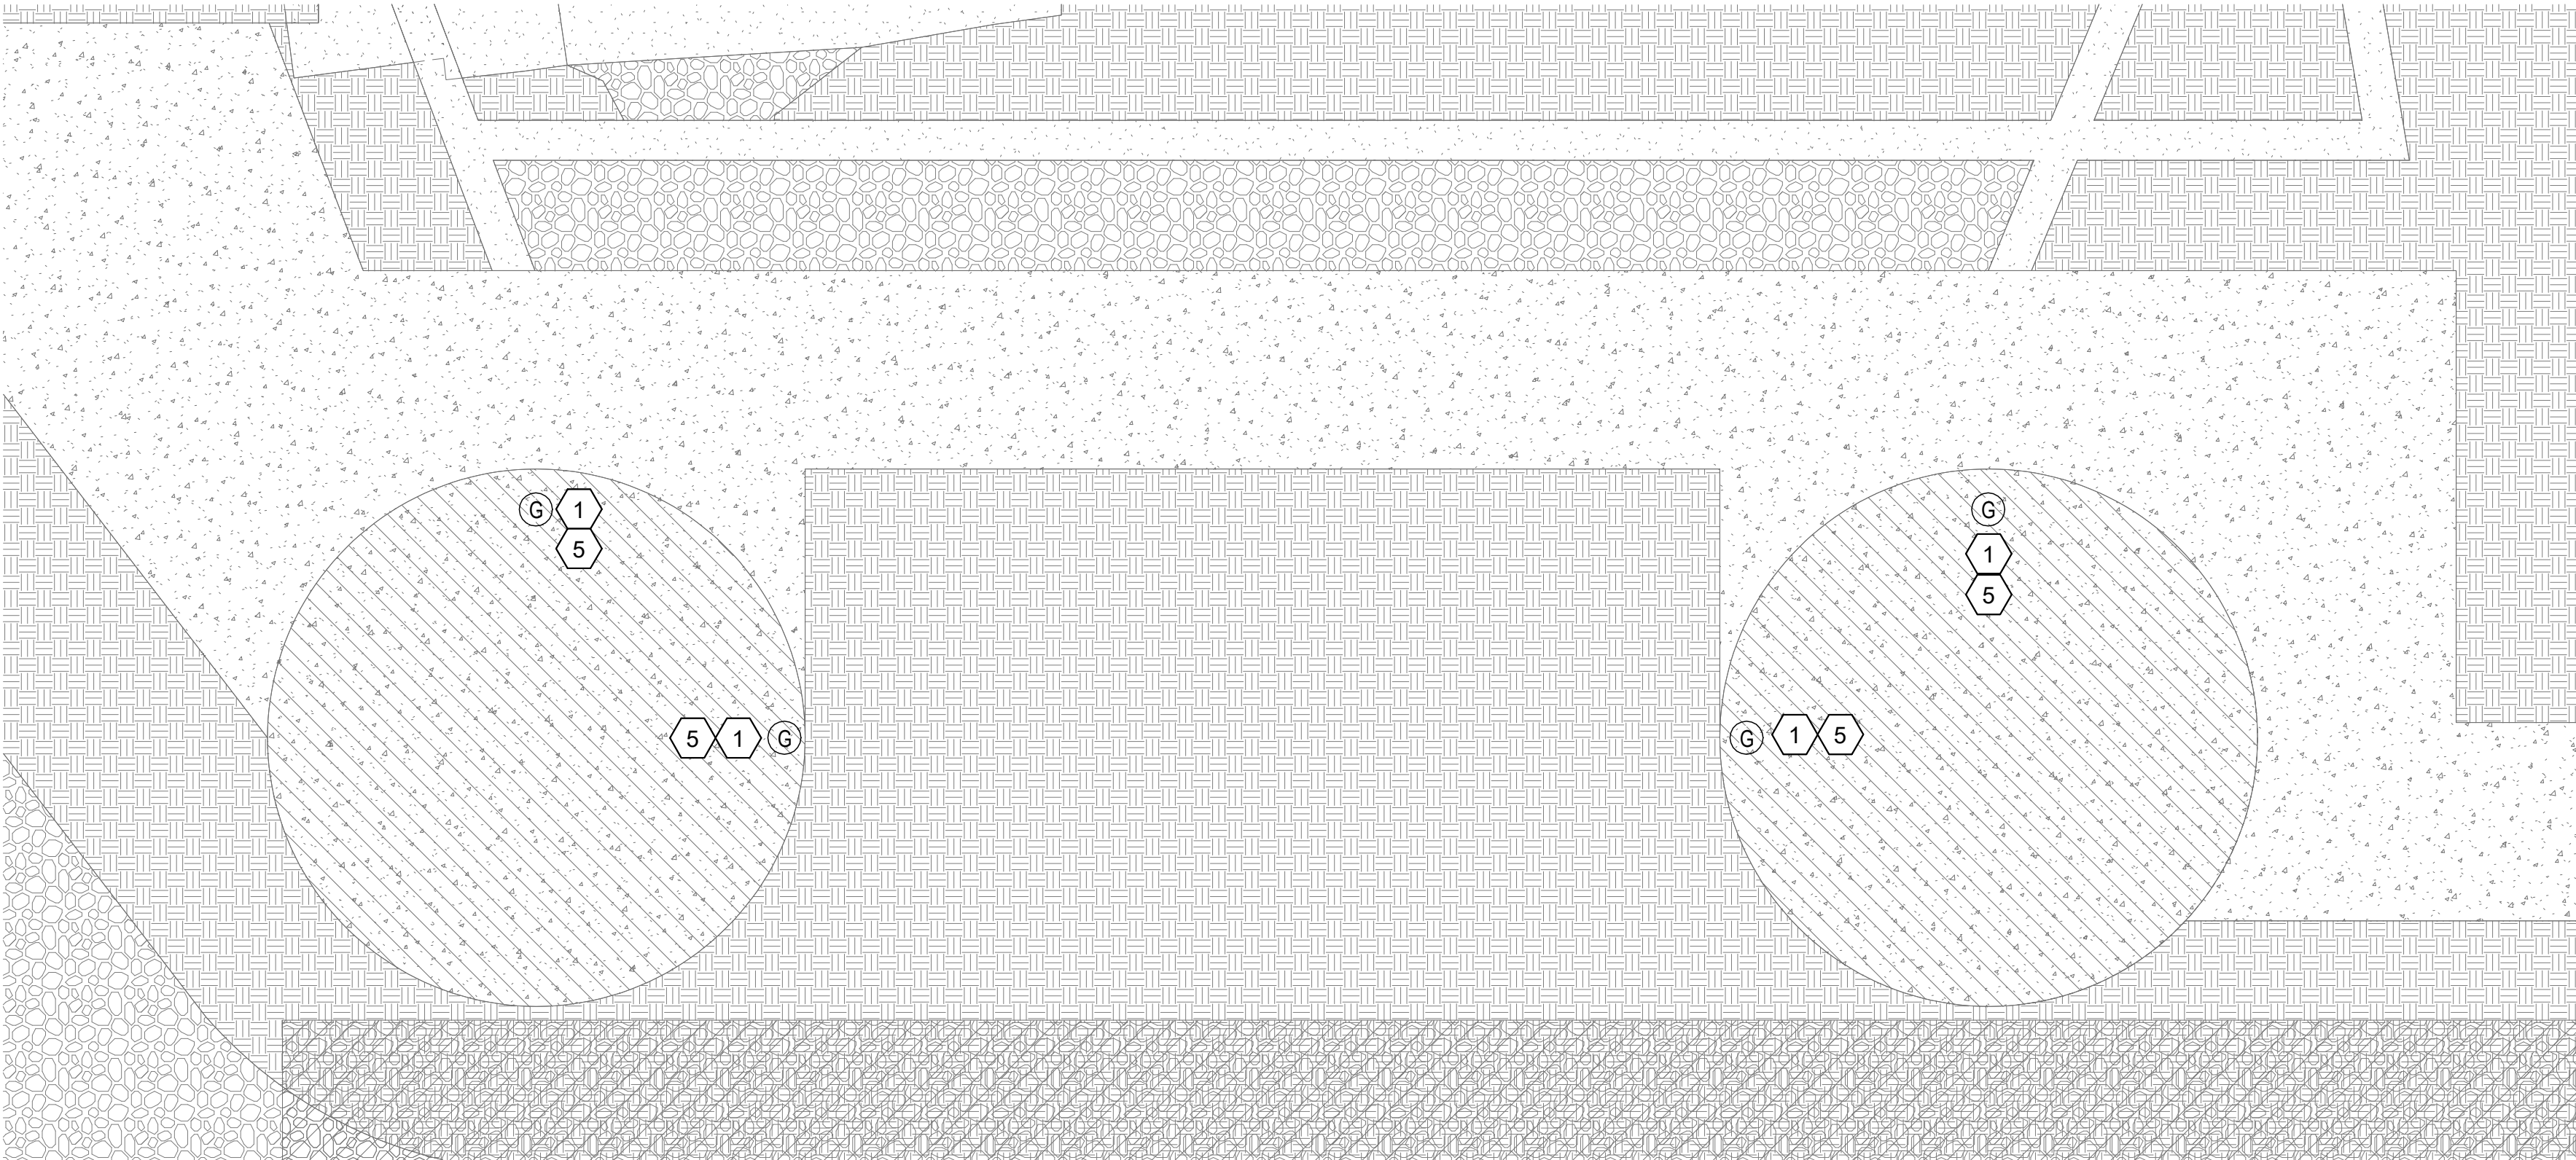

1
E2.1 ENLARGED POWER PLAN
SCALE: 1/16" = 1'-0"

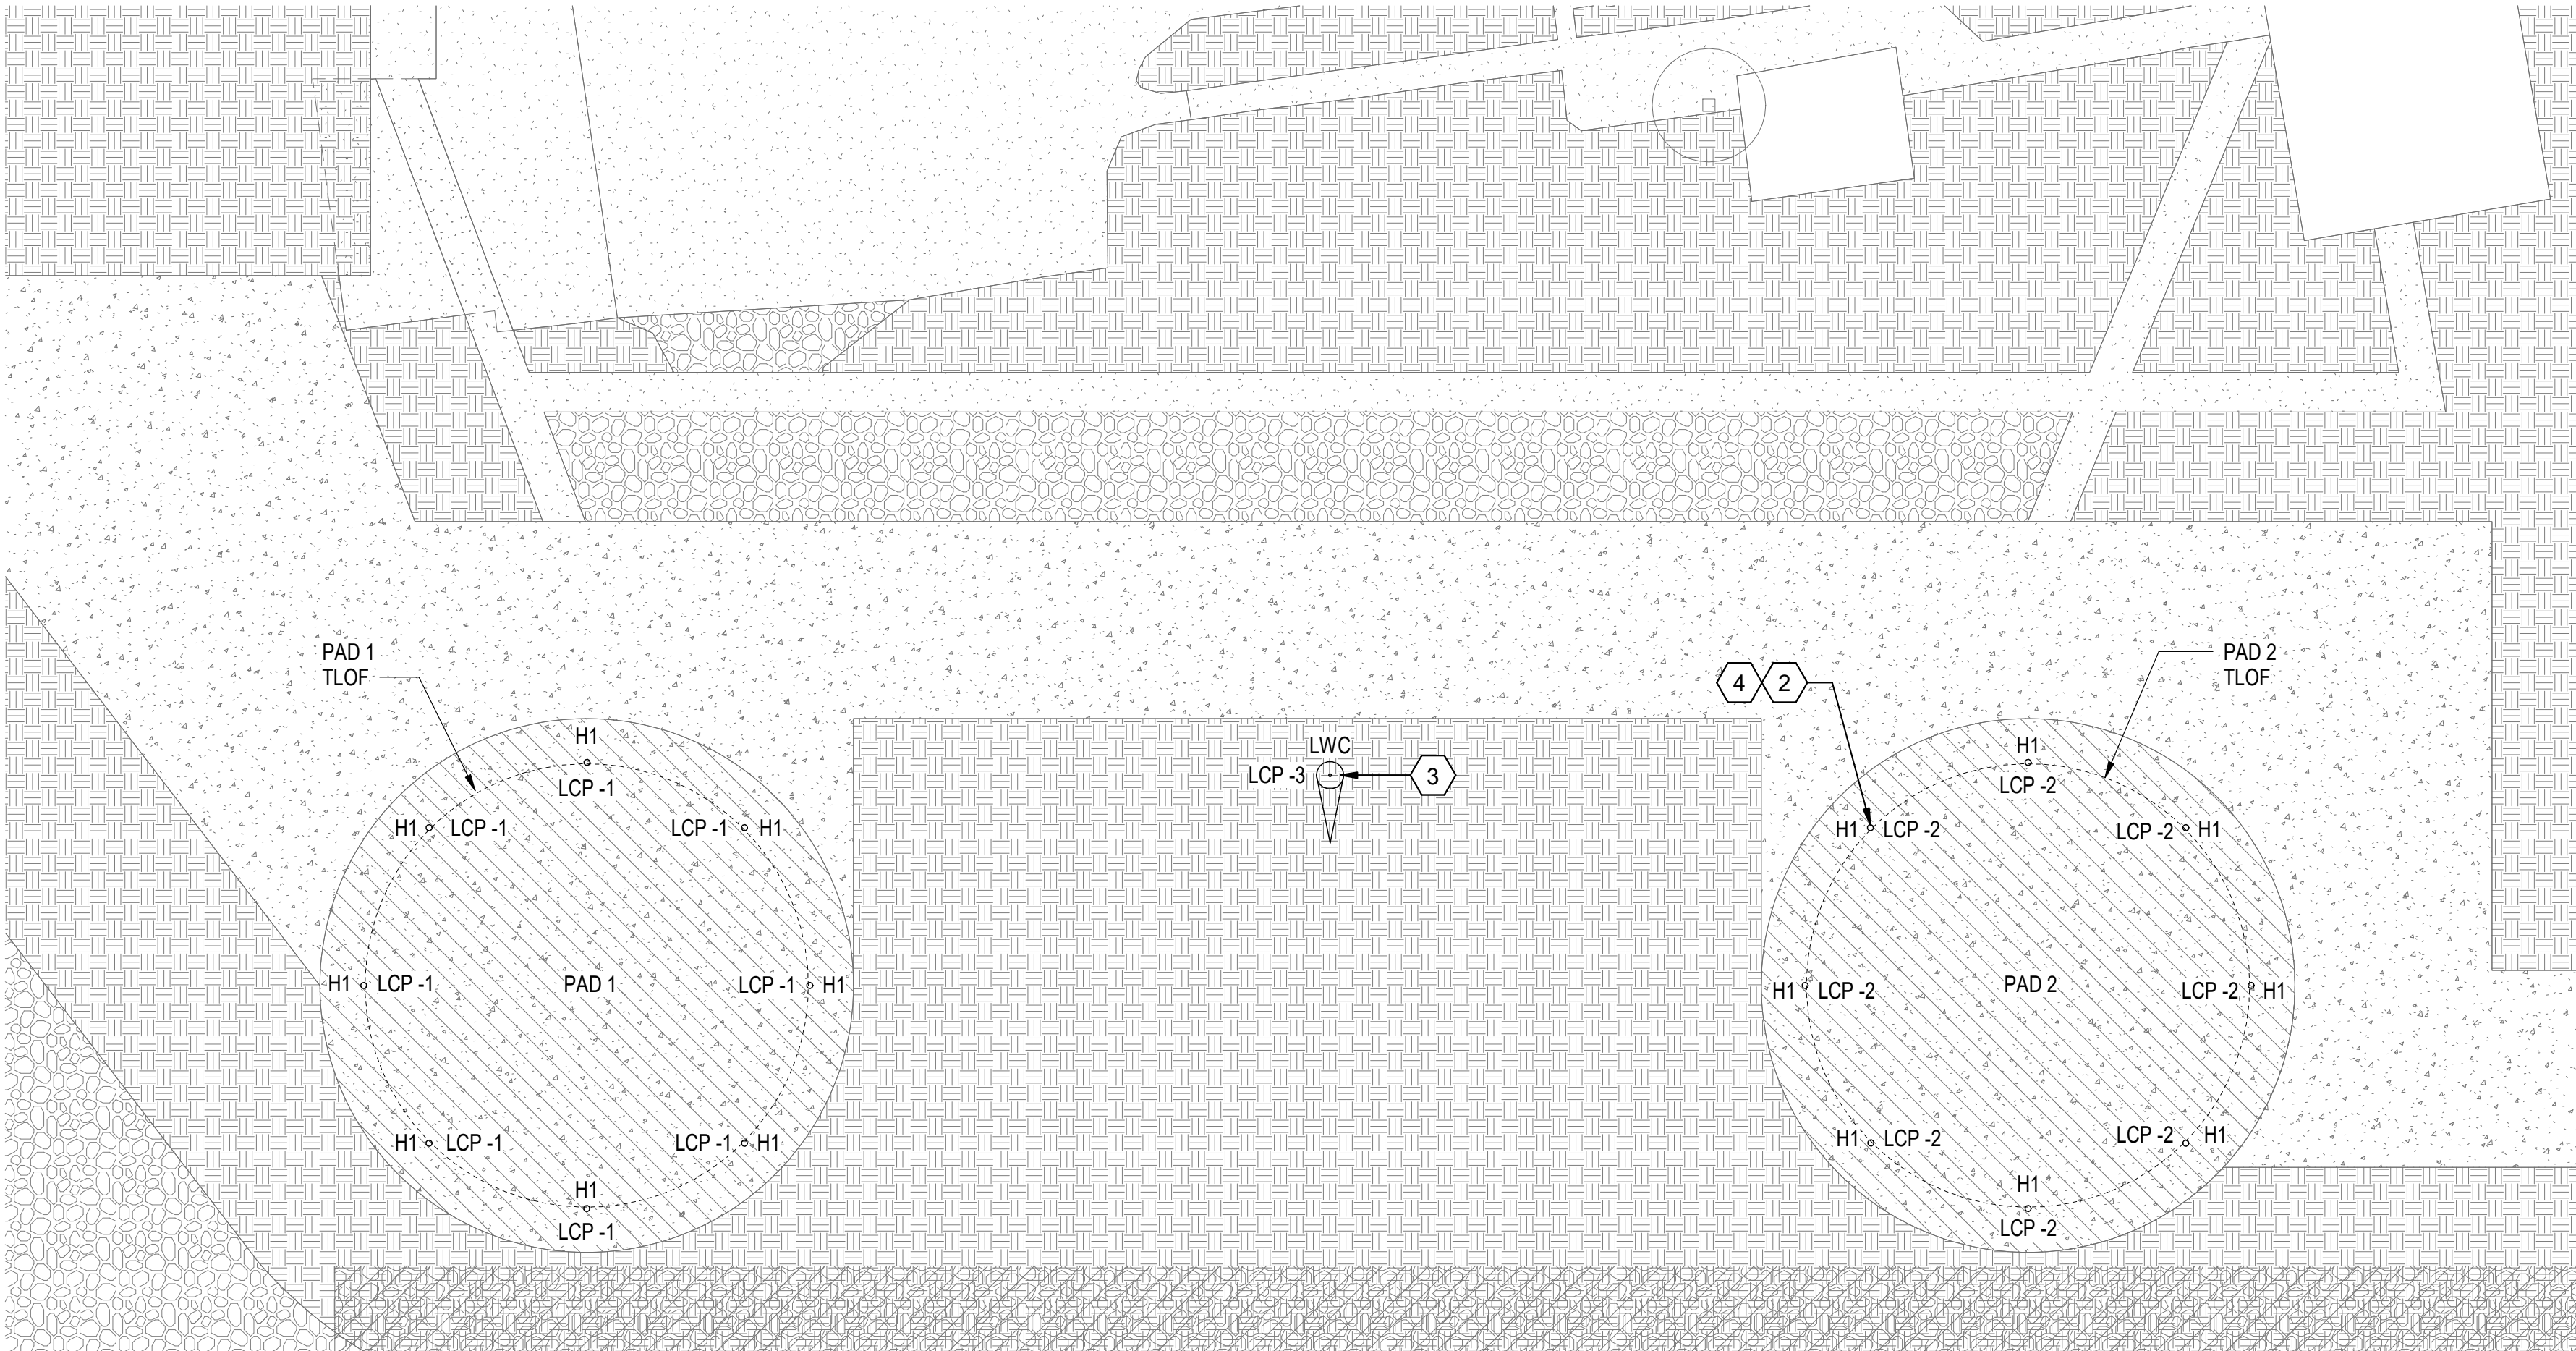

2
E2.1 ENLARGED LIGHTING PLAN
SCALE: 1/16" = 1'-0"



GENERAL NOTES - POWER

A ELECTRICAL CONTRACTOR SHALL VERIFY EXISTING CONDITIONS PRIOR TO ROUGH IN.

SHEET KEYNOTES

- 1 PROVIDE STATIC GROUND RECEPTACLE. RECEPTACLE MUST NOT EXTEND 2" ABOVE FATO/TLOF AREA SURFACE ELEVATION. SEE SHEET E3.1 FOR DETAIL.
- 2 PROVIDE FAA TYPE L-852H IN-PAVEMENT PERIMETER LIGHT FOR HELIPORT. 8 TYPICAL PER HELIPORT PAD. LOCATE WITHIN 1' INSIDE OR OUTSIDE OF TLOF. SEE SHEET E3.2 FOR CUTSHEET.
- 3 PROVIDE LIGHTED WIND CONE. LOCATE WIND CONE OUTSIDE OF SAFETY AREA.
- 4 ALL IN-PAVEMENT FIXTURES ON HELIPORT TO BE CIRCUITED TO HELIPORT LIGHTING CONTROL PANEL LCP.
- 5 BOND STATIC GROUND RECEPTACLES TO EXISTING BLDG SERVICE. SEE SHEET E3.1 DETAIL 4 FOR BONDING DETAIL.



9640 GRANITE RIDGE DR, SUITE 130
SAN DIEGO, CA 92123
619.688.9777 | www.coargroup.com



DESCRIPTION:	DATE:
PRELIMINARY DESIGN	03/13/26
50% CONSTRUCTION DOCUMENTS	04/20/26
95% CONSTRUCTION DOCUMENTS	06/02/26
100% CONSTRUCTION DOCUMENTS	06/11/26
PERMITTING SUBMITTAL	06/23/26





PROJECT:
**CALIFORNIA DEPARTMENT
OF FORESTRY AND FIRE
PROTECTION
CAL FIRE RAMONA AIR ATTACK BASE
- HELIPAD DESIGN**
2498 MONTECITO ROAD,
RAMONA, CALIFORNIA 92065

PROJECT NUMBER:
260101

SHEET TITLE:
**ENLARGED ELECTRICAL
PLANS**

SHEET NUMBER:


E2.1

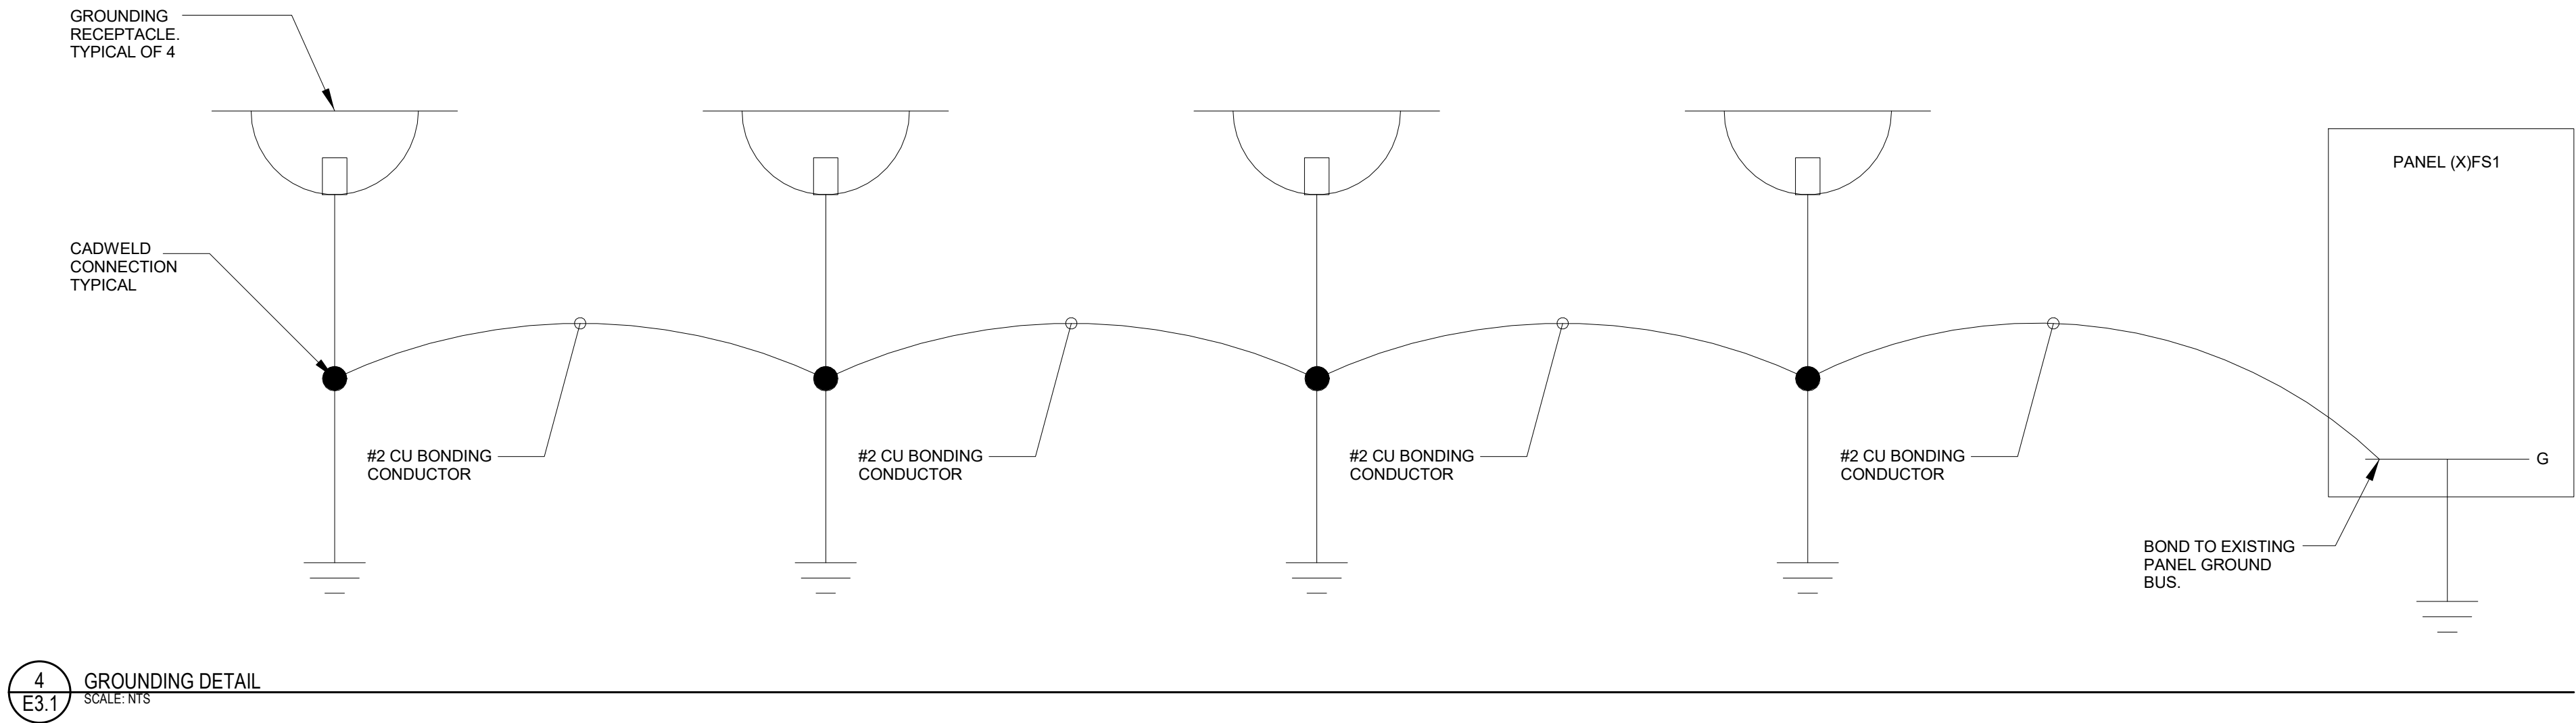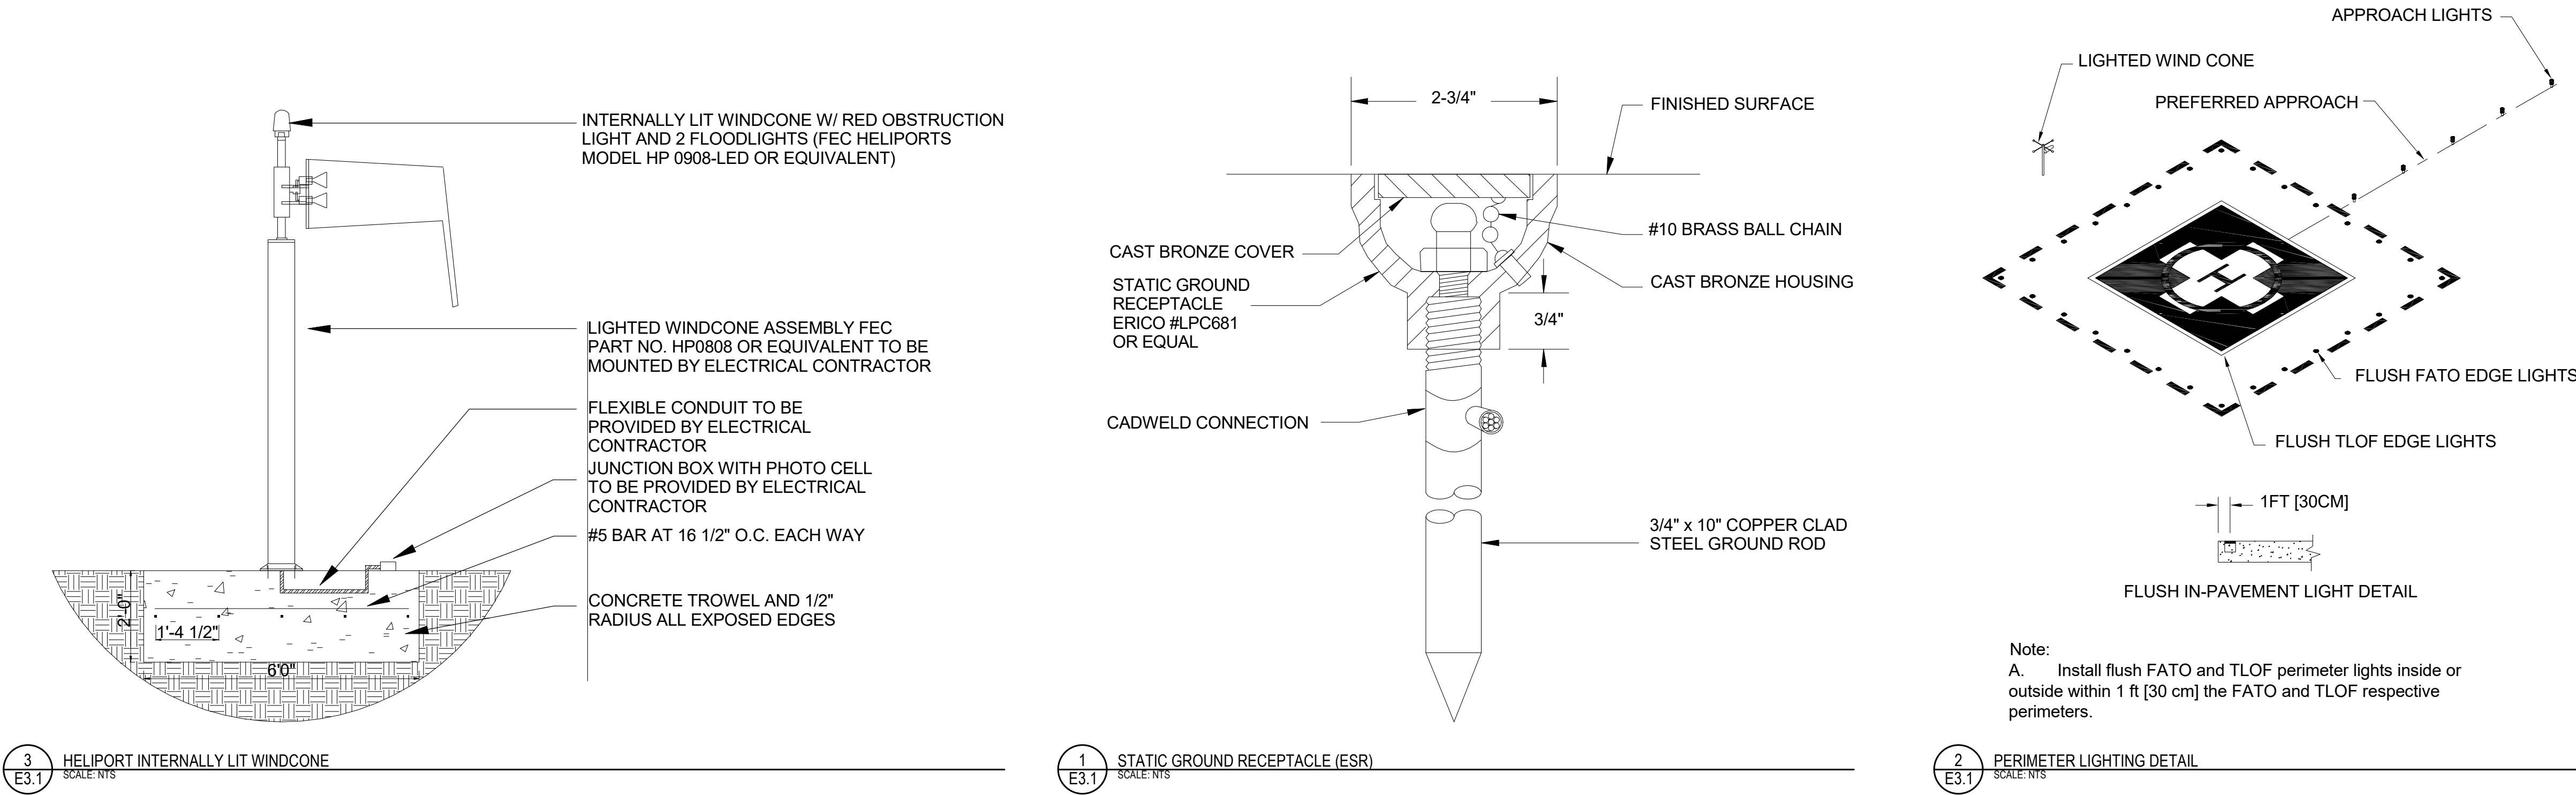

9640 GRANITE RIDGE DR, SUITE 130
SAN DIEGO, CA 92123
619-688-9777 | www.coargroup.com



DESCRIPTION:	DATE:
PRELIMINARY DESIGN	03/13/26
50% CONSTRUCTION DOCUMENTS	04/20/26
95% CONSTRUCTION DOCUMENTS	06/02/26
100% CONSTRUCTION DOCUMENTS	06/11/26
PERMITTING SUBMITTAL	06/23/26

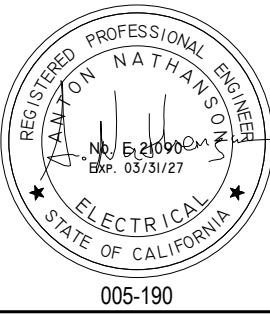

PROJECT:
CALIFORNIA DEPARTMENT OF FORESTRY AND FIRE PROTECTION
CAL FIRE RAMONA AIR ATTACK BASE - HELIPAD DESIGN
2498 MONTECITO ROAD,
RAMONA, CALIFORNIA 92065

PROJECT NUMBER:
260101

SHEET TITLE:
ELECTRICAL SCHEDULES AND DETAILS

SHEET NUMBER:

E3.1



POINT LIGHTING CORPORATION

POINT ROLLOVER LIGHTS

PRL LED v4

HELIPORT INSET LIGHT

Compliances: ETL Listed to UL 1598A Marine Vessels at -40 deg C to +55 deg C
 ETL Listed to CSA C22.2 No. 137-M1981 & No. 250.0-08 Canada
 ETL Listed to UL 1598 at -40 deg C to +55 deg C
 Tested & Certified to IP66, IP67 & IP69 Ingress Protection
 Certified to FAA L-852H(L), L-860H(L), L-861H(L), L-860H(R), L-860H(S)
 ICAO Annex 14, Volume II and ICAO Doc 9261
 Transport Canada Standard 325
 Registered ISO 9001:2015
 IEC CAA CAP 437 ed. 9 (2003), Chapter 4 & Appendix C
 American Bureau of Shipping (ABS) Type Approved Product




The PRL LED Point Rollover Light is used for heliports where an omnidirectional inset semi-flush light is required to provide visibility and circling guidance. Only 2.2 watts and 3.5 VA at 120V.

- ☒ The castings are copper-free (< 0.25%) aluminum.
- ☒ The lens is glass.
- ☒ The hardware is 316 (A4) stainless steel.
- ☒ The LED's are rated for 100,000 hours.
- ☒ Switchable color option available.
- ☒ IP66, IP67 & IP69 tested and listed.
- ☒ Standard with the exclusive Point Lighting Marine Treatment finish that is bonded to the metal and far exceeds the corrosion resistance of the standard FAA approved finish. See below.
- ☒ Six (6) years limited warranty subject to Point Lighting "Terms & Conditions of Sale".

Point Type	Voltage	Array	Color	Mounting & Options
PRL-97004	1: 120V	C: Heliport	C: Green	VB: Variable Brightness
	2: 220V	N: NVC*	Y: Yellow	PLS: Flush Base & Gasket
	3: 12V DC	V: Vertical*	W: White	NC: NVC compatibility**
	4: 24V DC	H: ICAO FATO	R: Red	SR: CAP 437 Seating Ring
	6: 277V	U: C-535-01	B: Blue	DR: Drain Hole in Base
			IR: Infra-red*	GR: Ground Lug in Base
				MTY: Marine Treatment Yellow
				TW: Taxiway Brightness (blue)
				SC: Switchable Color (see page 2)
				TRH: Tampo Resistant Hardware

Note: Array C brightness exceeds ICAO Annex 14 & meets CAP 437
 * For NVC tactical use only. PRL-97004-1N-IR-PL
 * Inspection uplight normally in white with narrow high intensity vertical beam.

Visiblity Range as Tested:
 Visible Color > 8 nautical miles
 Option -NC ** > 3 nautical miles

**** For Night Vision Goggles (NVC)**
 Option -NC adds IR LED at 855 nm
 Radiant Power: <array 137 mW/lr








Our Marine Treatment tolerates marine, high salt content air and other corrosive environments. Standard with green finish as shown. The FAA specified finish used by competitors flakes and falls in a short time under such conditions.

The fixture shall be treated for marine conditions by cleaning per US Department of Defense TFC-490 method III, pretreated with chrome-free aluminum conversion coating per MIL-C-5541 type I, epoxy powder base coat primer and glycol polyester powder coat finish in color RAL 6003 (RED-STD-395 color #14087) dark powder. Green coating per US Department of Defense MIL-PRF-24712A type VI and oven cured.

HL115 March, 2024

	
	
9640 GRANITE RIDGE DR, SUITE 130 SAN DIEGO, CA 92123 619.698.9177 www.coargroup.com	
	
DESCRIPTION:	DATE:
PRELIMINARY DESIGN	03/13/26
50% CONSTRUCTION DOCUMENTS	04/20/26
95% CONSTRUCTION DOCUMENTS	06/02/26
100% CONSTRUCTION DOCUMENTS	06/11/26
PERMITTING SUBMITTAL	06/23/26
	
005-190	
PROJECT:	CALIFORNIA DEPARTMENT OF FORESTRY AND FIRE PROTECTION CAL FIRE RAMONA AIR ATTACK BASE - HELIPAD DESIGN 2498 MONTECITO ROAD, RAMONA, CALIFORNIA 92065
PROJECT NUMBER:	260101
SHEET TITLE:	ELECTRICAL CUTSHEETS
SHEET NUMBER:	E3.2